


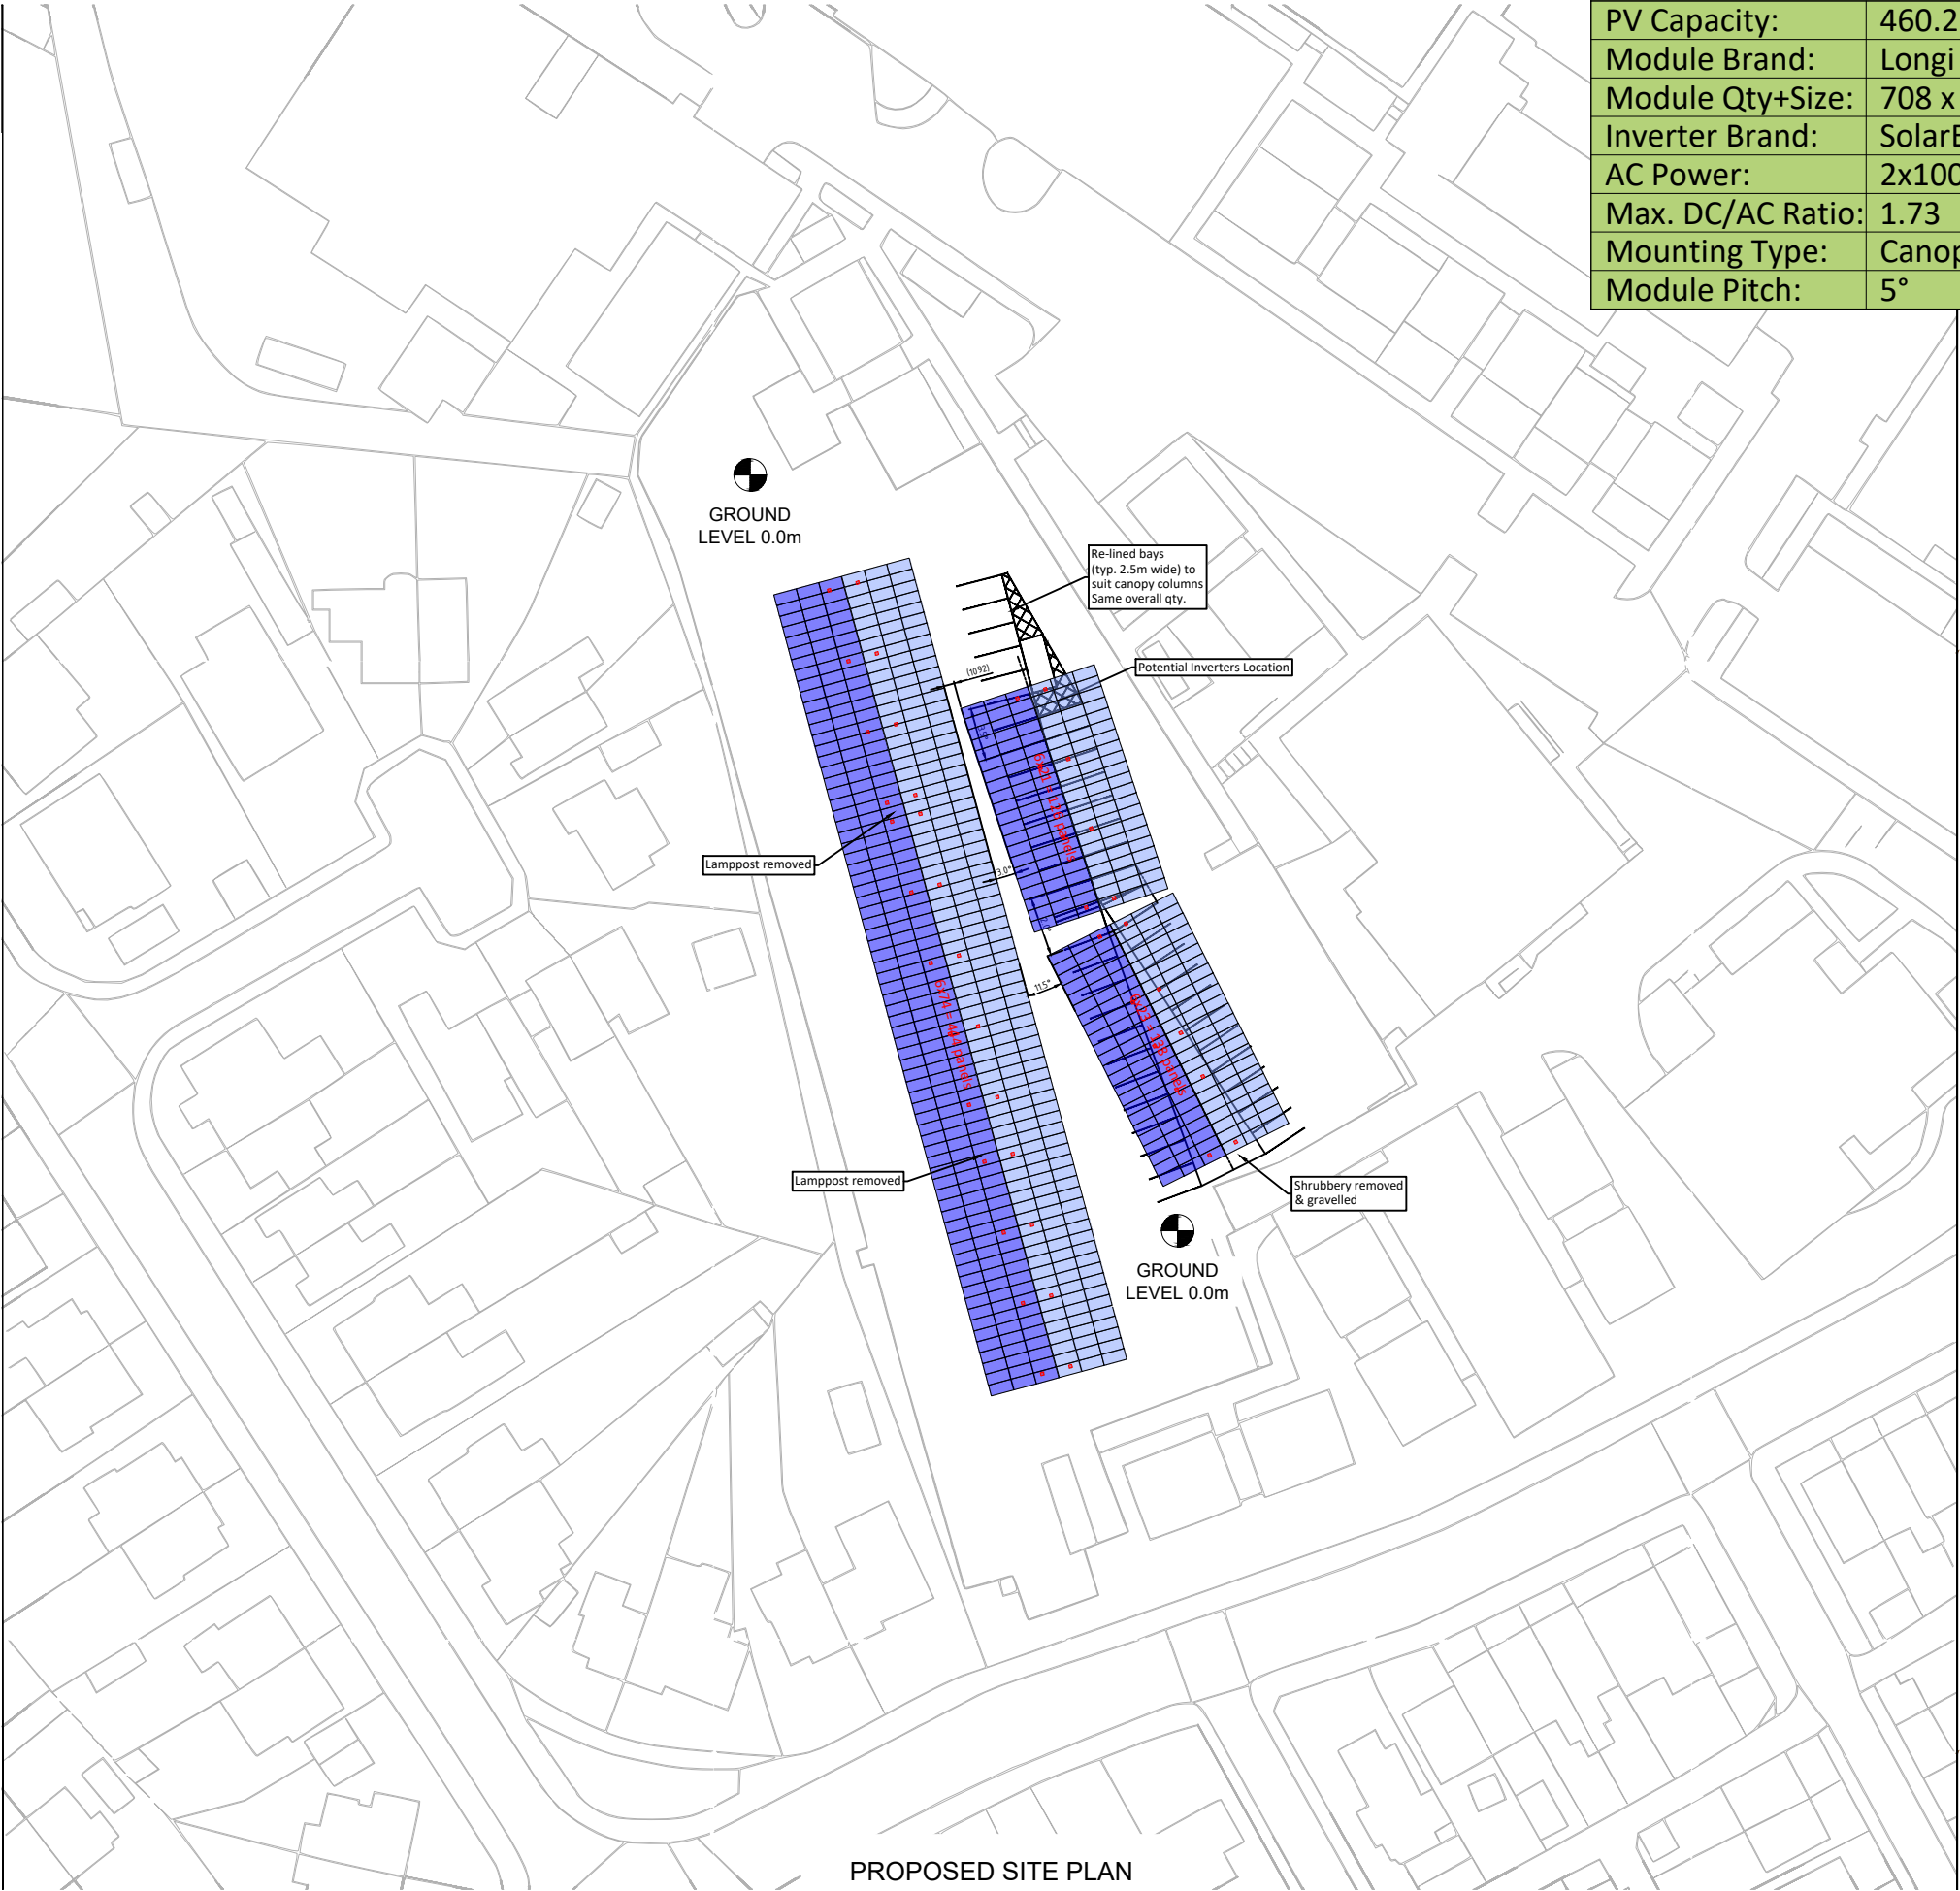

PROPOSED SITE PLAN



PV Layout Legend	
PV Capacity:	460.2 kWp
Module Brand:	Longi
Module Qty+Size:	708 x 650Wp
Inverter Brand:	SolarEdge
AC Power:	2x100K, 1x66K
Max. DC/AC Ratio:	1.73
Mounting Type:	Canopy
Module Pitch:	5°

NOTES:
1. ALL DIMENSIONS IN MM UNLESS OTHERWISE NOTED.

Company: CUSTOM SOLAR	Project: Project	Purpose of Issue: Planning	Issue: A
Date: 18/09/2026	Revision / Upgrade Description: First Issue		
Drawn: A.Marquez			
Checked: Ed.Salkild			
Approved: CS DA			




Custom Solar Ltd
Sunbeam House
Broombank Road
Chesterfield, S41 9QJ

T: 01246 488488
www.customsolar.co.uk
sales@customsolar.co.uk

Site Name:	CS - BARNSELY HOSPITAL
Address:	Barnsley Hospital, Gawber Rd, Barnsley, S75 2EP
Title:	150 PROPOSED SITE PLAN
Project:	PROJECT
Purpose of Issue:	PLANNING
Master Drawing Register No: CS - Barnsley Hospital_GA	Issue: A

Document Uncontrolled When Printed

ISO A3 Landscape