


Contractor must verify all dimensions on site before commencing any work or shop drawings. If this drawing exceeds the quantities taken in any way, the building designers are to be informed before the work is initiated. Only figured dimensions to be taken from this drawing. Do not scale off this drawing. Drawing based on Ordnance Survey and/or existing record drawings - design and drawing content subject to Site Survey, Structural Survey, Site Investigations, Planning and Statutory Requirements and Approvals. All drainage layouts are schematic and invert levels must be established prior to construction.



Material Key:

	Grey Brickwork.
	Composite Wood Look Cladding.
	Slate Effect Cladding.
	White Render.
	Grey Rooftiles.
	Black Aluminium.

Note:
All black fascias, soffits, gutters & downpipes.
All black windows & doors.

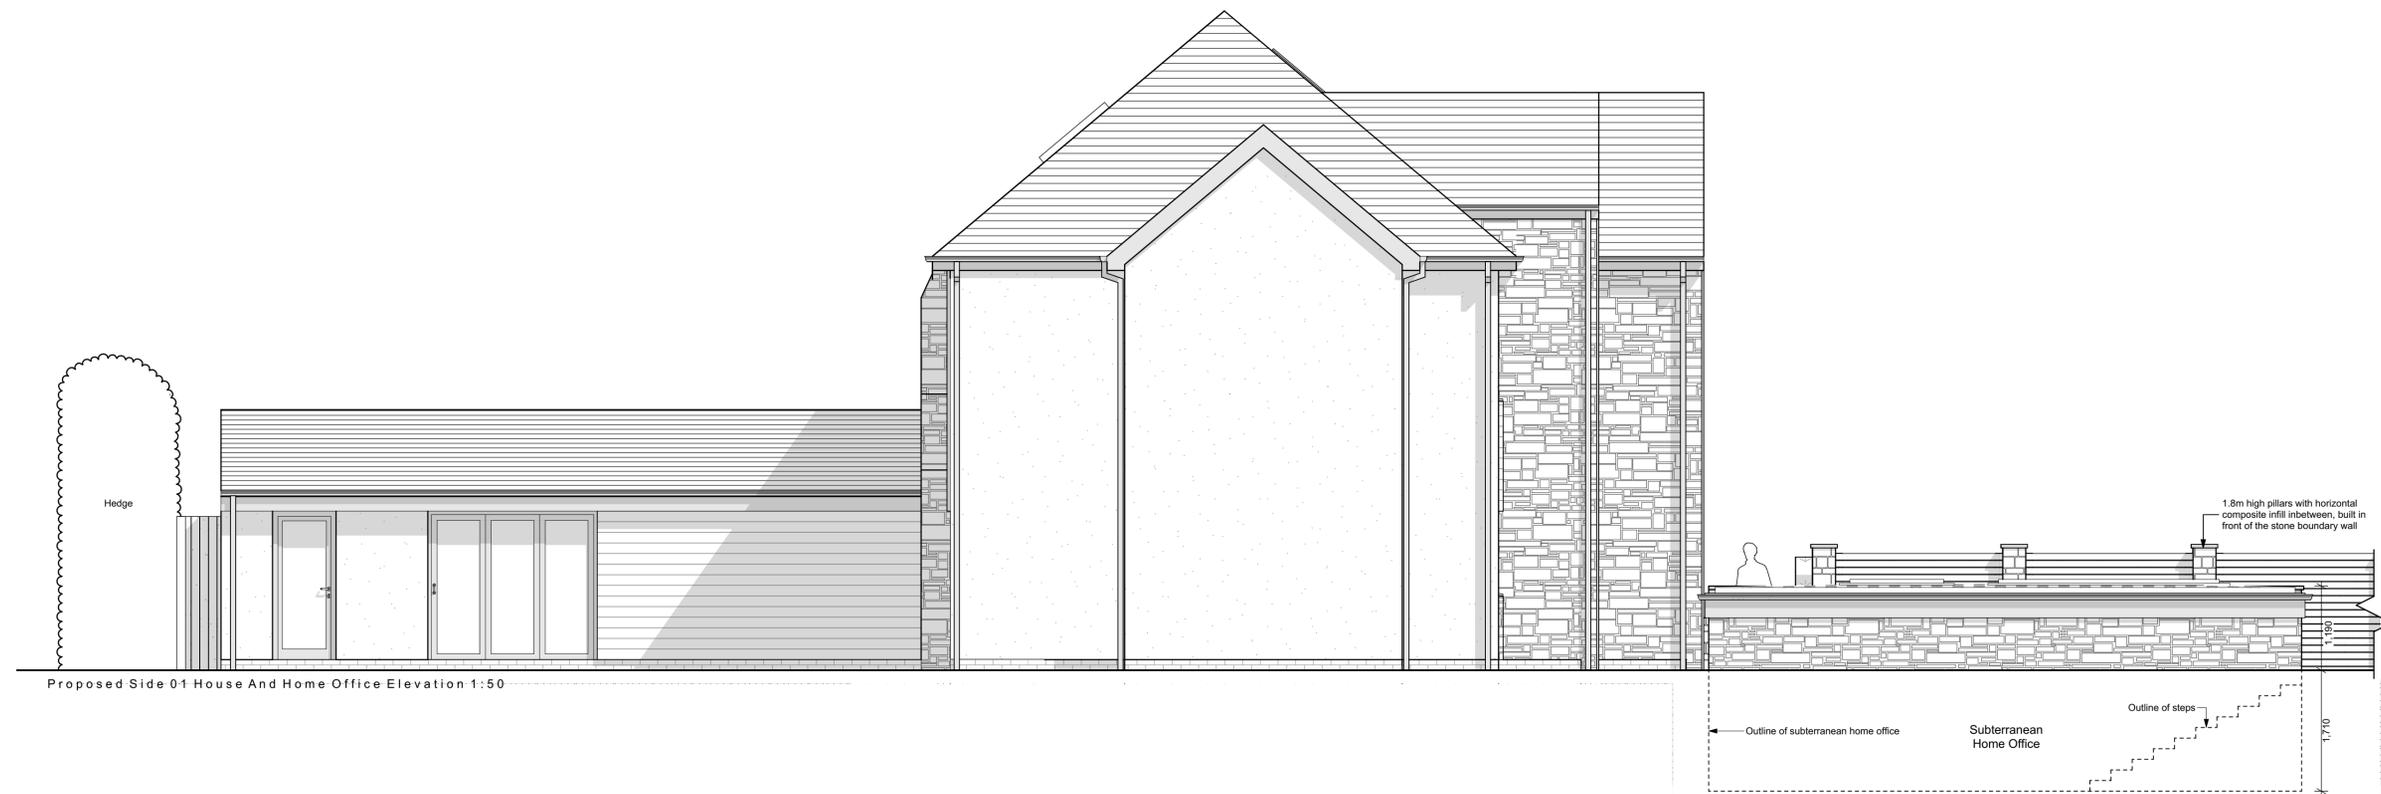

Project Status:	PLANNING ONLY
4 Rushmead Court, Ossett, WF5 0NZ tel: 01924 275 594 web: www.transformarchitects.co.uk email: info@transformarchitects.co.uk	
Project Address:	43 Intake Lane, Barnsley, S75 2HX
Client:	Mr and Mrs Rose
Drawing Title:	Proposed Elevations 01 A1
Scale:	1:50
Date:	04.06.2024
Drawn By:	JN
Drawing Number:	T1260 - PL07
Revision:	Nil