 



PROPOSED EE EQUIPMENT
CABINET REF: FLEXI UNITS WITHIN FREDO CABINET ON ROOF
DIMENSIONS: 900x800x1260 HIGH
MATERIAL: STEEL
COLOUR: GREY
CABINET REF: MK3 LINK/AC CABINET ON ROOF
DIMENSIONS: 600x500x1240 HIGH
MATERIAL: STEEL
COLOUR: GREY
15m PHASE 3 STREETWORKS TOWER
COLOUR: GALVANISED
SHROUD COLOUR: GREY
TRANSMISSION: LEASED LINE TO BE INSTALLED

ANTENNA DETAILS									
PROPOSED	HEIGHT (m)	ANTENNA TYPE	REFL	FEEDER LENGTH	FEEDER SYSTEM	FEEDER LOSS	FEEDER TYPE	MAIN	RETD
uA1	0	13.7	ANTENNA	No	17	0.4	2.679	LCF12-50	Yes
uB1	120	13.7	ANTENNA	No	17	0.4	2.679	LCF12-50	Yes
uC1	240	13.7	ANTENNA	No	17	0.4	2.679	LCF12-50	Yes
NOTE: FEEDER LENGTH SHOWN IS ONLY APPROXIMATE AND SHOULD BE CHECKED BY RIGGING CONTRACTOR PRIOR TO WORK COMMENCING									
TRANSMISSION DISH DETAILS									
DISH ID	PROPOSED	DISH SIZE	HEIGHT m AGL	POLE TAG REF	BEARING EGN	SITE LINK	SITE NAME	TIME No.	RL No.
D1	Proposed	300	12.5	TBA	TBA	TBA	TBA	TBA	TBA
Key to Dish Status									
Reserved: Approved transmission dish with Landlords & Planning consent Proposed: New transmission dish awaiting Landlords & Planning consent HCC: Replacement of existing transmission dish with Landlords & Planning consent									

EXCLUSION ZONES CONFORM TO THE ICNIRP
REFERENCE LEVEL FOR LIMITED EXPOSURE TO
MEMBERS OF THE GENERAL PUBLIC



PROPOSED CONTRACTORS
ACCESS & MAINTENANCE
ROUTE

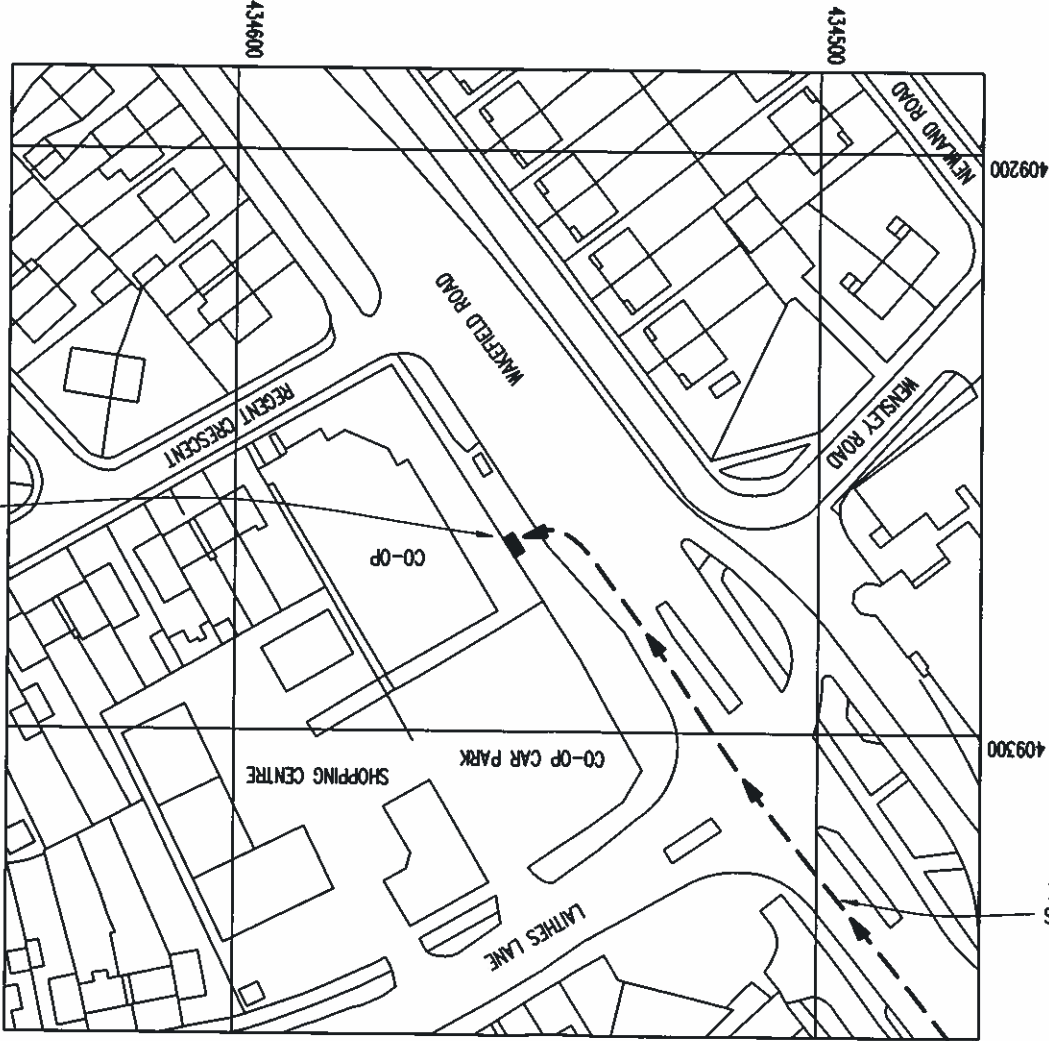

LOCATION PLAN


SCALE 1:1250
NGR E 434553
NGR N 409267
REPRODUCED FROM ORDNANCE SURVEY PROMAP DATA © CROWN COPYRIGHT 2012

No.	Revision	Date	By	ckd
PURPOSE OF ISSUE				
● Approval ● Planning ● Legal ○ Construction ○ As-built				
 everything everywhere Hartfield Business Park Hartfield Hertfordshire AL10 9BW Tel: 01707 315000 Fax: 01707 319001 WHP Wilkinson Helsby St. James Court Wilderspool Causeway Warrington WA4 6PS Tel: 01925 424100 Fax: 01925 424101 e-mail: info@wilkinson-helsby.co.uk				
Client CELL No. 96046				
Contract WAKEFIELD ROAD DNS ATHERSLEY BARNSELEY S71 3TY				
Title PROPOSED TELECOMMUNICATIONS STREETWORKS INSTALLATION SITE LOCATION				
Designed PSN	Checked SPN	Date 18.04.12	REVISION	
Drawn PSN	Approved SPN	Scale AS SHOWN	DRAWING No. 008 061-01	



- NOTE
1. STREETWORKS SAFETY SIGN ATTACHED TO TOWER 2000 BELOW ANTENNA ON ACCESS SIDE
 2. ELECTRICAL SAFETY SIGN TO BE FITTED ON OUTSIDE OF METER CABINET DOOR.
 3. ENTRY SIGN TO BE FITTED ON INSIDE OF STREETWORKS CABINET DOORS.
 4. ANTENNA-1 SAFETY SIGN TO BE FITTED TO BACK OF ANTENNA AND TO TOWER 200 BELOW EACH ANTENNA ON BORE SIGHT

SITE PLAN
SCALE 1:200

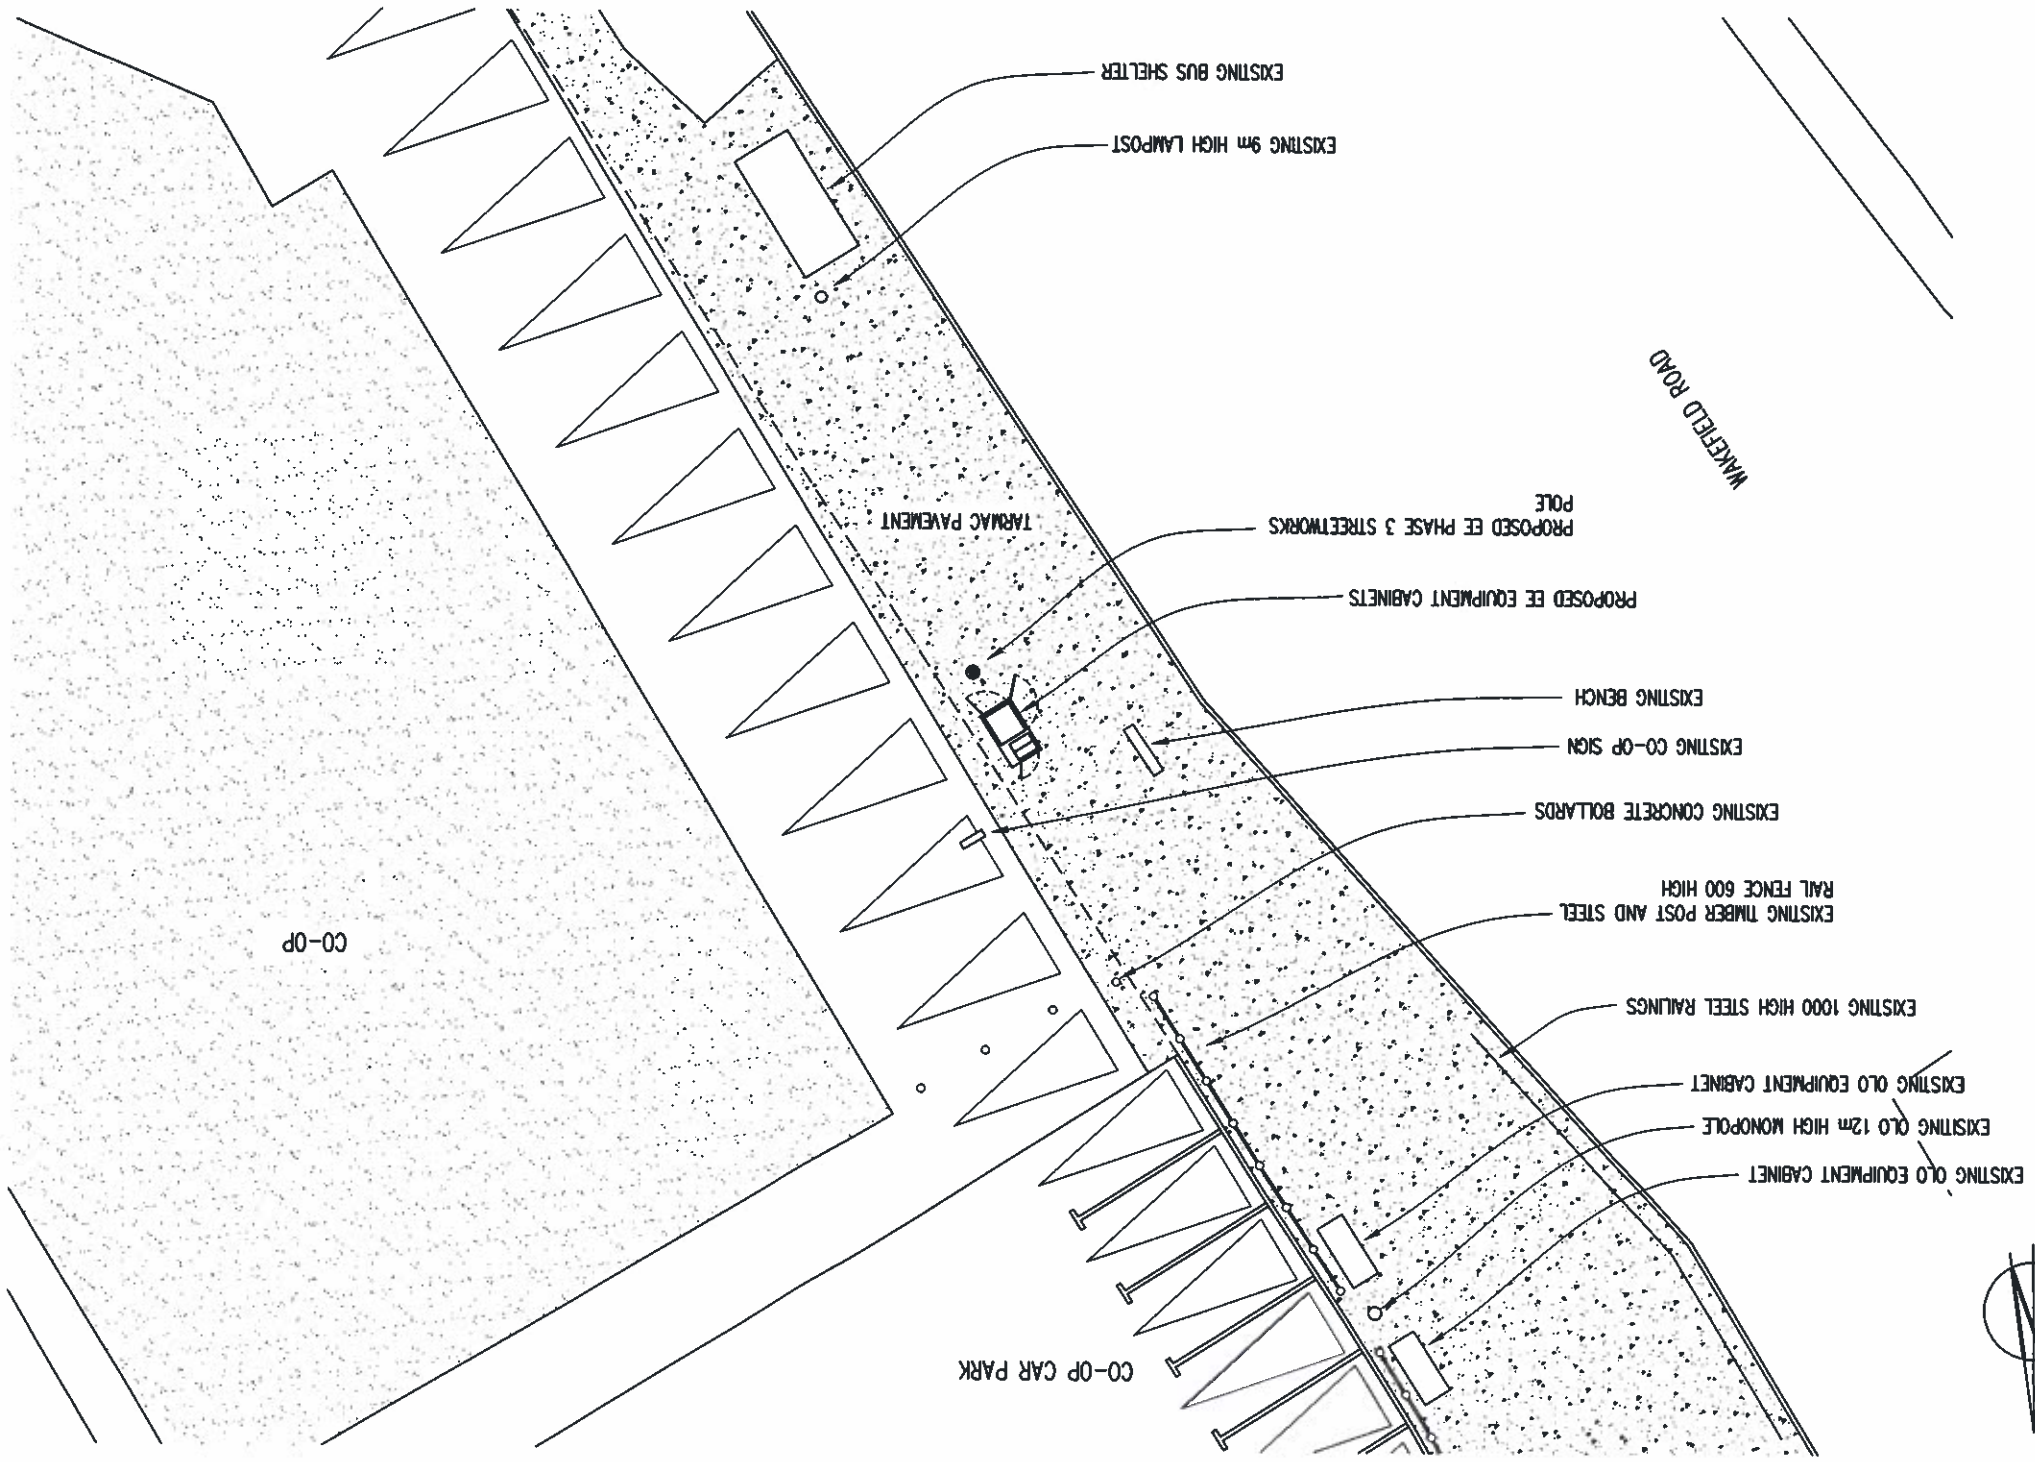

No.	Revision	Date	By	ckd
PURPOSE OF ISSUE				
☐ Approval ☐ Planning ☐ Legal ☐ Construction ☐ As-built				
				
Hatfield Business Park Hatfield Hertfordshire AL10 9BW Tel: 01707 315000 Fax: 01707 319001				
 WHP Wilkinson Helsby St James Court Wilderspool Causeway Warrington WA4 6PS Tel: 01925 424100 Fax: 01925 424101 e-mail: info@wilkinson-helsby.co.uk				
Client CELL No. 96046				
Contract WAKEFIELD ROAD DNS ATHERSLEY BARNSTLEY S71 3TY				
Title PROPOSED TELECOMMUNICATIONS STREETWORKS INSTALLATION SITE LAYOUT				
Designed	PSH	Checked	SPH	Date 18.04.12
Drawn	PSH	Approved	SPH	Scale AS SHOWN
DRAWING No.	008 061-02			
REVISION				


A3

100mm
50mm
100mm



PROPOSED EQUIPMENT LAYOUT

SCALE 1:50

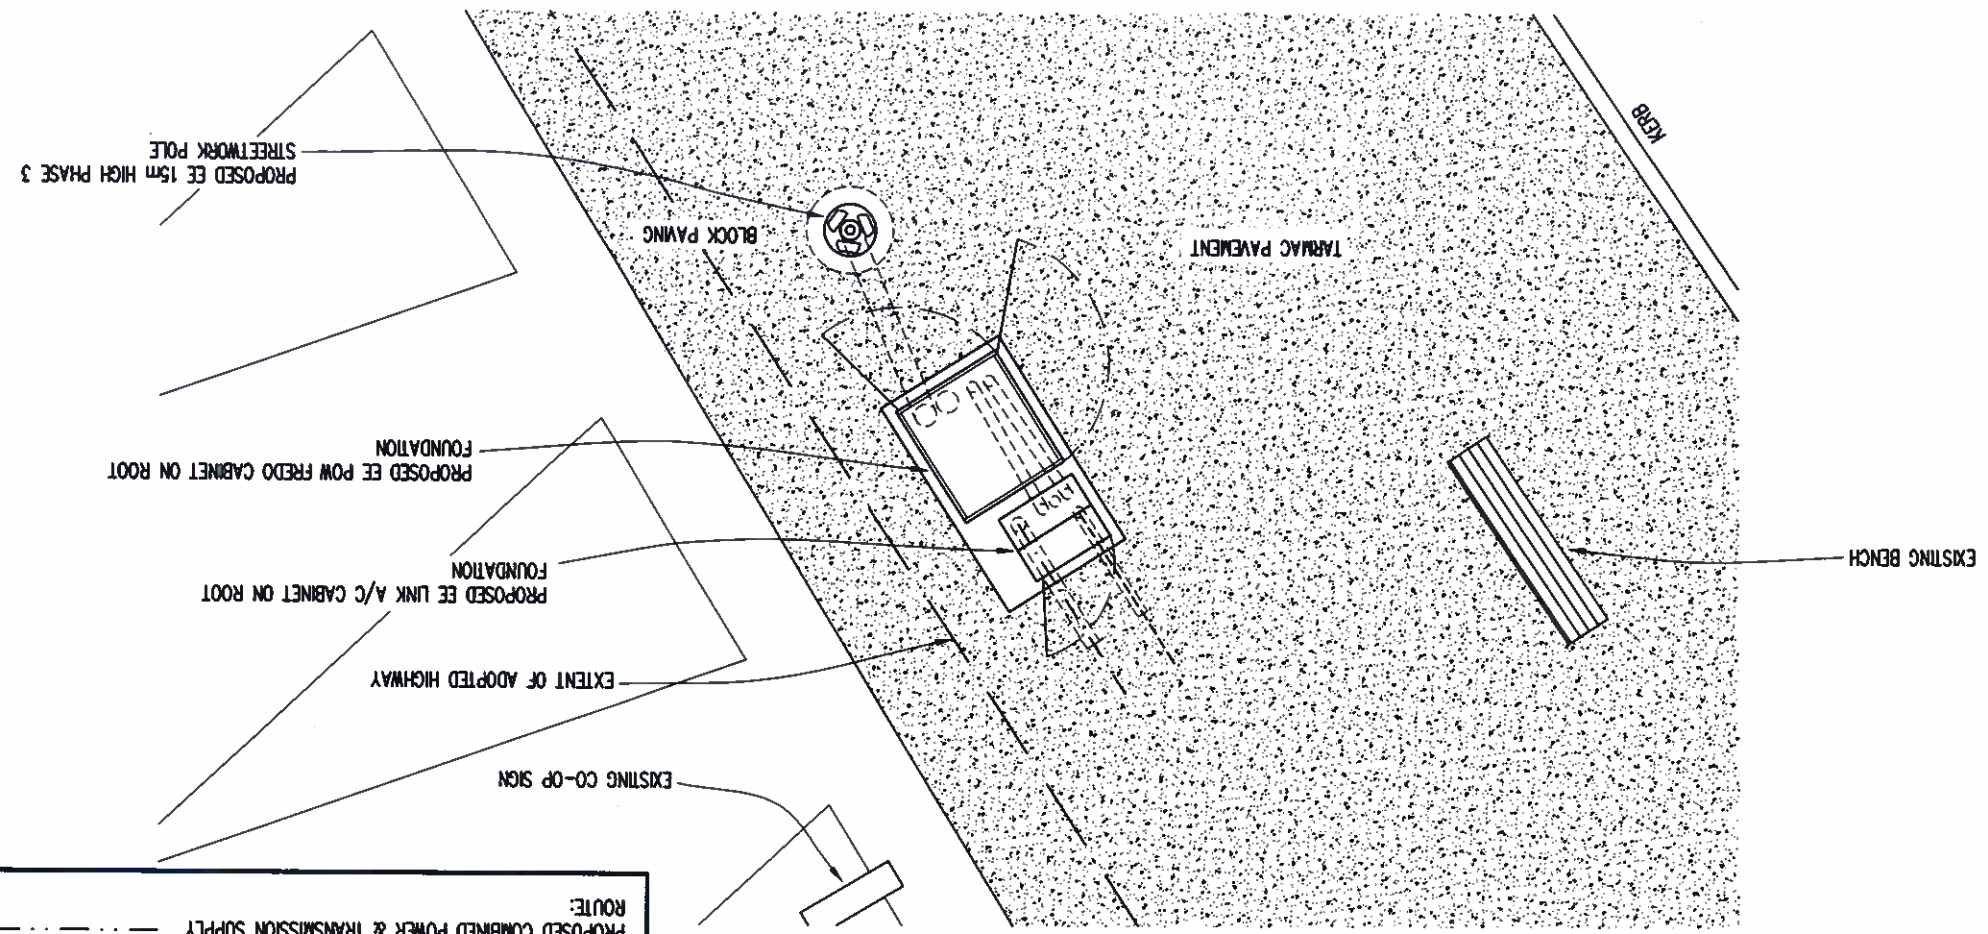

NOTE: ROUTE OF POWER AND TRANSMISSION SUPPLIES ARE APPROXIMATE AND ARE INDICATIVE ONLY


PROPOSED POWER SUPPLY ROUTE: ————

PROPOSED TRANSMISSION SUPPLY ROUTE: ————

PROPOSED COMBINED POWER & TRANSMISSION SUPPLY ROUTE: ————

ANTENNA DETAILS


SCALE 1:50

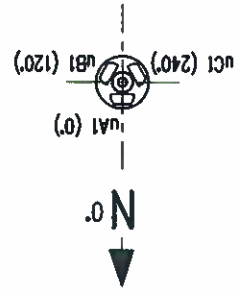

No.		Revision		Date		By		ckd	
PURPOSE OF ISSUE									
● Approval ● Planning ● Legal ● Construction ● As-built									
									
Hatfield Business Park Hatfield Hertfordshire AL10 9BW Tel: 01707 315000 Fax: 01707 319001									
									
WHP Wilkinson Helsby St. James Court Wilderspool Causeway Warrington WA4 6PS Tel: 01925 424100 Fax: 01925 424101 e-mail: info@wilkinson-helsby.co.uk									
Client		CELL No. 96046		Contract					
WAKEFIELD ROAD DNS		ATHERSLEY		BARNSELY S71 3TY					
Title		PROPOSED TELECOMMUNICATIONS STREETWORKS INSTALLATION EQUIPMENT LAYOUT							
Designed		PSH		Checked		SPH		Date 18.04.12	
Drawn		PSH		Approved		SPH		Scale AS SHOWN	
DRAWING No.		008 061-03							
REVISION									

No.		Revision		PURPOSE OF ISSUE		☐ Approval ☐ Planning ☐ Legal ☐ Construction ☐ As-built	
By		Date					
ckd							

everything everywhere Three.co.uk		Hatfield Business Park Hatfield Hertfordshire AL10 9BW Tel: 01707 315000 Fax: 01707 319001			
 WHP Wilkinson Helsby St James Court Willerspool Causeway Warrington WA4 6PS Tel: 01925 424100 Fax: 01925 424101 e-mail: info@wilkinson-helsby.co.uk		Client CELL No. 96046			
Contract WAKEFIELD ROAD DNS ATHERSLEY BARNSTLEY S71 3TY		Title PROPOSED TELECOMMUNICATIONS STREETWORKS INSTALLATION SITE ELEVATION			
Designed	PSH	Checked	SPH	Date	18.04.12
Drawn	PSH	Approved	SPH	Scale	AS SHOWN
DRAWING No.		008 061-04			
REVISION					

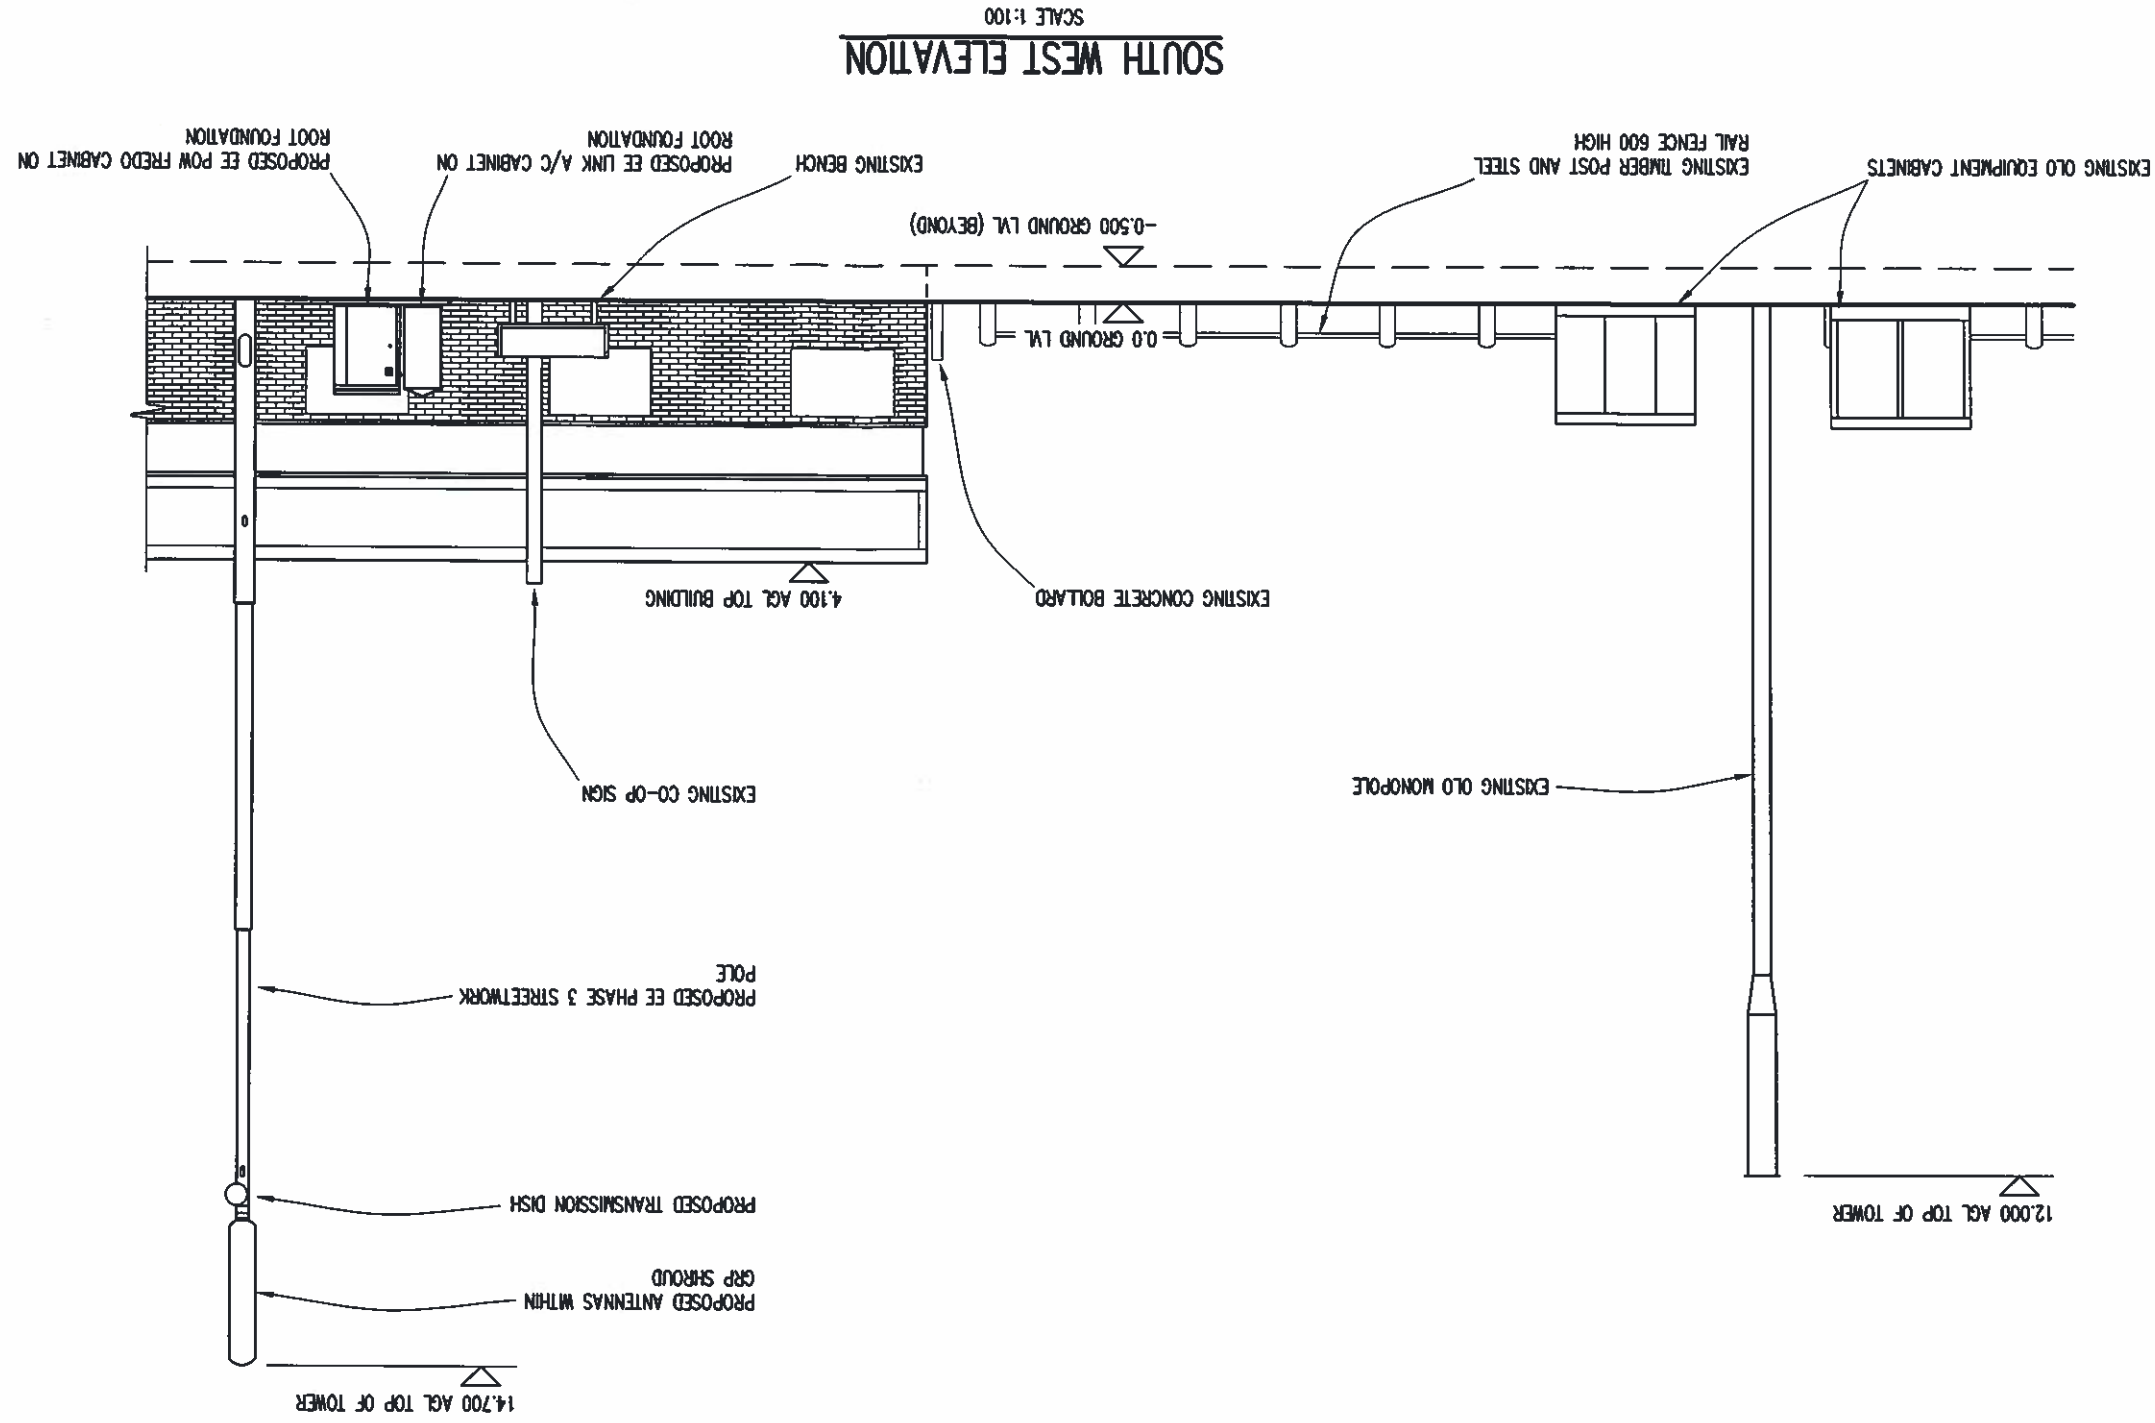

A3

10mm

50mm

100mm