
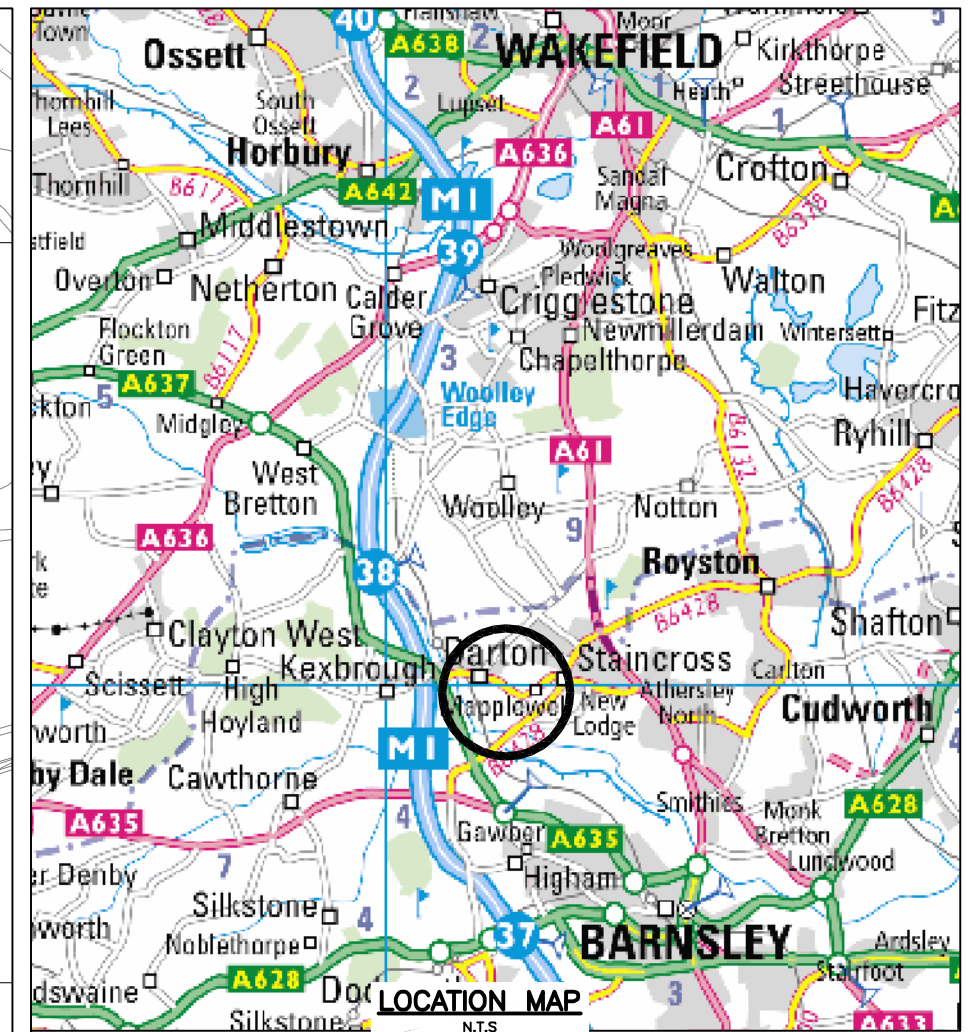


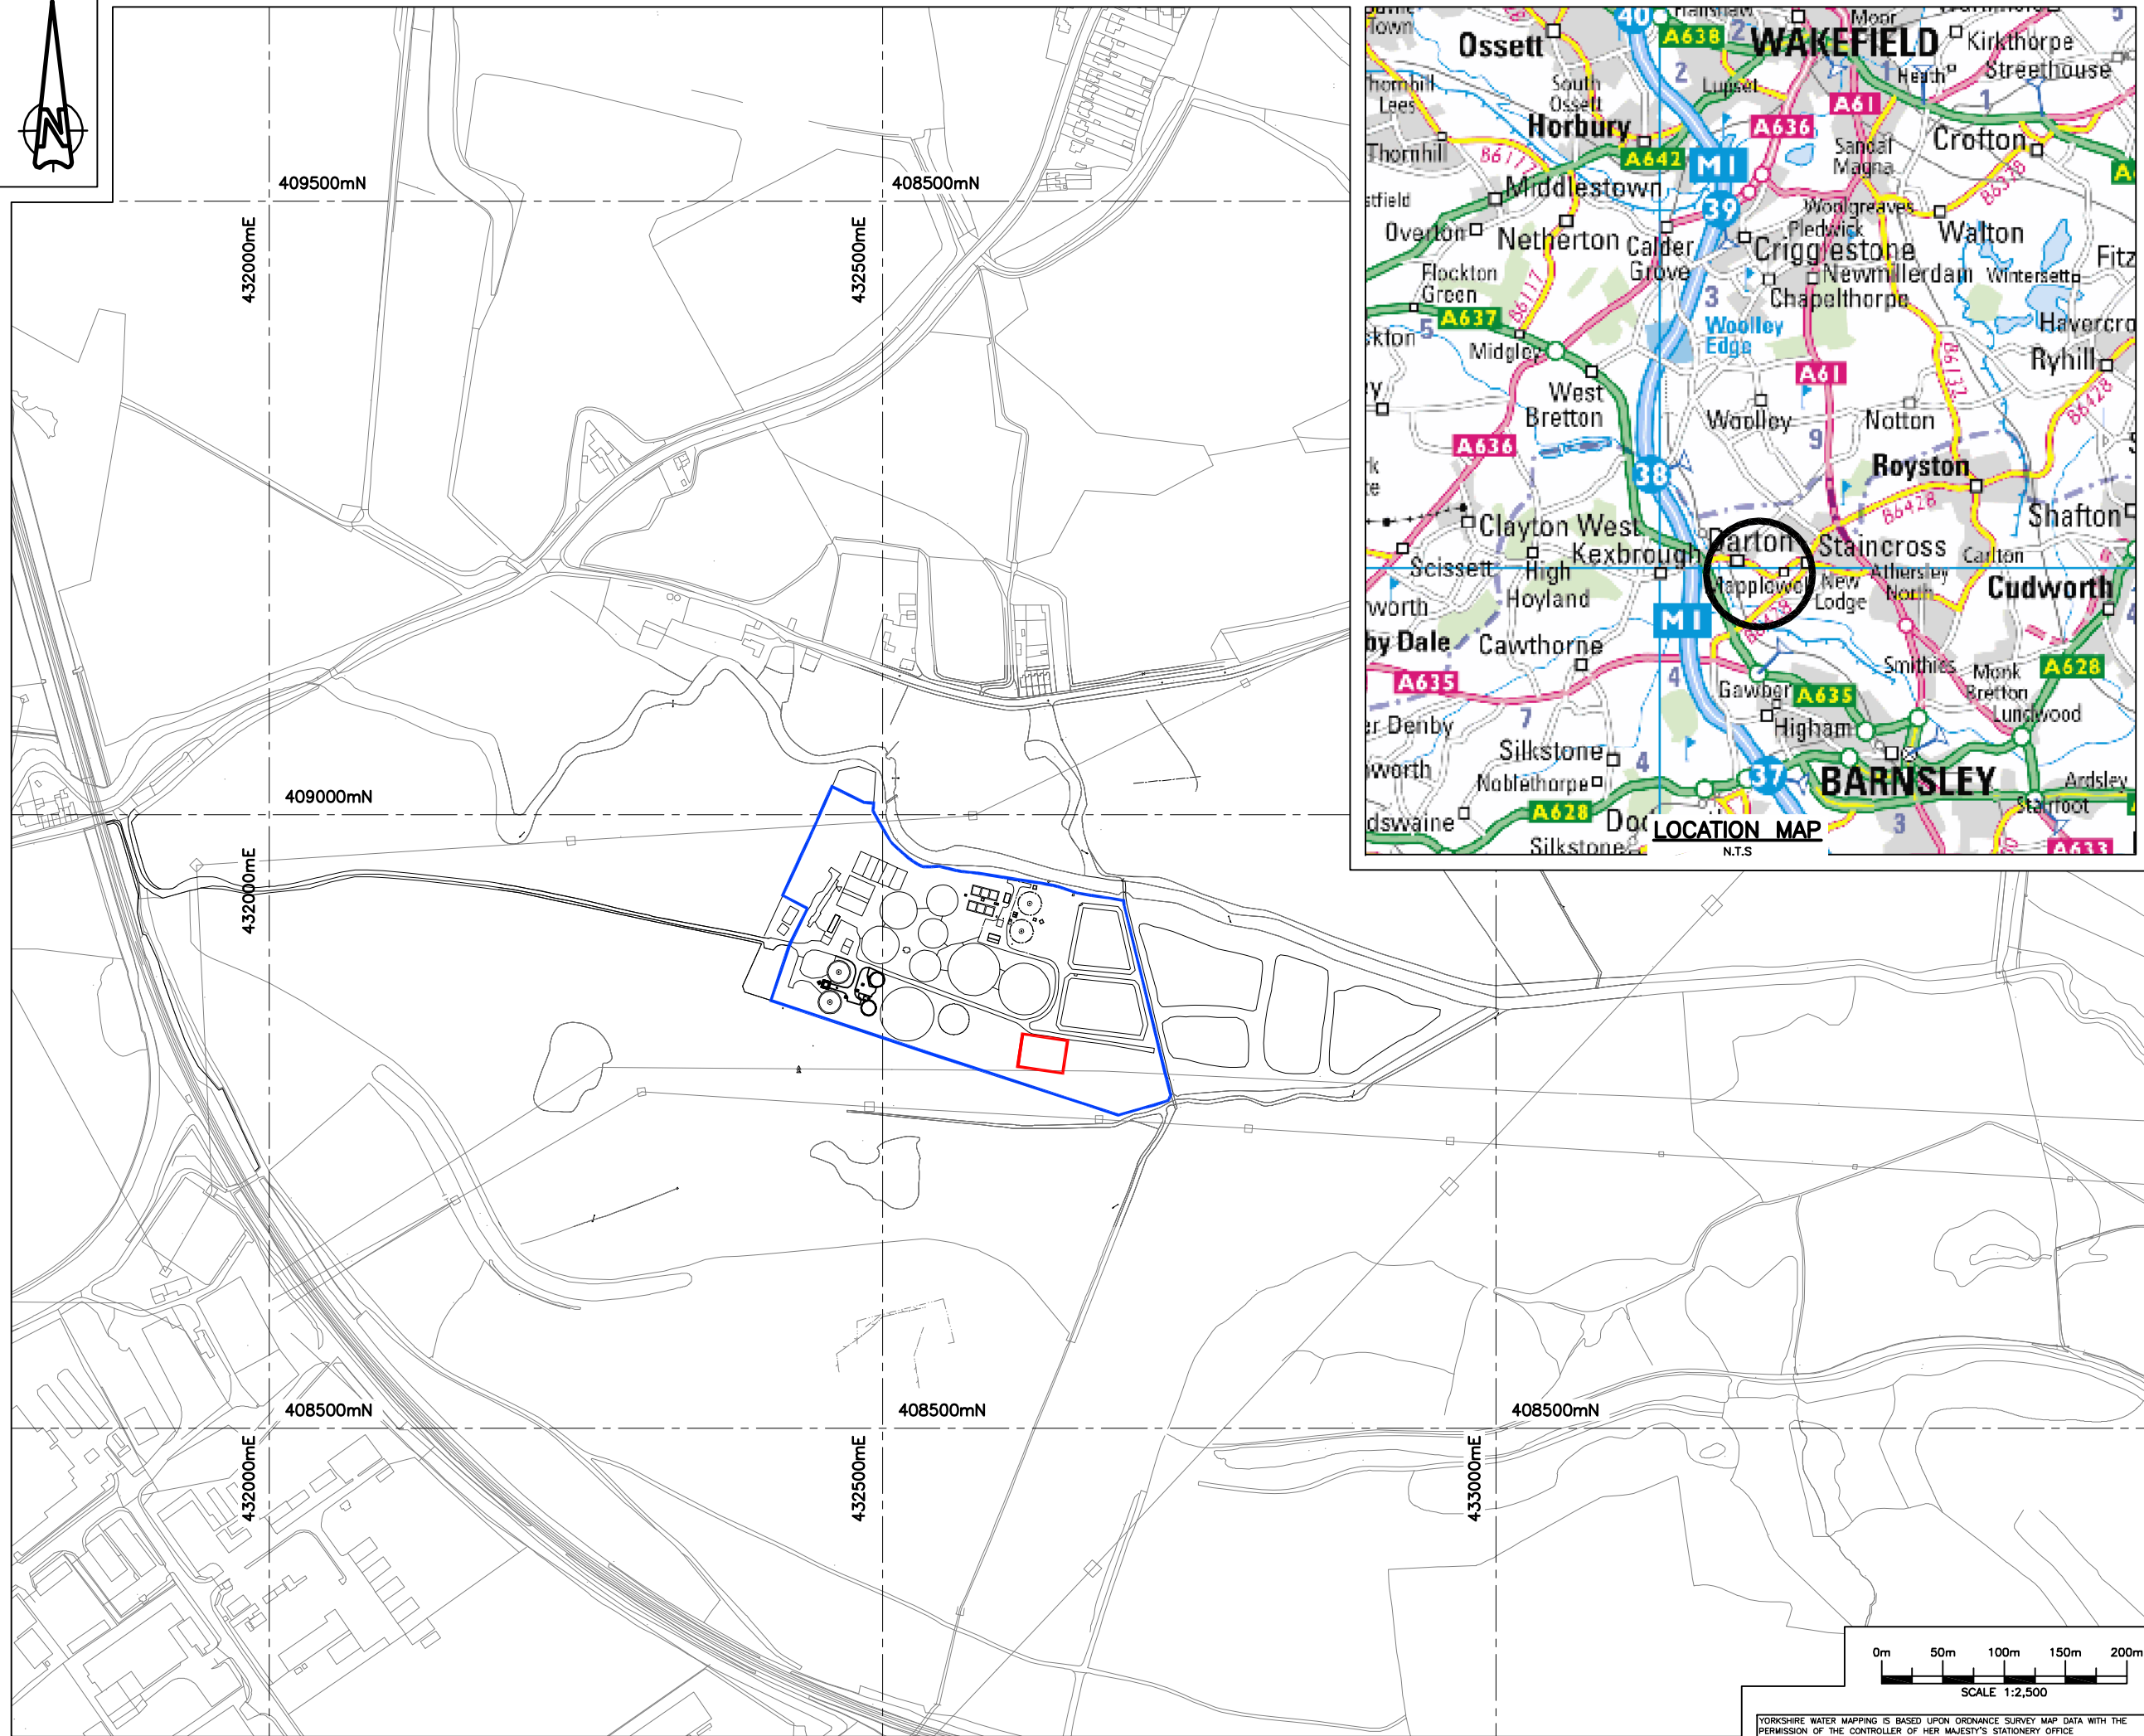

NOTES

1. ALL CIVIL WORKS TO BE COMPLETED IN ACCORDANCE WITH YORKSHIRE WATER SERVICES LIMITED CIVIL ENGINEERING SPECIFICATION FOR THE WATER INDUSTRY - 6TH EDITION INCORPORATING VERSION 11 OF THE ENGINEERING SPECIFICATION MARCH 2010.
2. ALL DIMENSIONS IN MILLIMETRES UNLESS STATED OTHERWISE.
3. ALL LEVELS IN METRES A.O.D. UNLESS STATED OTHERWISE.

LEGEND:

- APPLICATION BOUNDARY
- YORKSHIRE WATER LAND BOUNDARY

REV	DATE	DESCRIPTION	BY	CHKD	APP'D
-----	------	-------------	----	------	-------

REVISIONS

REV	DATE	FIRST ISSUE	BY	CHKD	APP'D
A	16/10/2012		AMH	DH	RBS

MULTIDISCIPLINARY CHECK BOX

REV	DATE	CIV	PR	ME	EL	ICA	STRUC	GEO	P&ENV
A	16/10/2012	DH	N/A	N/A	N/A	N/A	N/A	N/A	N/A



BYZAK ENTEC
LIVINGSTONE HOUSE
CHADWICK STREET
LEEDS
LS10 1LJ

EMPLOYER
YORKSHIRE WATER
SERVICE LTD.

YWS PROJECT NO.
R0444

YWS PROJECT TITLE
MTM100297
AMP5 MEDIUM TREATMENT
CROFTON, DARTON, LINDHOLME
AND LEVEN BATCH

 
TITLE
DARTON STW
SITE PLANNING LOCATION PLAN

LEAD DISCIPLINE / CATEGORY
CIVIL

STATUS
DESIGN

DRAWING SCALE (DO NOT SCALE) ORIGINAL DRAWING SIZE
1:2500 594 x 841 - A1

DRAWING No. 2012/R0444/02/3000 REV. A



YORKSHIRE WATER MAPPING IS BASED UPON ORDNANCE SURVEY MAP DATA WITH THE PERMISSION OF THE CONTROLLER OF HER MAJESTY'S STATIONERY OFFICE
(C) CROWN COPYRIGHT LICENCE No.1000019559