


PROPOSED BASEMENT PLAN 1:50



PROPOSED GROUND FLOOR PLAN 1:50

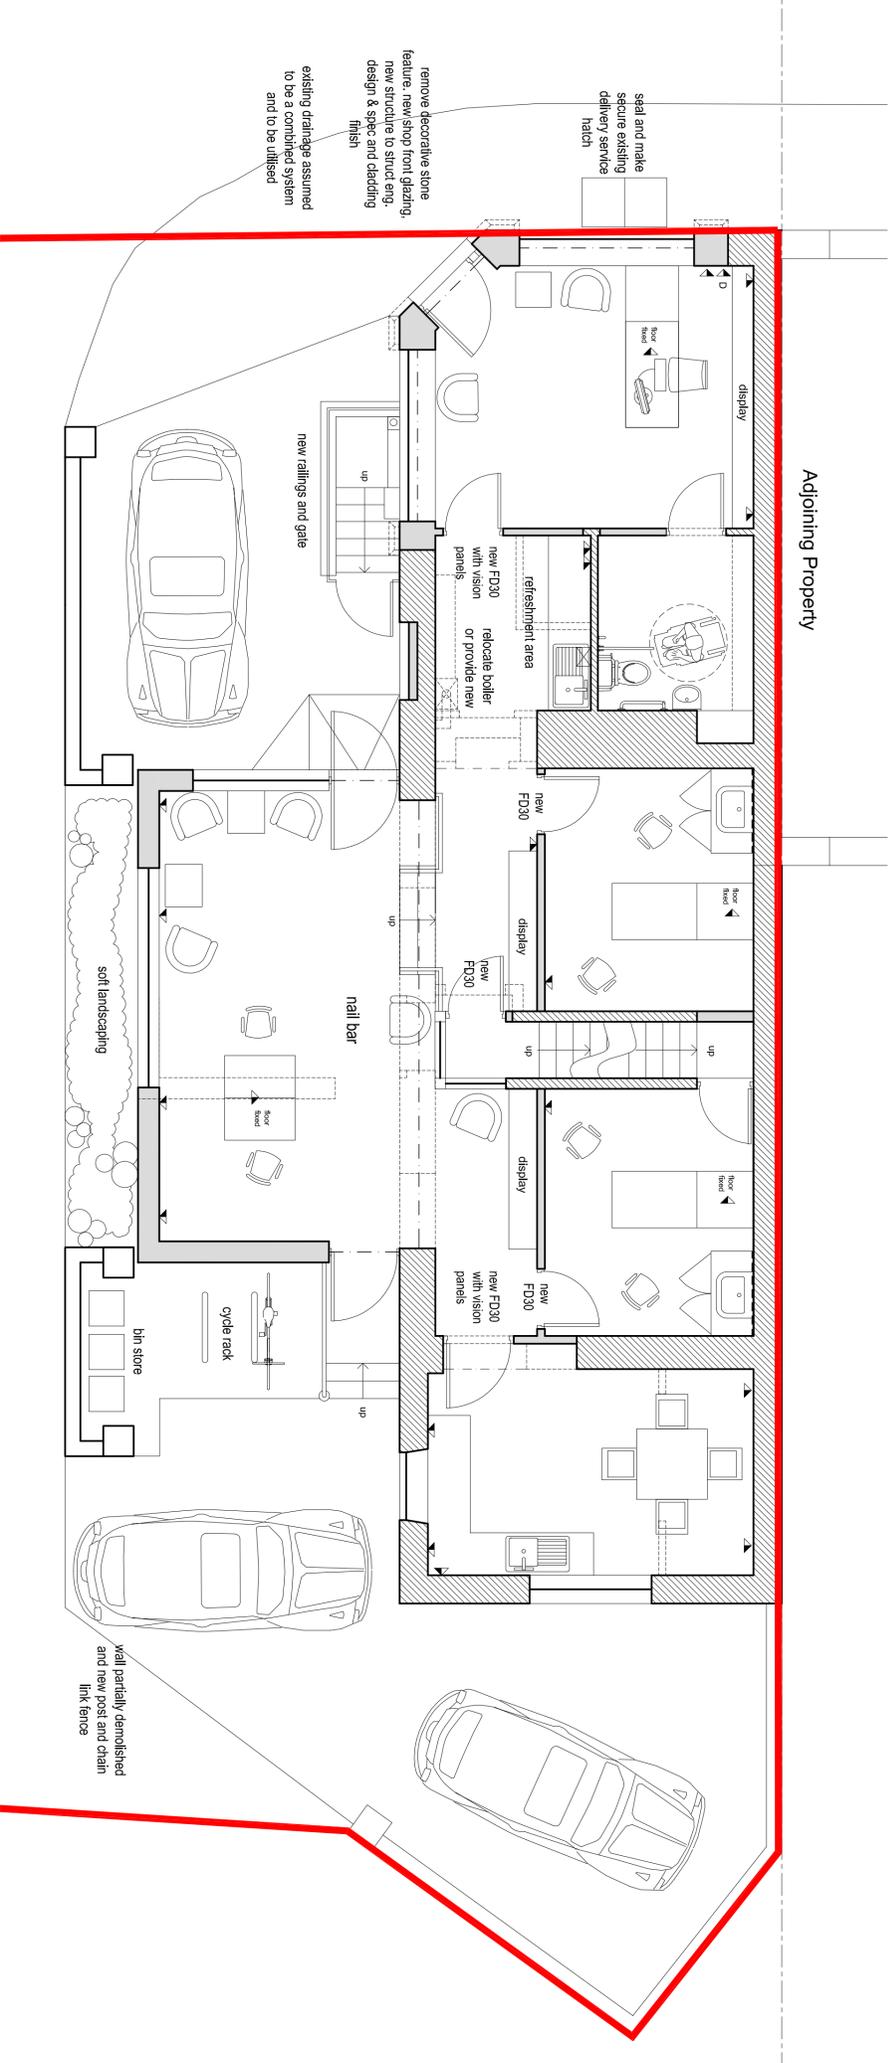

- NOTES**
1. This drawing is copyright.
  2. Do not scale from drawing.
  3. Contractor to check and verify that dimensions, details, drainage layouts etc. correspond to working drawings before providing client with final quotation, commencing work on site or fabricating specific bespoke items.
  4. Contractor / Subcontractor to bring any discrepancy to the attention of the Architect.
  5. Client and Contractor to study and understand the contents of drawings and approvals relating to the project as no claim arising out of the failure to do so will be entertained.
  6. Conditions stated in either the current title deed or council approvals should be complied with to the satisfaction of the local authority or any other relevant party.
  7. All applicable health and safety requirements to be complied with during and after construction.
  8. Drawing to be read in conjunction with specifications, notes and structural calculations.

Rev	Date	By	Note
A	18/11/20	DM	room name changed
B	23/10/20	DM	scheme changed & reduced as per comments

Project	Extension & Alterations for Ms Amy Sloyes at: 54 Smithies Lane, Barnsley, S71 1QW.
Drawing Title	Proposed Plans 1
Drawing no.	11
Scale	STATED @ A1
Date	02/07/20
Drawn	DM
Stage	Planning
Revision	B