




SOUTH WEST ELEVATION 1:100

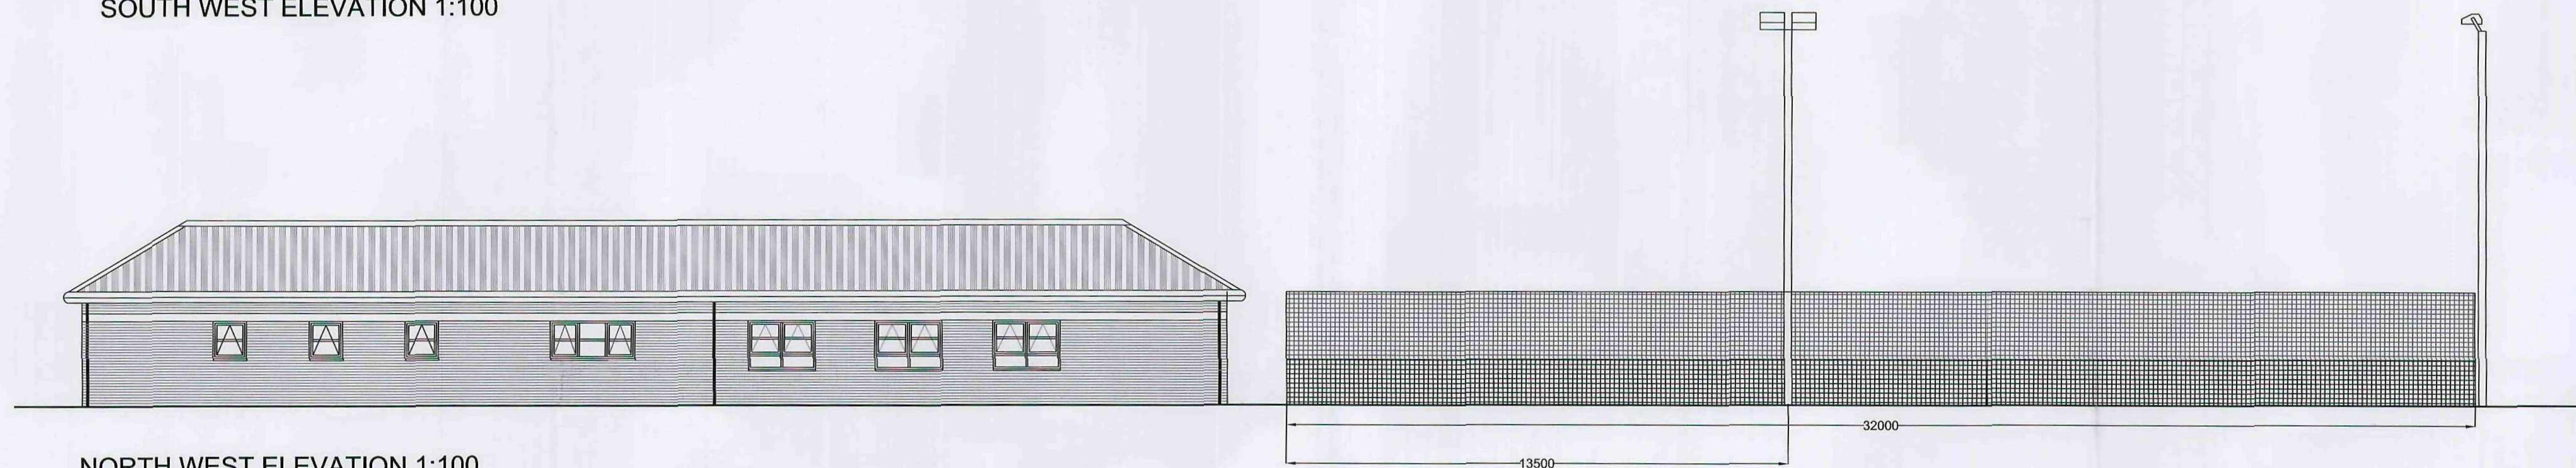

NORTH WEST ELEVATION 1:100

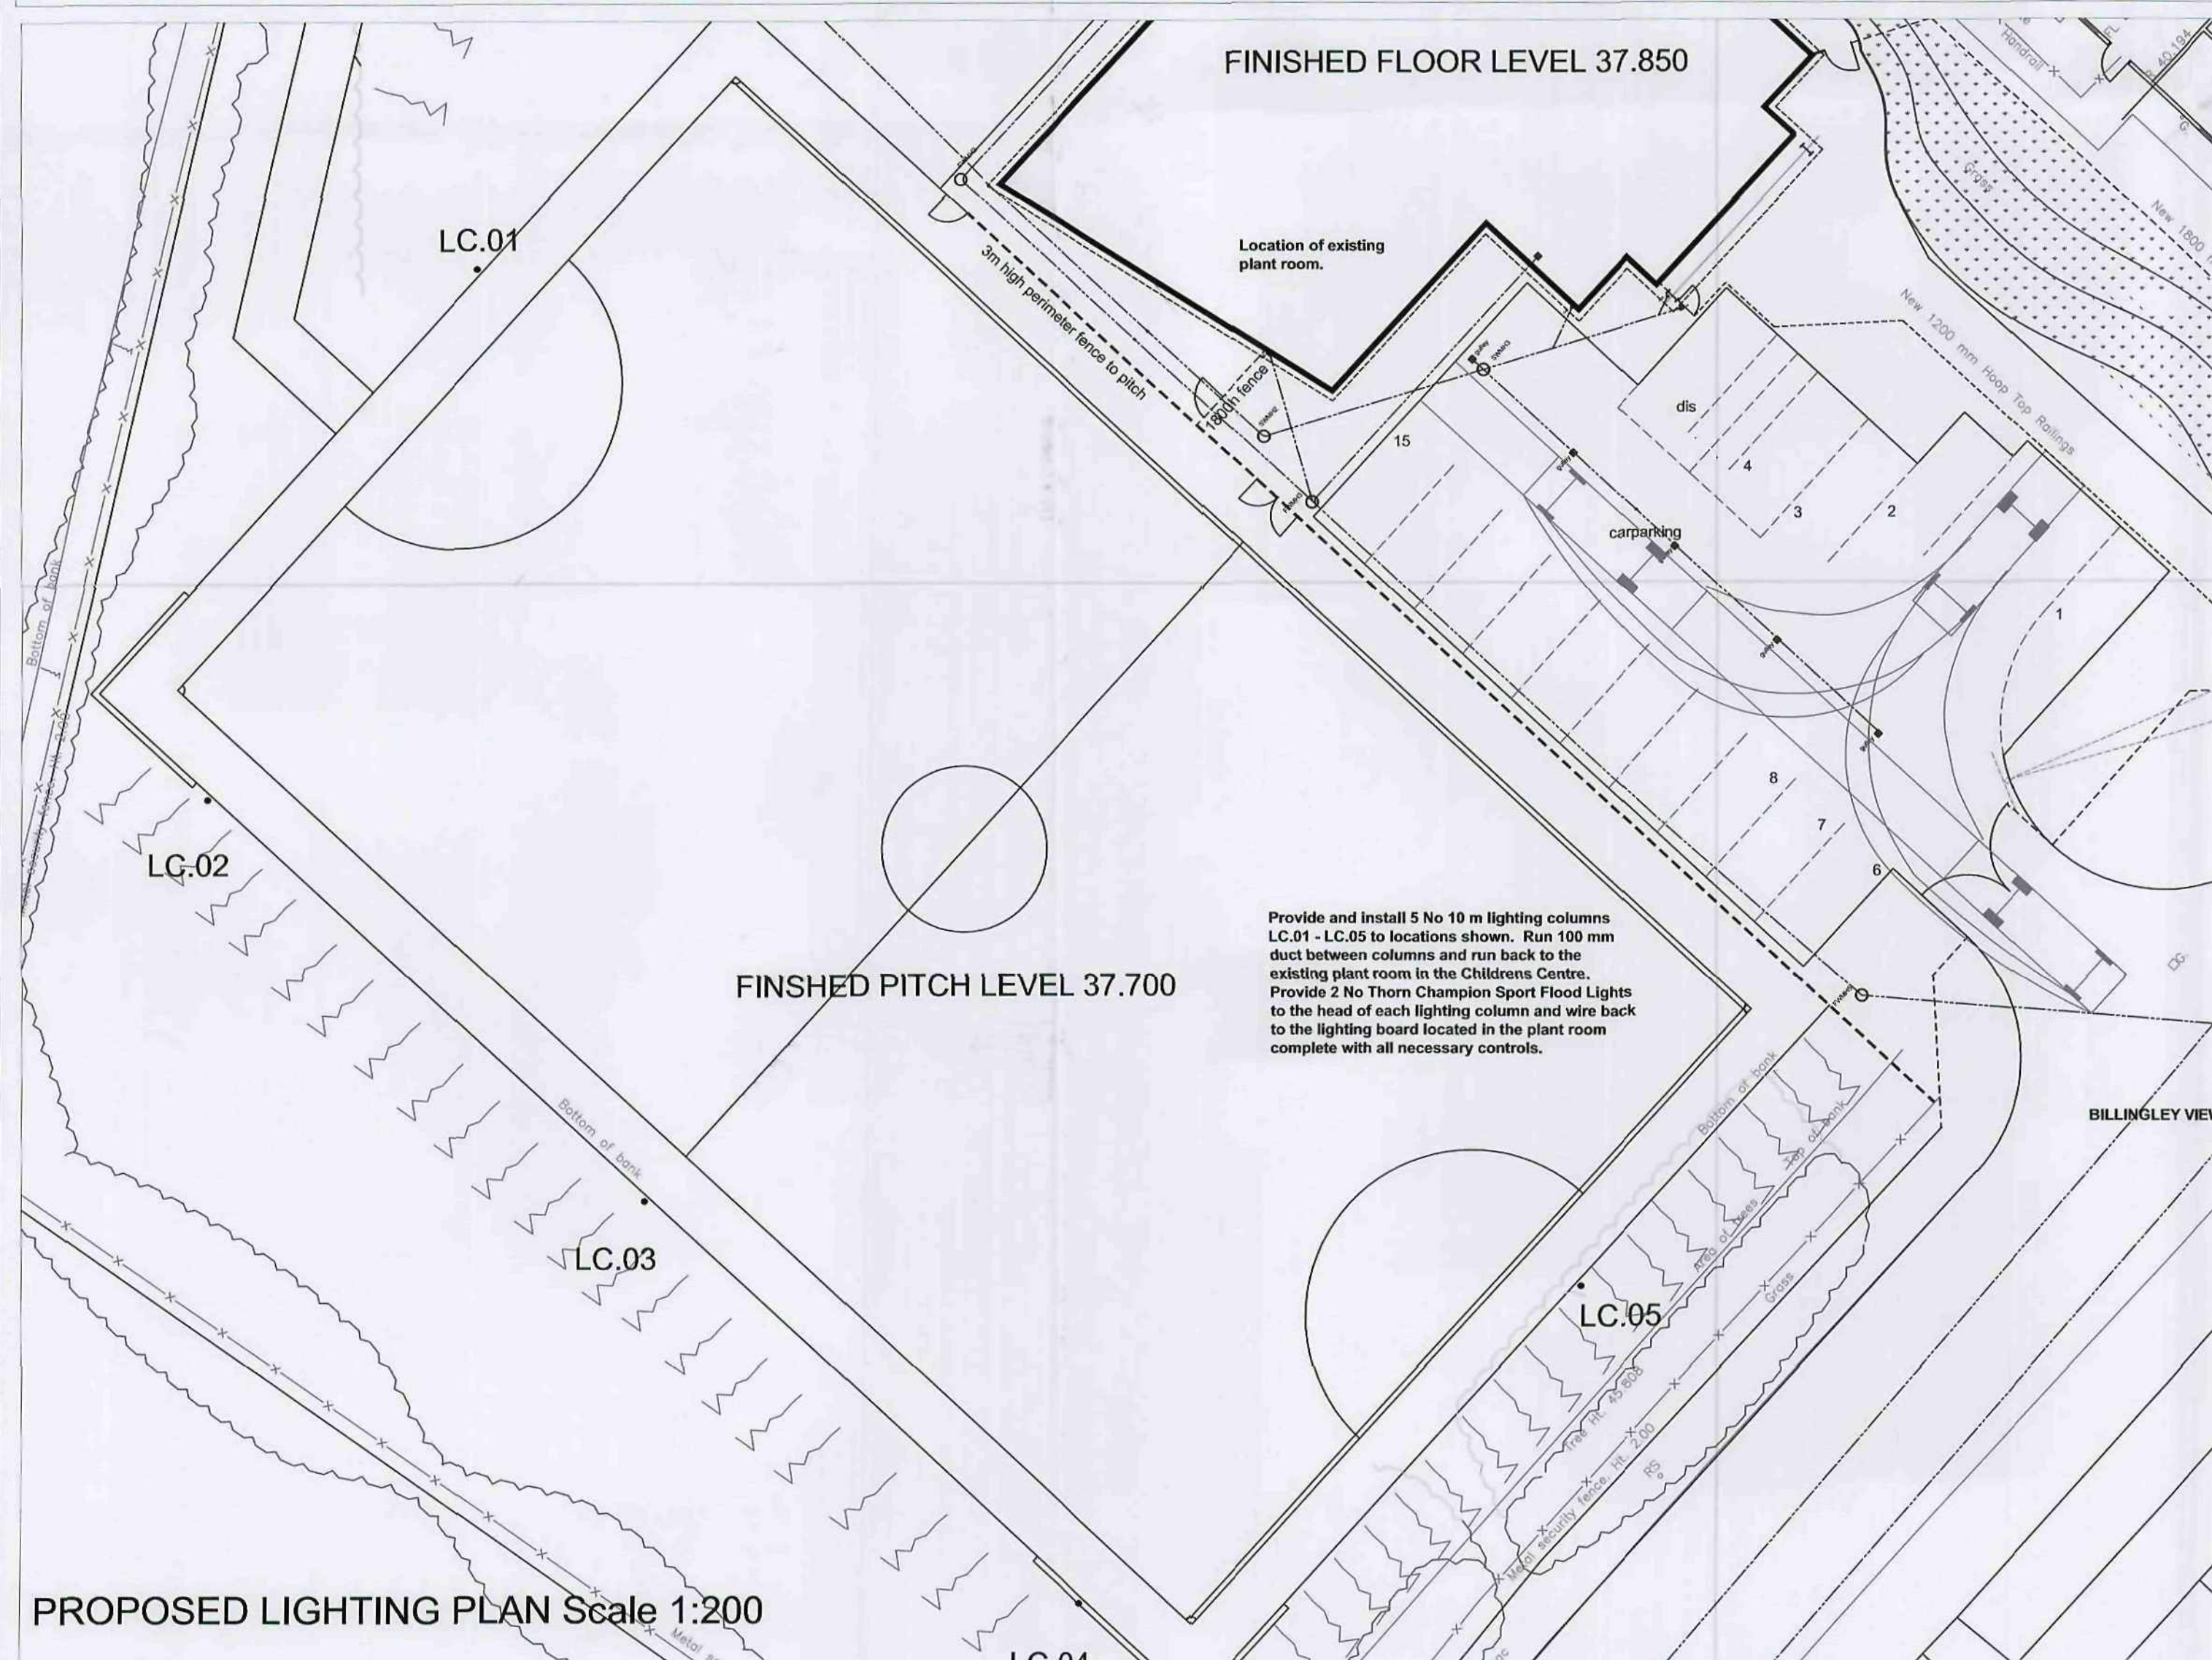

PROPOSED LIGHTING PLAN Scale 1:200

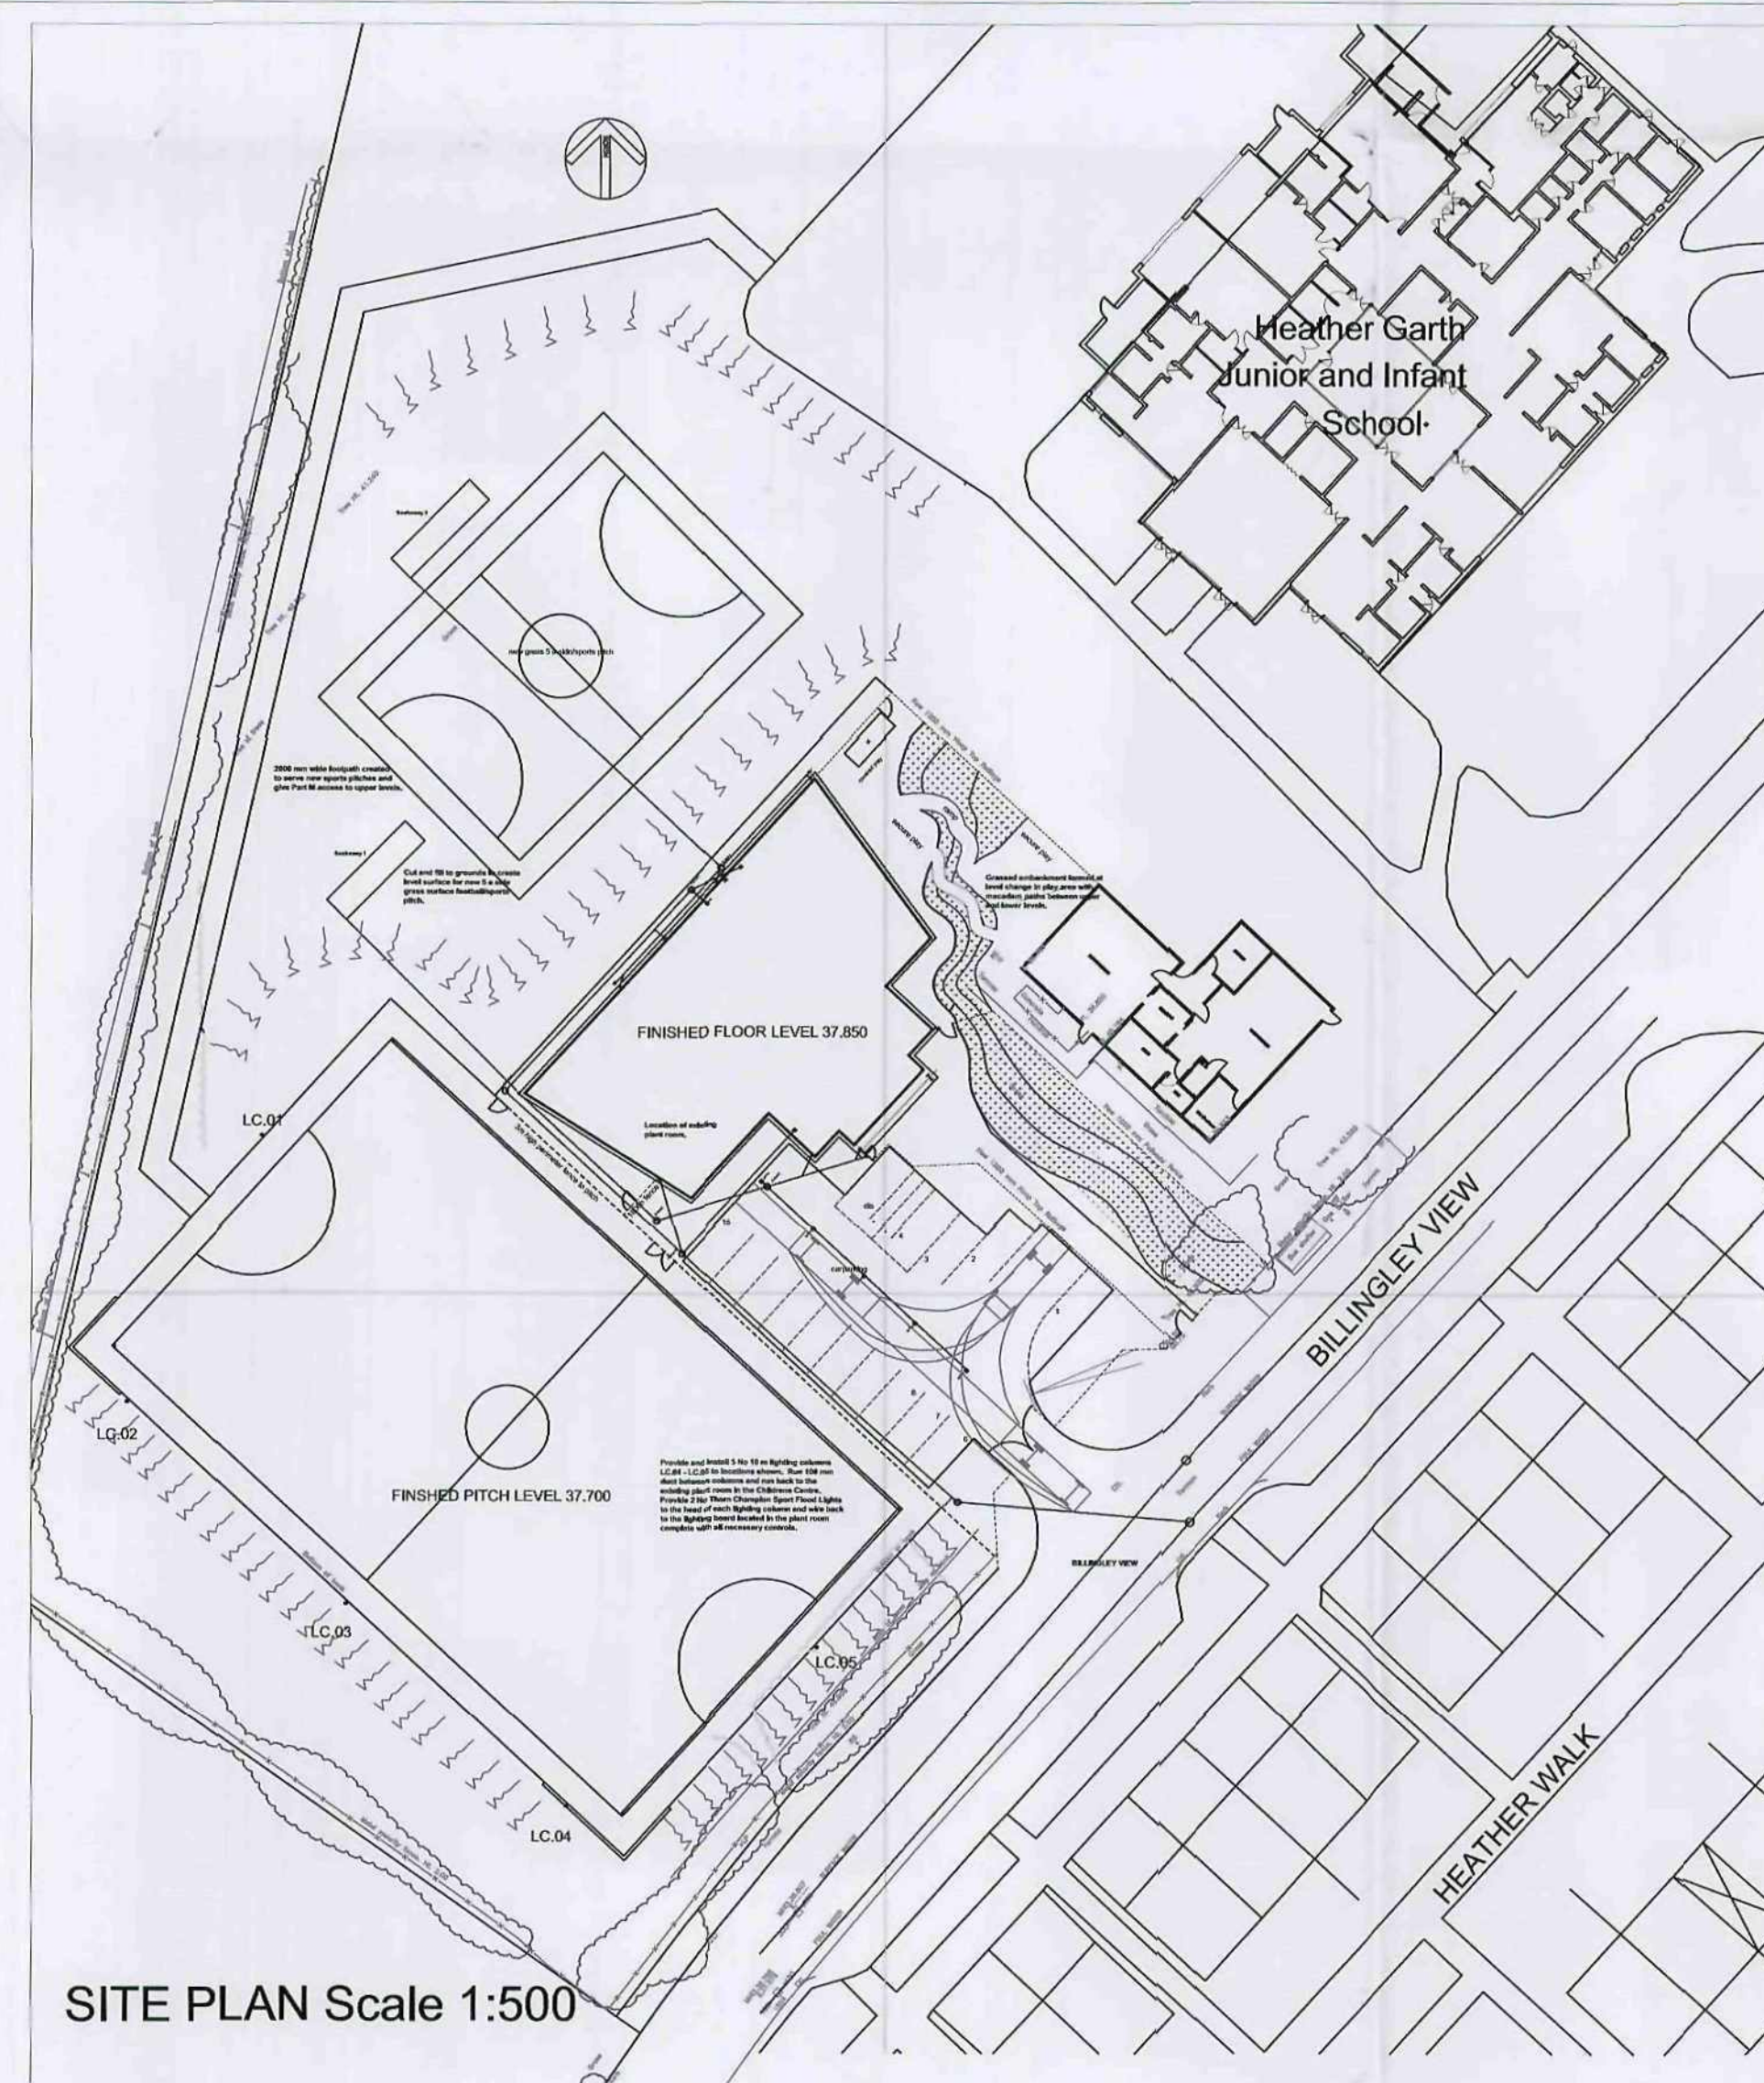

SITE PLAN Scale 1:500



Arcus Consulting LLP
Alexandra House 2 Well Lane Chapel Allerton Leeds LS7 4PQ
T: 0113 2185350 www.arcus.uk.com
F: 0113 2185351 info@arcus.uk.com

Client:
BARNESLEY EDUCATION DEPARTMENT

Project:
HEATHER GARTH PRIMARY SCHOOL
CHILDRENS CENTRE SPORTS FACILITIES

Title:
PROPOSED LIGHTING TO MUGA

Scale:
VARIOUS

Date:
10.07.09

Job No:
1543

Drawing No:
01A

Drawn:
AW

Approved:
This drawing is the copyright of Arcus. Contractors must check all dimensions on site. Only figured dimensions are to be worked to.