




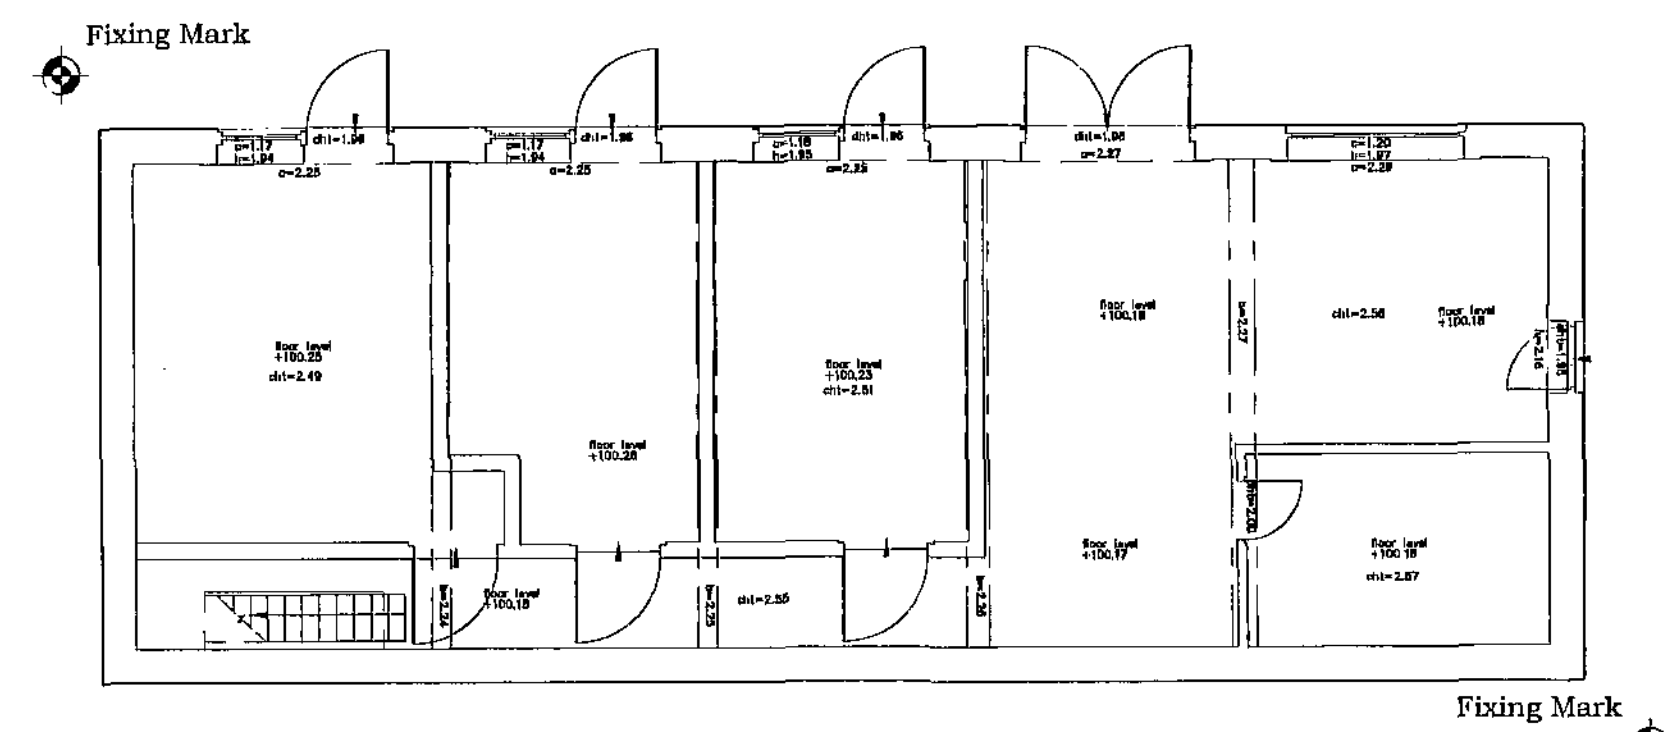


GROUND FLOOR PLAN

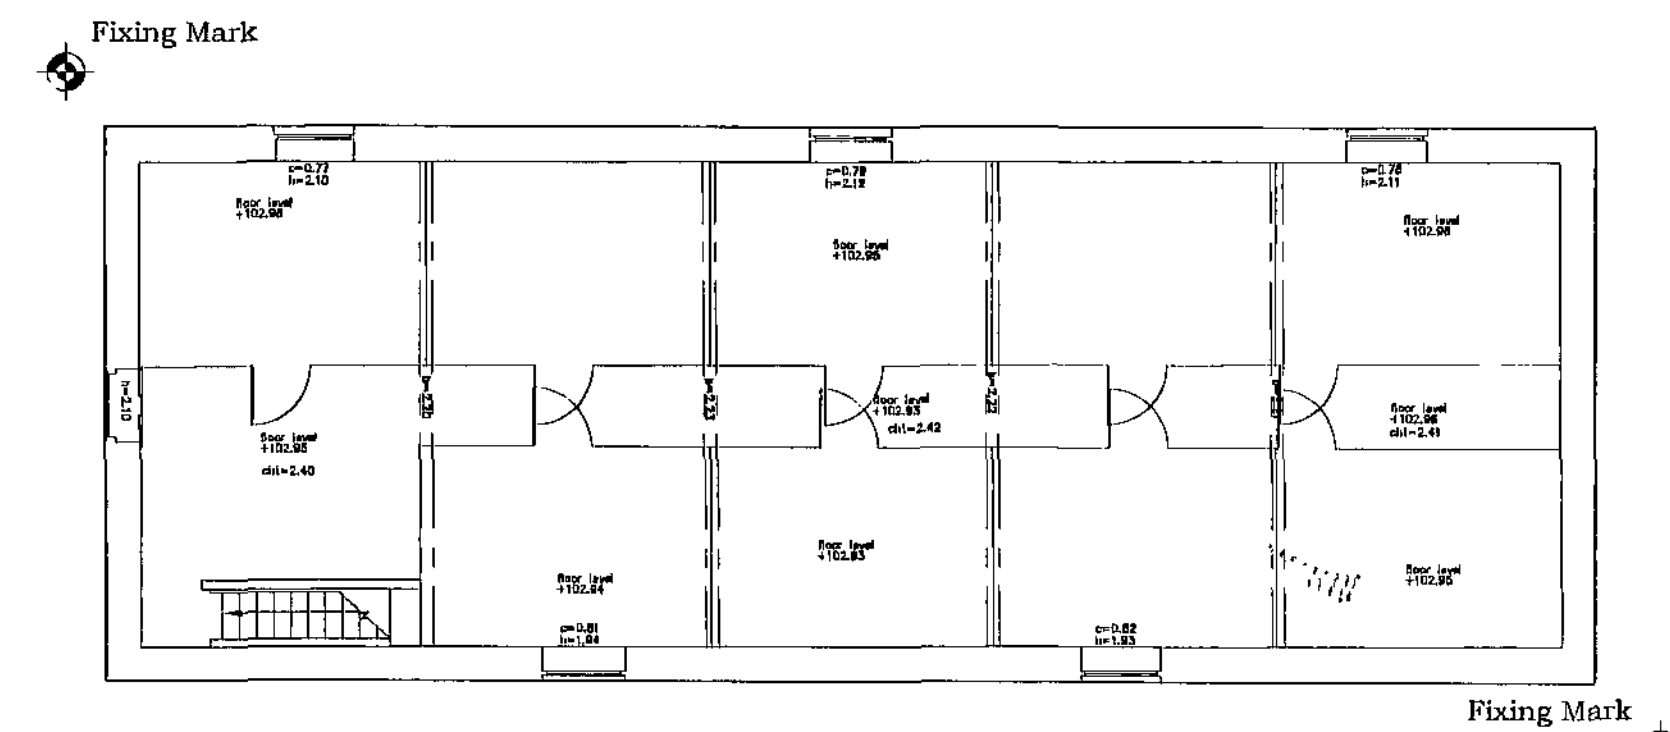


FIRST FLOOR PLAN

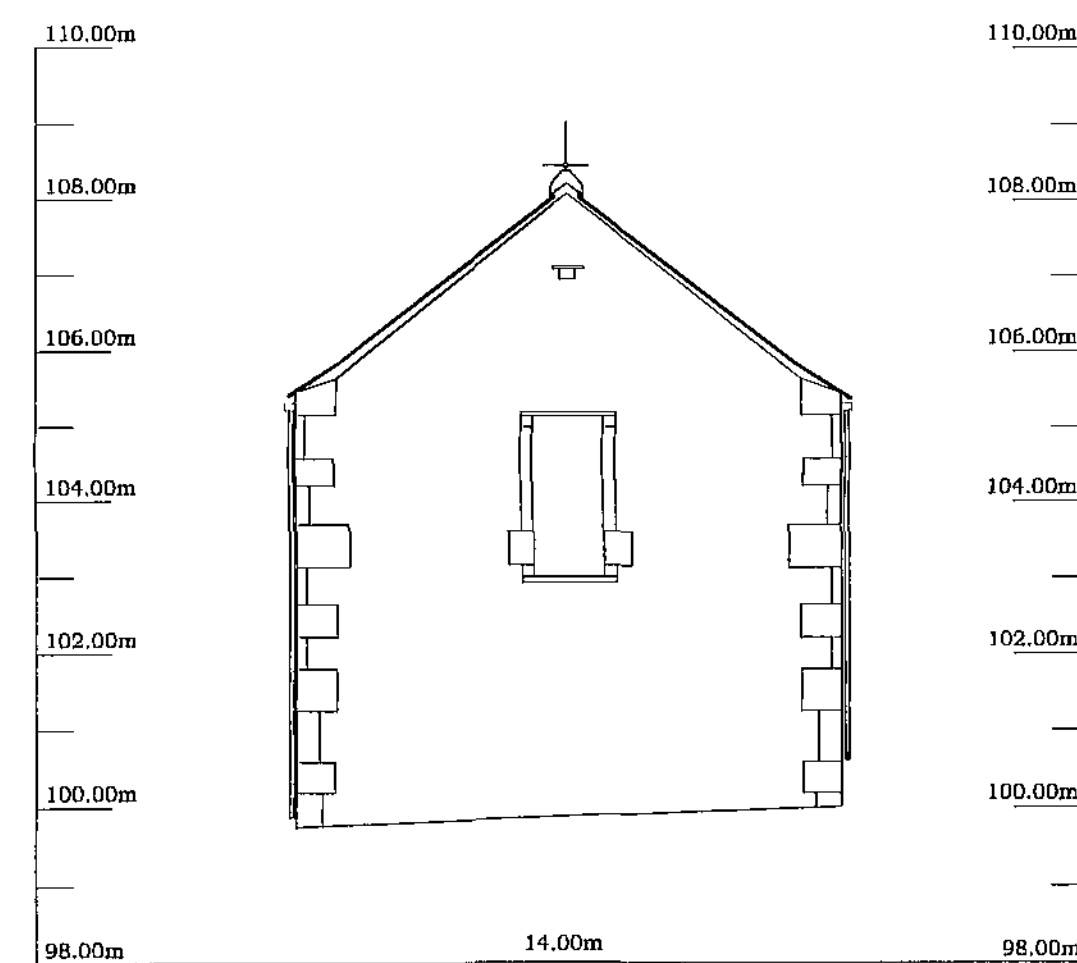


NORTH WEST ELEVATION

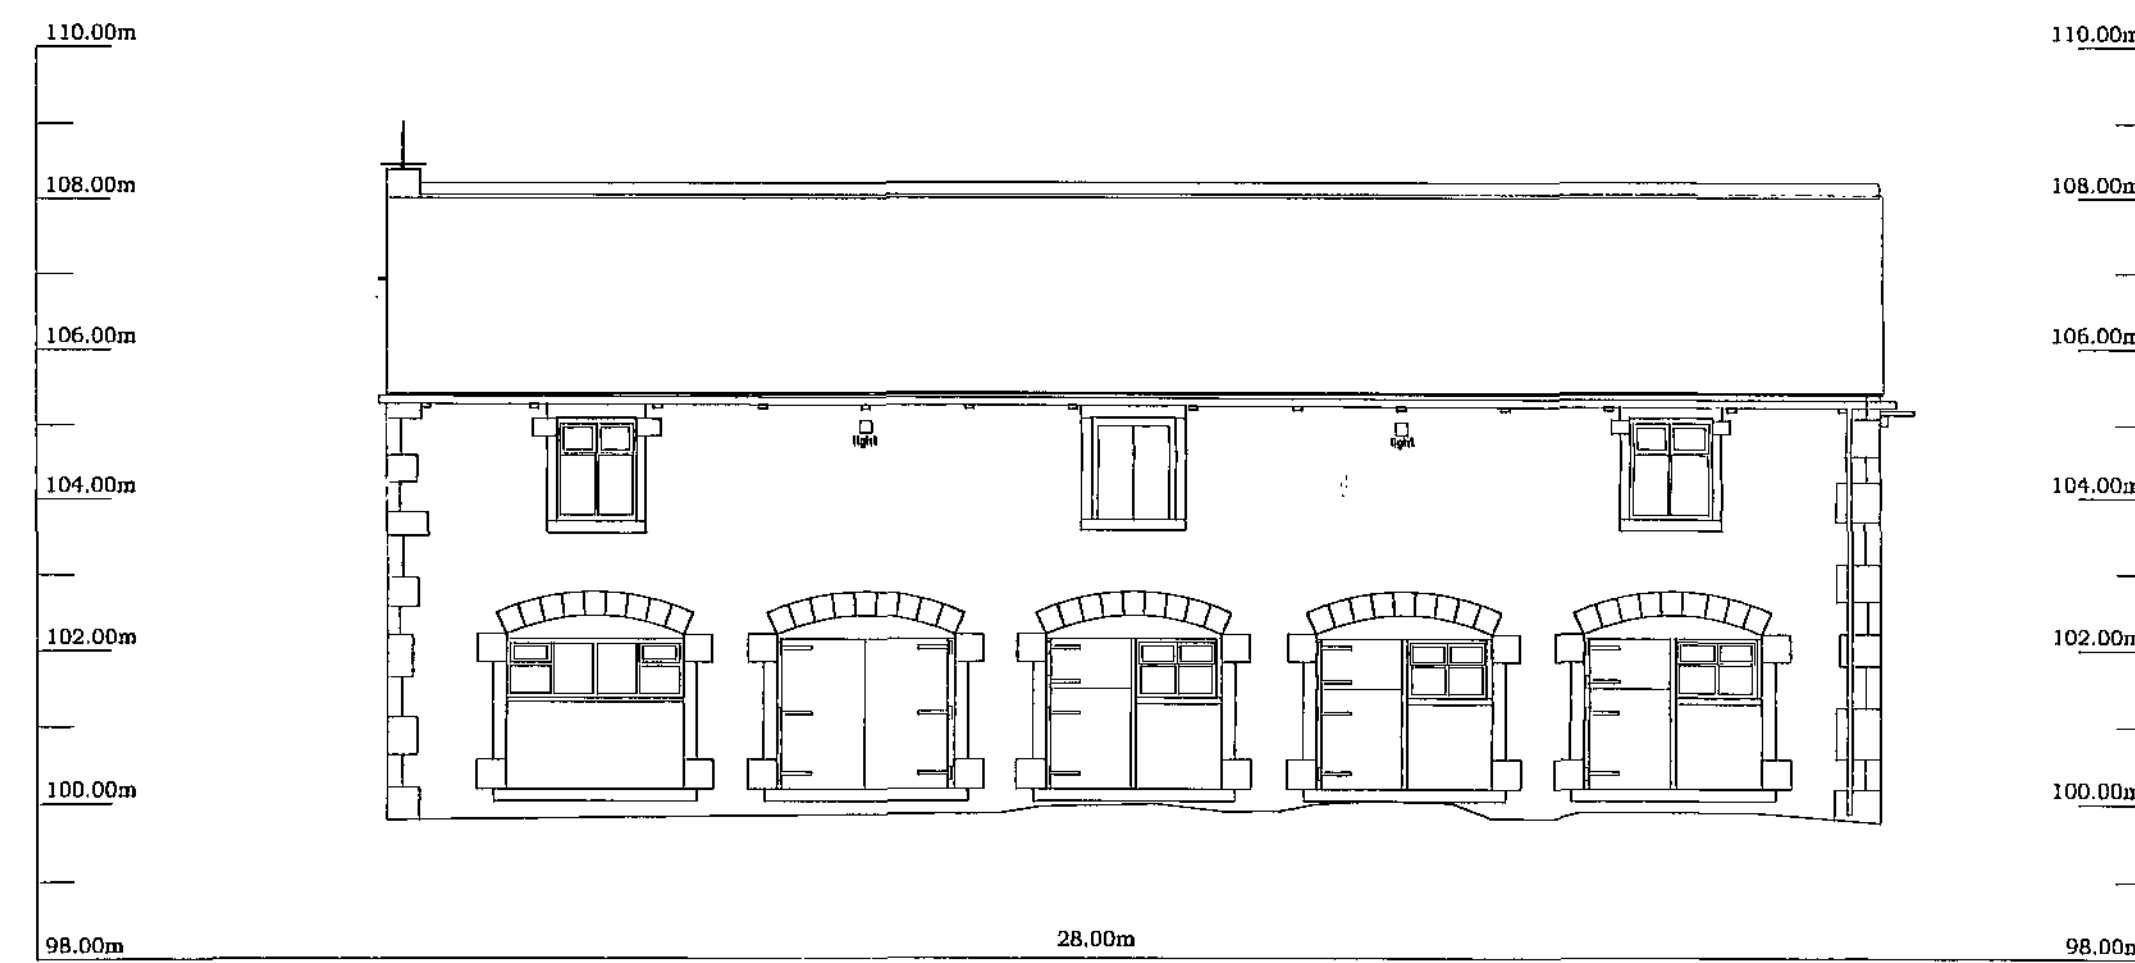

NORTH EAST ELEVATION

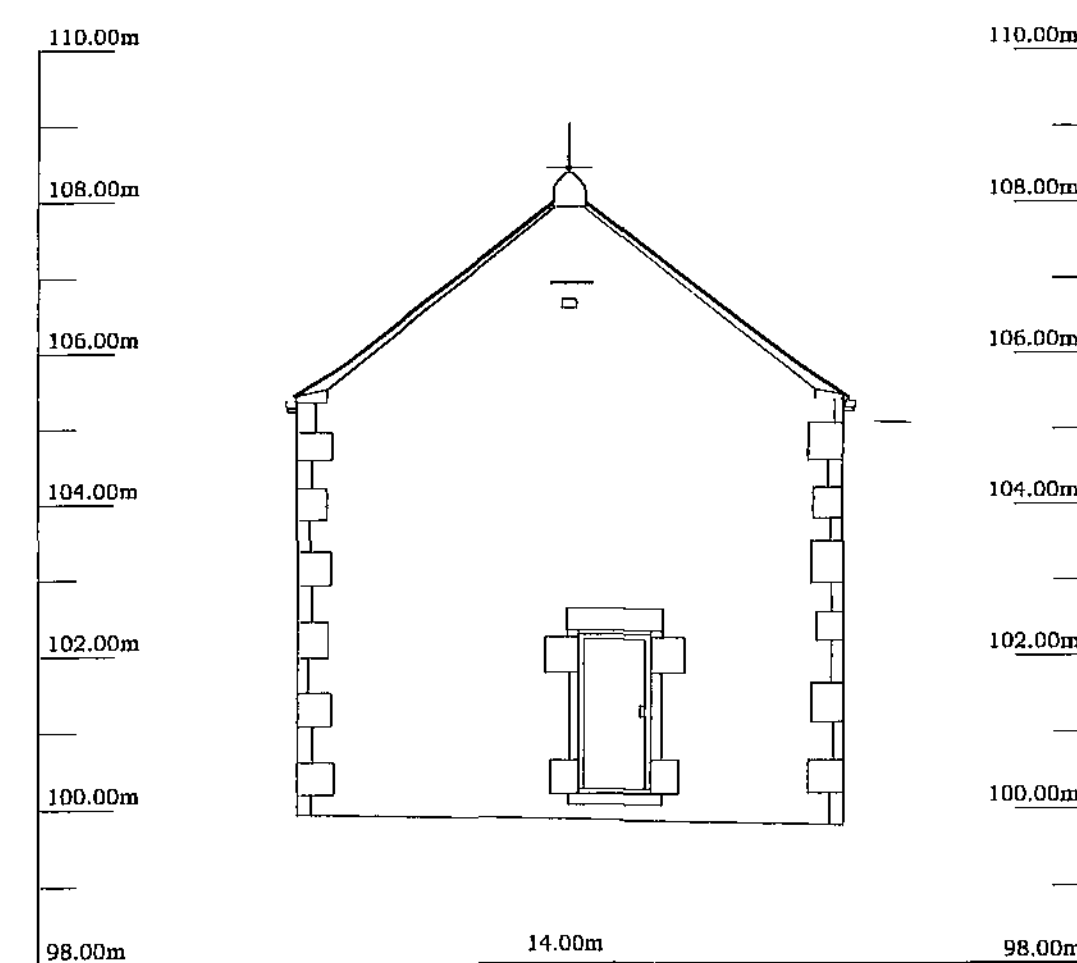

SOUTH EAST ELEVATION

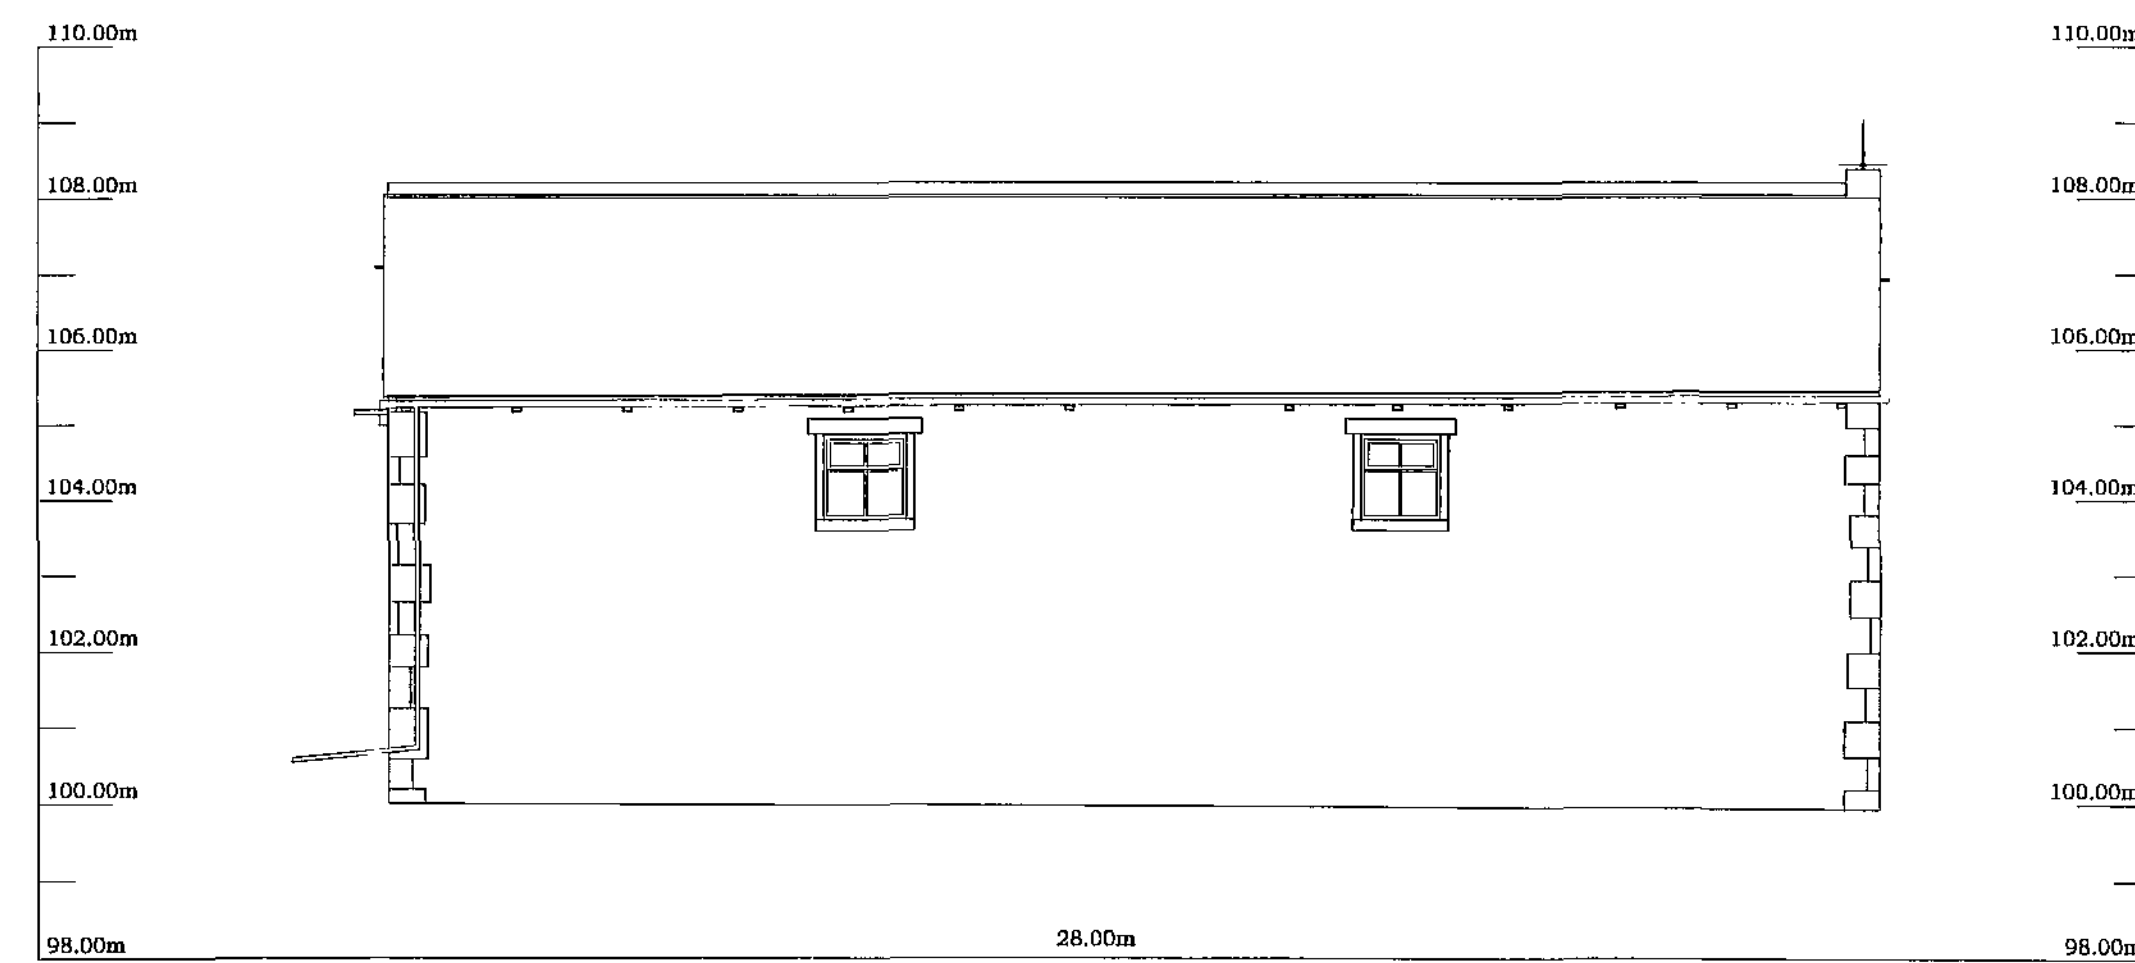

SOUTH WEST ELEVATION

END

AIR VALVE
BOLLARD
BORGHESE
BUS STOP
BRITISH TELECOM
CONCRETE COVER
CABLE MARKER
CATCH PIT
CABLE TV
DOWN PIPE
ELECT. CABLE FIT
ELEC. POLE/PISTON
SASHI RIG
FIRE HYDRANT
FOUL WATER SEWER
GULLY
GAS VALVE
HIGH VOLTAGE
INSPECTION COVER
JUNCTION BOX
KIDNEY WHEEL
LITTER BIN
LAMP HOUSE
LAMP POST
METAL COVER
MANTLE
MEDIUM VOLTAGE
POST / PILE
RODGING EYE
ROAD SIGN
SLAT
STOP COCK
STOP TAP
STOP VALVE
SURFACE WATER SEWER
TRAFFIC LIGHT
TRAFFIC LIGHTS
TILGNER'S POLE
TIRESHOED
VENT PIPE
WATER METER
WASH OUT

CILL HEIGHT
HEAD HEIGHT
CRILING HEIGHT
FALSE CEILING HEIGHT
BEAM HEIGHT
SPRING POINT
DOOR HEIGHT
STAIRS UP

MENT

Michael Clynch

EDUCATION

Sella Vista Farm
Penistone

PAGE 2 OF 2

SCALE 1 : 100 @ A1

DATE December 2010

EL DATUM	ARBITRARY
D DATUM	ARBITRARY

D DATUM	ARBITRARY
M. USED	TBM at threshold of

M. USED TBM at threshold of existing site office
Value 100.00m

Value 100.00m

1000

100

1

100

© 2006 The Authors

The diagram shows a horizontal beam of total length 1.0 m. It is supported at both ends by vertical reaction forces of 50 N each. A downward force of 100 N is applied at the center of the beam, which is 0.5 m from each support. The beam is divided into two equal segments of 0.5 m each.

DRAWING NO.

2054CT/2

[illegible]

Services to be Field Verified
Drawings remain the property of

Survive until all payments have been made.

Copyright CT Surveys Limited 2010

THE OLD MILL
HIGHFIELD, TINGLEY
WAKEFIELD
WF3 1LA

Tel : 0113 297023
Mob : 07949 155764
email : mail@ct-surveys.com
Web Site : www.ct-surveys.com



LEGEND

- AV AIR VALVE
- B BOLLARD
- BM BENCHMARK
- BS BUS STOP
- BT BRITISH TELECOM
- CC CONCRETE COVER
- CM CABLE MARKER
- CP CATCH PIT
- CATV CABLE TV
- DP DOWN PIPE
- ECP ELEC. CABLE PIT
- EP ELEC. POLE / PYLON
- ER EARTH ROD
- FR FIRE HYDRANT
- FWS Foul Water Sewer
- G GULLY
- GV GAS VALVE
- HV HIGH VOLTAGE
- IC INSPECTION COVER
- JB JUNCTION BOX
- KW KISS WIRE
- LB LITTER BIN
- LH LAMP HOUSE
- LP LAMP POST
- MC METAL COVER
- MH MANHOLE
- MY MEDIUM VOLTAGE
- P POST / POLE
- RE RISING EYE
- RS ROAD SIGN
- S STAY
- SC STOP COCK
- ST STOP TAP
- SV STOP VALVE
- SWW SURFACE WATER SEWER
- TC TRAFFIC CONTROL
- TL TRAFFIC LIGHTS
- TP TELEGRAPH POLE
- TH THRESHOLD
- VP VENT PIPE
- WM WATER METER
- WO WASH OUT

- c CELL HEIGHT
- h HEAD HEIGHT
- chl CHLORO HEIGHT
- hcm FALSE CEILING HEIGHT
- b BEAM HEIGHT
- sp SPONGE POINT
- dht DOOR HEIGHT
- st STAIRS UP

CLIENT


Michael Clynnh

LOCATION

Bella Vista Farm
Penistone

SHEET 1 OF 2

SCALE 1 : 100 @ A1
DATE December 2010
LEVEL DATUM ARBITRARY
GRID DATUM ARBITRARY
B.M. USED TBM at threshold of
existing site office
Value 100.00m

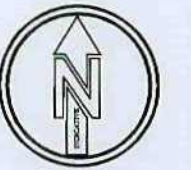

DRAWING NO.
2054CT/1

All Services to be Field Verified
All Drawings remain the property of
CT Surveys until all payments have been made.
© Copyright CT Surveys Limited 2010

