


Notes:
1. All dimensions to be checked on site before construction.

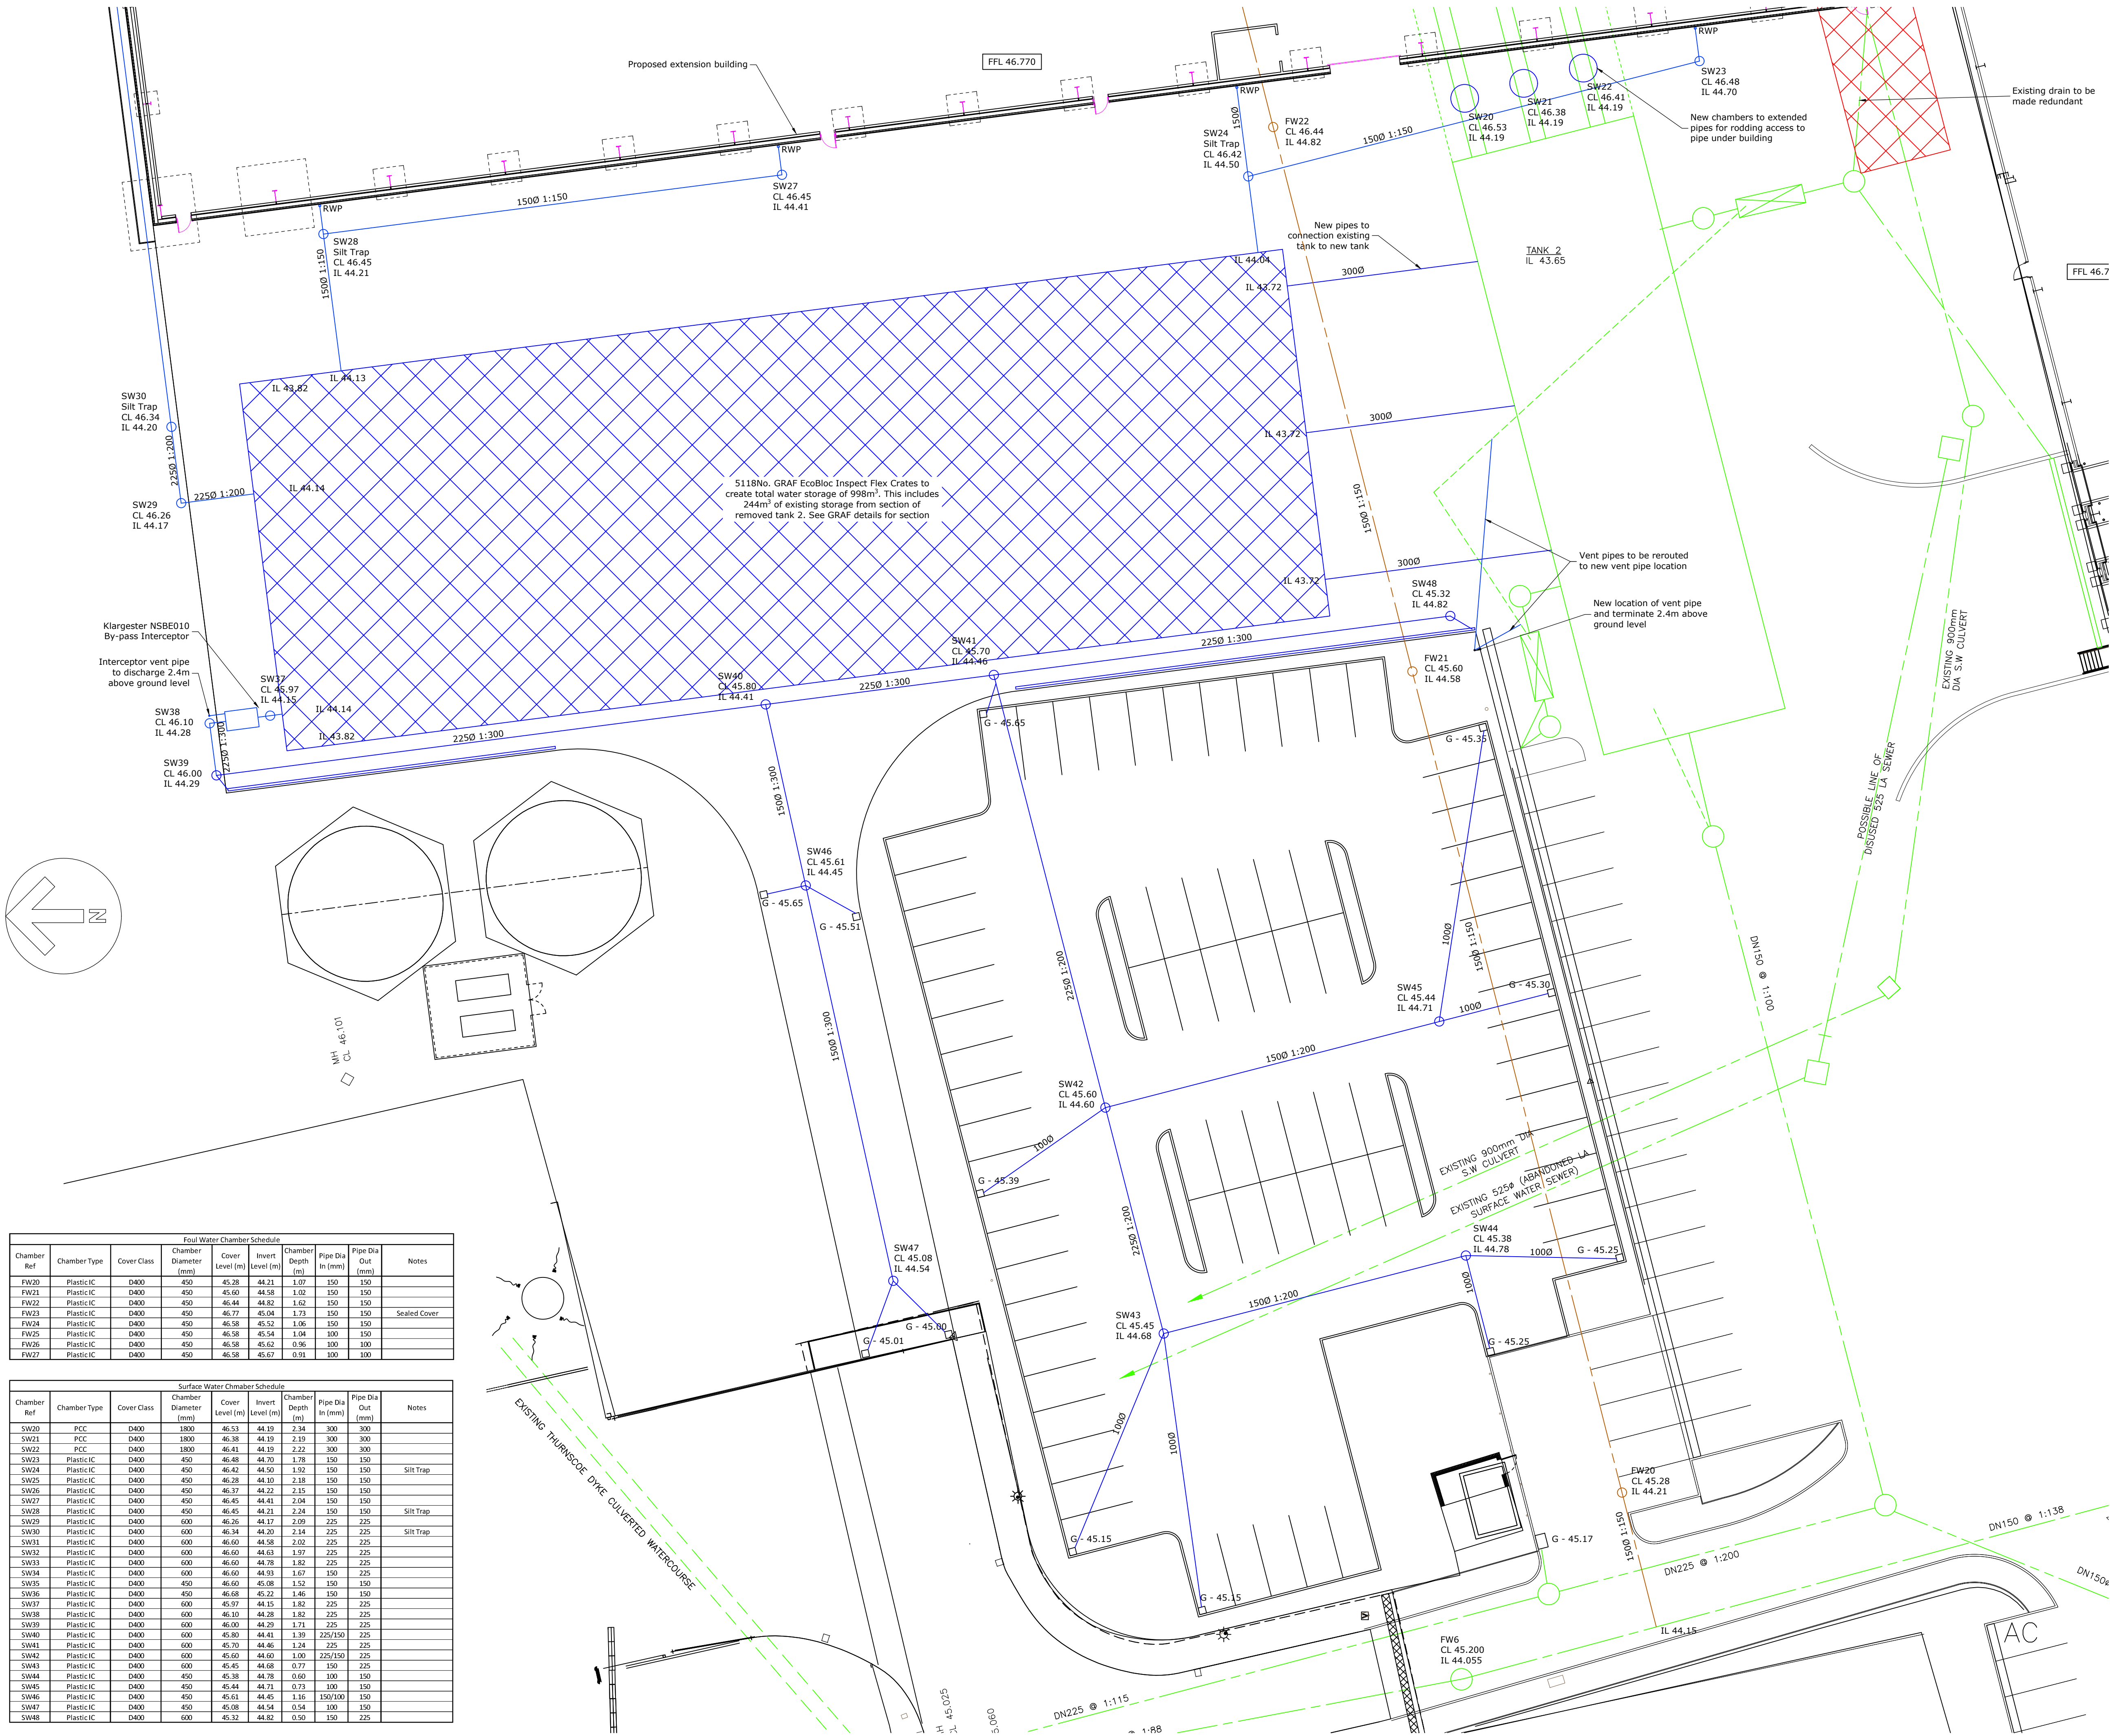

Foul Water Chamber Schedule									
Chamber Ref	Chamber Type	Cover Class	Chamber Diameter (mm)	Cover Level (m)	Invert Level (m)	Chamber Depth (m)	Pipe Dia In (mm)	Pipe Dia Out (mm)	Notes
FW20	Plastic IC	D400	450	45.28	44.21	1.07	150	150	
FW21	Plastic IC	D400	450	45.60	44.58	1.02	150	150	
FW22	Plastic IC	D400	450	46.44	44.82	1.62	150	150	Sealed Cover
FW23	Plastic IC	D400	450	46.77	45.04	1.73	150	150	
FW24	Plastic IC	D400	450	46.58	45.52	1.06	150	150	
FW25	Plastic IC	D400	450	46.58	45.54	1.04	100	150	
FW26	Plastic IC	D400	450	46.58	45.62	0.96	100	100	
FW27	Plastic IC	D400	450	46.58	45.67	0.91	100	100	

Surface Water Chamber Schedule									
Chamber Ref	Chamber Type	Cover Class	Chamber Diameter (mm)	Cover Level (m)	Invert Level (m)	Chamber Depth (m)	Pipe Dia In (mm)	Pipe Dia Out (mm)	Notes
SW20	PCC	D400	1800	46.53	44.19	2.34	300	300	
SW21	PCC	D400	1800	46.38	44.19	2.19	300	300	
SW22	PCC	D400	1800	46.41	44.19	2.22	300	300	
SW23	Plastic IC	D400	450	46.48	44.70	1.78	150	150	
SW24	Plastic IC	D400	450	46.42	44.50	1.92	150	150	Silt Trap
SW25	Plastic IC	D400	450	46.28	44.10	2.18	150	150	
SW26	Plastic IC	D400	450	46.37	44.22	2.15	150	150	
SW27	Plastic IC	D400	450	46.45	44.41	2.04	150	150	
SW28	Plastic IC	D400	450	46.45	44.21	2.24	150	150	Silt Trap
SW29	Plastic IC	D400	600	46.26	44.17	2.09	225	225	
SW30	Plastic IC	D400	600	46.34	44.20	2.14	225	225	Silt Trap
SW31	Plastic IC	D400	600	46.60	44.58	2.02	225	225	
SW32	Plastic IC	D400	600	46.60	44.63	1.97	225	225	
SW33	Plastic IC	D400	600	46.60	44.78	1.82	225	225	
SW34	Plastic IC	D400	600	46.60	44.93	1.67	150	225	
SW35	Plastic IC	D400	450	46.60	45.08	1.52	150	150	
SW36	Plastic IC	D400	450	46.68	45.22	1.46	150	150	
SW37	Plastic IC	D400	600	45.97	44.15	1.82	225	225	
SW38	Plastic IC	D400	600	46.10	44.28	1.82	225	225	
SW39	Plastic IC	D400	600	46.00	44.29	1.71	225	225	
SW40	Plastic IC	D400	600	45.80	44.41	1.39	225/150	225	
SW41	Plastic IC	D400	600	45.70	44.46	1.24	225	225	
SW42	Plastic IC	D400	600	45.60	44.60	1.00	225/150	225	
SW43	Plastic IC	D400	600	45.45	44.68	0.77	150	225	
SW44	Plastic IC	D400	450	45.38	44.78	0.60	100	150	
SW45	Plastic IC	D400	450	45.44	44.71	0.73	100	150	
SW46	Plastic IC	D400	450	45.61	44.45	1.16	150/100	150	
SW47	Plastic IC	D400	450	45.08	44.54	0.54	100	150	
SW48	Plastic IC	D400	600	45.32	44.82	0.50	150	225	

Drainage schedule added 13/06/21
A | DW
Construction issue 07/09/21
B | DW

Current Revision Information:
Extension moved as per comments 30/09/21
C | DW

Client & Project Details:
Portwest Clothing Ltd
Plot 5, Fieldsend Business Park

Gravica
Gravica Limited
Unit 385, Clifford House
7 - 9 Clifford Street
York, YO1 9RA
www.gravica.co.uk
01904 236 306
info@gravica.co.uk

Gravica Project Supervisor:
Daniel Cox
01904 236 306
info@gravica.co.uk

Status: **Construction**

Drawing Title:
**Site Drainage
Drainage Plan Sheet 1**

Drawing Number:
21cm1452.100.C