


Revisions		
Issue ID	Issue Name	Date

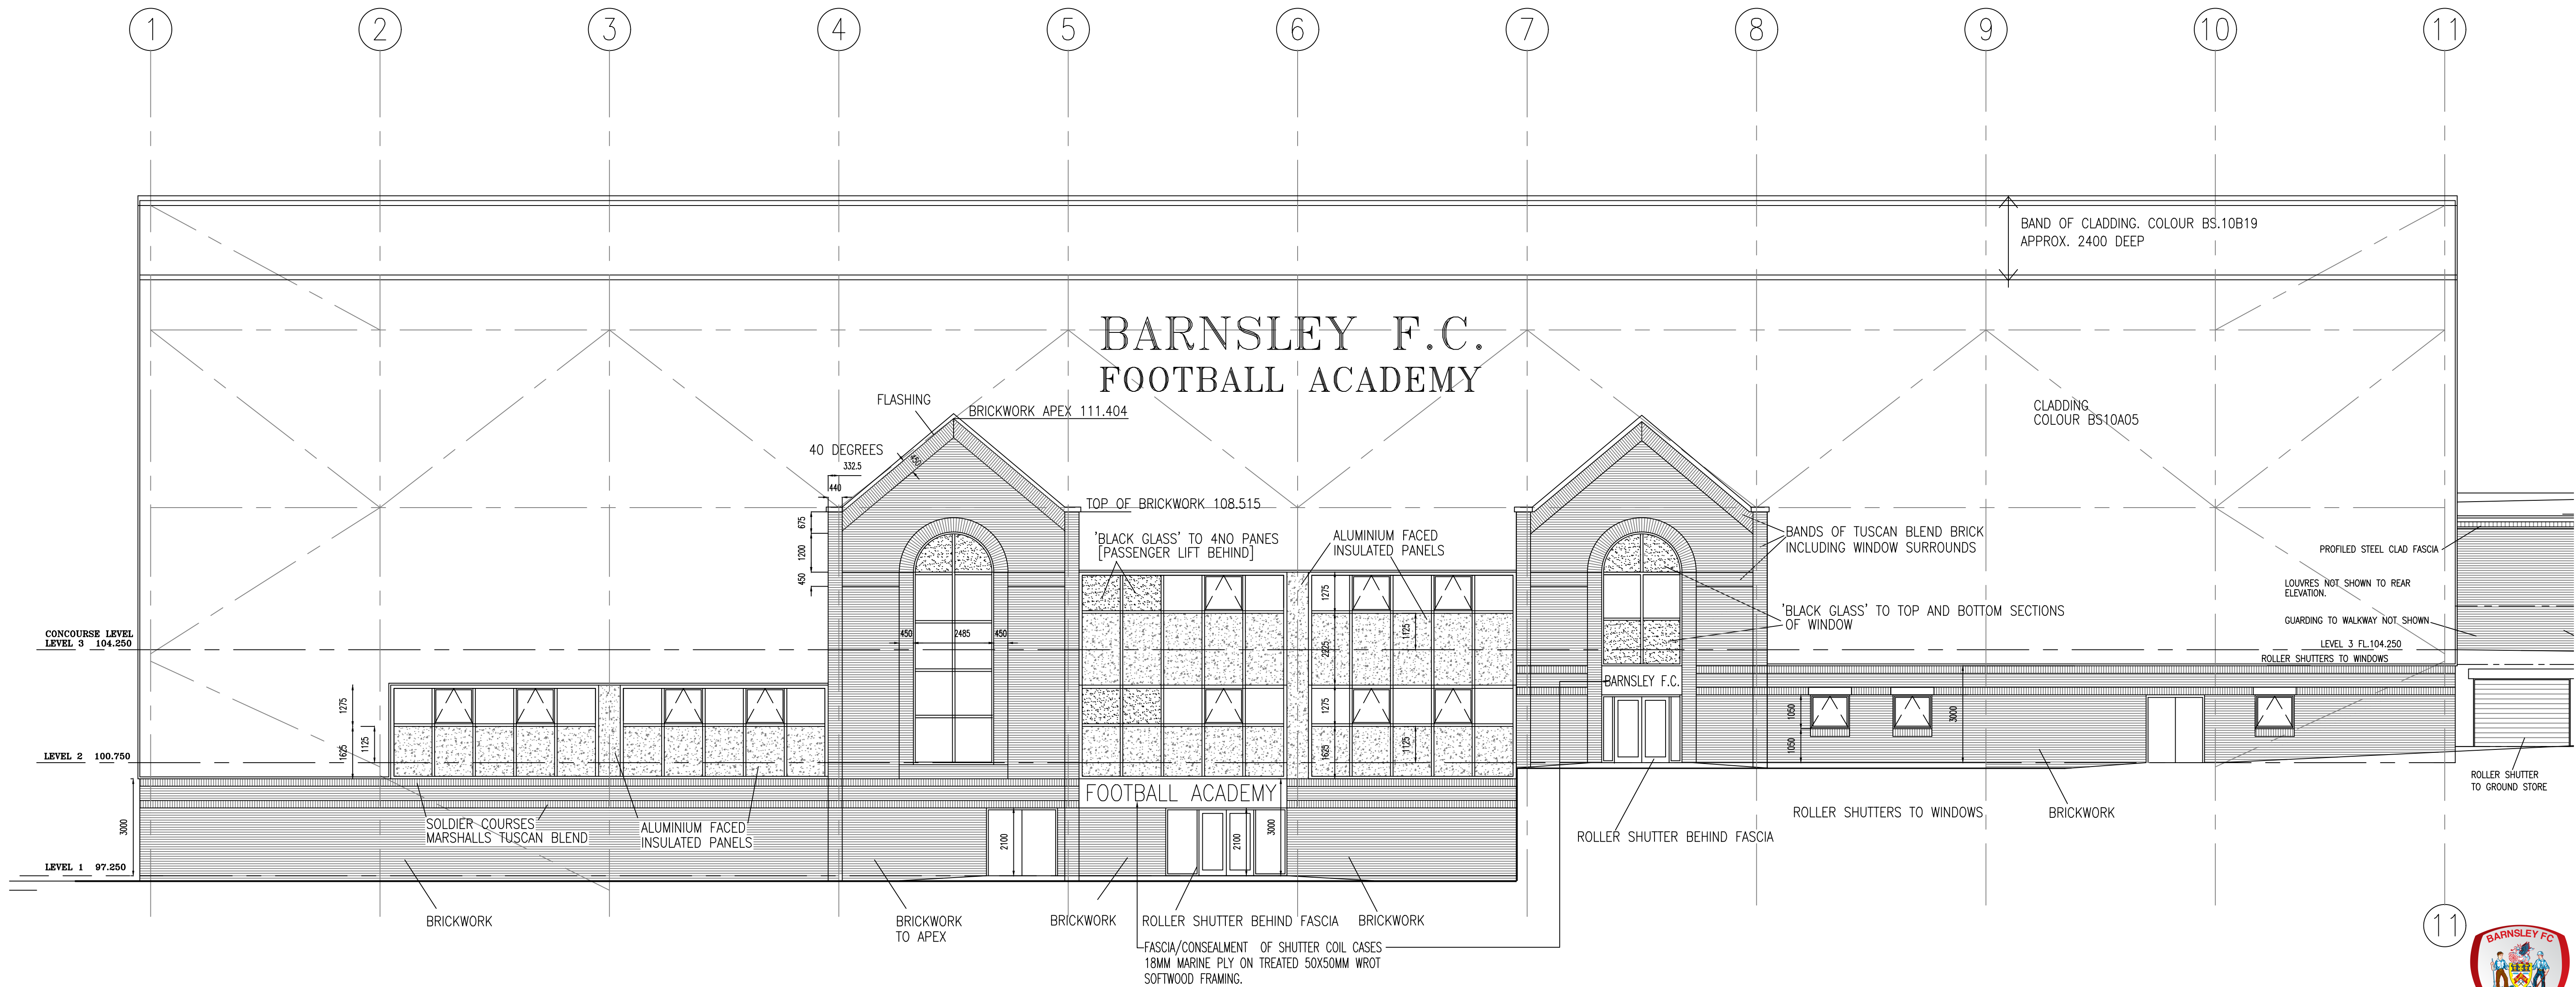

NORTH ELEVATION

Notes:

Please refer to the following documents for additional unit technical details

- [Barnsley FC TSP_ct70-1_50Hz_400V_500NOx_1902007.pdf](#)
- [2G Product Range UK 0119.pdf](#)



aad
architects

Units 11/12 South Street
Park Hill
Sheffield
S2 5OX
T: +44 (0)114 275 9896
E: home@aadarchitects.co.uk

Planning

Client Details
Barnsley Football Club

Oakwell Stadium, Grove Street,,
Barnsley, S71 1ET

CHP (Combined Heat and Power)
Equipment installation

Existing North Elevation

scale(s) 1:100 @A1		
Date 10/11/2020	drawn TJ	checked NN

Job Number: 020-035

Document Number:
020-035-AAD-01-GF-DR-A-0004- PL01

This document and its design content is copyright ©. It shall be read in conjunction with all other associated project information including models, specifications, schedules and related consultants documents. Do not scale from documents. All dimensions to be checked on site. Immediately report any discrepancies, errors or omissions on this document to the Originator. If in doubt ASK. Where this document has been printed at a paper size not indicated on the drawing the user should be aware that scales will also vary and care should be taken when viewing these drawings.