


Do not scale from this drawing
The contractor is to check all dimensions on site
and report any discrepancies to the architect
All rights reserved by chapter IV of the
copyright, designs and patents act 1988
have been generally asserted

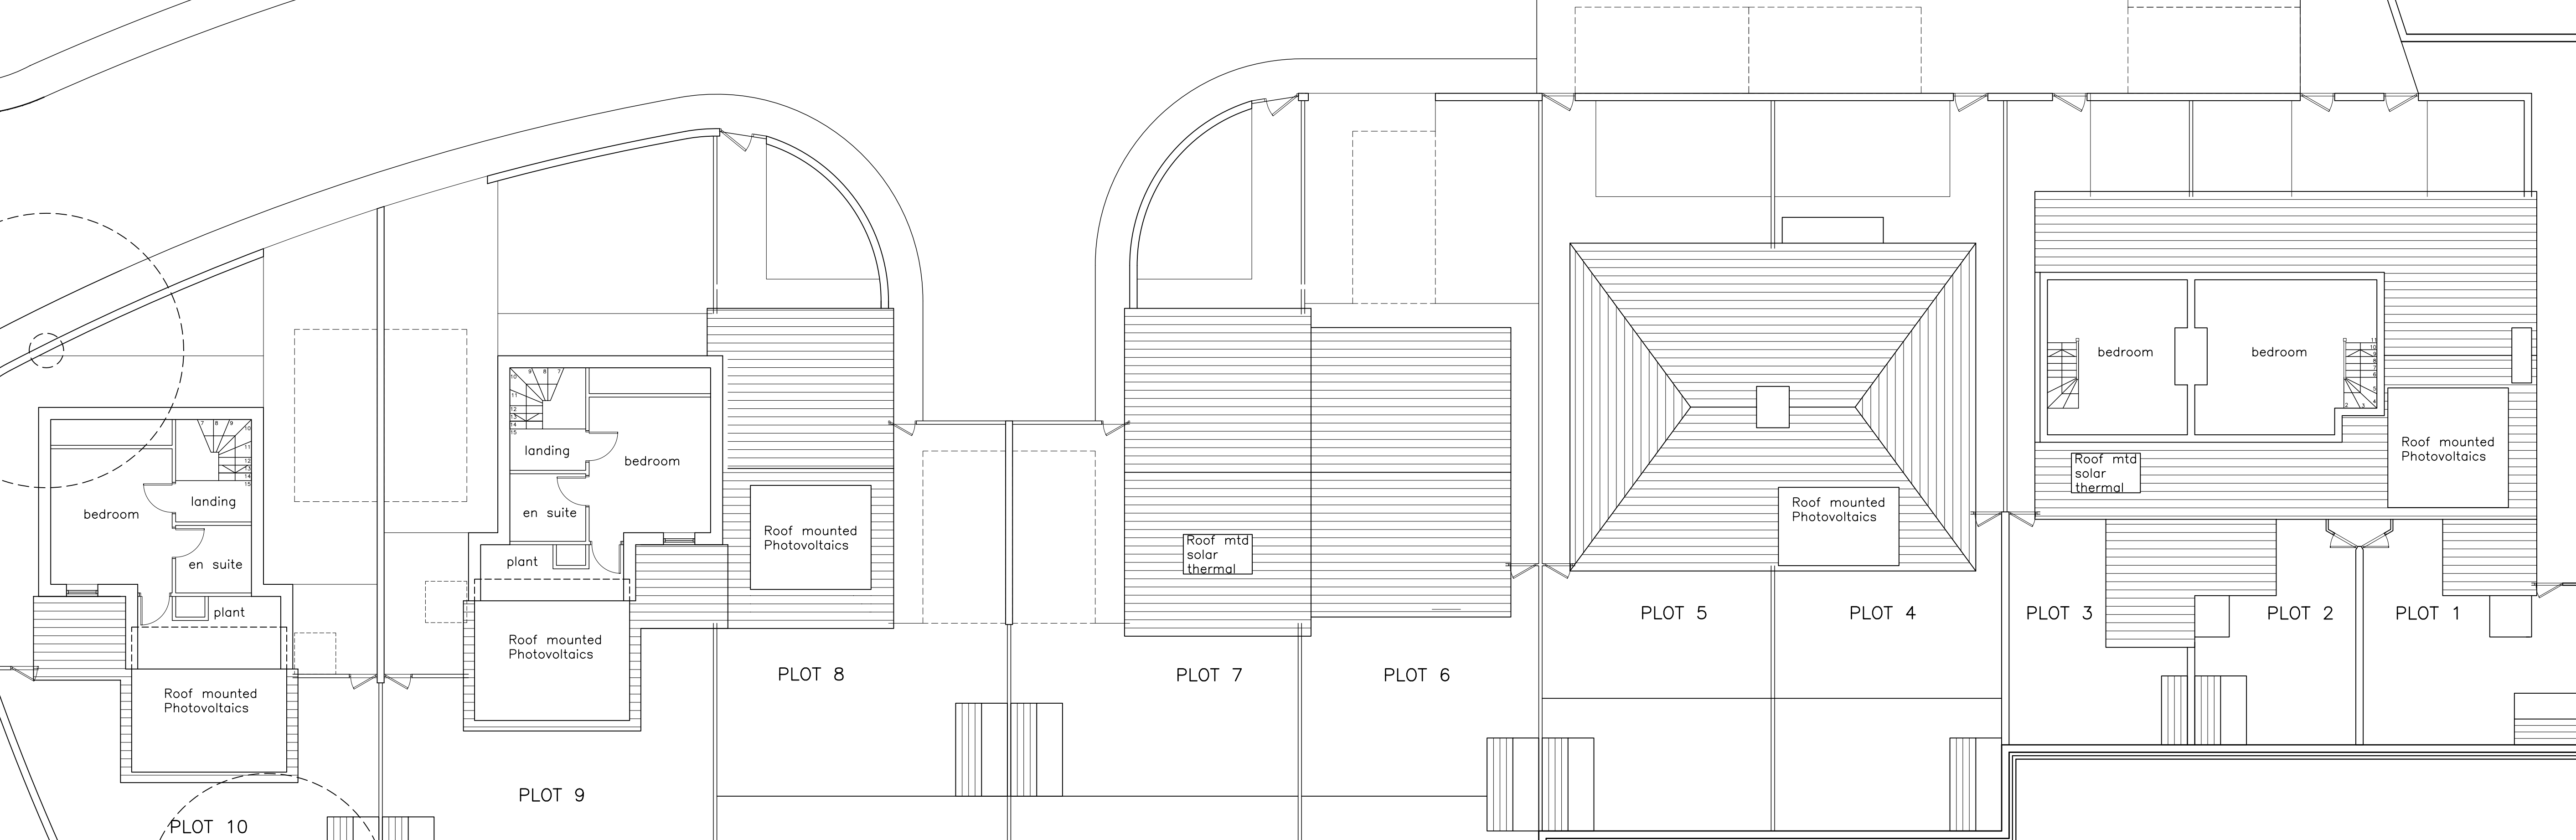

B 12/10/11 Drawn: SS Check: CA

Photovoltaics/solar thermal added to roofs.
Window added to plot 9 & 10 bedrooms.
PLANNING ISSUE.

A 02/06/2010 Drawn: CA Check: PP

External works ammended. **STAGE C DESIGN**

- 10-11-2010 Drawn: MTH Check: PP

Initial Issue

Fulcrum
2 Sidney Street
Sheffield S1 4RH
Telephone +44(0)1142761651
Facsimile +44(0)1142799191
Website www.jeffersonsheard.com

Jefferson Sheard Architects

Drawn: CA Check: PP

Project
Barnsley College
Honeywell Housing
Demonstration Units

Drawing
Proposed General Arrangement
Second Floor Plan

Scale	Date	
1:100@A1	13/10/2010	
Ref.	Number	Rev.
0022	A_2102	B