


Contractor must verify all dimensions on site before commencing any work or shop drawings. If this drawing exceeds the quantities taken in any way, the building designers are to be informed before the work is initiated. Only figured dimensions to be taken from this drawing. Do not scale off this drawing. Drawing based on Ordnance Survey and/or existing record drawings - design and drawing content subject to Site Survey, Structural Survey, Site Investigations, Planning and Statutory Requirements and Approvals. All drainage layouts are schematic and invert levels must be established prior to construction.

Tree Key:	
	Root protection area
	Trees

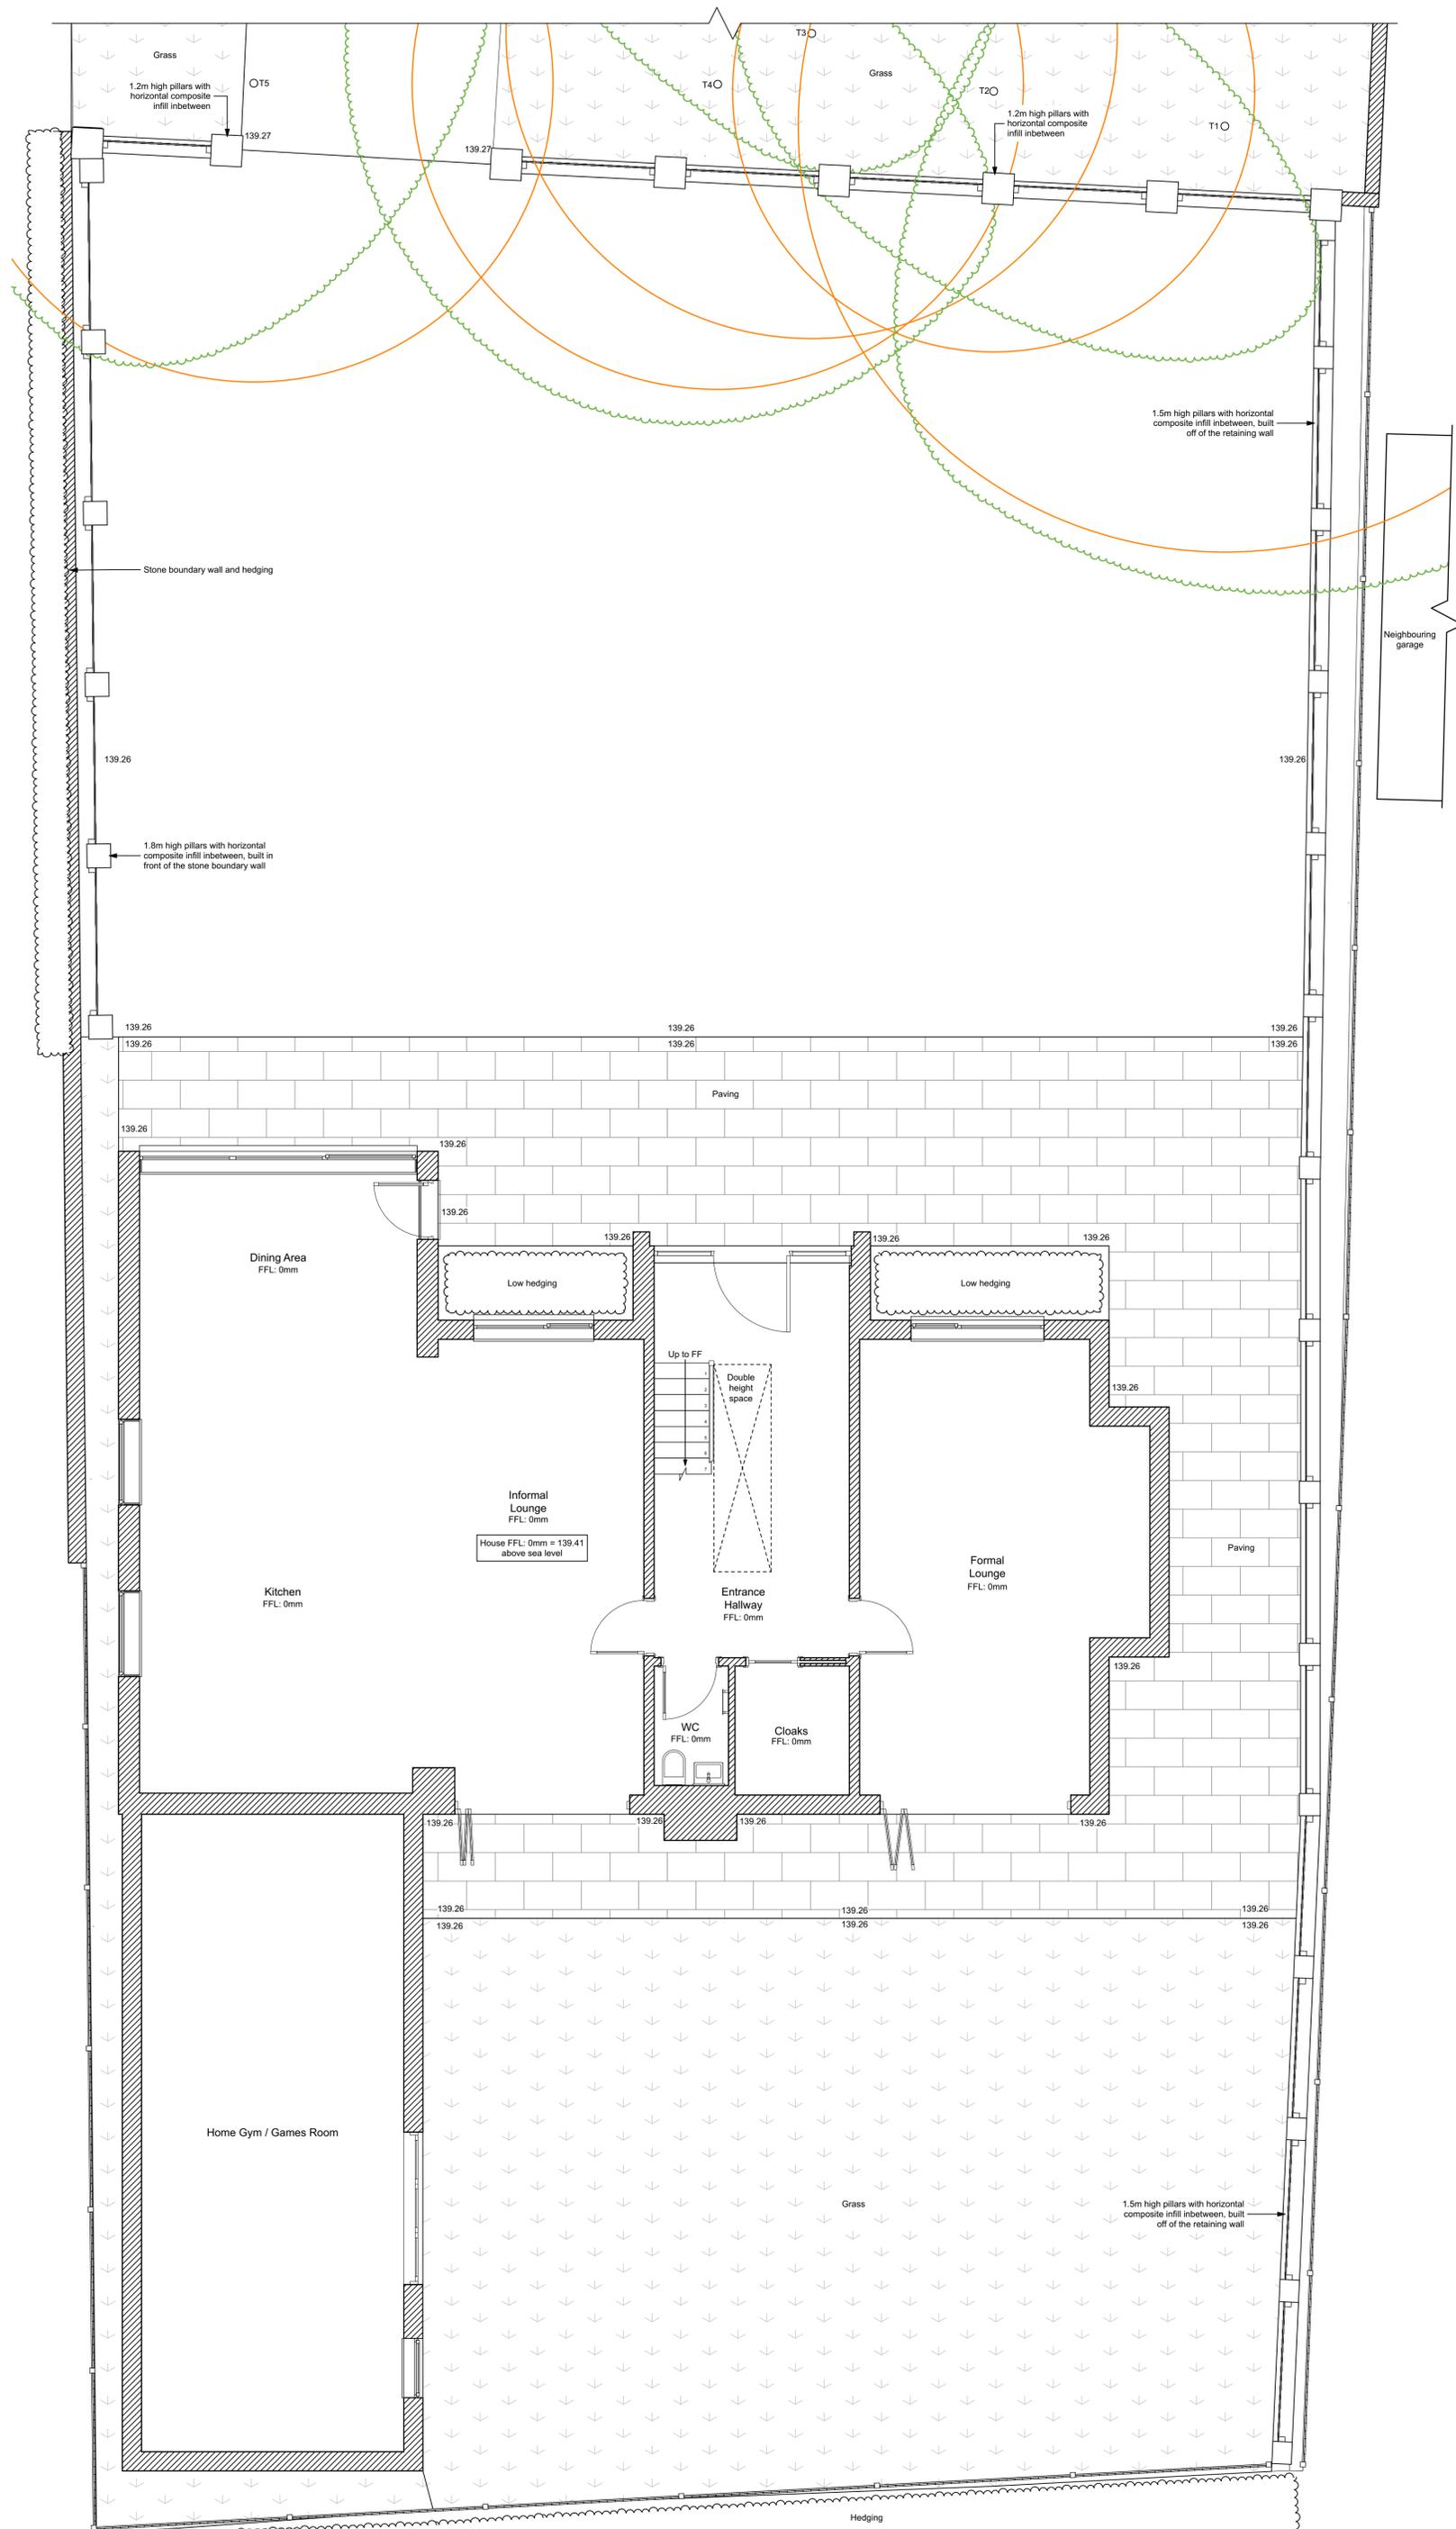

Ground Floor Plan (As Previously Approved and Currently Under Construction) 1:50

Project Status: PLANNING ONLY



4 Rushmead Court, Ossett, WF5 0NZ  
 tel: 01924 275 594  
 web: www.transformarchitects.co.uk email: info@transformarchitects.co.uk

Project Address: 43 Intake Lane, Barnsley, S75 2HX

Client: Mr and Mrs Rose

Drawing Title: Ground Floor Plan A1 (Currently Under Construction)

Scale: 1:50

Date: 04.06.2024

Drawn By: JN

Drawing Number: T1260 - PL02

Revision: Nil