

REVISIONS				
PRELIMINARY	☒	TENDER	☒	CONSTRUCTION
C/D FILE NAME: P:\projects\359\Bentley\359.ccd				
Rev.	Date	Description	Drawn	Checked/Approved
P1	12/04/17	P1=First Issue	SJD	MJG
P2	24/04/17	Step 1 to step 2 now enlarged and the step positions amended to adding.	SJD	MJG
P3	24/04/17	Step 2 and addition of final line within the step arrowhead.	SJD	MJG
P4	06/05/17	Dimensions added to support for helixes.	SJD	MJG
Issued/Approved: (non project)				

Technical specification

LED strip

Latest high lighting chip technology giving 70 lumens per watt output.

Over 1000 Lumens per metre LED output. Only 14cts/watt per metre power consumption

15% energy saving compared to fluorescent, 2x volt input, less current less voltage drop, 6000k cool white or 3000k warm white 120

degrees celsius, 50,000 hours* lamp life, IP65 protected.

2 year Warranty, Full CE certification and RoHS compliant.

Drivers Epoxy encapsulated fully isolated cases with 100% protection.

Constant voltage design. Short circuit, over current, over voltage protection. Fitted with MCPCB release slide in clear trays.

Full CE certification and RoHS compliant.

Light fitting Specially designed 50mm diameter

aluminium extrusion supplied up to 6000mm lengths which can be joined together using cast aluminium connectors.

Die cast aluminium end caps. Standard 3000mm kwik fit brackets.

Snaps in polycarbonate 90 degree magnifying lens diffuser.

Casing sealed and certificated to IP64. Full CE certificate and 2 year parts warranty.

Conforms to BS4533: SECTION 102.1:1990 / EN60598-2-1:1989 and BS EN60598-2-6:1995

with BS EN 60598-1:2008 "UK Deviations Only"


The manufacturer's right to alter specifications without prior notification

Price will include: Polyester powder coated black or white and 300mm universal brackets.

Telephone: 01922 721 133
Facsimile: 01922 659 545



Proposed light fitting data sheet

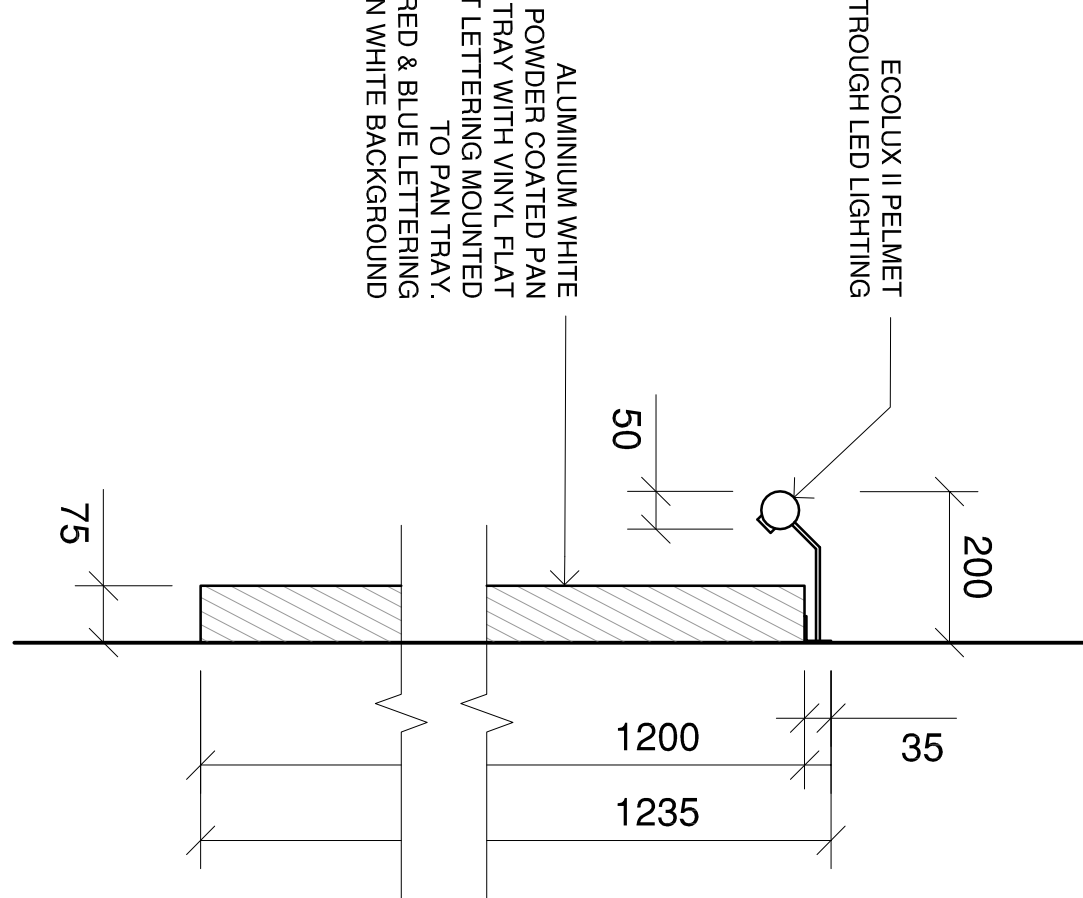

Signage Lighting Detail 1:10

PRELIMINARY

© WARD MCHUGH ASSOCIATES LIMITED 2016

Copyright in this document belongs to Ward McHugh Associates Limited and all rights in it are reserved by the owner. No part of this drawing may be copied, transferred or made available to users other than the original recipient including electronically without prior permission from Ward McHugh Associates Limited.

CUEB

BOYES
for good value!
Since 1881

Since 1881

PROJECT TITLE
Retail Fit Out
Hoyland

Hoyland

DRAWING TITLE
Proposed Store External Signage
and External Lighting

3 TITLE



ARCHITECTS
PLANNERS
INTERIOR DESIGNERS

NORFOLK HOUSE
STAFFORD LANE
SHEFFIELD S2 3HR
TEL 0114 268 3322
www.wma-architects.co.uk

SCALE


1

PROJECT NO.	DRAWING NO.	REV
7359	602	P4


7359

02


P4

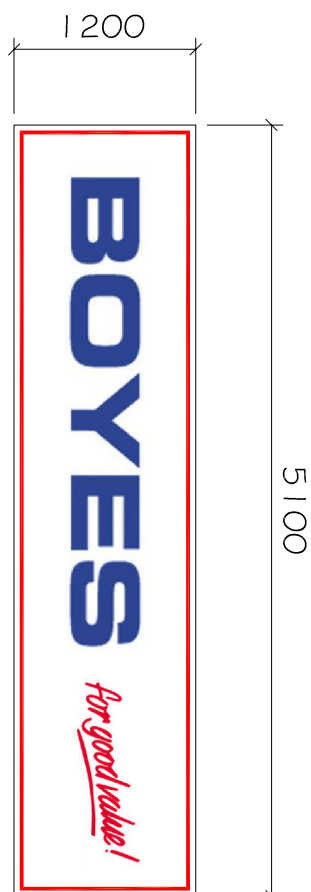


Sign N°1 Front Elevation 1:50

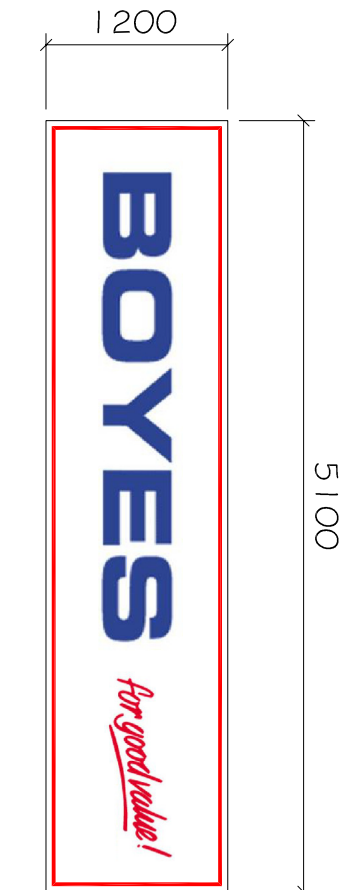


Sign N°2 Side Elevation 1:50

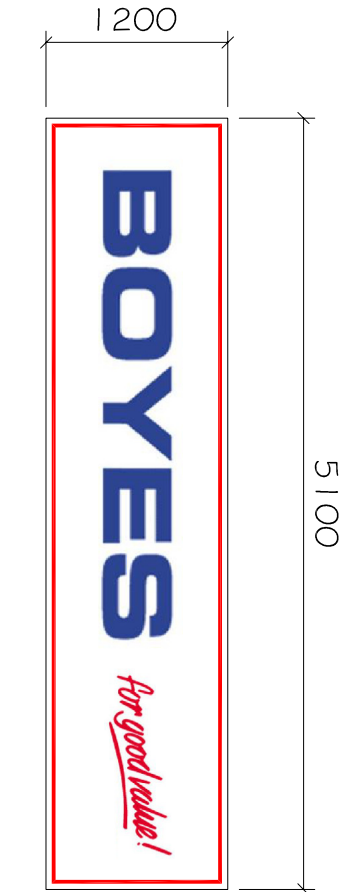

Sign N°3 Side Elevation 1:50

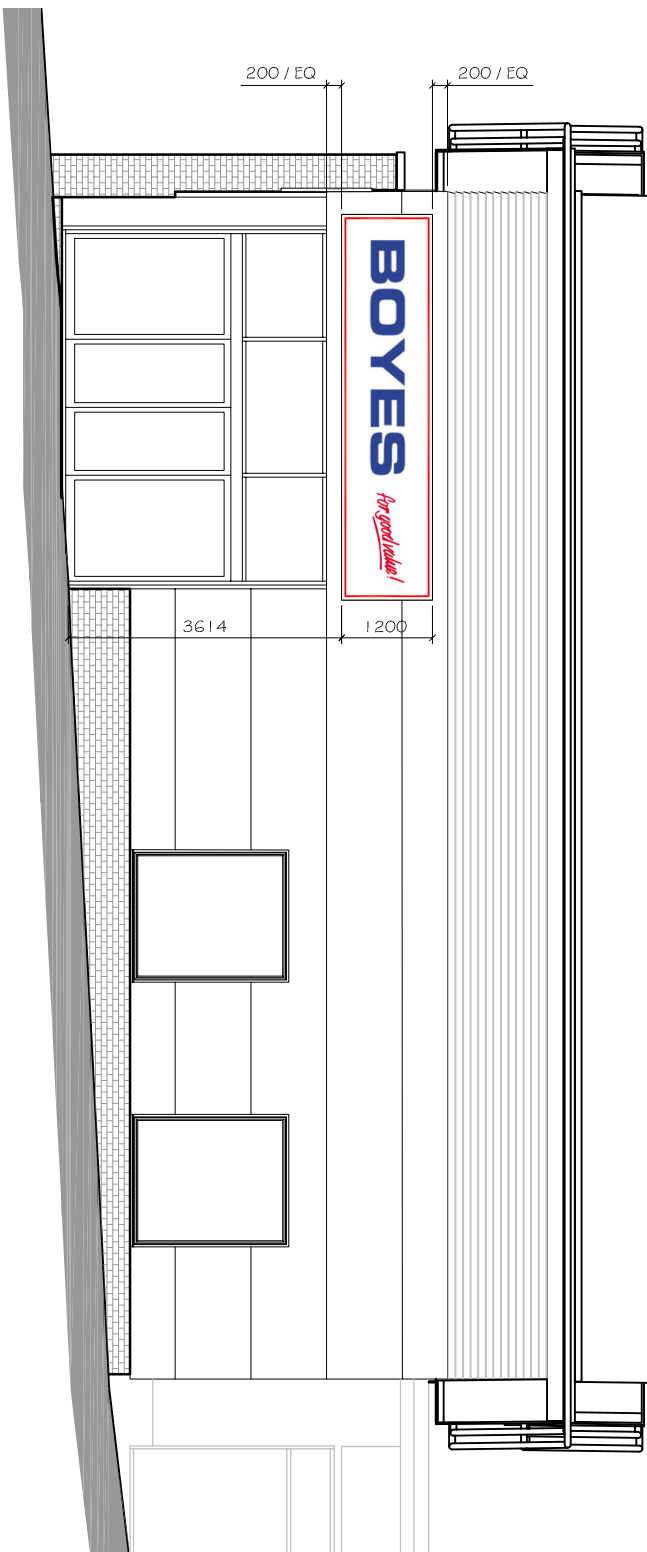

Sign N°1 Front Elevation 1:100
East Elevation

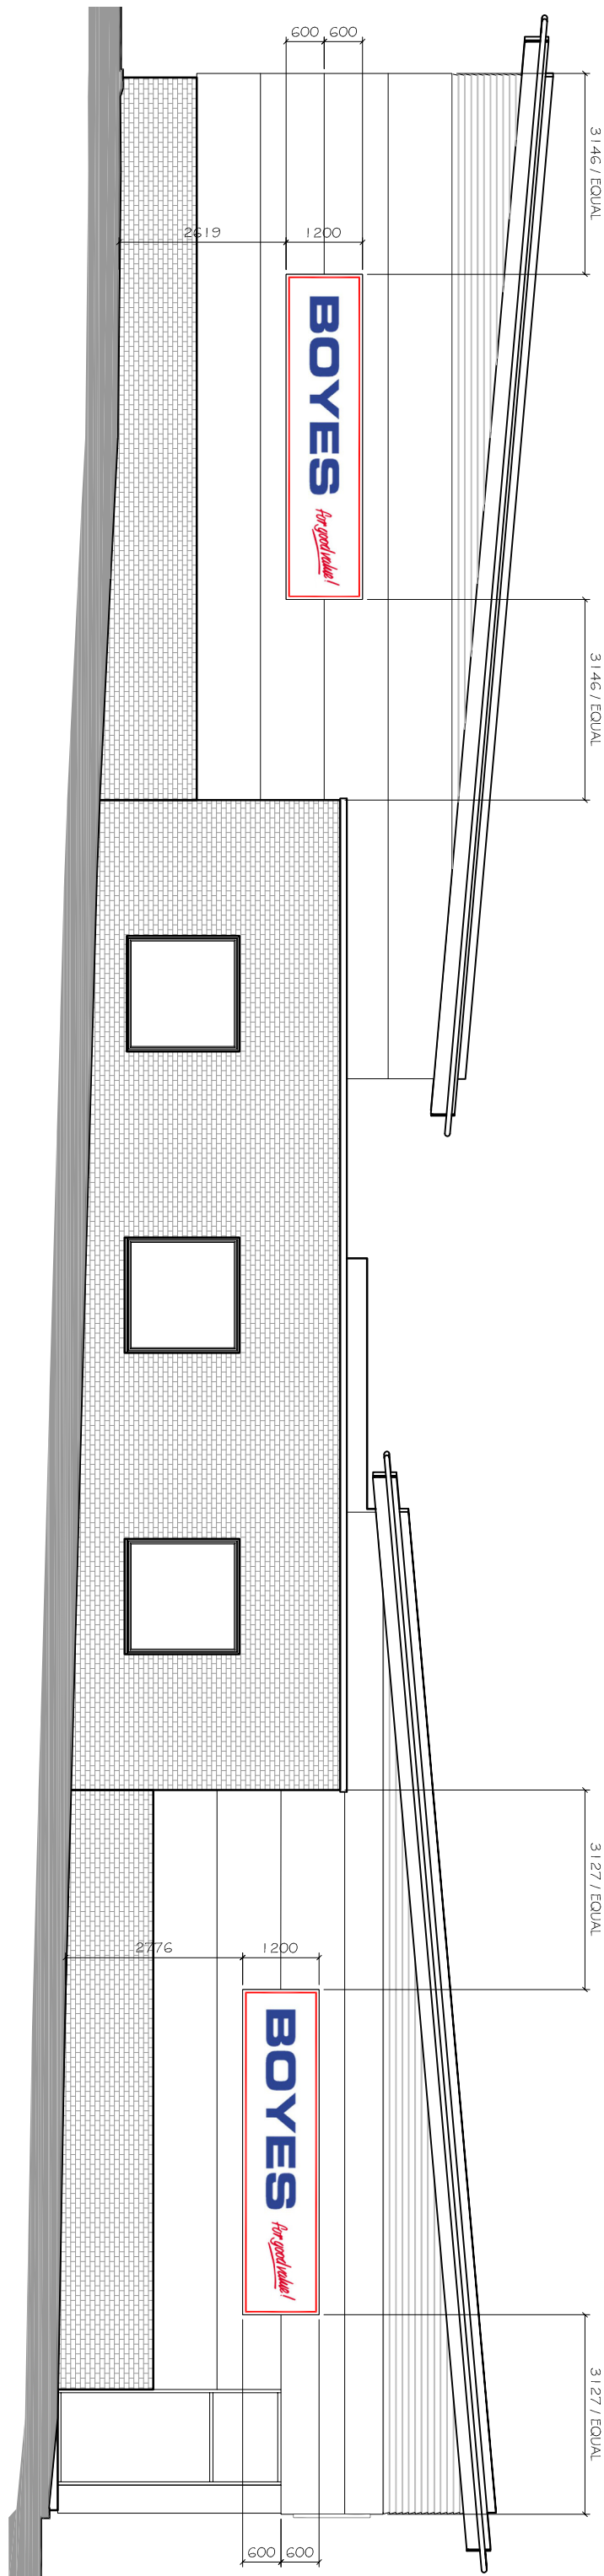

Sign N°2 and Sign N°3 Side Elevation 1:100 South Elevation