




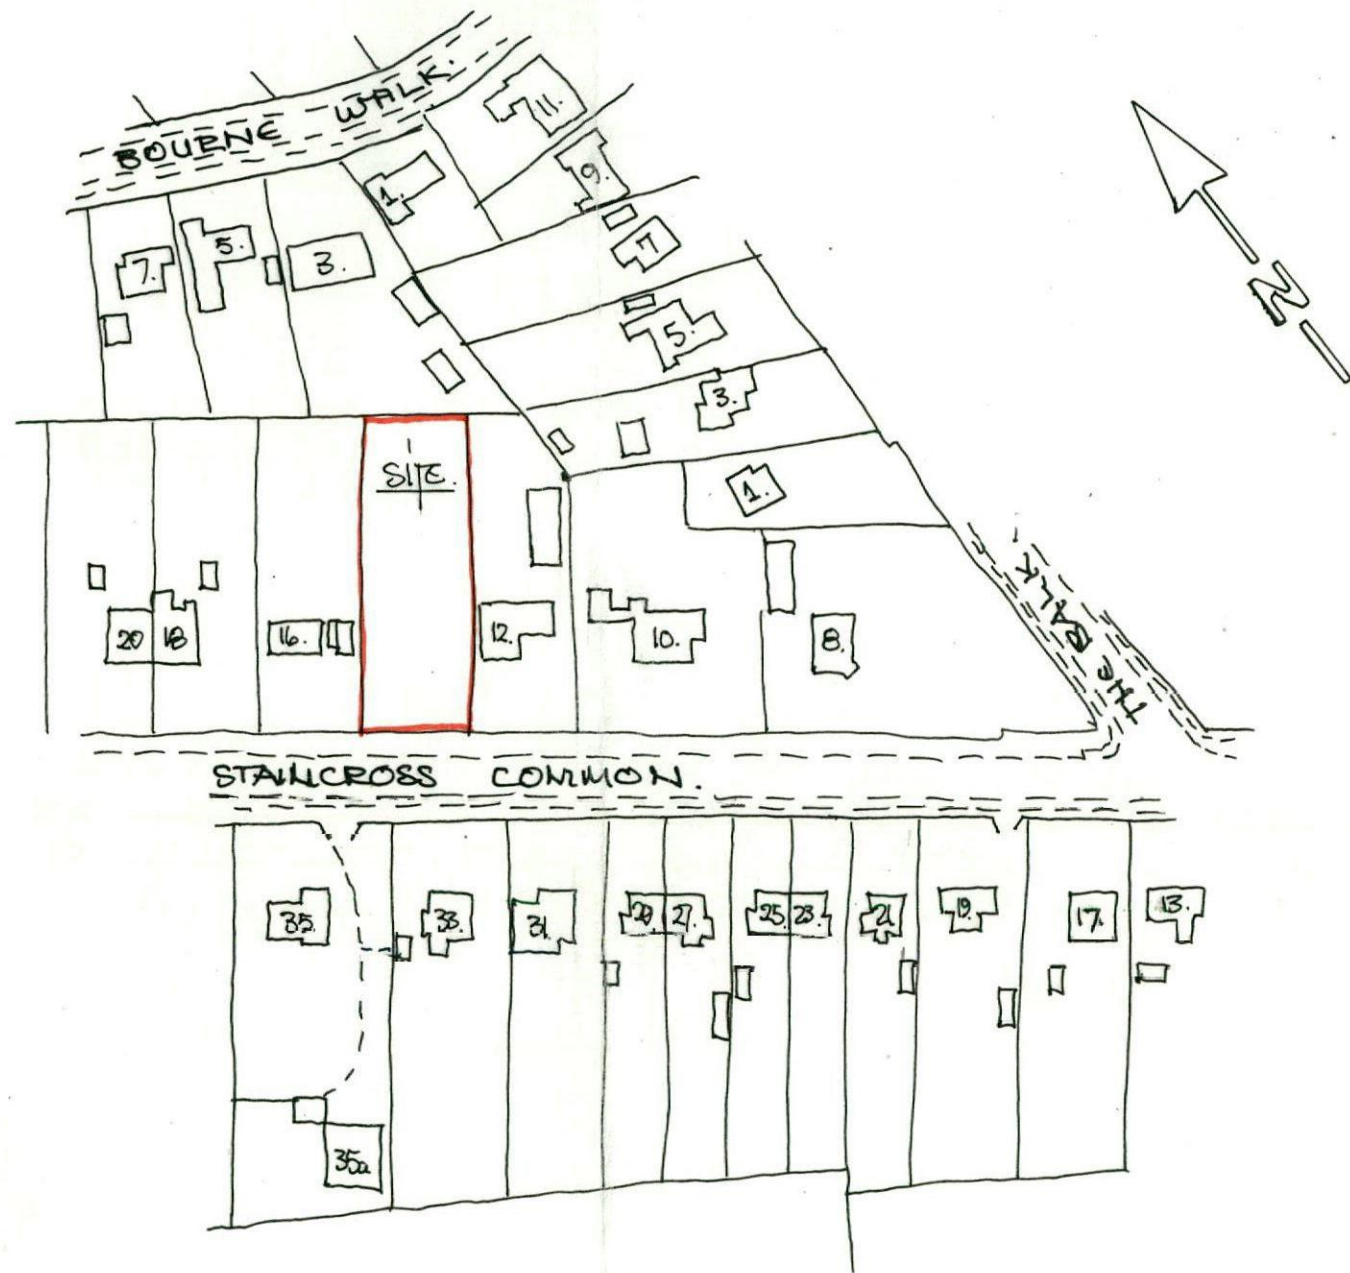


LOCATION PLAN @ 1:1250!

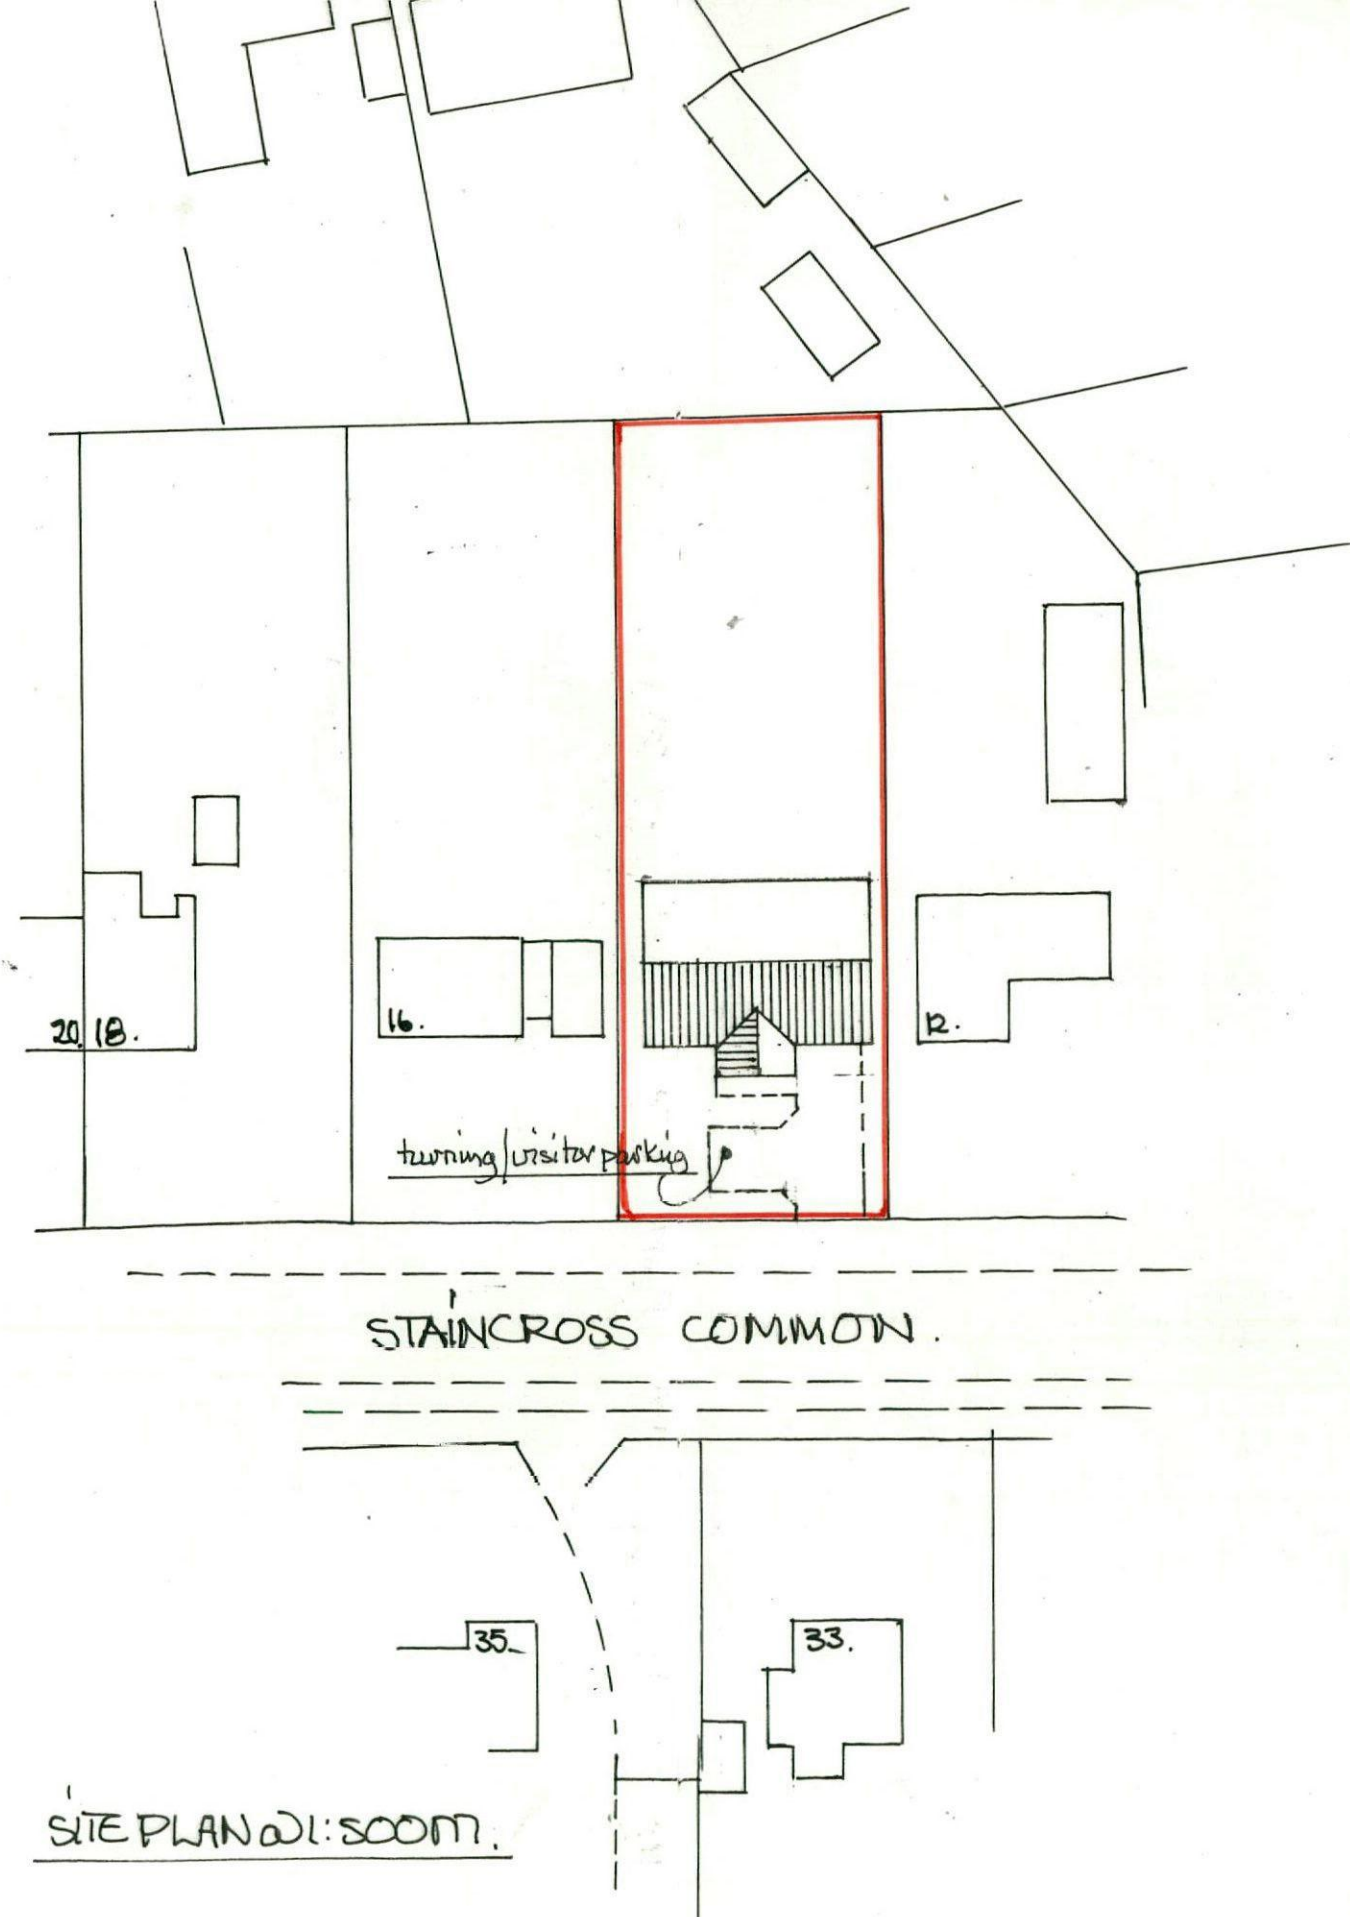

SITE PLAN @ 1:500M.

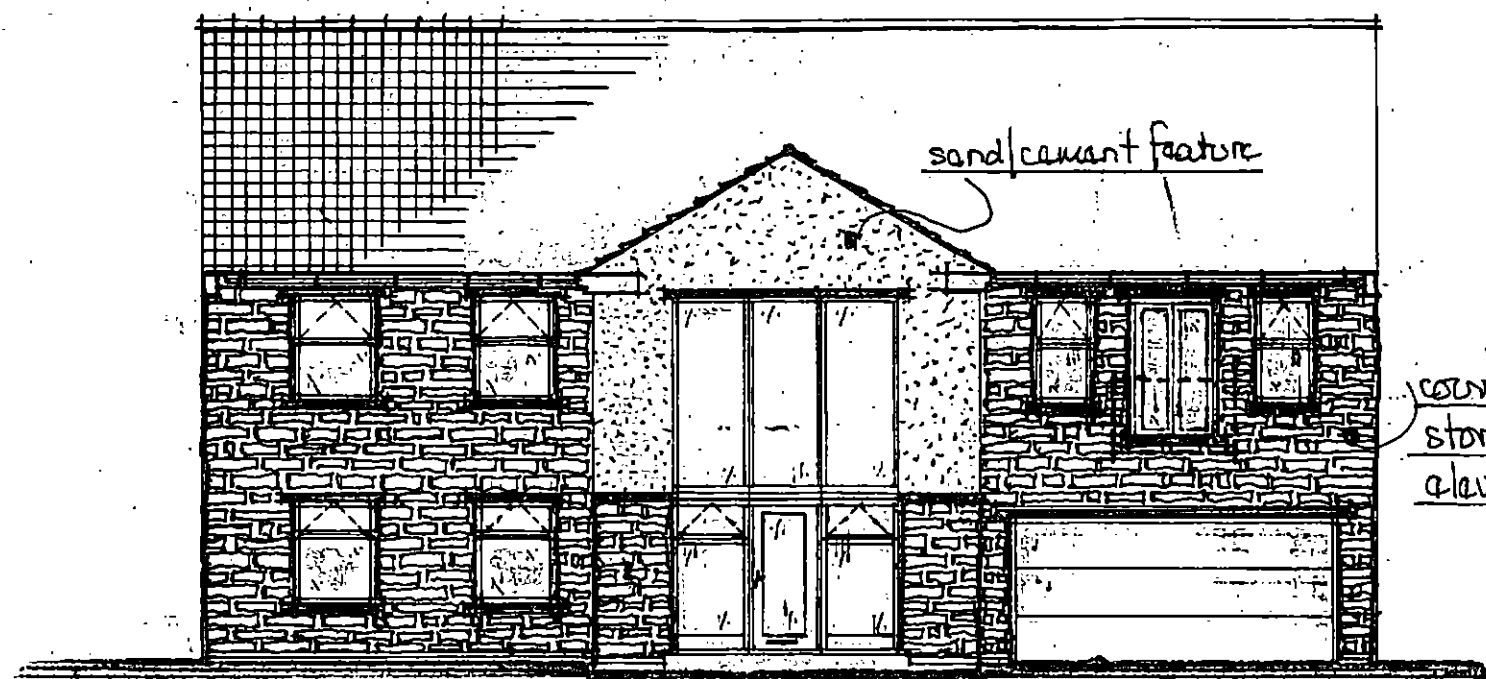

PROPOSED FRONT VIEW FROM STAINLESS COMMON.


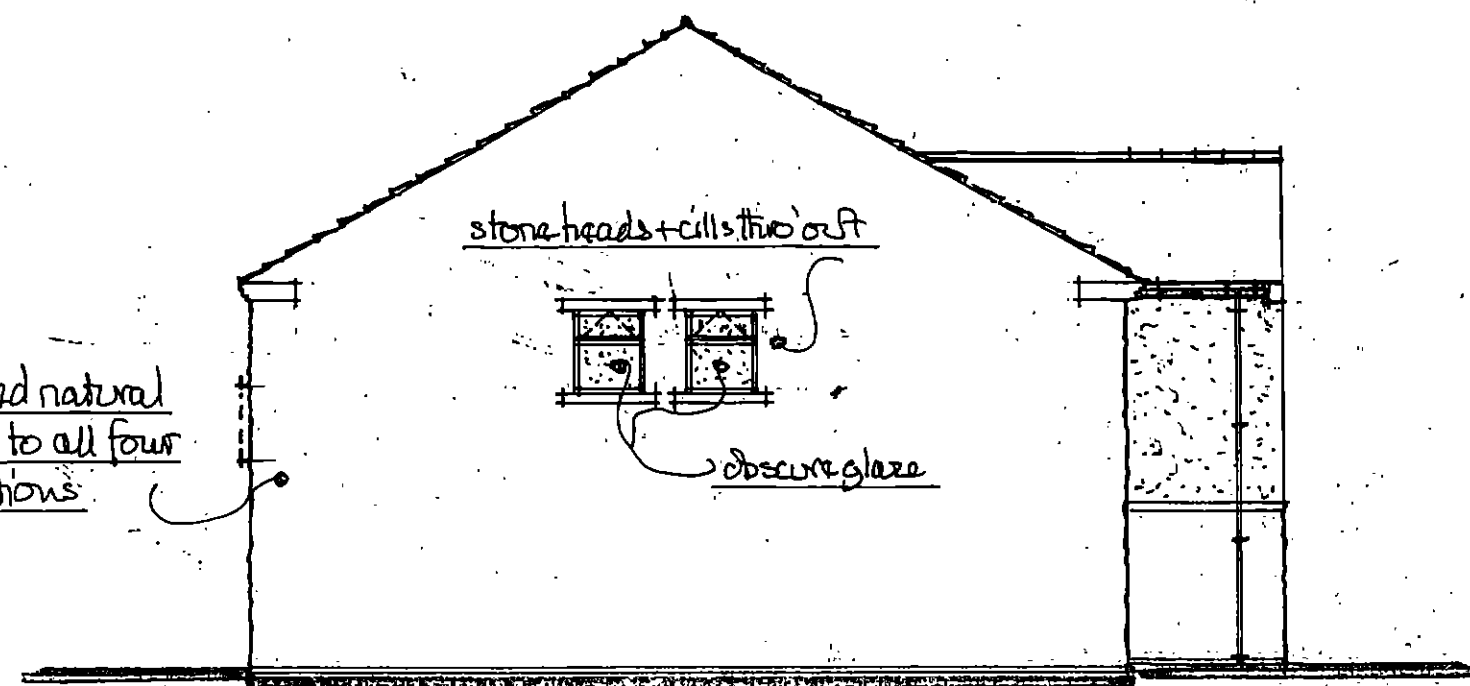



PROPOSED SIDE VIEW FROM NO 16.

PROPOSED REAR VIEW FROM GARDEN.

SCALE 1:100M

PROPOSED SIDE VIEW FROM NO 12.

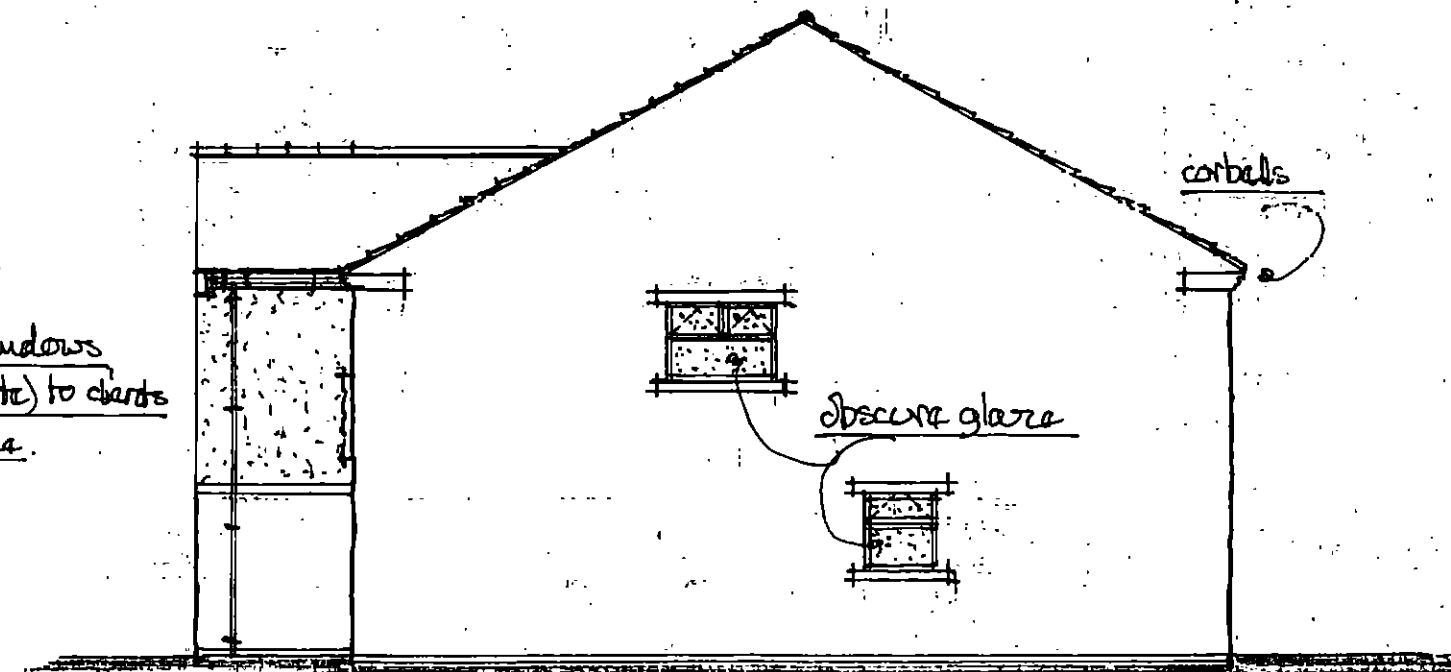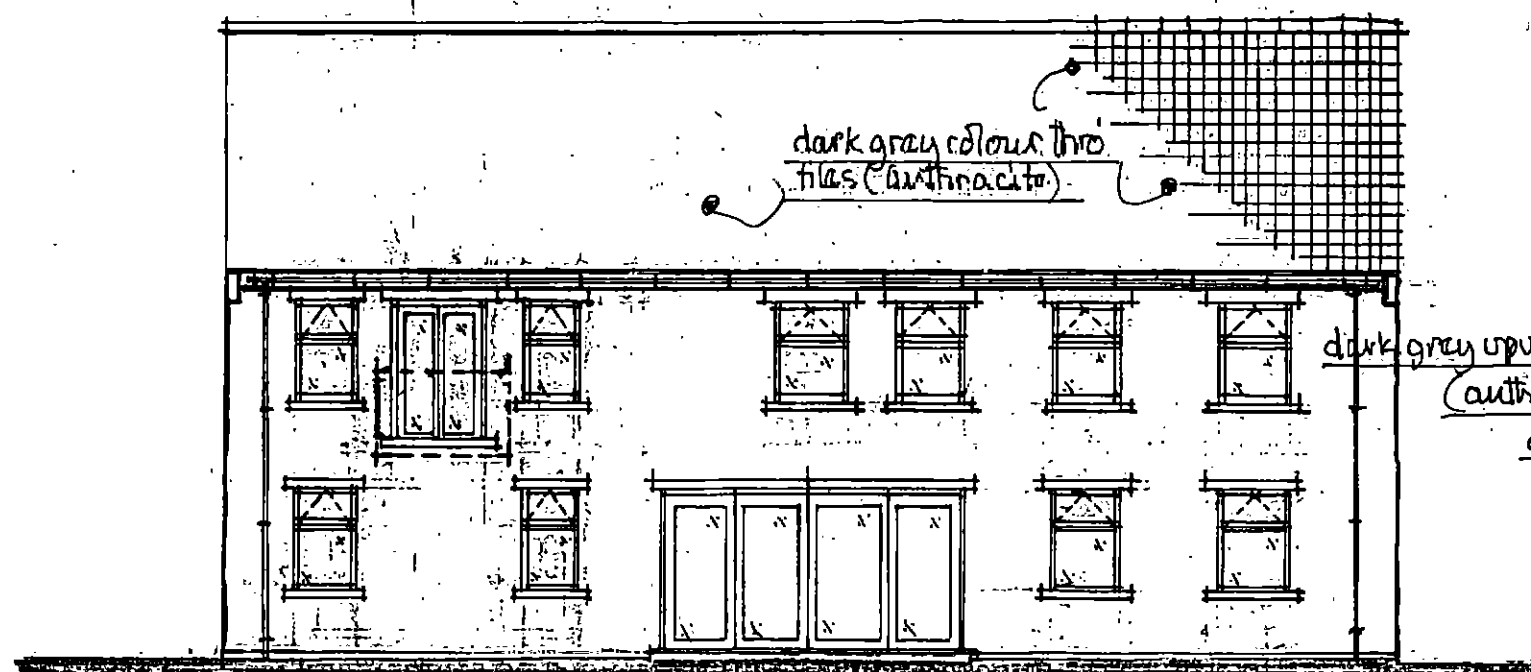

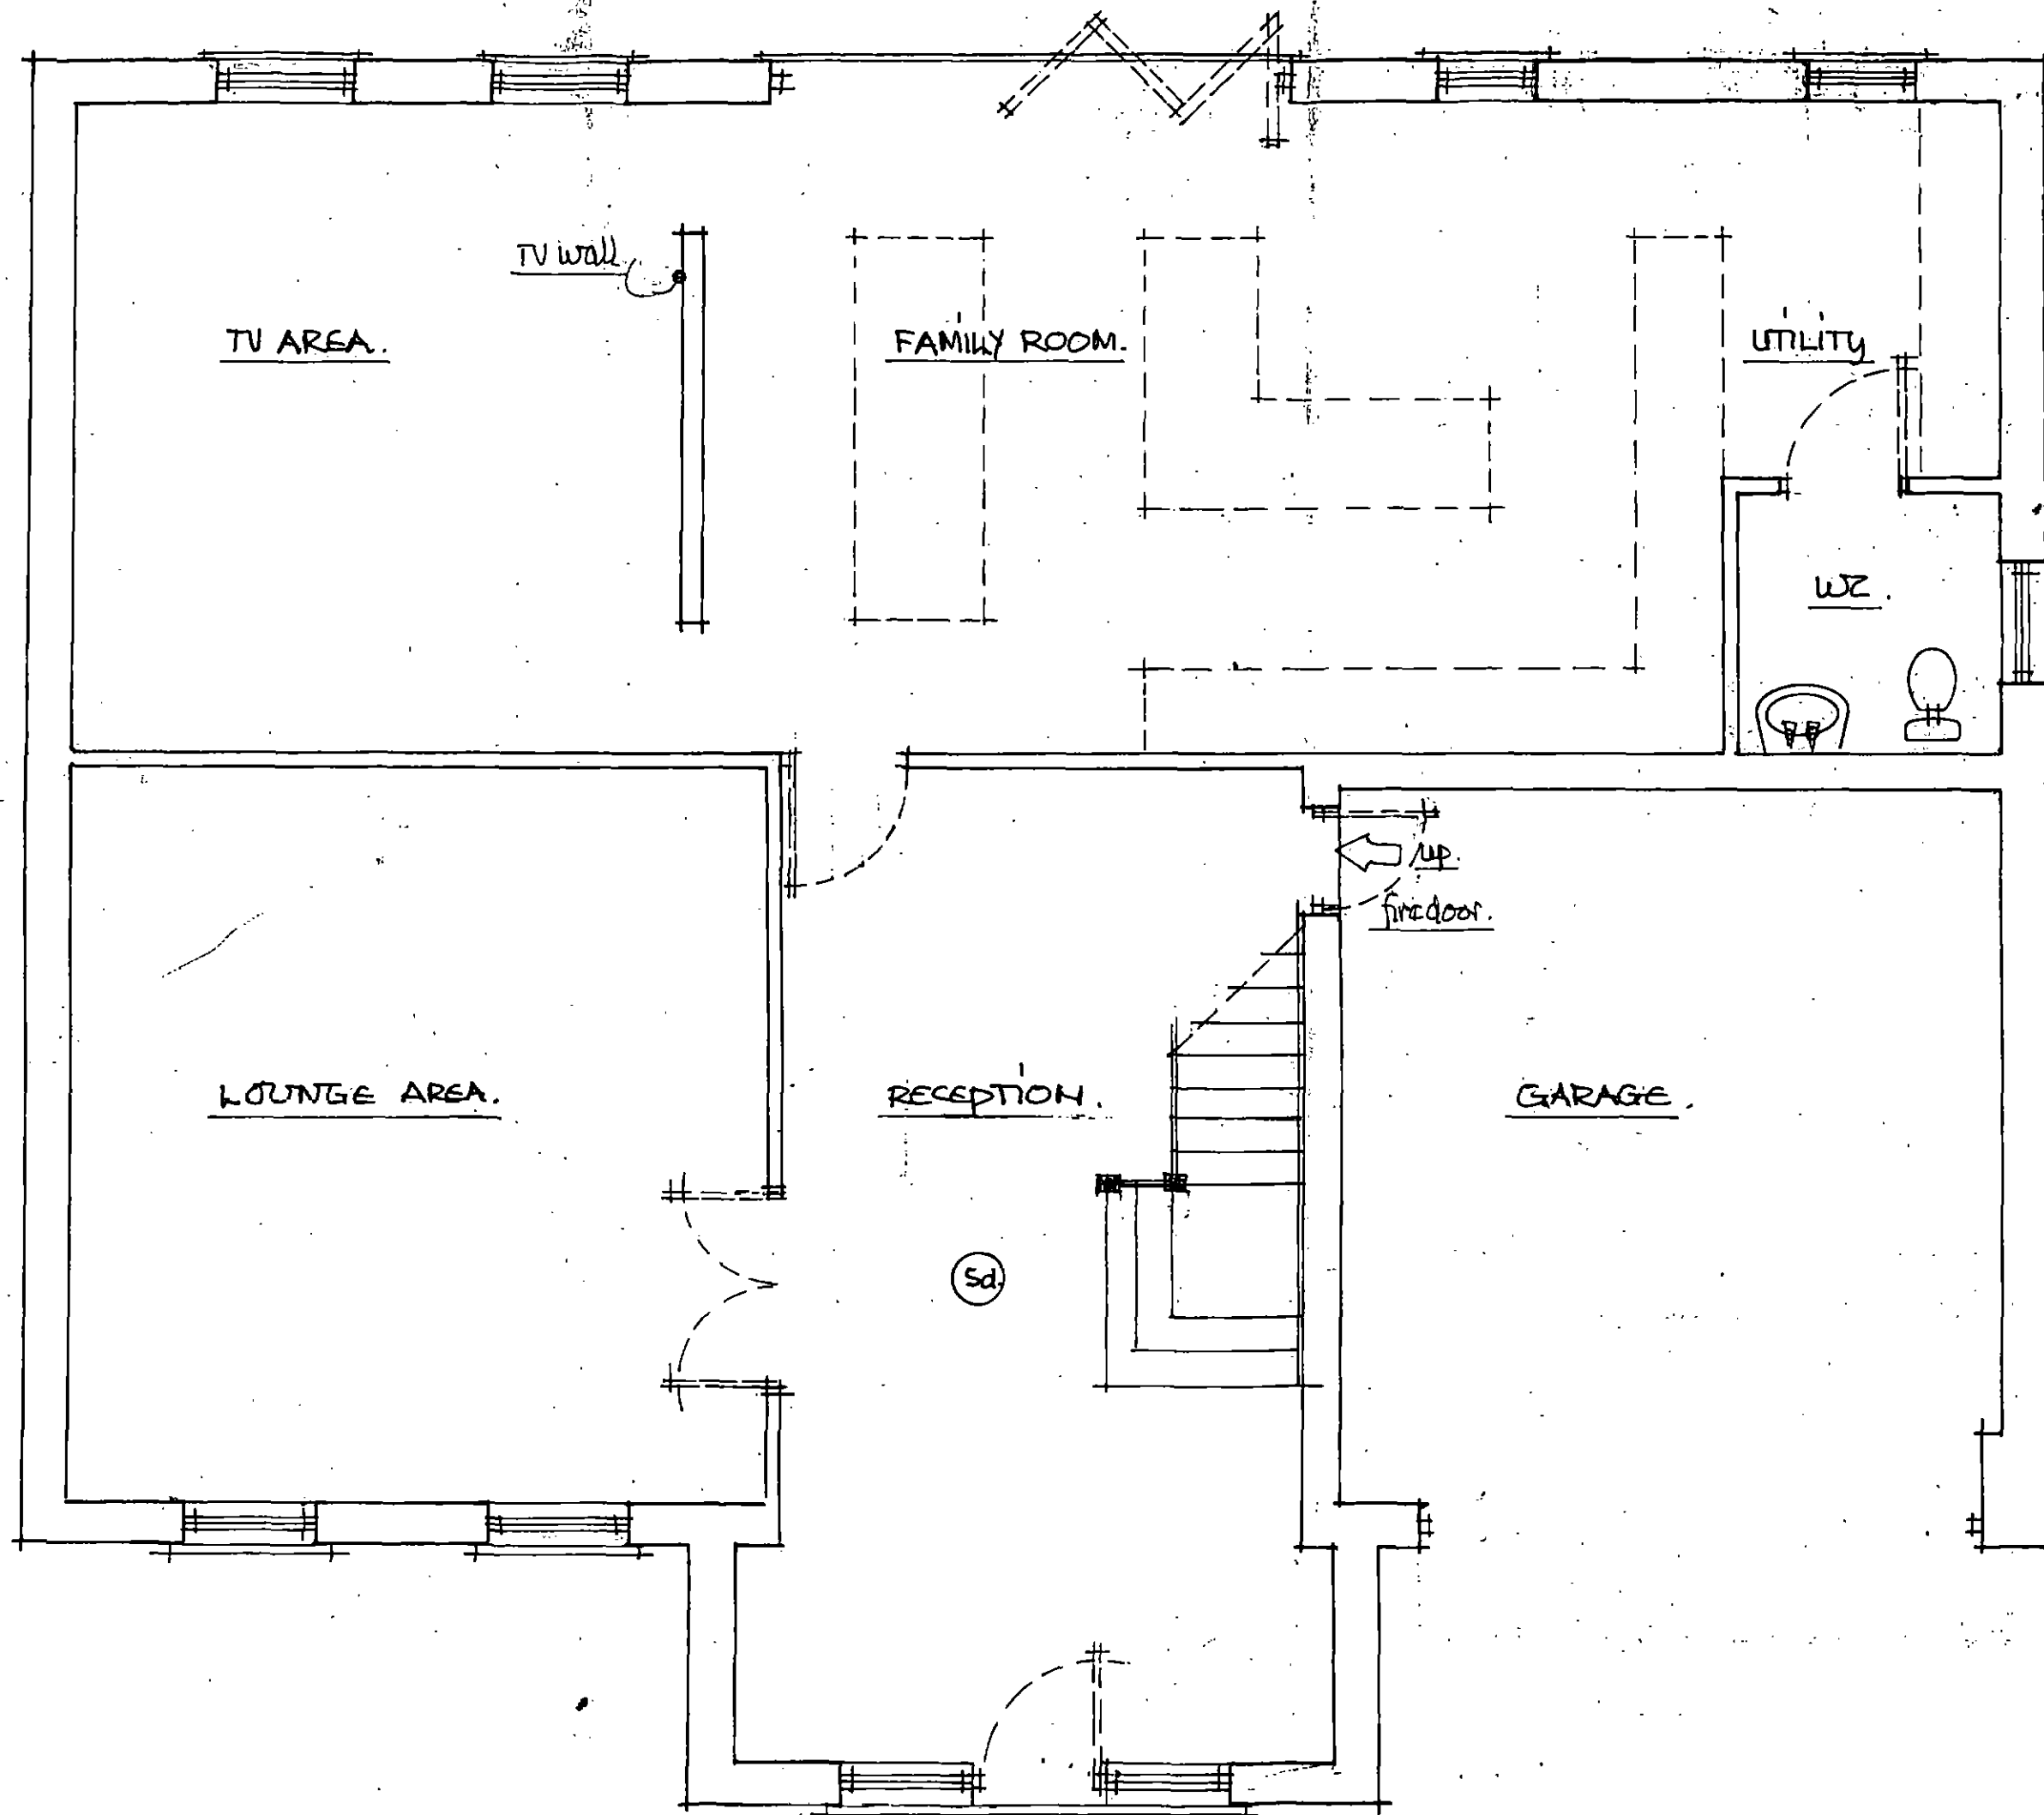


GROUND FLOOR LAYOUT @ 1:50

(Sd) SHOWS CEILING MOUNTED

SMOKE DETECTORS

* ALL FIXTURES + FITMENTS

TO CLIENTS CHOICE +
POSITIONING.

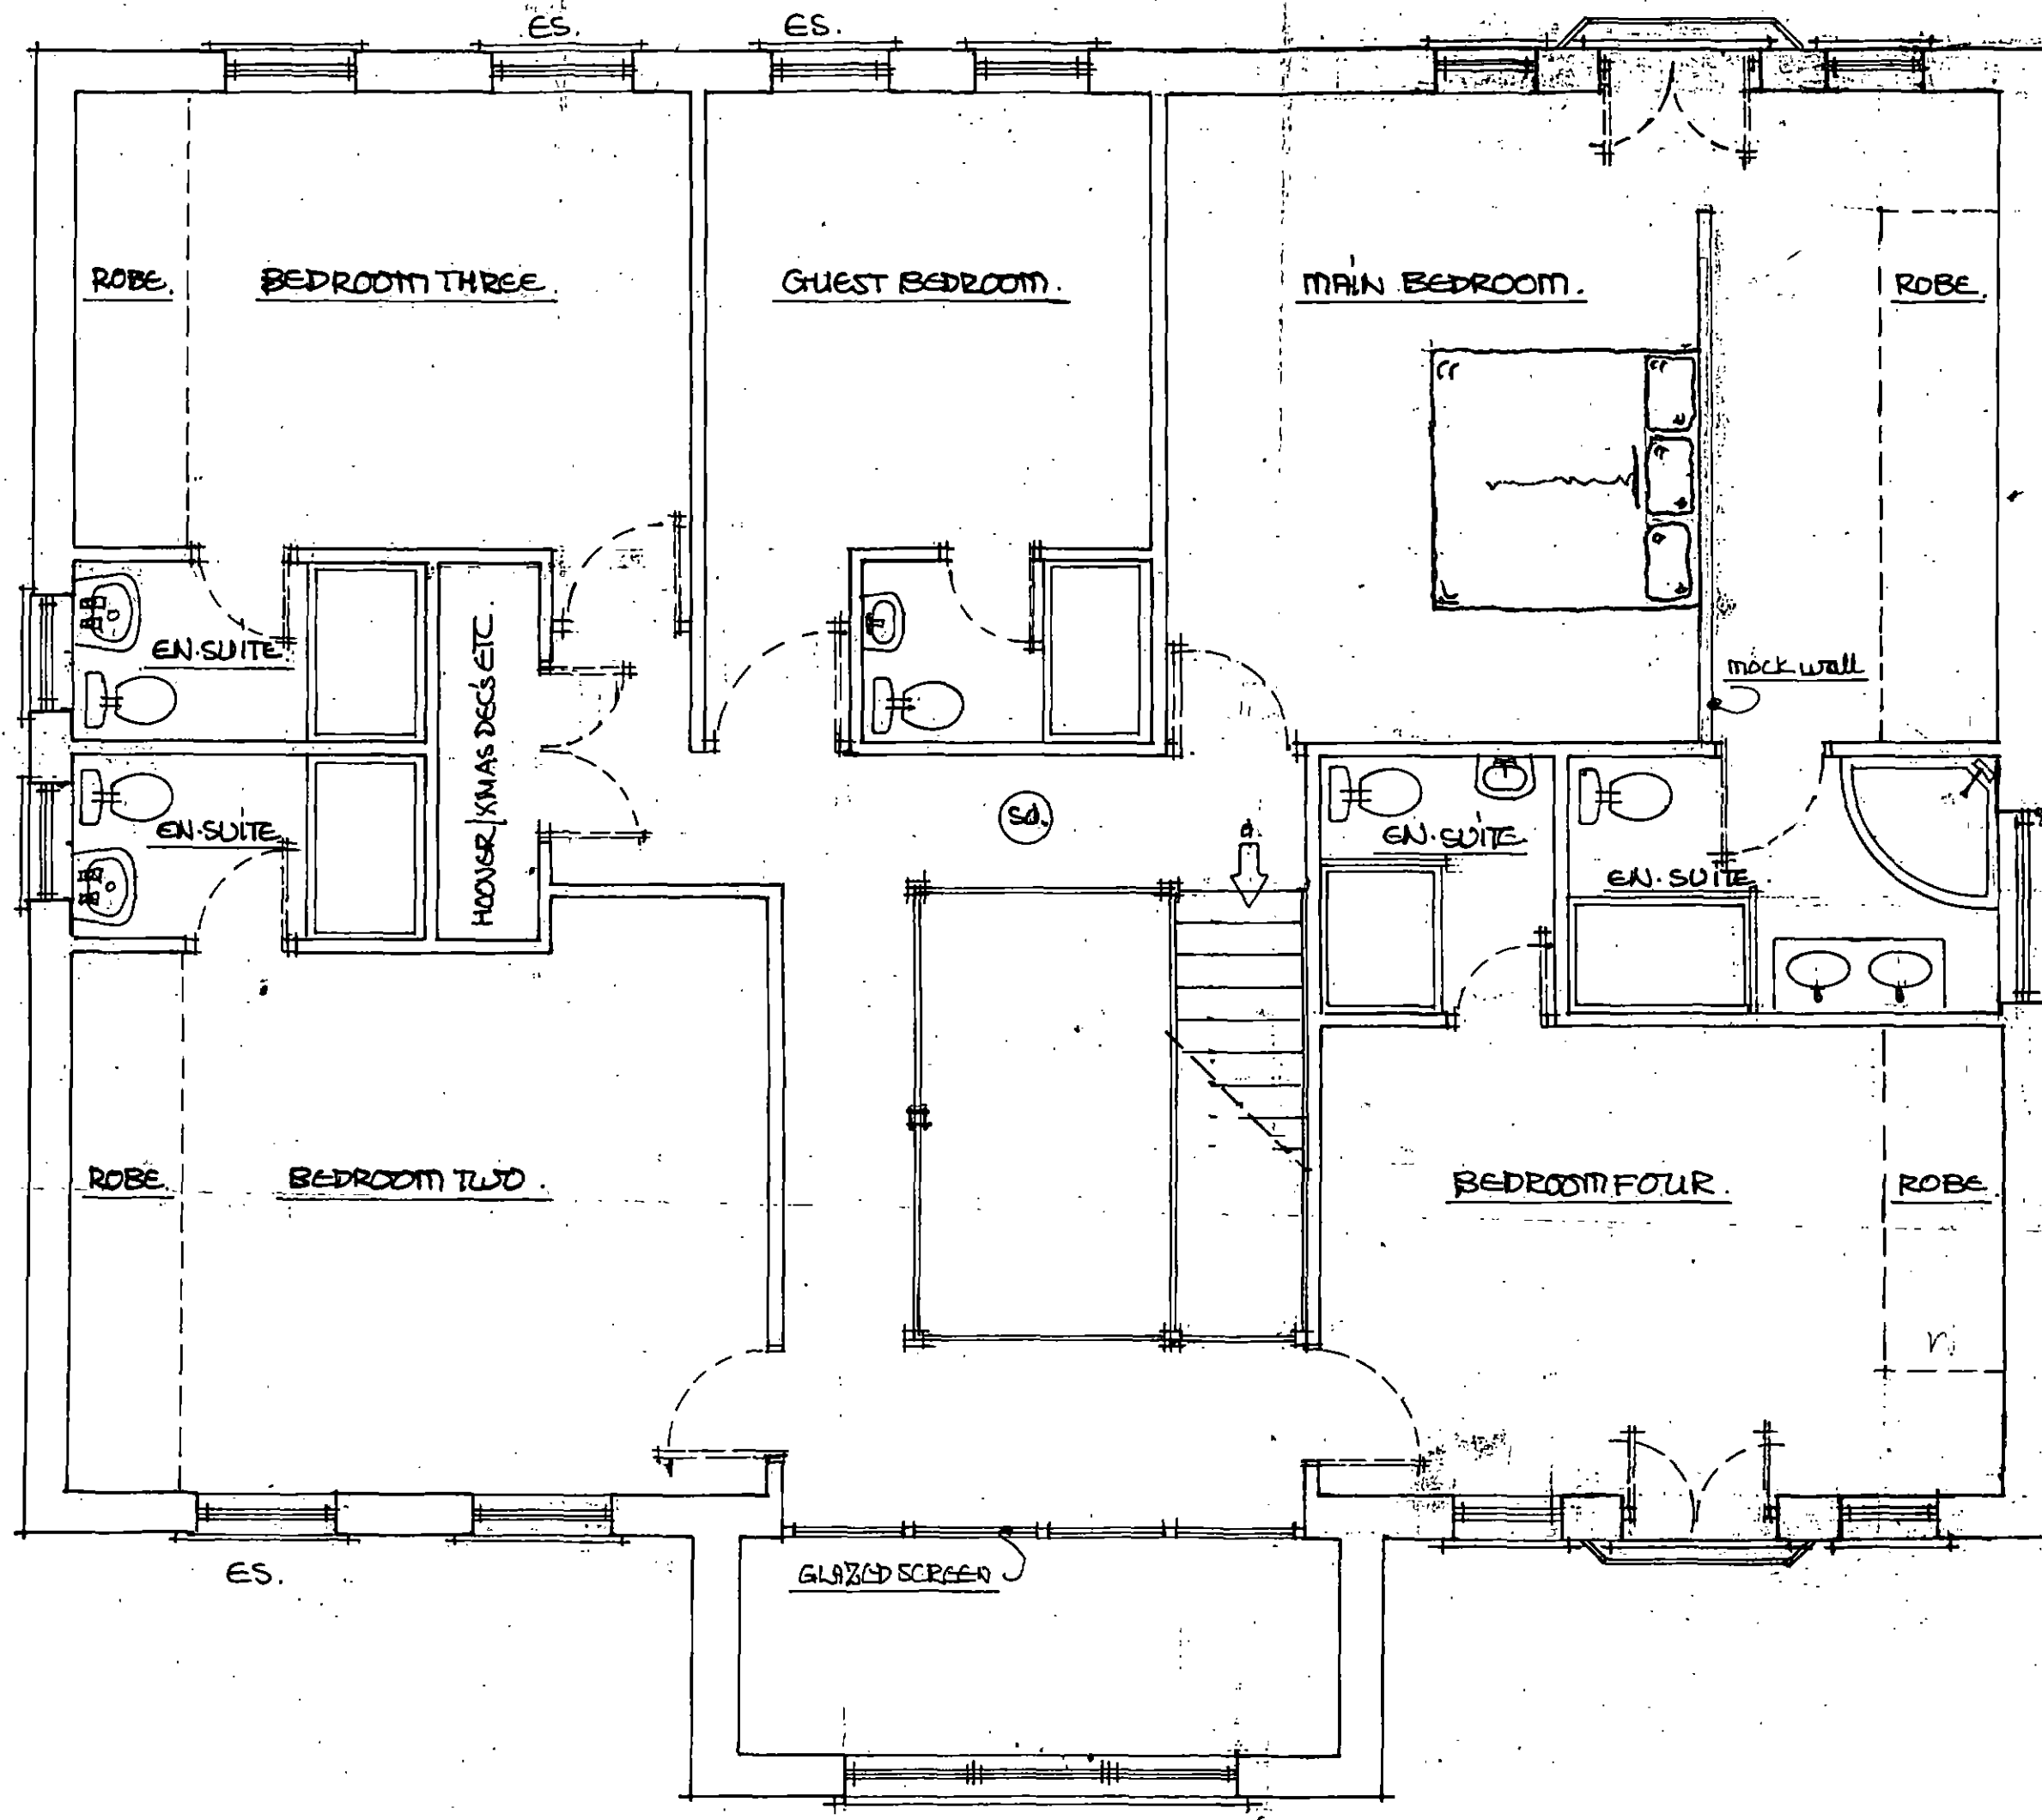

FIRST FLOOR LAYOUT @ 1:50

(SD) SHOWS CEILING MOUNTED
SMOKE DETECTORS 300MM
MIN FROM LIGHT FITTINGS
+ WALL JUNCTIONS - TO BE
INTERCONNECTED TO G.F.
DETECTORS + WIRED BACK
TO FUSE BD + BATTERY
BACK-UP.

ES - SHOWS FIRE SAFETY ESCAPE
SASH MIN 750H X 450W TO
OPEN THRO' 90° BOTTOM OF
SASH BETWEEN 800/1100MM
ABOVE FLOOR LEVEL.

* ALL FIXTURES + FITMENTS
TO CLIENTS CHOICE +
POSITIONING.