

PLANT

New Hubbard DA Pack
Model : External Housed Pack
HT : 1 X ZBD45 and 2 X ZB45 Scroll Compressors
LT : 1 X ZFD13 and 1 X ZF09 Scroll Compressors
Dimensions: 1792mm(L) x 750mm(D) x 1946mm(H)
Sound Power Level: 60 dB(A) Day time, 57 dB(A) Night time
TP&N Power supply
Full Load Current: 54 Amps
Design Run Current : 38 Amps

New Searle Condenser
Model : **RF-NB102L3H-091E-SC7-AV**
Dims: 3323mm(L) x 1578mm(D) x 1583mm(H)
Sound Power Level: 65 dB(A) Day time, 58dB(A) Night time.
Weight: 700kg.


AIR CONDITIONING

AC1
Existing Relocated Mitsubishi AC unit
Model : PUHZ-RP140YKA
Dimensions: 1050mm(W) x 360mm(D) x 1338mm(H)
Weight : 137kg
Sound Pressure level: 52dB(A) @1m Unit operational during day time only.
TP&N Supply to the unit.
Fuse rating 16Amps. System running current 7.66Amps.

AC2
New Daikin AC unit
Model : RXYSQ10TY1
Dimensions: 940mm(W) x 460mm(D) x 1615mm(H)
Weight : 180kg
Sound Power Level : 74dB(A) Unit operational during day time only.
TP&N Supply to the unit.
Fuse rating 25Amps. System running current 10.7Amps.



AC3
New Daikin AC unit for Post office
Model : RXS35L3
Dimensions: 765mm(W) x 285mm(D) x 550mm(H)
Weight : 38kg
Sound Power level: 61dB(A) Unit operational during day time only.
Single Phase Supply to the unit.
Fuse rating 10Amps. System running current 4.10Amps.

REVISION

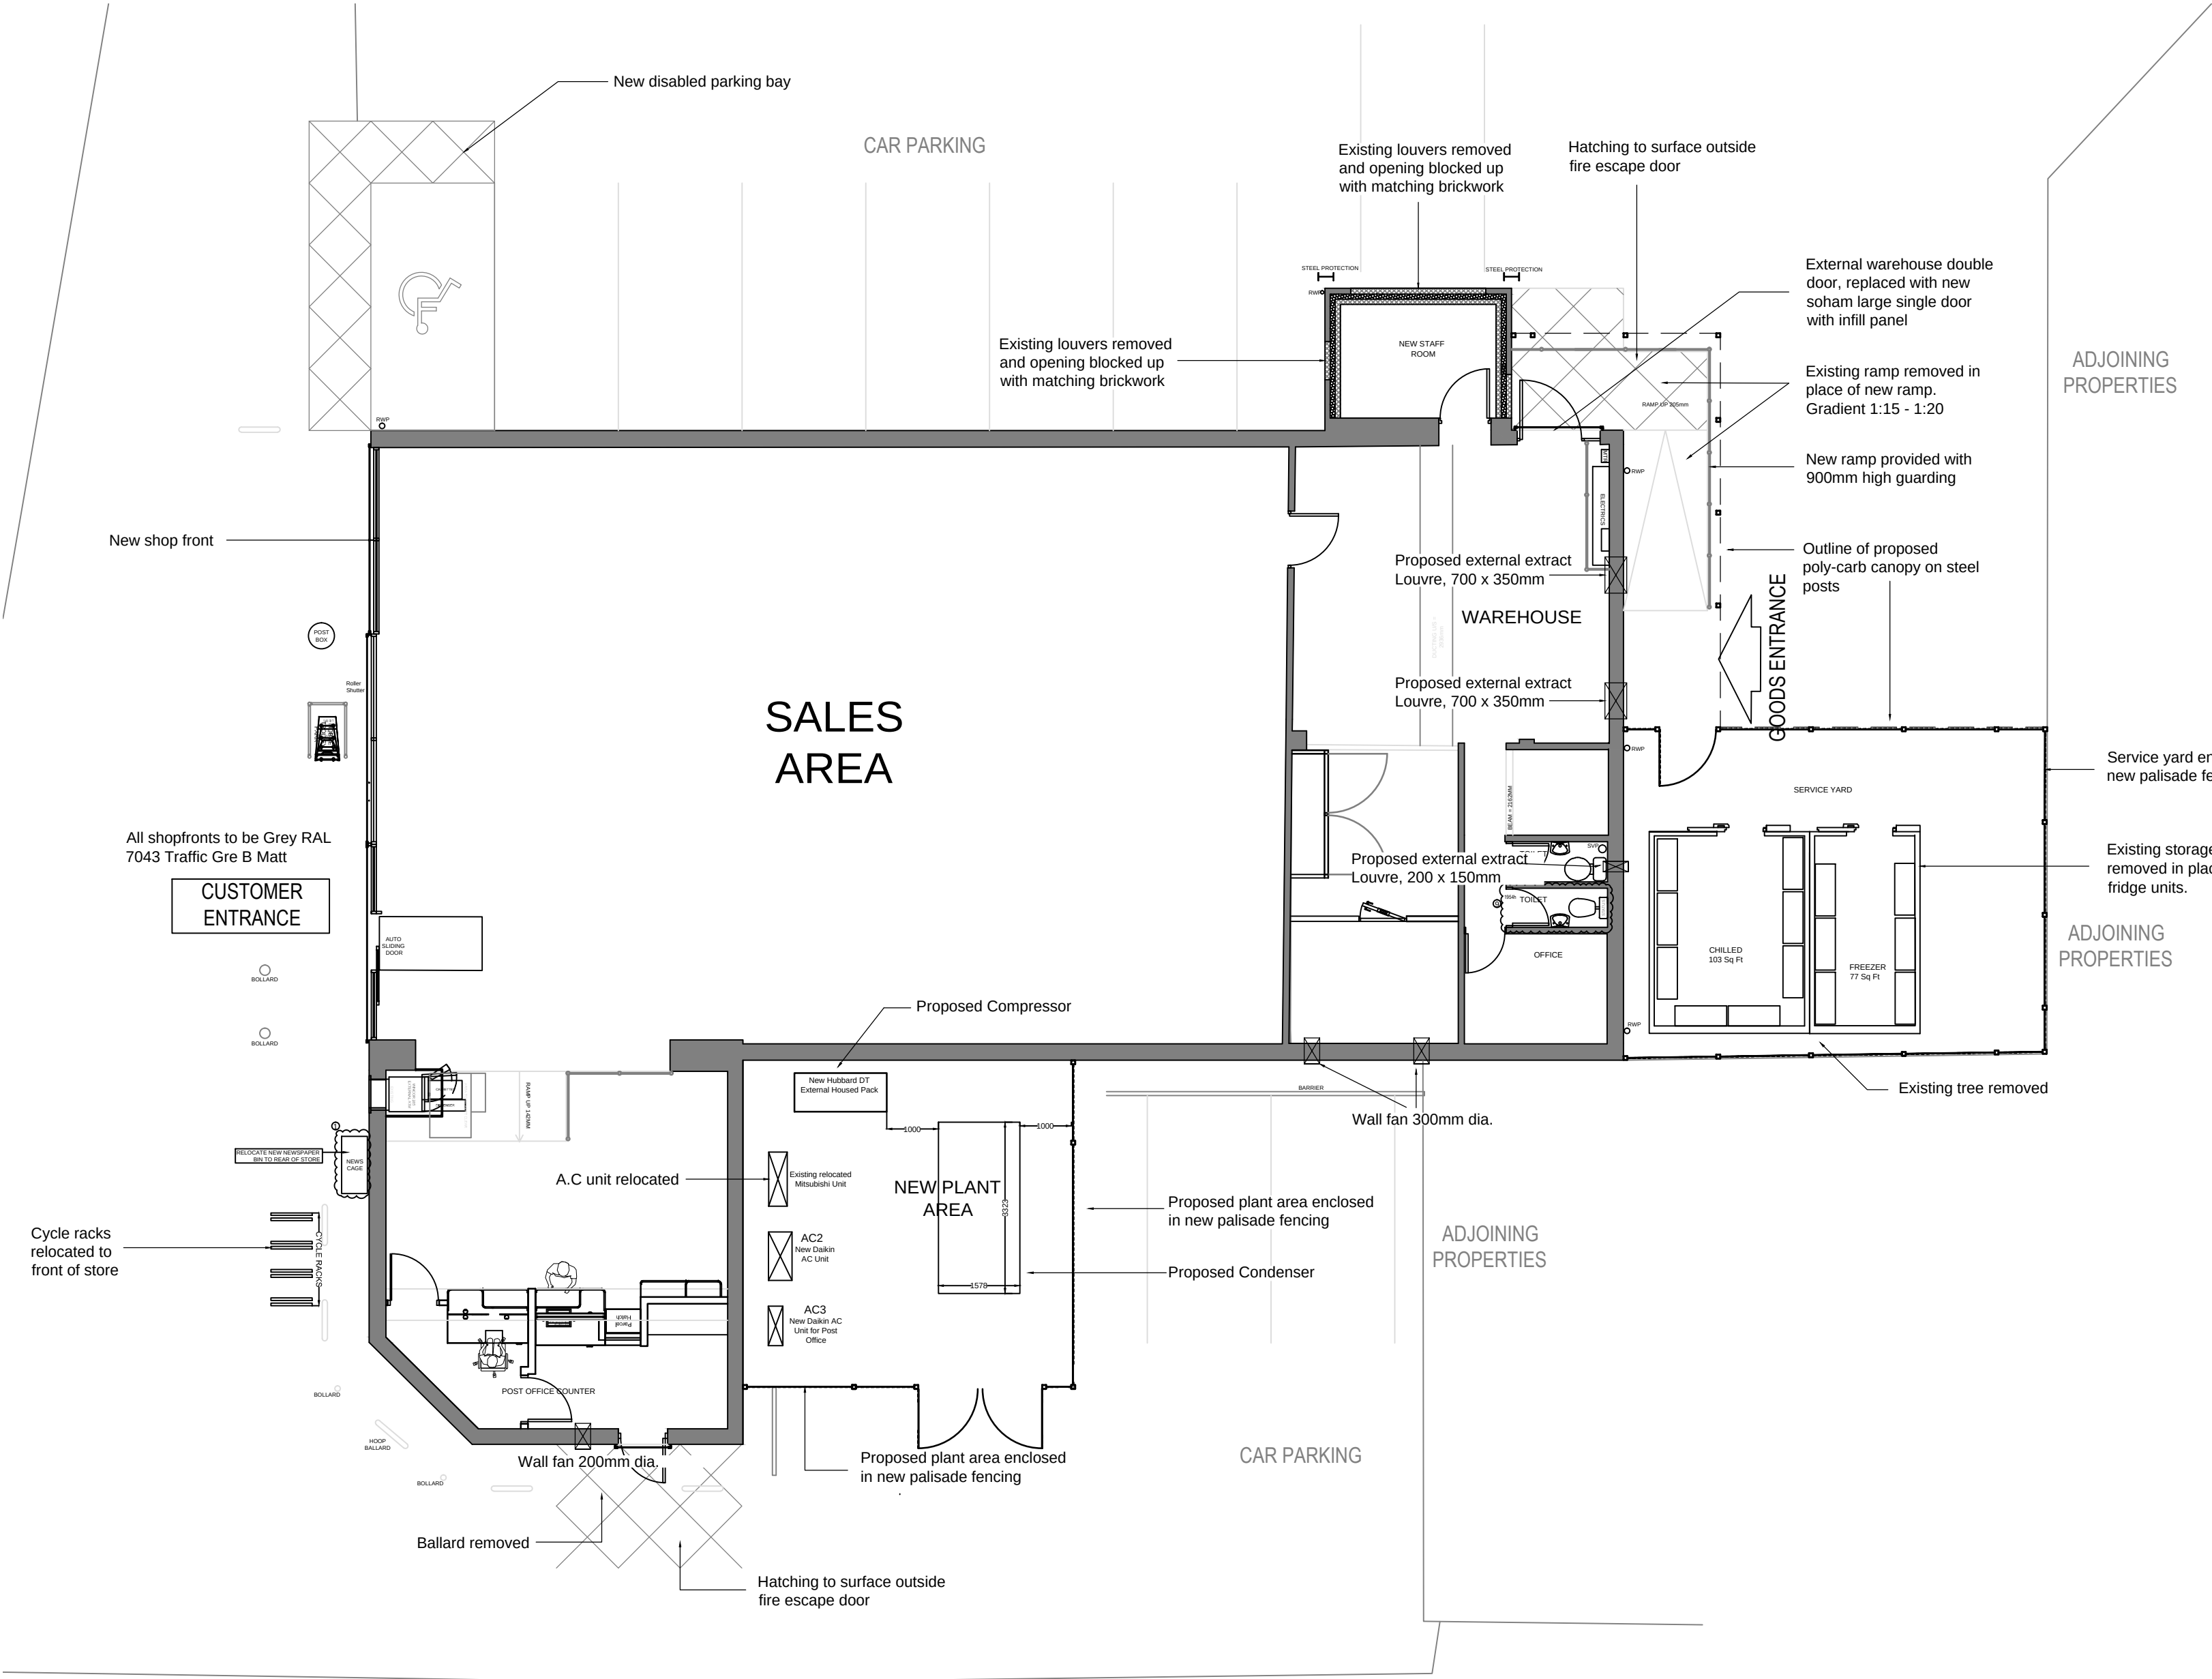

PROPOSED GROUND FLOOR PLAN


 
SCALE 1:100

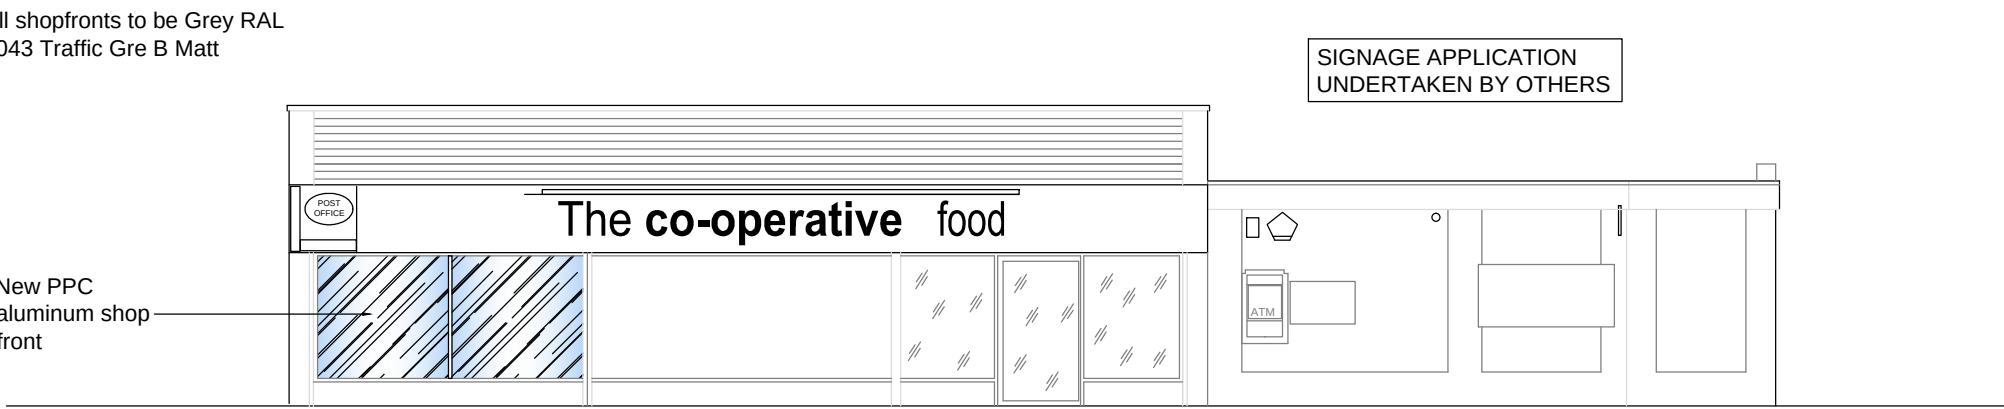

ELEVATION A-A

PROPOSED ELEVATION A-A


 
SCALE 1:100

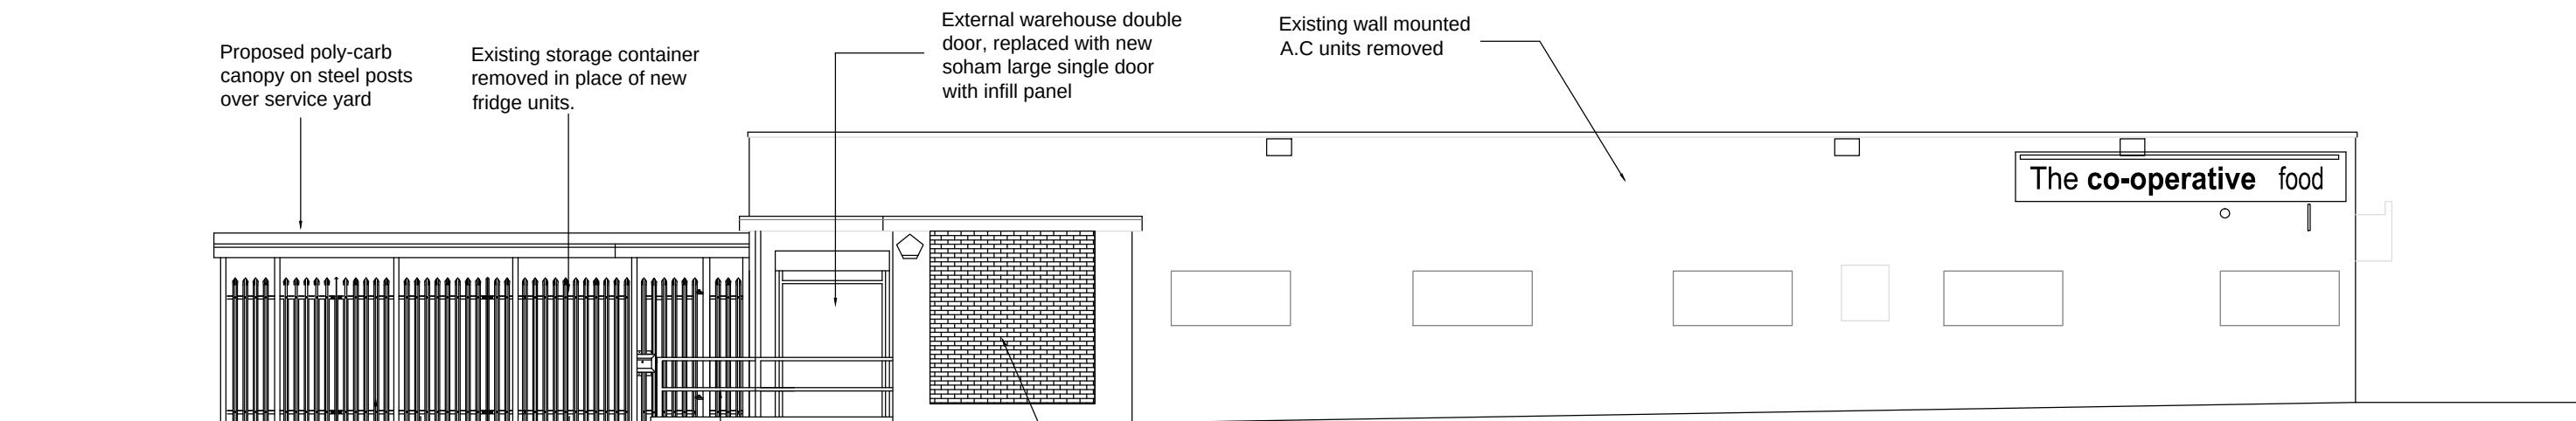

ELEVATION B-B



PROPOSED ELEVATION B-B

 SCALE 1:100

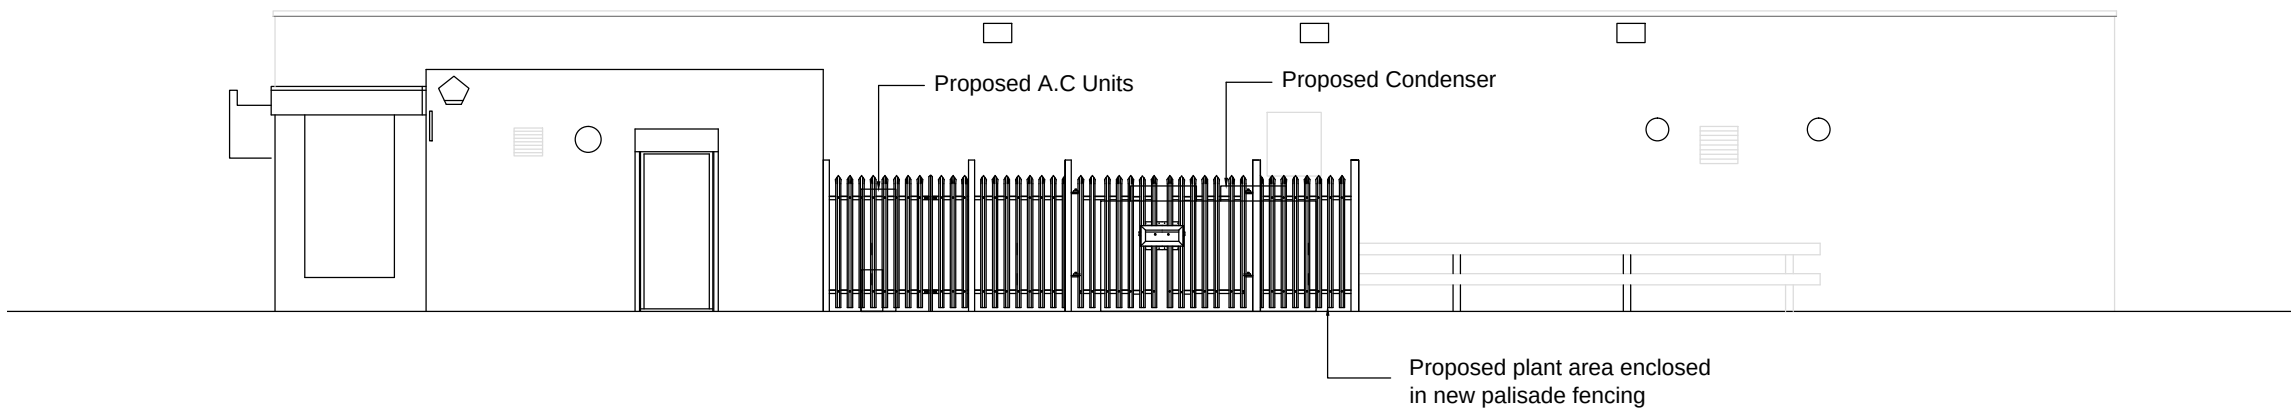


PROPOSED ELEVATION C-C

 SCALE 1:100

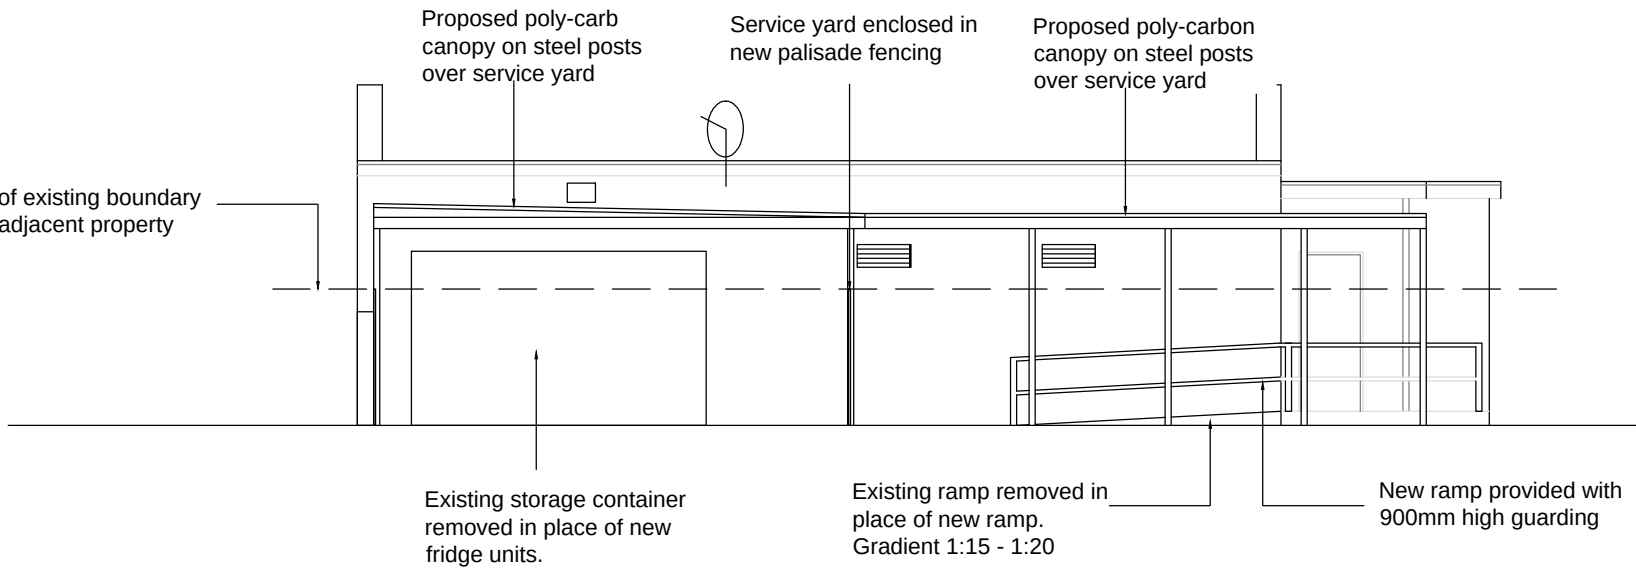

PROPOSED ELEVATION D-D

 SCALE 1:100



© THE CONTENTS OF THIS DRAWING REMAIN THE SOLE PROPERTY OF WELLSFIELD ASSOCIATES AND MUST NOT BE COPIED OR REPRODUCED WITHOUT PRIOR PERMISSION.

FULL SURVEY NOT CARRIED OUT, DRAWING PRODUCED USING INFORMATION SUPPLIED BY THE CLIENT

Wellsfield Associates

project

CO-OP SUPERMARKET
Hoyland Road,
Barnsley,
S74 ONE

PROPOSED PLANS

date

JULY 16

drawn

WJ

scale

1:100 AND 1:50

drg no.

3170 - 03