


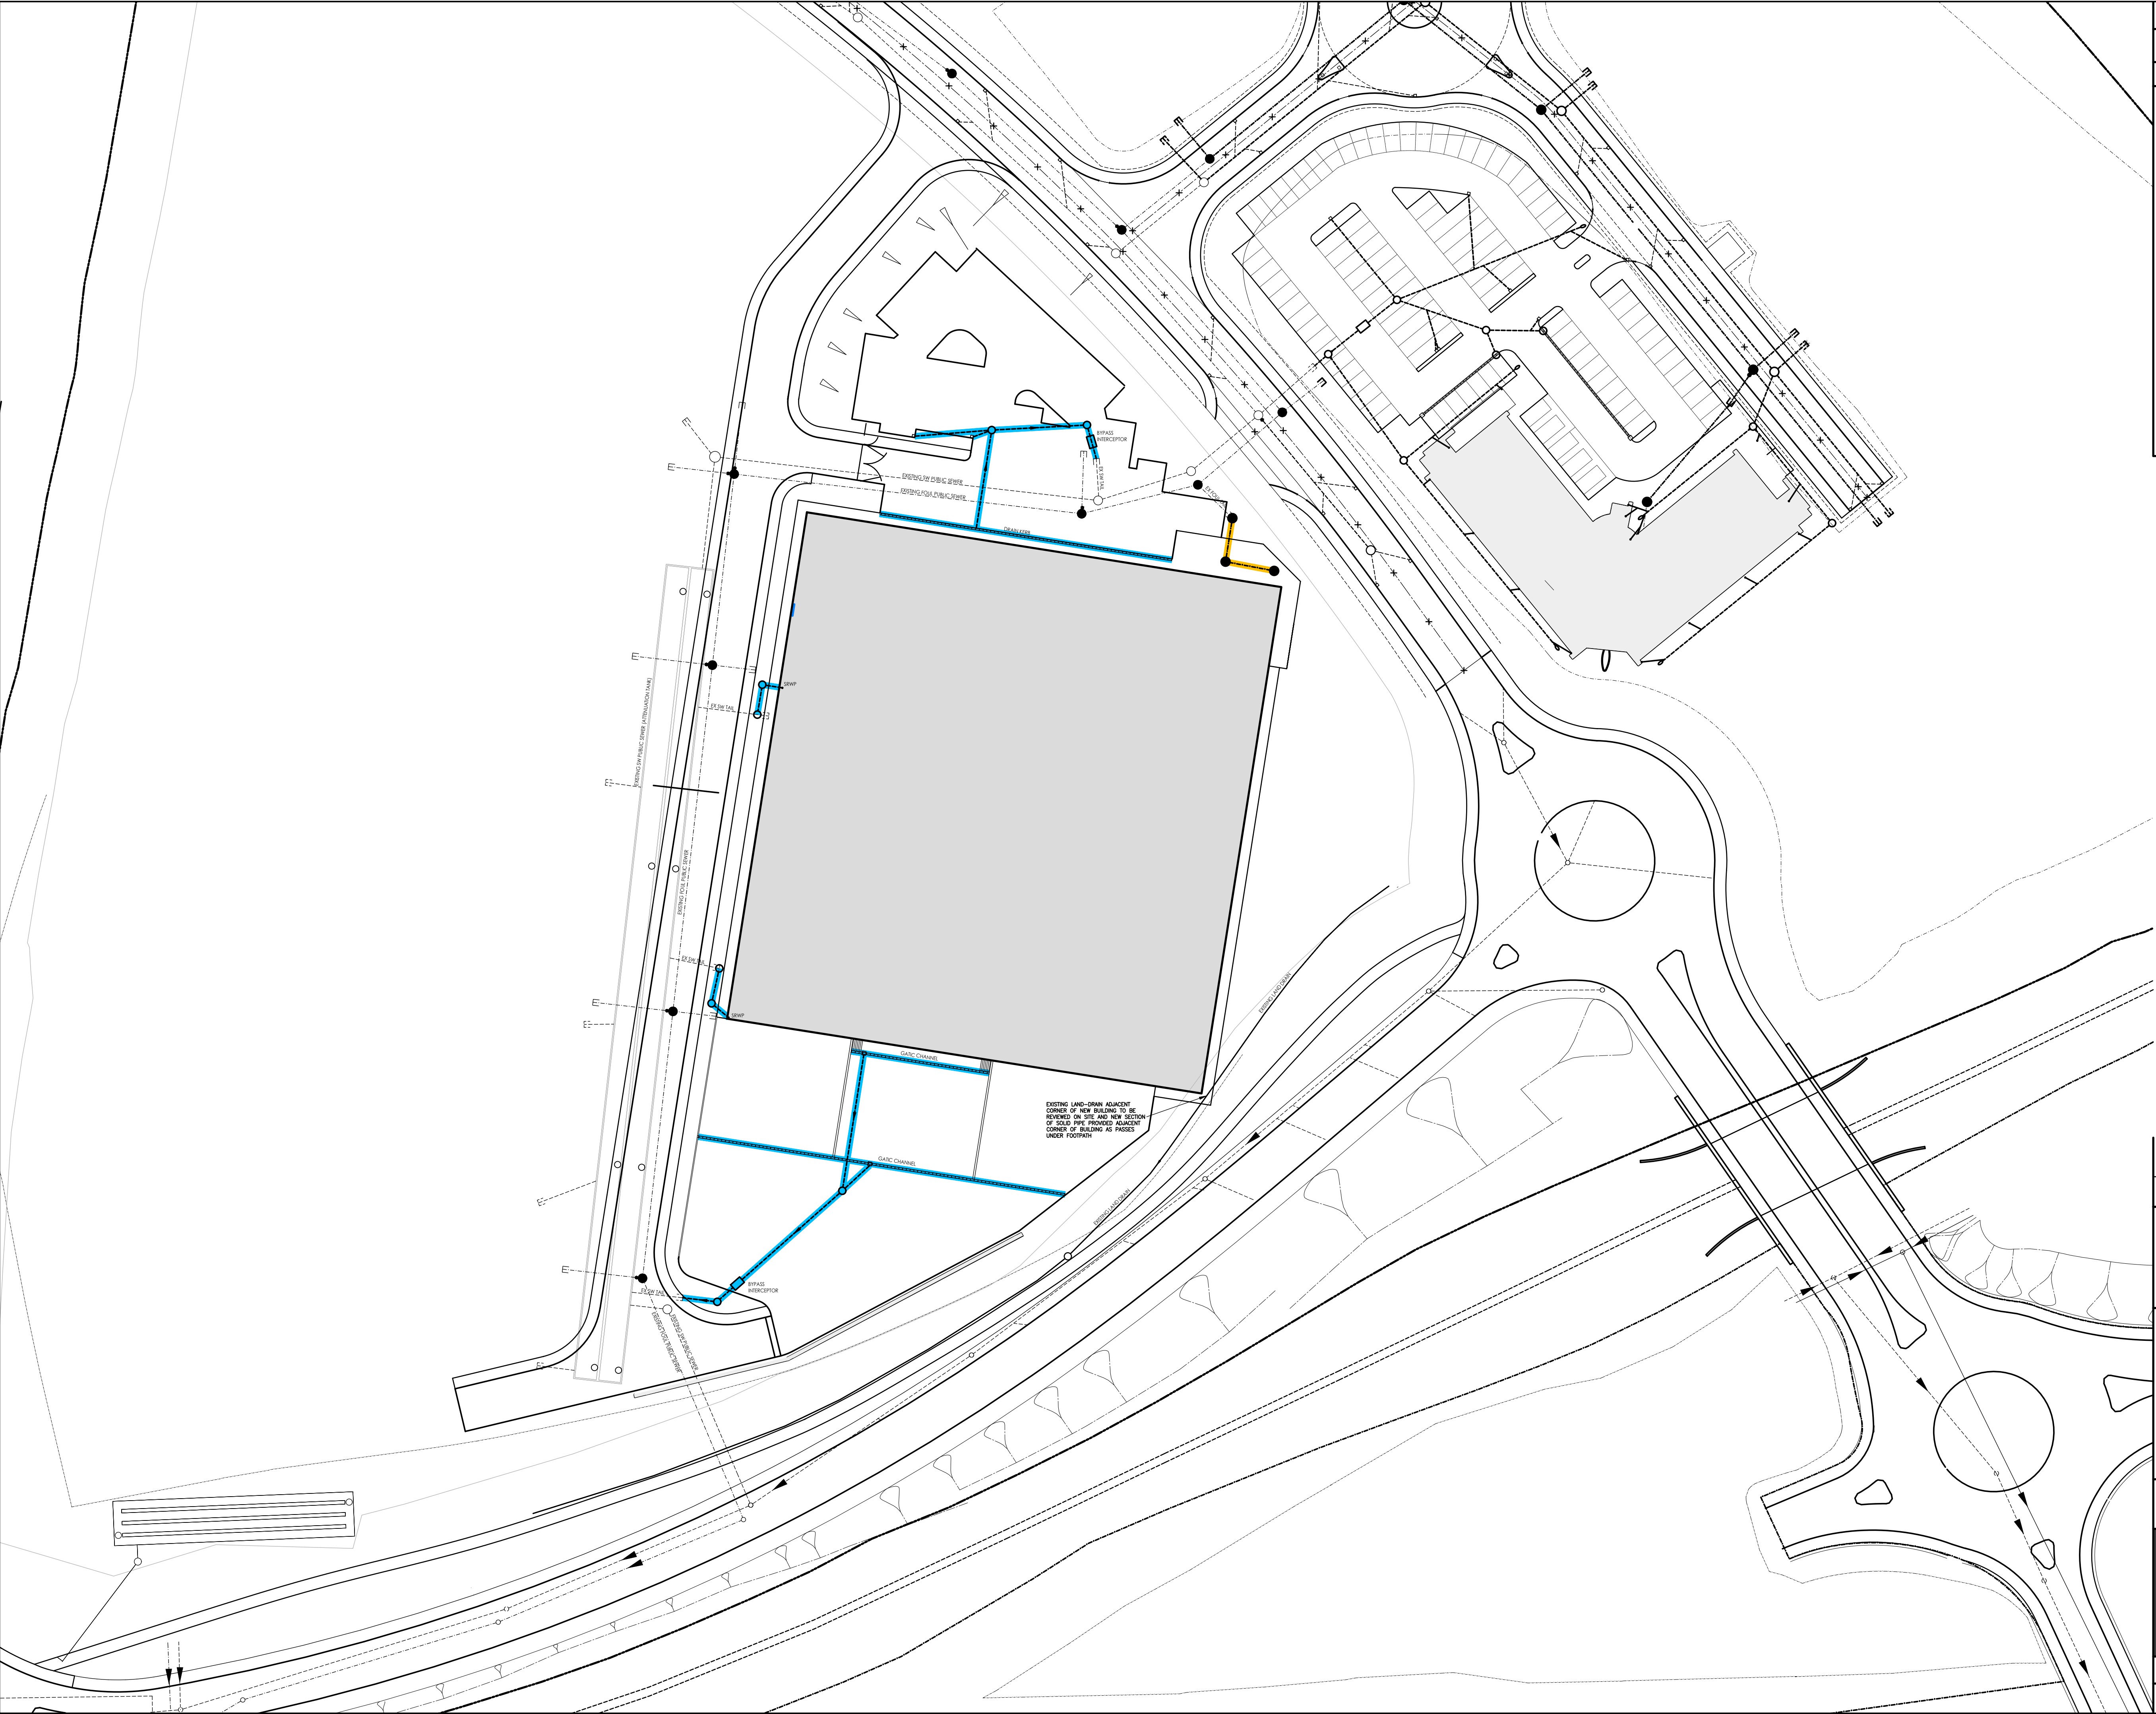

© THIS DRAWING IS THE PROPERTY OF JPG (LEEDS) LIMITED
REGISTERED IN ENGLAND NO 4274608. COPYRIGHT RESERVED

DO NOT SCALE

NOTES

DRAINAGE KEY:

EXISTING SURFACE WATER DRAIN

EXISTING FOUL DRAIN

PROPOSED SURFACE WATER DRAIN

PROPOSED FOUL DRAIN

PROPOSED DRAIN WITH 150mm CLASS 2' BED AND SURROUND (CONCRETE).

FW PROPOSED FOUL WATER MANHOLE

SW PROPOSED SURFACE WATER MANHOLE

G PROPOSED ROAD GULLY

BD MANHOLE WITH BACKDROP CONNECTION

RWP PROPOSED RAINWATER PIPE

SRWP PROPOSED SIPHONIC RAINWATER PIPE

AB PROPOSED GATIC ACCESS BOX

SB PROPOSED GATIC SILT BOX

RE PROPOSED RODDING EYE

REV	DESCRIPTION	DATE	BY
Job Title CAPITOL PARK BARNSELEY			
Drawing Title DRAINAGE LAYOUT			
Architect			
JPG www.jpggroup.global Leeds: +44 (0)113 263 1155 Also: London & Muscat			
Checked	Date	Scale	Drawn
	14.02.17	1:500	A1 JH
Drawing No		2450.2017-DSK1	-