


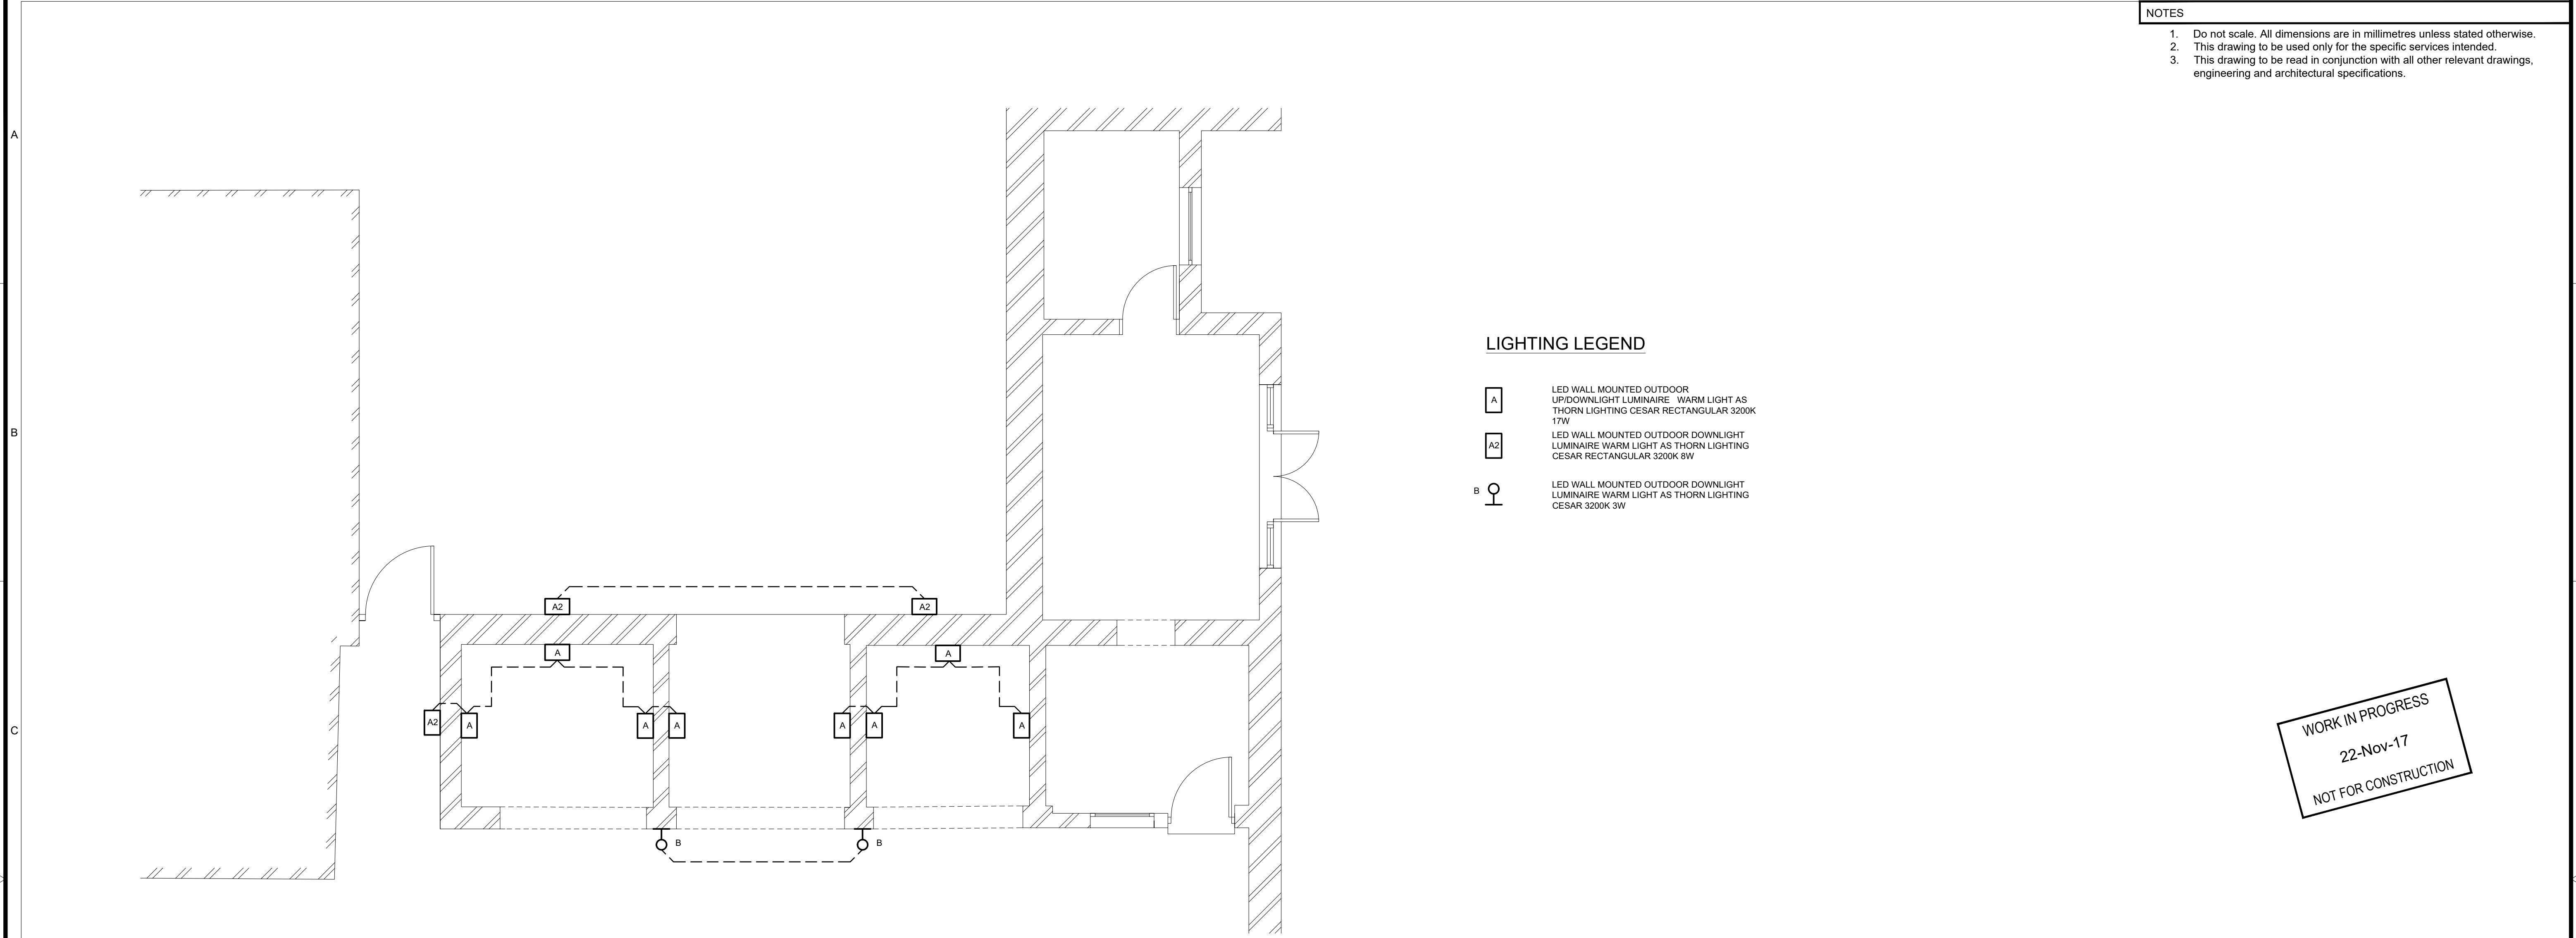

LIGHTING LEGEND

- A


LED WALL MOUNTED OUTDOOR UP/DOWNLIGHT LUMINAIRE WARM LIGHT AS THORN LIGHTING CESAR RECTANGULAR 3200K 17W
- A2

LED WALL MOUNTED OUTDOOR DOWNLIGHT LUMINAIRE WARM LIGHT AS THORN LIGHTING CESAR RECTANGULAR 3200K 8W
- B

LED WALL MOUNTED OUTDOOR DOWNLIGHT LUMINAIRE WARM LIGHT AS THORN LIGHTING CESAR 3200K 3W

- NOTES
1. Do not scale. All dimensions are in millimetres unless stated otherwise.
 2. This drawing to be used only for the specific services intended.
 3. This drawing to be read in conjunction with all other relevant drawings, engineering and architectural specifications.

WORK IN PROGRESS
22-Nov-17
NOT FOR CONSTRUCTION

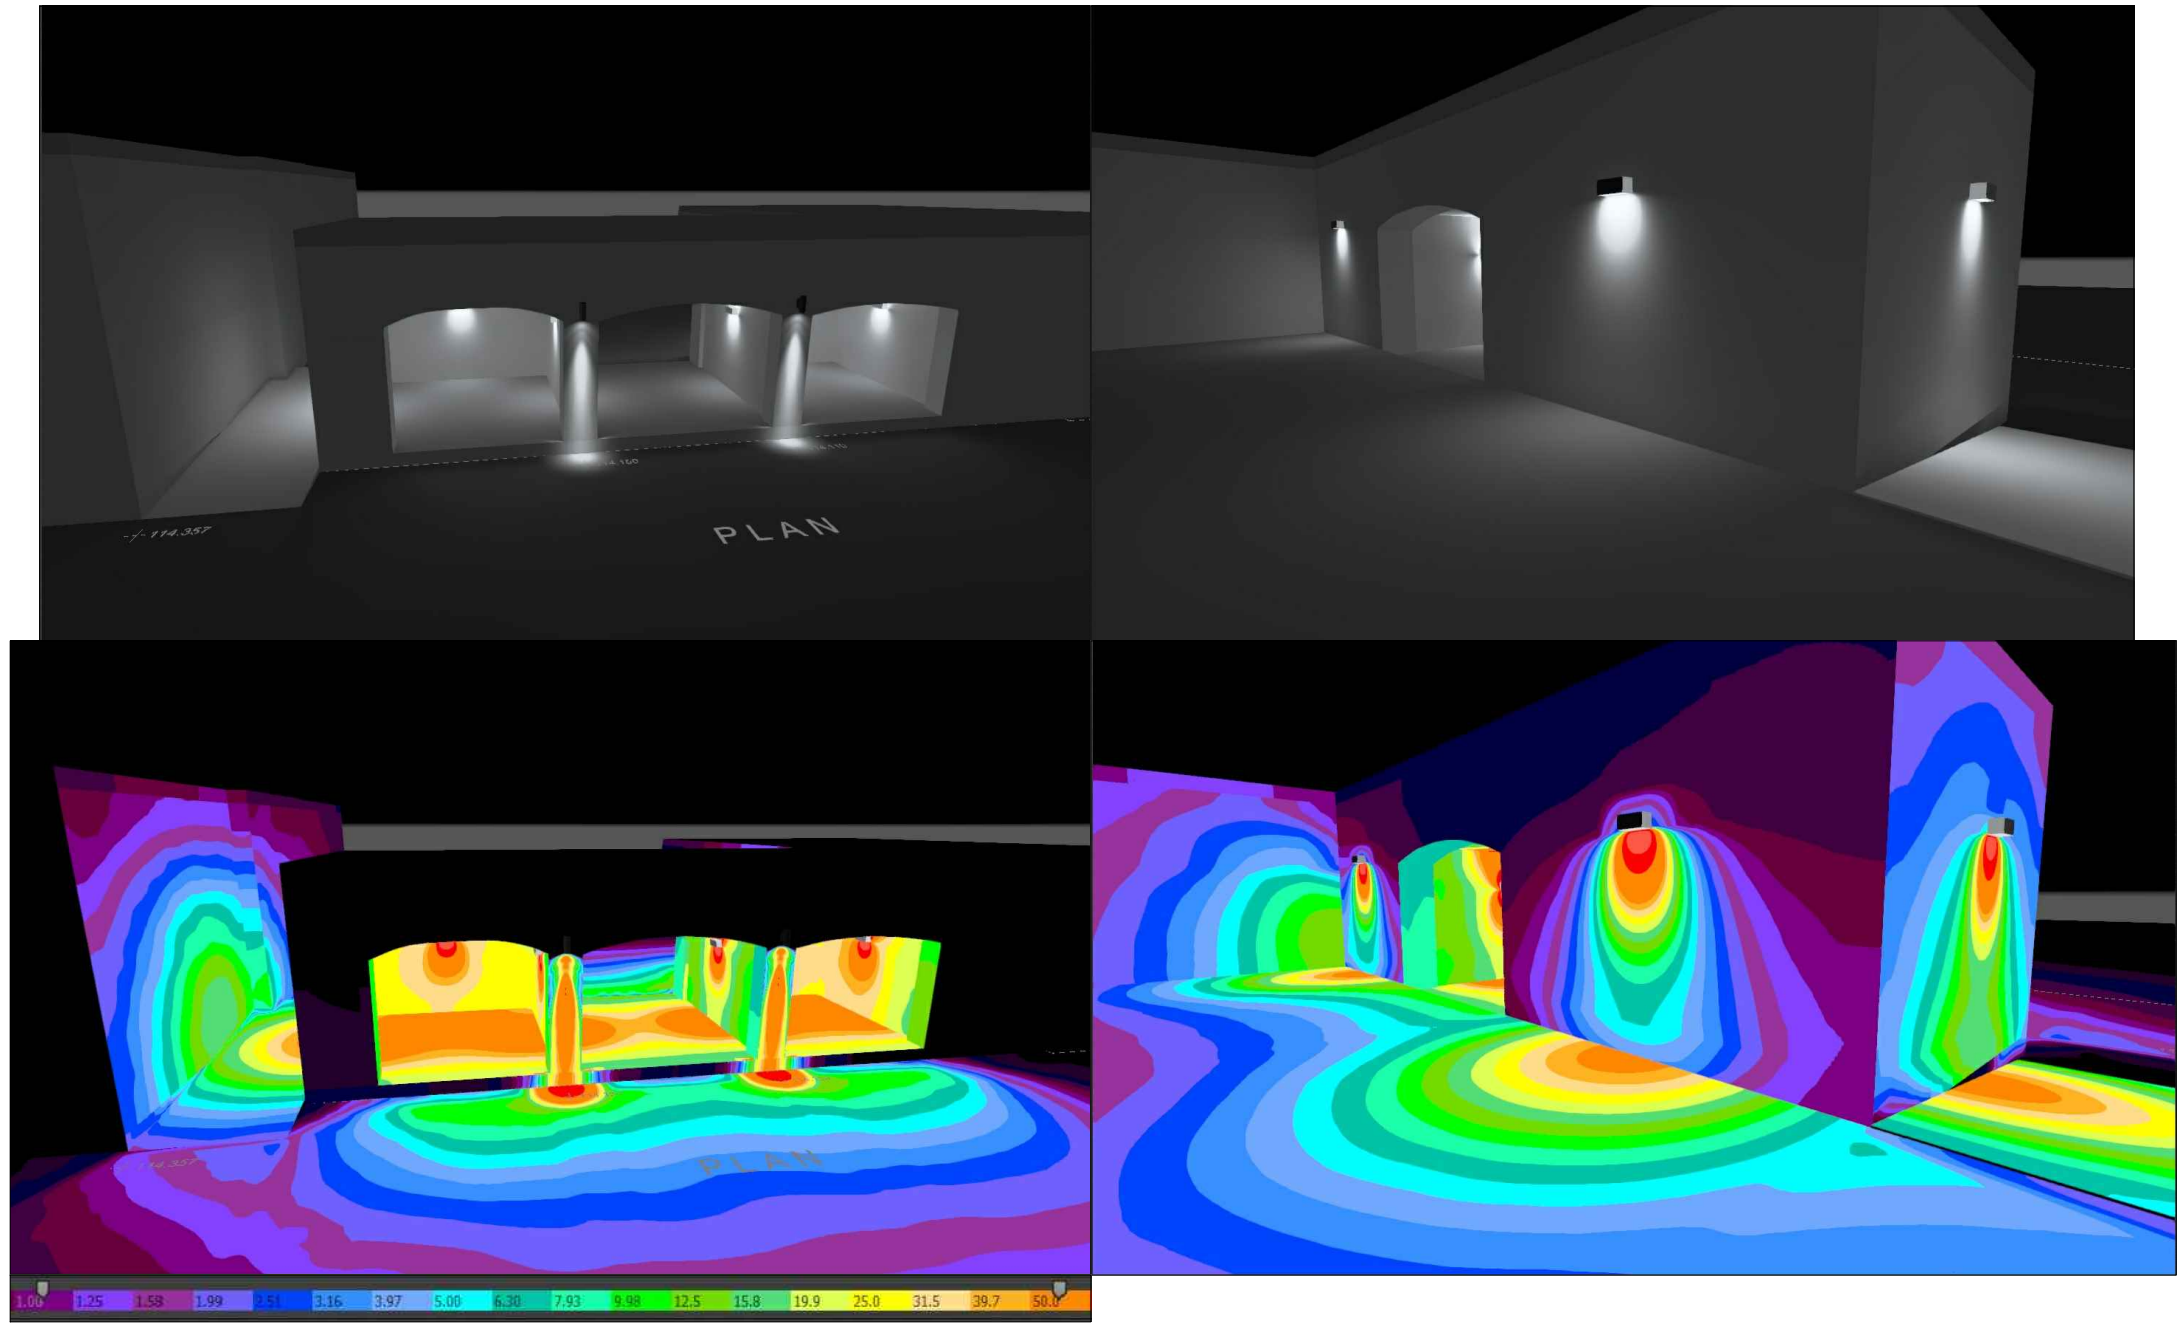

FOR COMMENT

P1	22.11.17	KC	Issued for Comment	KC	PH
Rev	Date	Drawn	Description	Ch'k'd	App'd

greenways
Building Services Consultants
BEDFORD COURT, 26-28 BEDFORD STREET
LEAMINGTON SPA,
WARWICKSHIRE CV32 3DY
TELEPHONE: 01926 337430
FAX: 01926 428964
E-mail: office@greenwaysbsc.com

Client

CANON HALL PARK
BARNSELY
-
-

Title

CART SHED
LIGHTING LAYOUT
-
-

Designed	KC	Drawn	KC	Approved	PH
Scale at A1	1:50	CAD NAME	GBSC-E500		
Drawing No	1764-E500				Rev
					P1