



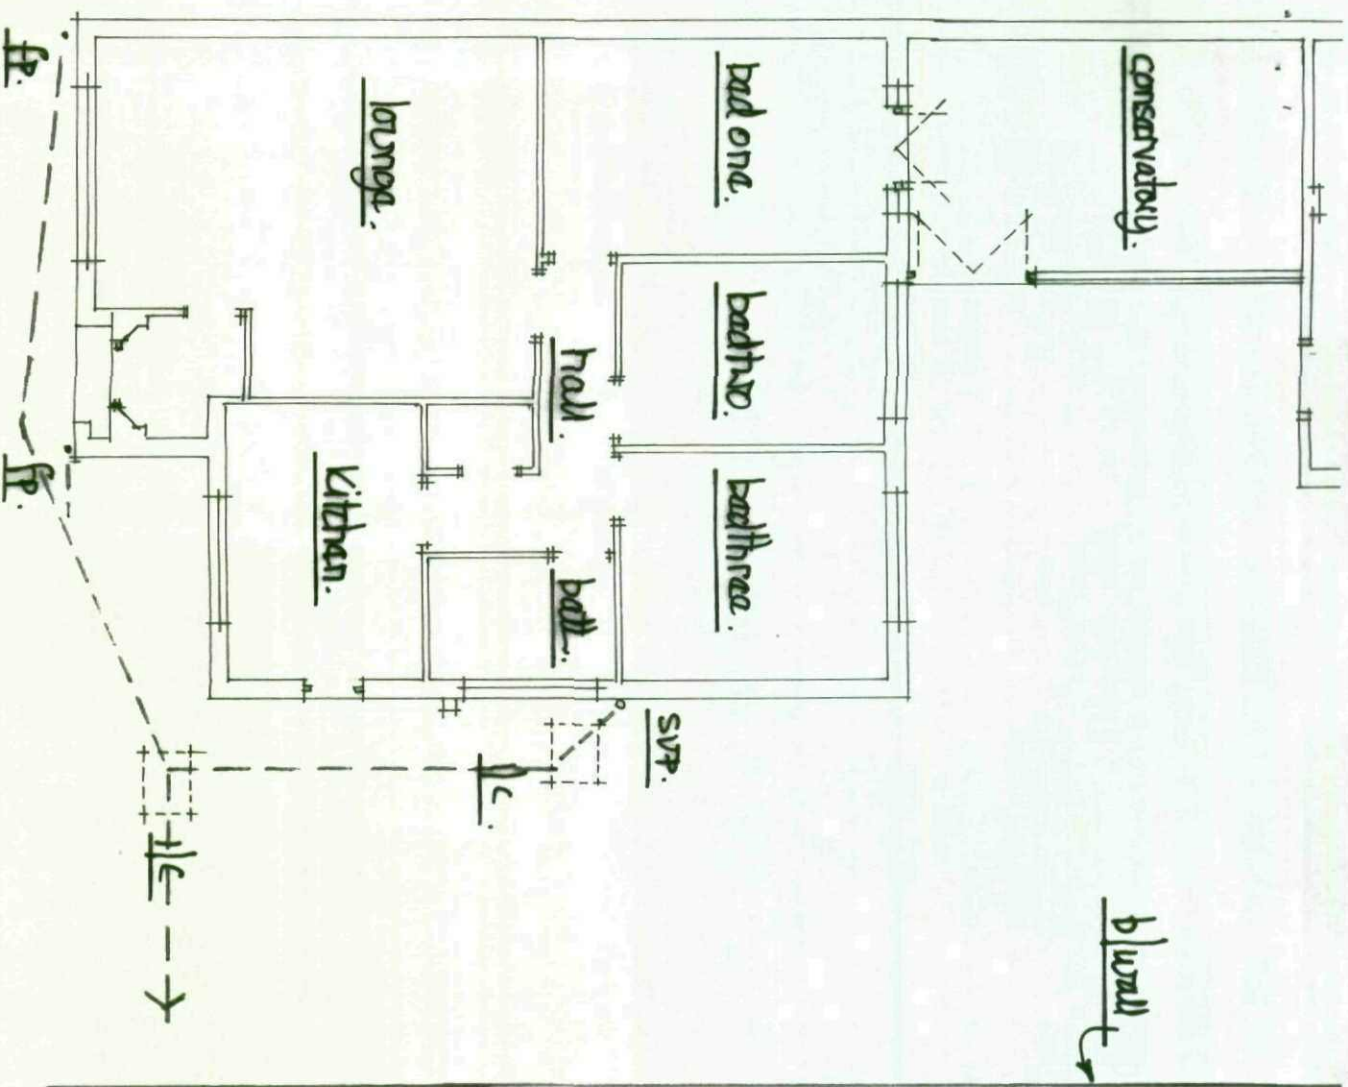

Floor plan.



front view.

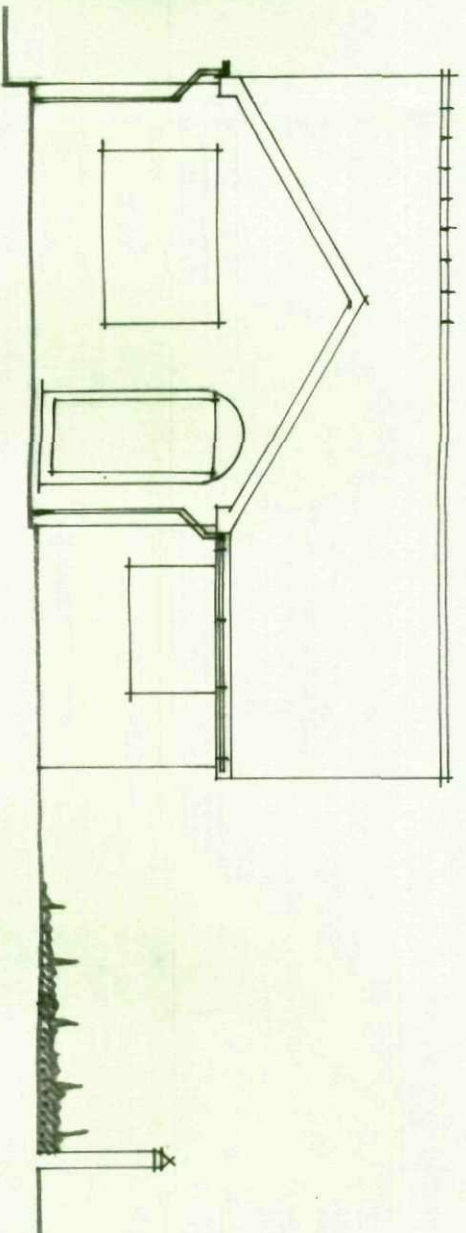

site plan: scale 1:500m.

rear view from gable/driveway not mileswood close.

side view from mileswood close.

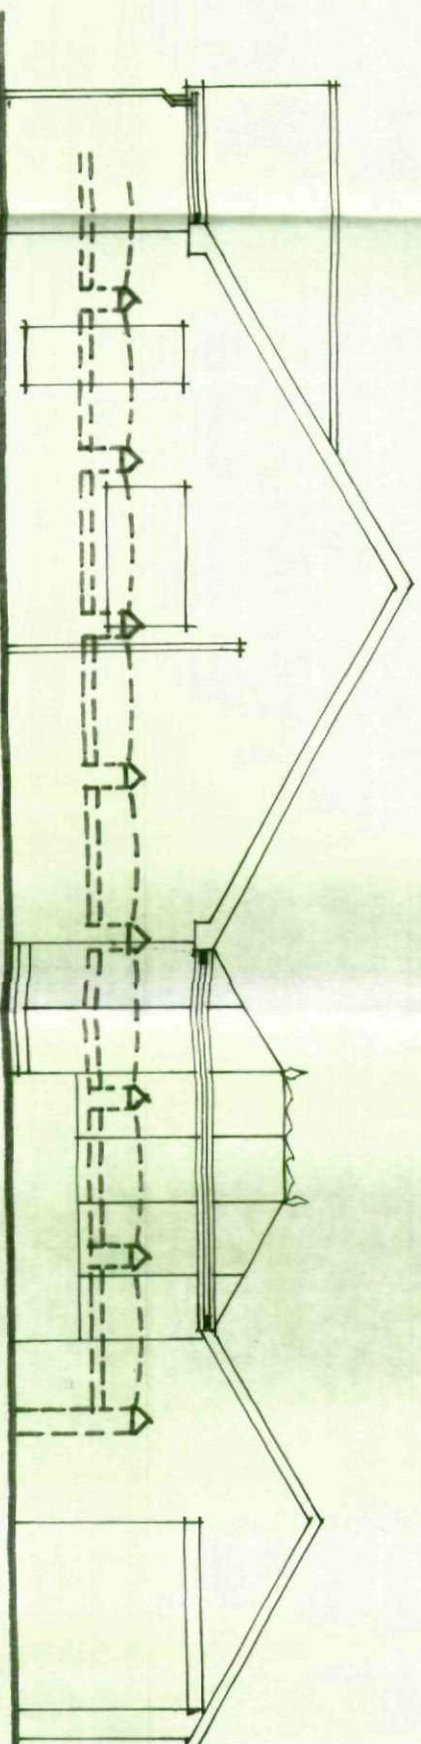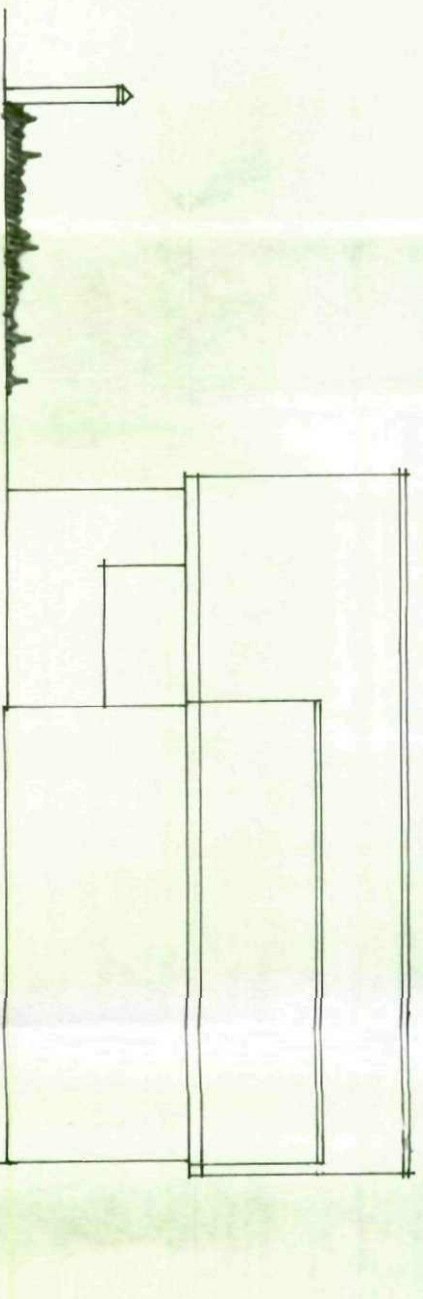

sunray scale 1:100m.


* all fixtures + fittings to clients choice + positioning
 * 100mm ϕ SUP cage terminal 900 above opening lights
 32mm ϕ bath + shower wastes 32mm ϕ wash hand basin
 waste - auto vac traps - wastes to discharge below g/g level
 but above water trap level.

* electric extract :- bathroom 15L/sec.

kitchen 60L/sec. or 30L/sec. hood.


(Sd) shows ceiling mounted smoke detectors - wired back to

fuse bd - battery back up - fixed min. 300mm from wall junctions
 + light fittings.

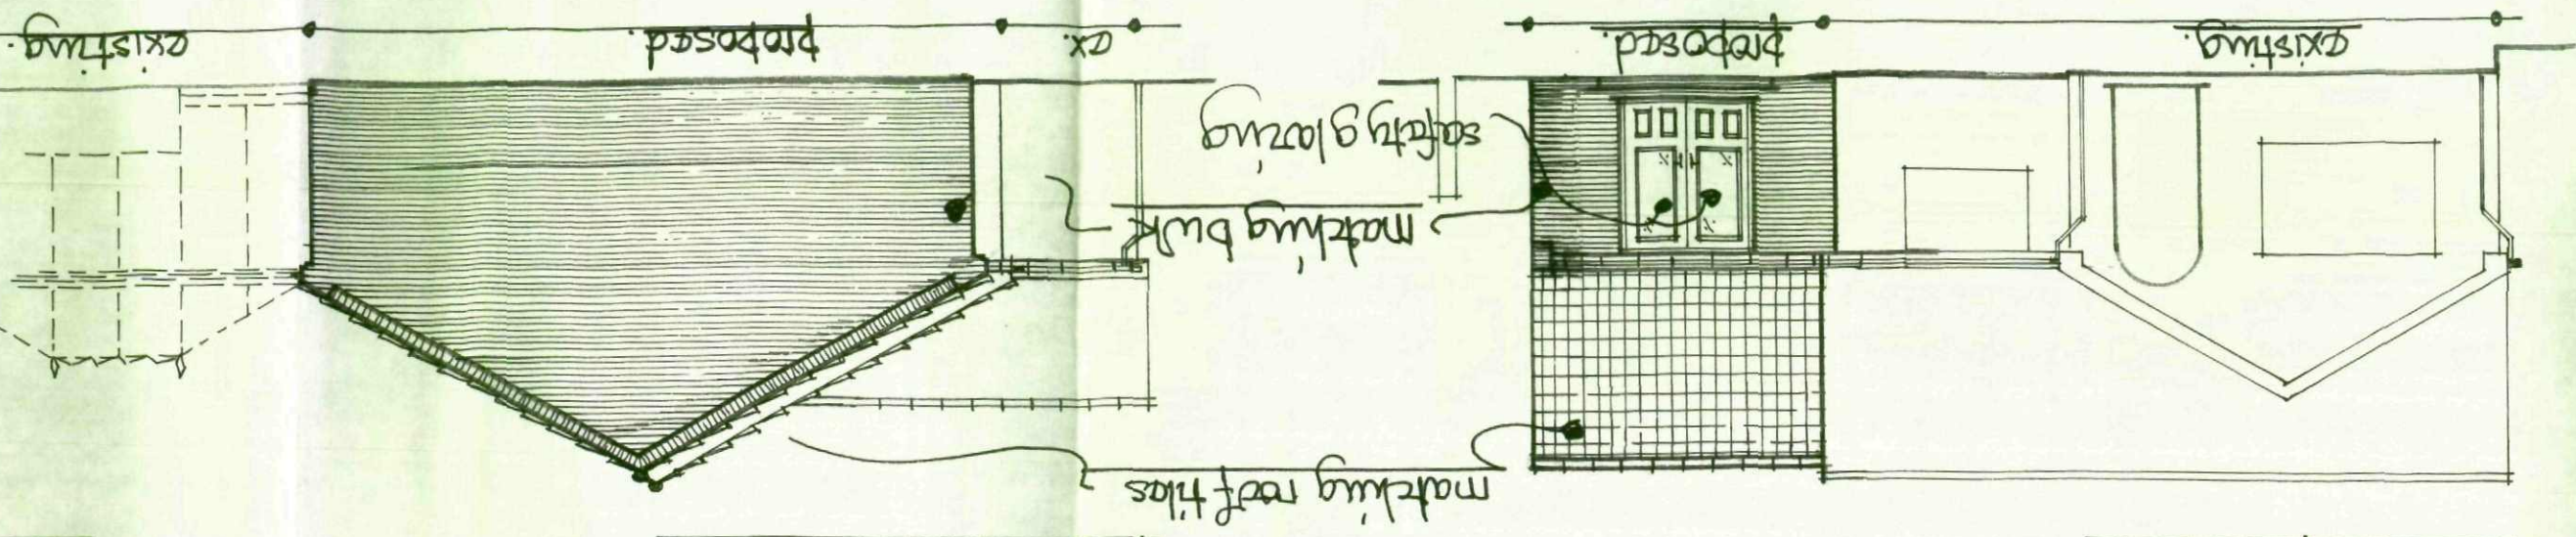

scale 1:100m.

* revised 8th sept 2003 - 400mm set back
 to brickwork from existing front wall
 to BMB TCP requirements from
 Ms Georgina Whitthouse *

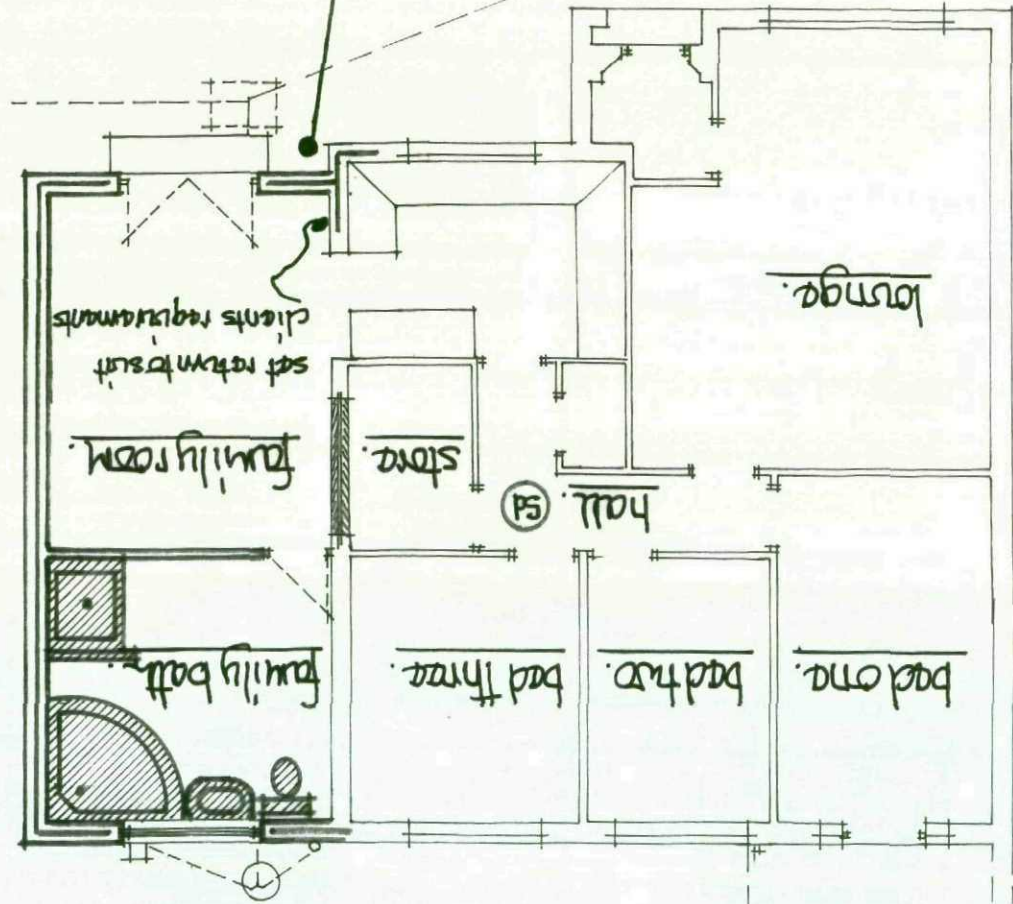

conservatory