
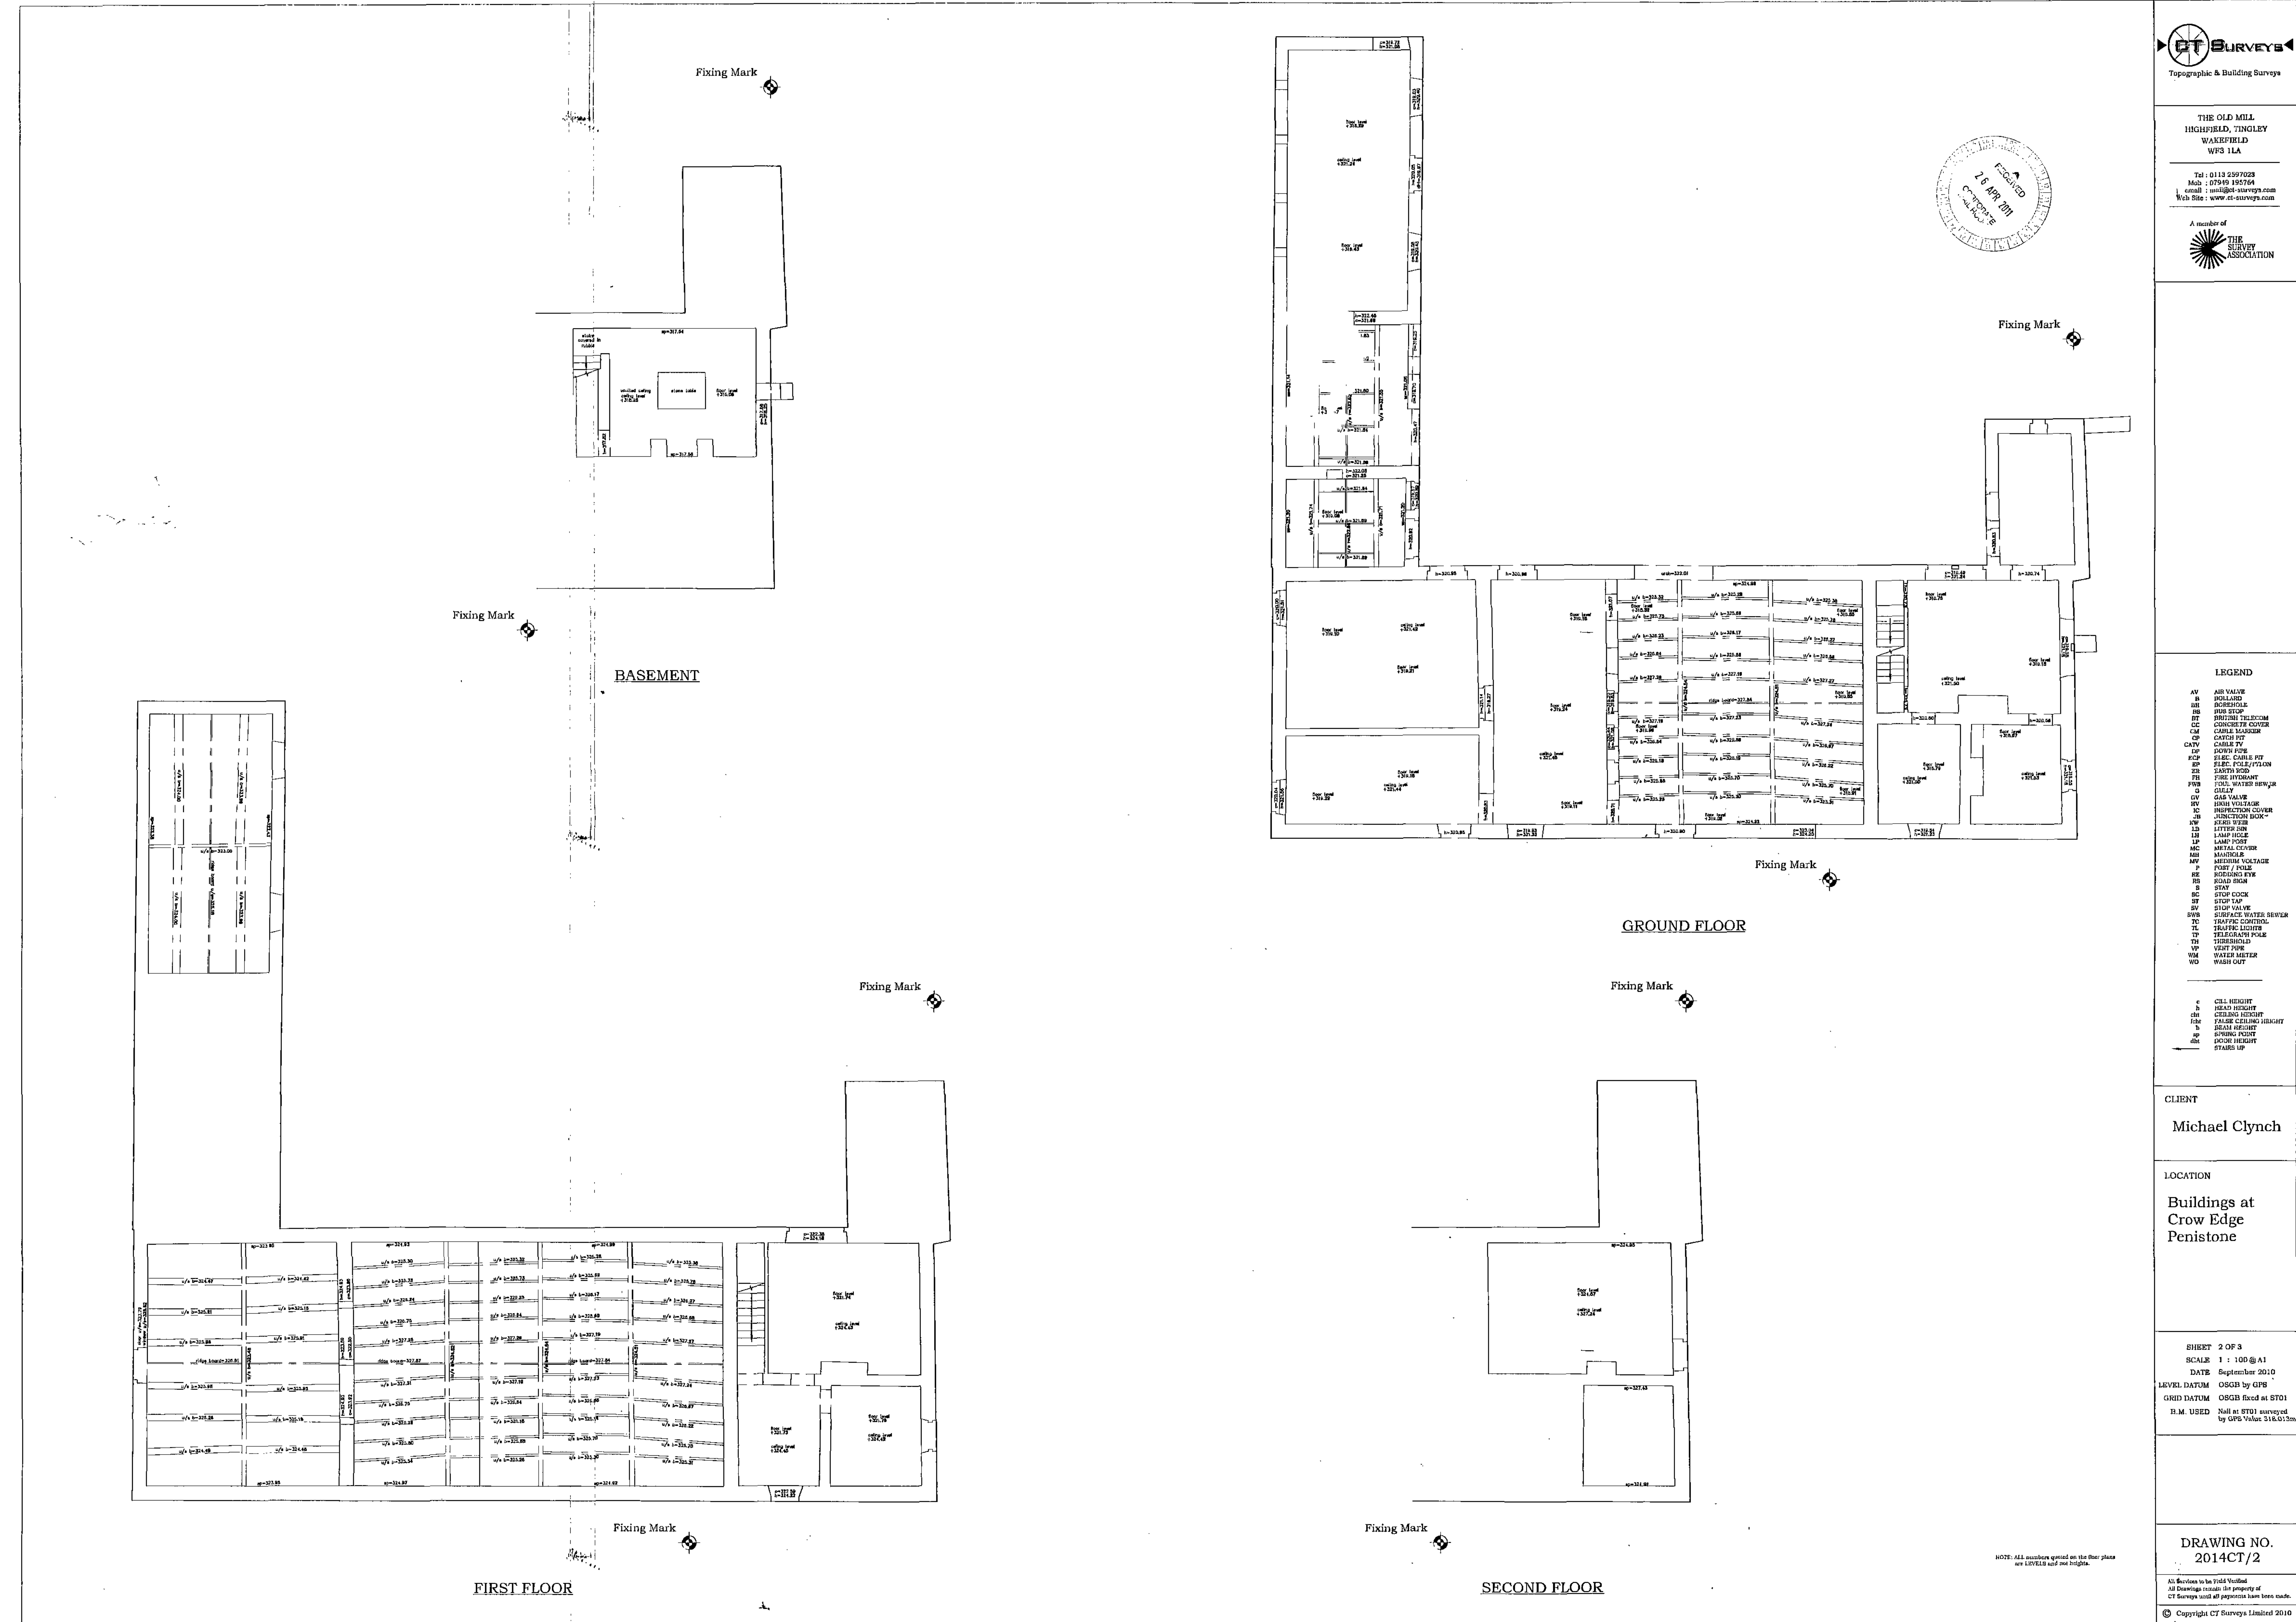


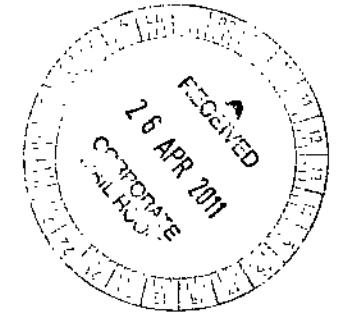

LEGEND

- AV AIR VALVE
- B BOLLARD
- BB BOREHOLE
- BS BUS STOP
- BT BRUSH TELECOM
- CC CONCRETE COVER
- CM CABLE MANAGER
- CP CATCH PIT
- CATV CABLE TV
- UP DRAIN PIPE
- ECP ELEC. CABLE PIT
- EP ELEC. POLE/PLANK
- ER EARTH ROD
- FR FIRE HYDRANT
- PWB TOLL WATER SEWER
- G GULLY
- GV GAS VALVE
- HV HORN VALVE
- IC INSPECTION COVER
- JB JUNCTION BOX
- HW FISH WEIR
- LB LITTER BIN
- LP LAMP POST
- MC MANHOLE
- MM MEDIUM VOLTAGE
- P PILE
- RE ROLLING FIVE
- RS ROAD SIGN
- S STAT
- SC STOP COCK
- ST STOP TAP
- SV STOP VALVE
- SWS SURFACE WATER SEWER
- TD TRAFFIC CONTROL
- TL TRAFFIC LIGHTS
- TP TELEGRAPH POLE
- TH THRESHOLD
- VP VENT PIPE
- WM WATER METER
- WD WASH OUT

- c CELL HEIGHT
- h HEAD HEIGHT
- SH CEILING HEIGHT
- FSM FALSE CEILING HEIGHT
- h BEAM HEIGHT
- SP SPRING POINT
- SH ROOM HEIGHT
- SH STAIRS UP

CLIENT

Michael Clynh

LOCATION

Buildings at
Crow Edge
Penistone

SHEET 2 OF 3

SCALE 1 : 100 @ A1

DATE September 2010

LEVEL DATUM OSGB by GPS


GRID DATUM OSGB fixed at ST01

H.M. USED Nail at ST01 surveyed by GPS Value 516.012m


DRAWING NO.
2014CT/2

All Surveys to be Field Worked
All Drawings remain the property of
CT Surveys until all payments have been made.

Copyright CT Surveys Limited 2010

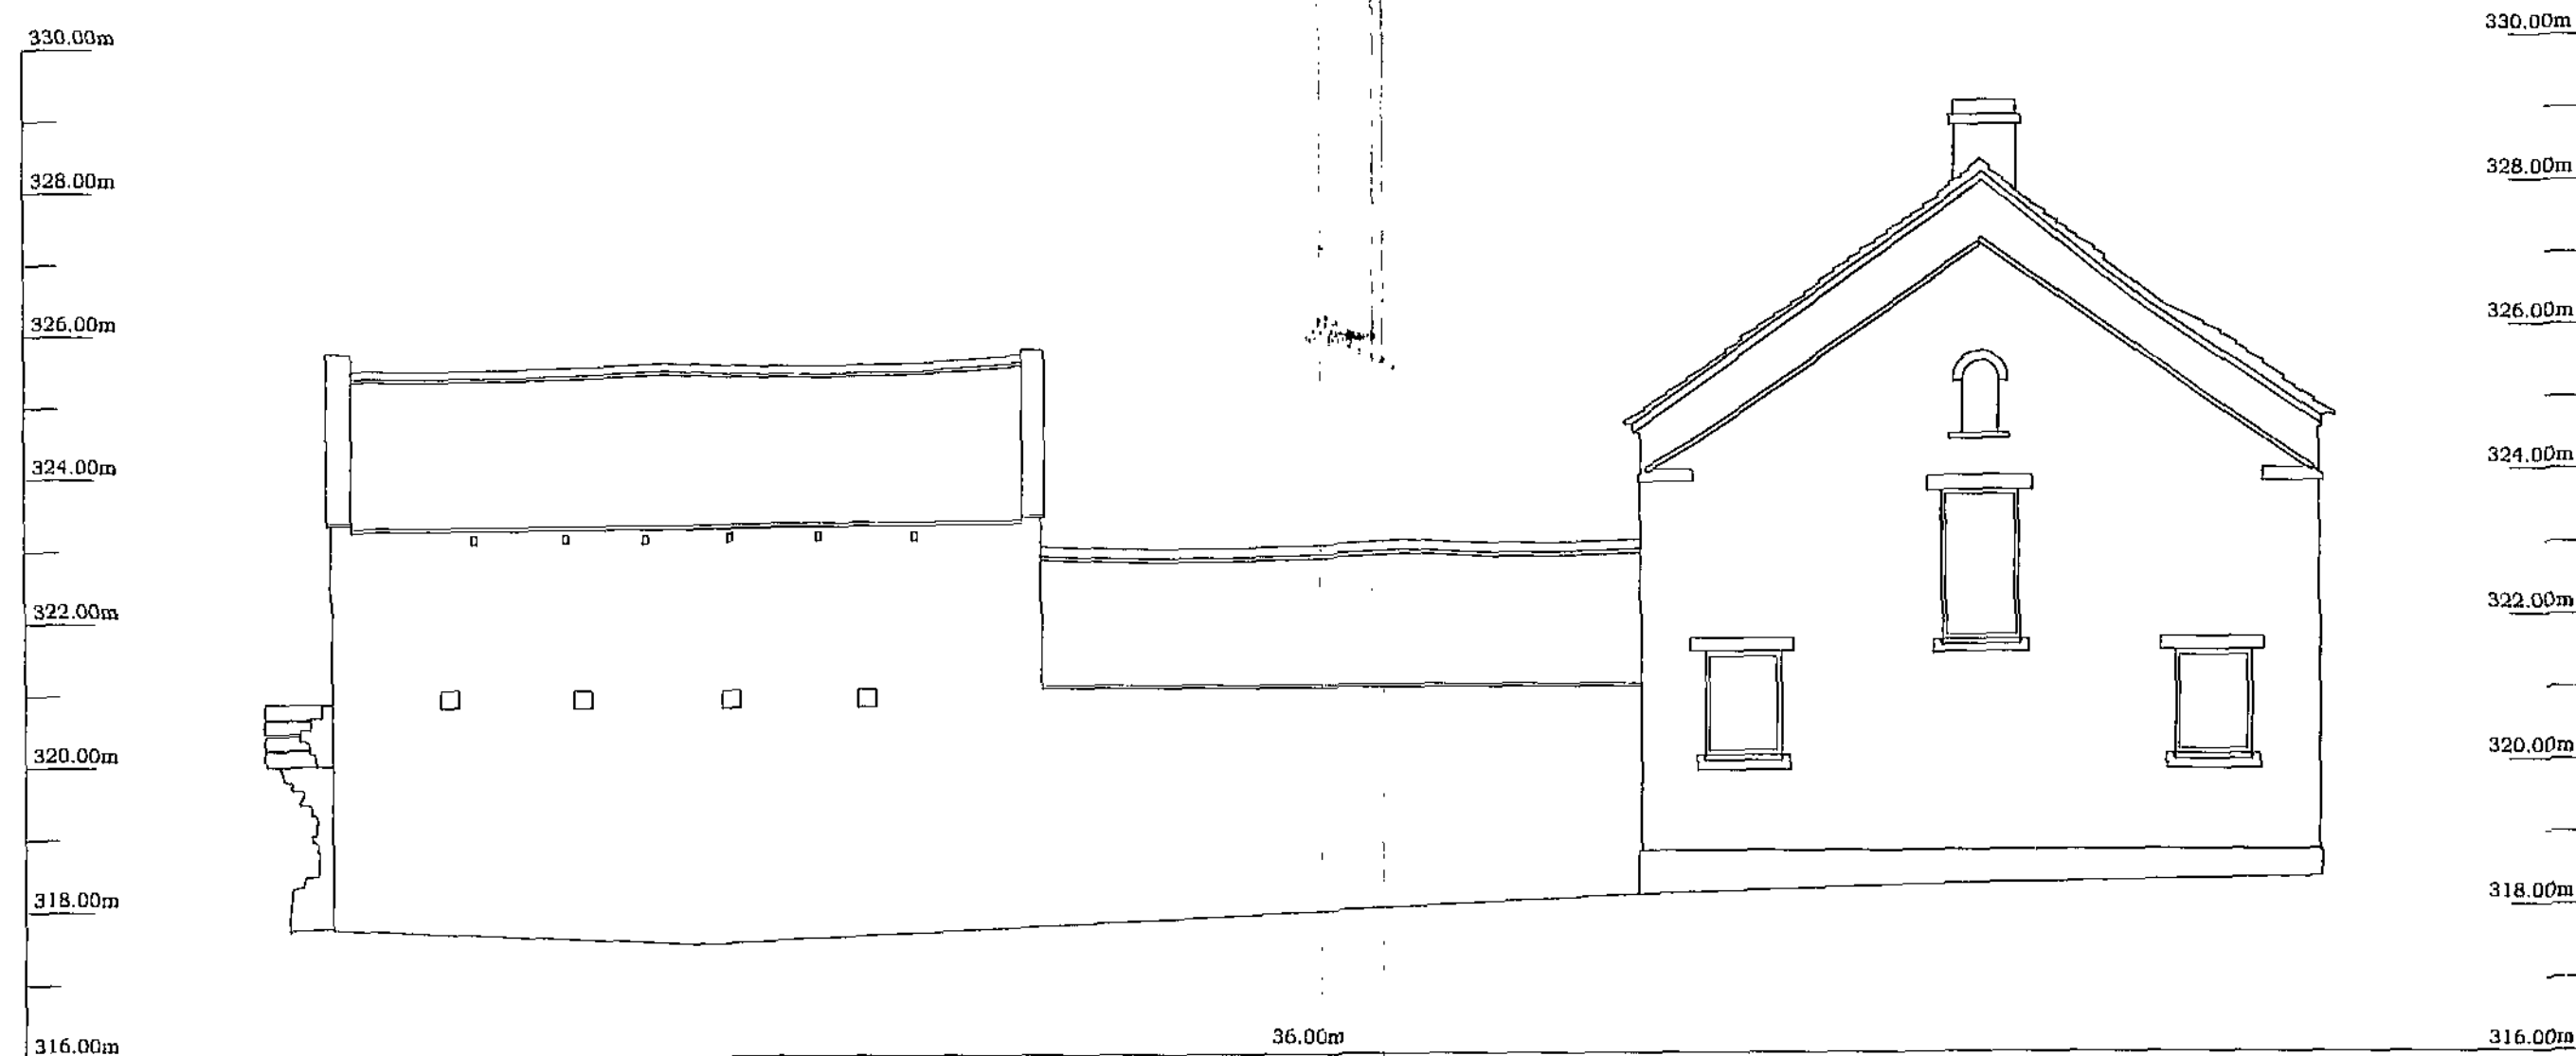


NORTH ELEVATION

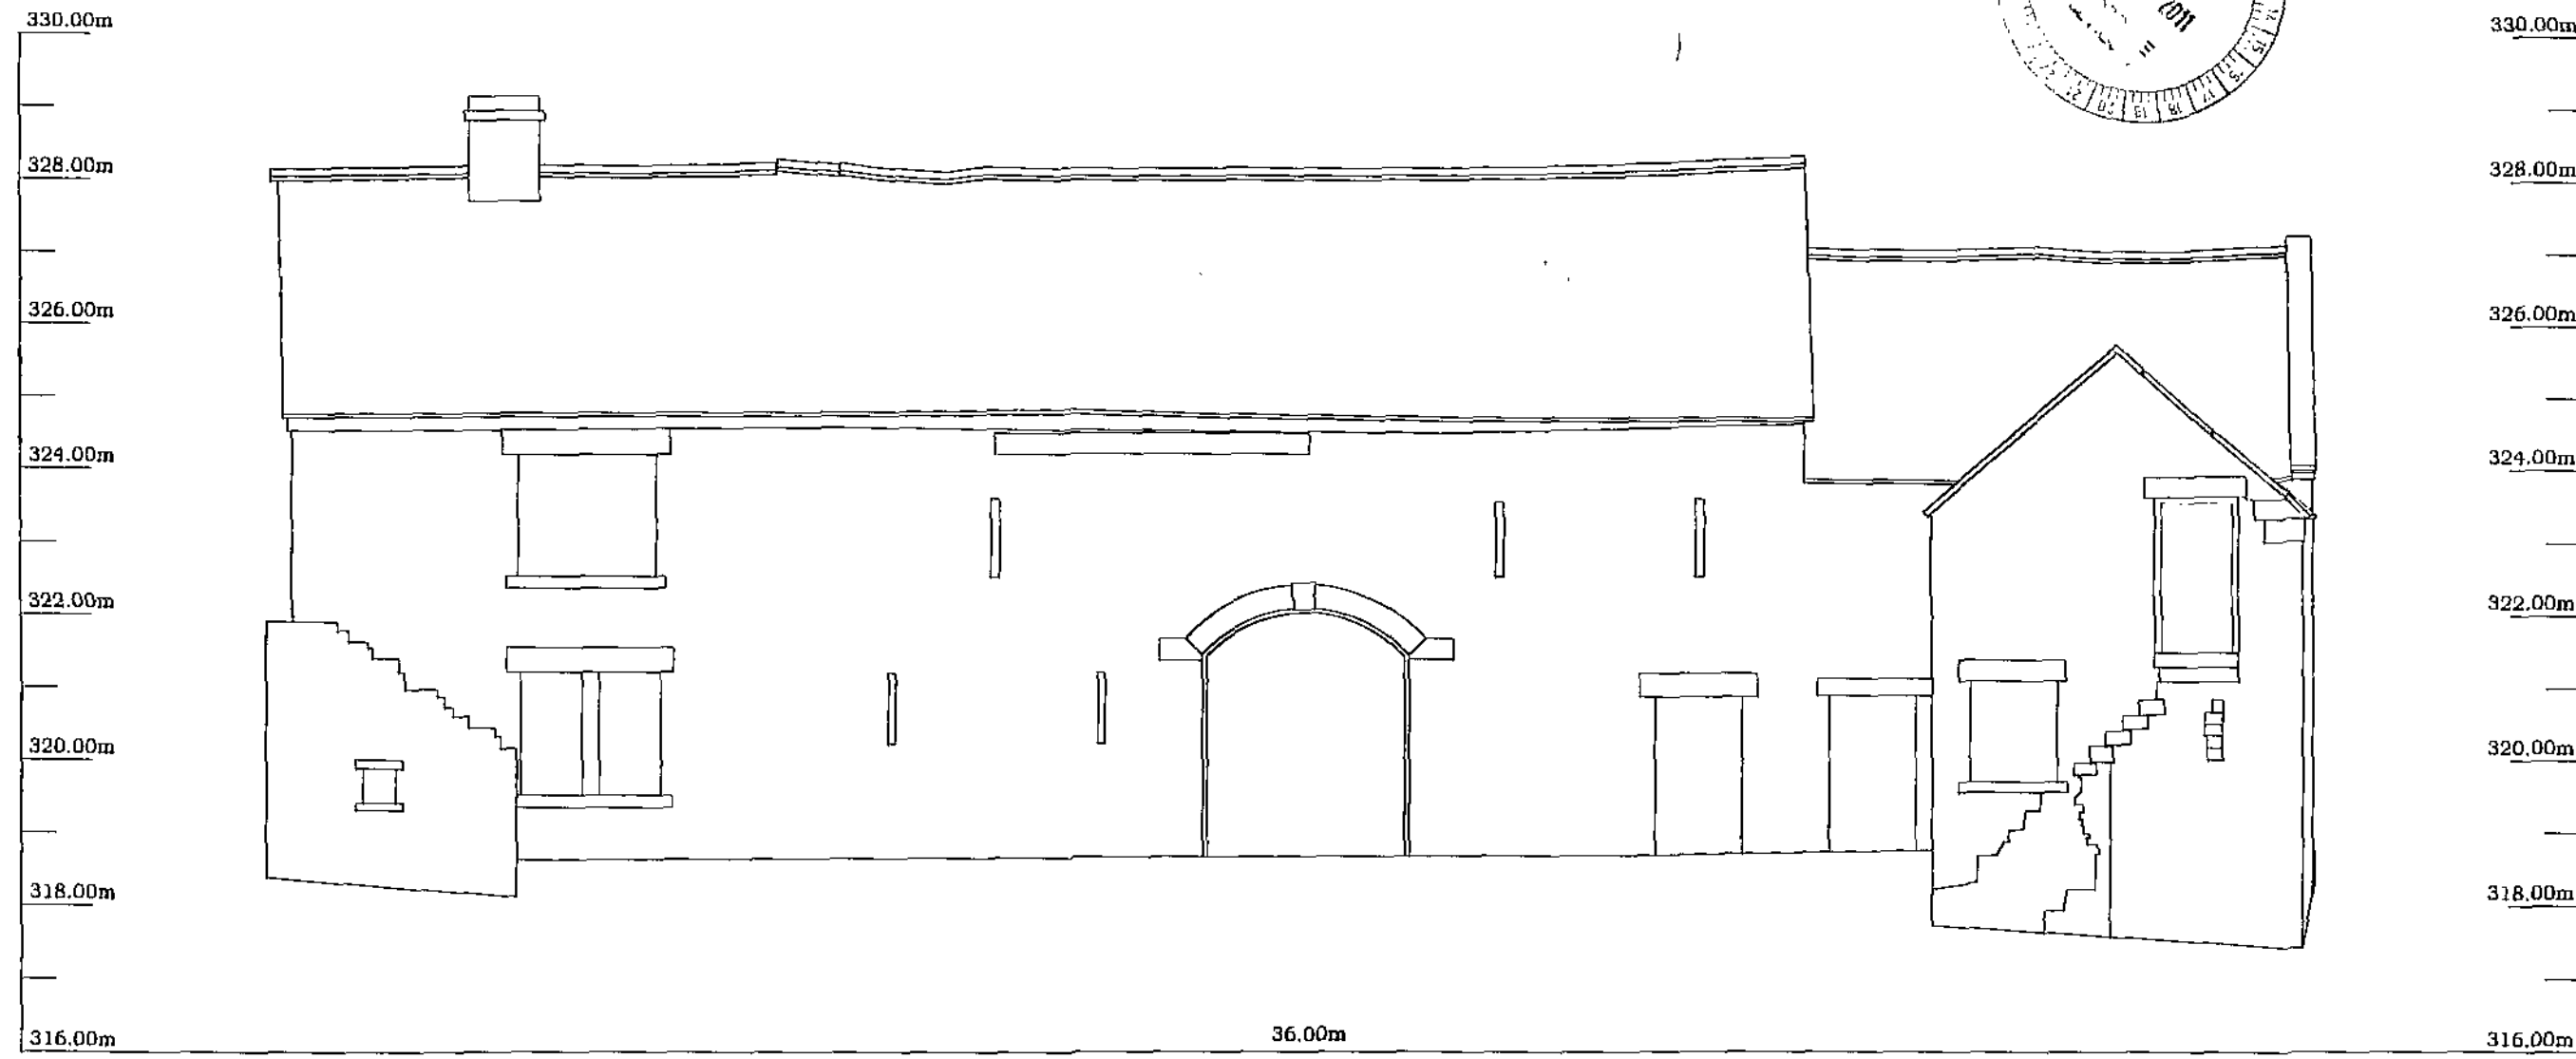


EAST ELEVATION




SOUTH ELEVATION

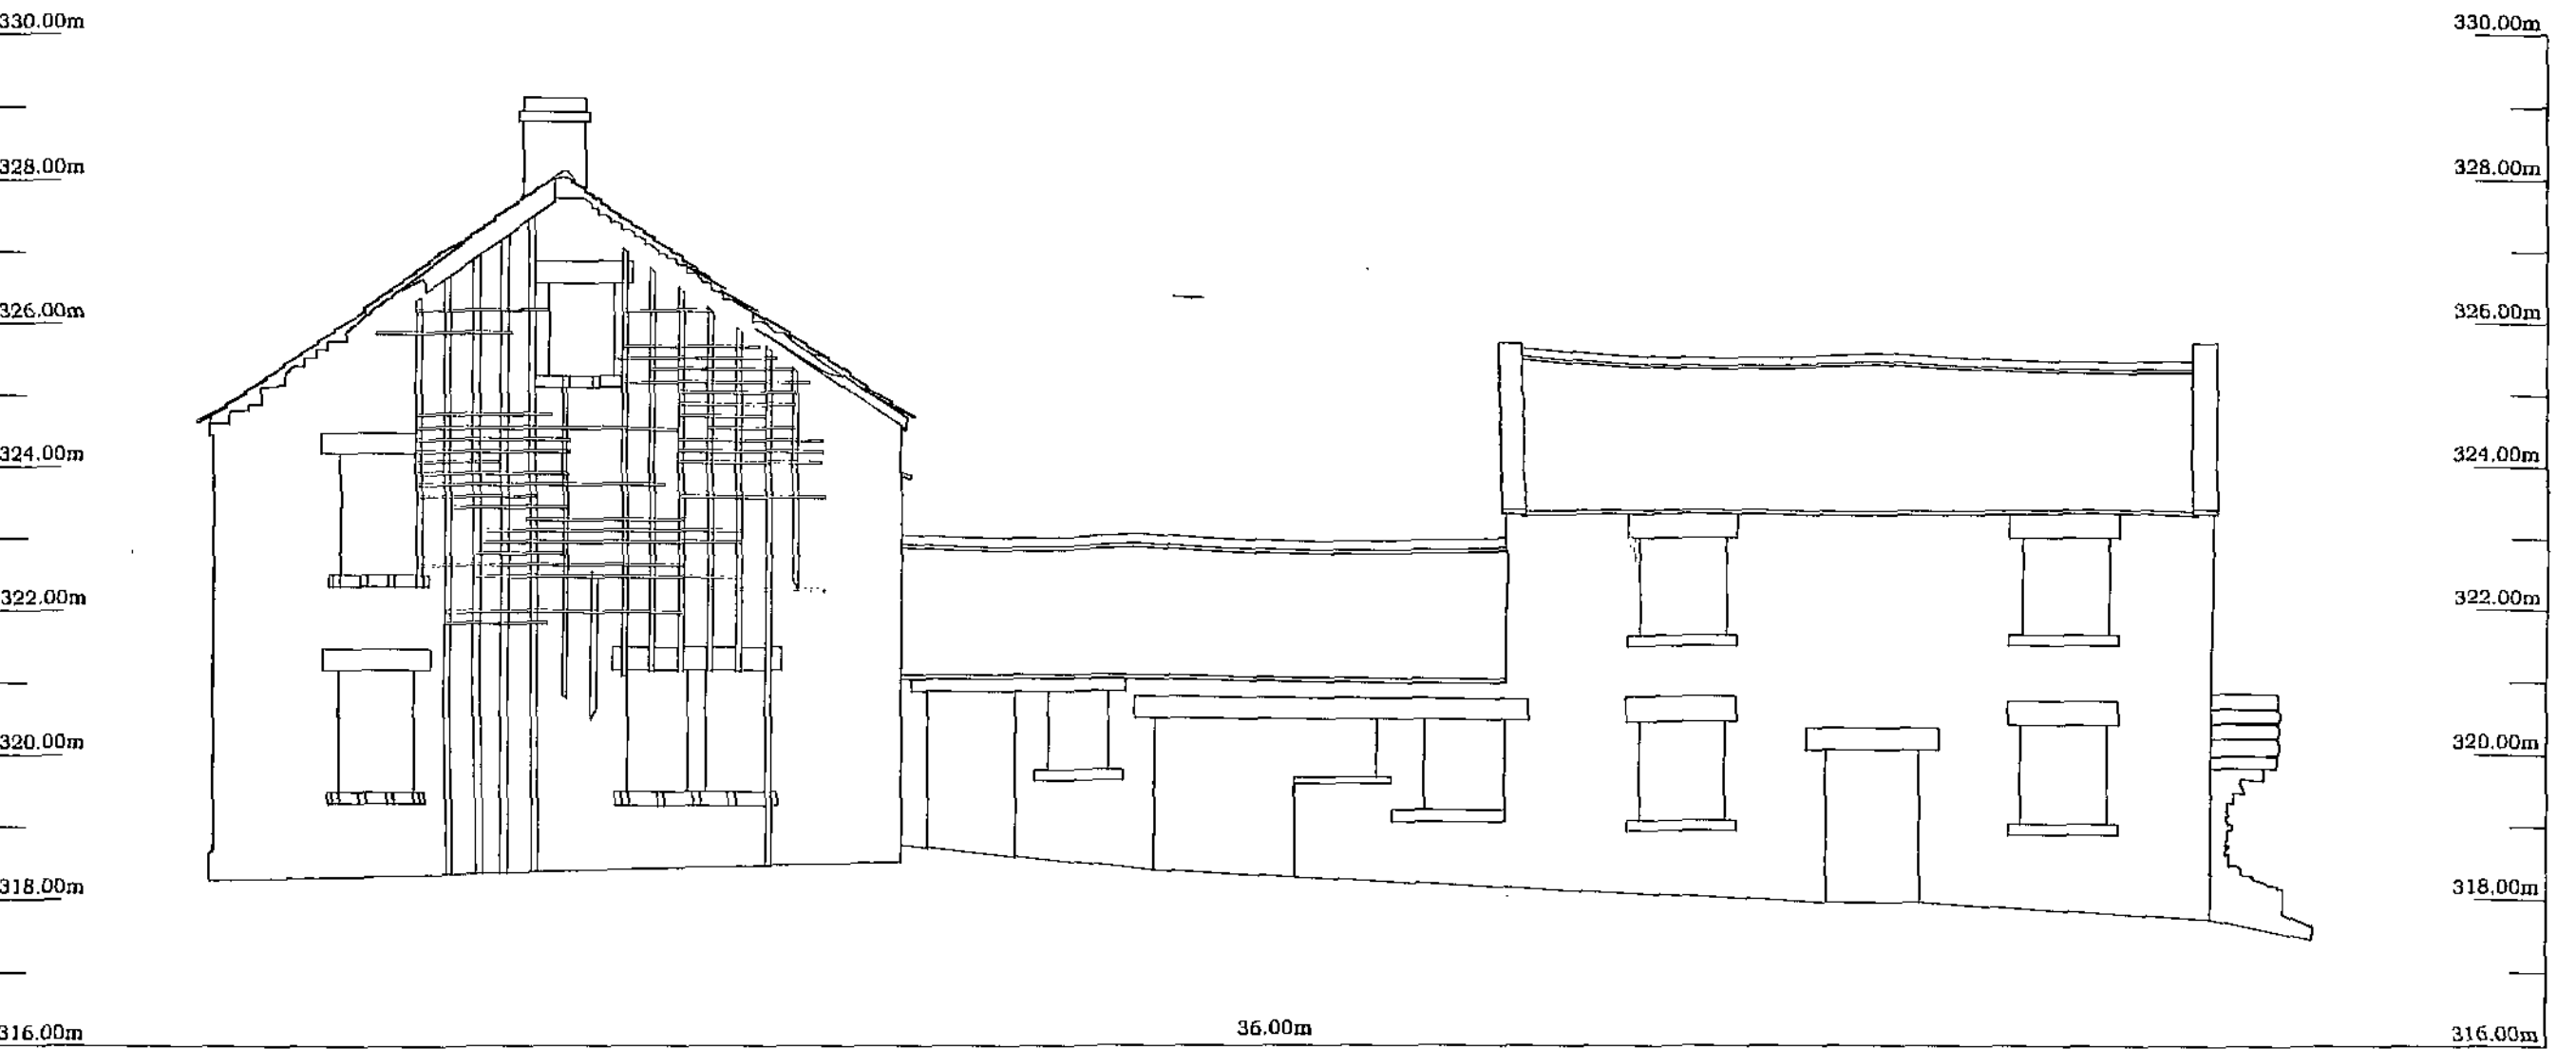

SOUTH ELEVATION

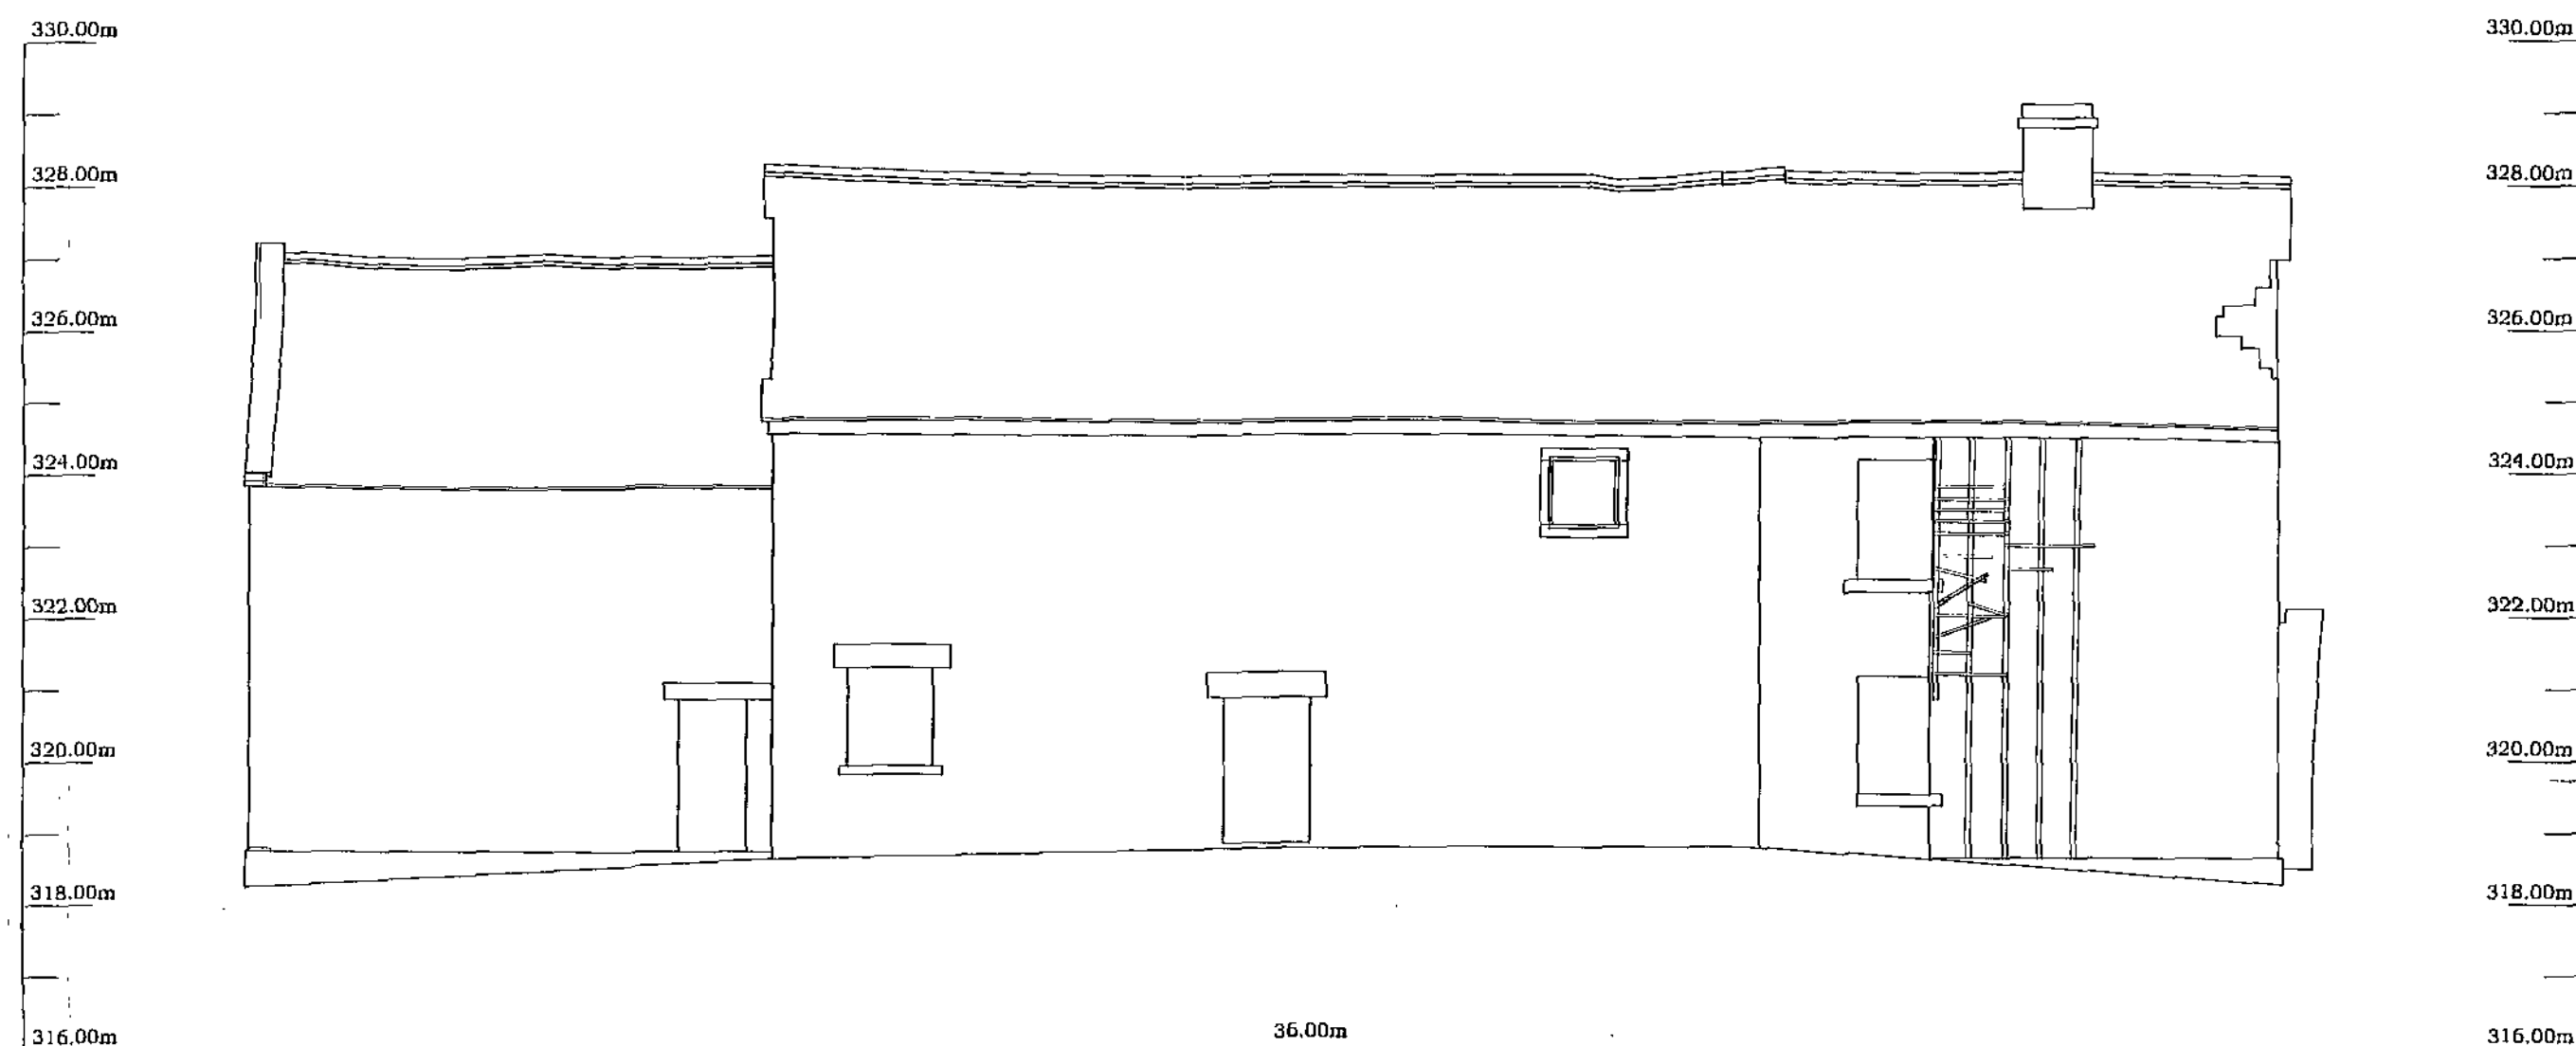

WEST ELEVATION

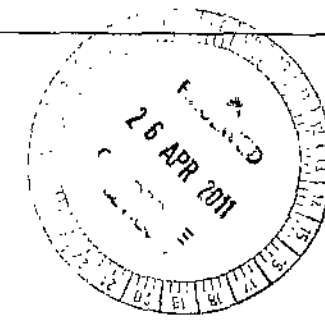

THE OLD MILL
HIGHFIELD, TINGLEY
WAKEFIELD
WF3 1LA

Tel : 0115 2997028
Mob : 07549 195764
email : info@ct-surveys.com
Web Site : www.ct-surveys.com



LEGEND

AV AIR VALVE
B BOLLARD
BN BENCH
BT BUS STOP
BTM BOTTOM TELECOM
CC CONCRETE COVER
CM CABLE MANHOLE
CP CATCH PIT
CCTV CABLE TV
DWP DRAIN PIPE
ECP ELEC. CABLE PIT
EP ELEC. PILE/PTLW
EWH EARTH ROD
FV FIRE HYDRANT
FWS Foul WATER SEWER
G GULL
GV GAS VALVE
HV HIGH VOLTAGE
IC INSPECTION COVER
JN JUNCTION BOX
JW JEND. WER
LJ LITTER JAR
LH LAMP HOLE
LP LAMP POST
MC METAL COVER
MH MANHOLE
MV MEDIUM VOLTAGE
P POST
RE RETAINING EYE
RB ROAD SIGN
S STAY
SC STOP CHOK
ST STOP TAP
SV STOP VALVE
SWB SURFACE WATER SEWER
TC TRAFFIC CONTROL
TL TRAFFIC LIGHTS
TLED TELEGRAPH LAMP
TH THRESHOLD
VP VENT PIPE
WM WATER METER
WD WASH DUT

CLIENT

Michael Clynh

LOCATION

Buildings at
Crow Edge
Penistone

SHEET 3 OF 3

SCALE 1 : 100 @ A1

DATE September 2010

LEVEL DATUM OSGB by DPs

GRID DATUM OSGB sheet at ST01

H.M. USED Null at STD surveyed
by GPS Value 318.03m

DRAWING NO.
2014CT/3

All Drawings to be Field Verified
All Drawings remain the property of
CT Surveys until all payments have been made.
© Copyright CT Surveys Limited 2010