


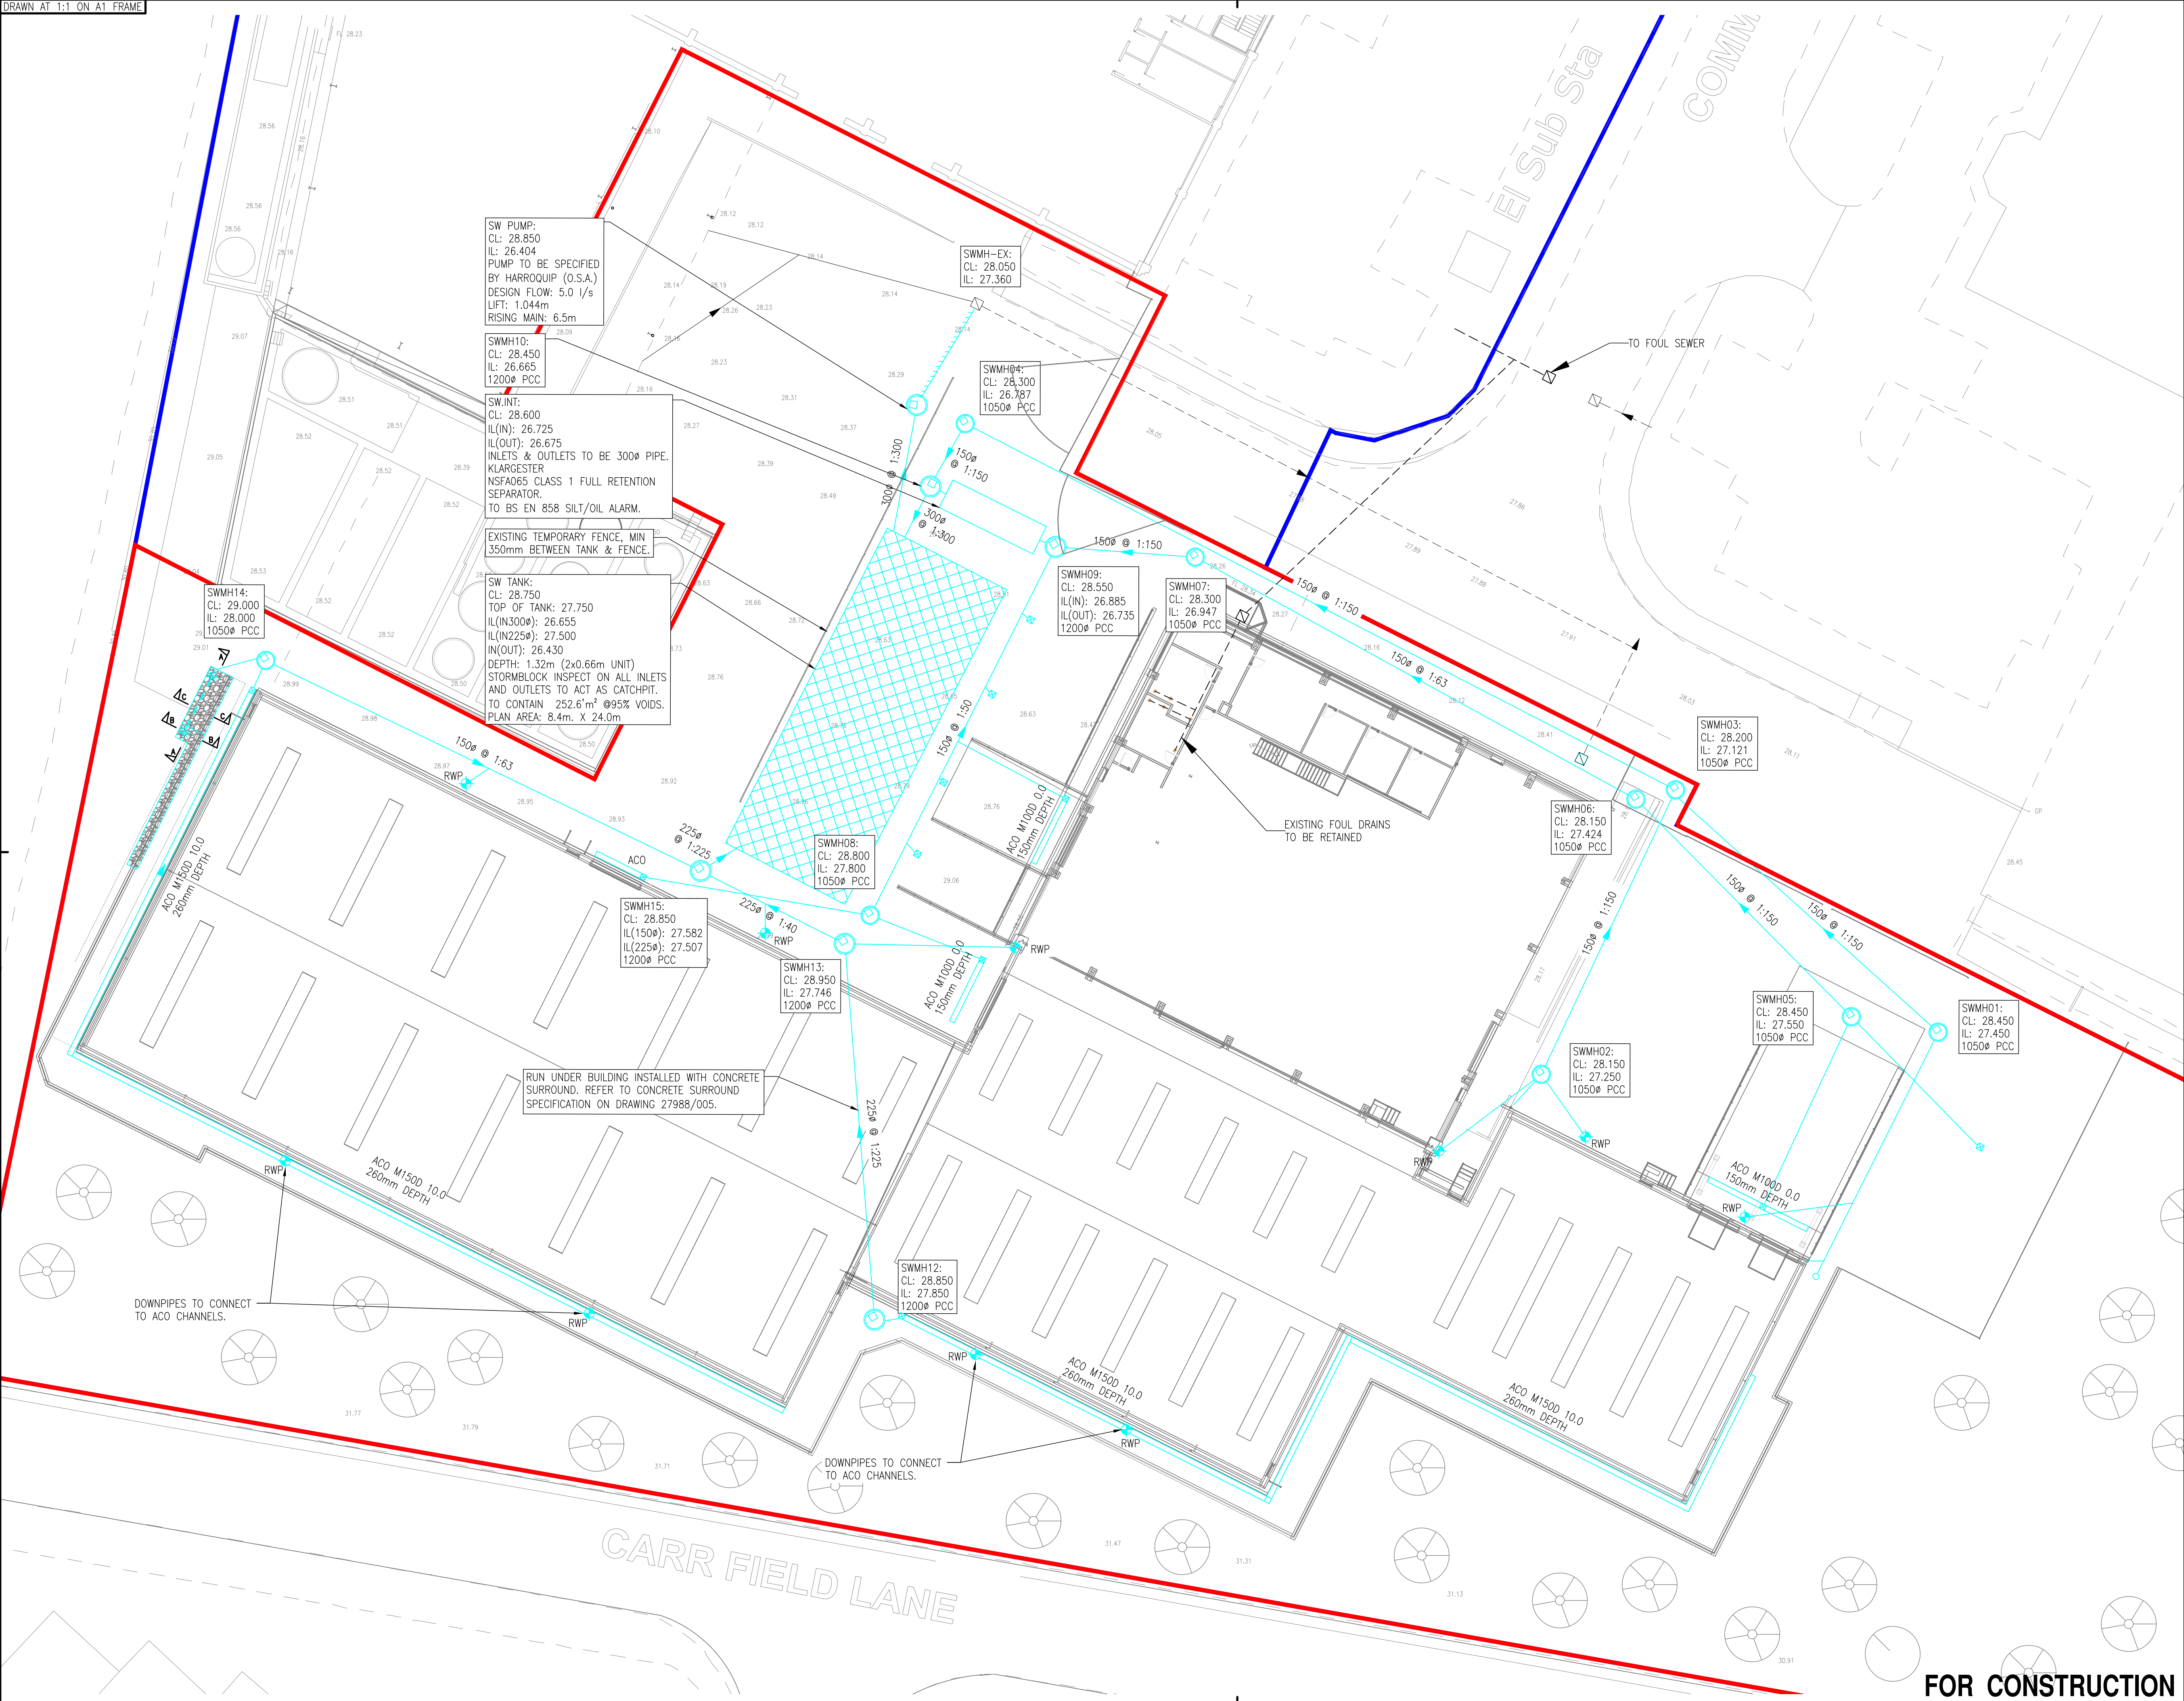

- NOTES:-
1. All dimensions must be checked on site and not scaled from this drawing.
 2. The Contractor shall be responsible for obtaining all dimensions and levels necessary for the proper fabrication of the proposal as indicated.
 3. All levels shown on this drawing are relative to Agreed Datum
 4. This drawing is to be read in conjunction with 27988/100 Series Drawings.
 5. All existing invert levels are to be confirmed by contractor prior to construction. Connection subject to approval.

- DENOTES EXTENTS OF SITE OWNERSHIP
- DENOTES EXTENTS OF SITE
- DENOTES EXISTING SURFACE WATER SEWER
- DENOTES ASSUMED EXISTING SURFACE WATER SEWER
- DENOTES EXISTING FOUL WATER SEWER
- DENOTES SURFACE WATER SEWER
- DENOTES SURFACE WATER CONCRETE CHAMBER
- DENOTES SURFACE WATER PPIC CHAMBER
- DENOTES RODDING EYES
- DENOTES RAIN WATER PIPE
- DENOTES ATTENUATION TANK
- DENOTES SURFACE WATER PUMPING RUN

Rev	Date	Description	DR	CH
G	20/1/20	FOUL DRAINAGE ADDED	NSA	NSA
F	30/10/19	ISSUED FOR CONSTRUCTION	DJC	NSA
E	28/08/19	ISSUED FOR TENDER	DJC	NSA
D	15/08/19	ISSUED FOR TENDER	DJC	NSA
C	02/08/19	ISSUED FOR TENDER	DJC	NSA
B	21/01/19	ISSUED FOR APPROVAL	DJC	NSA
A	11/01/19	ISSUED FOR APPROVAL	DJC	NSA

© copyright

UVDB
Registered

Link-up
Qualified via Audit

GGP CONSULT

CONSULTING ENGINEERS
PROJECT MANAGEMENT

2 Hallam Road
Priory Park East
HULL HU4 7DY
United Kingdom

Telephone (+44) 01482 627963
Fax (+44) 01482 641736
Email info@ggpconsult.co.uk

Client
GRANVILLE OILS & CHEMICALS LTD.

Job Title
GRANVILLE OILS

Drawing Title
PROPOSED SURFACE WATER DRAINAGE LAYOUT

Status	CONSTRUCTION		
Scale	1:200 @ A1	Date	11/01/2019
Drawn By	Daniel Cook	Checked	MN
		Approved	NA
Orig. No.	27988/103		Rev
			G

FOR CONSTRUCTION