




Scaled @ 1:500
0 10m 20m 50m

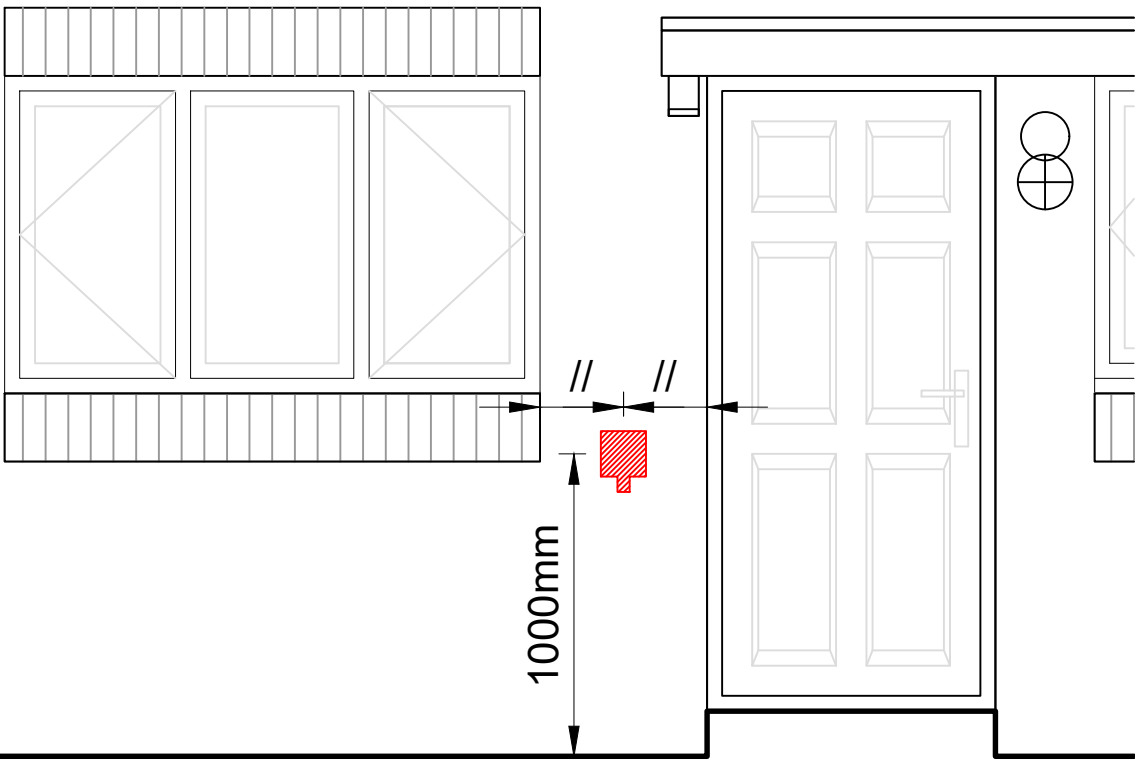

Typical Front Elevation
(when parking is directly in front of the dwelling)
Scale 1:25

E = Electric Vehicle Charging
Point Location (EVCP) (Mode 3)

Notes

- 1) Mode 3 charging point to be Installed within garages or adjacent driveways & parking spaces.
- 2) Positioning of charging point to be a minimum of 1000mm from Ground Level
- 3) FOG's and plots with integral garages to receive charger within garage only.

D	EVCP Changed to be mode 3 units	OF	07/02/23
B	As previously agreed with Chris Shields (Technical Officer (Pollution Control), Regulatory Services) at BMBC, the EVCP has been updated to a 32amp socket. Therefore allowing an occupant to upgrade the to a charging pod at a later date if needed.	JP	06/01/2021
A	External sockets added to the following plots, 15, 16,17,21,33,45,56,61,62,63,64,68,69,72,73,74,75, 88,89 & 91 also lockable sockets added for parking spaces that are remote & spec updated to a standard 13amp IP rated socket	JP	10/11/2020

Rev	Details	Date	By	Chk
	DATE	13/07/2020	DRAWN	JP
	SCALE	NTS	CHK	DC

Electric Vehicle Charging Points

Carlton Road
Carlton, Barnsley

Dwg No 2028-Y2-04-02

Rev
D

Keepmoat, The Waterfront, Lakeside Boulevard,
Doncaster, DN4 5PL.
Tel: 01302 346620 www.keepmoat.com

