

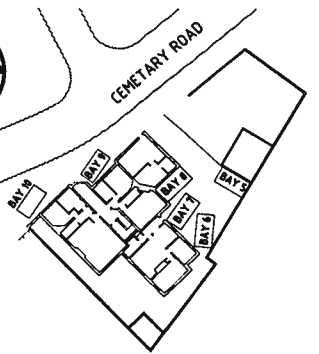
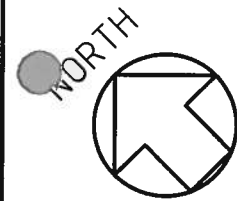


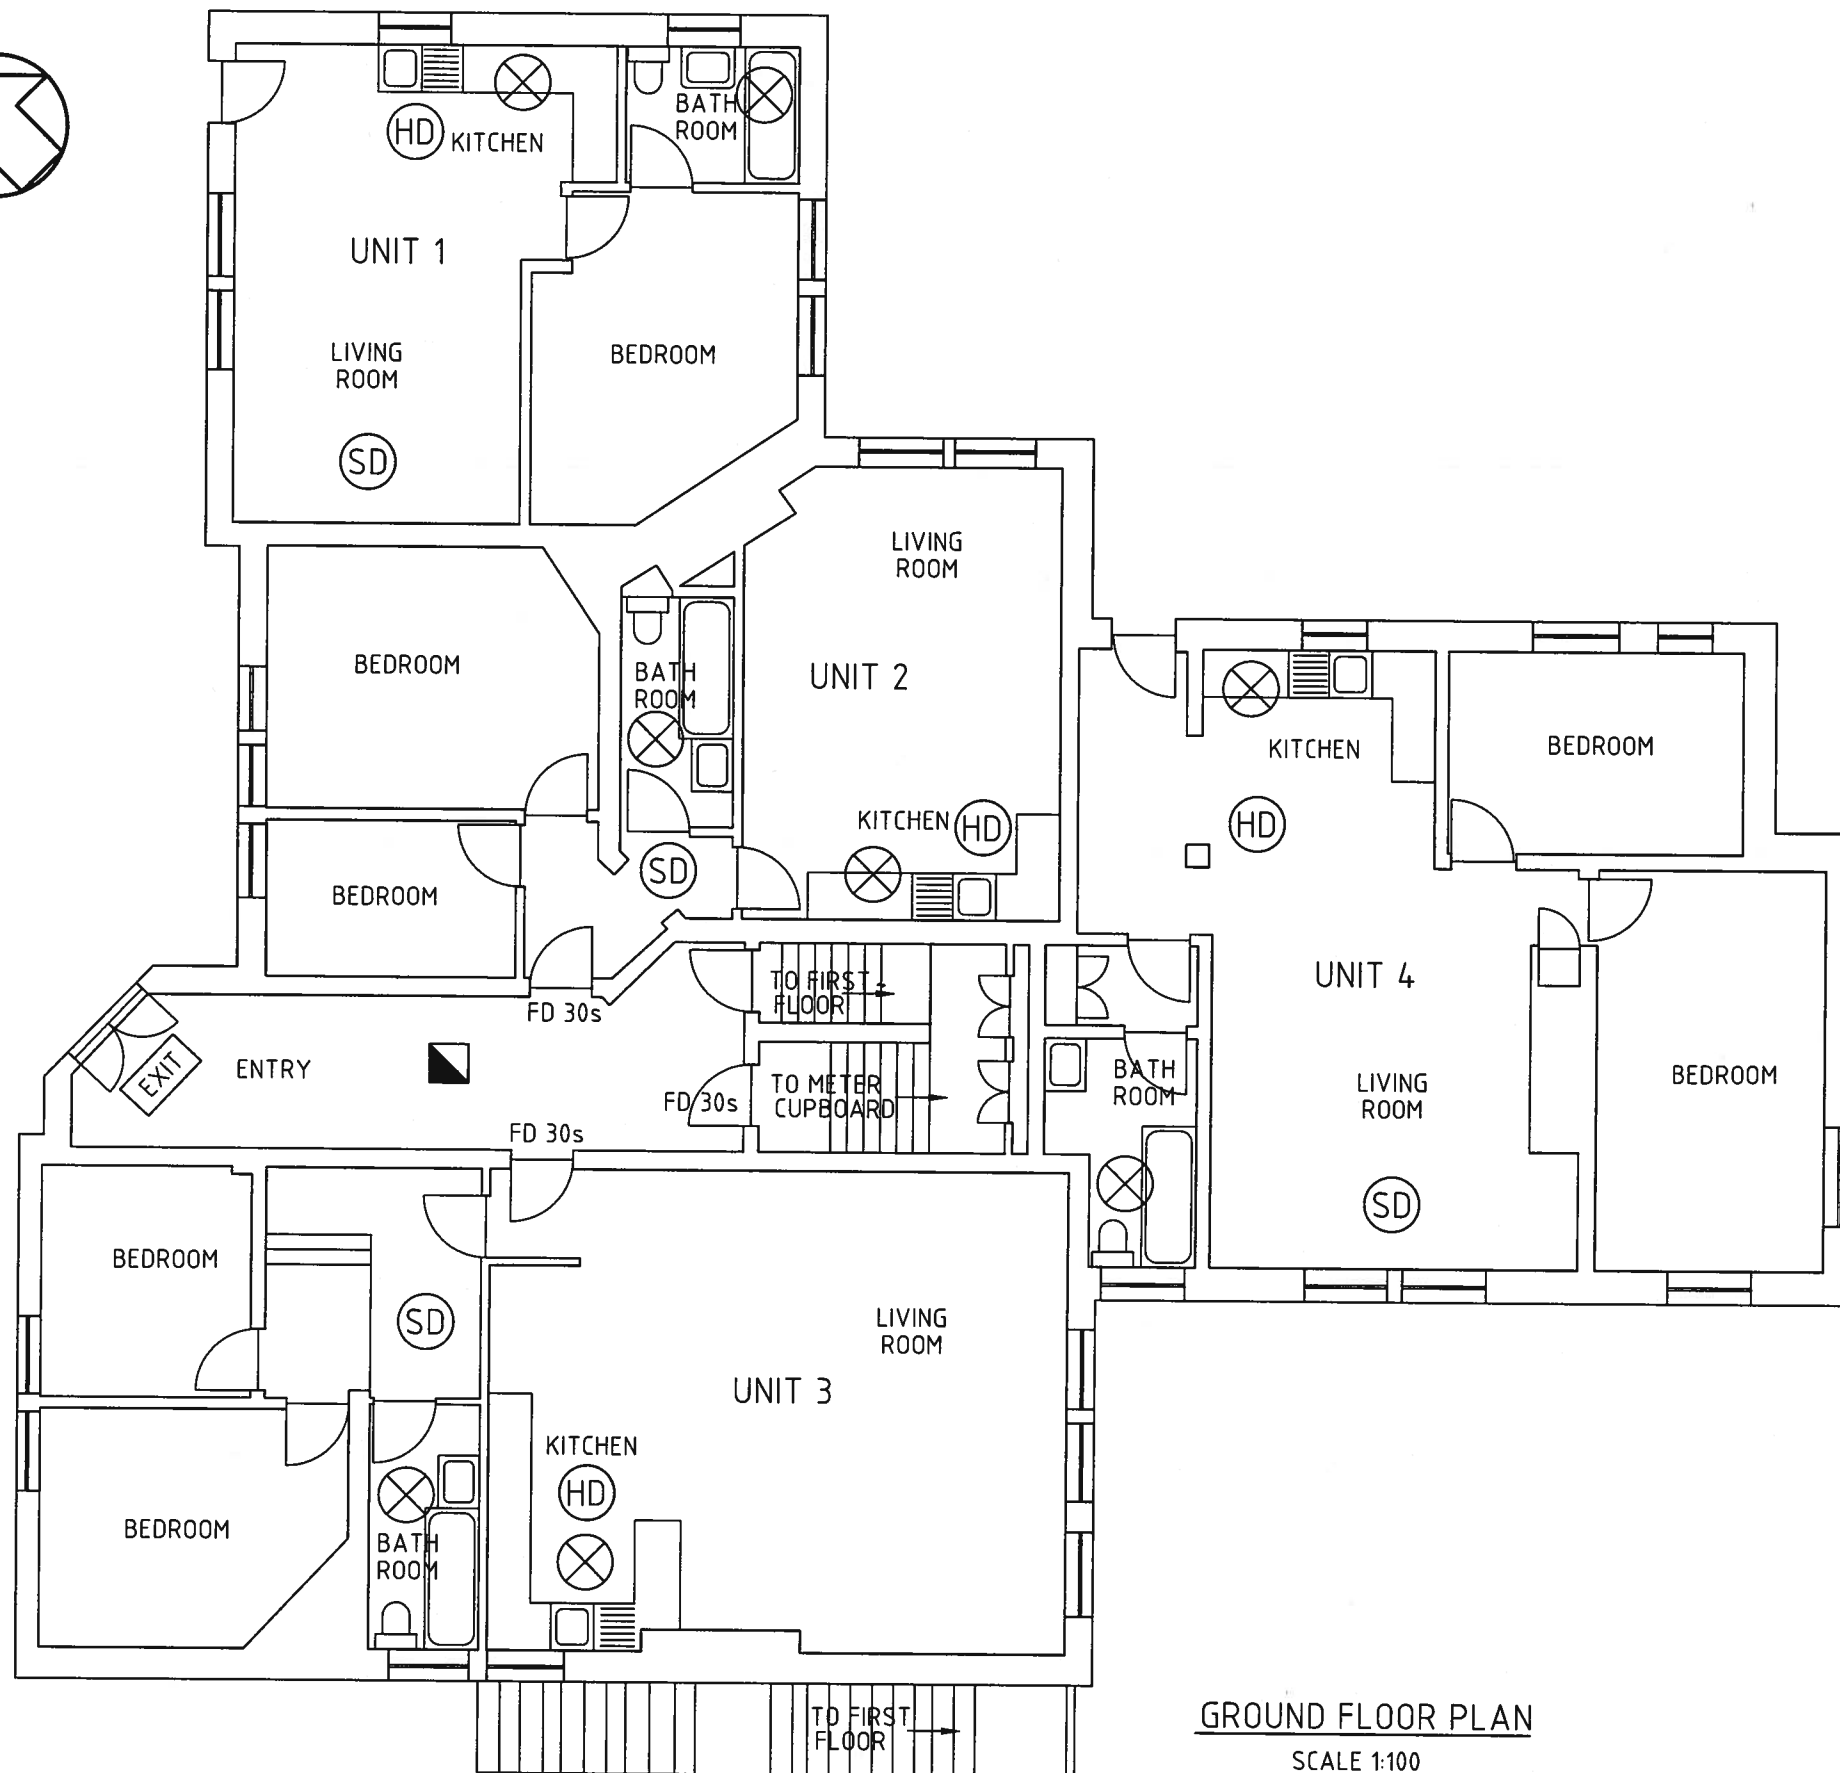

SITE PLAN
SCALE 1:1250

LEGEND

- (SD) SMOKE DETECTOR
- FD 30s 1/2 HR SELF CLOSING FIRE DOOR WITH SMOKE SEAL
- EXIT ILLUMINATED EMERGENCY EXIT SIGN
- EMERGENCY LIGHTING
- MECHANICAL EXTRACTOR FAN
- (HD) HEAT DETECTOR

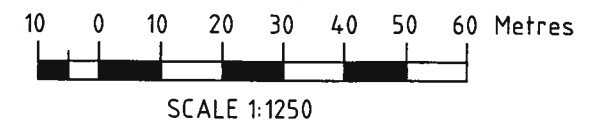

GROUND FLOOR PLAN
SCALE 1:100



Piping Logic
Level 4, Gladson Building
731 Hay Street
Perth 6000
Western Australia
ph: +61 (08) 6424 9888
fax: +61 (08) 9322 4040

COPYRIGHT SUBSISTES IN THIS DRAWING AND SUCH COPYRIGHT IS THE PROPERTY OF PIPING LOGIC. THIS DRAWING ALSO CONTAINS CONFIDENTIAL INFORMATION WHICH IS THE PROPERTY OF PIPING LOGIC. ANY REPRODUCTION OF THIS DRAWING OR ANY PART THEREOF WITHOUT THE WRITTEN CONSENT OF PIPING LOGIC IS NOT PERMITTED AND WILL BE AN INFRINGEMENT OF PIPING LOGIC COPYRIGHT. ANY COMPLIANCE OF THIS DRAWING WITH THE CODE OF PRACTICE OR ANY PART OF THE INFORMATION CONTAINED IN THIS DRAWING WITHOUT THE WRITTEN CONSENT OF PIPING LOGIC IS NOT PERMITTED AND WILL BE A BREACH OF CONTRACT.


CONTRACTOR

ASSET MANAGER:

TITLE: FIDDLERS PTY LTD
FIDDLERS INN - HEMINGFIELD
GROUND FLOOR SAFETY EQUIPMENT LAYOUT

DRN.	SWH	POST CODE:	REV.
ENG.		S73 0QD	
CHK.			
APPD.			
DATE	2 OCT 2011	PL-FI-005	001 B

REV	DATE	DESCRIPTION	BY	CHKD	APPR
B	4-11-2011	ISSUED FOR APPROVAL	SWH		
A	2-10-2011	ISSUED FOR REVIEW	SWH		

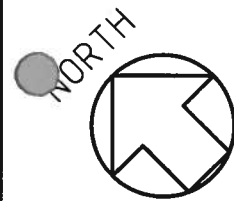

CEMETARY ROAD

BAY 10

BAY 9

BAY 8

BAY 7

BAY 6

BAY 5

RECYCLE
BINS

DOMESTIC
BINS


PARKING BAY LOCATION PLAN

SCALE 1:200



SITE PLAN

 SCALE 1:1250



SCALE 1:1250



SCALE 1:200



Piping Logic
Level 4, Gledden Building
731 Hay Street
Perth 6000
Western Australia
ph: +61 (08) 6424 9888
fax: +61 (08) 9322 4040

COPYRIGHT SUBSISTS IN THIS DRAWING AND SUCH COPYRIGHT IS THE PROPERTY OF PIPING LOGIC.
THIS DRAWING ALSO CONTAINS CONFIDENTIAL INFORMATION WHICH IS THE PROPERTY OF PIPING LOGIC.
ANY REPRODUCTION OF THIS DRAWING OR ANY PART THEREOF WITHOUT THE WRITTEN CONSENT
OF PIPING LOGIC IS NOT PERMITTED AND WILL BE AN INFRINGEMENT OF PIPING LOGIC COPYRIGHT.
ANY COMMUNICATION OF AND/OR DEALING WITH THE OR ANY PART OF THE INFORMATION CONTAINED
IN THIS DRAWING WITHOUT THE WRITTEN CONSENT OF PIPING LOGIC IS NOT PERMITTED AND WILL BE
A BREACH OF CONFIDENCE.

CONTRACTOR

ASSET MANAGER:

TITLE:

FIDDLERS PTY LTD
FIDDLERS INN - HEMINGFIELD
PARKING BAY LAYOUT

DRN.	SWH
ENG.	
CHK.	
APPD.	
DATE	2 OCT 2011

POST CODE:

S73 0QD

DWG No:

PL-FI-004



SHT No:

001

REV.

B


REV	DATE	DESCRIPTION	BY	CHKD	APPR
B	4-11-2011	ISSUED FOR APPROVAL	SWH		
A	2-10-2011	ISSUED FOR REVIEW	SWH		

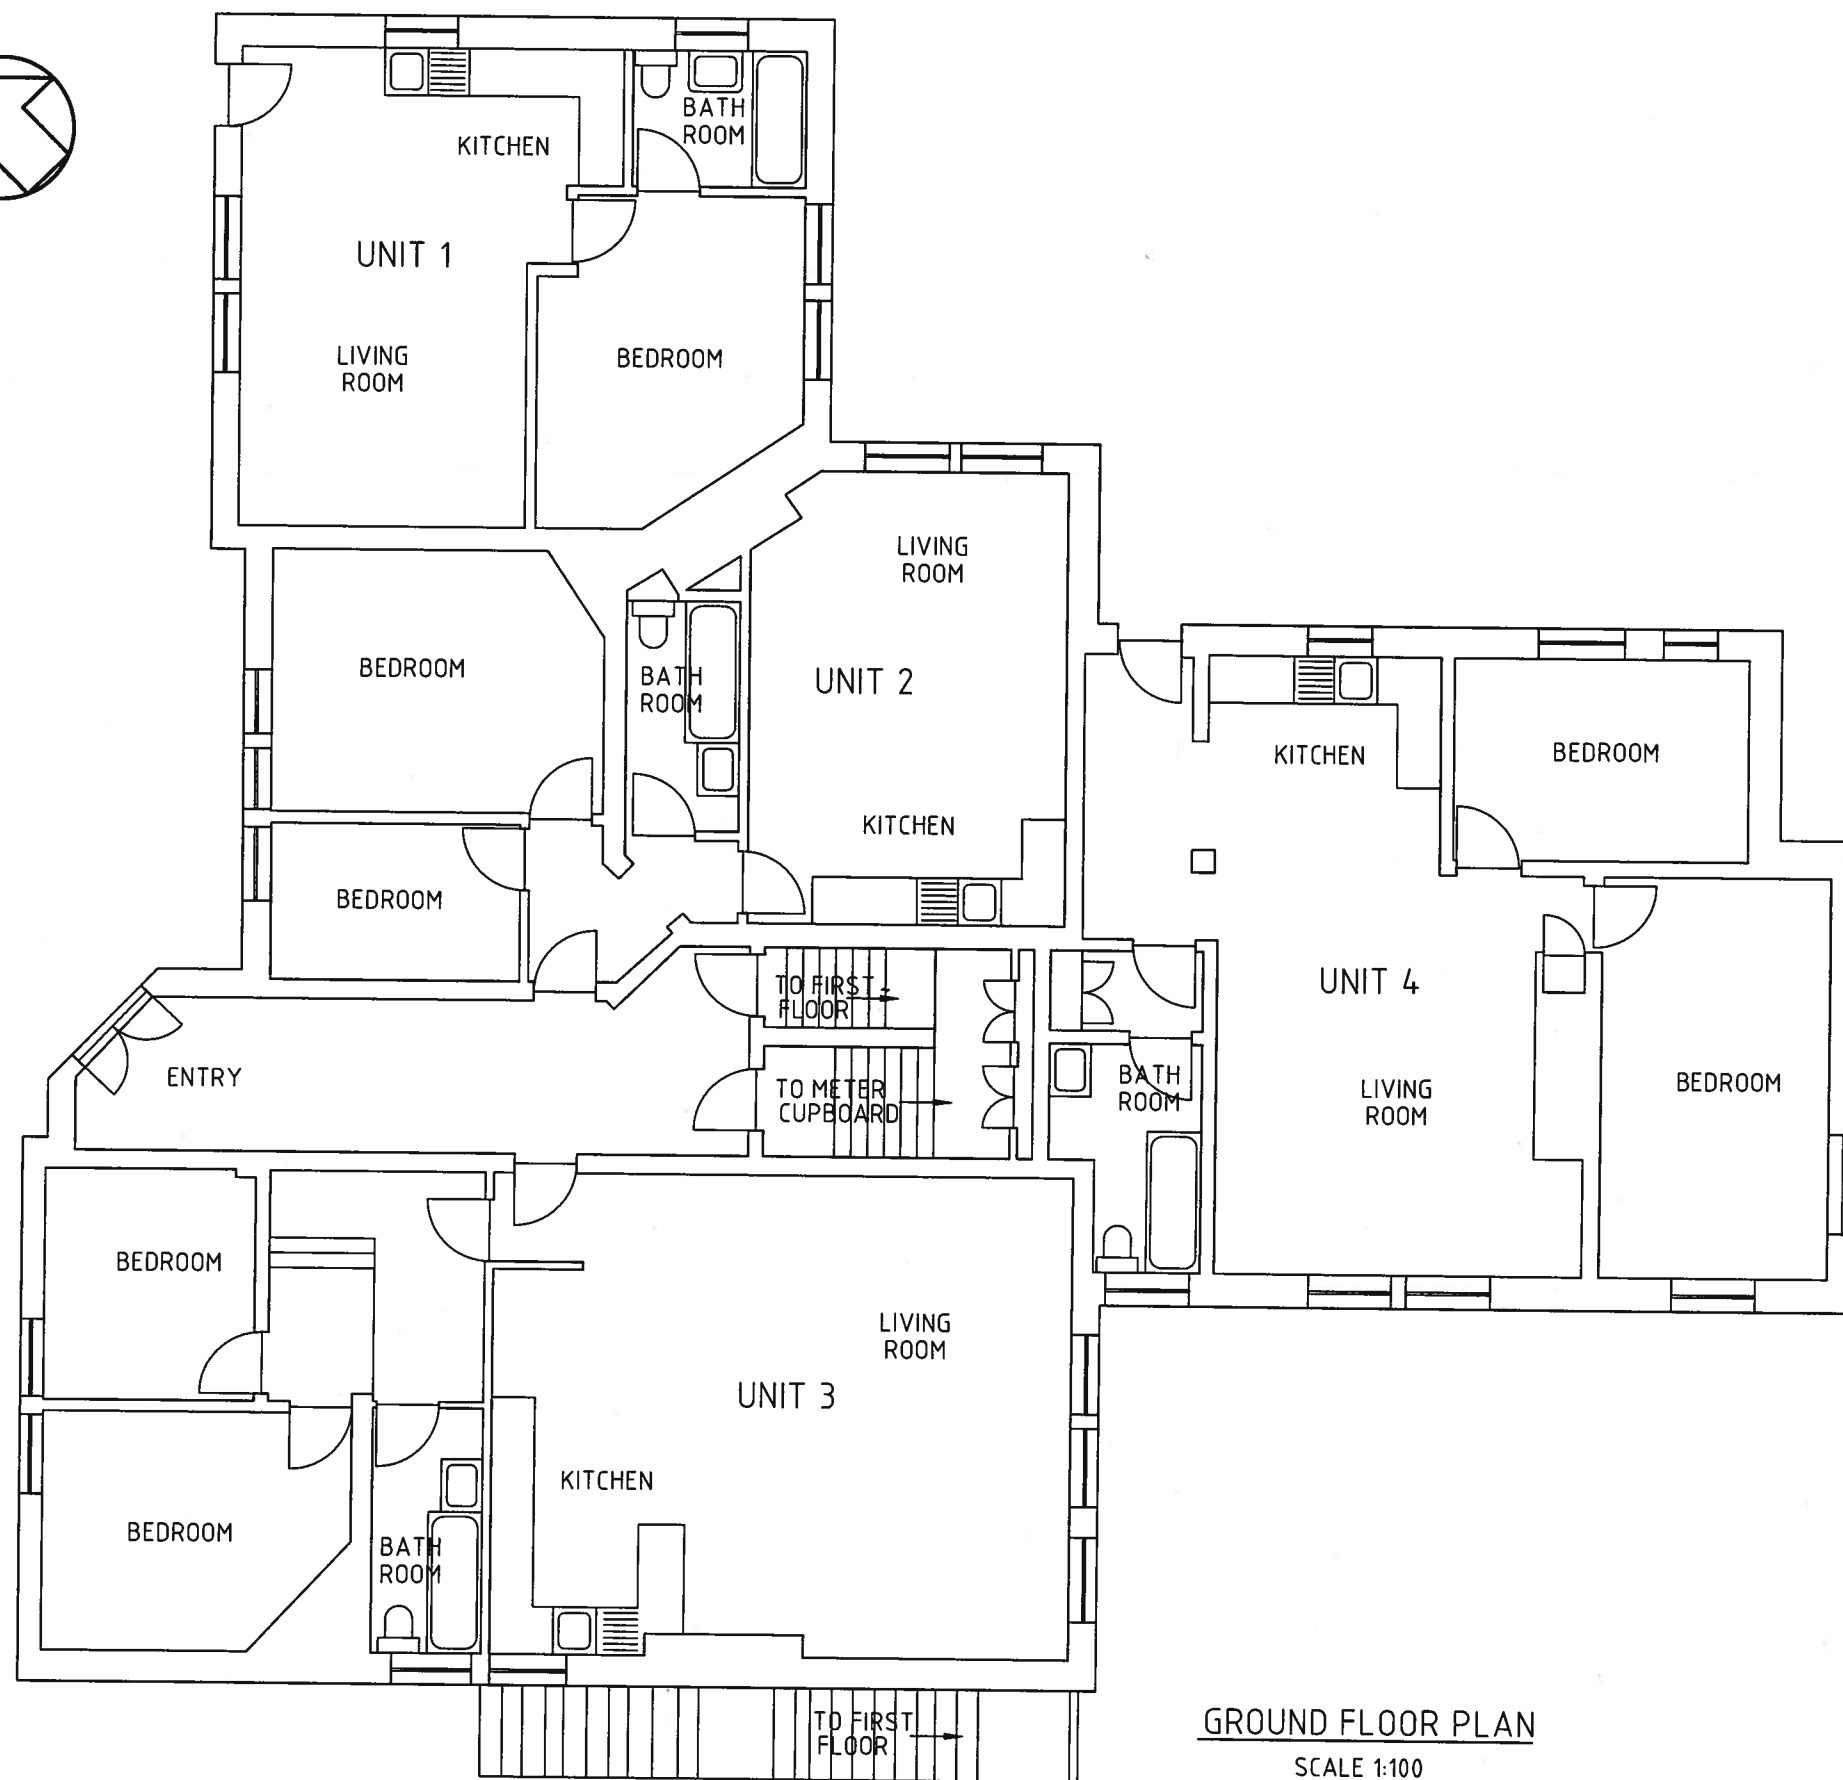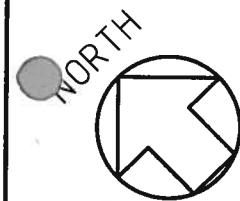

GROUND FLOOR PLAN
SCALE 1:100



SITE PLAN
SCALE 1:1250

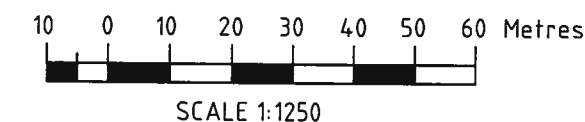

Piping Logic
Level 4, Gladden Building
731 Hay Street
Perth 6000
Western Australia
ph: +61 (08) 6424 9888
fax: +61 (08) 9322 4040

COPYRIGHT SUBSISTS IN THIS DRAWING AND SUCH COPYRIGHT IS THE PROPERTY OF PIPING LOGIC.
THIS DRAWING ALSO CONTAINS CONFIDENTIAL INFORMATION WHICH IS THE PROPERTY OF PIPING LOGIC.
ANY REPRODUCTION OF THIS DRAWING OR ANY PART THEREOF WITHOUT THE WRITTEN CONSENT
OF PIPING LOGIC IS NOT PERMITTED AND WILL BE AN INFRINGEMENT OF PIPING LOGIC COPYRIGHT.
ANY COMMUNICATION OF AND/OR DEALING WITH THE CONTENT OF THIS DRAWING OR INFORMATION
CONTAINED IN THIS DRAWING WITHOUT THE WRITTEN CONSENT OF PIPING LOGIC IS NOT PERMITTED AND WILL BE
A BREACH OF EMPLOYMENT CONTRACT.

CONTRACTOR

ASSET MANAGER:

TITLE:
FIDDLERS PTY LTD
FIDDLERS INN - HEMINGFIELD
GROUND FLOOR LAYOUT

DRN.	SWH
ENG.	
CHK.	
APPD.	
DATE	2 OCT 2011


POST CODE:
S73 0QD

DWG No:
PL-FI-002


SHT No:
001

REV.
B


REV	DATE	DESCRIPTION	BY	CHKD	APPR
B	4-11-2011	ISSUED FOR APPROVAL	SWH		
A	2-10-2011	ISSUED FOR REVIEW	SWH		

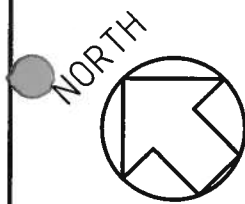

SITE PLAN
SCALE 1:1250

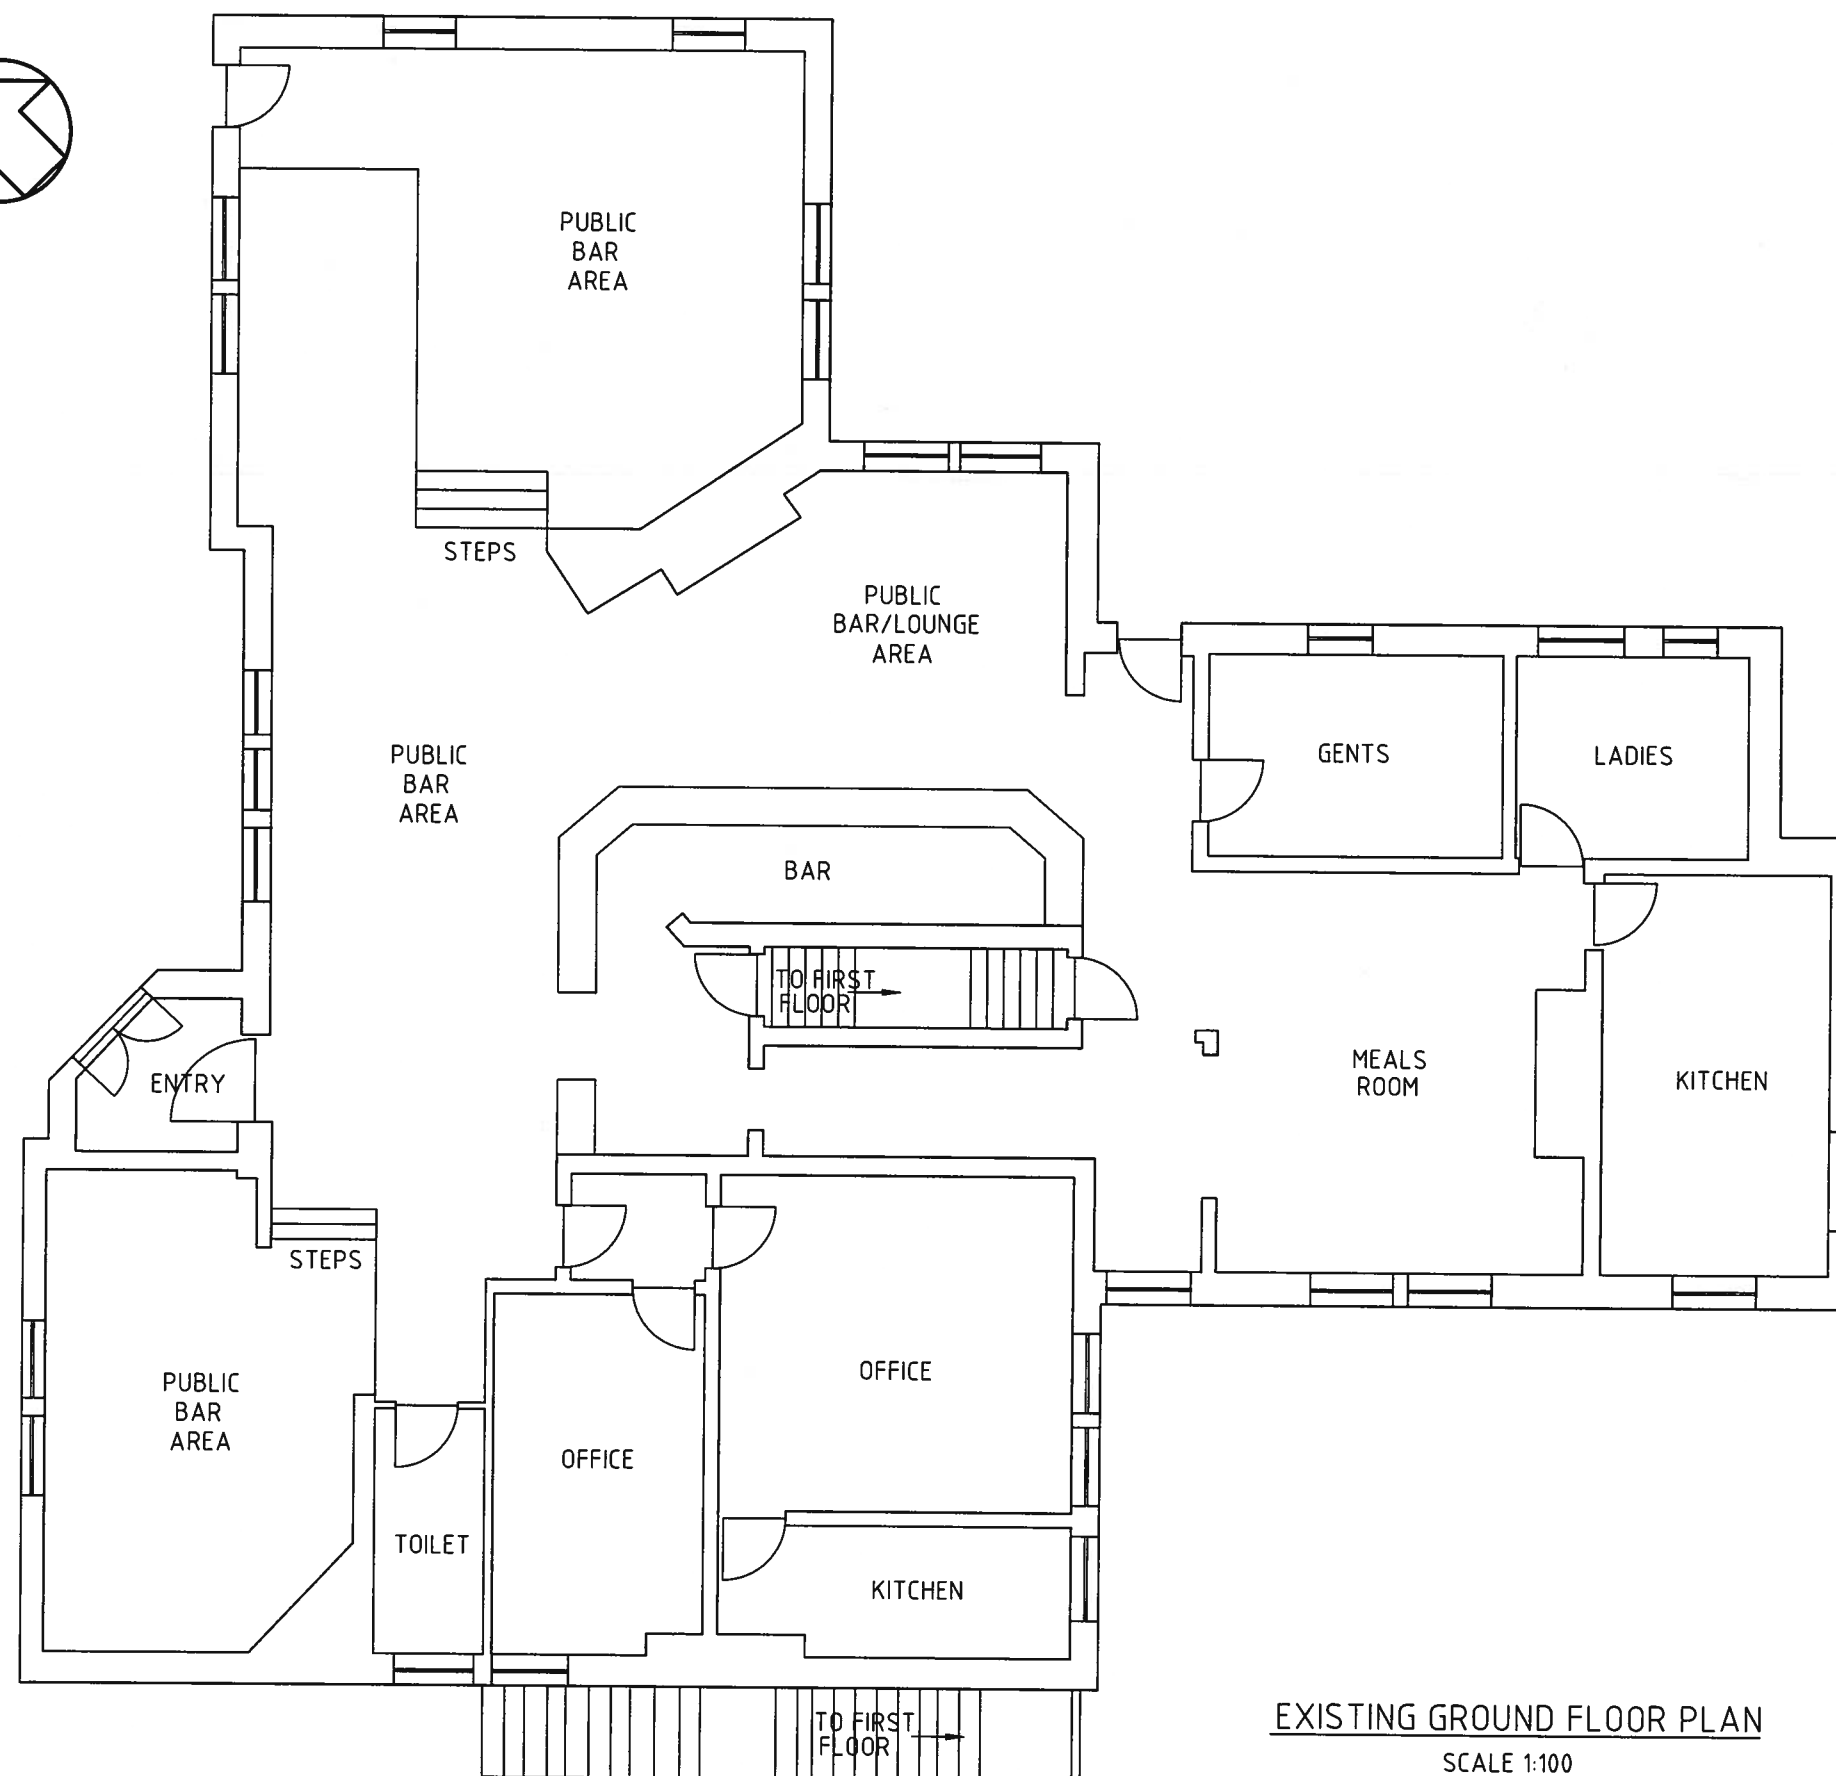

EXISTING GROUND FLOOR PLAN
SCALE 1:100

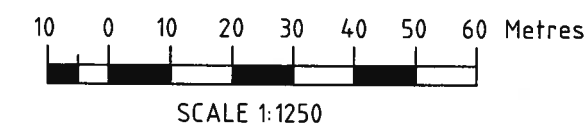

Piping Logic
Level 4, Gladson Building
731 Hay Street
Perth 6000
Western Australia
ph: +61 (08) 6424 8888
fax: +61 (08) 9322 4040

COPYRIGHT SUBSISTS IN THIS DRAWING AND SUCH COPYRIGHT IS THE PROPERTY OF PIPING LOGIC. THIS DRAWING ALSO CONTAINS CONFIDENTIAL INFORMATION WHICH IS THE PROPERTY OF PIPING LOGIC. ANY REPRODUCTION OF THIS DRAWING OR ANY PART THEREOF WITHOUT THE WRITTEN CONSENT OF PIPING LOGIC IS NOT PERMITTED AND WILL BE AN INFRINGEMENT OF PIPING LOGIC COPYRIGHT. ANY COMPLETION OF THIS DRAWING WITH THE OR ANY PART OF THE INFORMATION CONTAINED IN THIS DRAWING WITHOUT THE WRITTEN CONSENT OF PIPING LOGIC IS NOT PERMITTED AND WILL BE A BREACH OF COPYRIGHT.

CONTRACTOR

ASSET MANAGER:

TITLE: FIDDLERS PTY LTD
FIDDLERS INN - HEMINGFIELD
EXISTING GROUND FLOOR LAYOUT

DRN.	SWH
ENG.	
CHK.	
APPD.	
DATE	2 OCT 2011

POST CODE:	S73 0QD
DWG No:	PL-FI-001

SHT No:	001	REV.	B
---------	-----	------	---

REV	DATE	DESCRIPTION	BY	CHKD	APPR
B	4-11-2011	ISSUED FOR APPROVAL	SWH		
A	2-10-2011	ISSUED FOR REVIEW	SWH		