


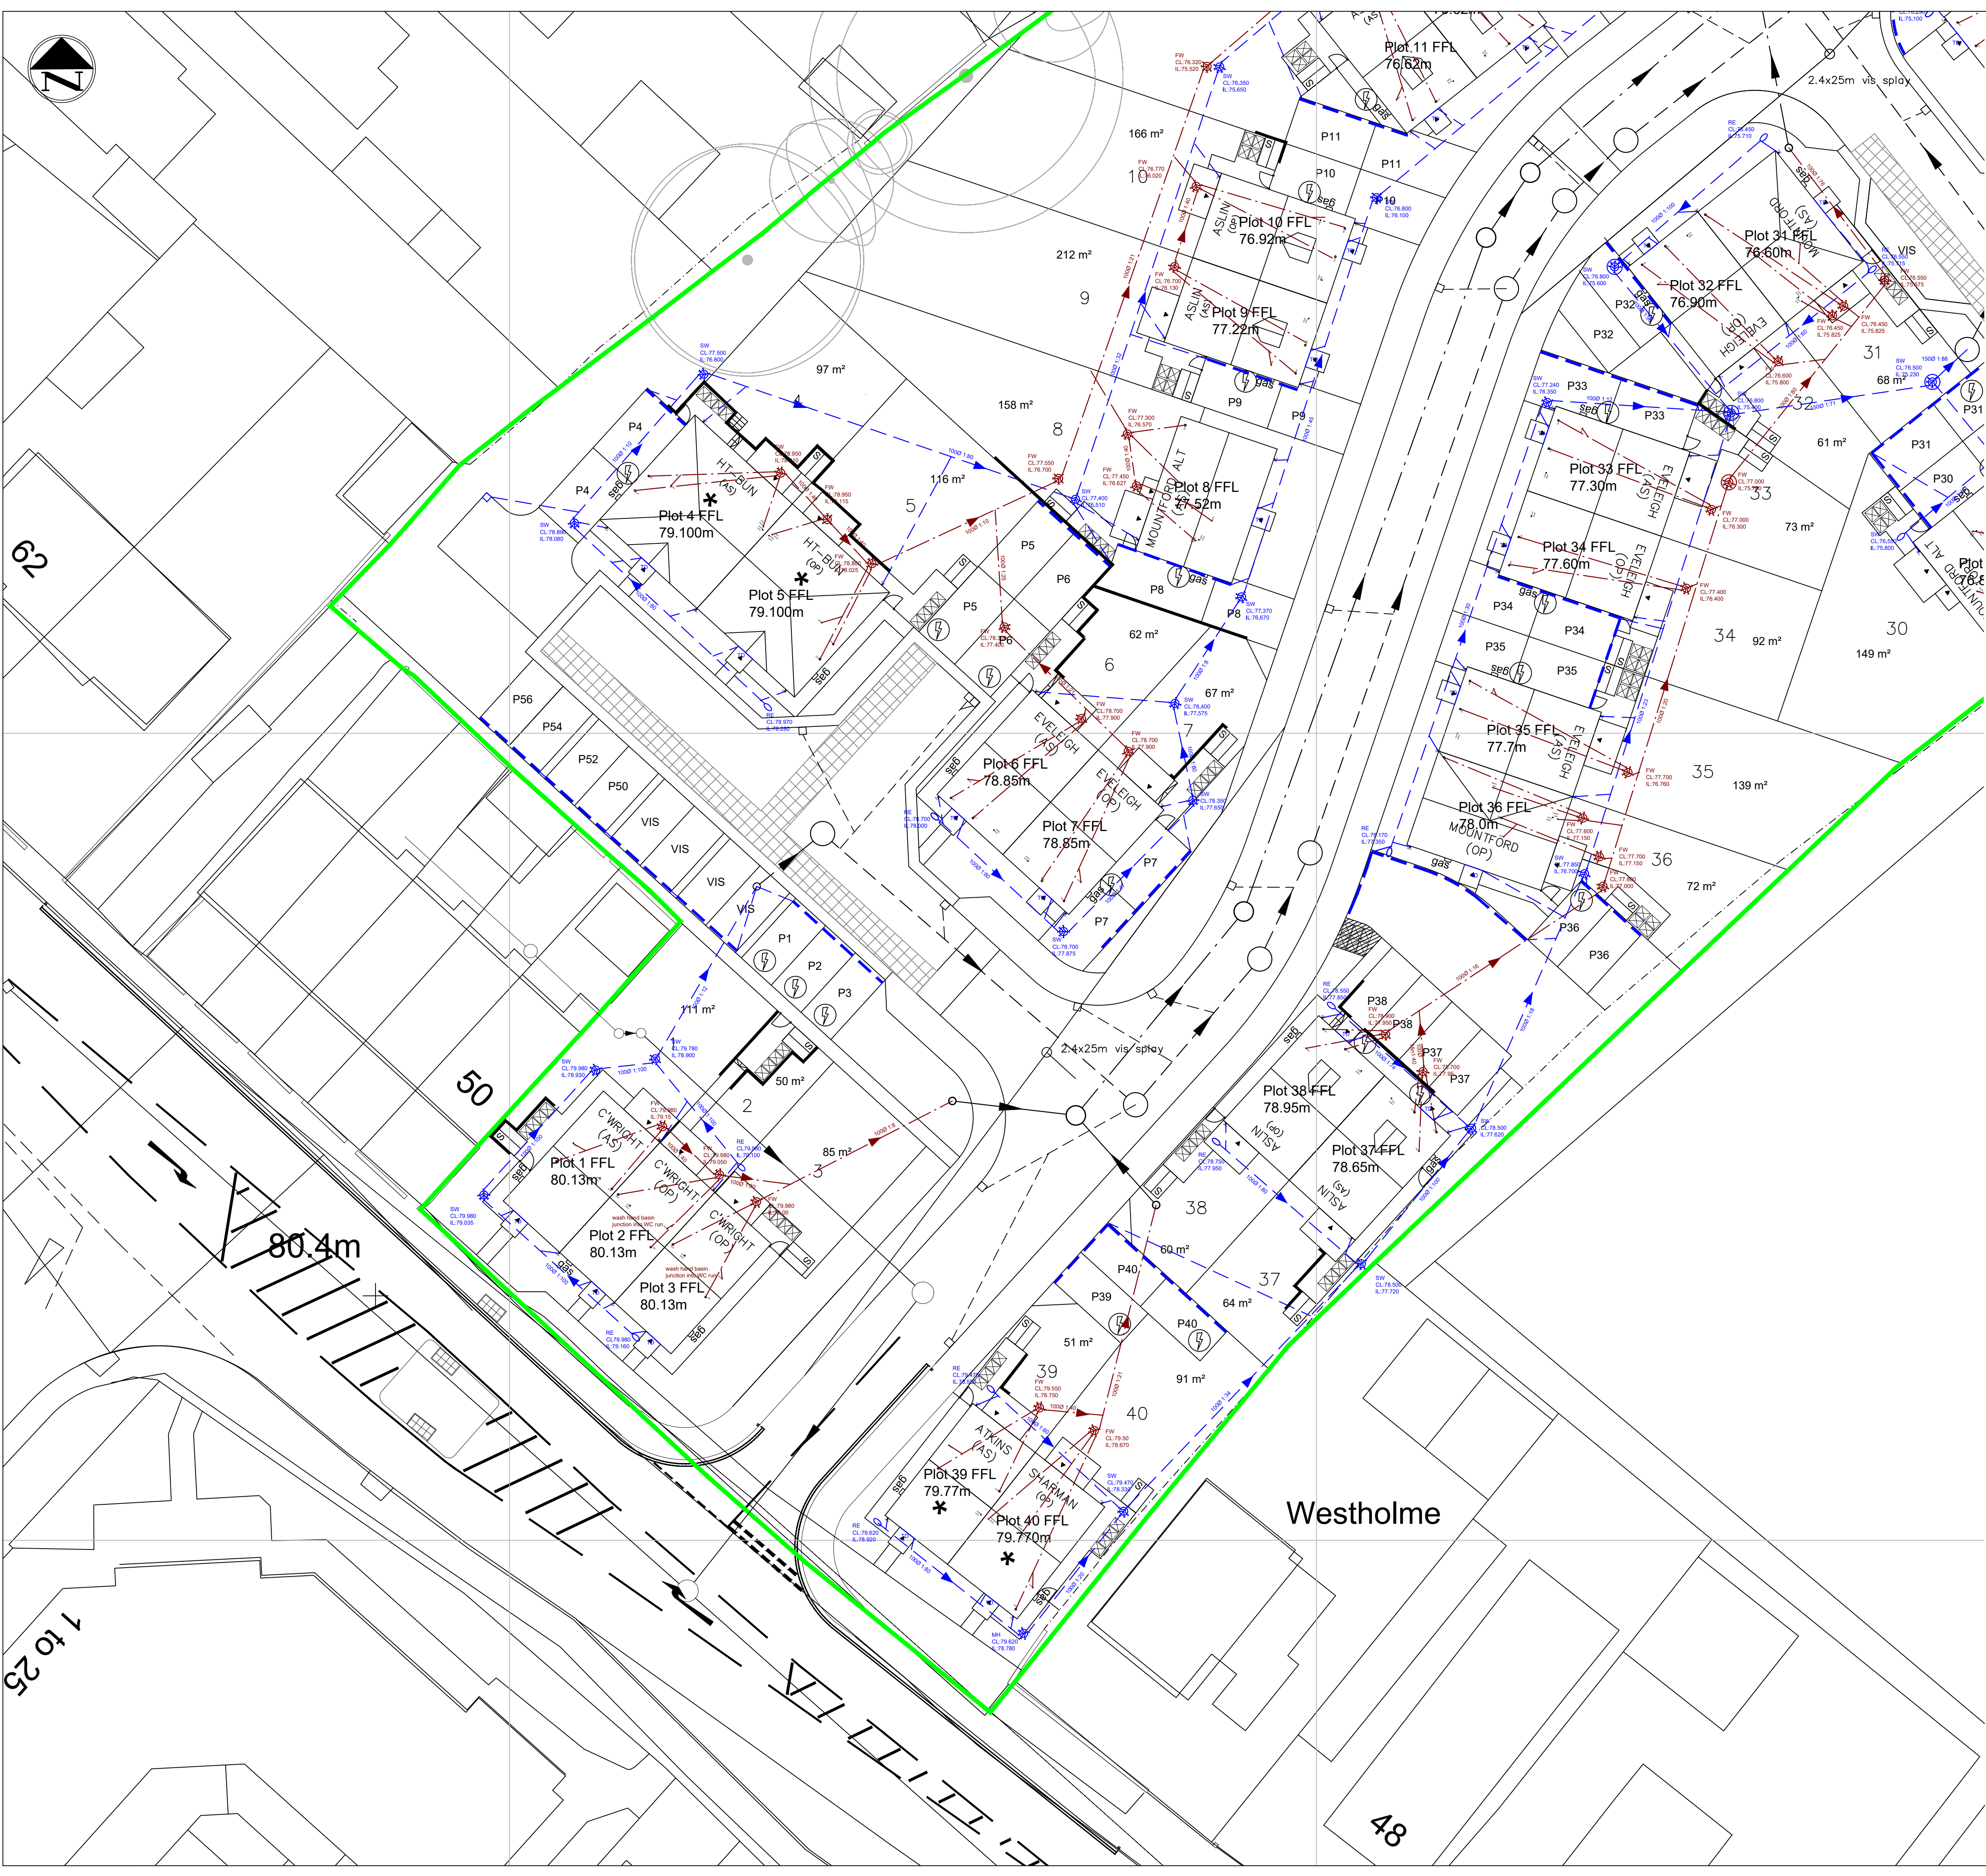

KEY

Proposed Surface Water

Proposed Foul Water

Private Surface Water

Private Foul Water

Existing Sewers

Gully

Service Margin

Site Boundary

Restricted access PPIC

PPIC

Note:
No work is to be carried out until the appropriate technical approvals are in place and relevant planning conditions are discharged. Any work carried out on site before technical approval is obtained and planning conditions are discharged is entirely at the contractor's risk.

Note:
All cover levels indicative.

P10	Drainage run removed from plots 6,7,8,9,10,11,12,13,14,15,16,17,18,19,20,21,22,23,24,25,26,27,28,29,30,31,32,33,35,36,37,38,40. FW IC levels revised plots 1,2,3,4,5,6,7,9,10,13,14,15,16,20,22,23,25,26,27,28,29,31,32,33,34,37,38,39,40. Plot 3 FW moved closer to plot. D/S pipe gradient revised. Plots 4 & 5 FW moved closer to plots. Plots 8-16 FW moved to avoid walls. Plot 8 FW moved closer to plot. Plots 9 & 10 FW connected together. Plot 12 IC moved. Plots 13 & 14 FW runs connected together. Plots 15 & 16 FW runs connected together. Plot 18 FW IC removed. Plots 20,21,22 FW IC moved closer to plots. Plots 23 & 24 FW run connected together. Plots 27-29 SW grad revised. Plots 39-40 FW runs separated.	LW	MH	24-01-24
P9	FW drainage outside plots 8, 35, 30, 27-29, 23-24, 17-18 revised	LW	MH	13.11.23
P8	Drainage revised as clouded	LW	MH	11.09.23
P7	SW drainage to plots 4 & 5 revised.	MH		31/03/2023
P6	PPIC types clarified in key, RWP & Internal foul locations updated.	LW	MH	29-03-23
P5	Architectural background updated at road 3	LW	MH	12.12.22
P4	Cover levels updated to suit plot level changes	LW	MH	16.09.22
P3	Private drainage altered to suit adoptable drainage changes	LW	MH	11/08/2022
P2	Rising main altered	LW	MH	20/06/2022
P1	Initial Issue	LW	MH	10/06/2022
Rev	Revision	By	Chk	Date

SCALE @ A1	ISSUING OFFICE	MSJ PROJECT NUMBER
1:200	Leeds	219112

STATUS	PURPOSE OF ISSUE
S4	FOR APPROVAL

MSJ

Melia Smith & Jones

Melia Smith & Jones

Consulting Civil & Structural Engineers
Vinery Court
58 Cardigan Lane
Leeds LS4 2LD
0113 2346060
www.msj.co.uk

PROJECT	High Street, Shafton
TITLE	Private Drainage Layout Sheet 1 of 2
CLIENT	Vistry Partnerships
DRAWING NUMBER	219112-MSJ-ZZ-XX-DR-D-4008
REV	P10