



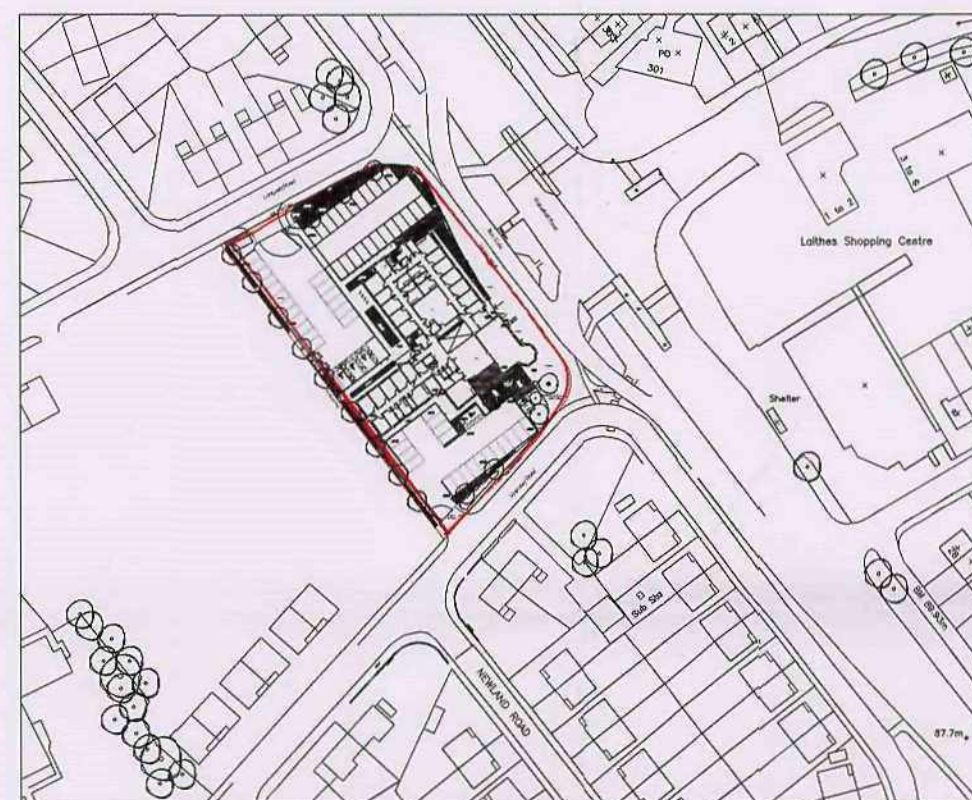

20 0 20 40 60 80 100
Metres

Location Plan
Scale 1:1250

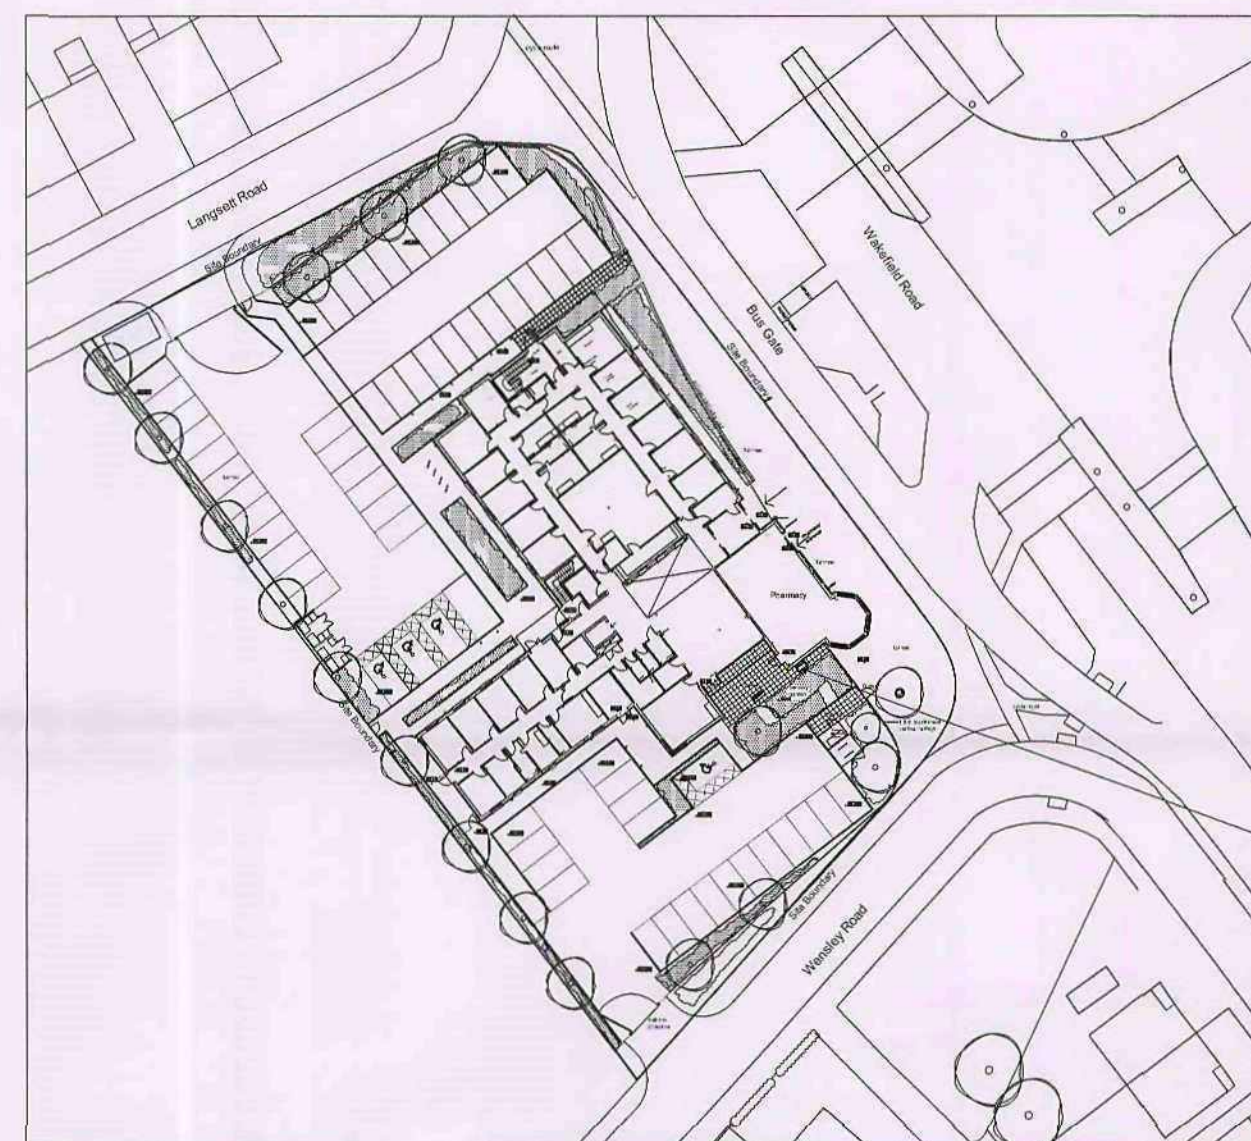

20 0 20 40 60
Metres

Site Plan
Scale 1:500

Proposed A/C
condenser unit

**ISSUED FOR PLANNING
PERMISSION**

Rev.	Date	Description	By	Chkd
A	Jan. 11	Issued For Planning Permission	TJH	

The **co-operative** pharmacy

Project:
Athersley/New Lodge Medical Centre
Wakefield Road
BARNLEY
S71 1RH


200438

Drawing Title:
**PROPOSED A/C CONDENSER
Proposed Site Plans**


Dwg. No:	401/11/02	A
Scales:	As noted	Date: Jan. 2011
Drawn:	TJH	Checked:

TOM HILL Building Design
11 St. Oswalds Road
Ashton in Makerfield Nr Wigan WN4 9NU
TEL: 01942 728748 Fax: 01942 272919
MOBILE: 07836 755240 e-mail: t.hill@btinternet.com



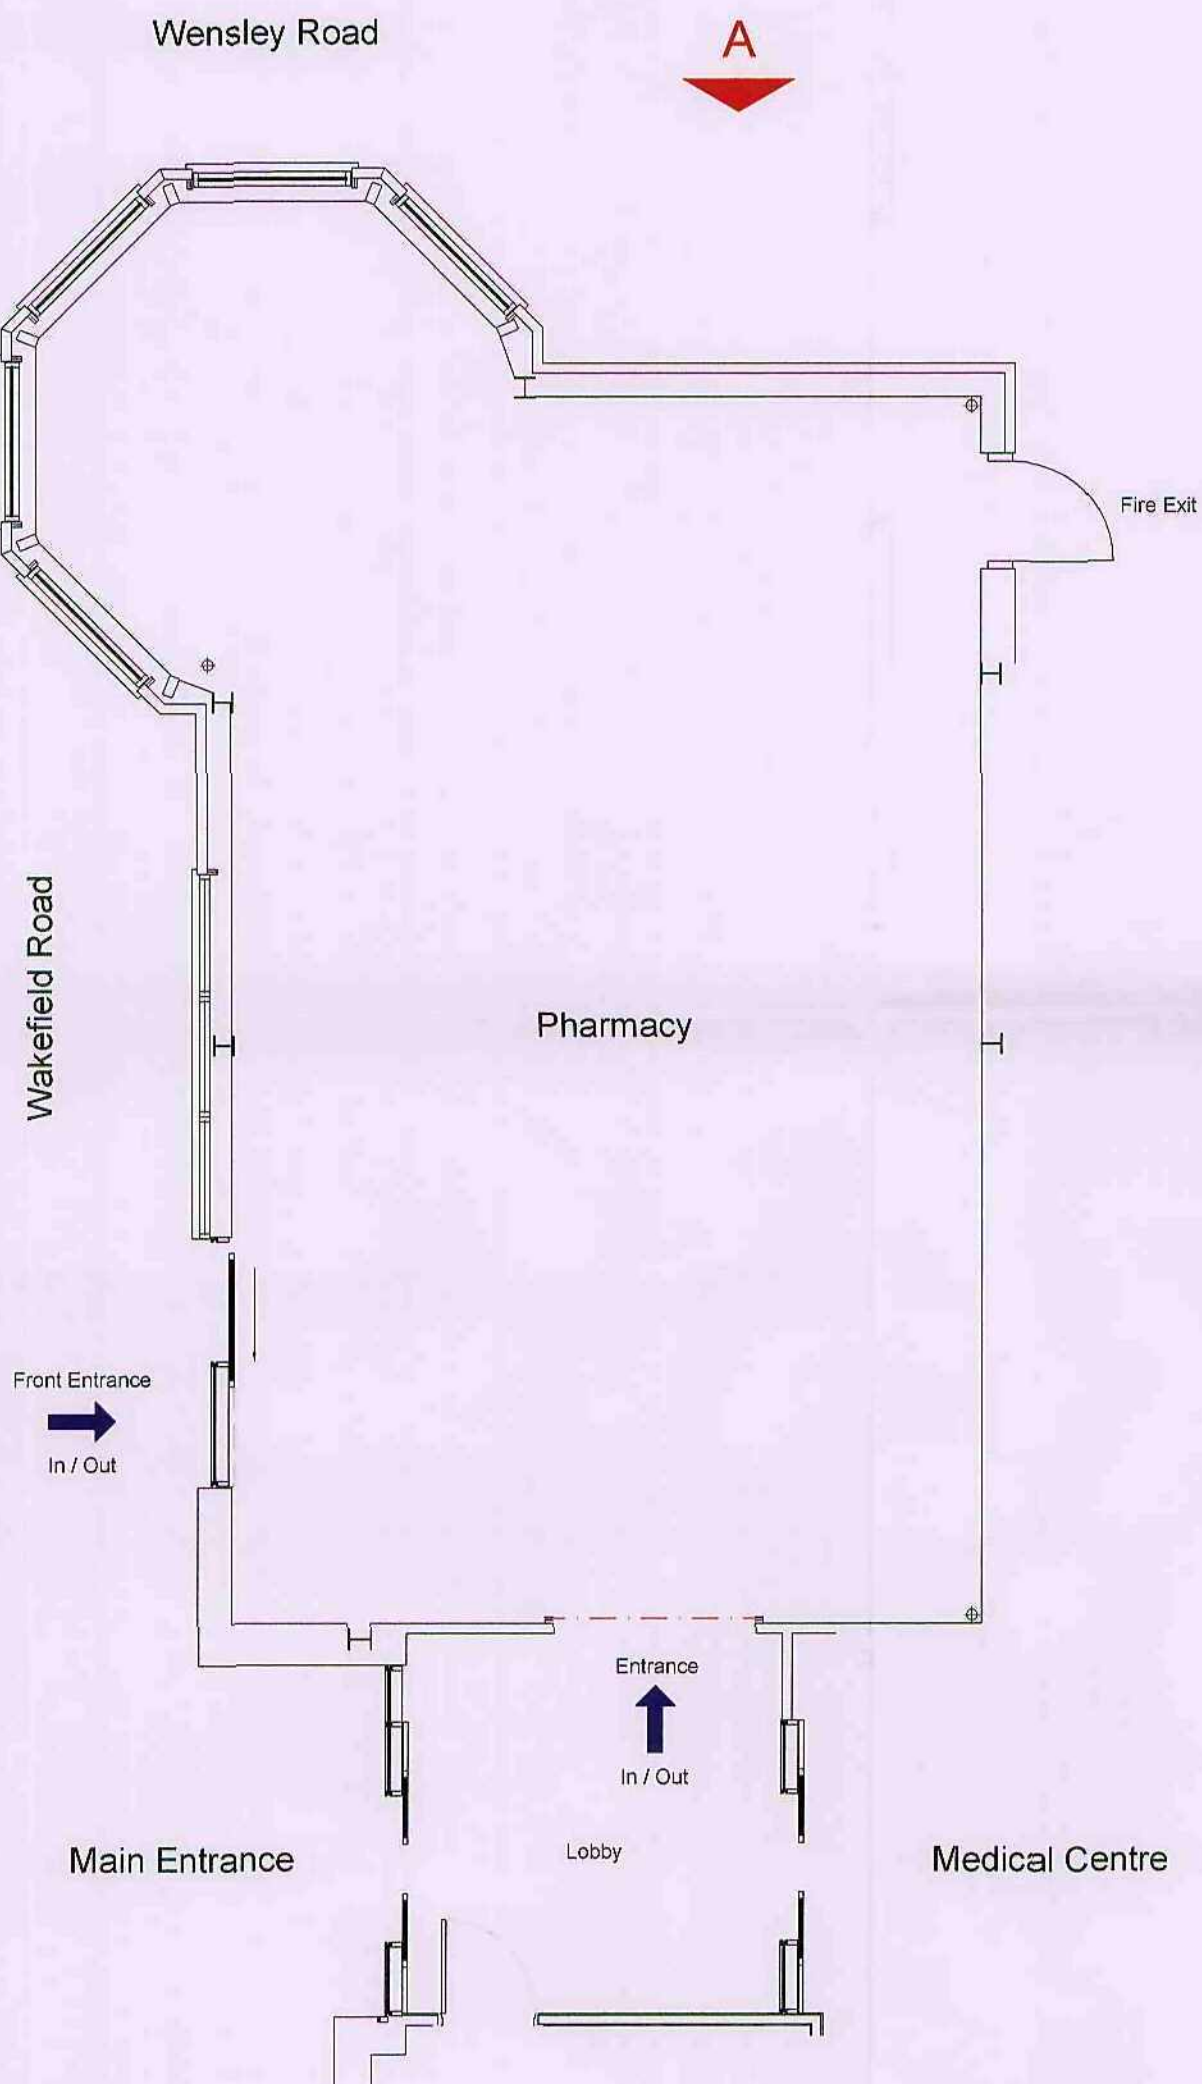


Existing Ground Floor Plan
Scale 1:50

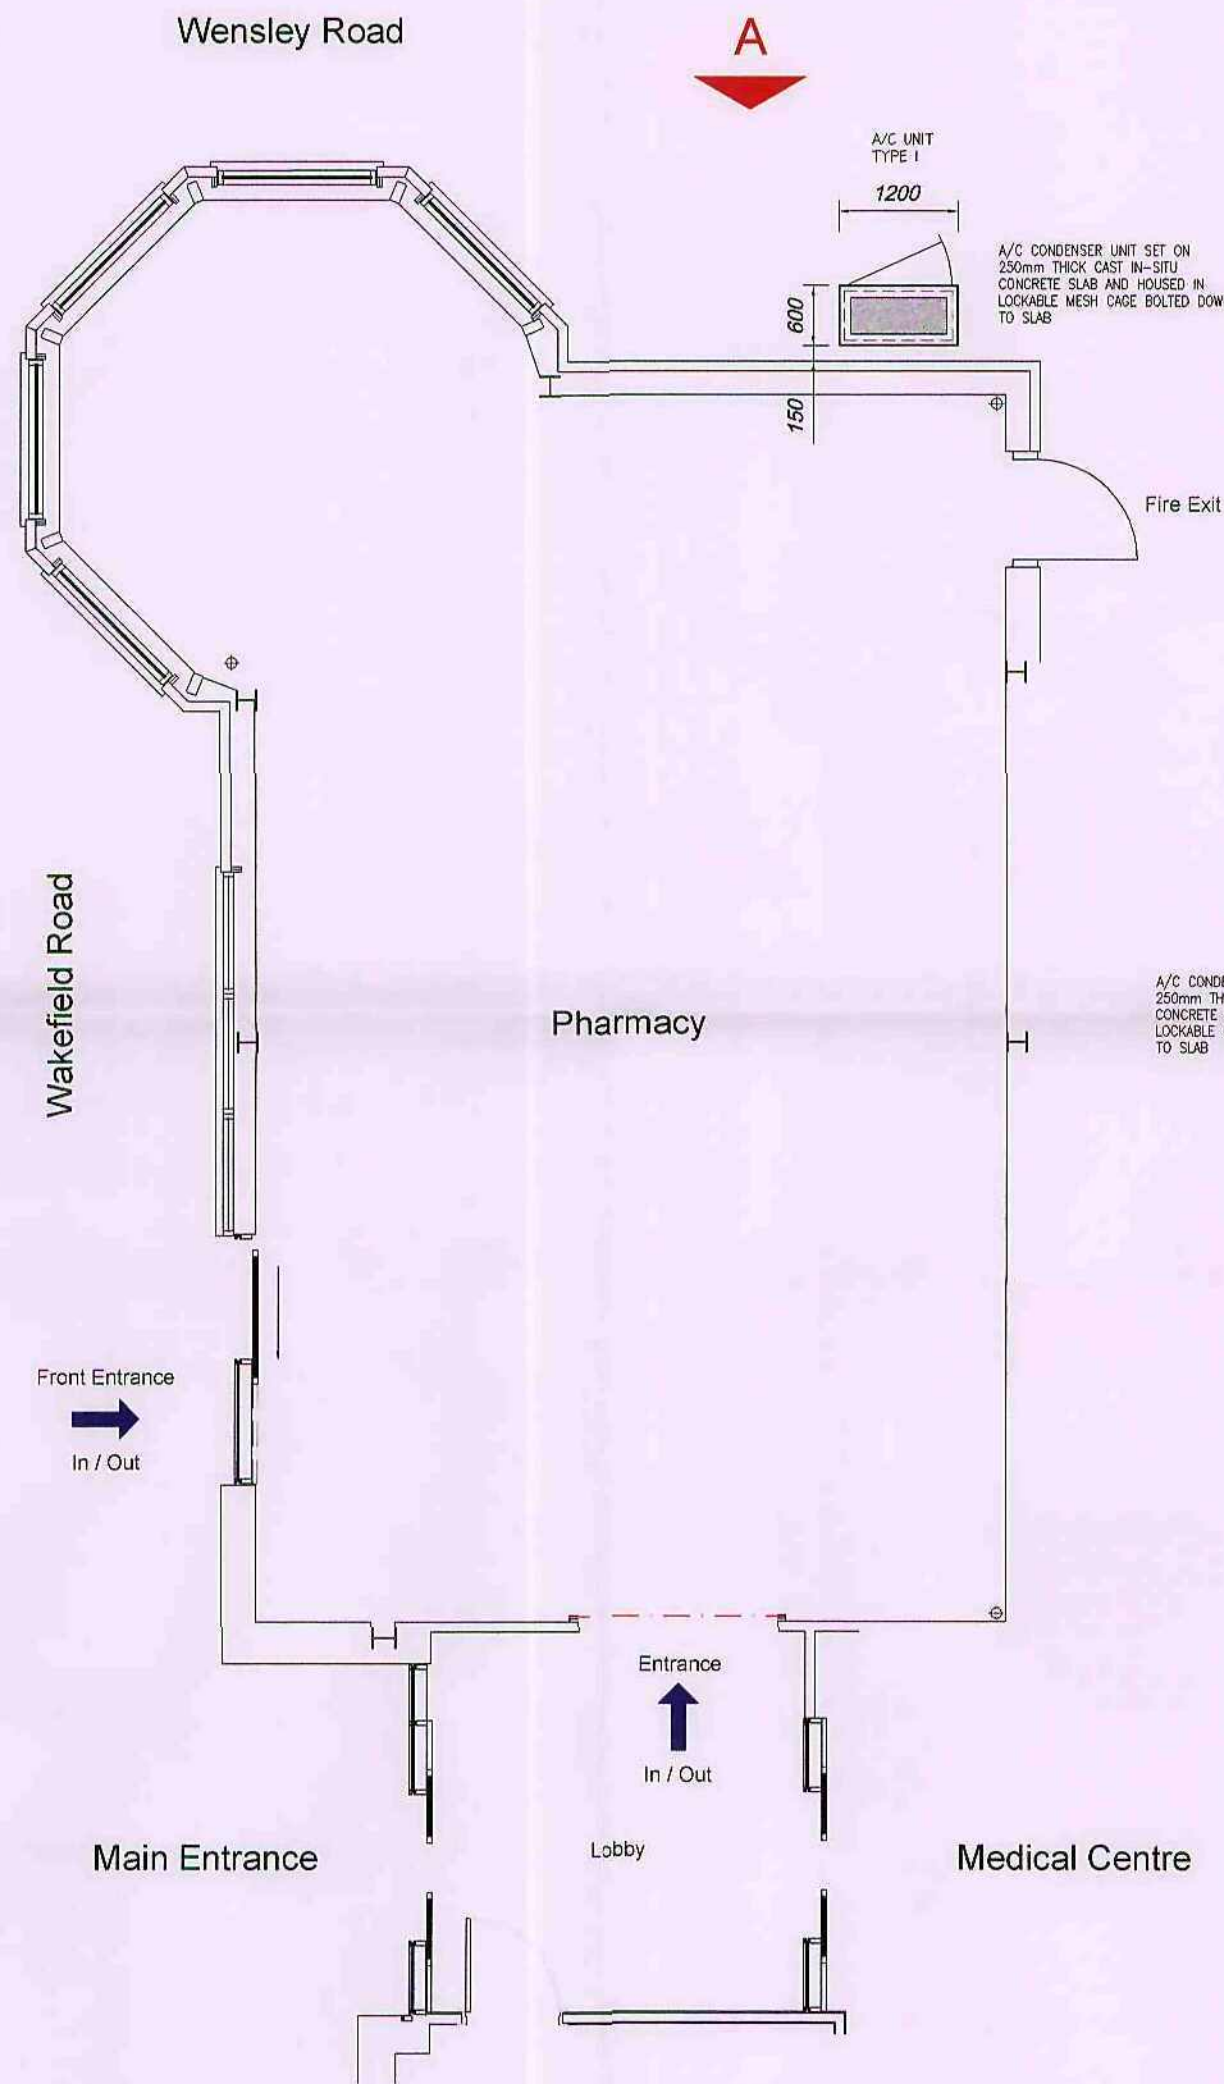


Proposed Ground Floor Plan
Scale 1:50

AIR CONDITIONING CONDENSER UNITS
(subject to survey by A/C contractor)


UNIT(TYPE I) - 1no.
MITSUBISHI PUHZ-RP140
950W x 1350H x 360d
see manufacturer's details for noise levels

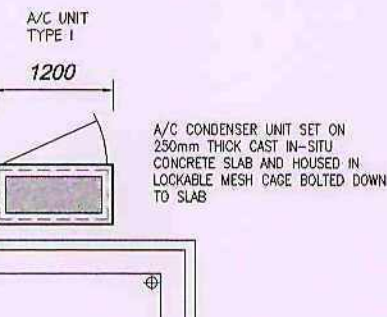

A/C CONDENSER UNIT SET ON
250mm THICK CAST IN-SITU
CONCRETE SLAB AND HOUSED IN
LOCKABLE MESH CAGE BOLTED DOWN
TO SLAB

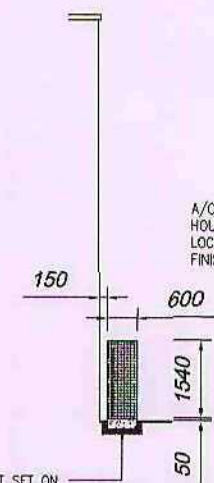

Proposed
Side View

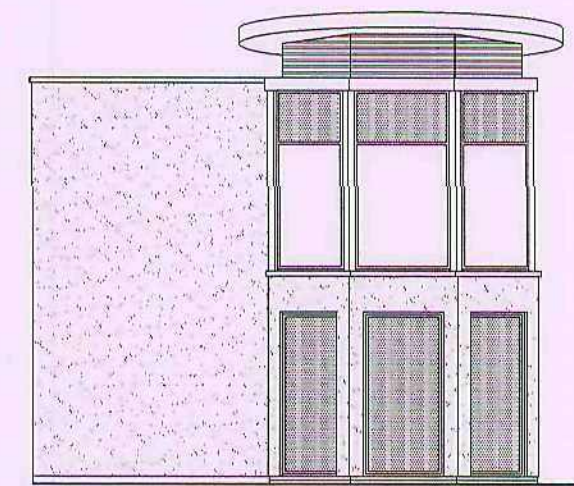

Existing Elevation on 'A'
(Wensley Road)



Proposed Elevation on 'A'
(Wensley Road)
Elevations At Scale 1:100

0 1 2 3m
SCALE - 1:50

ISSUED FOR PLANNING
PERMISSION

Rev.	Date	Description	By	Chkd.
A	Jan. 11	Issued For Planning Permission	TJH	

The co-operative pharmacy

Project:
Athersley/New Lodge Medical Centre
Wakefield Road
BARNSELY
S71 1RH

200438

Drawing Title:
**PROPOSED A/C CONDENSER
Existing & Proposed Details**

Dwg. No: **401/11/01**

Scales: 1:50 1:100 Date: Jan. 2011

Drawn: TJH Checked:

TOM HILL Building Design
11 St. Oswalds Road
Ashton in Makerfield Nr Wigan WN4 9NU
TEL: 01942 729746 Fax: 01942 272919
MOBILE: 07899 755240 e-mail: t.hill@btinternet.com

