




PROPOSED SITE PLAN Sc 1:1250




3D VIEW OF NEW PROPOSED ALC

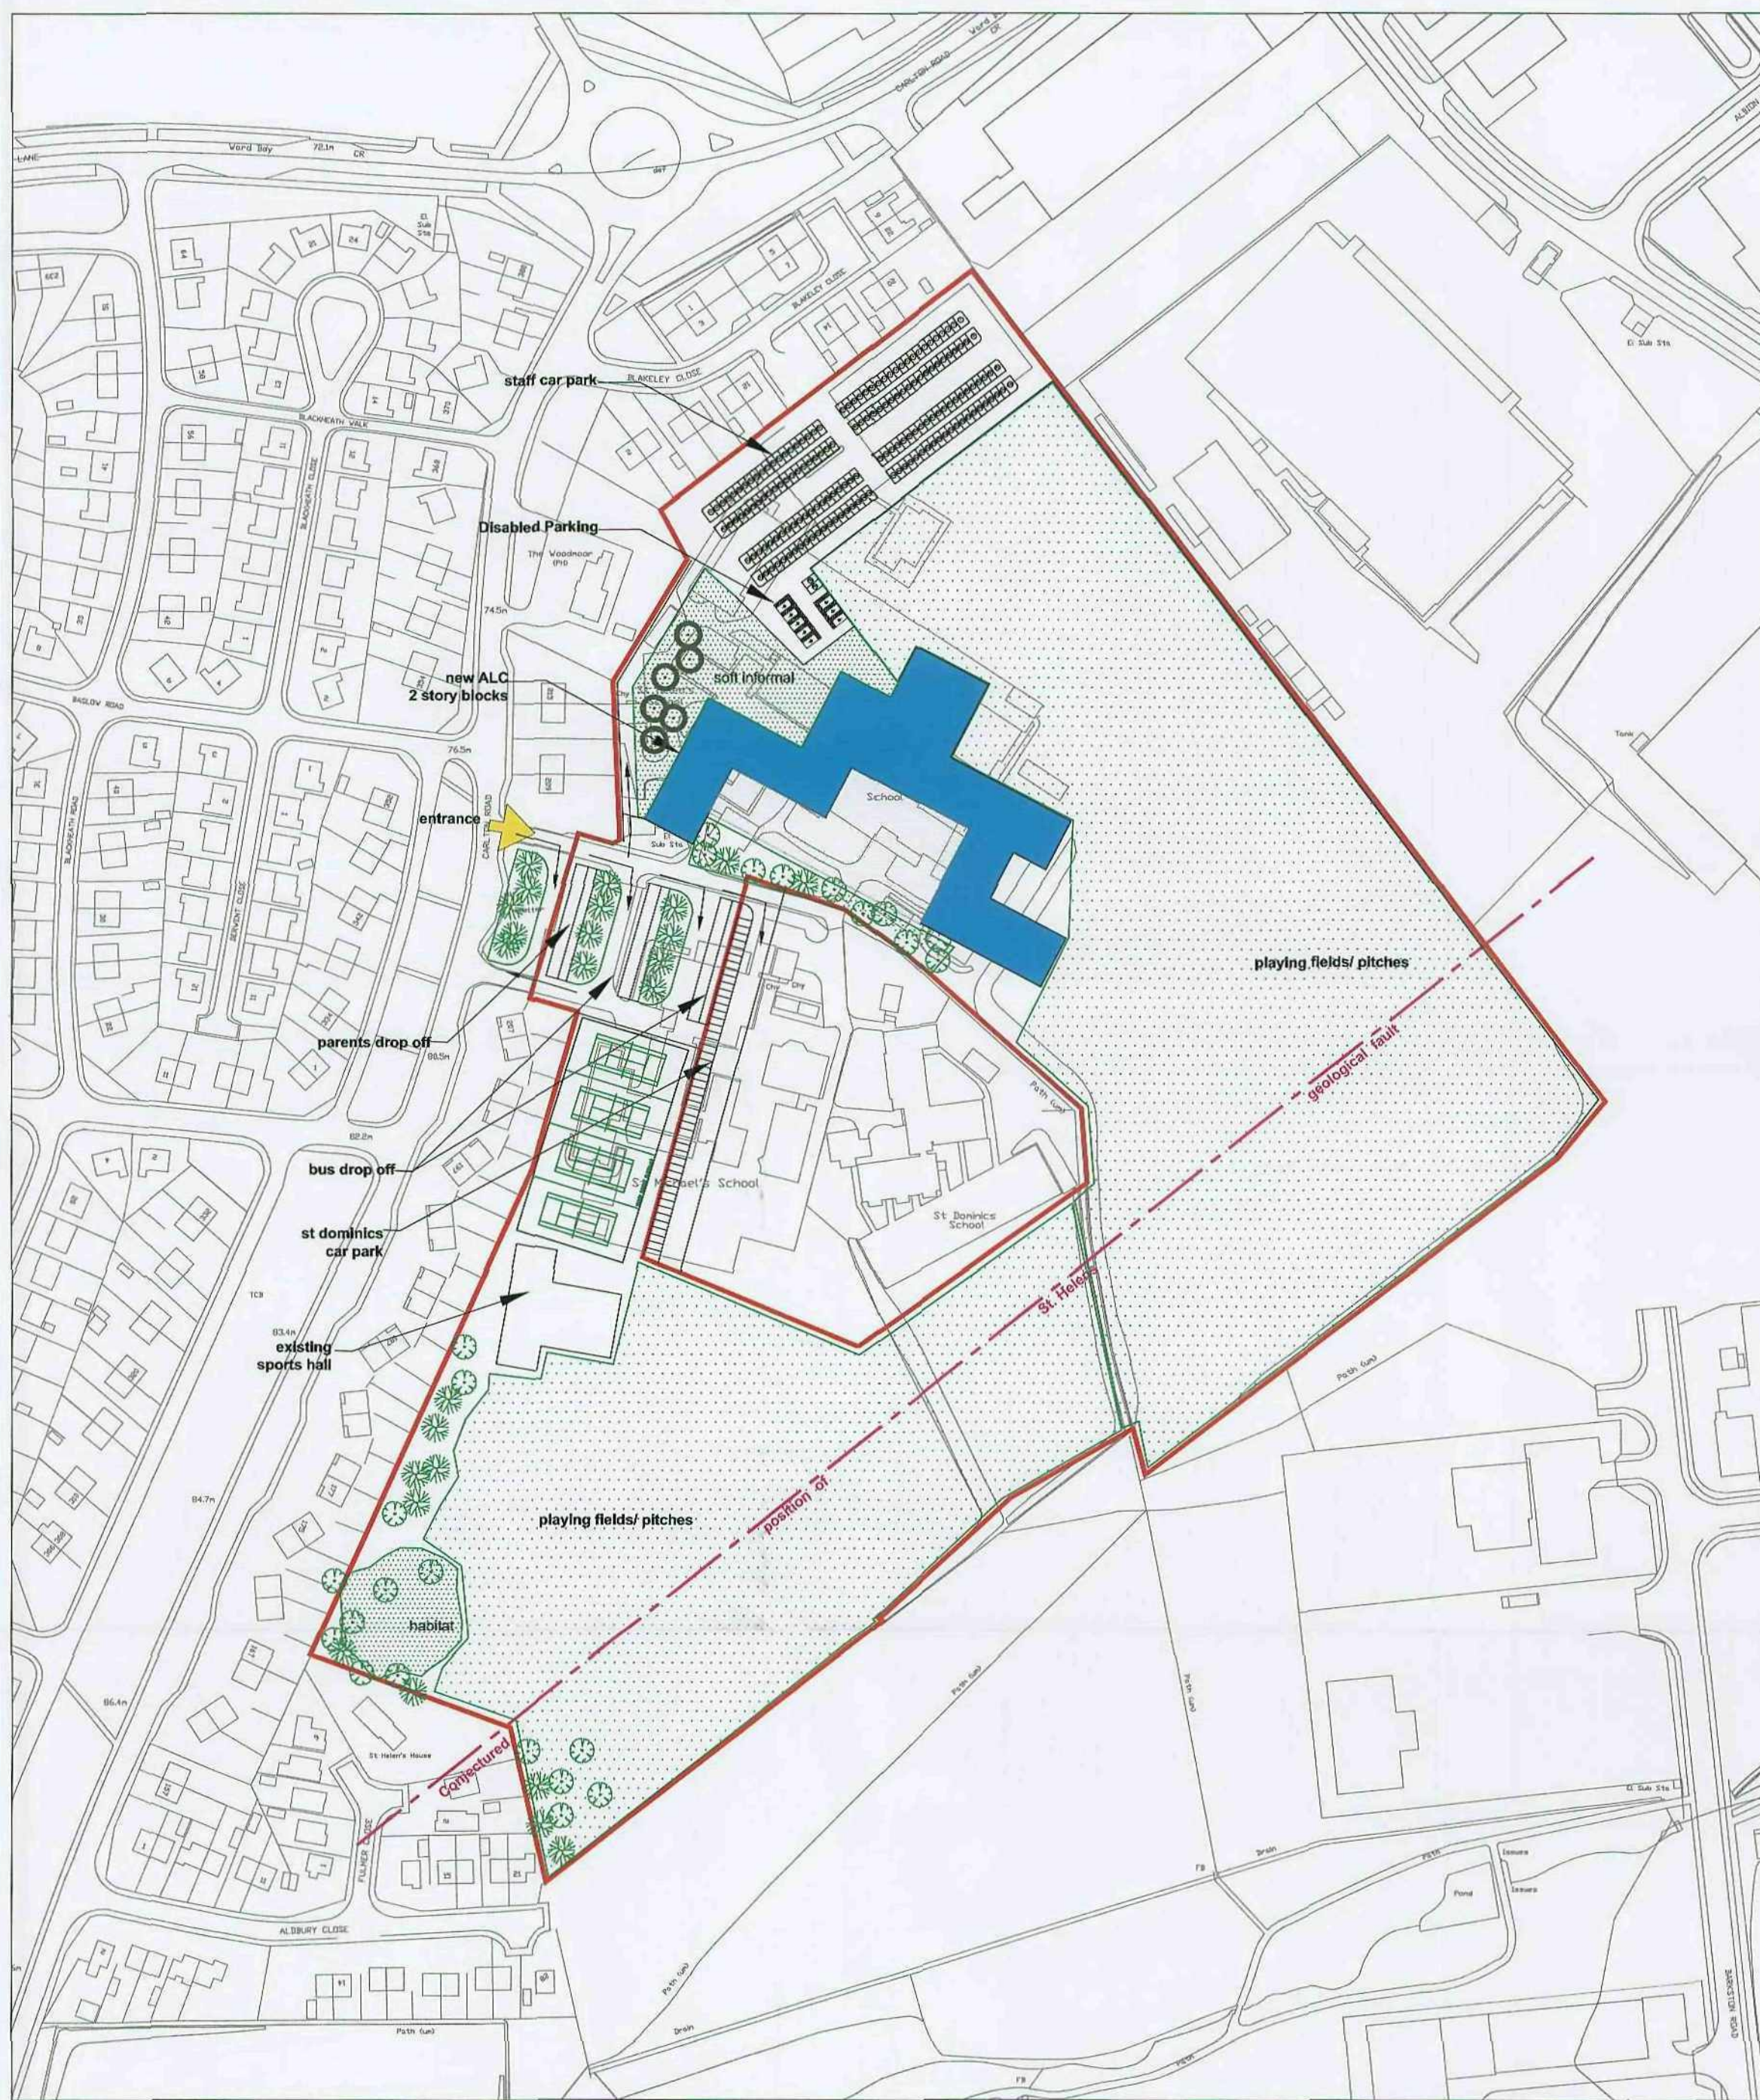

AERIAL VIEW OF EXISTING SITE




AERIAL VIEW OF PROPOSED SITE

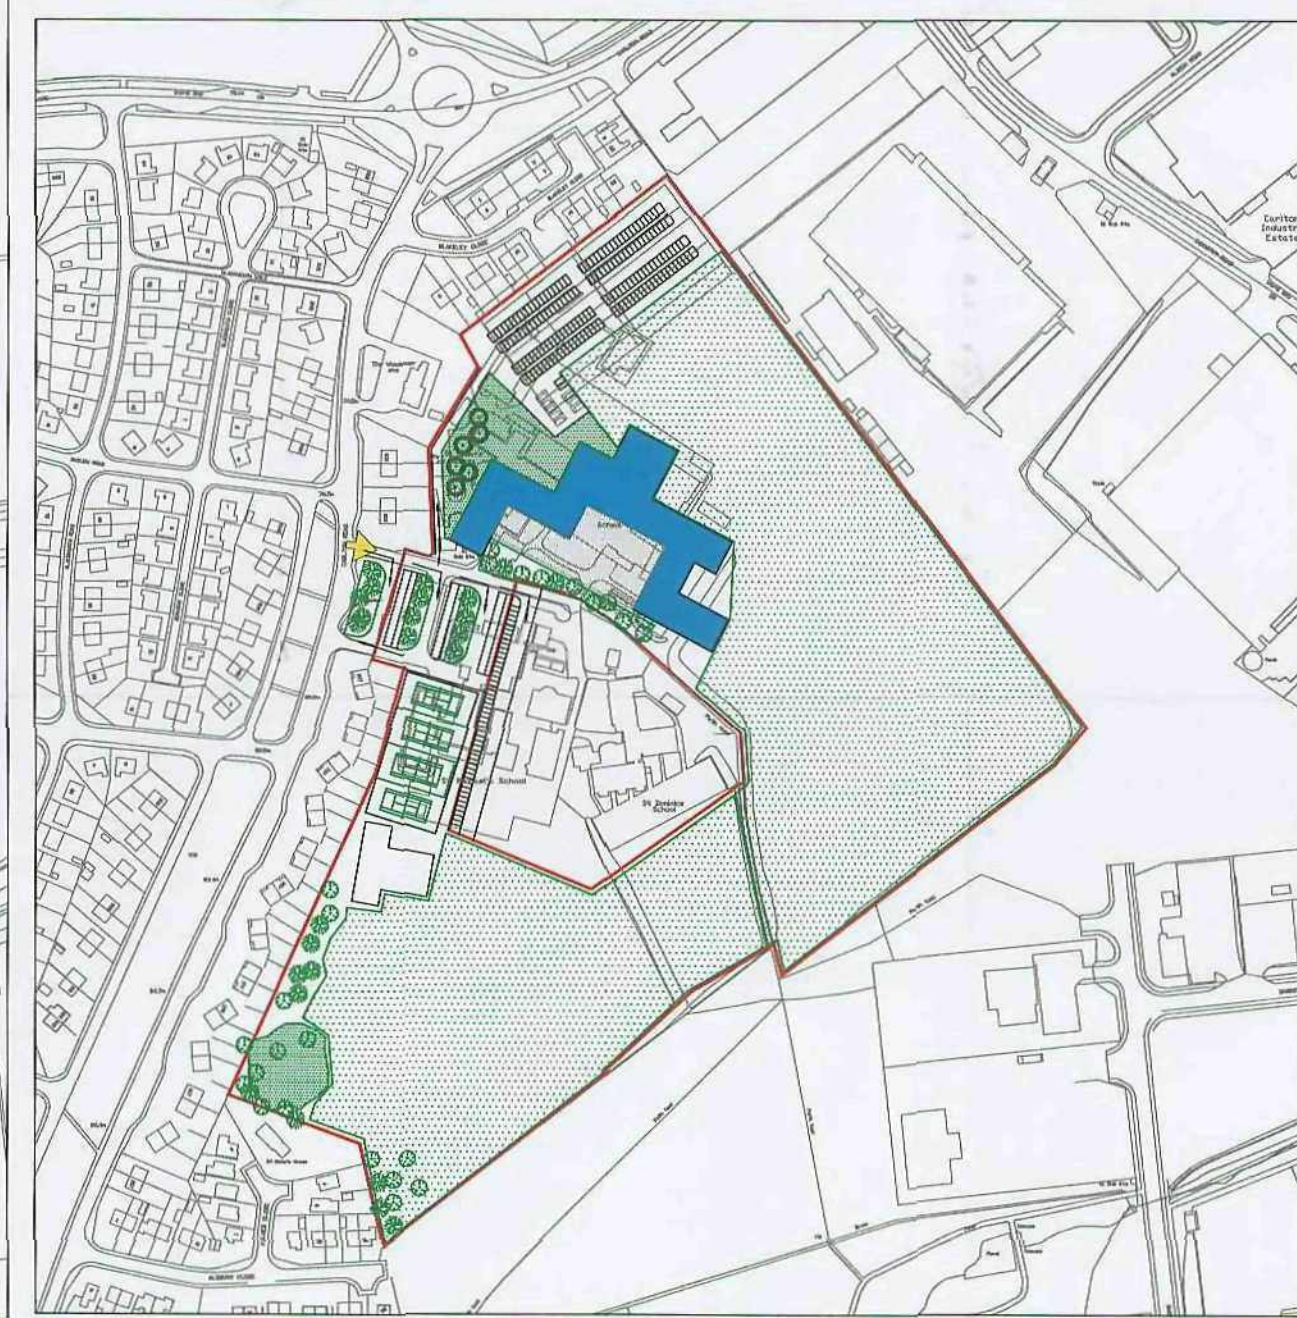

LOCATION PLAN Sc 1:2500



 OFFICIAL REGISTERED MEMBER
 H:\Software\CLIPART\LOGOS\BARNLEY COUNCIL.Jpg

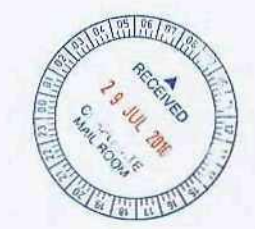

BARNSELEY
Metropolitan Borough Council

Property & Procurement
 Springfield House, Springfield St
 Barnsley S70 6HH
 Tel: 01226 770770
 Fax: 01226 774399

PROJECT
 BSF
 PROGRAMME

DRAWING
 ST MICHAELS HIGH SCHOOL
 PROPOSED ALC

Drawn	Revision
FR	

Scale	Date
1:1250-1:2500	JUNE 06

Project Code	Drawing No.
ED 1942	AL (0) 01

C.A.D File Name
 Layer State

1. Do not scale from the drawing or the computer model. All dimensions are in mm (A.O.D.) unless noted otherwise.
2. All dimensions are by room and all levels are in m (A.O.D.) unless noted otherwise.
3. Existing survey information was obtained from Yorkshire Water records and from a connectivity survey completed on site during March 2010.
4. All official flows have been agreed by Yorkshire Water.
5. The location of existing services shown on this drawing are from the topographical survey.
6. The Contractor should take note of H400 47 'Warning Danger from Underground Services' signs and ensure that they are visible at all times.
7. It is the responsibility of the Contractor to ensure that the existing services are not damaged or disturbed in any way work commencing on the site. Any damage to existing services should be reported directly to the Engineer.
8. Unless stated otherwise, all gully covers shall be D400 to BS EN124 in made and finished areas, where possible all covers to be orientated to be parallel to traffic and parking.
9. Rain water pipe positions are shown indicatively prior to construction.
10. All gully positions should be confirmed in accordance with the current Building Regulations.
11. All drainage to be laid soffit to soffit unless otherwise stated.
12. All concrete pipes, manholes and other below ground drainage to meet with appropriate meeting gully covers.
13. All materials and components to be supplied of and provided from the drainages manhole.
14. All new drainage shall be to be laid and CCTV surveyed with recording equipment to confirm satisfactory construction.
15. Rain water harvesting tank shown in position where it will pick the rain water from the roof space.
16. All pipes to be a Class 1 pressure pipe - 150mm diameter and laid at 1 in 100 unless otherwise stated.
17. All pipes to be a Class 1 pressure pipe - 150mm diameter and laid at 1 in 100 unless otherwise stated.
18. Drawing based on Architects building layout issued 15.07.2010
19. Manufacturer listed as all types must incorporate a 450mm deep sump.



Legend
Proposed site boundary
Proposed surface water drain
Proposed surface water manhole
Proposed rainwater harvesting tank
Proposed gully and connection
Proposed ACO Multi-Drain channel
Proposed channel drain outlet
Proposed rain water pipe
Proposed Oil Separator
(See notes for unit reference)
Existing drainage system

ARUP

4th Floor, New Oxford Square
100 Broad Street, Birmingham B1 2HT
Tel: +44 (0)121 272 2000 Fax: +44 (0)121 272 2001
www.arup.com

LANG OROURKE

100 Broad Street
Birmingham B1 2HT
Tel: +44 (0)121 272 2000 Fax: +44 (0)121 272 2001
www.langoro.co.uk

Barnsley BSF

100 Broad Street
Birmingham B1 2HT
Tel: +44 (0)121 272 2000 Fax: +44 (0)121 272 2001
www.barnsleybsf.co.uk

Rev	Date	By	Chkd	Appd
P3	17/07/10	P.A./R.L.	R.L.	R.W.
P2	06/06/10	P.A./R.L.	R.L.	R.W.
P1	26/05/10	P.A./R.L.	R.L.	R.W.


Issued for information

Scale of A2: 1:500

Drawing Title: Proposed Surface Water Drainage

Drawing Status: Site Development

Information: Drawn by: ARUP, P3
212882

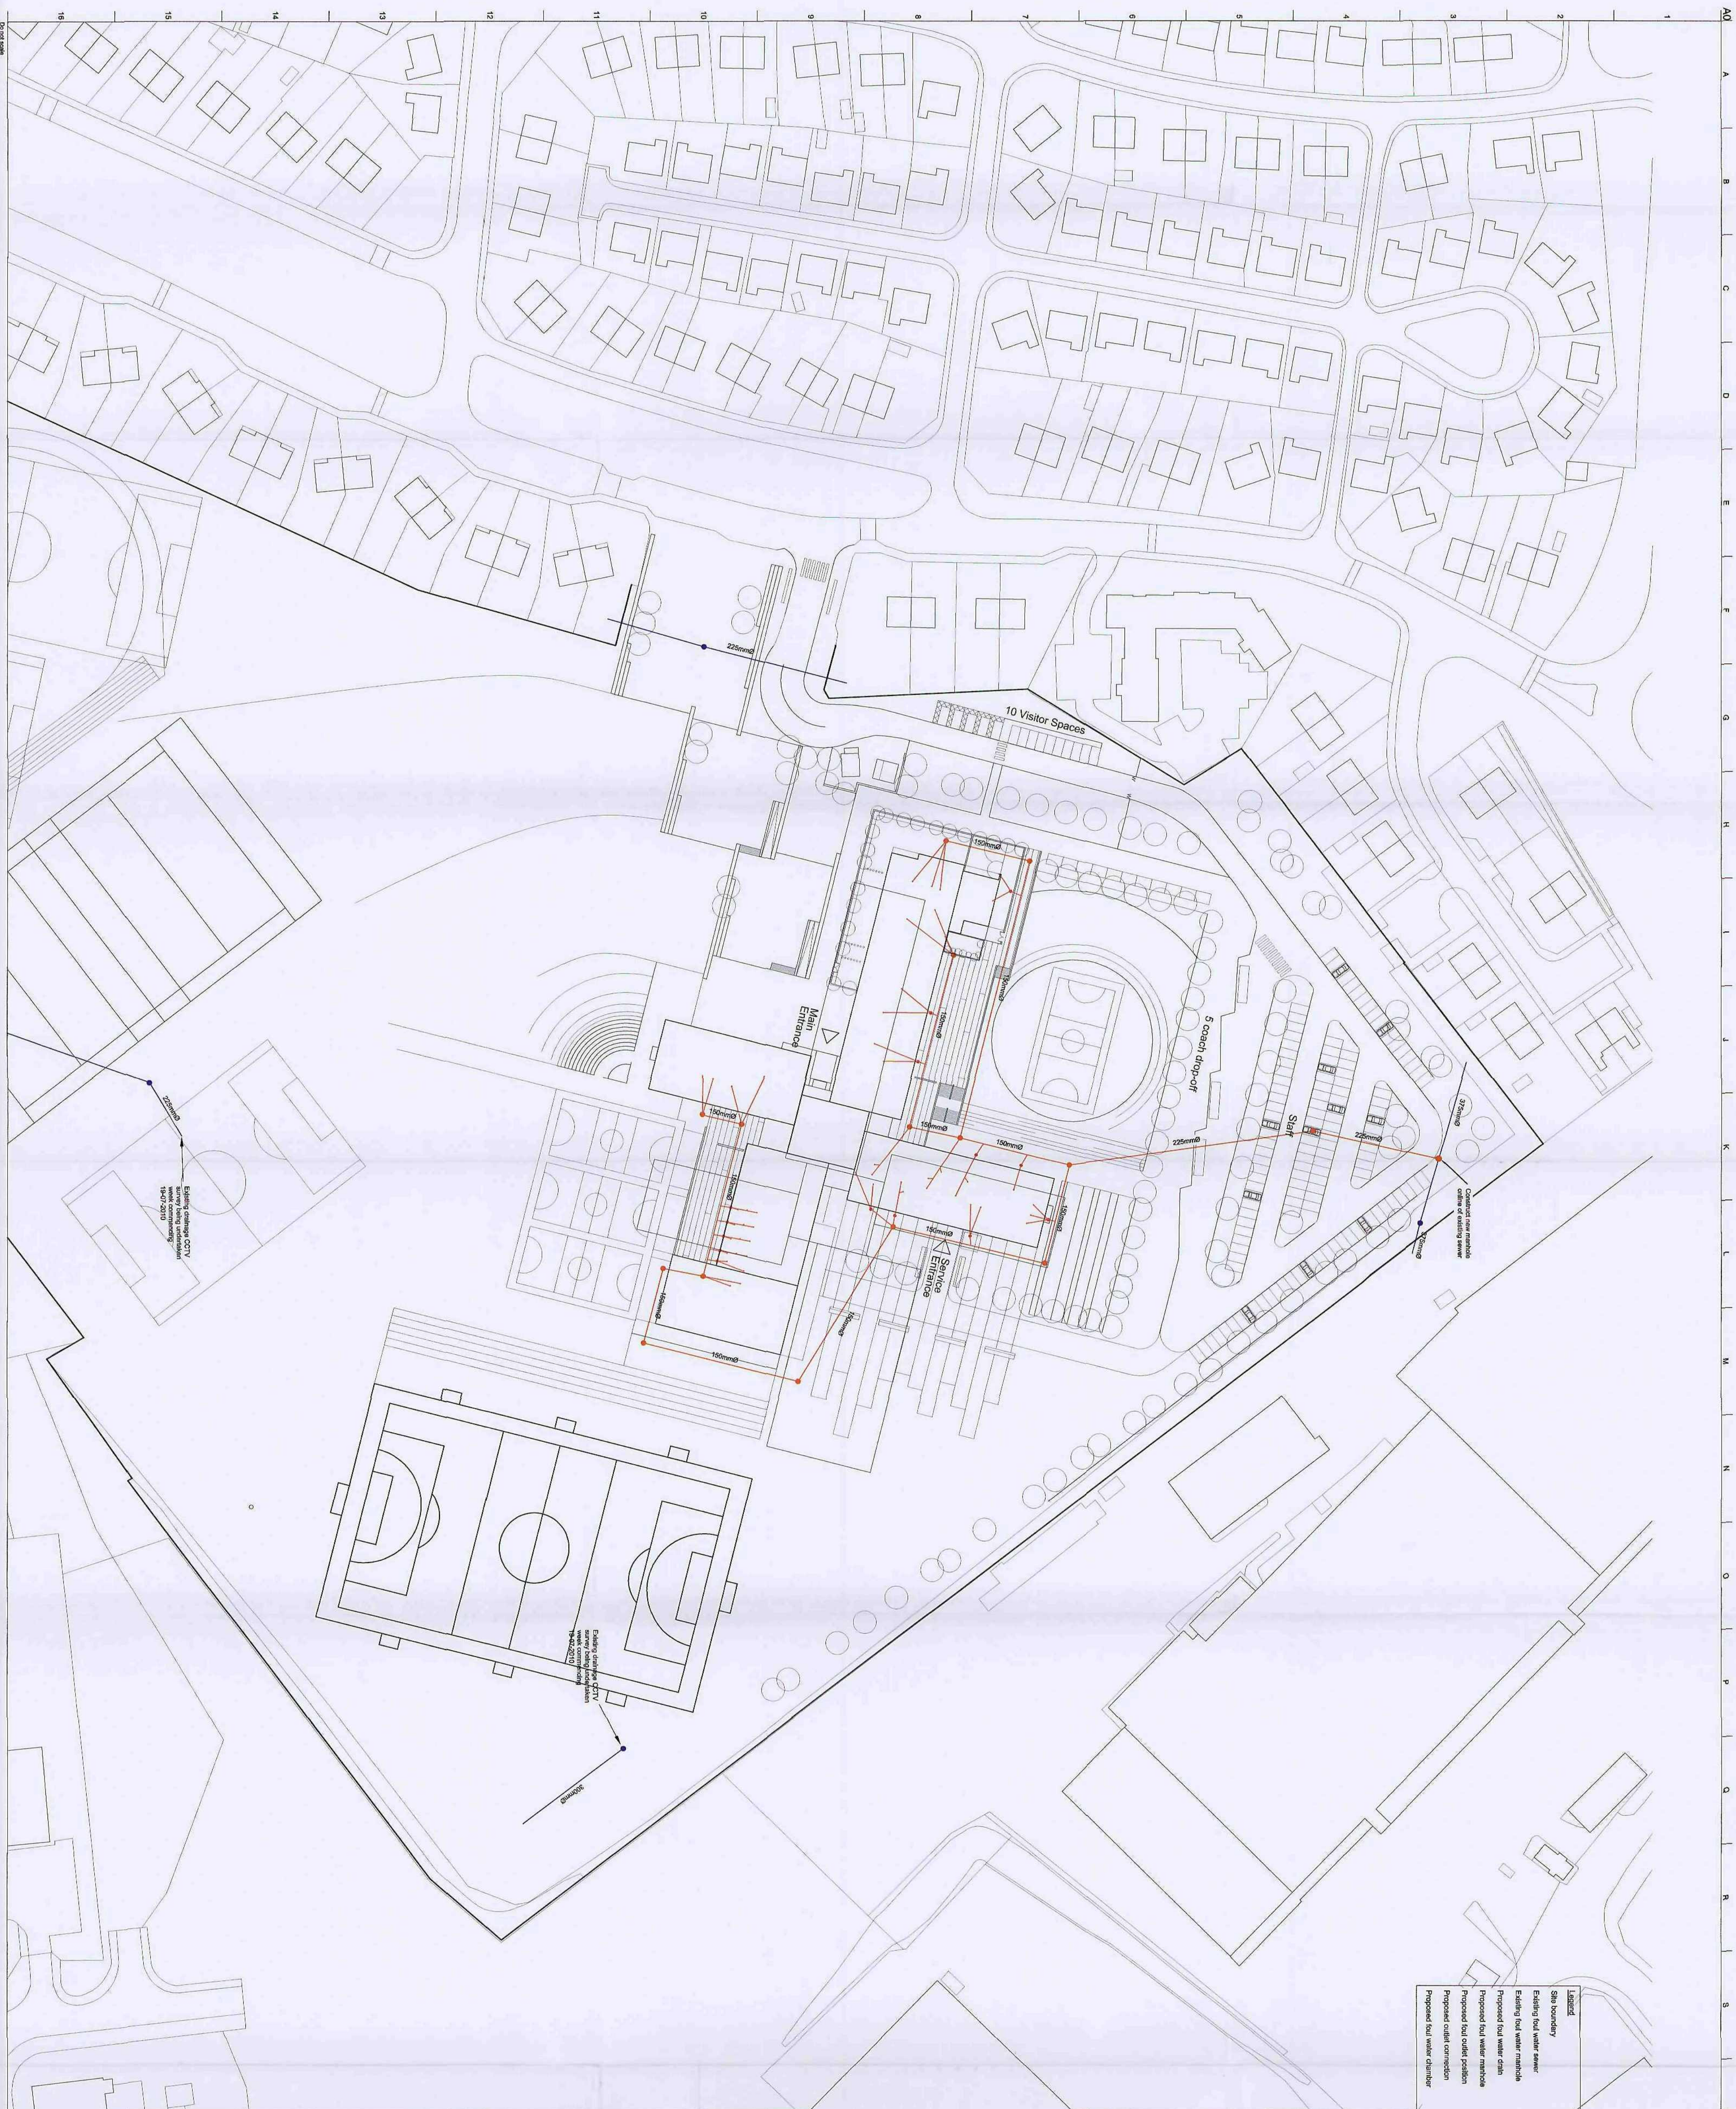

Notes


- [illegible]

ARUP

Tel: +44 (0)114 272 8247 Fax: +44 (0)114 275 9553
www.aapd.com

LAING D'ROURKE

Barnsley BSF

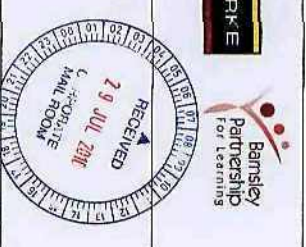

Proposed Foul Water Drainage

Discipline
Site Development

Information

212582

01	01-01-10-10-10	01-01-10-10-10
----	----------------	----------------