

 
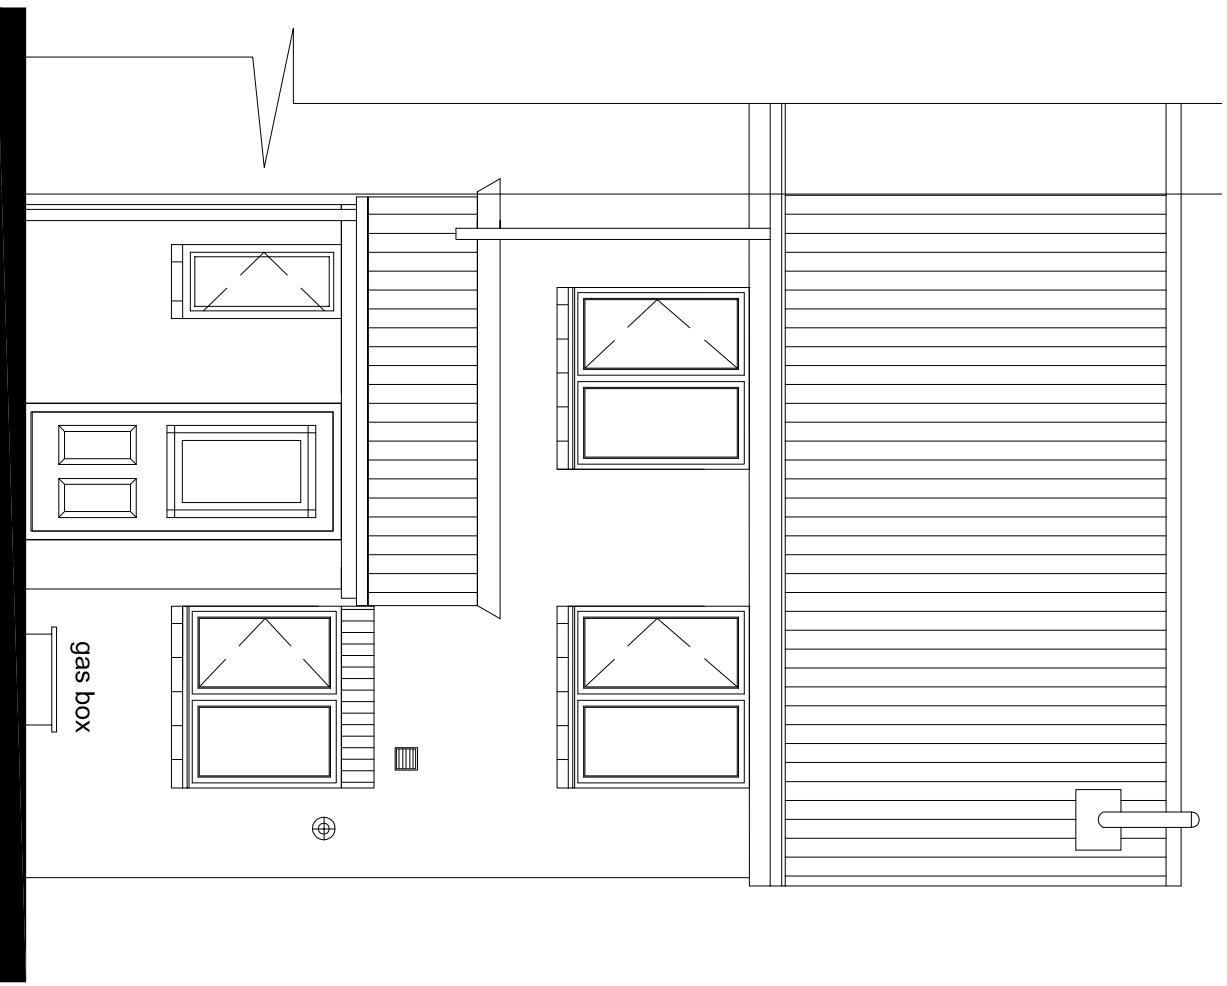


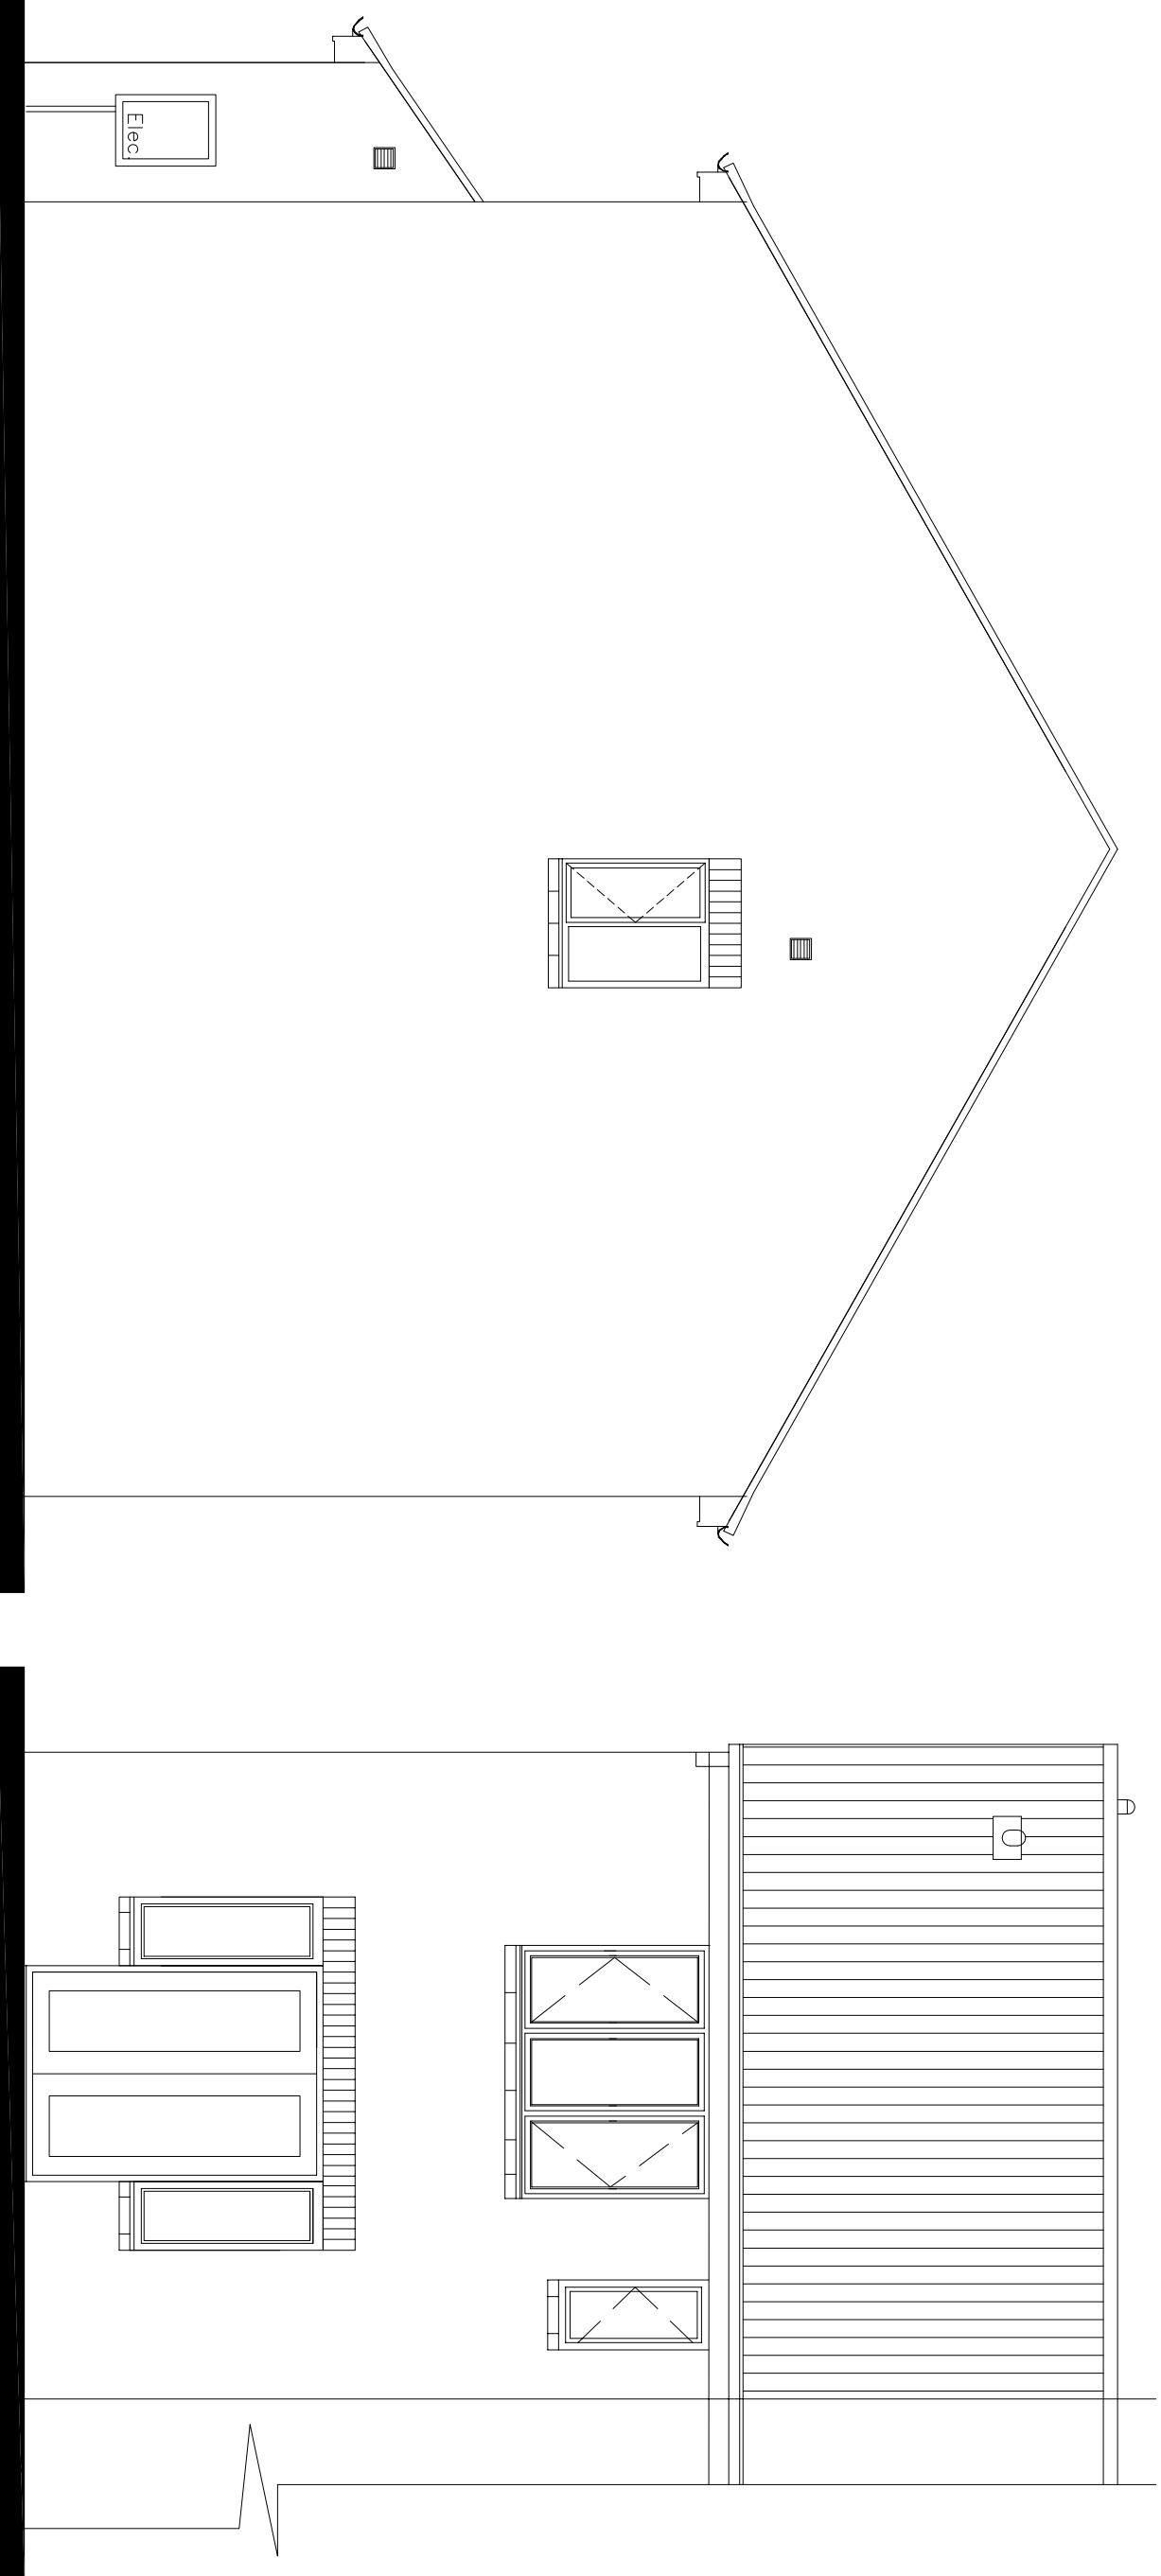

Front Elevation




Side Elevation

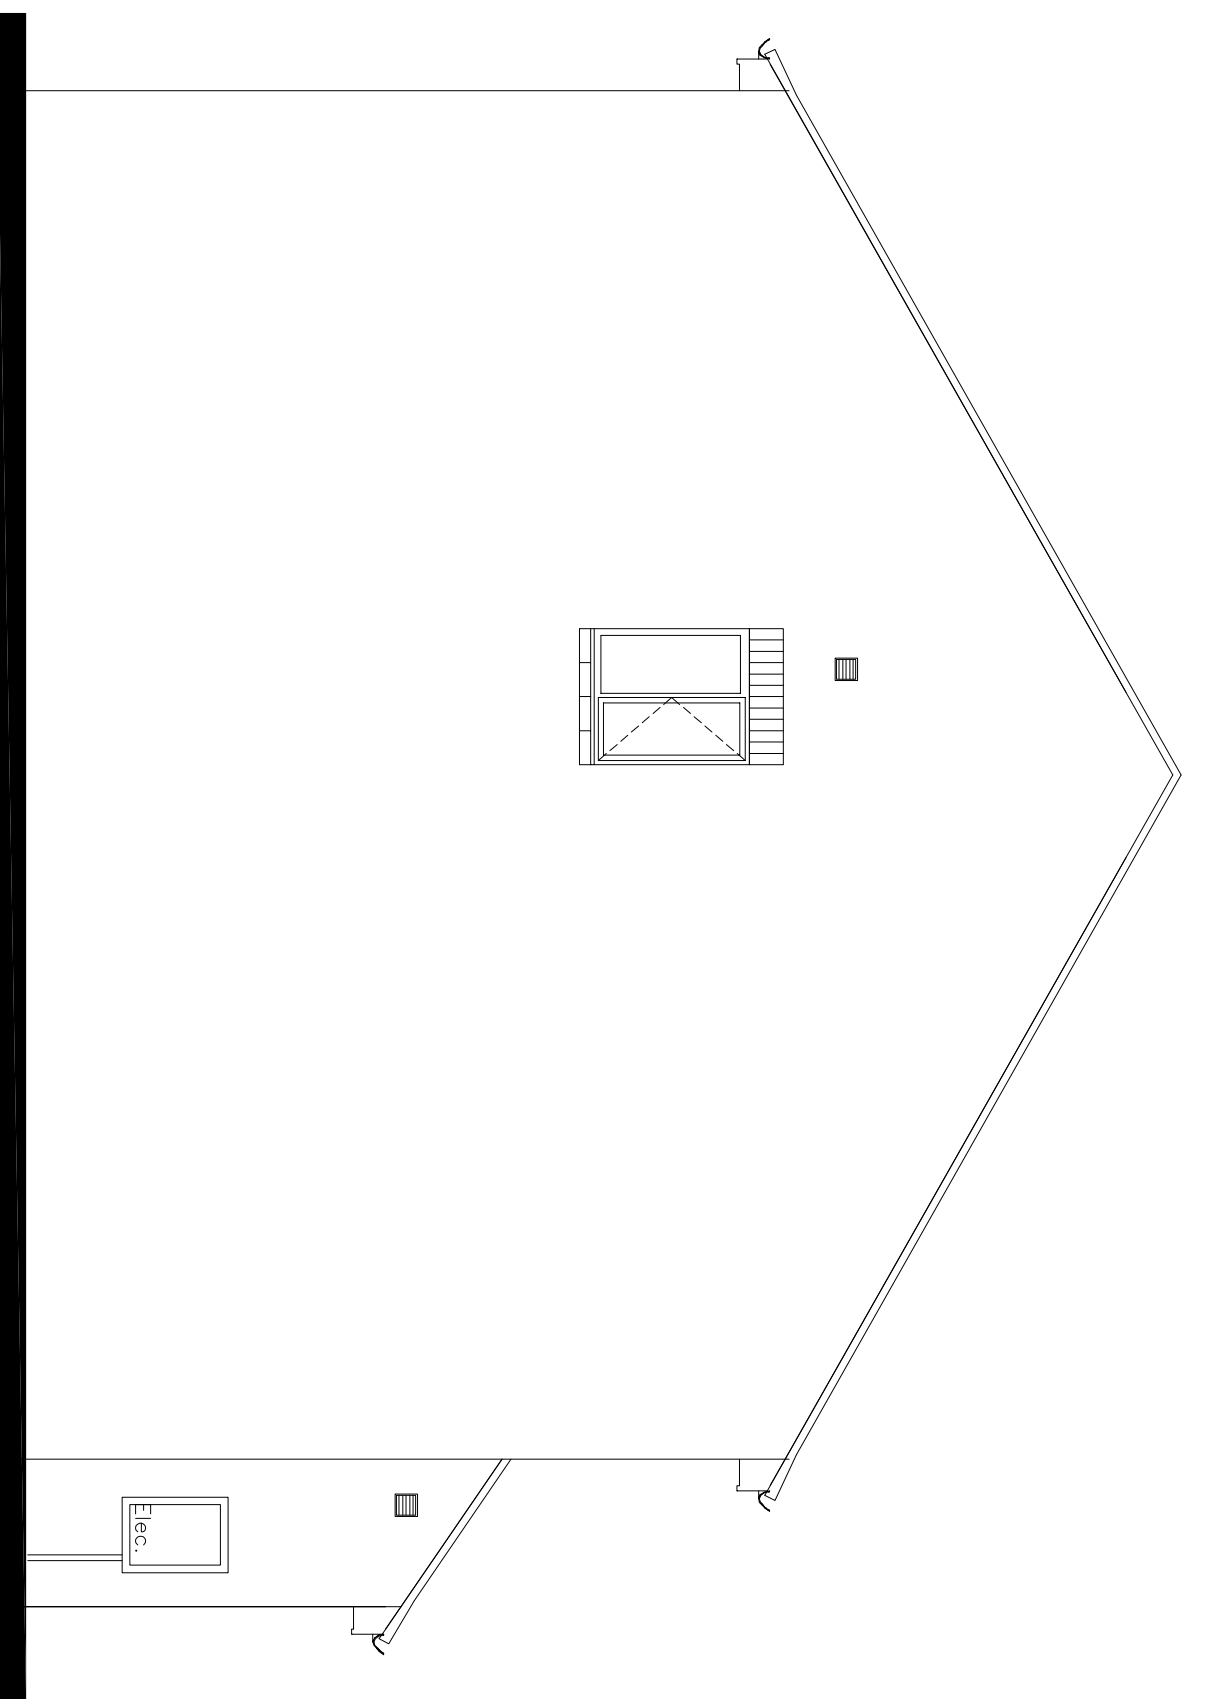


Side Elevation



Rear Elevation

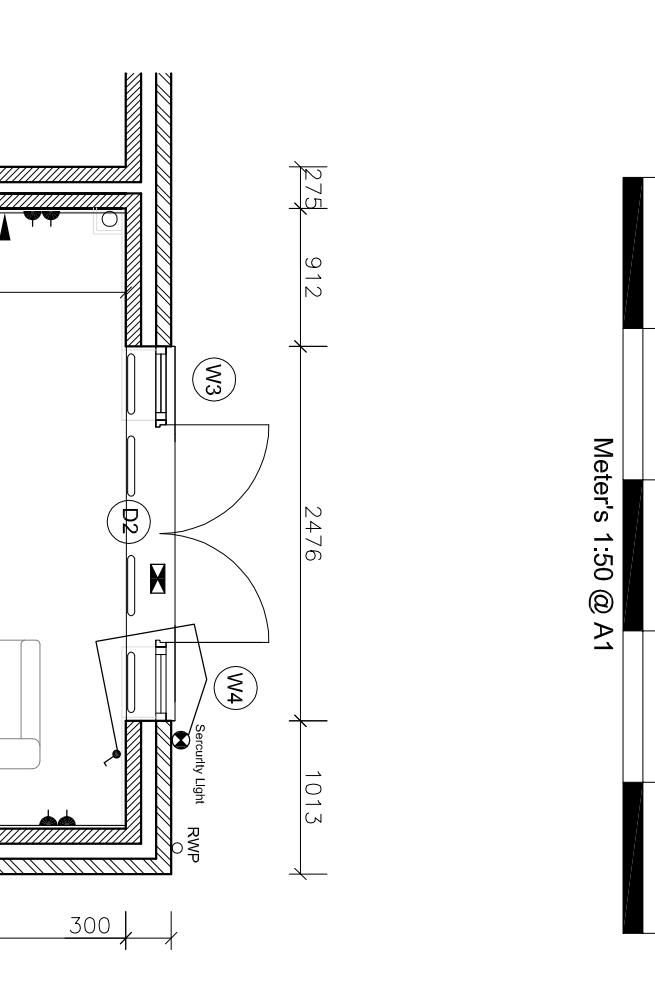


Ground Floor Plan

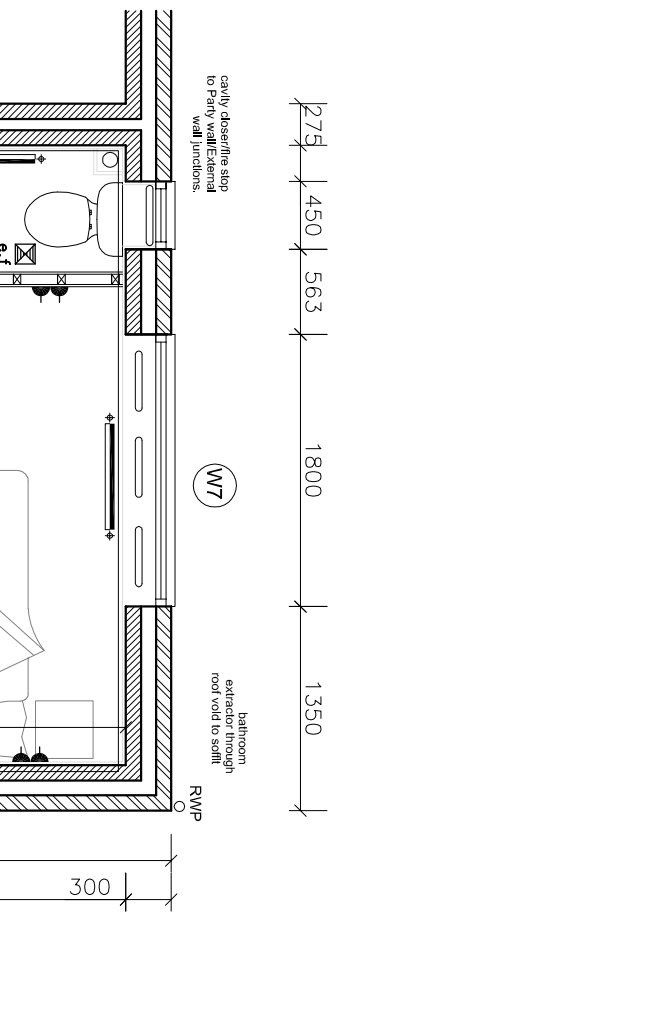

First Floor Plan

LAND OFF STATION ROAD, WOMB WELL

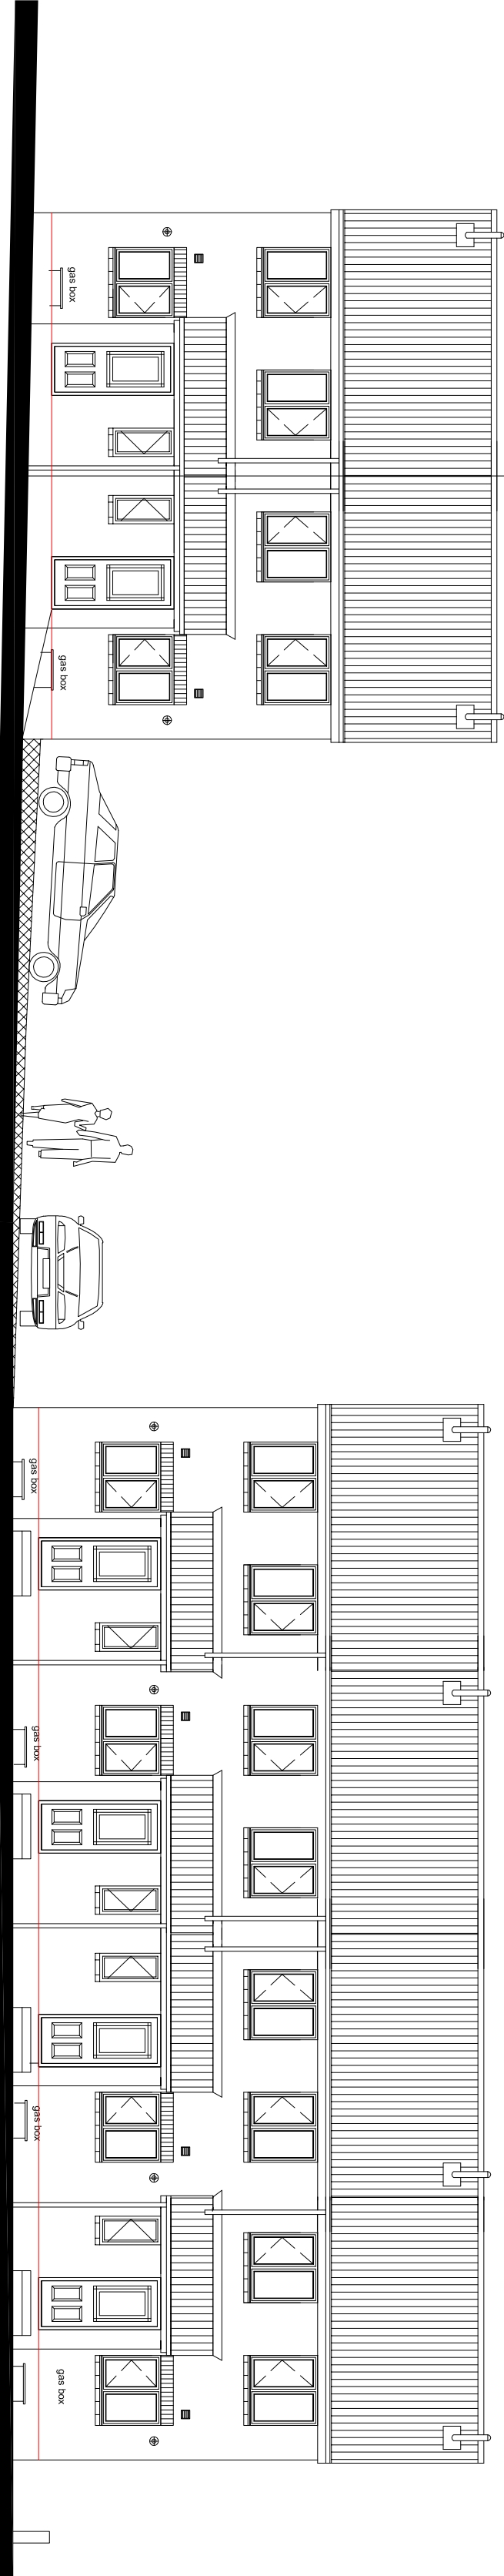

NOTES

This drawing and all the information shown is the property of DK Designs and shall not be copied whole or in part, or used for any other purpose without written permission of the Company

ALL DIMENSIONS TO BE CHECKED ON SITE
ALL SUBJECT TO STRUCTURAL ENGINEERS CHECKS AND CALCULATIONS
DO NOT SCALE FROM THIS DRAWING EXCEPT FOR THE PURPOSES OF LOCAL AUTHORITY PLANNING

IF ANY VARIATIONS ARE MADE TO SPECIFICATION/DRAWINGS WITHOUT DK DESIGNS KNOWLEDGE, DK DESIGNS WILL NOT BE HELD ACCOUNTABLE FOR NON COMPLIANCE OF PLANNING AND BUILDING REGULATIONS

DK DESIGNS
FUTURE PROJECTS TODAY

96 BLACKBURN ROAD
SHEFFIELD
S35 2ZP
TEL/FAX: 0114 2571043 MOB: 07710783875
EMAIL: DESIGN@DK-DESIGNS.CO.UK
WEB: WWW.DK-DESIGNS.CO.UK

Client: White Rose Homes Ltd

Project Title: Station Road, Wombwell
House Type: Floor Plans and Elevations

Scale:	Date:
1:100 1:50	Dec 13
Drawing Number:	Revision:
2013-76-04	A.

DOOR	SCHEDULE	TRICKLE VENT
Ref.	LOCATION	DOOR SIZE (w x h)
D01	Hall	1000 x 2100 (Opening)
D02	Lounge	1500 x 2100 (Bmk Opening) (French Doors)
D03	WC/Kitchen	838 x 1981
D04	Kitchen/Cupd	762 x 1981 (Cut to Sillie)
D05	Lounge/Kitchen	838 x 1981
D06	Lounge/Bedroom	762 x 1981
D07	Bedroom/Ensuite	886 x 1981
D08	Bedroom	886 x 1981
D09	Landing Bedroom	762 x 1981
D10	Landing Bedroom	762 x 1981

WINDOW SCHEDULE	TRICKLE VENT
Win Ref.	LOCATION
W01	WC
W02	Kitchen
W03	Lounge
W04	Lounge
W05	Bedroom
W06	Bedroom
W07	Bedroom
W08	Bathroom

TRICKLE VENT	TRICKLE VENT
W01	488 x 1050
W02	1200 x 1050
W03	488 x 1350
W04	488 x 1350
W05	1200 x 1200
W06	1200 x 1200
W07	1800 x 1200
W08	900 x 1050

Trickle Vent Requirements - 70m2 3 bed = 50,000

TRICKLE VENT	TRICKLE VENT
W01	488 x 1050
W02	1200 x 1050
W03	488 x 1350
W04	488 x 1350
W05	1200 x 1200
W06	1200 x 1200
W07	1800 x 1200
W08	900 x 1050

TRICKLE VENT	TRICKLE VENT
W01	488 x 1050
W02	1200 x 1050
W03	488 x 1350
W04	488 x 1350
W05	1200 x 1200
W06	1200 x 1200
W07	1800 x 1200
W08	900 x 1050

ELECTRICAL AND HEATING SYMBOLS	HEATING SYMBOLS
⊗ Ceiling light point.	⊕ Consumer Unit at 2.00m above floor.
⊕ Bulk head light.	⊖ Thermostat, 1000mm above floor.
⊕ External Lantern	⊕ Shower unit
⊕ Spot Light	⊕ Gas or 3/220V Detector
⊕ Switch. (All switches 1000mm above floor)	⊕ Separately fused circuit
⊕ Two way switch.	⊕ Gas outlet point.
⊕ Ceiling pull chord switch.	⊕ Control heating control unit
⊕ 13 Amp socket, 450mm min. above floor.	⊕ Heat Detector
⊕ 13 Amp socket, 1000mm above floor.	⊕ Mechanical extract fan
⊕ 13 Amp fused spur, 1000mm above floor.	⊕ External alarm box of escape level
⊕ 13 Amp fused spur for Cooler Extract Hood	⊕ Alarm Control Unit
⊕ 220V above floor for Cooler Extract Hood	⊕ Door Infrared entry sensor
⊕ Telephone jack socket, 1000mm high	⊕ PIR Alarm Sensor
⊕ Telephone jack socket.	⊕ Under wall unit lighting (Tilted) with switch located 1000mm above floor.
⊕ Cooler panel with 13 Amp socket	

SUBJECT TO BUILDING REGS APPROVAL

SUBJECT TO BUILDING REGS APPROVAL

Note:- All subject to Structural Engineers Calculations