



Rev	Revision Note	Date	Drawn by	Approved
1-0	Original drawing	05/04/11	AS	KB
1-1	Duct details amended	29/03/12	AS	MS
1-2	Wording of sub station stamp amended	10/09/14	SW	MS

FOR FULL BASE DETAIL PLEASE
REFER TO GTC SUBSTATION
DRAWING GTC-E-SS-001X AND
SUBSTATION DOCUMENT
GE-TGI-IG-0032

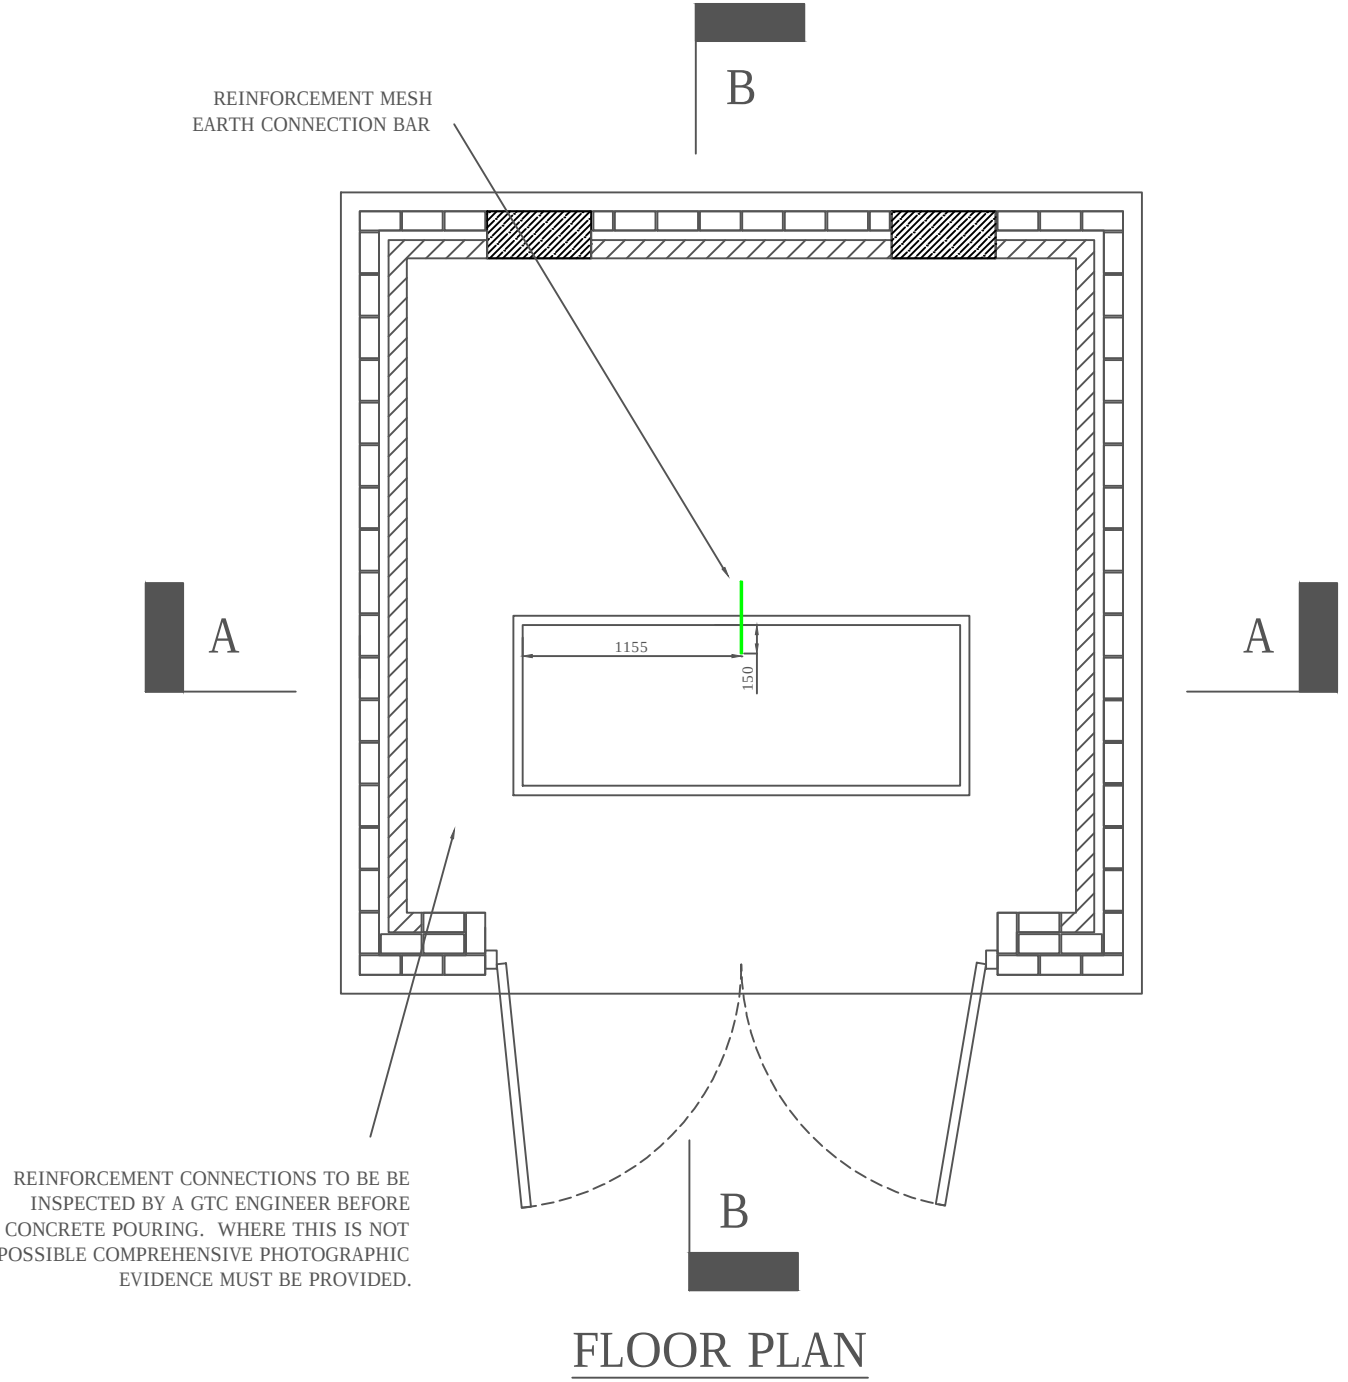


FLOOR PLAN

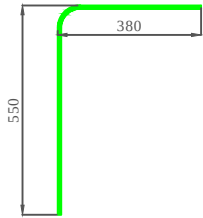

REINFORCING MESH EARTH CONNECTION BAR
H10 "L" BAR, 900mm LONG, TO BE WELDED TO
REINFORCING MESH TO MAINTAIN MINIMUM
200mm FROM TOP OF FOUNDATION.

THIS DRAWING IS TO BE READ IN
CONJUNCTION WITH DRAWING
GTC-E-EA-0001 OR GTC-E-EA-0002

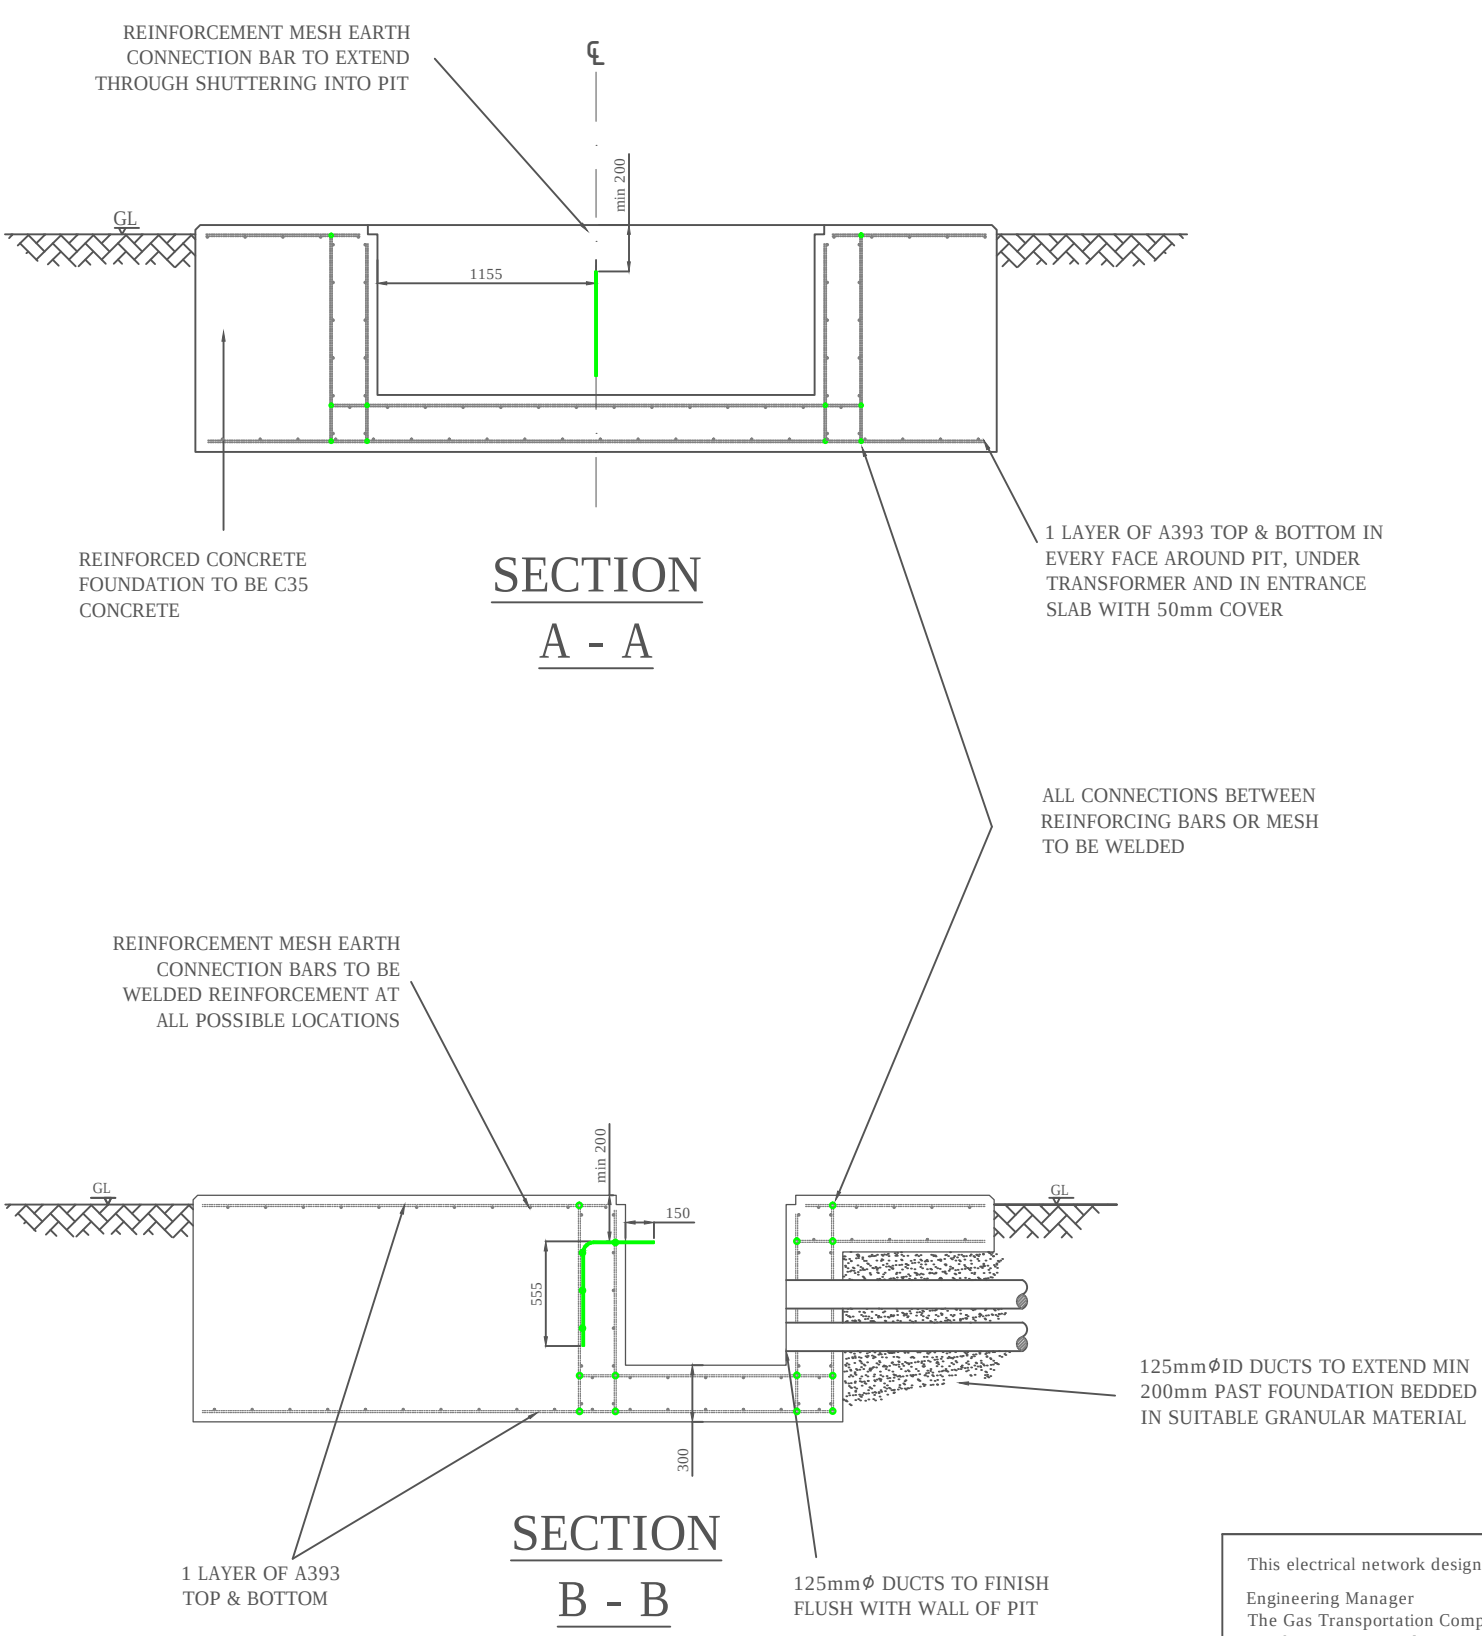

SECTION
A - A

SECTION
B - B

APPROVED FOR
CONSTRUCTION

This electrical network design has been carried out by :
Engineering Manager
The Gas Transportation Company Ltd Tel : 01359 240363
Woolpit Business Park Fax : 01359 244398
Bury St Edmunds www.gtc-uk.co.uk
Suffolk
IP30 9UP

All cables and equipment used on this design are to be in accordance with G81 standards. © Electricity Networks Company Ltd

Drawing Scale : NOT TO SCALE
O.S.REF : N/A

enc
the electricity network co.

Drawing Number : GTC-E-EA-0003_R1-2

Description : REINFORCEING MESH EARTH
CONNECTION BAR LAYOUT

SHEET
SIZE A2