


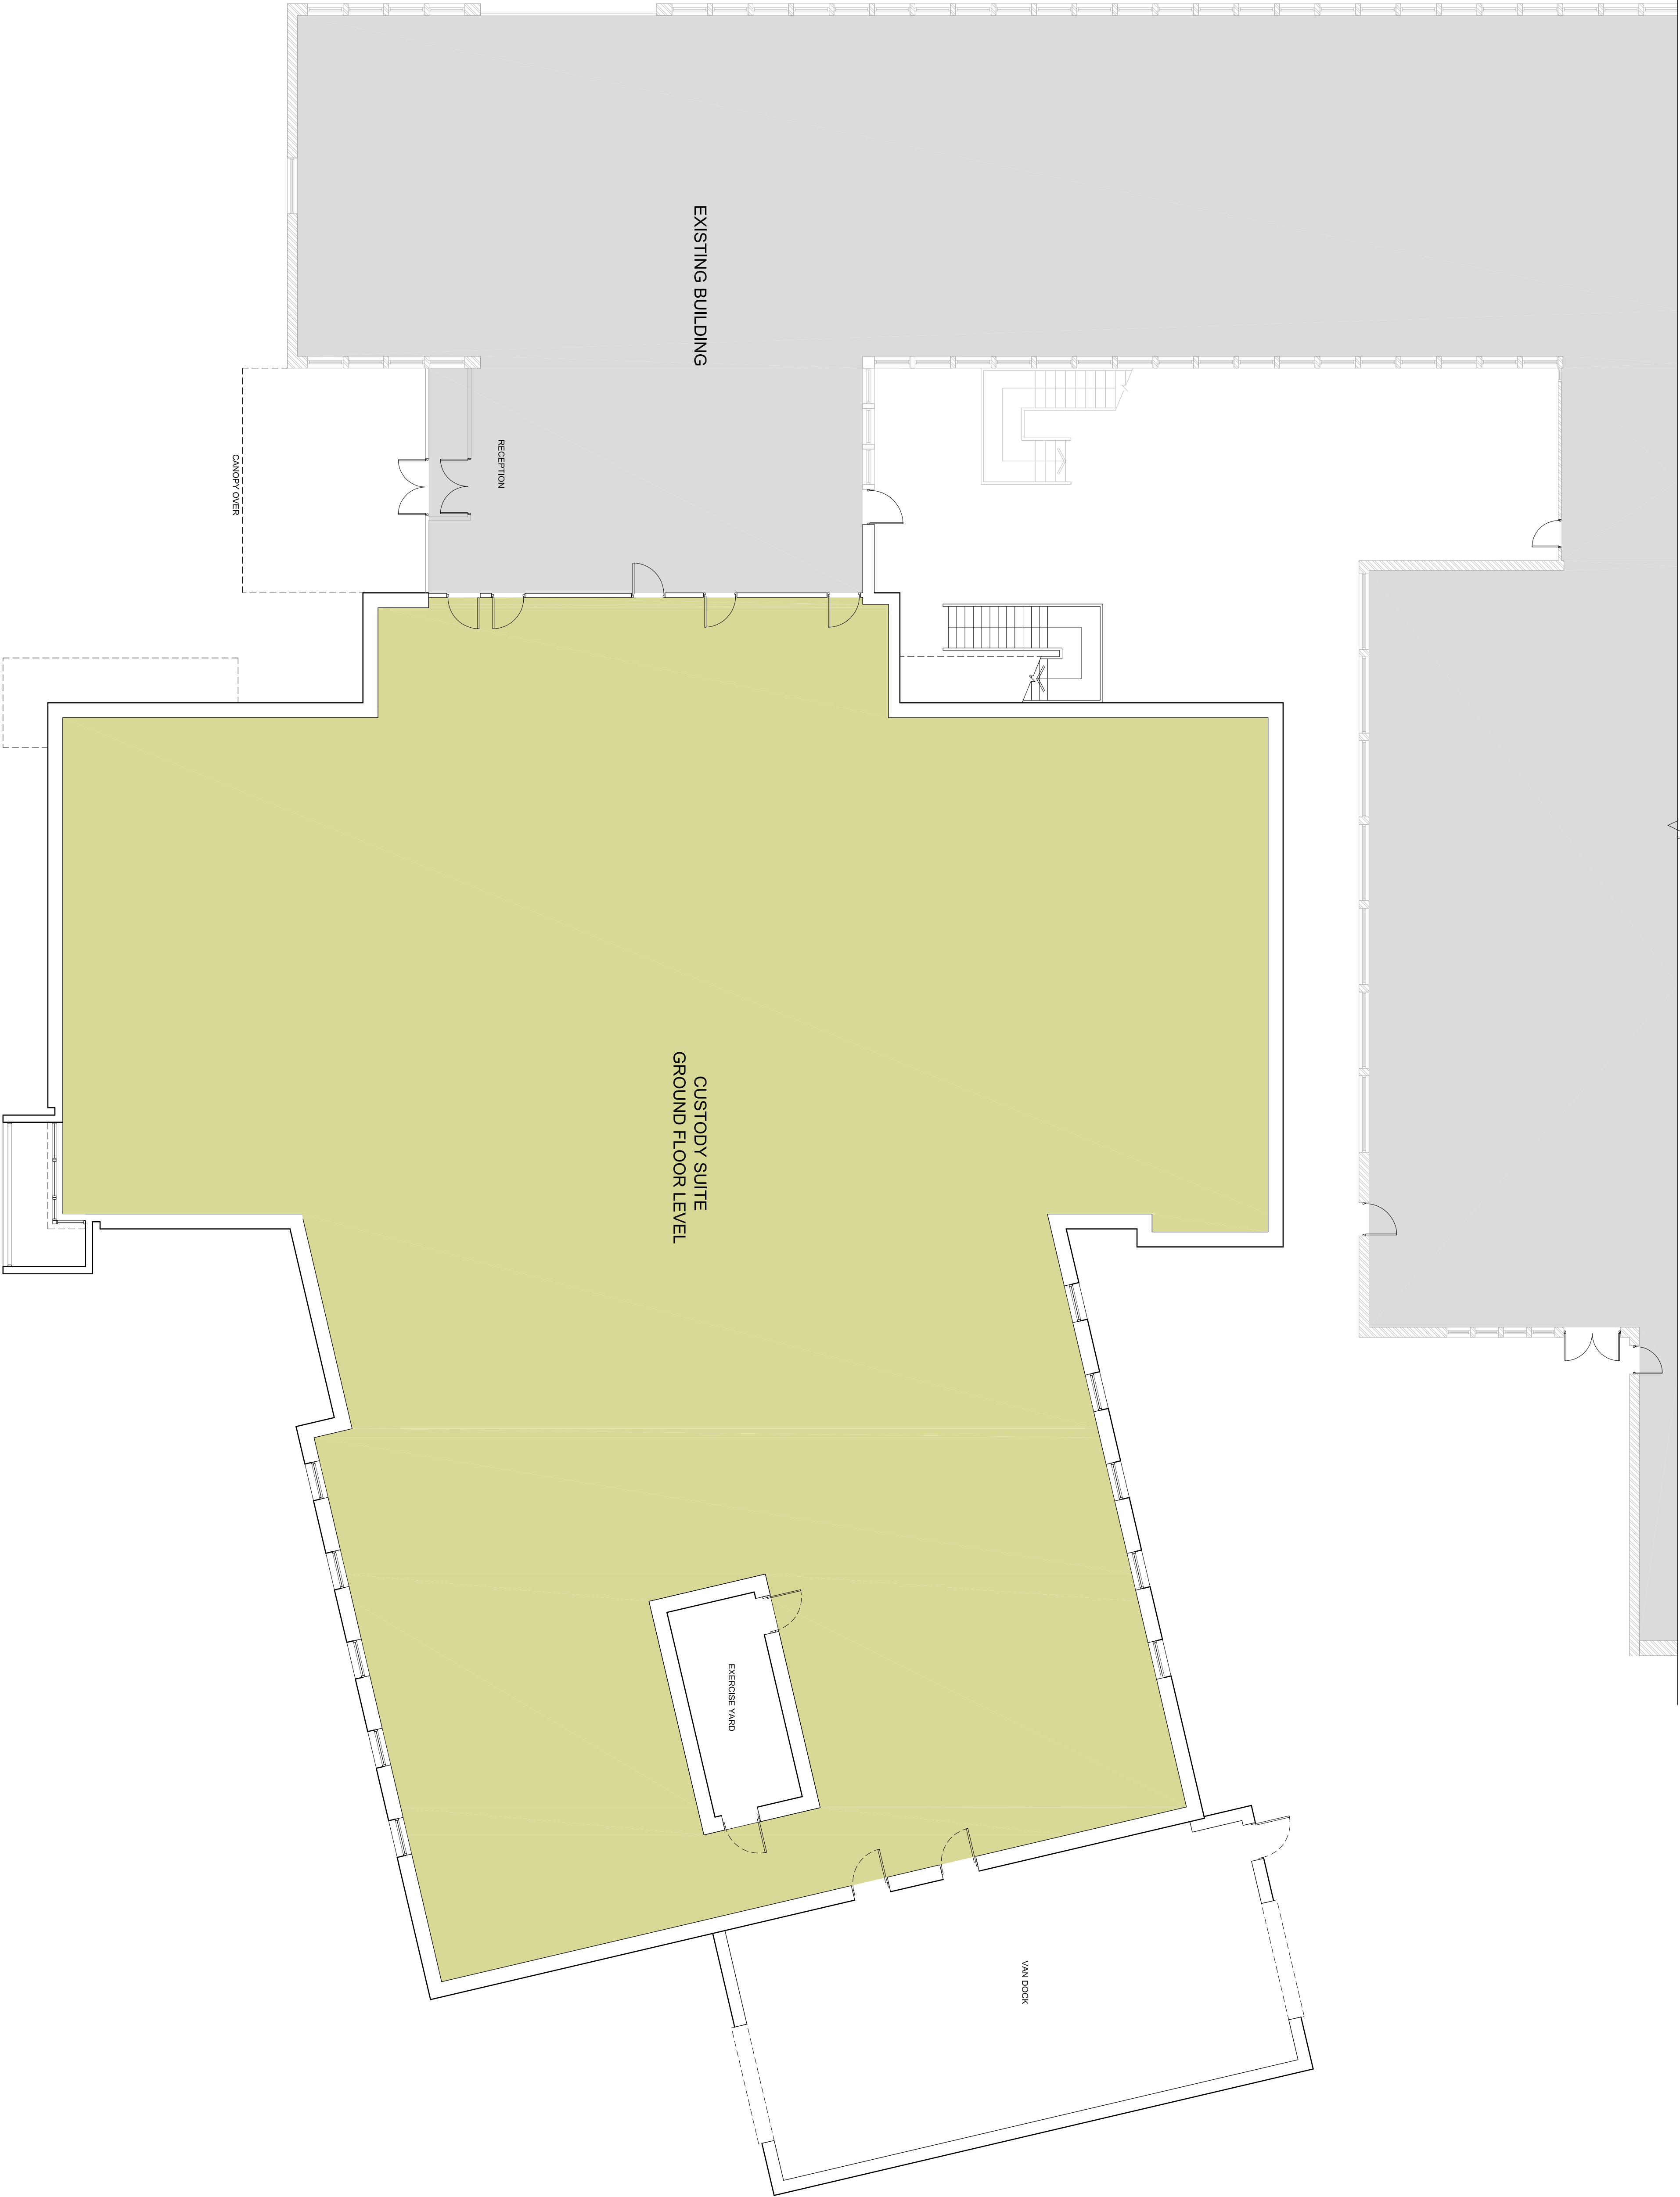

- 11.08.14 Planning Issue.			
Rev.	Date	Details	VG SC
Issued for:			Drawn checked

PLANNING

Project/Client:	Project No:
South Yorkshire Police	IABR 13003900
Dwg No:	113
Rev:	-

Drawing:	Scale:
Ground Floor Plan	1:100 @A1
Without Internal Layout	Drawn By: VG Date: 04.09.14
	Checked By: SC Date: 04.09.14

ARCHIAL | NORR