




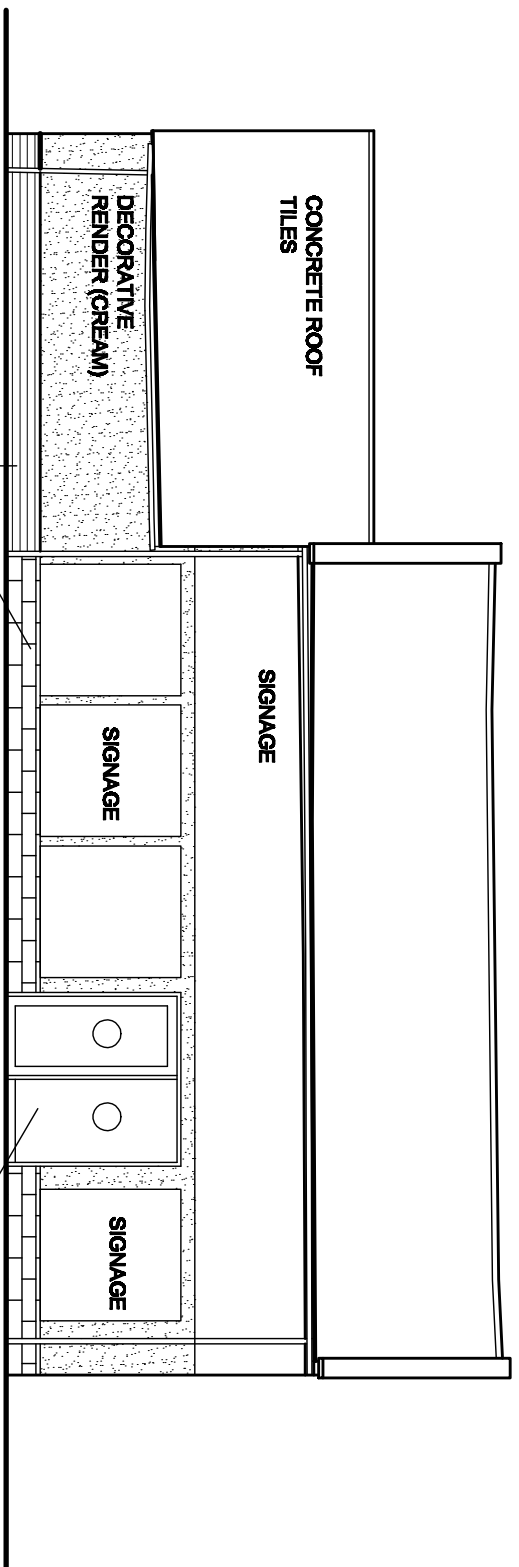


SE ELEVATION

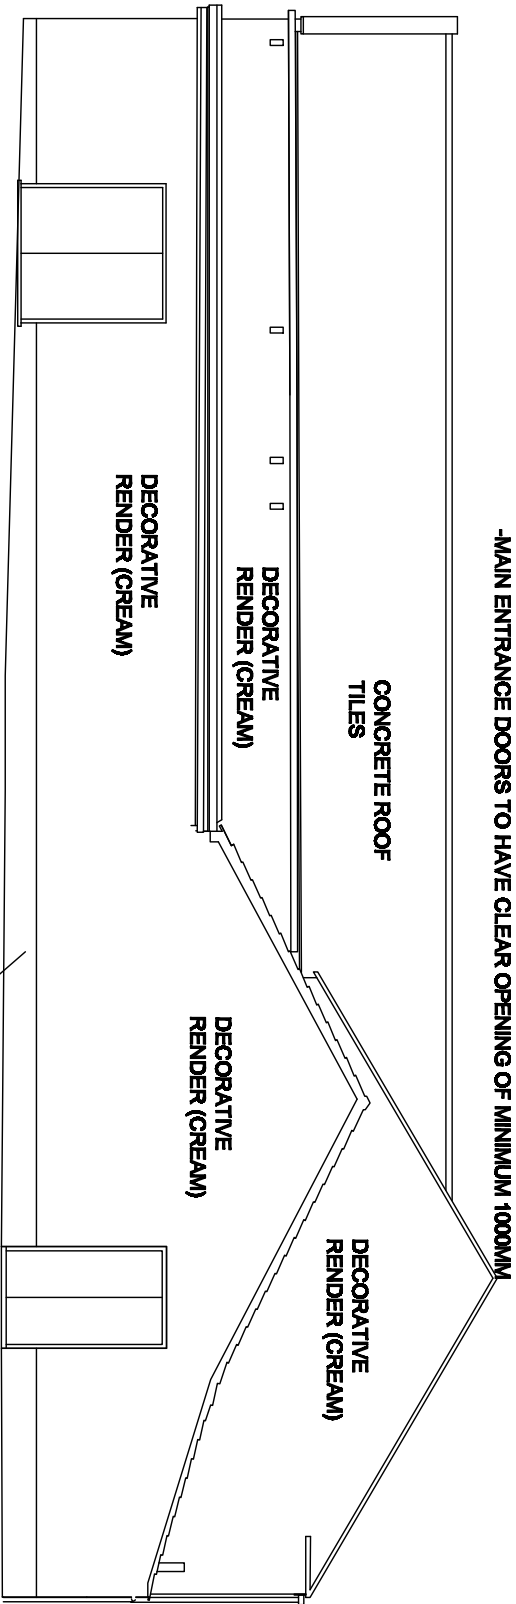


SW ELEVATION

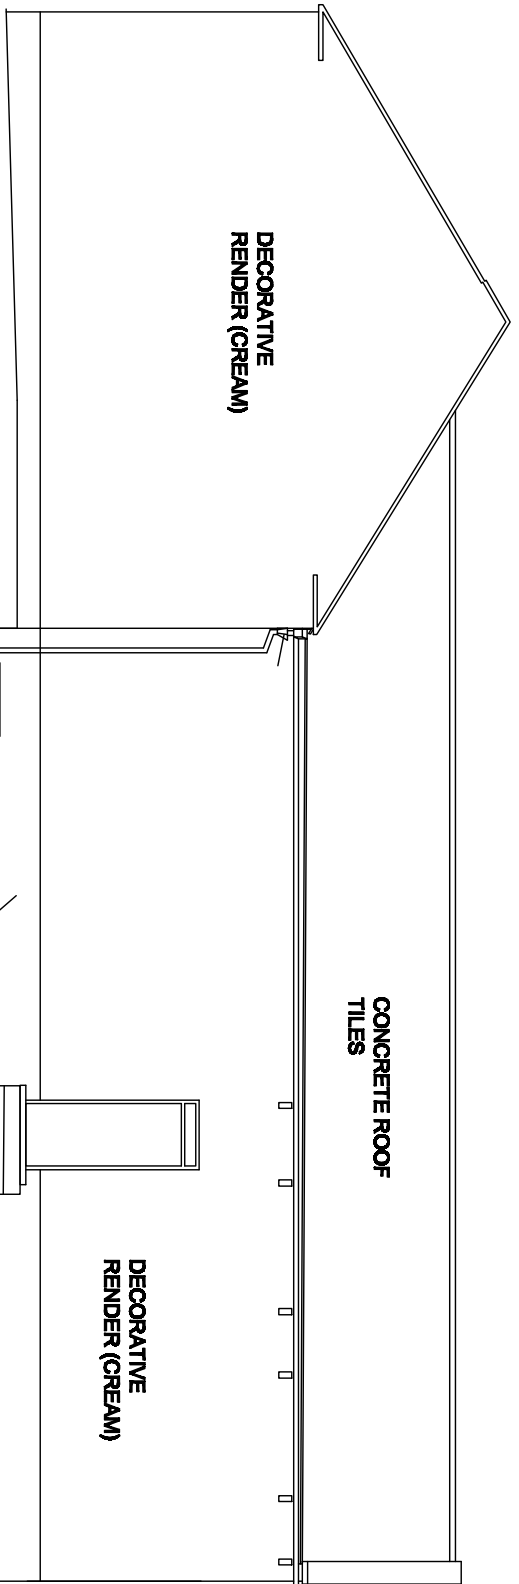

NE ELEVATION

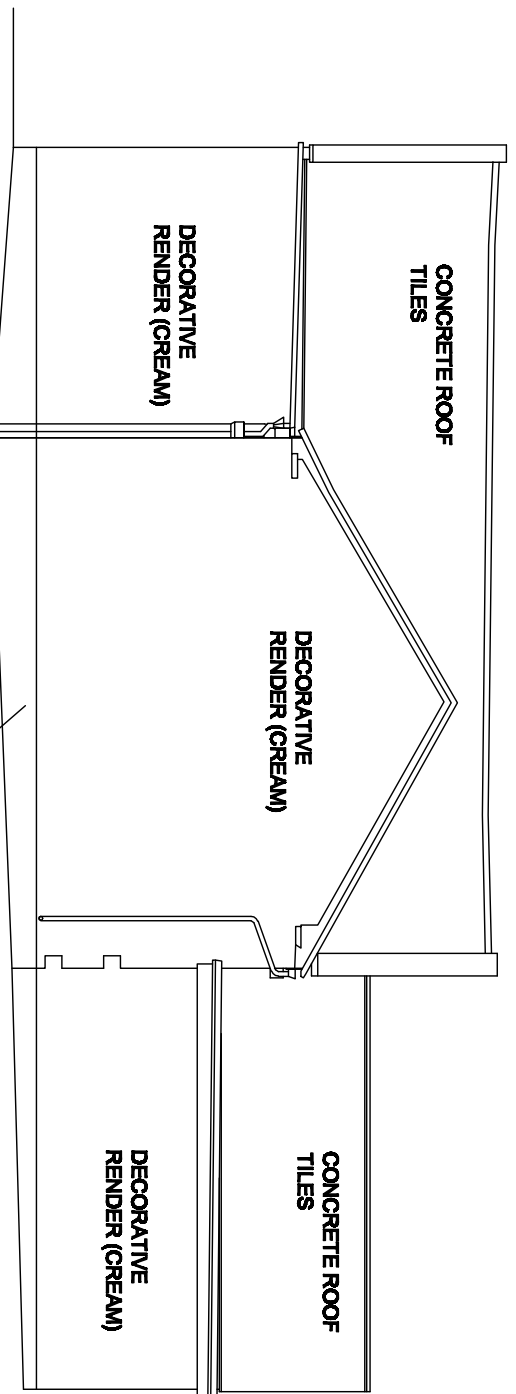


NW ELEVATION

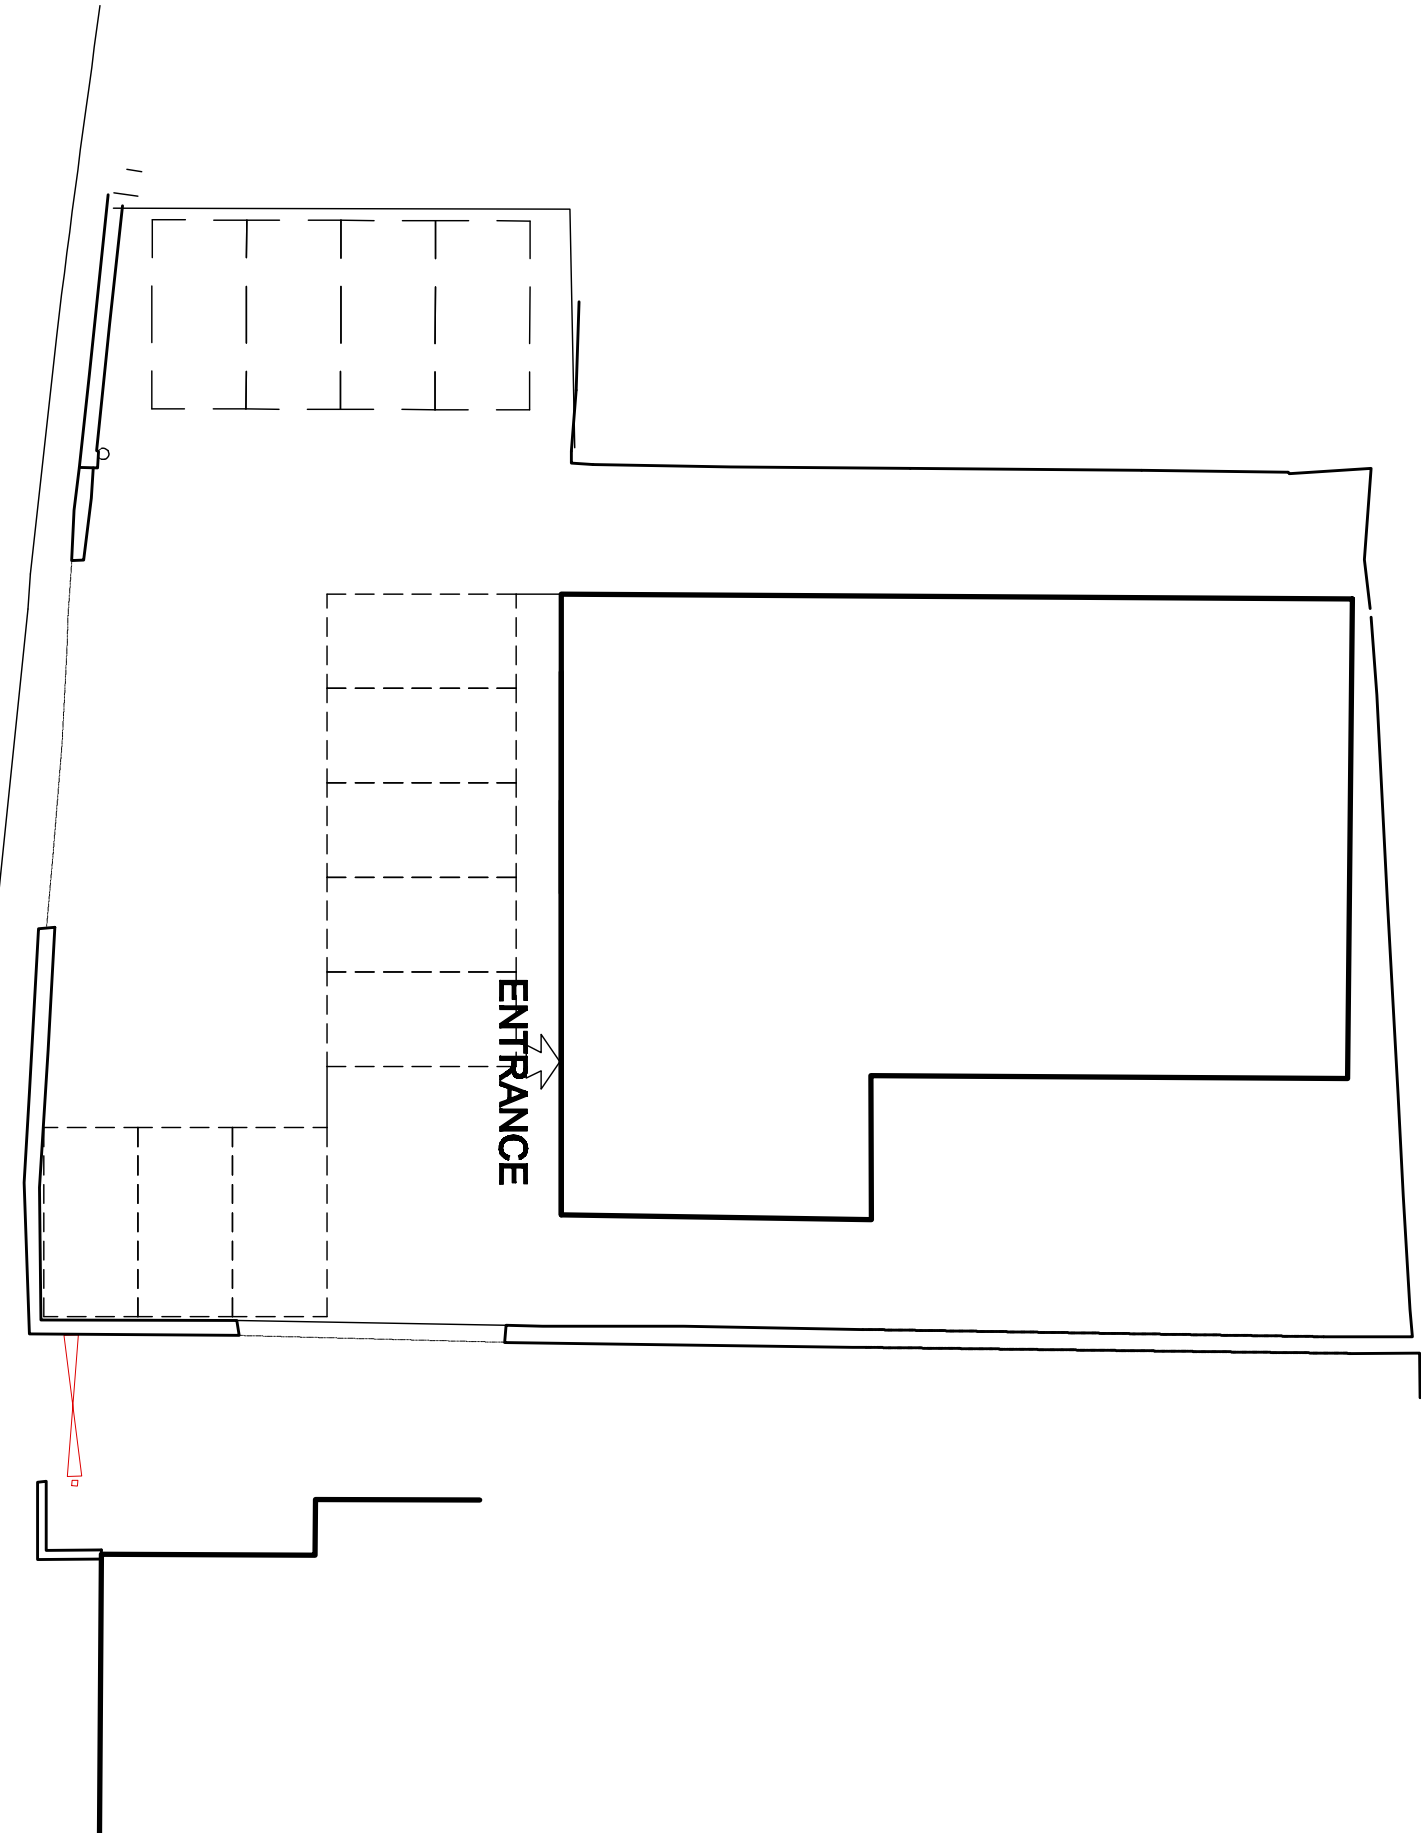


SITE PLAN

SCALE 1:200

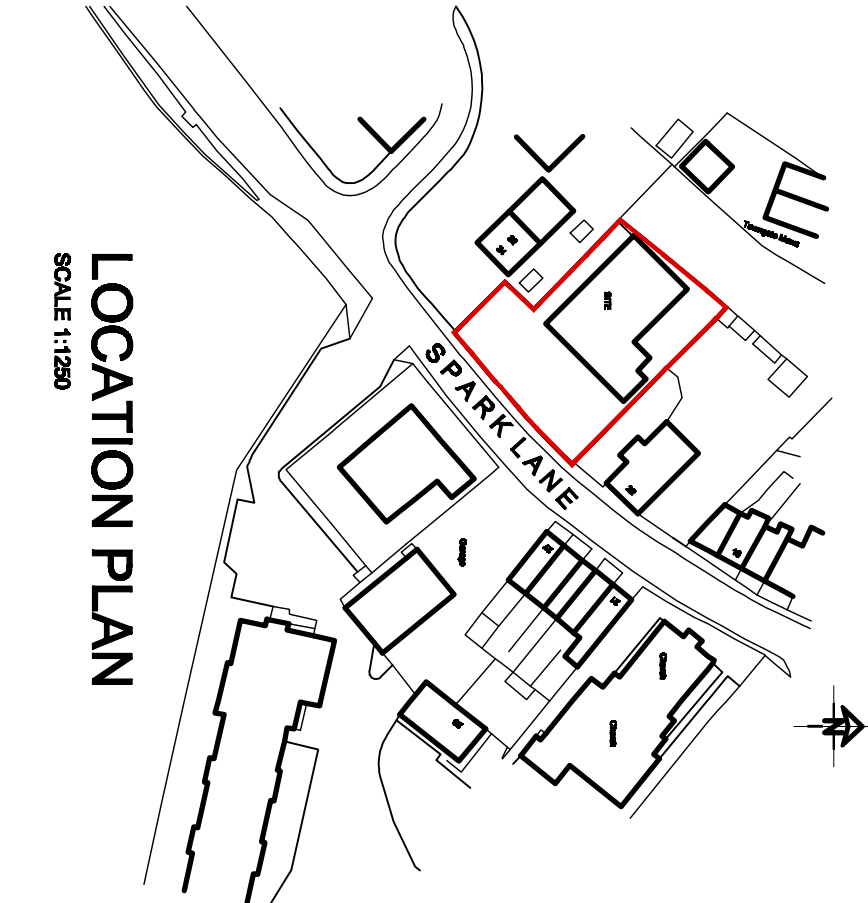


LOCATION PLAN

SCALE 1:1200

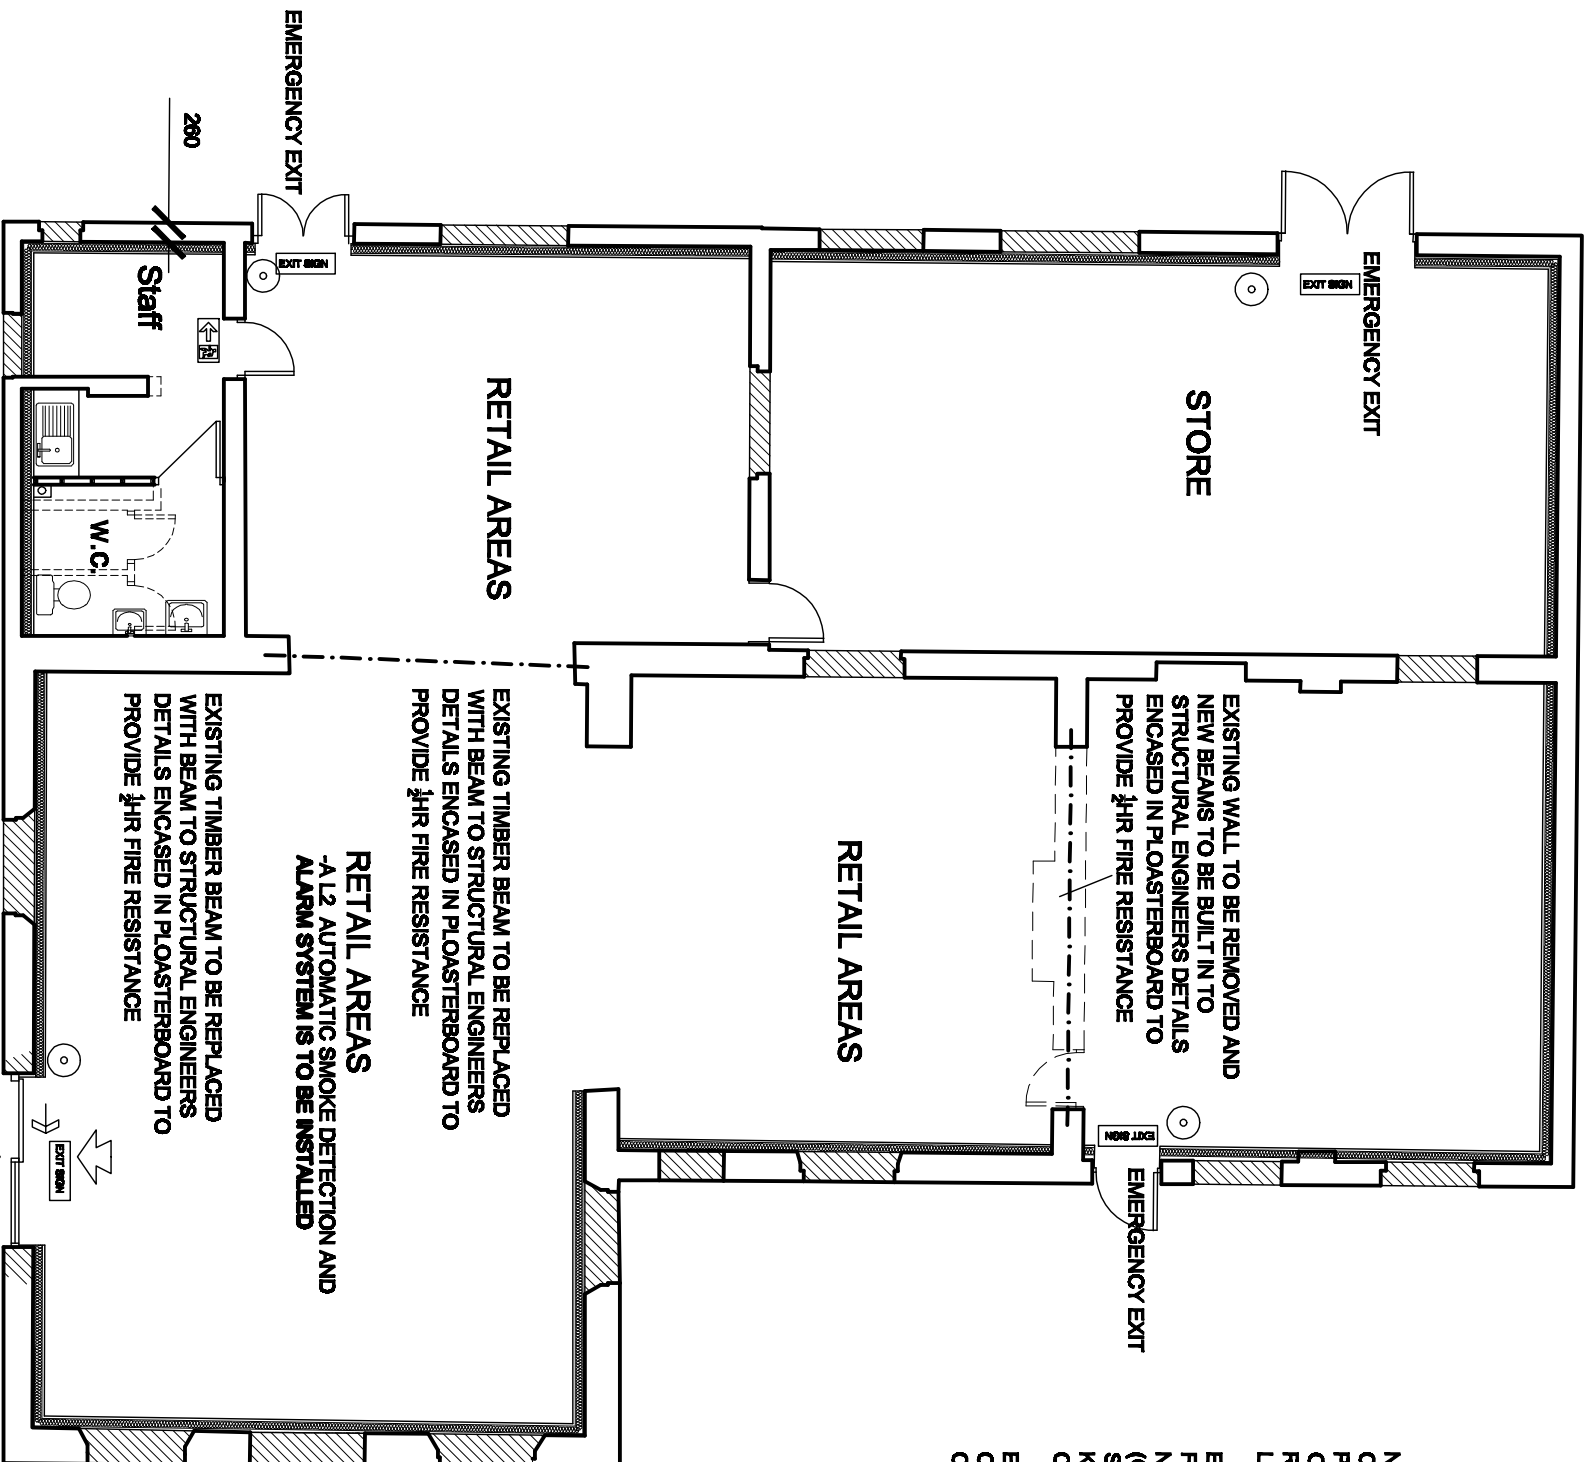

PLAN AS PROPOSED

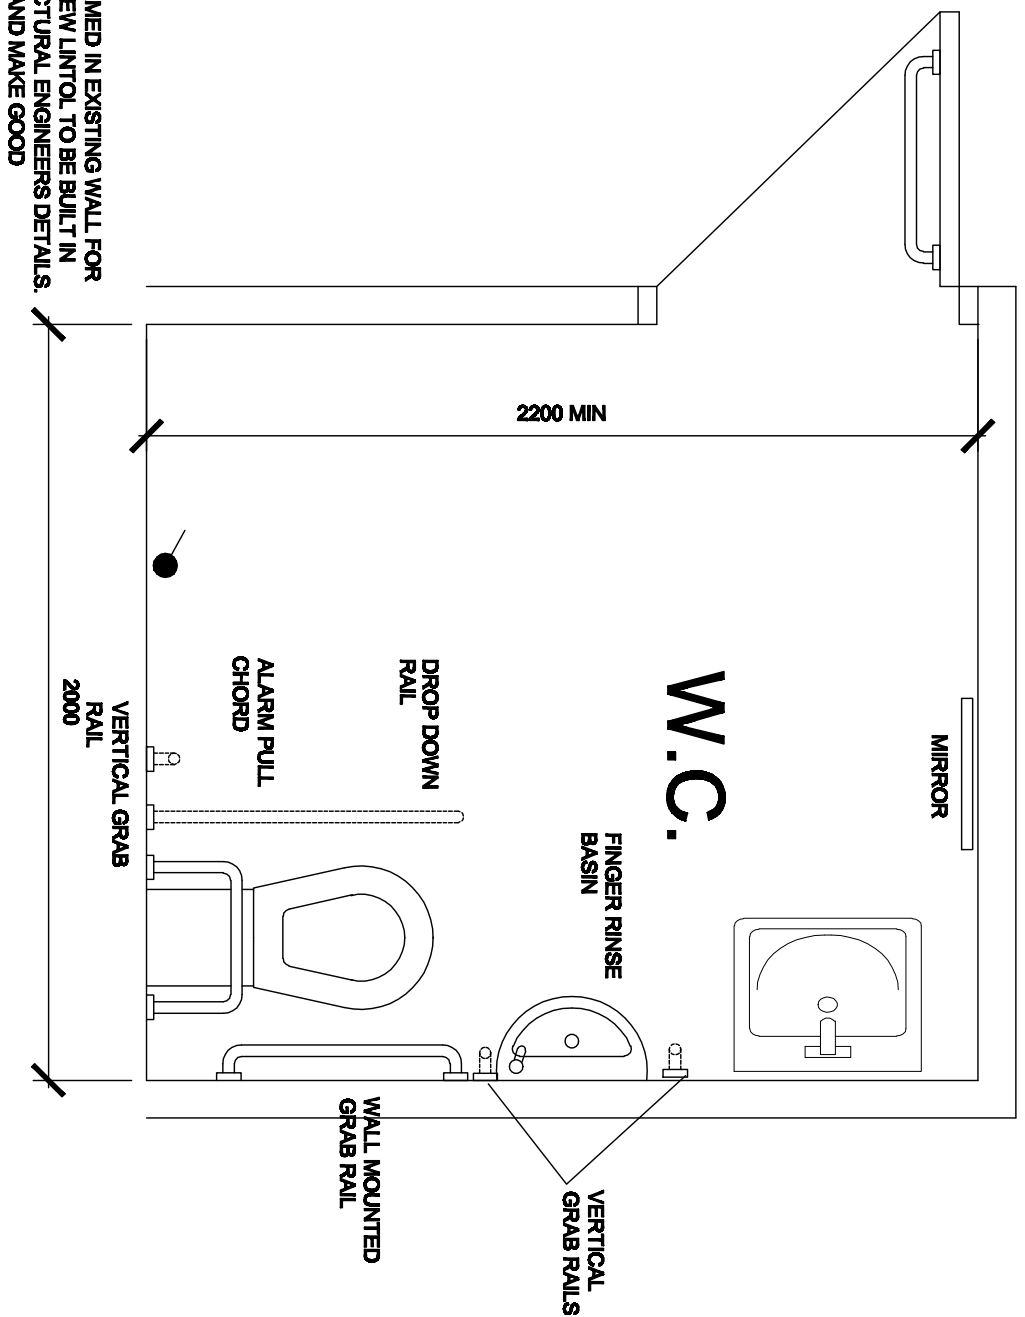

TOILET LAYOUT

THE SANITARYWARE, FITTINGS AND FIXTURES TO THE W.C. SHALL BE INSTALLED IN ACCORDANCE WITH DIAGRAM 18 TO PART M OF THE BUILDING REGULATIONS

- DIRECTIONAL RUNNING MAN /**
EXIT SIGNS TO SITE
POINT
- EMERGENCY LIGHTING TO COMPLY WITH B.S. 5268: PART 1: 1988.
 - EXIT SIGNAGE TO COMPLY WITH B.S. 5468: PART 1: 1980.
 - DETAILS OF EMERGENCY LIGHTING AND FIRE ALARM SYSTEM TO BE SUBMITTED TO B.C.O. APPROVAL BEFORE INSTALLATION COMMENCE ON SITE
 - **DETAILS OF HEATING INSTALLATION TO BE SUBMITTED TO L.A. FOR APPROVAL MINIMUM 28 DAYS BEFORE WORK BEGINS ON SITE**
 - GLAZING TO BE IN ACCORDANCE WITH PART N OF THE BUILDING REGULATIONS.
 - AREAS TO HAVE SAFETY GLAZING (CERTICAL LOCK TONGS) ARE INTERNAL AND EXTERNAL WALLS AND BETWEEN FLOOR LEVEL AND 1500mm ABOVE THAT LEVEL. IN DOORS, SIDE SCREENS OR PANELS CLOSE TO THE EDGE OF THE DOOR.
 - FULL STRUCTURAL DETAILS AND CALCULATIONS SHALL BE SUBMITTED TO LOCAL AUTHORITY FOR APPROVAL MINIMUM 28 DAYS BEFORE WORK BEGINS ON SITE.
 - FULL DETAILS OF FIRE ALARMS AND EMERGENCY LIGHTING TO BE SUBMITTED TO LOCAL AUTHORITY FOR APPROVAL MINIMUM 28 DAYS BEFORE INSTALLATION BEGINS ON SITE.
 - DETAILS OF THE ARTIFICIAL LIGHTING SYSTEM TO BE SUBMITTED FOR APPROVAL TO THE LOCAL AUTHORITY MINIMUM 28 DAYS BEFORE WORK BEGINS ON SITE.
 - DETAILS OF THE SOUNDING SYSTEM, INCLUDING ALARMS AND ROUTING OF SOUNDRING TO BE SUBMITTED TO THE BUILDING CONTROL OFFICER MINIMUM 28 DAYS BEFORE THE WORK BEGINS ON SITE.
 - EMERGENCY LIGHTING TO COMPLY WITH B.S. 5268:
 - EXIT SIGNAGE TO COMPLY WITH B.S. 5468: PART 1: 1980.
 - NEW DRAINS TO BE FLEXIBLE JOINTED CLAYWARE PRES BED AND SURROUNDED IN PE4 GRAVEL. DRAINS WITHIN 1200mm OF BUILDING TO BE ENCASED IN MIN. 150mm CONCRETE TO DUS OF FOUNDATIONS WITH JOINTS.
 - WASTE SIZES:
 - SINKS 300MM DIA ALL FITTED WITH MINIMUM 75MM DEEP SEAL TRAPS.
 - BASINS 320MM DIA
 - DRAINS TO BE LINTOLLED OVER WHERE PASSING THROUGH WALLS
 - NEW MANHOLES TO BE BUILT UP IN 225MM CLASS B ENGINEERING BRICKWORK OFF 150MM CONC BASE
 - DISPOSED DRAINS TO BE SEALED OFF
 - WASTES TO BE DISPOSED IN 225MM CLASS B ENGINEERING BRICKWORK OFF 150MM CONC BASE
 - 100MM DIA SOIL AND VENT PIPE TO TERMINATE MINIMUM 100MM ABOVE OPENING LIGHTS AND TO BE FITTED WITH DURABLE COKE
 - MECHANICAL VENTILATION TO BE PROVIDED AS FOLLOWS:
 - TOILETS:
 - EXTRACT AT A RATE OF 4L/SEC PER WC OR 3 AIR CHANGES PER HOUR.
 - FAN TO OPERATE IN CONJUNCTION WITH LIGHT SWITCH WITH 15MINUTE OVER-RUN
 - FANIC BARS WITH PUSH BAR TO OPEN SIGNS TO BE PROVIDED ON EMERGENCY EXIT DOORS.
 - VISION PANELS IN DOORS TO HAVE MINIMUM ZONE OF VISION BETWEEN 900-1500 MM ABOVE FLOOR LEVEL.

White Agus Partnership

PROVIDENCE VILLA,
42 SACKVILLE STREET,
BARNESLEY,
S10 2DB

Phone: 01228 206442
Fax: 01228 283050
Email: info@whiteagusparkpartnership.co.uk
Web: www.whiteagusparkpartnership.co.uk

Project: PROPOSED CO-OPERATIVE
SPARK LANE, MAPPLEWELL

Client: NORTHERN SERVICES LTD

Drawing Title.		Date.	Scale.		
PLANS AND ELEVATIONS AS PROPOSED		FEB 2011	1:100 @ A1		
Date	Suffix	Description	Date	Suffix	Description