




Do not scale from this drawing
The contractor is to check all dimensions on site
and report any discrepancies to the architect
All rights described by chapter IV of the
copyright, designs and patents act 1988
have been generally asserted

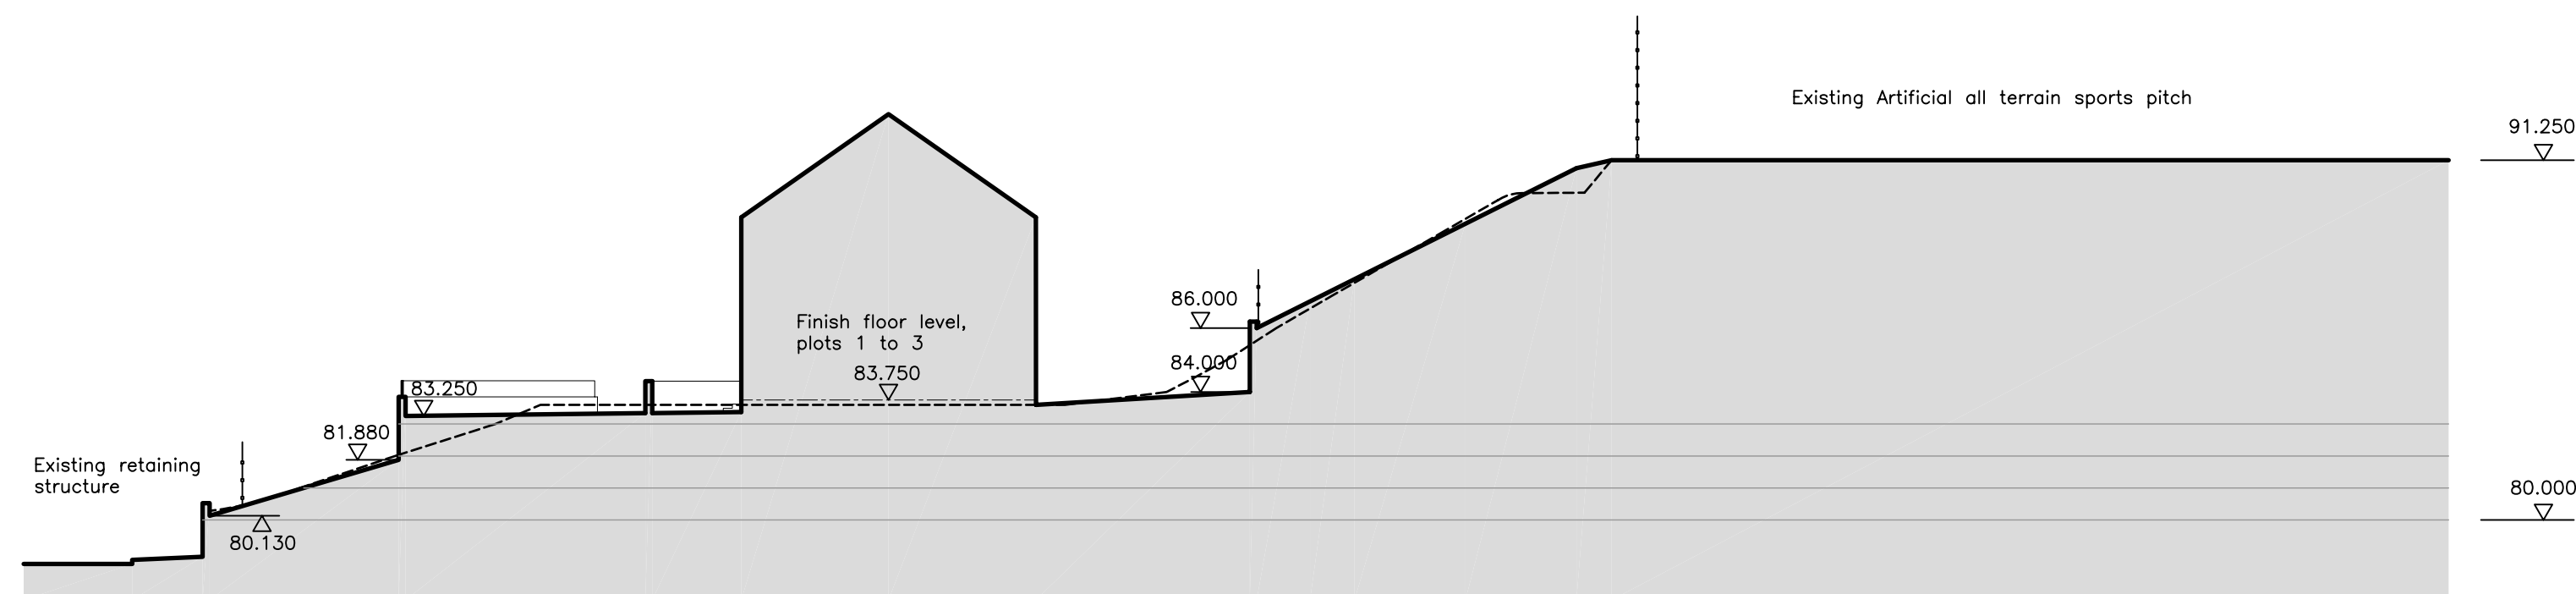


SECTION A-A

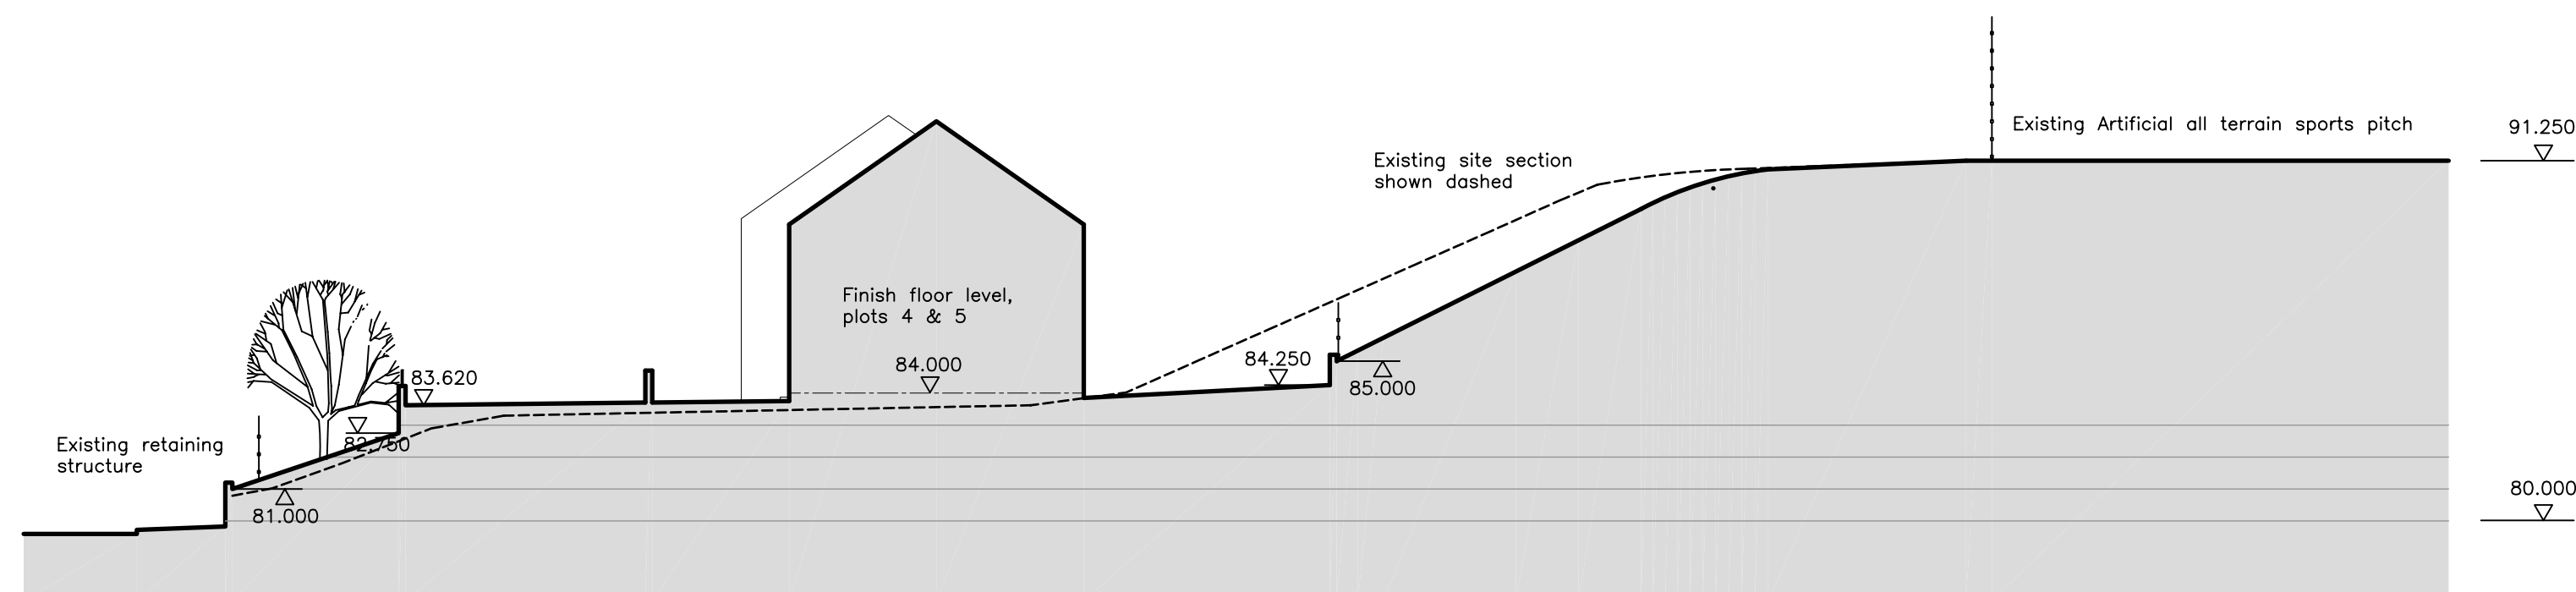


SECTION B-B

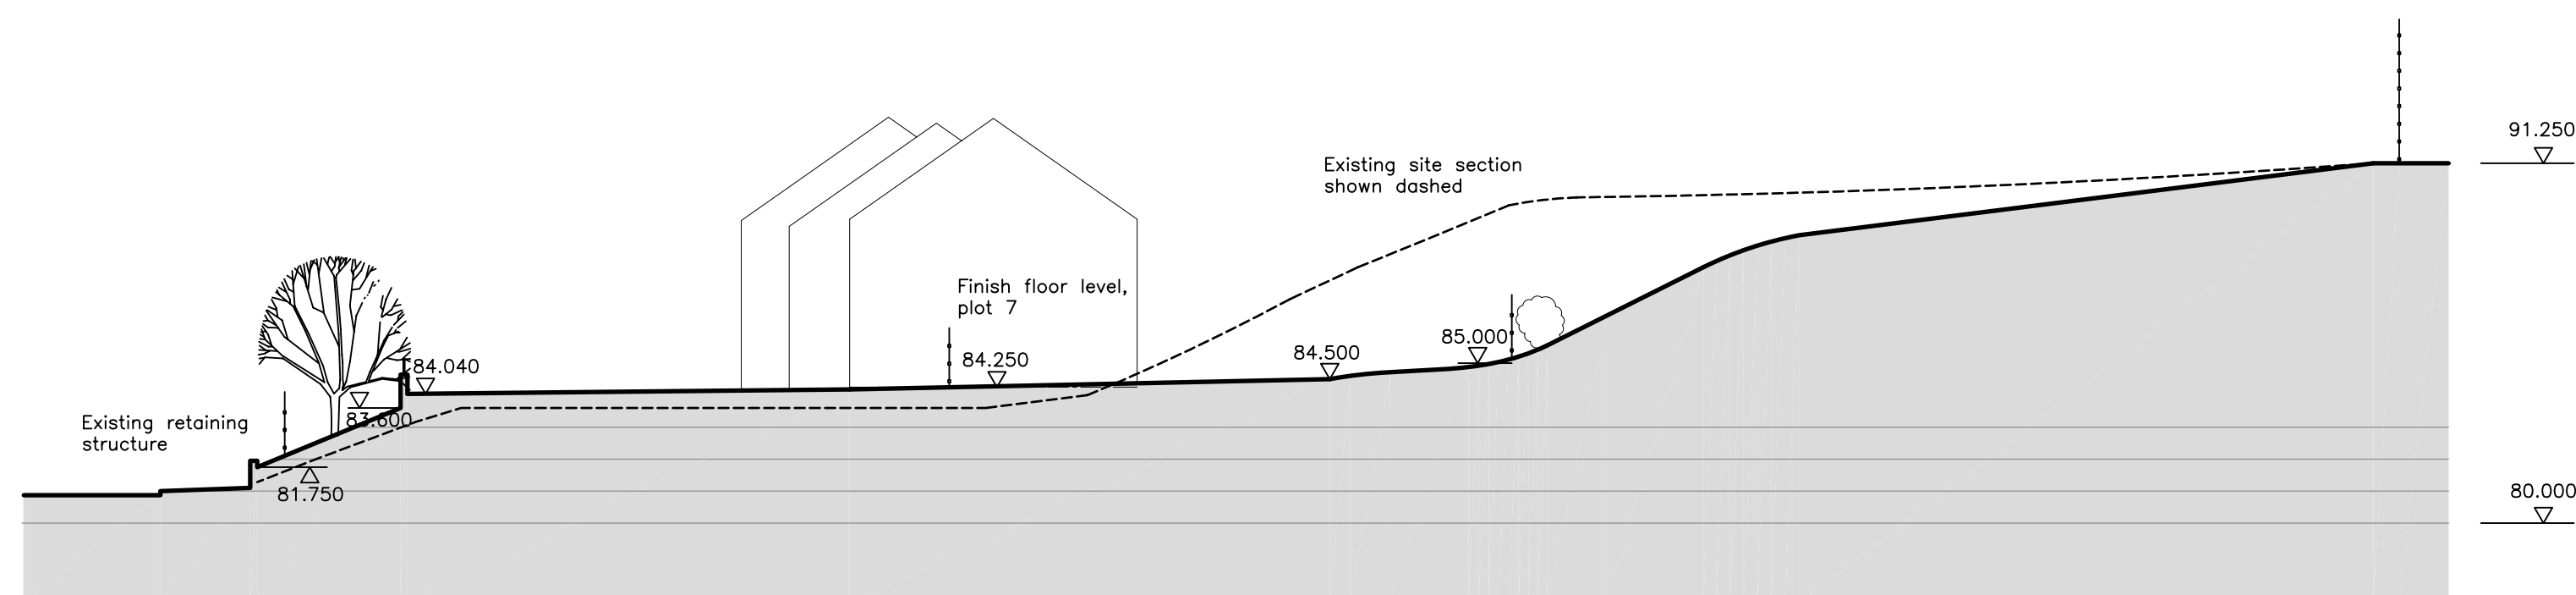

SECTION C-C

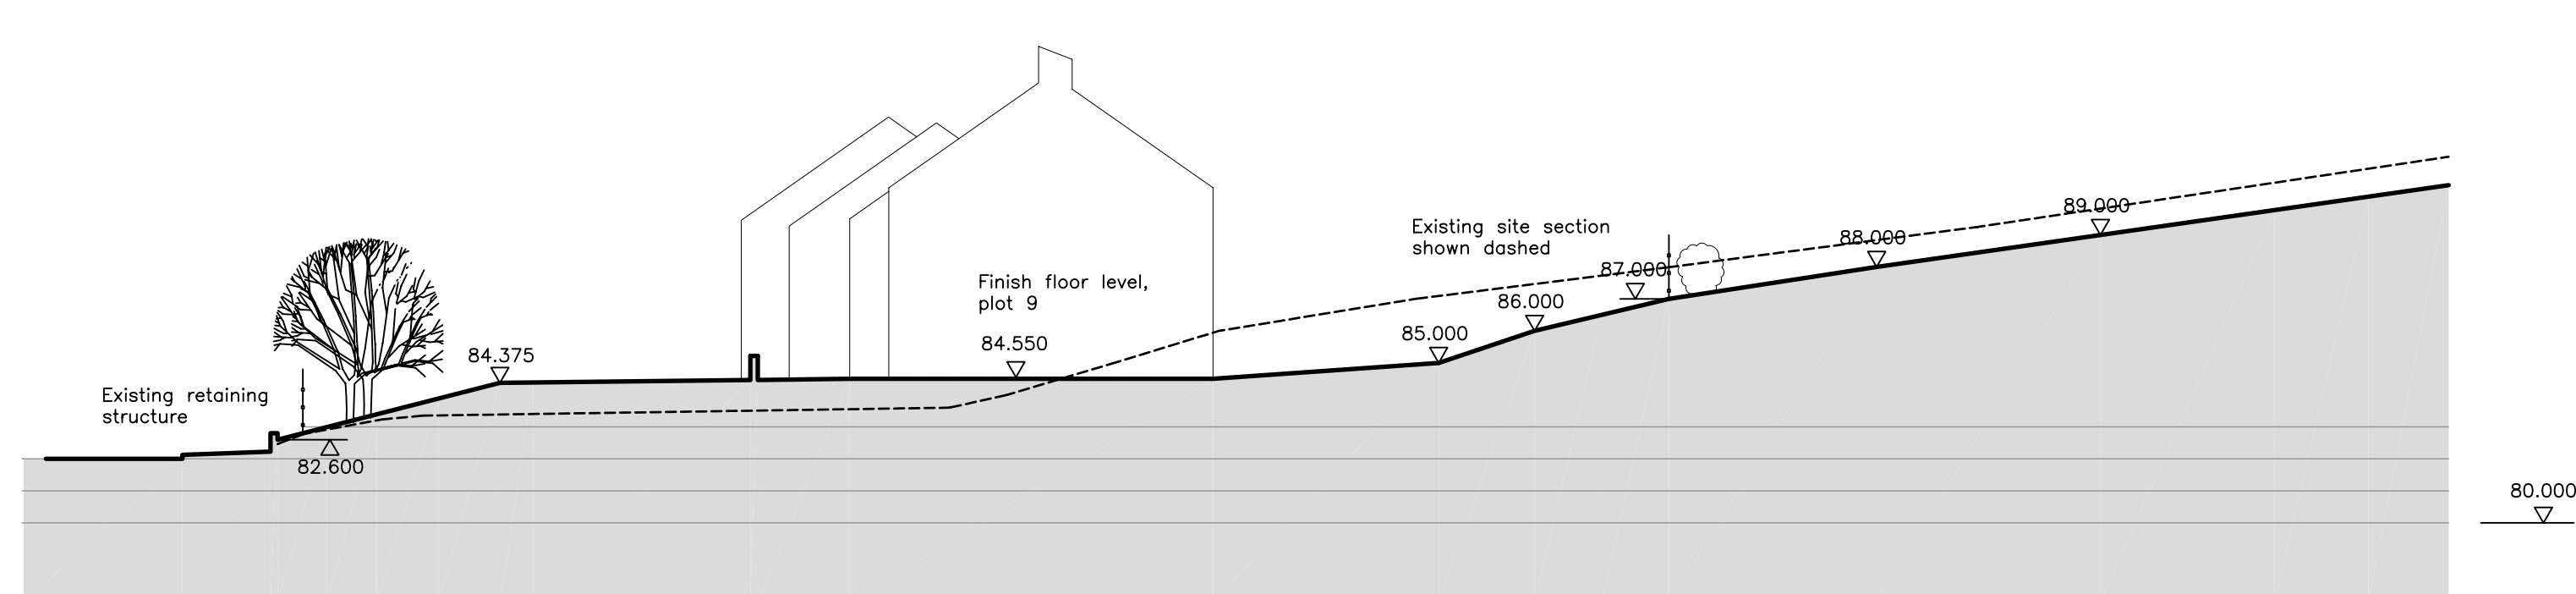

SECTION D-D

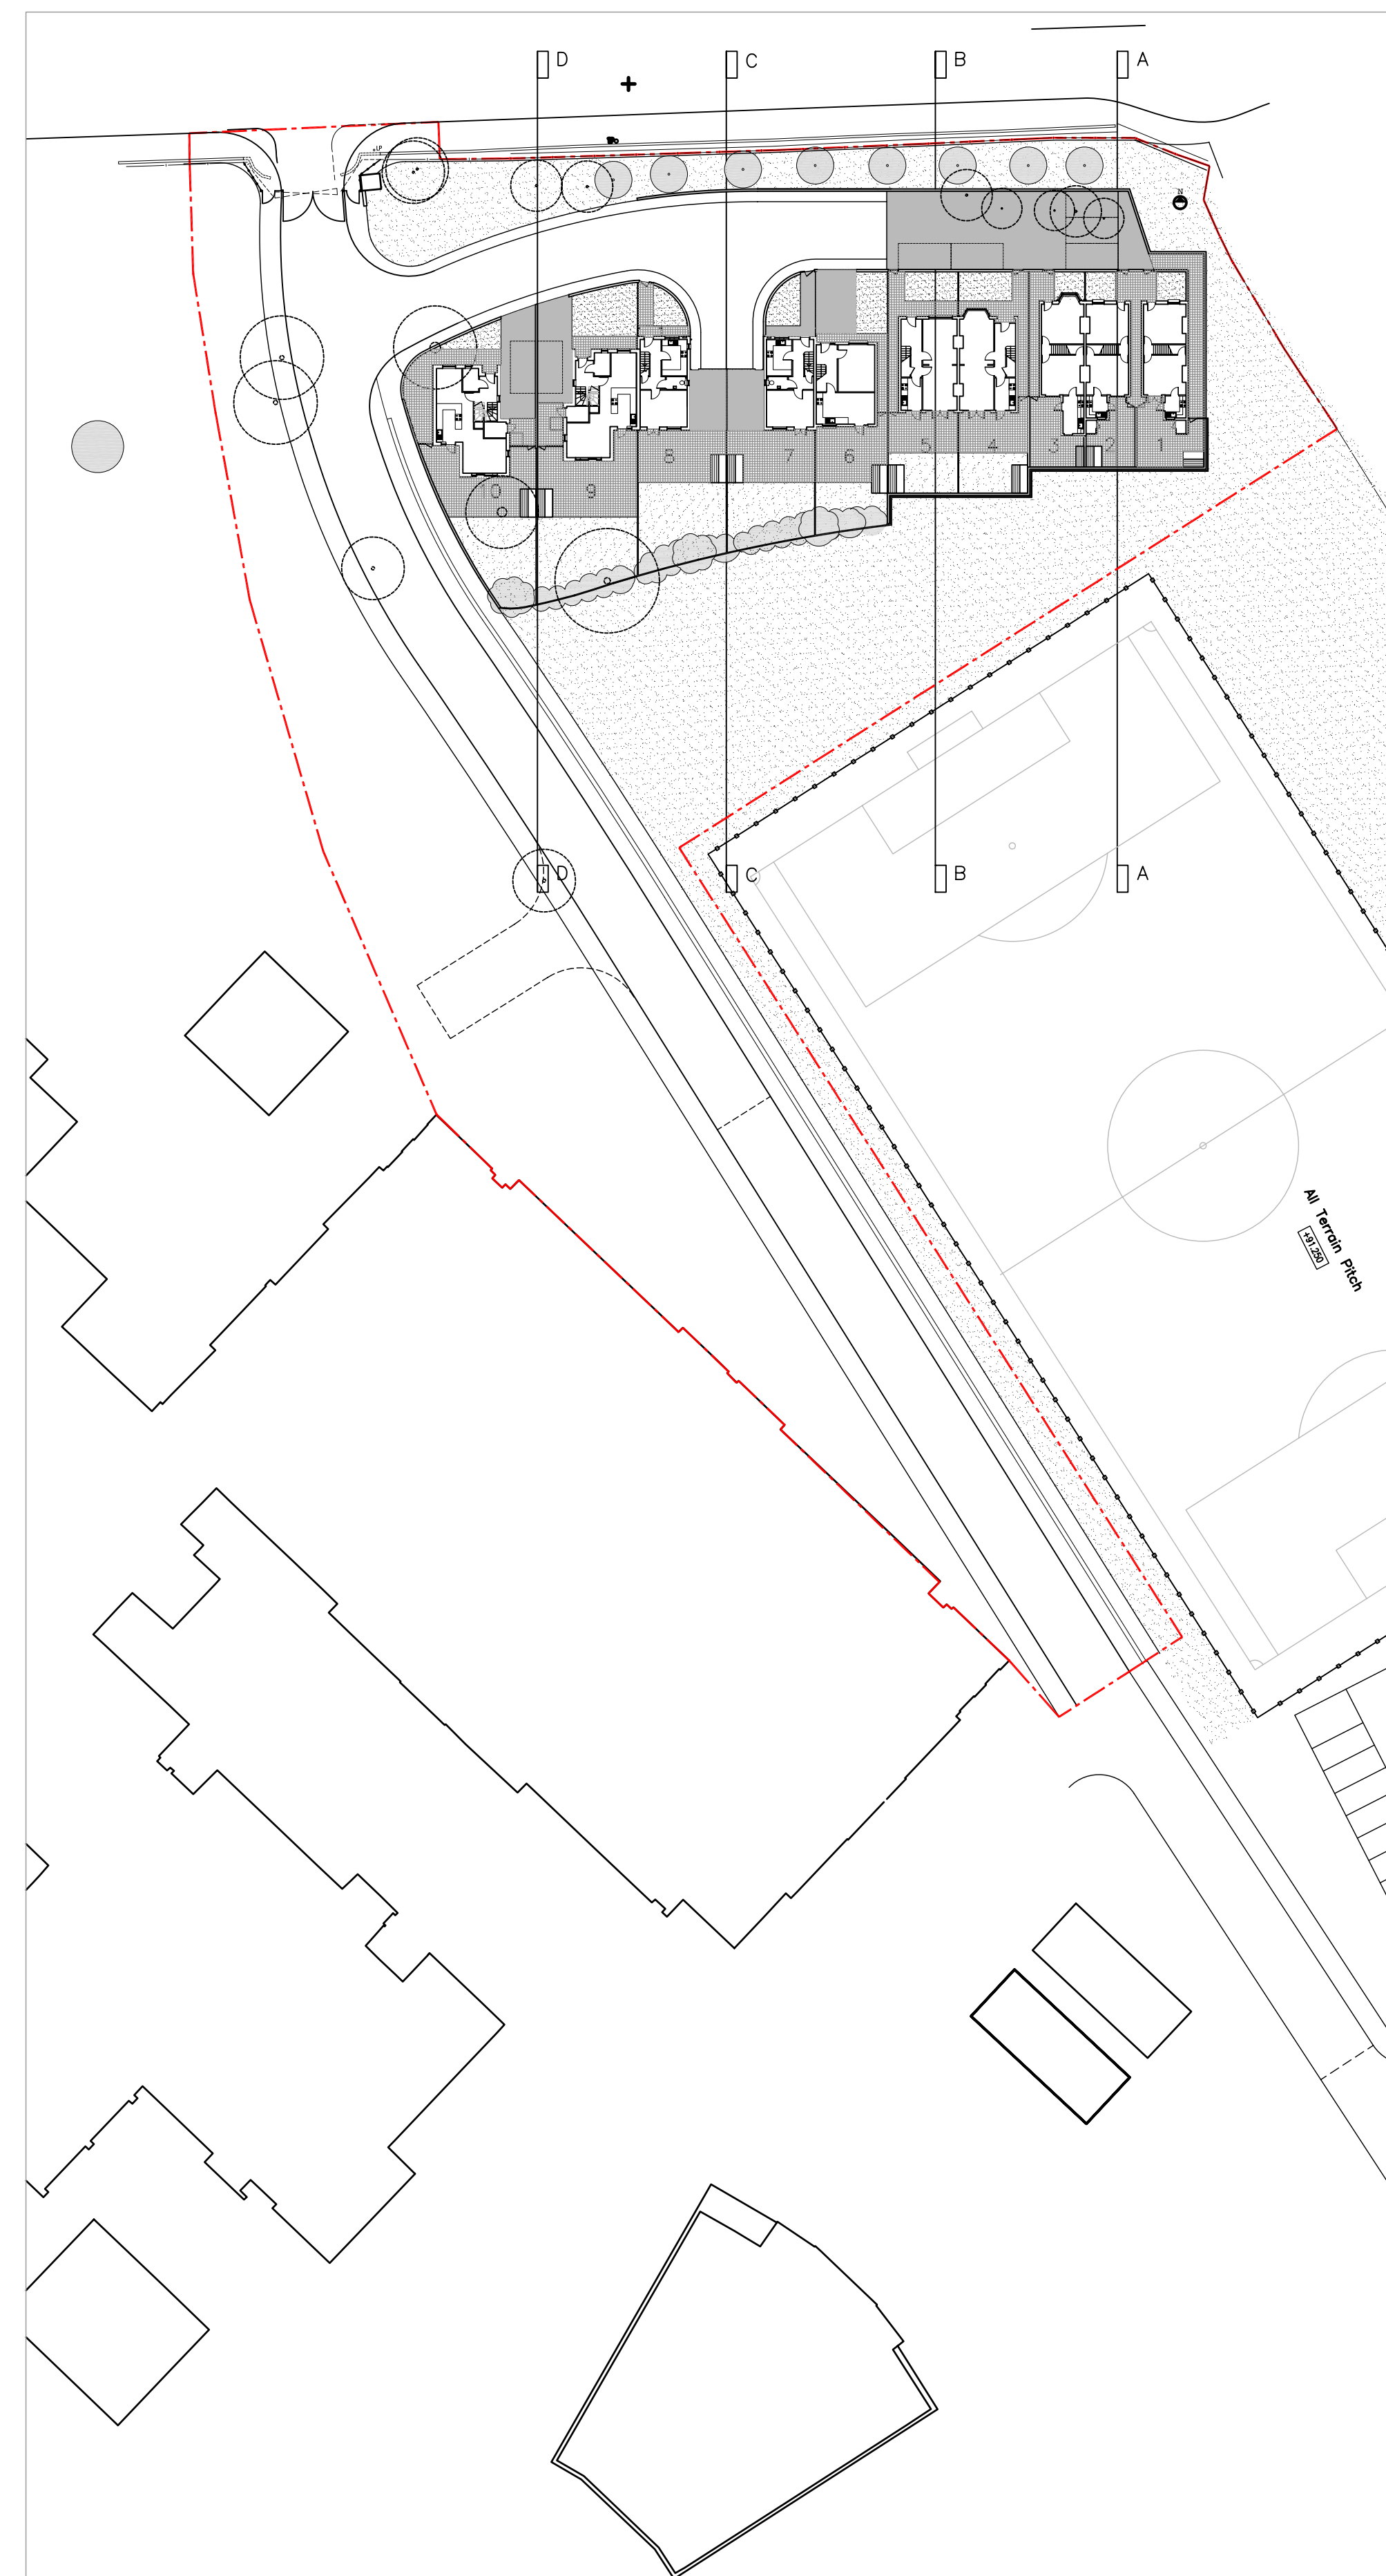

B	12/10/11	Drawn: SS	Check: CA
Sections co-ordinate with revised site plan & levels. PLANNING ISSUE.			
A	02-06-11	Drawn: CA	Check: PP
Minor amendments, Stage C Design.			
-	25-05-11	Drawn: CA	Check: PP
Initial Issue			

Fulcrum
2 Sidney Street
Sheffield S1 4RH
Telephone +44(0)1142761651
Facsimile +44(0)1142799191
Website www.jeffersonsheard.com

**Jefferson
Sheard
Architects**

Drawn: CA Check: PP

Project
Barnsley College
Honeywell Housing
Demonstration Units

Drawing
Site Cross Sections

Scale	Date	
1:200@A1	25-05-2011	
Ref.	Number	Rev.
0022	A_4000	B