 


SITE LOCATION




Reproduced by permission of Ordnance Survey on behalf of the Controller of Her Majesty's Stationary Office
All rights reserved. © Crown Copyright licence no. 100062043

SITE AREA PLAN




SITE PHOTOGRAPH

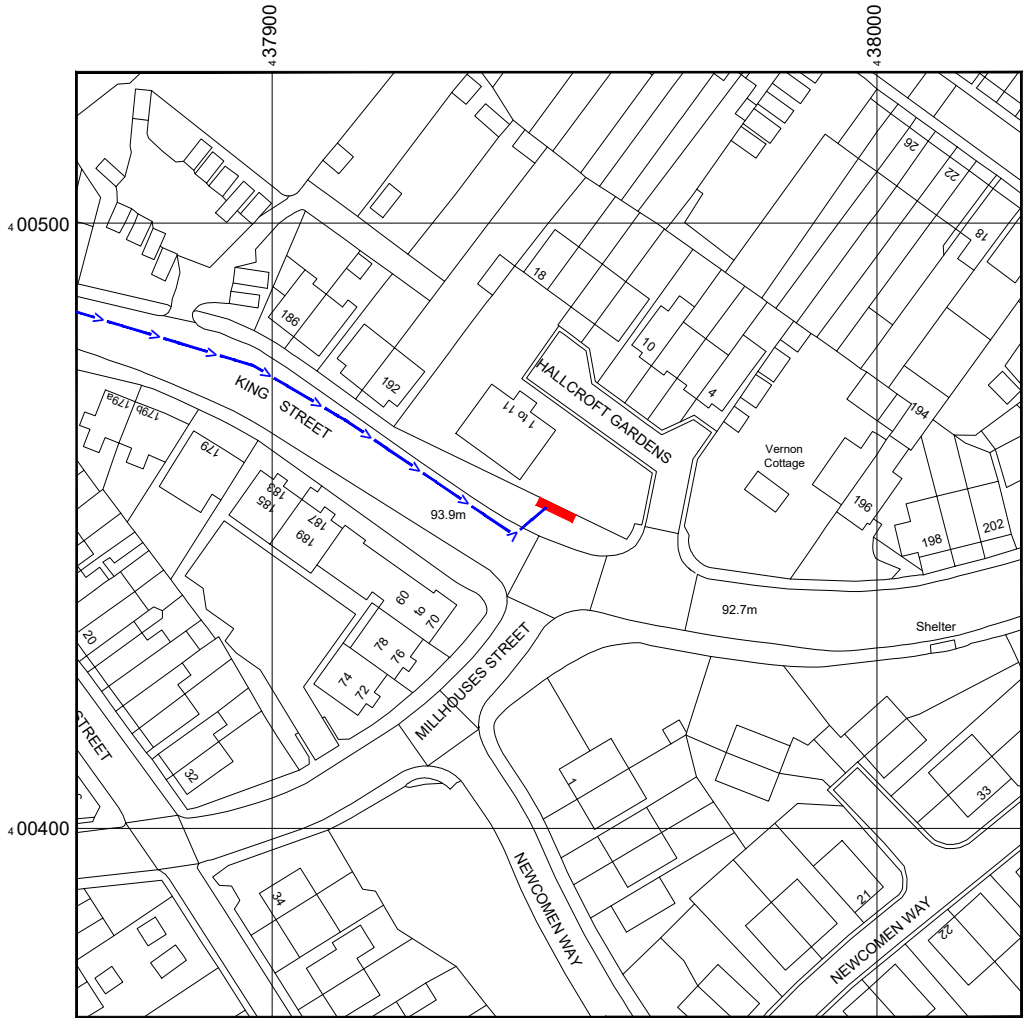

Reproduced by permission of Ordnance Survey on behalf of the Controller of Her Majesty's Stationary Office
All rights reserved. © Crown Copyright licence no. 100062043

NGR E: 437947 N: 400455

 SITE LOCATION PLAN



GOOGLE MAPS QR CODE

GOOGLE MAPS - <https://goo.gl/maps/L9zDUq5i12xD6Q6h7>

GOOGLE STREETVIEW - <https://goo.gl/maps/AXa8VzJYA4ob3JAz8>

NOTES:

1. ALL DIMENSIONS IN MM UNLESS OTHERWISE NOTED.

DIRECTIONS TO SITE:
Head north on M1. At junction 36, take the A61 exit to Barnsley (South). At the roundabout, take the 3rd exit onto A61. Continue straight to stay on A61. At Birdwell Roundabout, continue straight onto Birdwell Roundabout. Keep left to continue on Dearne Valley Pkwy/A6195. At the roundabout, take the 2nd exit and stay on Dearne Valley Pkwy/A6195. At the roundabout, take the 1st exit and stay on Dearne Valley Pkwy/A6195. At Shortwood Roundabout, take the 2nd exit and stay on Dearne Valley Pkwy/A6195. At the roundabout, take the 2nd exit onto Rycroft Bank/B6096. At the roundabout, take the 2nd exit and stay on Rycroft Bank/B6096. Turn left onto Hawshaw Ln/B6096. At the roundabout, take the 2nd exit onto Market St. Continue onto King St/B6097. Follow King St and site location is on the left hand side.



Master:	MBNL / EE:	Project:	Purpose of Issue:	Issue:
M001	MBNL	3UK DNSW	Planning	A
Date:	17/04/2023	Revision / Upgrade Description:		
Drawn:	CDN	First Issue - Site nomination dated: TBC		
Checked:	DH			
Approved:	SD			

CK Hutchison
Networks (UK)
Limited

Green Park
450 Longwater Avenue
Reading
RG30 3UR

Design Consultant & Principal Contractor:



WHP Telecoms

Unit 1 Maple Park,
Low Fields Avenue, Leeds
LS12 6HH

Tel: 01133023550
e-mail: info@whptelecoms.com

Site Name:
KING STREET STREETWORKS

Site ID:
BAR22975

Address:
KING STREET, HOYLAND, BARNSELY,
SOUTH YORKSHIRE MAYORAL
COMBINED AUTHORITY, ENGLAND,
S74 9LL


Title:
002 SITE LOCATION PLAN

Project:
3UK DNSW

Purpose of Issue:
PLANNING

EE Cell ID:	MBNL Cell ID:	Cell ID:
95772	BAR163	S1413

Master Drawing No:	Issue:
BAR22975_M001	A

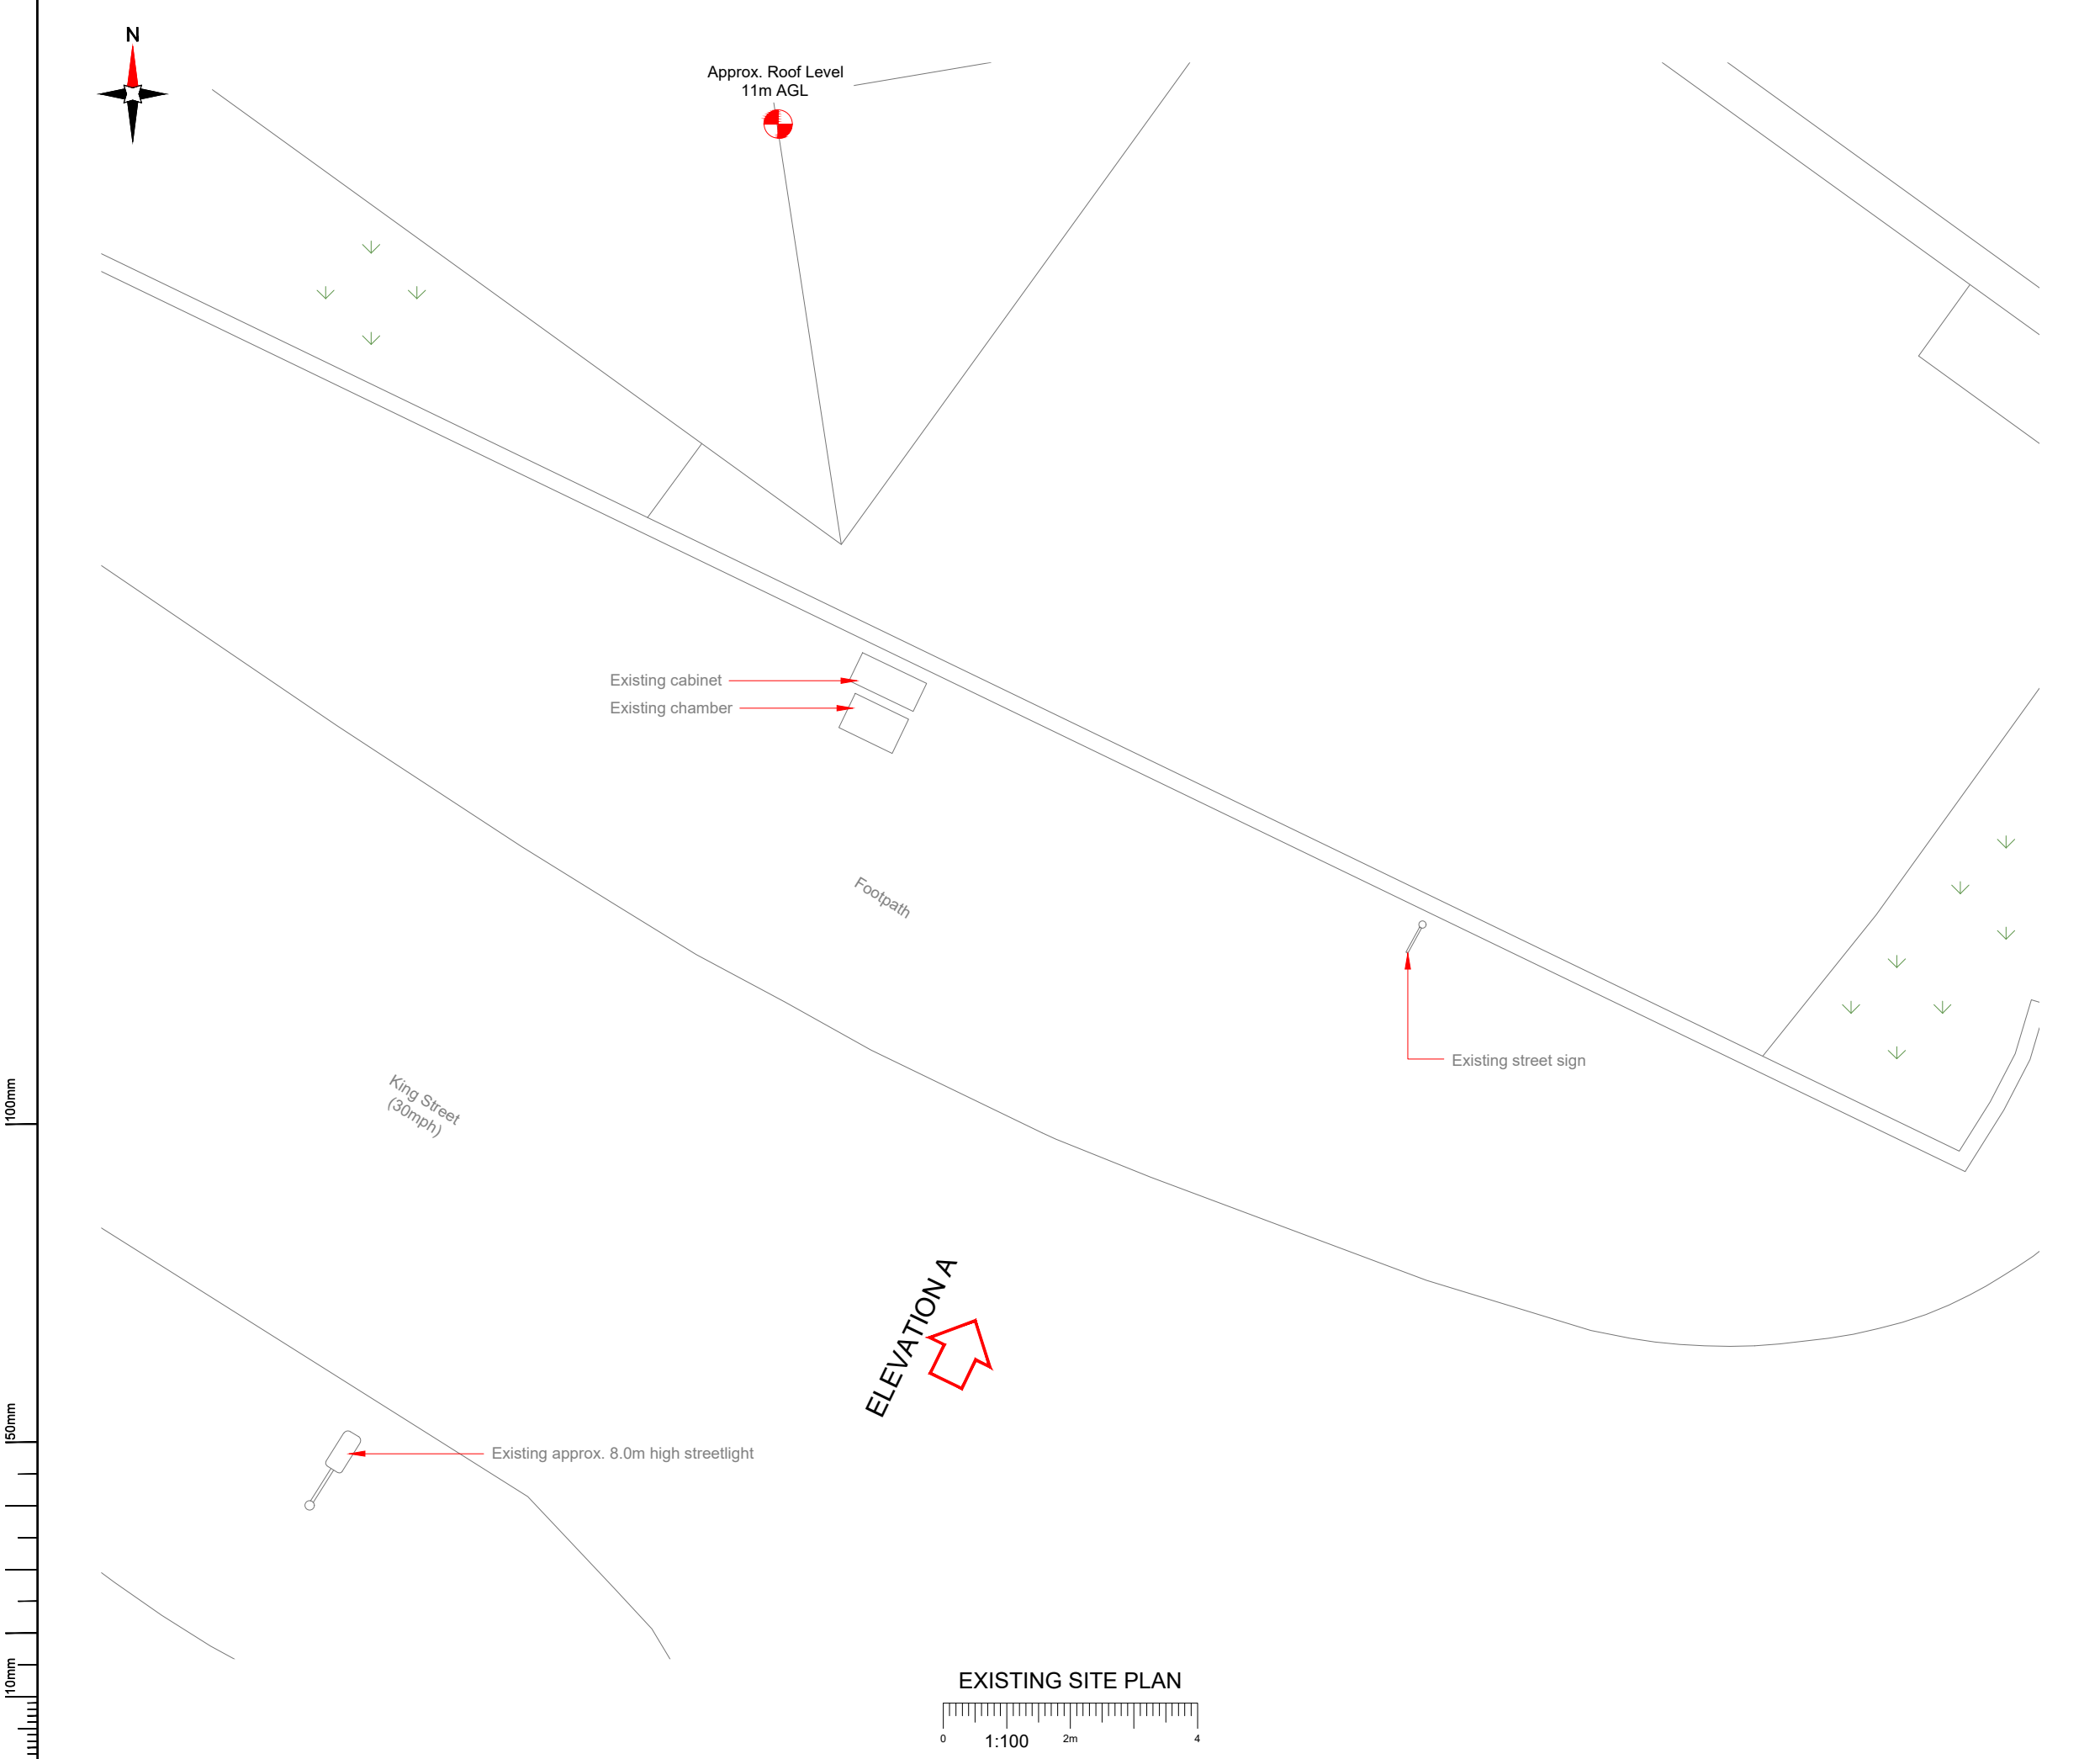

NOTES:

1. ALL DIMENSIONS IN MM UNLESS OTHERWISE NOTED.

Master:	MBNL / EE:	Project:	Purpose of Issue:	Issue:
M001	MBNL	3UK DNSW	Planning	A
Date:	17/04/2023	Revision / Upgrade Description:		
Drawn:	CDN	First Issue - Site nomination dated: TBC		
Checked:	DH			
Approved:	SD			

CK Hutchison Networks (UK) Limited

Green Park
450 Longwater Avenue
Reading
RG30 3UR

Design Consultant & Principal Contractor:



WHP Telecoms
Unit 1 Maple Park,
Low Fields Avenue, Leeds
LS12 6HH

Tel: 01133023550
e-mail: info@whptelecoms.com

Site Name:

KING STREET STREETWORKS

Site ID:

BAR22975

Address:

**KING STREET, HOYLAND, BARNSELY,
SOUTH YORKSHIRE MAYORAL
COMBINED AUTHORITY, ENGLAND,
S74 9LL**

Title:

100 EXISTING SITE PLAN

Project:

3UK DNSW

Purpose of Issue:

PLANNING

EE Cell ID:	MBNL Cell ID:	Cell ID:
95772	BAR163	S1413

Master Drawing No:

BAR22975_M001


Issue:

A


100mm

50mm

10mm

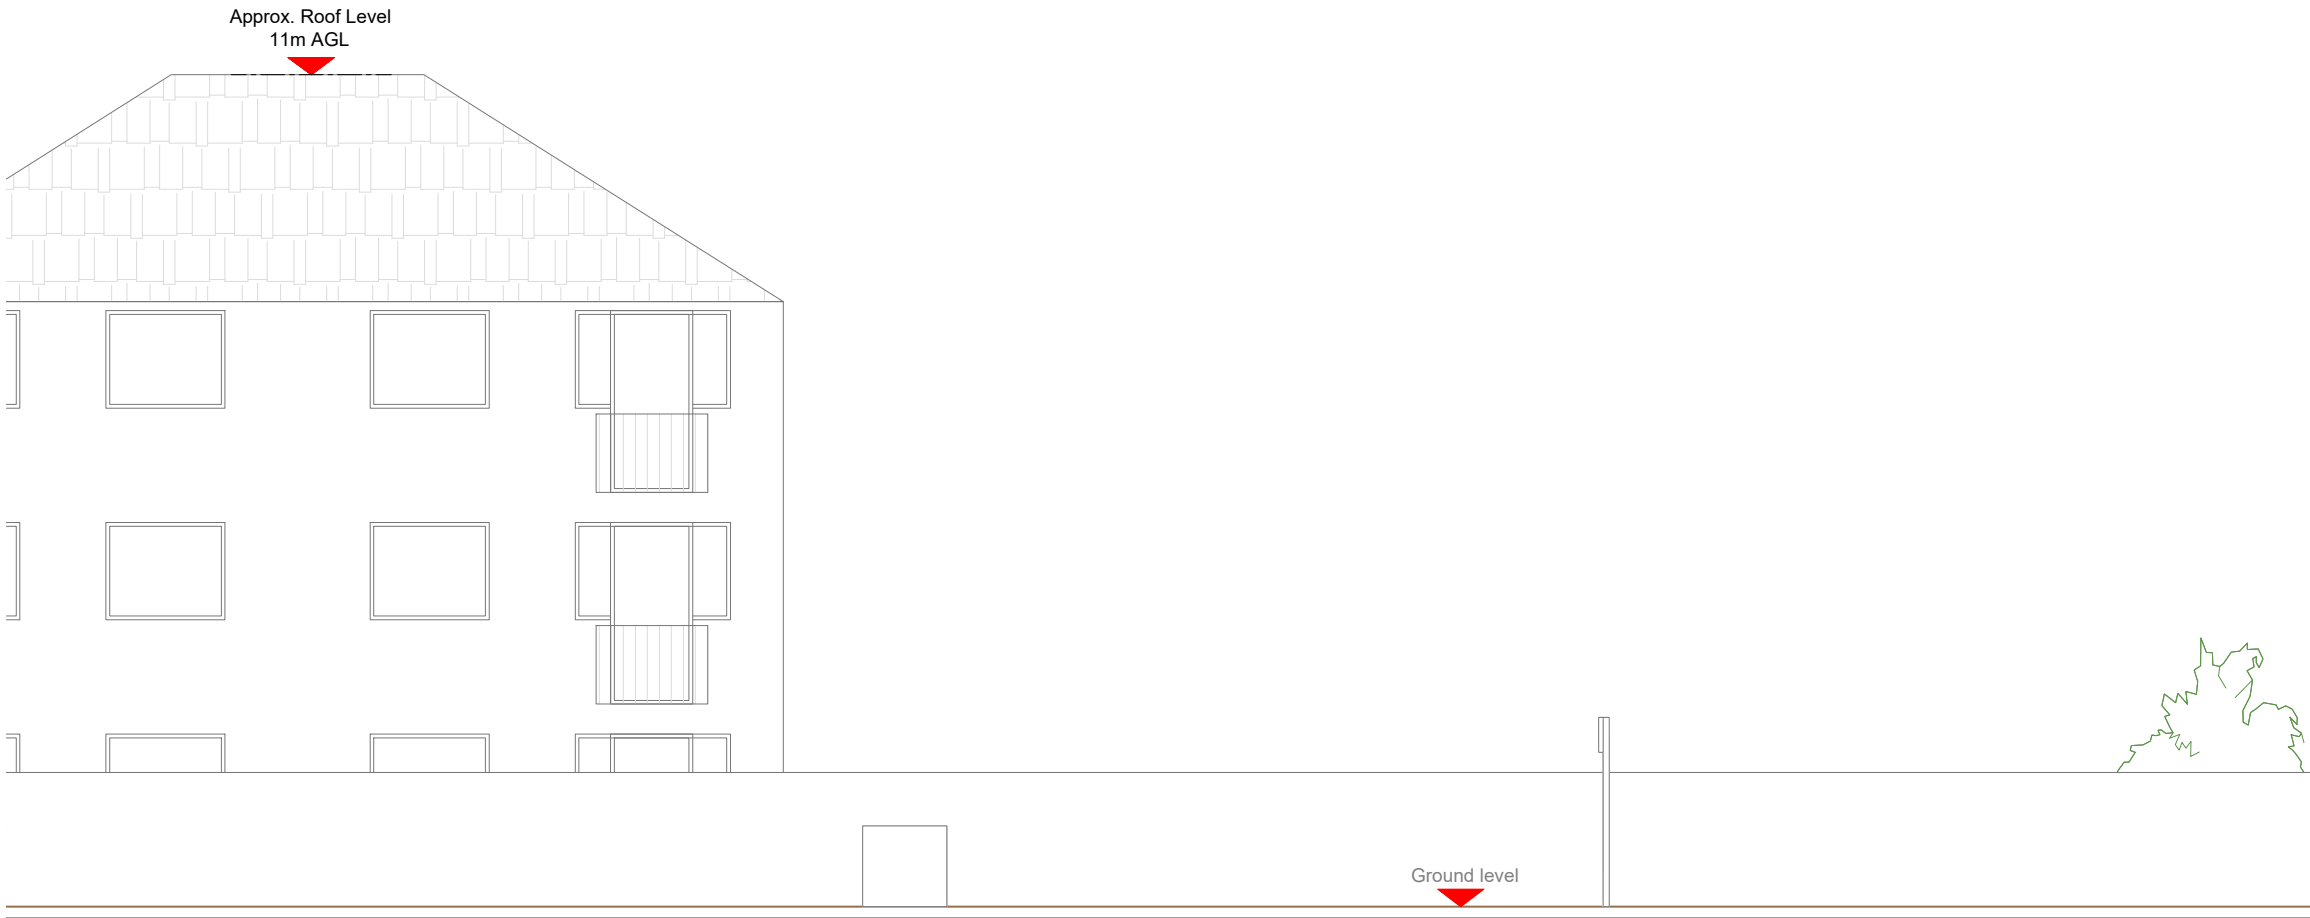

EXISTING ELEVATION A

 

- NOTES:
1. ALL DIMENSIONS IN MM UNLESS OTHERWISE NOTED.

Master:	MBNL / EE:	Project:	Purpose of Issue:	Issue:
M001	MBNL	3UK DNSW	Planning	A
Date:	17/04/2023	Revision / Upgrade Description:		
Drawn:	CDN	First Issue - Site nomination dated: TBC		
Checked:	DH			
Approved:	SD			

CK Hutchison
Networks (UK)
Limited

Green Park
450 Longwater Avenue
Reading
RG30 3UR

Design Consultant & Principal Contractor:



WHP Telecoms
Unit 1 Maple Park,
Low Fields Avenue, Leeds
LS12 6HH

Tel: 01133023550
e-mail: info@whptelecoms.com

Site Name:
KING STREET STREETWORKS

Site ID:
BAR22975

Address:
KING STREET, HOYLAND, BARNSELY,
SOUTH YORKSHIRE MAYORAL
COMBINED AUTHORITY, ENGLAND,
S74 9LL

Title:
150 EXISTING ELEVATION A

Project:
3UK DNSW

Purpose of Issue:
PLANNING


EE Cell ID: 95772	MBNL Cell ID: BAR163	Cell ID: S1413
----------------------	-------------------------	-------------------

Master Drawing No: BAR22975_M001	Issue: A
-------------------------------------	-------------






Approx. Roof Level
11m AGL

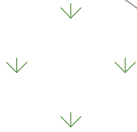

Existing cabinet
Existing chamber

 

Proposed Phase 8 monopole

Proposed 2No. cabinets

Proposed G-100876 cabinet

3300

700

4500

Existing street sign

Footpath

 
King Street
(30mph)

Existing approx. 8.0m high streetlight



ELEVATION A

PROPOSED SITE PLAN



Antenna Aperture ID	Proposed 4G/5G Bearing
B1	120°
B2	120°
C1	240°
C2	240°

NOTES:

1. ALL DIMENSIONS IN MM UNLESS OTHERWISE NOTED.

Master:	MBNL / EE:	Project:	Purpose of Issue:	Issue:
M001	MBNL	3UK DNSW	Planning	A
Date:	17/04/2023	Revision / Upgrade Description:		
Drawn:	CDN	First Issue - Site nomination dated: TBC		
Checked:	DH			
Approved:	SD			

CK Hutchison
Networks (UK)
Limited

Green Park
450 Longwater Avenue
Reading
RG30 3UR

Design Consultant & Principal Contractor:



WHP Telecoms

Unit 1 Maple Park,
Low Fields Avenue, Leeds
LS12 6HH

Tel: 01133023550
e-mail: info@whptelecoms.com

Site Name:

KING STREET STREETWORKS

Site ID:

BAR22975

Address:

KING STREET, HOYLAND, BARNSELY,
SOUTH YORKSHIRE MAYORAL
COMBINED AUTHORITY, ENGLAND,
S74 9LL

Title:

210 PROPOSED SITE PLAN

Project:

3UK DNSW

Purpose of Issue:

PLANNING


EE Cell ID:	MBNL Cell ID:	Cell ID:
95772	BAR163	S1413
Master Drawing No:		
BAR22975_M001		
Issue:		
A		



100mm

50mm

10mm

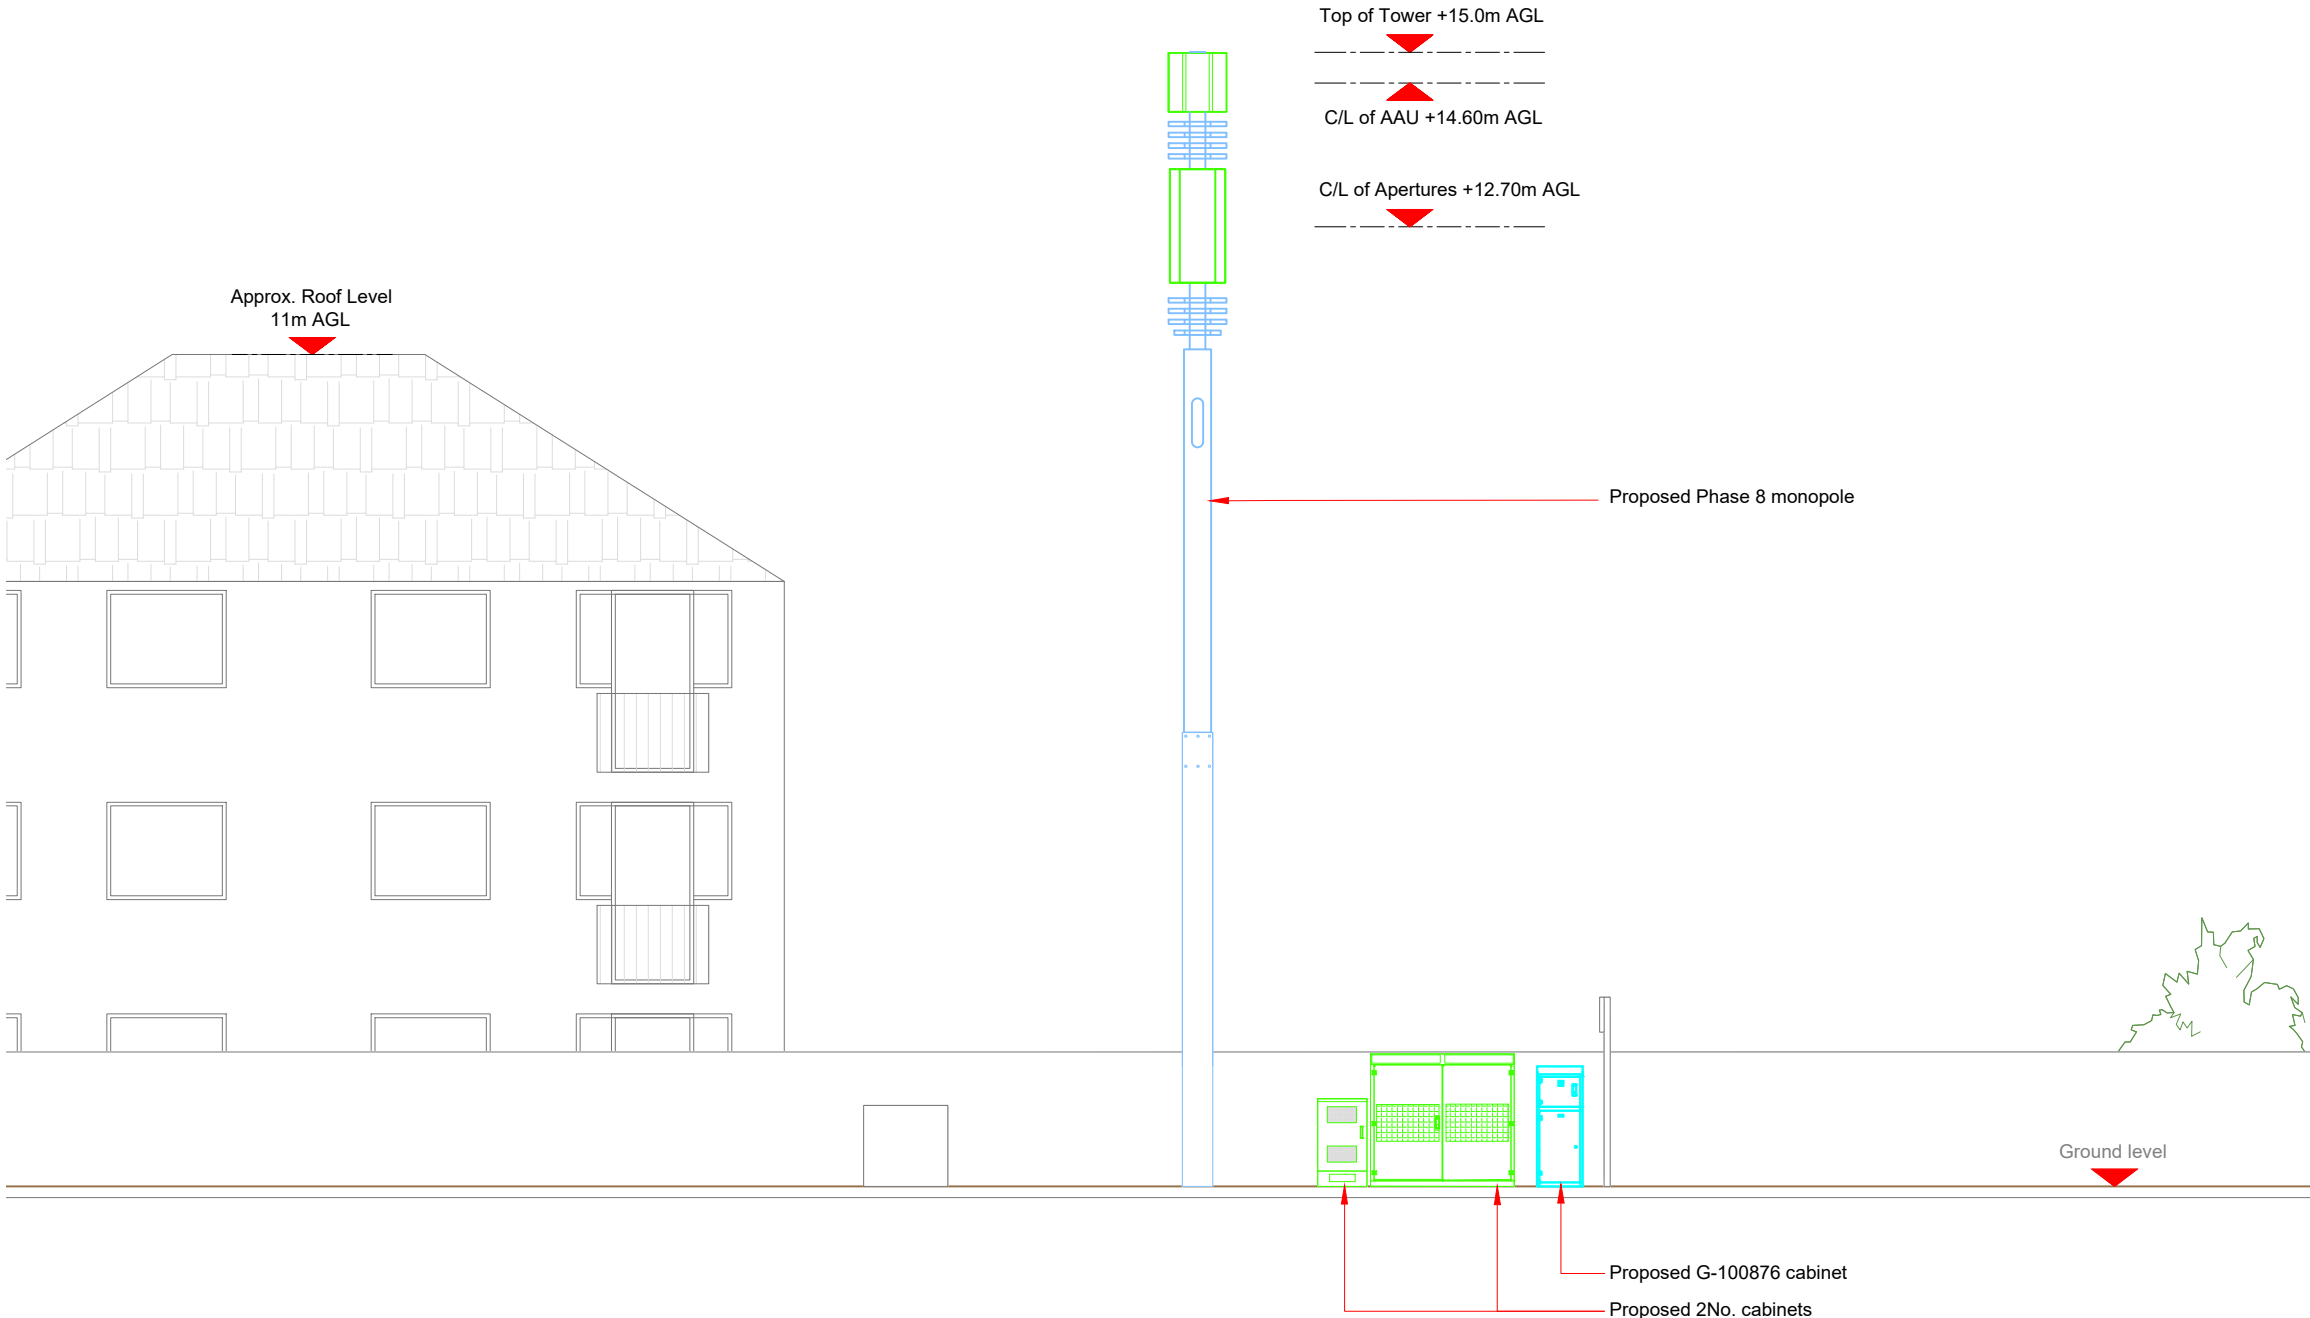

Antenna Aperture ID	Proposed 4G/5G Bearing
B1	120°
B2	120°
C1	240°
C2	240°

NOTES:
1. ALL DIMENSIONS IN MM UNLESS OTHERWISE NOTED.

Master:	MBNL / EE:	Project:	Purpose of Issue:	Issue:
M001	MBNL	3UK DNSW	Planning	A
Date:	17/04/2023	Revision / Upgrade Description:		
Drawn:	CDN	First Issue - Site nomination dated: TBC		
Checked:	DH			
Approved:	SD			

CK Hutchison Networks (UK) Limited

Green Park
450 Longwater Avenue
Reading
RG30 3UR

Design Consultant & Principal Contractor:



WHP Telecoms

Unit 1 Maple Park,
Low Fields Avenue, Leeds
LS12 6HH

Tel: 01133023550
e-mail: info@whptelecoms.com

Site Name:
KING STREET STREETWORKS

Site ID:
BAR22975

Address:
**KING STREET, HOYLAND, BARNSELY,
SOUTH YORKSHIRE MAYORAL
COMBINED AUTHORITY, ENGLAND,
S74 9LL**

Title:
260 PROPOSED ELEVATION

Project:
3UK DNSW

Purpose of Issue:
PLANNING

EE Cell ID: 95772	MBNL Cell ID: BAR163	Cell ID: S1413
-----------------------------	--------------------------------	--------------------------

Master Drawing No: BAR22975_M001	Issue: A
--	--------------------

