


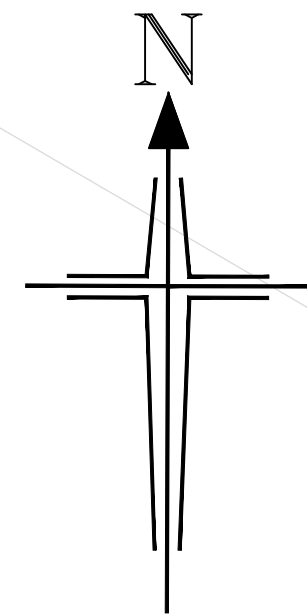

THE HOUSING LAYOUT SHOWN ON THIS PLAN IS TAKEN FROM JRP LANDSCAPE MASTER PLAN LAYOUT REFERENCED P14:4905:101 rev C DATED 13 APRIL 2017.

THE TOPOGRAPHICAL SURVEY SHOWN ON THIS PLAN IS TAKEN FROM ELLAM LAND SURVEYS TOPOGRAPHICAL SURVEY REFERENCED 6523/1 DATED JANUARY 2012.


GRID AND DATUM DETERMINED BY GPS

This drawing is copyright and shall not be reproduced nor used for any other purpose without the written permission of the Bryan G Hall Ltd. This drawing must be read in conjunction with all other related drawings and documentation.

It is the contractors responsibility to ensure full compliance with the Building Regulations. Do not scale from this drawing, use figured dimensions only. It is the contractors responsibility to check and verify all dimensions on site. Any discrepancies to be reported immediately. If in DOUBT ASK.

Materials not in conformity with relevant British or European Standards/Codes of practice or materials known to be deleterious to health & safety must not be used or specified on this project.

- NOTES:**
- KEY:**
- Proposed Surface Water Sewer and Manhole
 - Flow Control Manhole
 - Proposed Surface Water Attenuation Tank
 - Proposed Foul Water Sewer and Manhole
 - Proposed Foul Water Rising Main
 - Proposed Gully and Connection

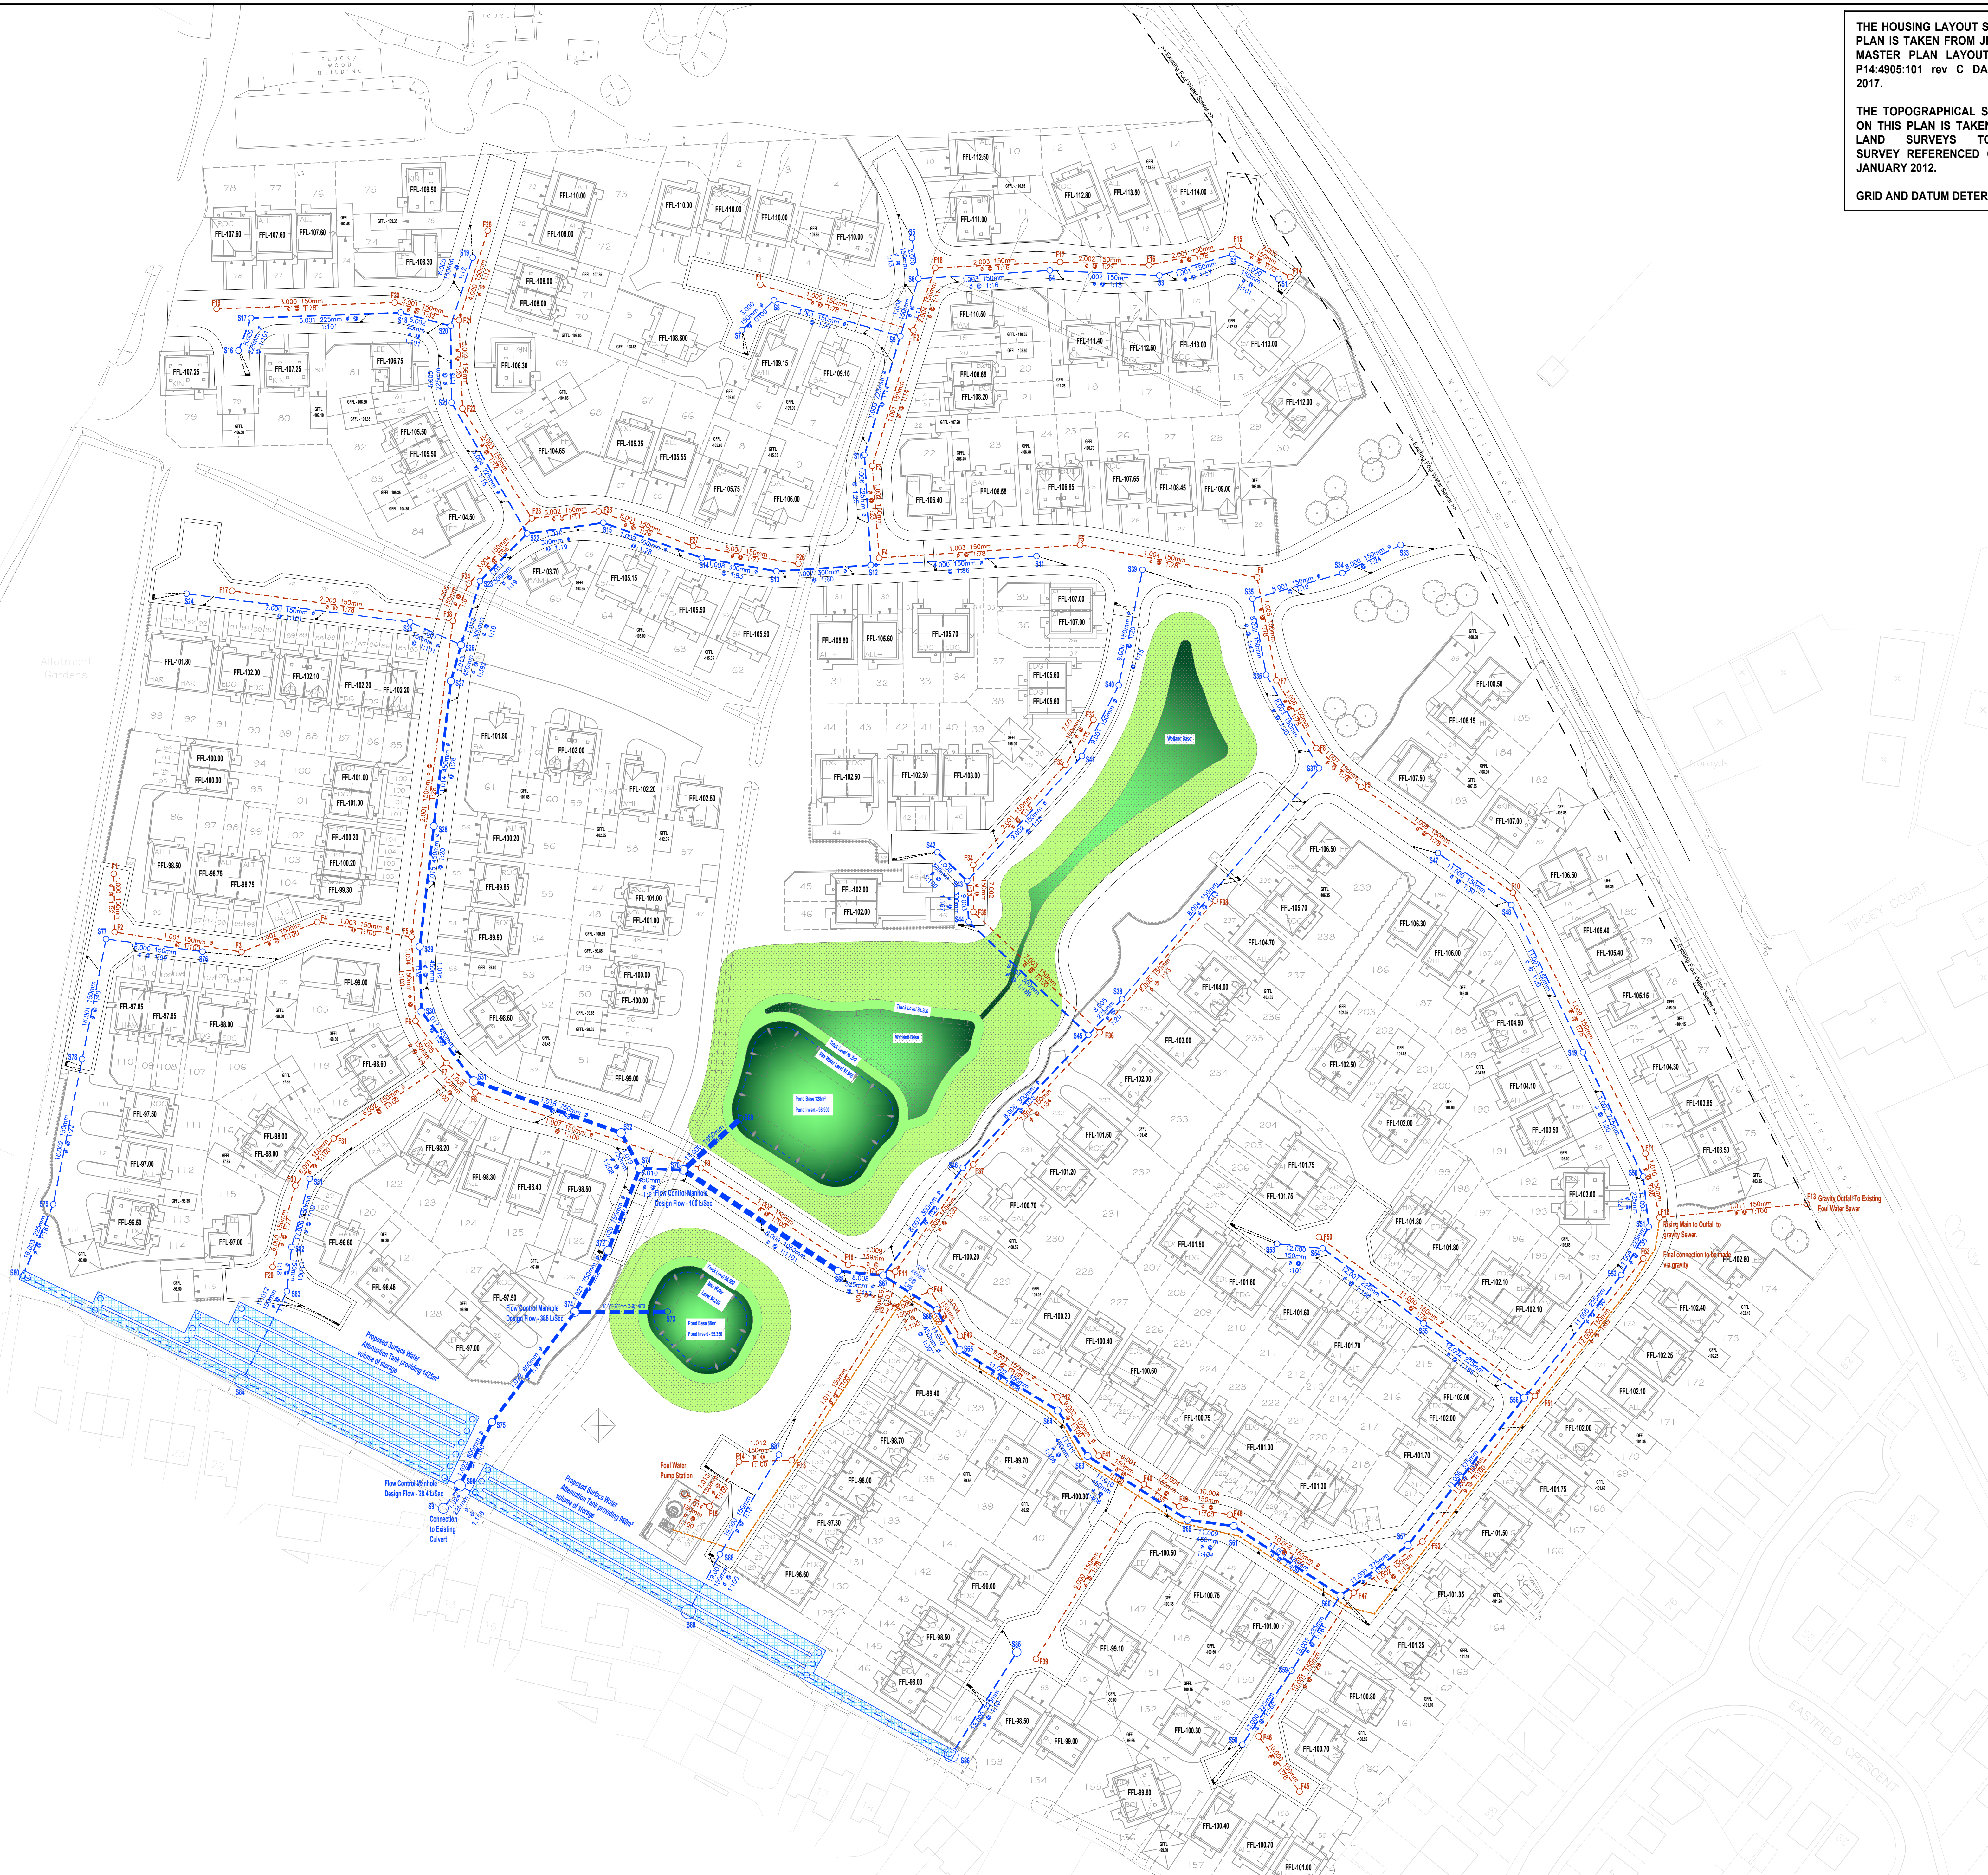

Rev: Date: Amendment: DRN: CHK:

BRYAN G HALL

CONSULTING CIVIL & TRANSPORTATION PLANNING ENGINEERS
Copyright Reserved Bryan G Hall Ltd.

E: bgh@bryanghall.co.uk W: www.bryanghall.co.uk

Suite E115 | Josephine Wall
Harwood Walk | LEEDS | LS3 1AB
T 0113 246 1555
F 0113 234 2201

Lighterman House
26/36 Wharfedale Road
LONDON | N1 8YV
T 0203 6532366

Client: NETHERTON HOMES

Status:

Scale: 1:500
Size: A0 - 841 x 1189
Drawn: IE
Chkd:
Appvd:

Project: RESIDENTIAL DEVELOPMENT,
WAKEFIELD ROAD,
MAPPLEWELL, BARNSELY

Title: PROPOSED DRAINAGE LAYOUT

Drawing No: 19/122/DE/002
Job No: 19-122

Revision:
Date: 18/05/19