




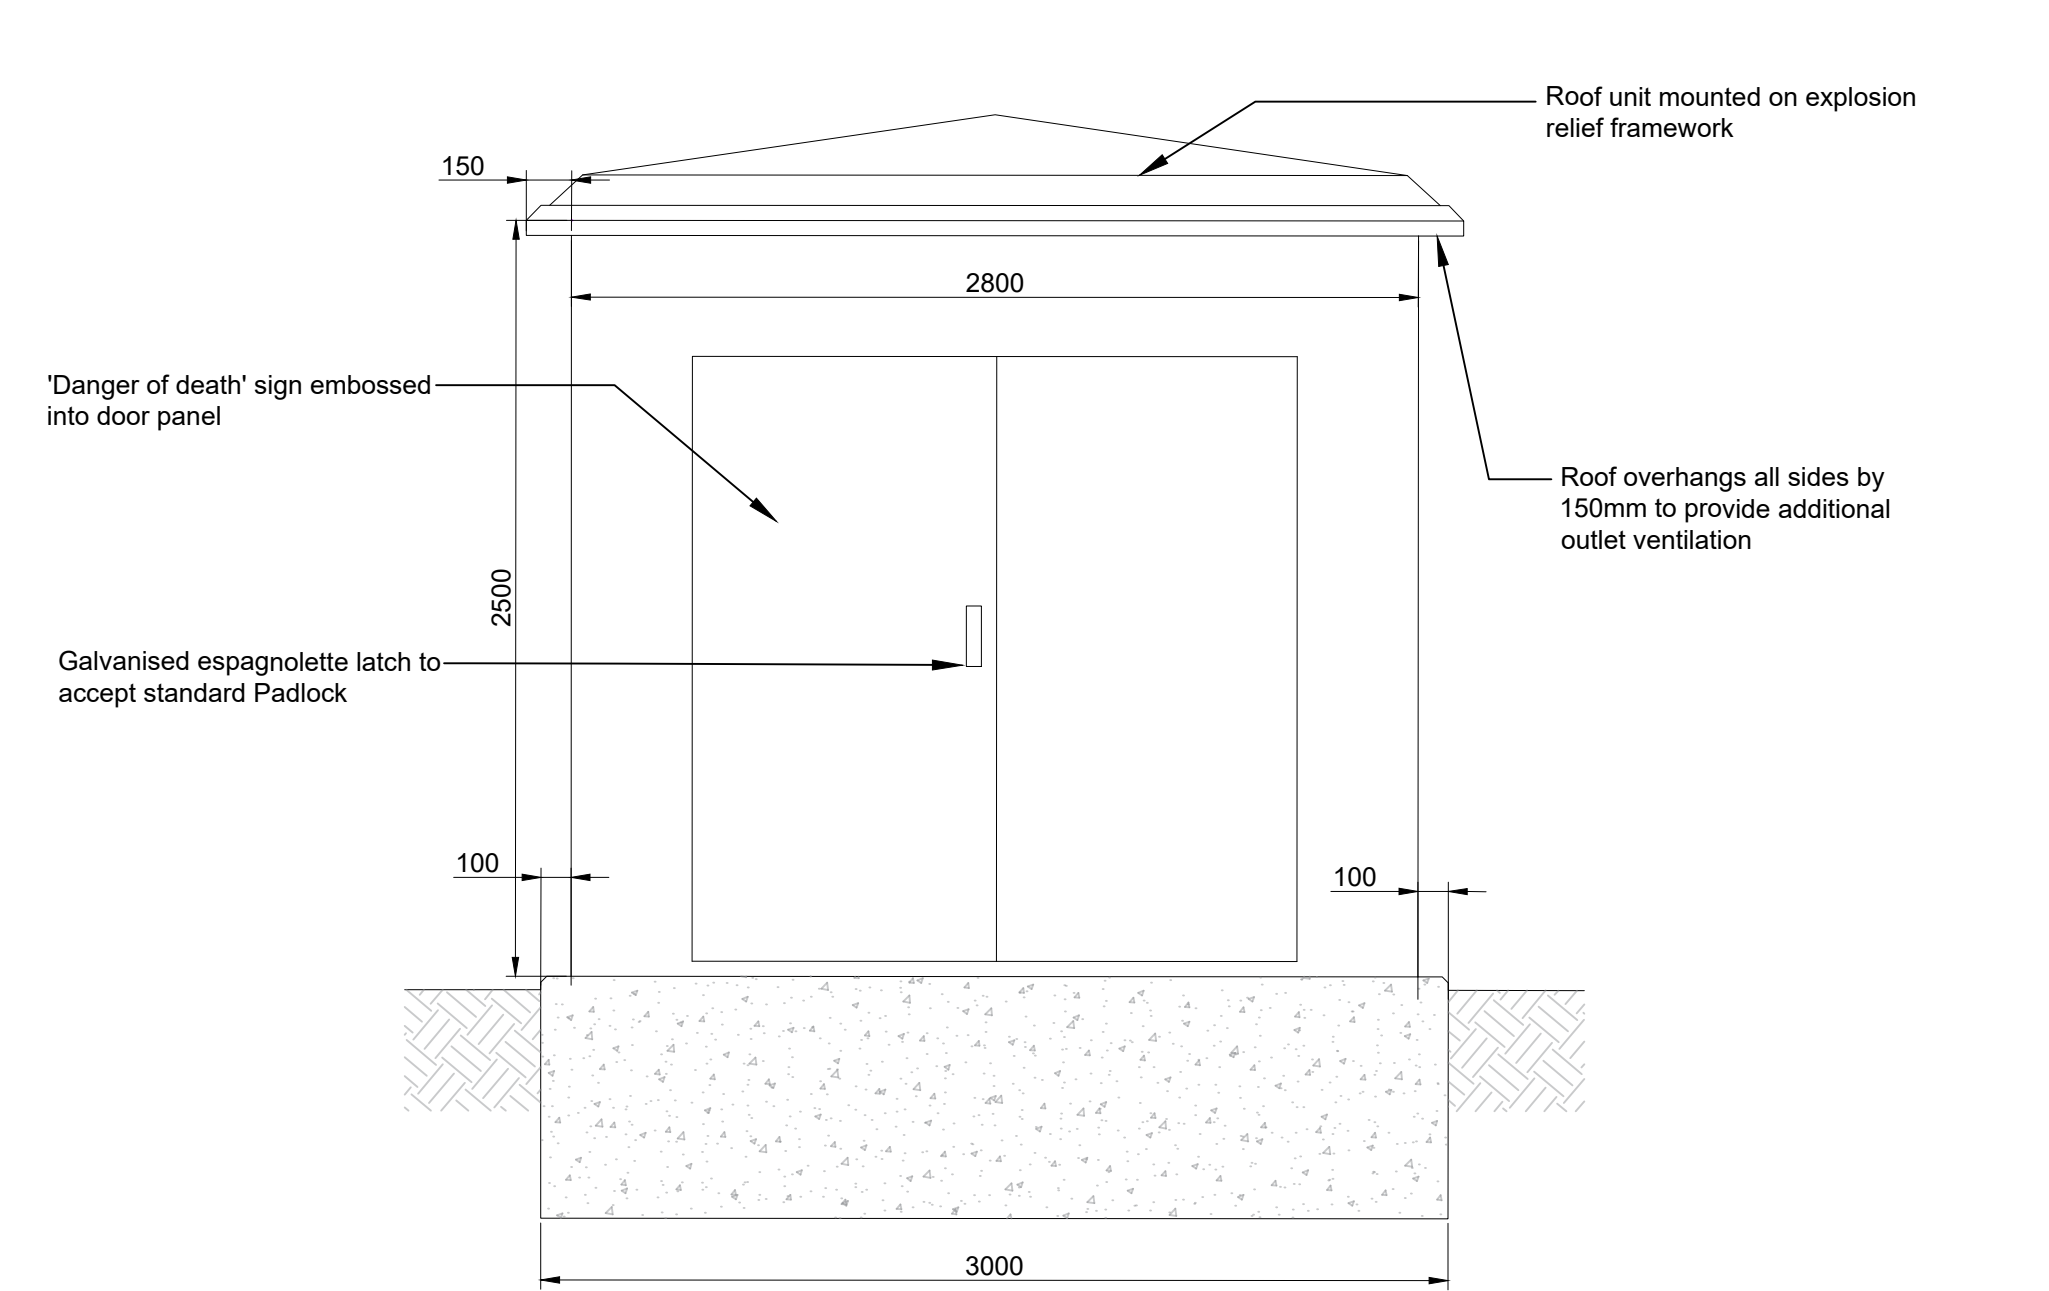


Front Elevation Scale 1:25

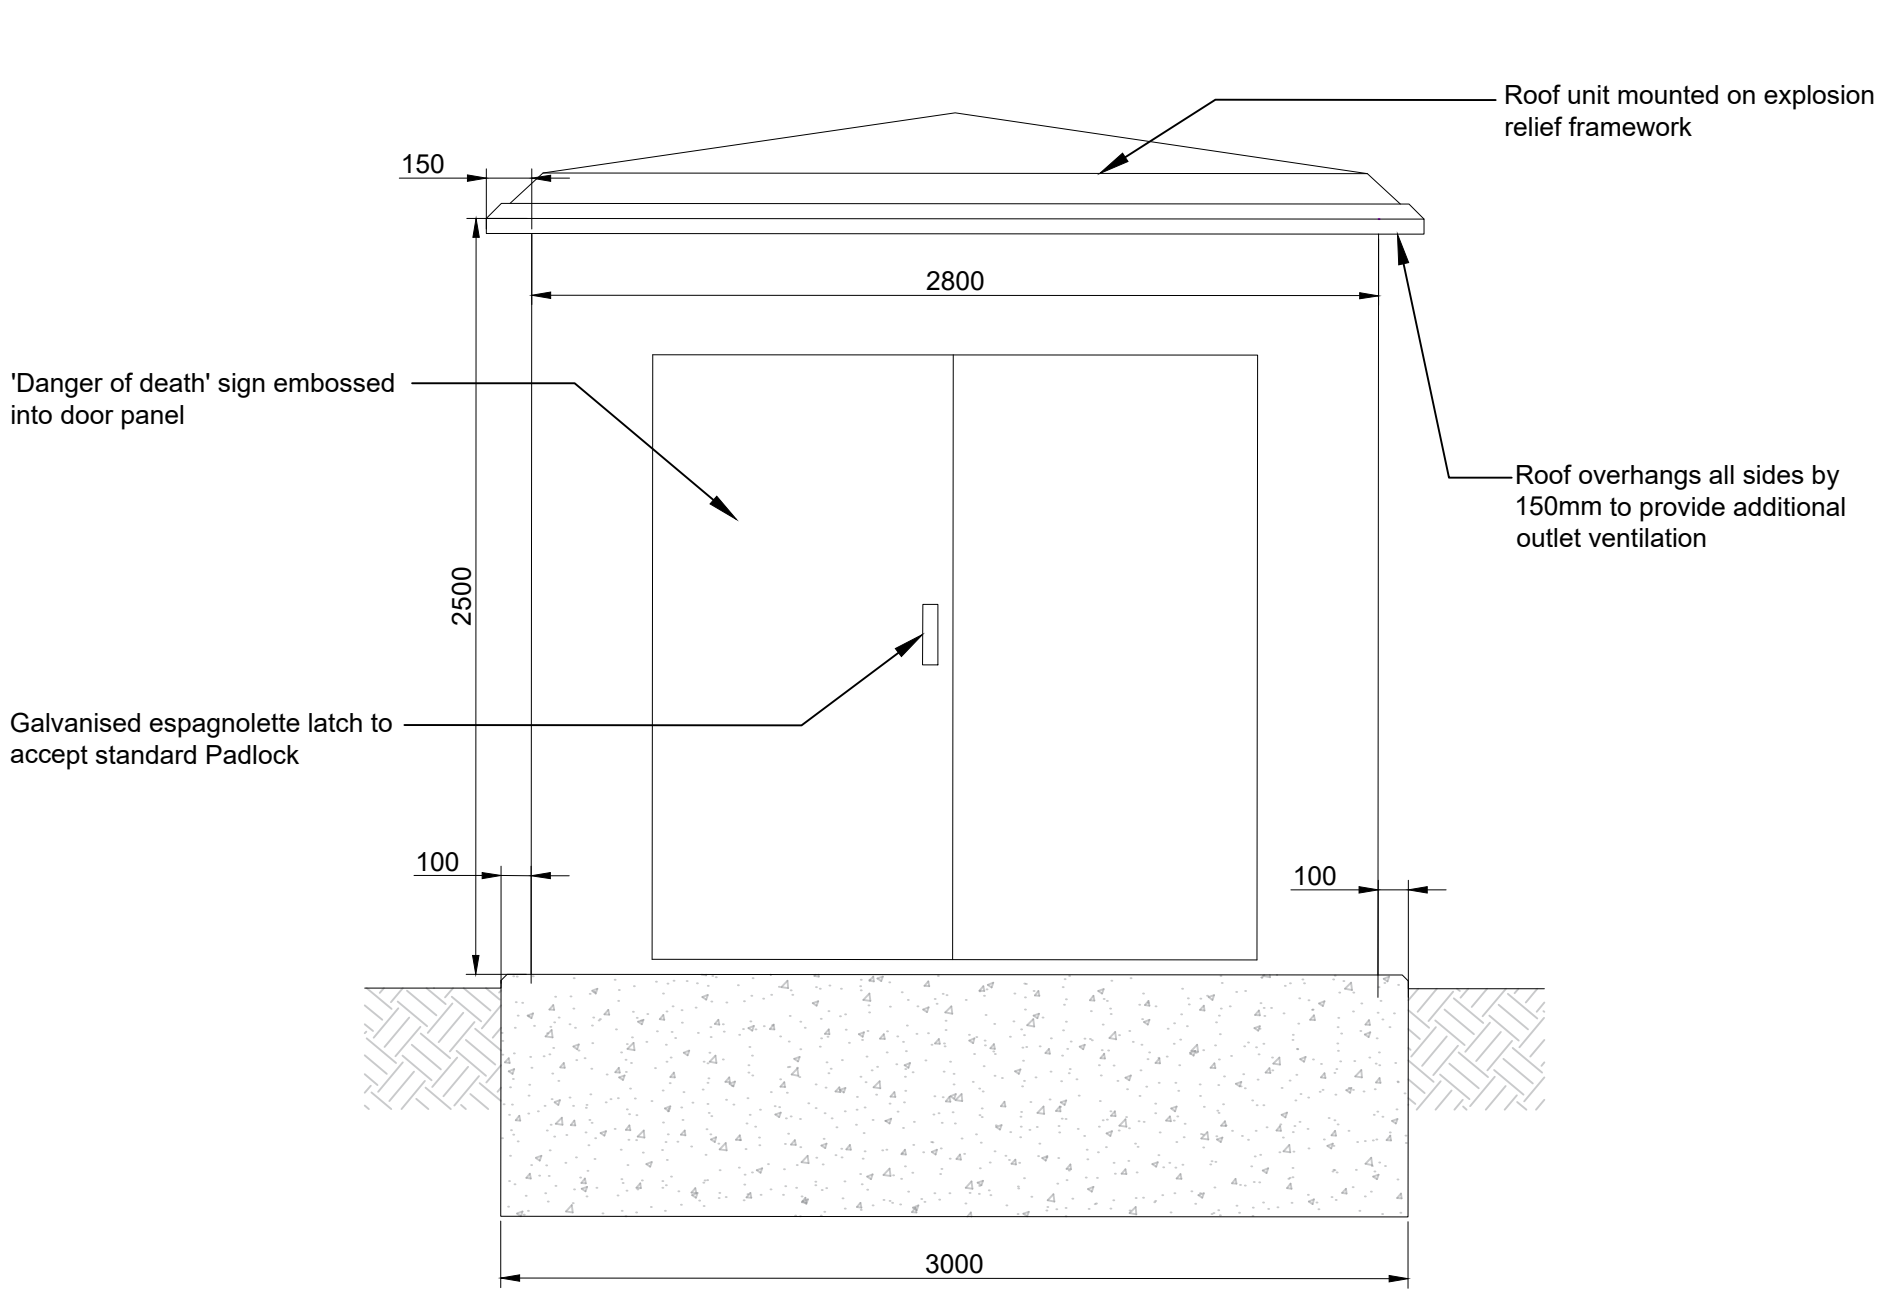


Back Elevation Scale 1:25

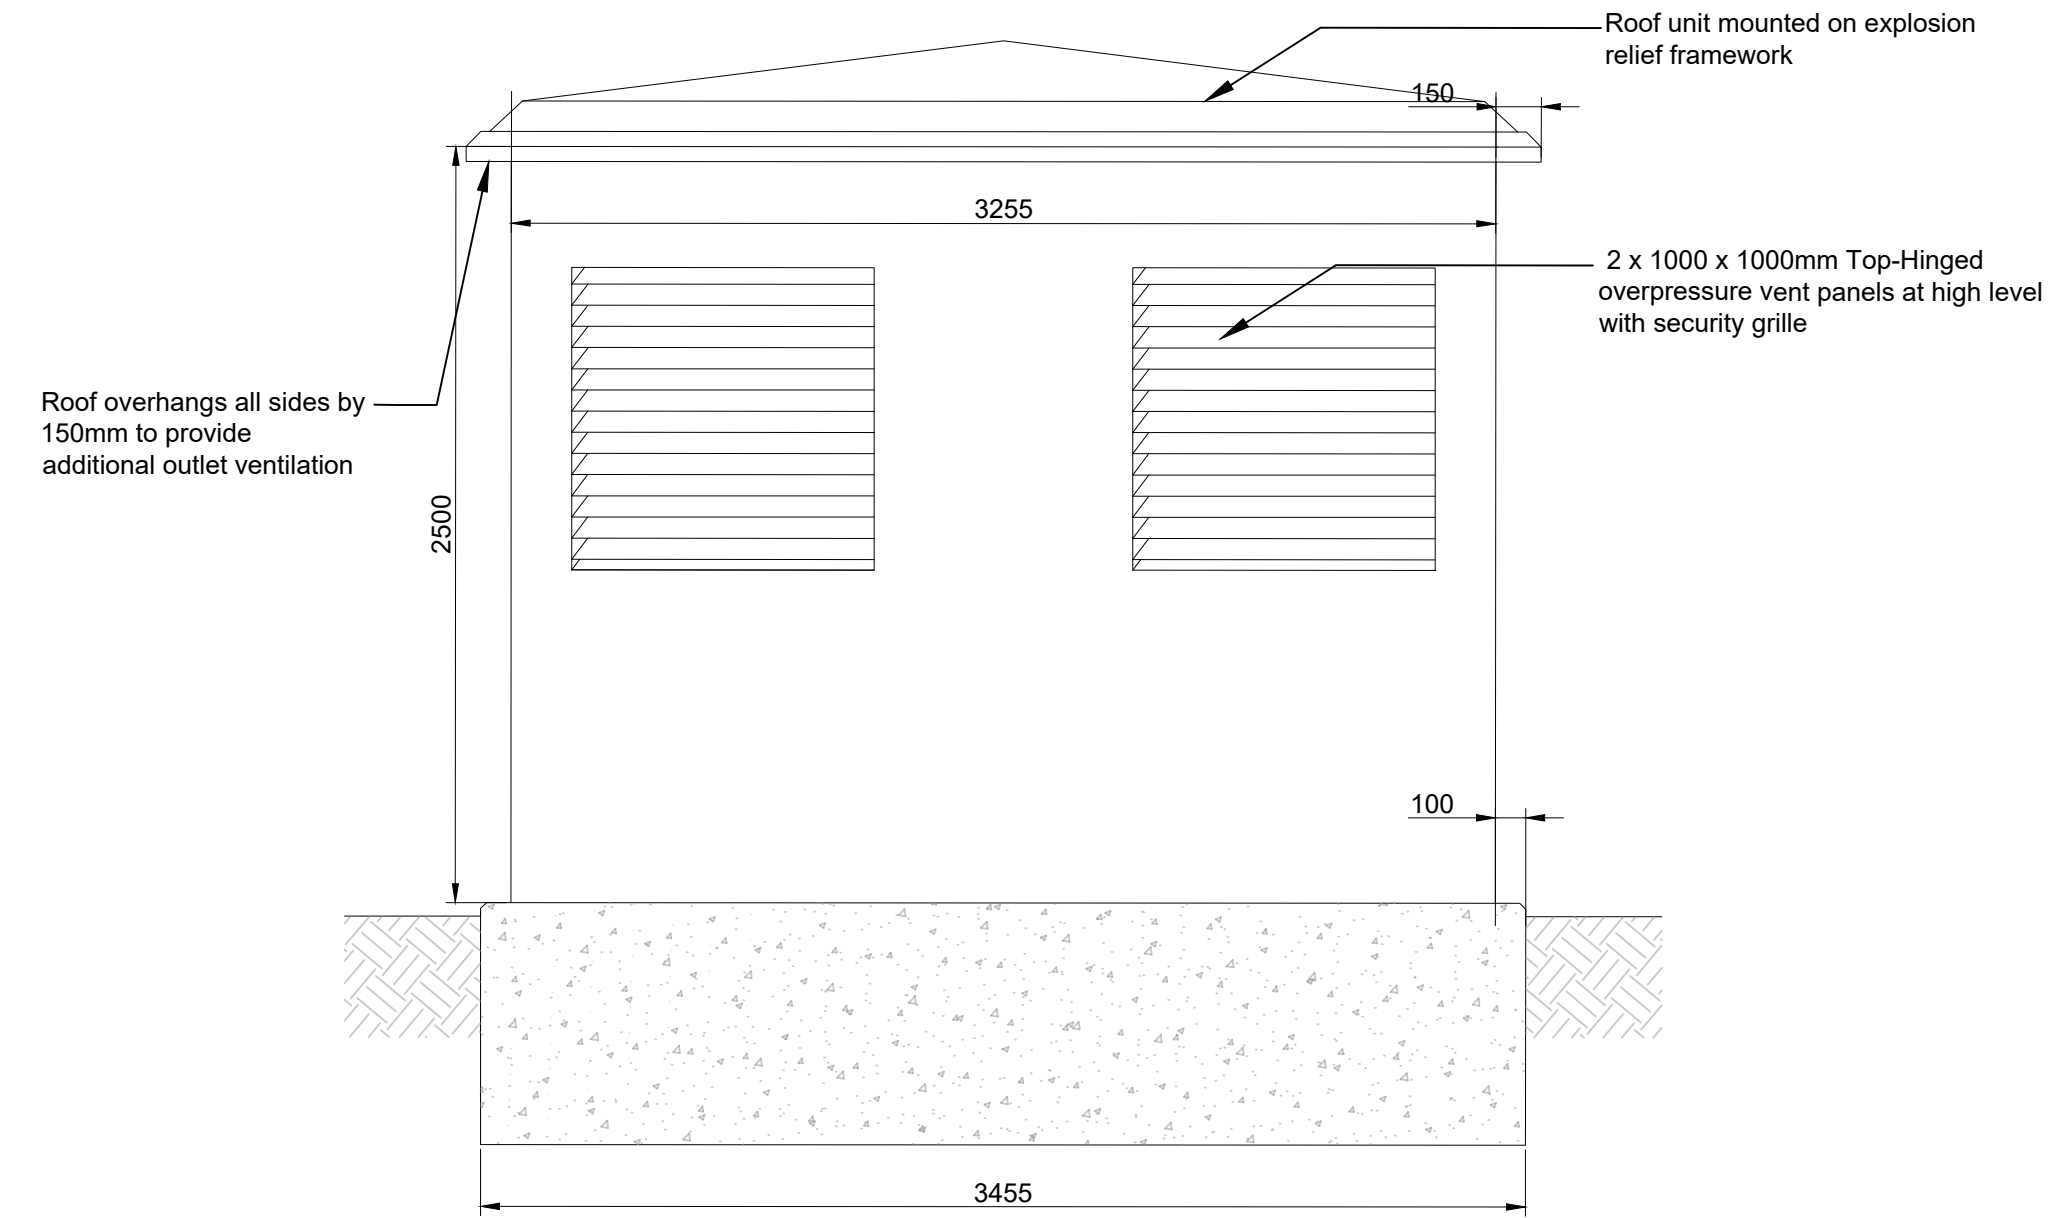


Side Elevation Scale 1:25

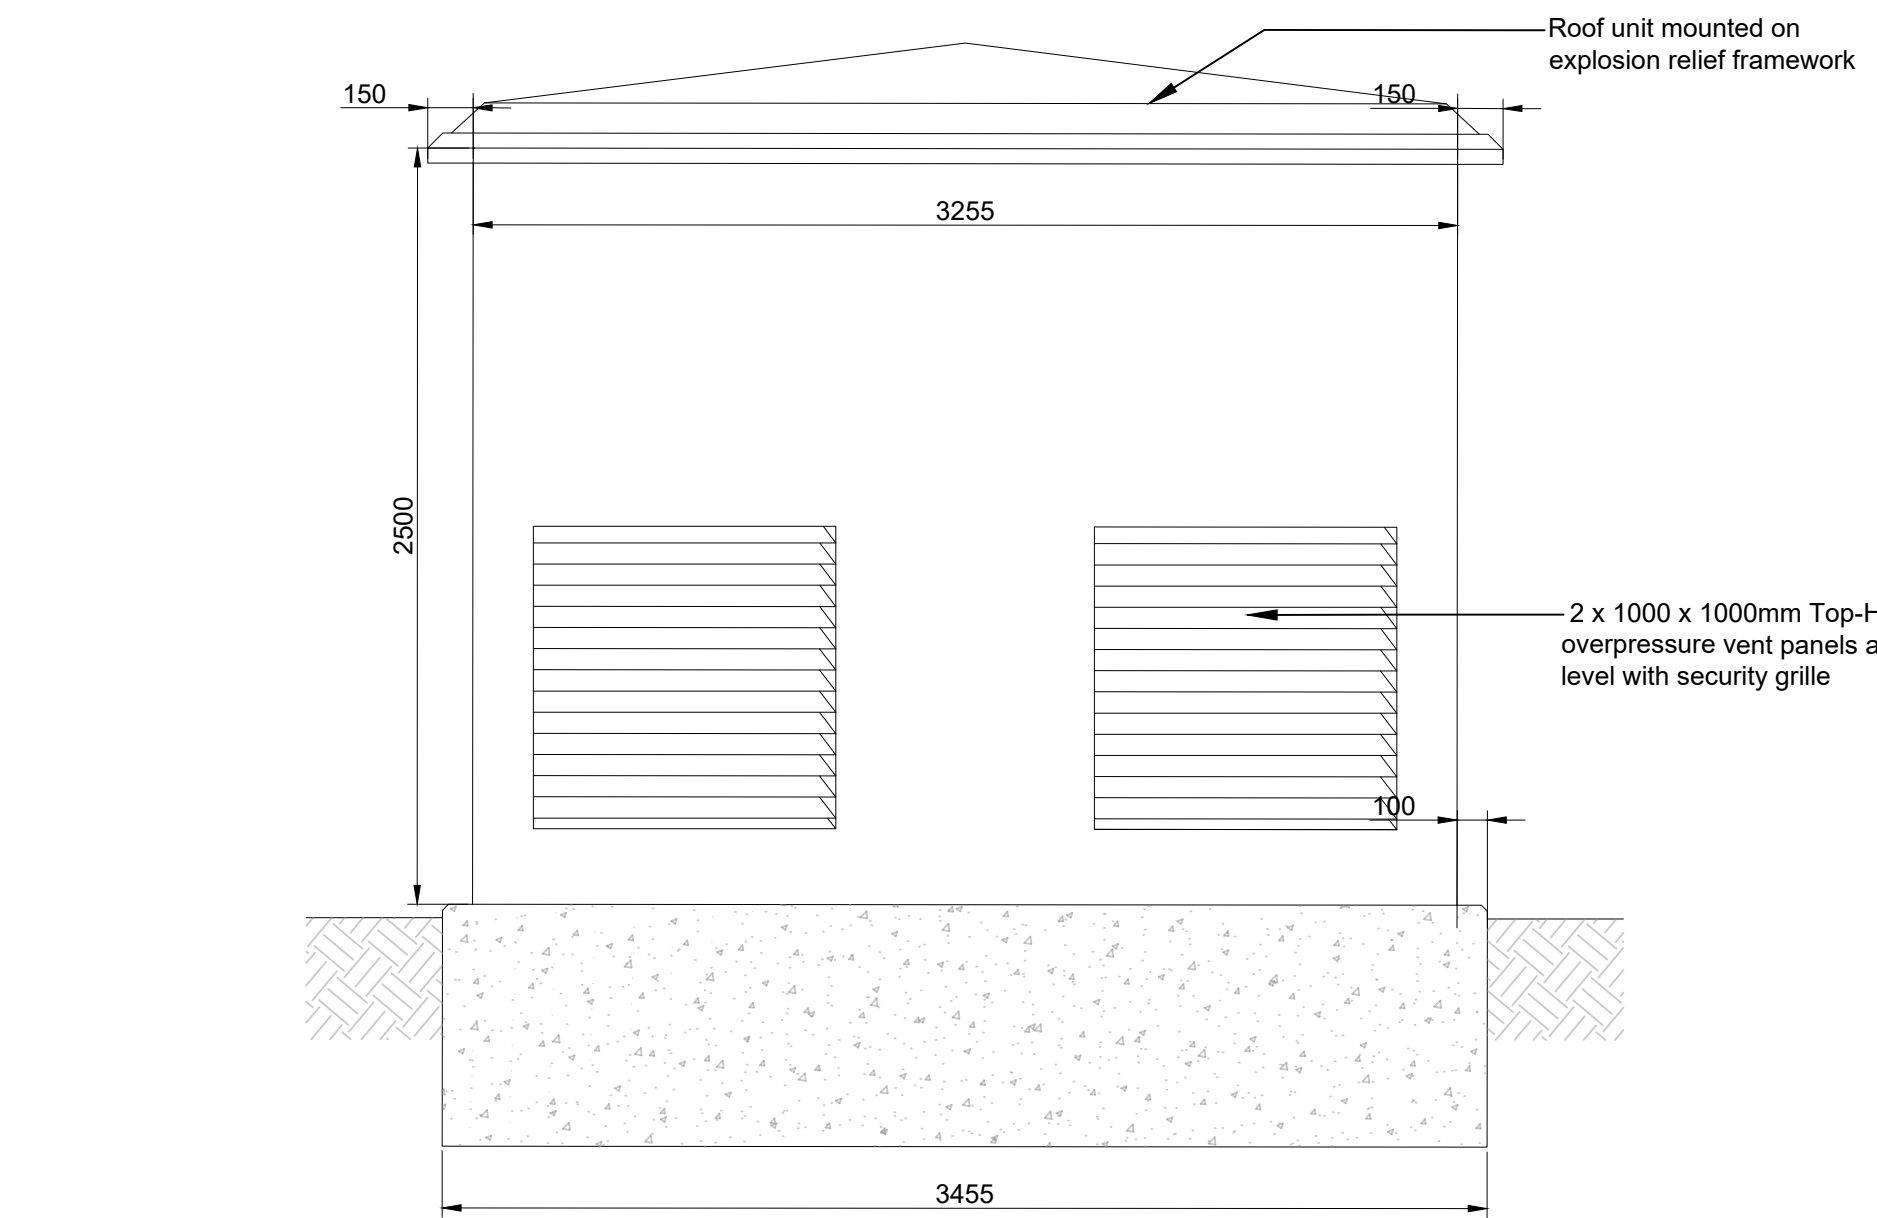

Side Elevation Scale 1:25

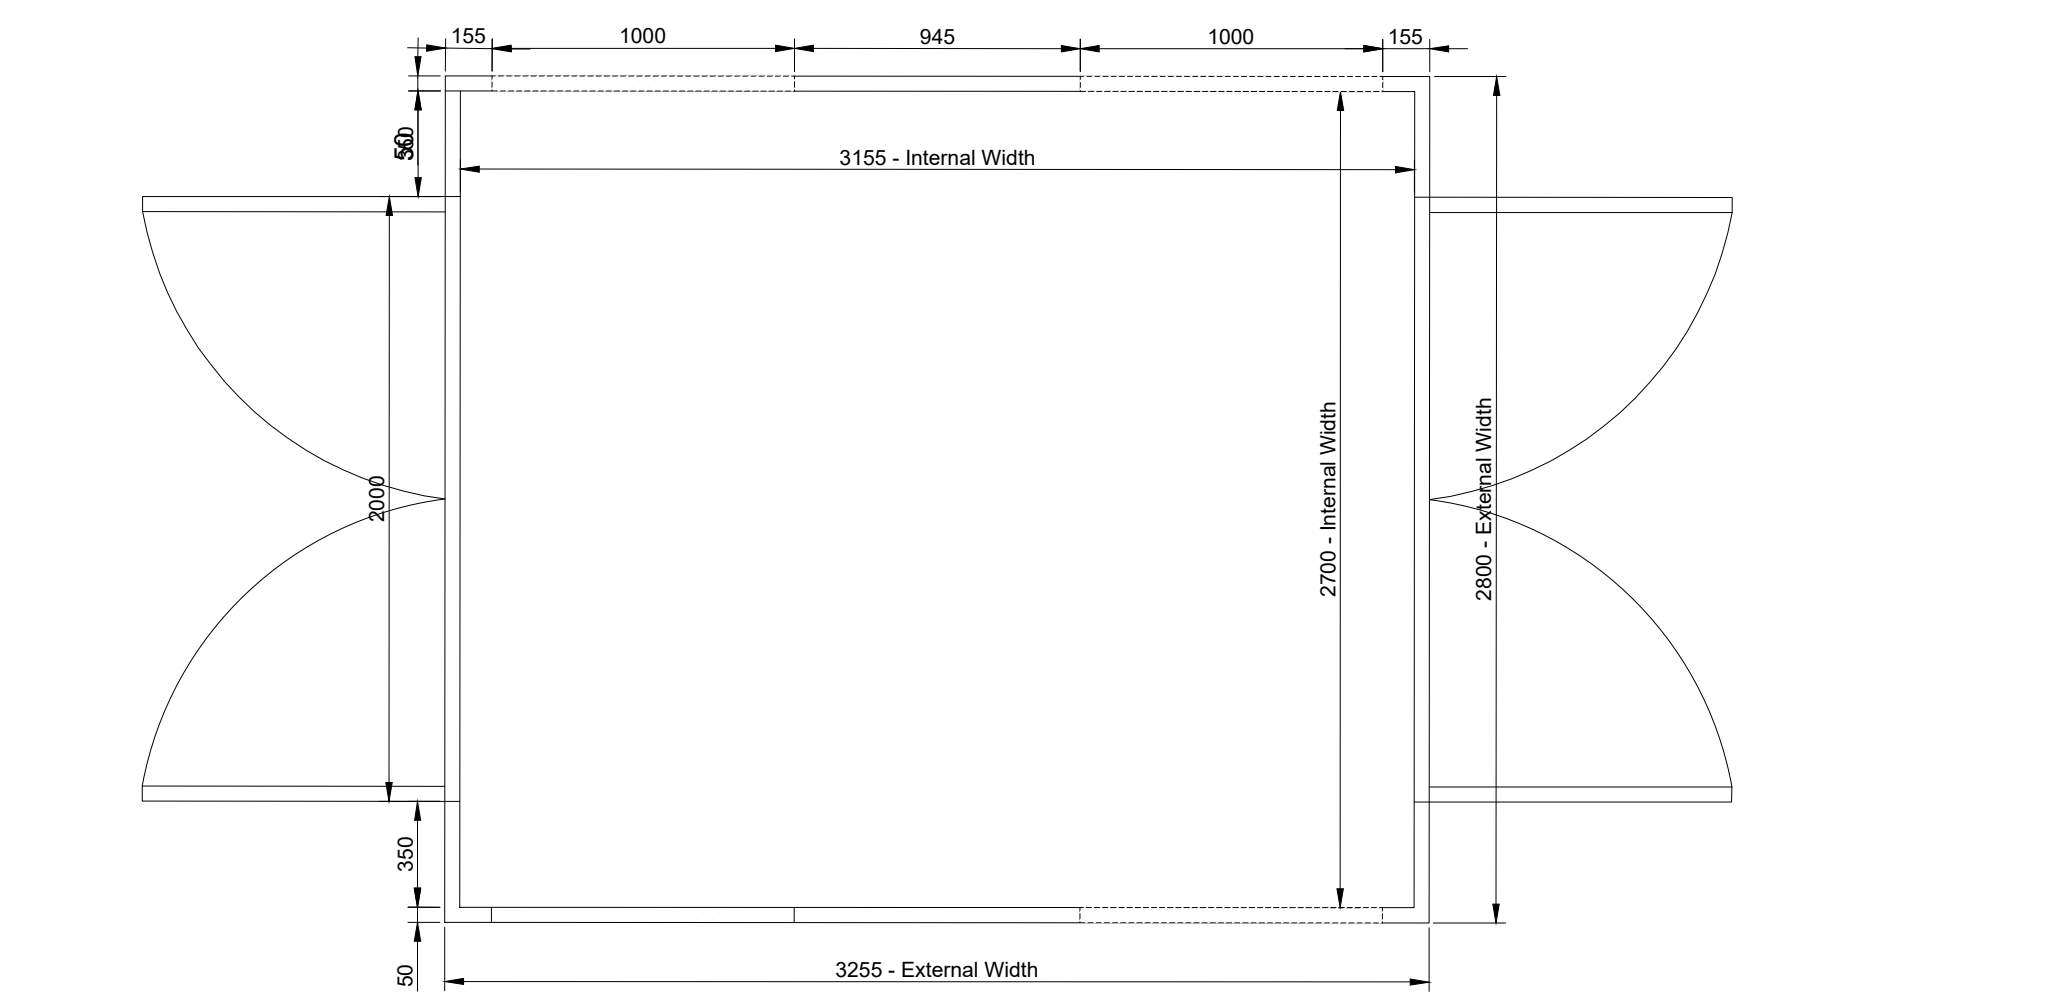

Substation Plan Scale 1:25

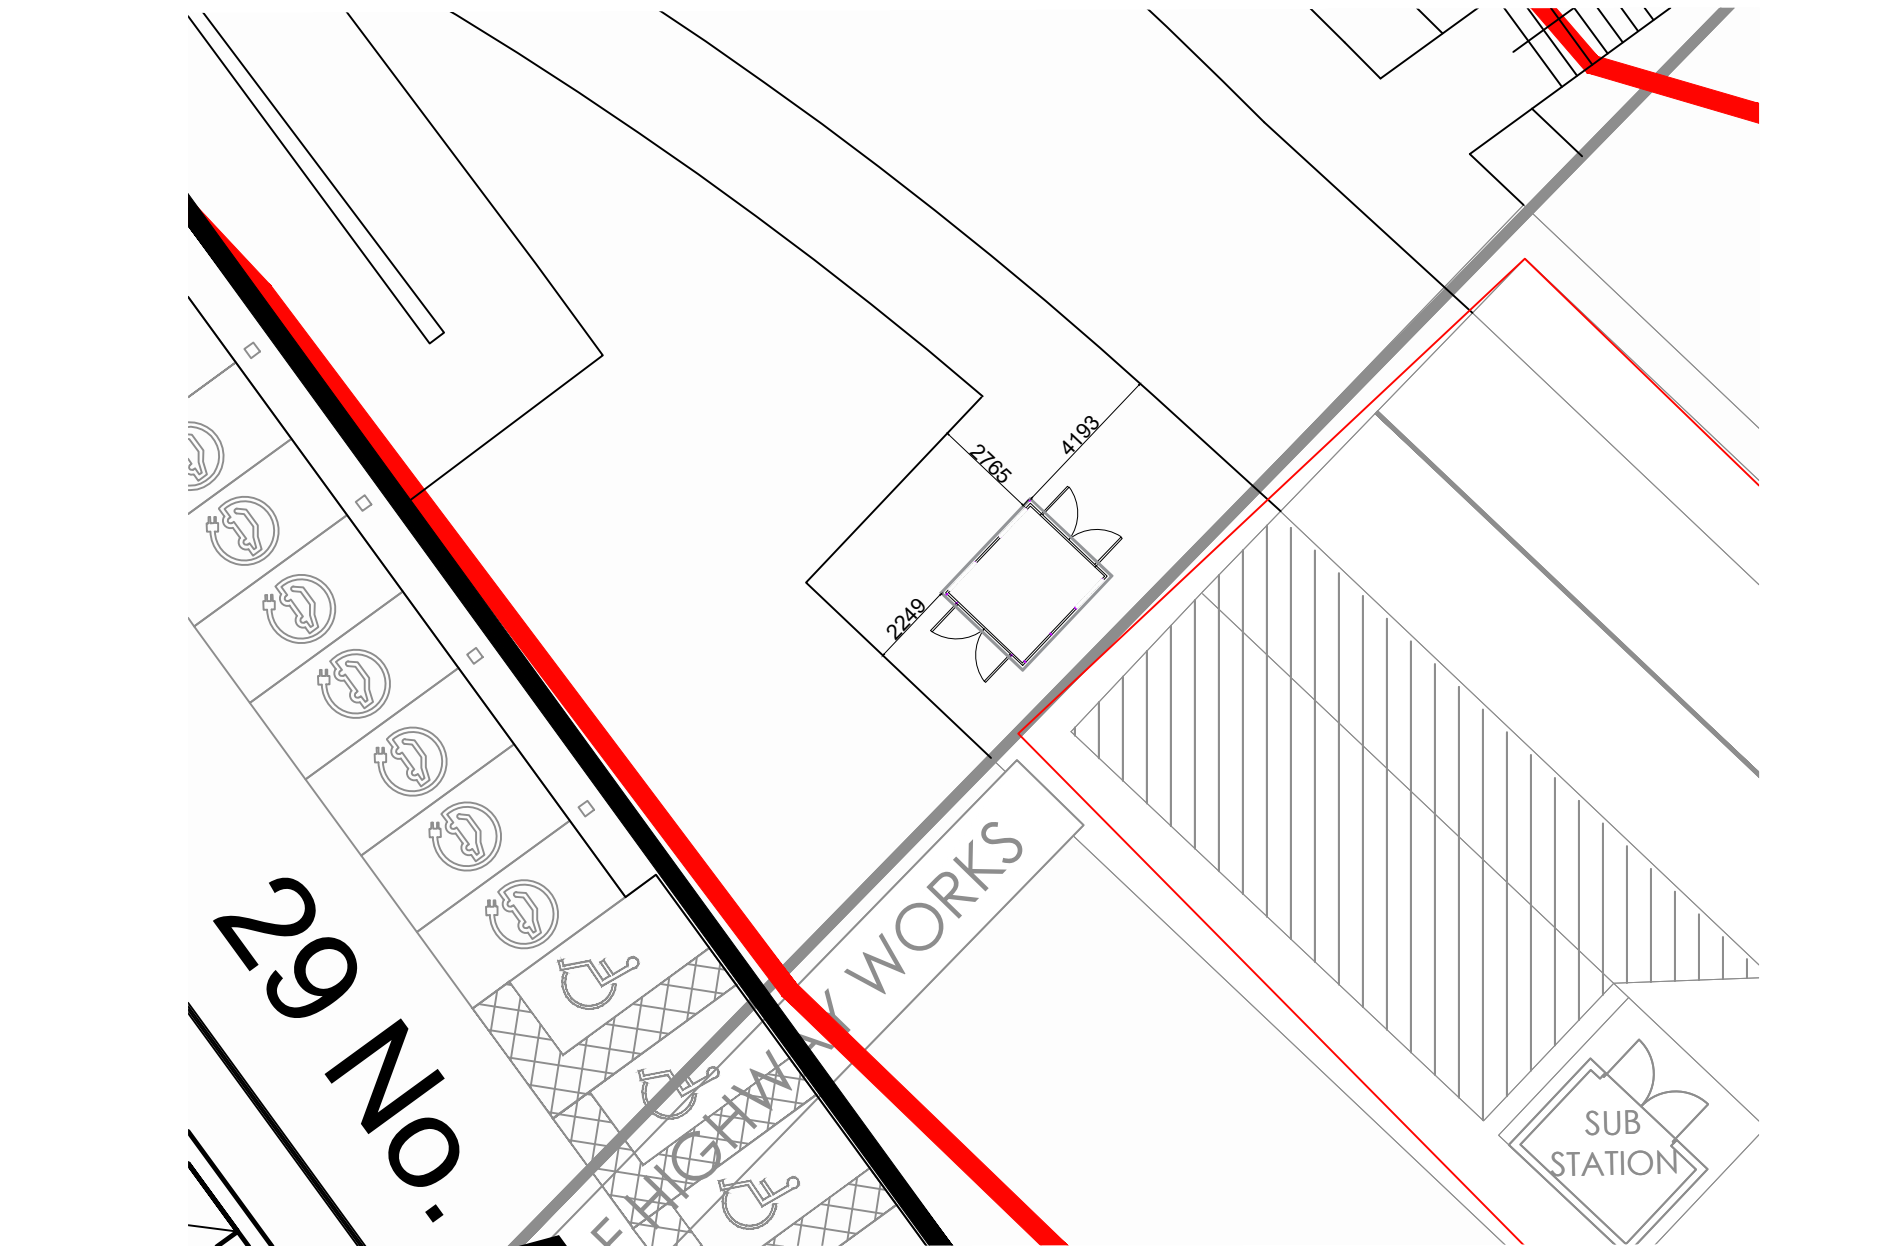

Call Out Scale 1:200


N

Key


Demise Boundary

Denotes Location of Substation.

NOTE: Substation finishes colour:
RAL 18-B-25 Merlin Grey

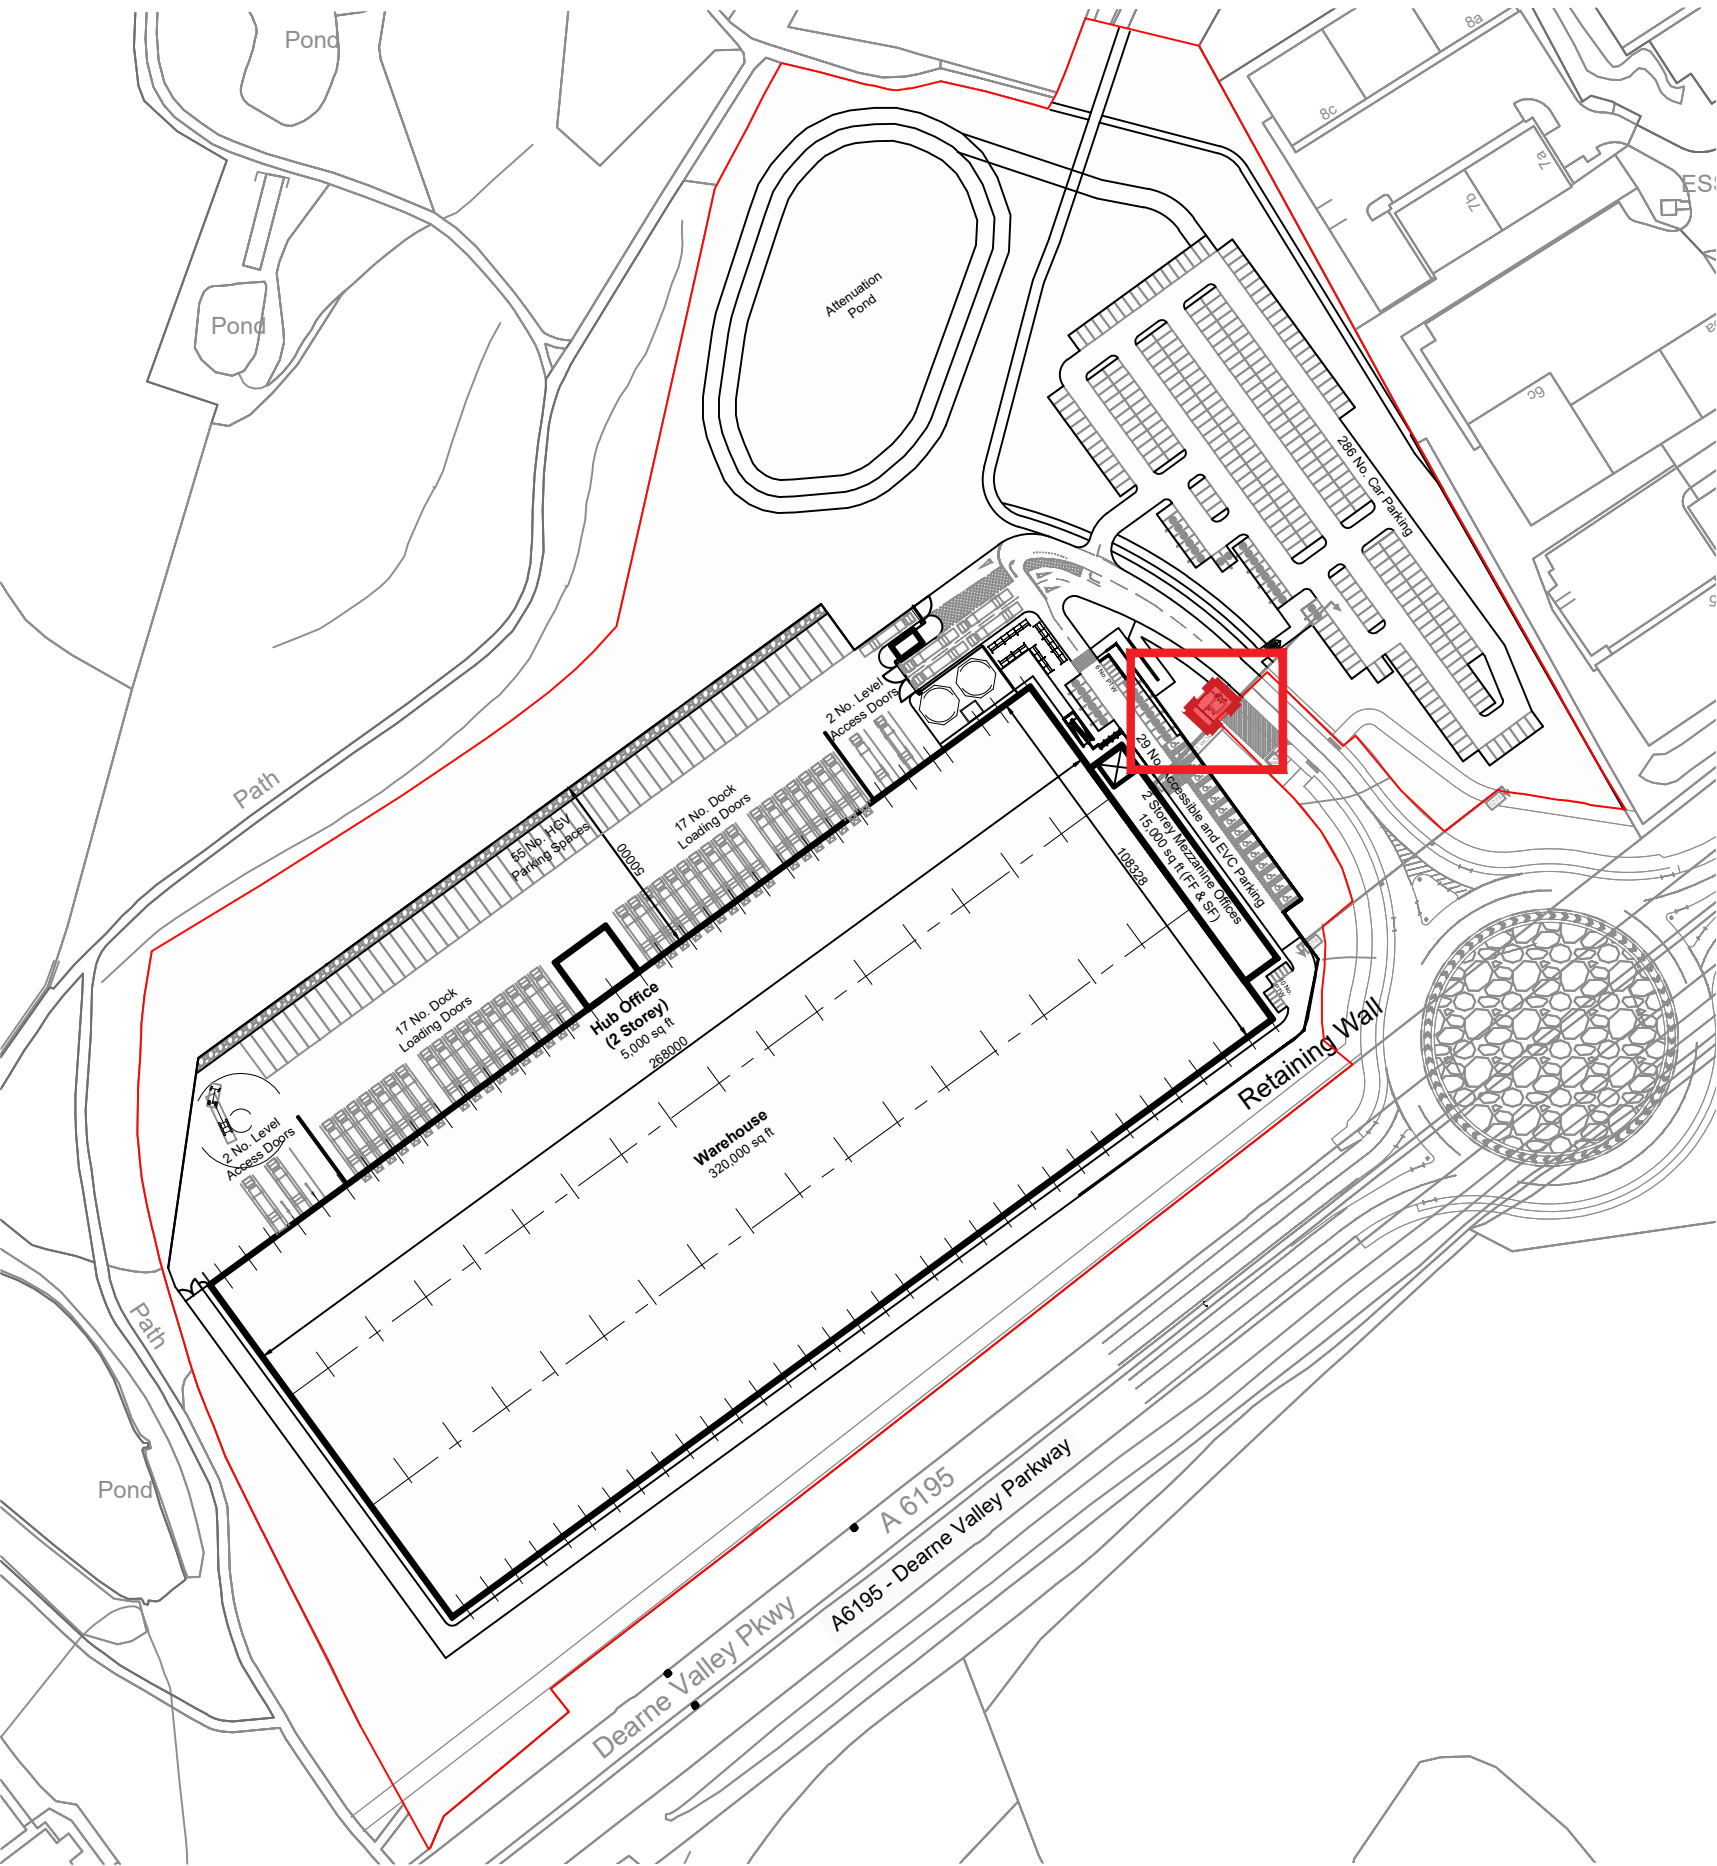

Site Plan Scale 1:2000

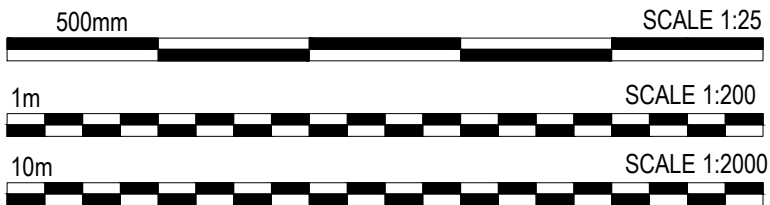

rev

amendments

by

ckd

date

Dearne Valley Parkway, Barnsley

Substation No.1 Details

Information Container LOD: Verified

FirethornTRUST

Glencar

CONSTRUCTION

umc

architects

3rd Floor, Manchester Club, 81 King Street, Manchester, M2 4AH
t. +44 (0)161 413 0590
e. info@umcarchitects.com

RIBA PoW Stage: S1

Document Suitability: CO / BSC

Date: 31/05/2023

Scale: 1:1000 A1

UMC Project Number: 21049

Document Reference: G1144 - UMC -ZZ-XX - DR - A

3 - Spatial Coordination

Drawing no: 00704

Revision: P02