


Scale: 1:1250 Paper Size: A4 Map Centre: 440495,411095

0m 70m

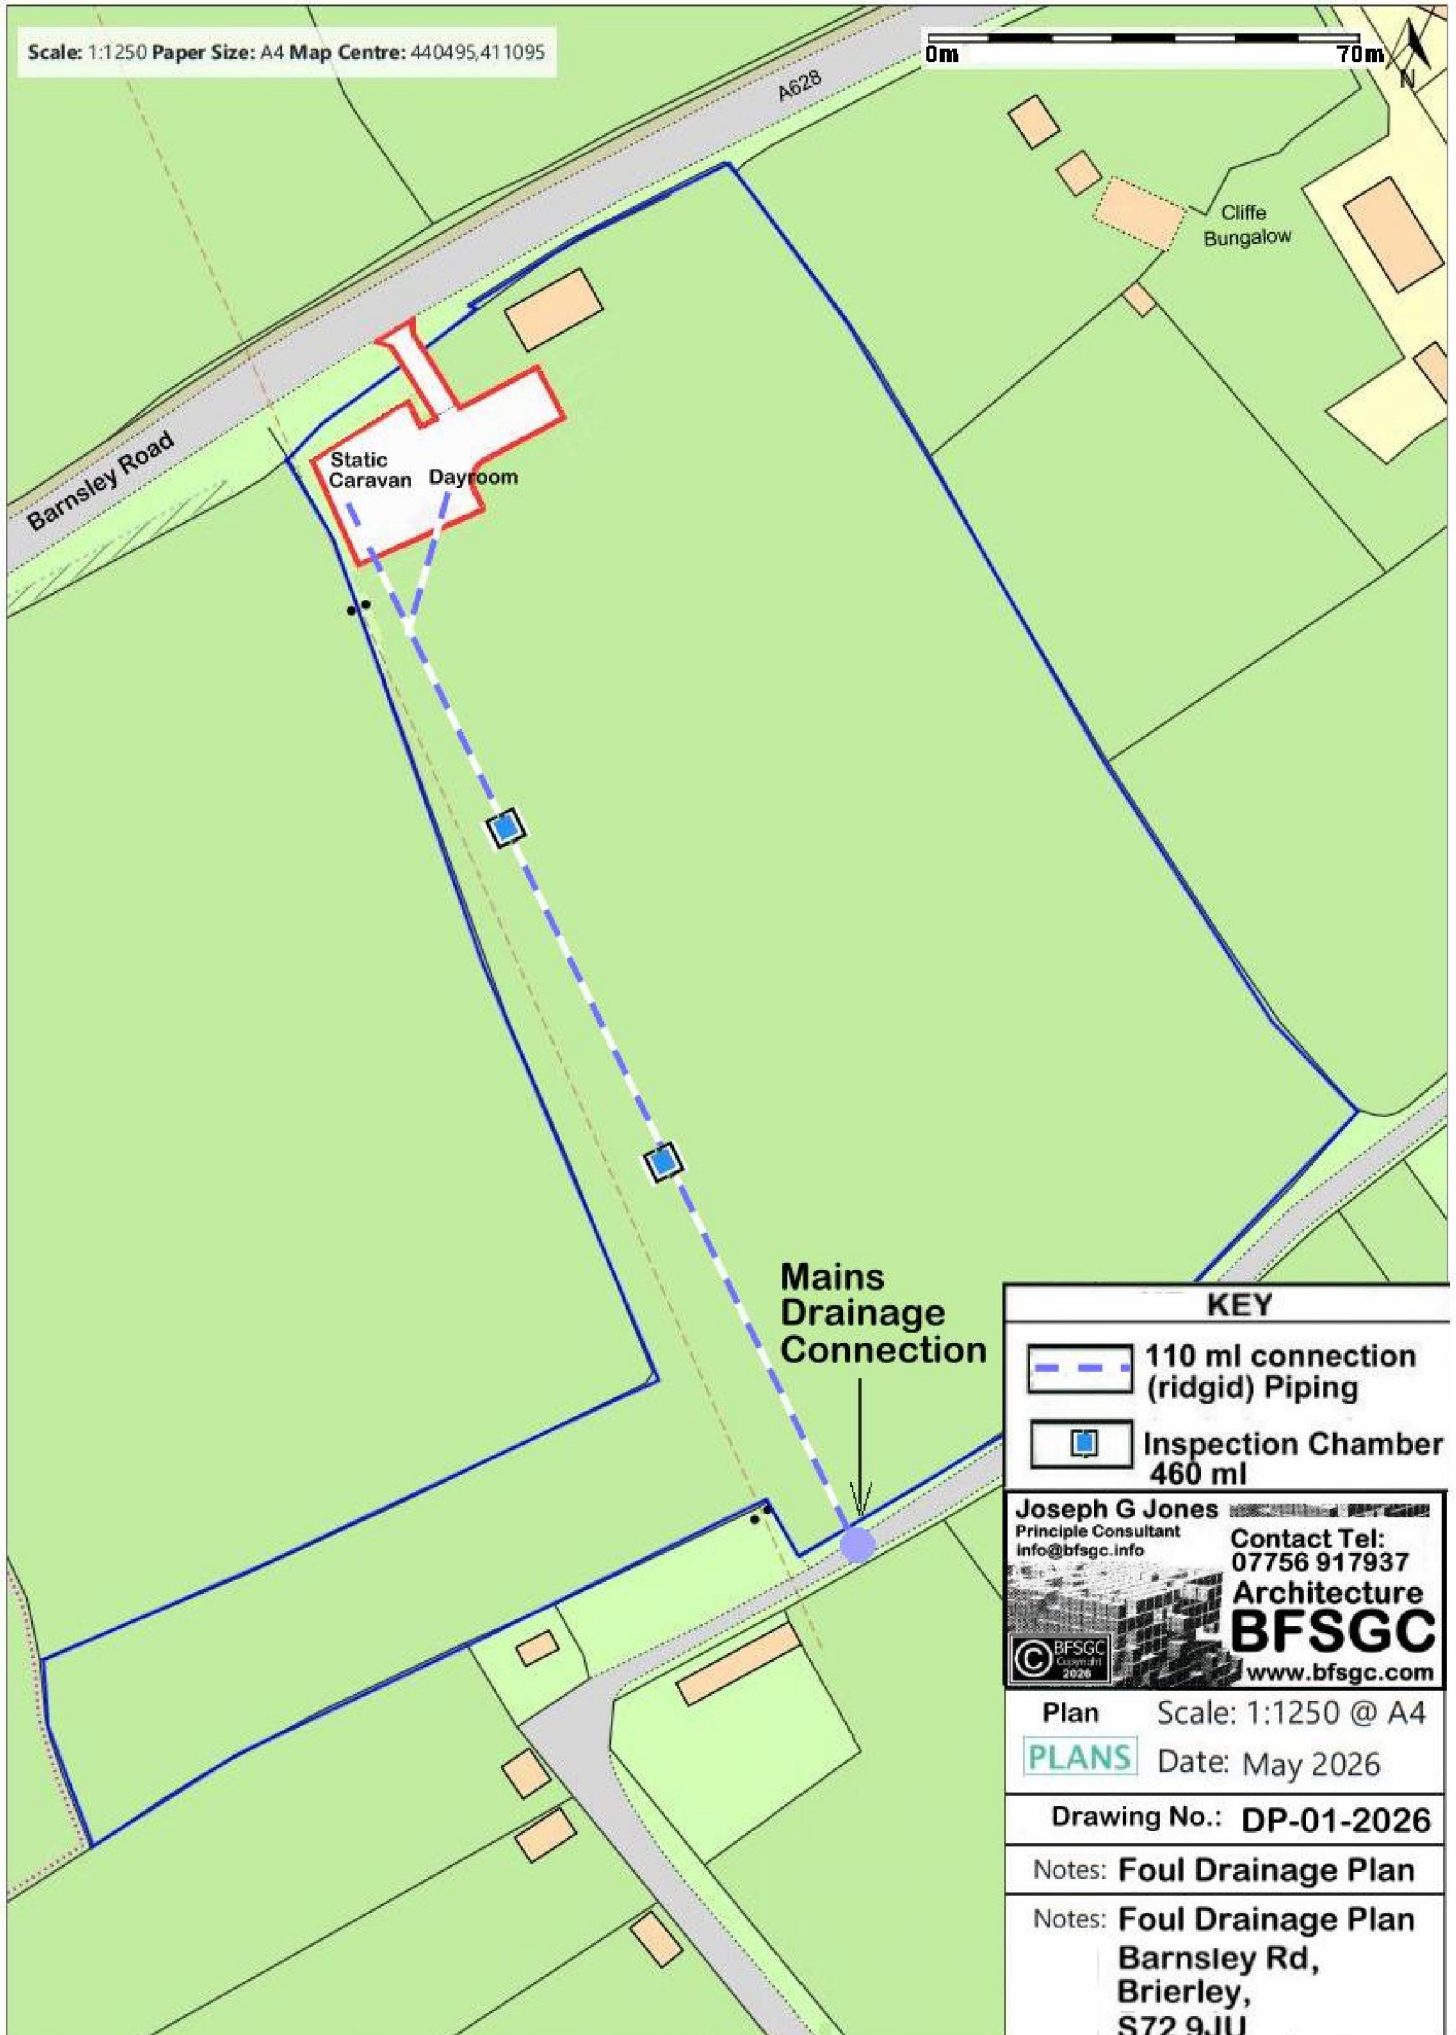

KEY

-  110 ml connection (rigid) Piping
-  Inspection Chamber 460 ml

Joseph G Jones
Principle Consultant
info@bfsgc.info

Contact Tel:
07756 917937
Architecture
BFSGC
www.bfsgc.com



Plan Scale: 1:1250 @ A4

PLANS Date: May 2026

Drawing No.: DP-01-2026

Notes: **Foul Drainage Plan**

Notes: **Foul Drainage Plan**
Barnsley Rd,
Brierley,
S72 9JU