

 **Standard construction hazards that a competent contractor would be aware of have not been identified on this drawing. Any risks not immediately apparent are identified within the CDM Residual Risk Register.**


LEGEND

SVP - SOIL VENT PIPE
WVP - WASTE VENT PIPE
WP - WASTE PIPE
AAV - AIR ADMITTANCE VALVE
RE - RODDING EYE


 EXISTING ABOVE GROUND DRAINAGE PIPEWORK, FITTINGS, BRACKETS, FIXINGS AND ANCILLARY ITEMS TO BE DECOMMISSIONED AND STRIPPED BACK TO THE CONNECTION TO BELOW GROUND DRAINAGE SYSTEM. WHERE EXISTING CONNECTIONS ARE TO NOT BE UTILISED AS PART OF THE NEW INSTALLATION, THE CONNECTIONS ARE TO BE SUITABLY SEALED AND CAPPED.

NOTES

- THIS DRAWING SHOWS THE DESIGN PROPOSAL FOR A WORKSTAGE 4 TECHNICAL DESIGN LEVEL OF DETAIL AND COMPLETENESS AS DEFINED BY BSRIA 958:2018. ALL QUANTITIES AND LOCATIONS ARE BASED ON GENERIC EQUIPMENT SELECTIONS AND SHALL BE CONFIRMED AND FULLY COORDINATED AS PART OF THE CONSTRUCTION STAGE DESIGN ACTIVITIES.
- ALL DIMENSIONS ARE IN MILLIMETERS UNLESS NOTATED OTHERWISE.
- ALL PIPE SIZES AND EQUIPMENT SELECTIONS ARE PROVISIONAL.
- PIPEWORK SHALL BE ADEQUATELY SUPPORTED IN THE RUNNING LENGTH USING PROPRIETARY CLIPS, BRACKETS & SUPPORT SYSTEMS.
- PIPELINES PASSING THROUGH A FIRE RATED ELEMENT OF CONSTRUCTION SHALL INCLUDE A SUITABLY RATED FIRE COLLAR.
- RODDING ACCESS POINTS SHALL BE PROVIDED IN VERTICAL PIPEWORK AT GROUND LEVEL AND EVERY 3RD STOREY, LOCATED 150mm ABOVE FFL.
- RODDING ACCESS POINTS SHALL BE PROVIDED IN THE ENDS OF HORIZONTAL SOIL AND WASTE PIPEWORK AND AT CHANGES IN PIPE DIRECTION.
- INCLUDE PROPRIETARY WATERLESS TRAPS AT RELIEF VALVE TUNDRISH WASTE PIPE AND CONDENSATE DISPOSAL PIPE CONNECTIONS INTO THE AGD PIPE SYSTEM.
- SVPS NOT ROUTED TO ABOVE ROOF LEVEL SHALL INCLUDE A PROPRIETARY AIR ADMITTANCE VALVE ASSEMBLY.
- SVPS WHICH EXIT THE BUILDING THROUGH THE ROOF SHALL BE FITTED WITH A SUITABLE WEATHER FLASHING AND PROPRIETARY PIPE TERMINAL/BIRD SCREEN.
- WASTE PIPEWORK AND FITTINGS SHALL BE IN PUSH-JOINTED PVCU PIPE, SIZES < 40mm DIA.
- SOIL PIPEWORK AND FITTINGS SHALL BE PUSH-JOINTED PVCU PIPE, SIZES > 82mm DIA.

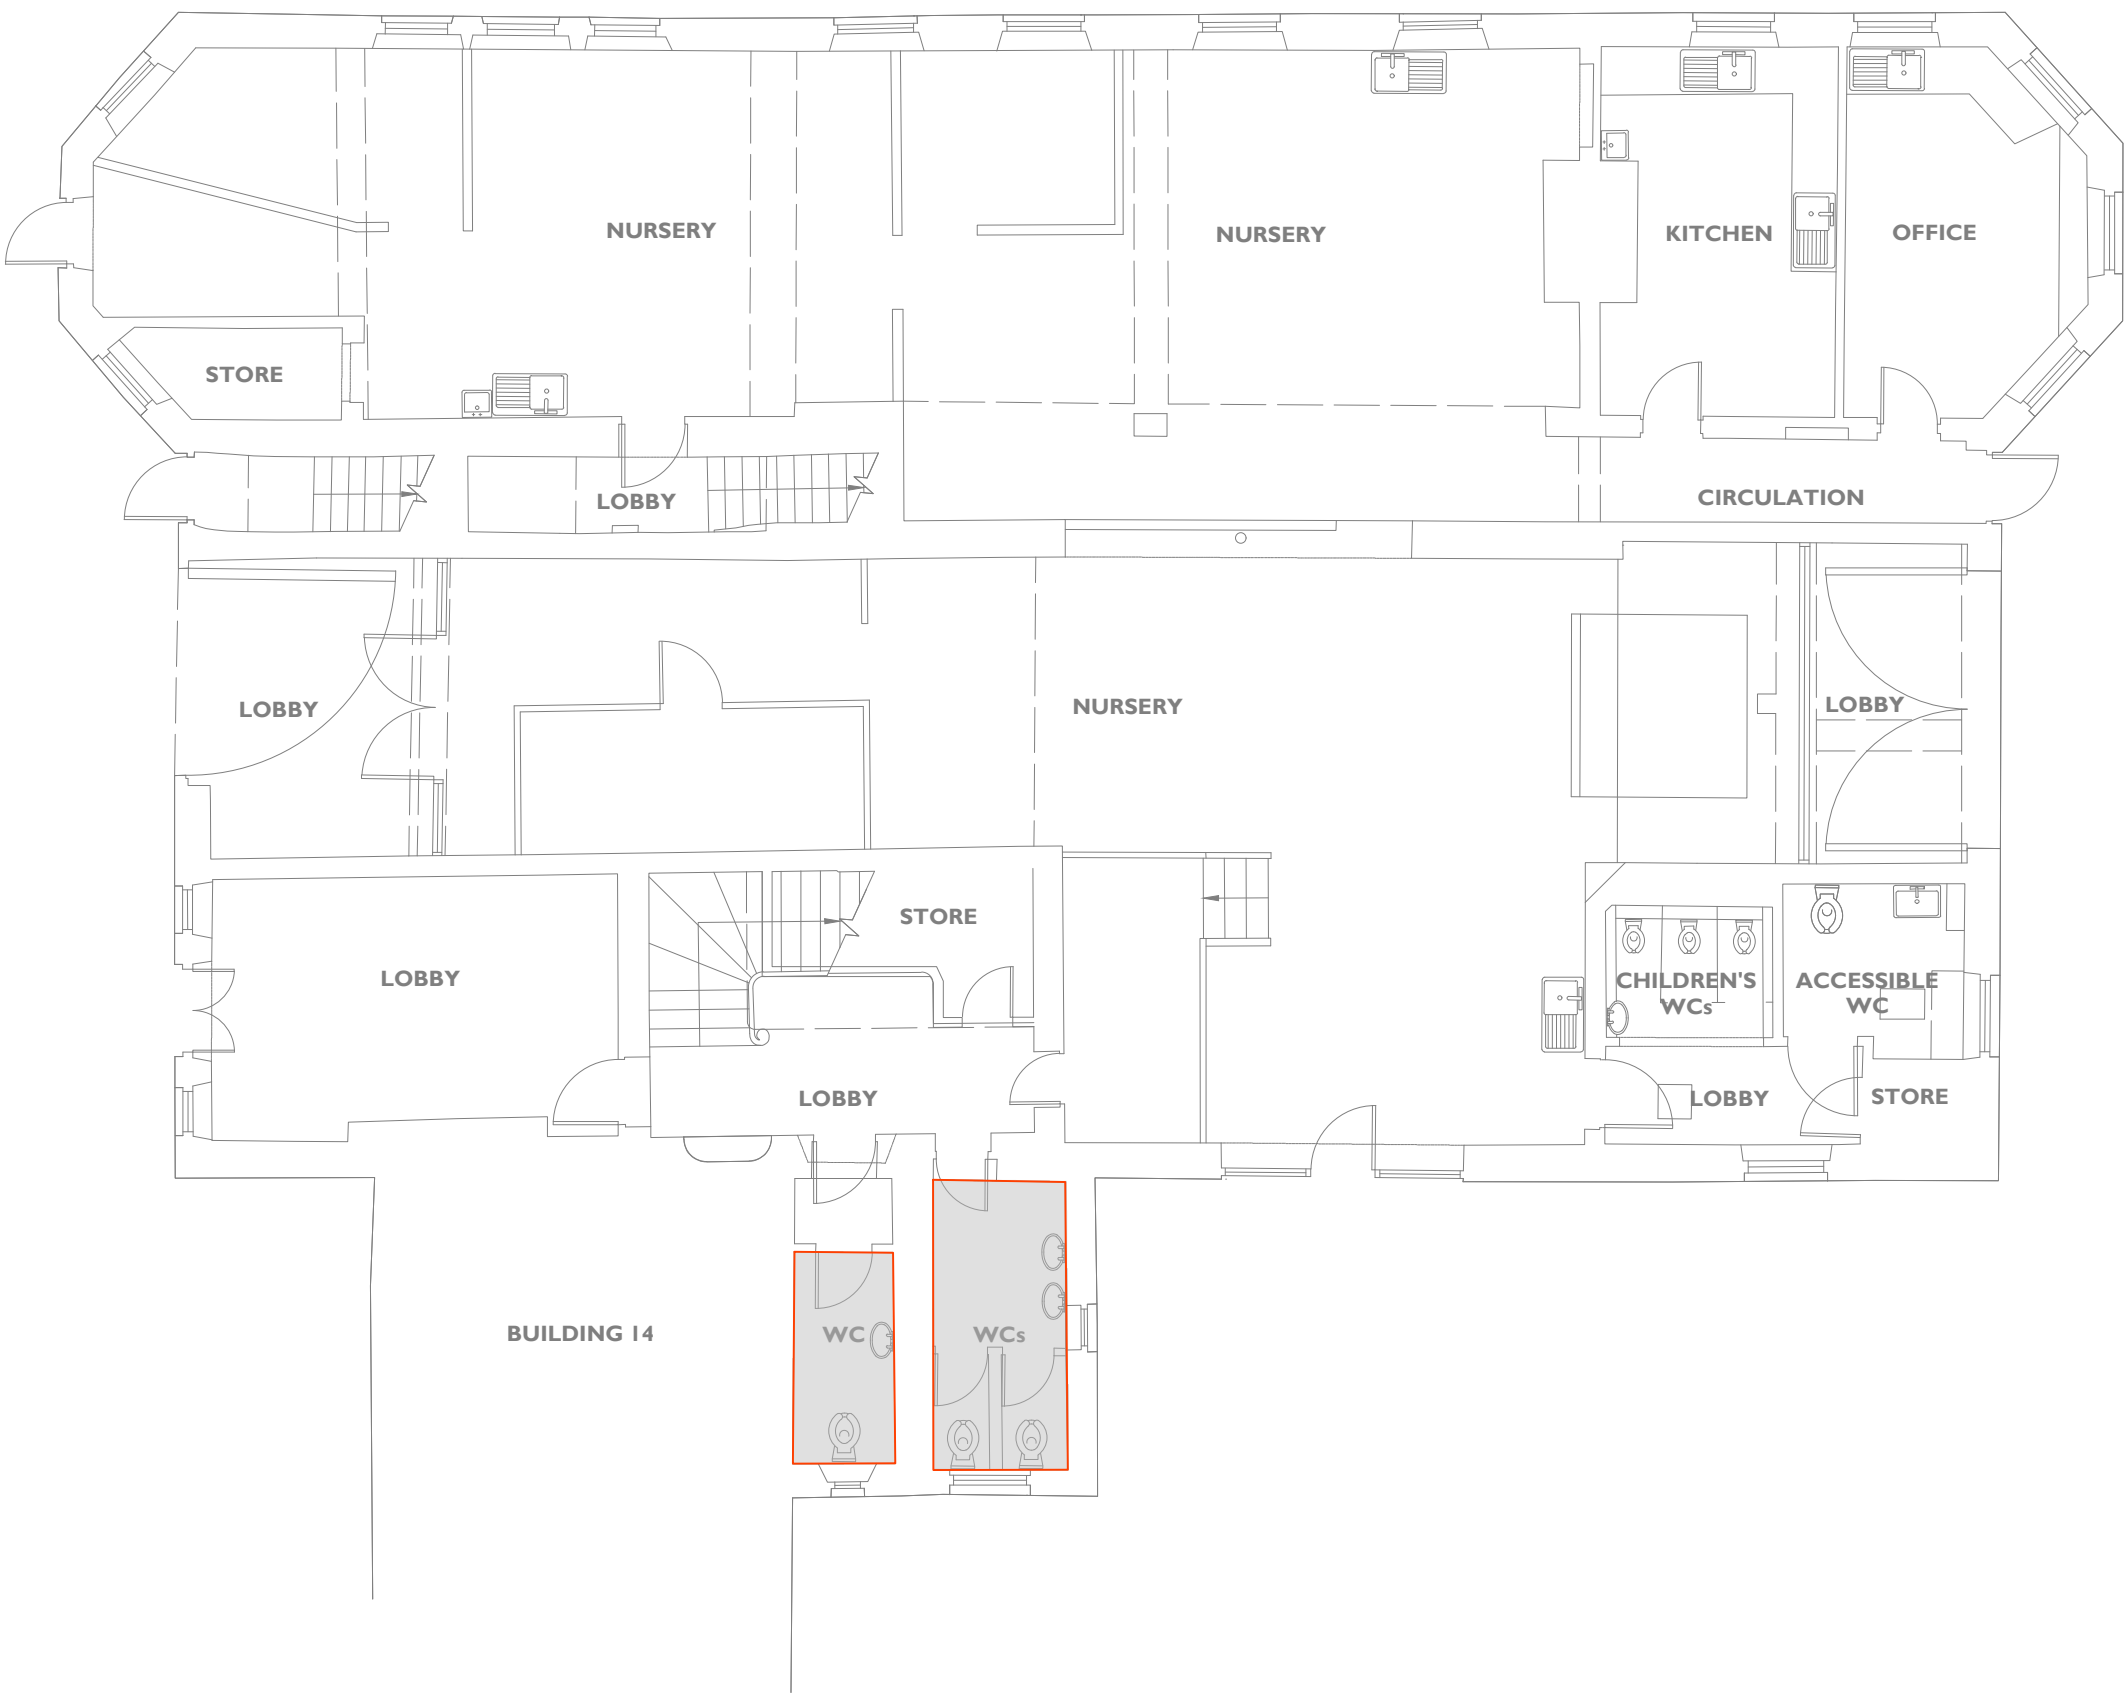

P04	22.08.23	SUITABLE FOR TENDER	RC	RE
P03	25.08.23	STAGE 4 REVIEW	BM	RE
P02	02.06.23	UPDATED TO ARCHITECTS COMMENTS AND LAYOUTS	LC	RP
P01	31.03.23	PRELIMINARY ISSUE	JW	RE
REV	DATE	DESCRIPTION	DRAWN	APP

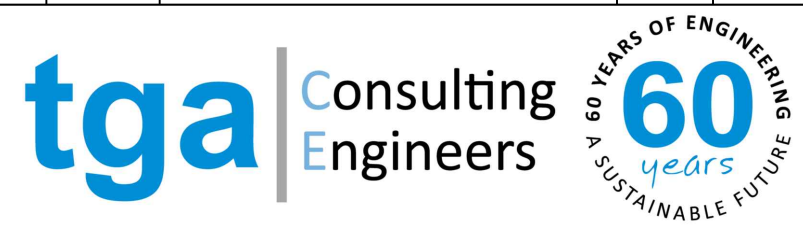

tga Consulting Engineers
60 years
A SUSTAINABLE FUTURE

TGA Consulting Engineers LLP,
Salvus House, Aykley Heads, Durham City. DH1 5TS.
E: info@tgace.co.uk T: 0191 3862314

Project

ELSECAR: FORGING AHEAD

Title

MECHANICAL ENGINEERING SERVICES
EXISTING ABOVE GROUND DRAINAGE SYSTEM
BUILDING 13
GROUND FLOOR

Architect

PURCELL

Client

BARNSELEY MBC

Suitability:	Code	Description
	D2	FOR TENDER

Revision:	Scale:	TGA Proj No:	Stage:
P04	1:100	8193	4

Drawing Reference:
Project-Originator-Zone-Level-Type-Role-Classification-Number
EFAS-TGA-13-00-DR-M-52001

 **Standard construction hazards that a competent contractor would be aware of have not been identified on this drawing. Any risks not immediately apparent are identified within the CDM Residual Risk Register.**


LEGEND

- SVP - SOIL VENT PIPE
WVP - WASTE VENT PIPE
WP - WASTE PIPE
AAV - AIR ADMITTANCE VALVE
RE - RODDING EYE


 EXISTING ABOVE GROUND DRAINAGE PIPEWORK, FITTINGS, BRACKETS, FIXINGS AND ANCILLARY ITEMS TO BE DECOMMISSIONED AND STRIPPED BACK TO THE CONNECTION TO BELOW GROUND DRAINAGE SYSTEM. WHERE EXISTING CONNECTIONS ARE TO NOT BE UTILISED AS PART OF THE NEW INSTALLATION, THE CONNECTIONS ARE TO BE SUITABLY SEALED AND CAPPED.

NOTES

- THIS DRAWING SHOWS THE DESIGN PROPOSAL FOR A WORKSTAGE 4 TECHNICAL DESIGN LEVEL OF DETAIL AND COMPLETENESS AS DEFINED BY BSRIA B08:2018. ALL QUANTITIES AND LOCATIONS ARE BASED ON GENERIC EQUIPMENT SELECTIONS AND SHALL BE CONFIRMED AND FULLY COORDINATED AS PART OF THE CONSTRUCTION STAGE DESIGN ACTIVITIES.
- ALL DIMENSIONS ARE IN MILLIMETERS UNLESS NOTATED OTHERWISE.
- ALL PIPE SIZES AND EQUIPMENT SELECTIONS ARE PROVISIONAL.
- PIPEWORK SHALL BE ADEQUATELY SUPPORTED IN THE RUNNING LENGTH USING PROPRIETARY CLIPS, BRACKETS & SUPPORT SYSTEMS.
- PIPELINES PASSING THROUGH A FIRE RATED ELEMENT OF CONSTRUCTION SHALL INCLUDE A SUITABLY RATED FIRE COLLAR.
- RODDING ACCESS POINTS SHALL BE PROVIDED IN VERTICAL PIPEWORK AT GROUND LEVEL AND EVERY 3RD STOREY, LOCATED 1500mm ABOVE FFL.
- RODDING ACCESS POINTS SHALL BE PROVIDED IN THE ENDS OF HORIZONTAL SOIL AND WASTE PIPEWORK AND AT CHANGES IN PIPE DIRECTION.
- INCLUDE PROPRIETARY WATER-LESS TRAPS AT RELIEF VALVE TUNDRISH WASTE PIPE AND CONDENSATE DISPOSAL PIPE CONNECTIONS INTO THE AGD PIPE SYSTEM.
- SVPS NOT ROUTED TO ABOVE ROOF LEVEL SHALL INCLUDE A PROPRIETARY AIR ADMITTANCE VALVE ASSEMBLY.
- SVPS WHICH EXIT THE BUILDING THROUGH THE ROOF SHALL BE FITTED WITH A SUITABLE WEATHER FLASHING AND PROPRIETARY PIPE TERMINAL/BIRD SCREEN.
- WASTE PIPEWORK AND FITTINGS SHALL BE IN PUSH-JOINTED PVCU PIPE, SIZES < 40mm DIA.
- SOIL PIPEWORK AND FITTINGS SHALL BE PUSH-JOINTED PVCU PIPE, SIZES > 82mm DIA.

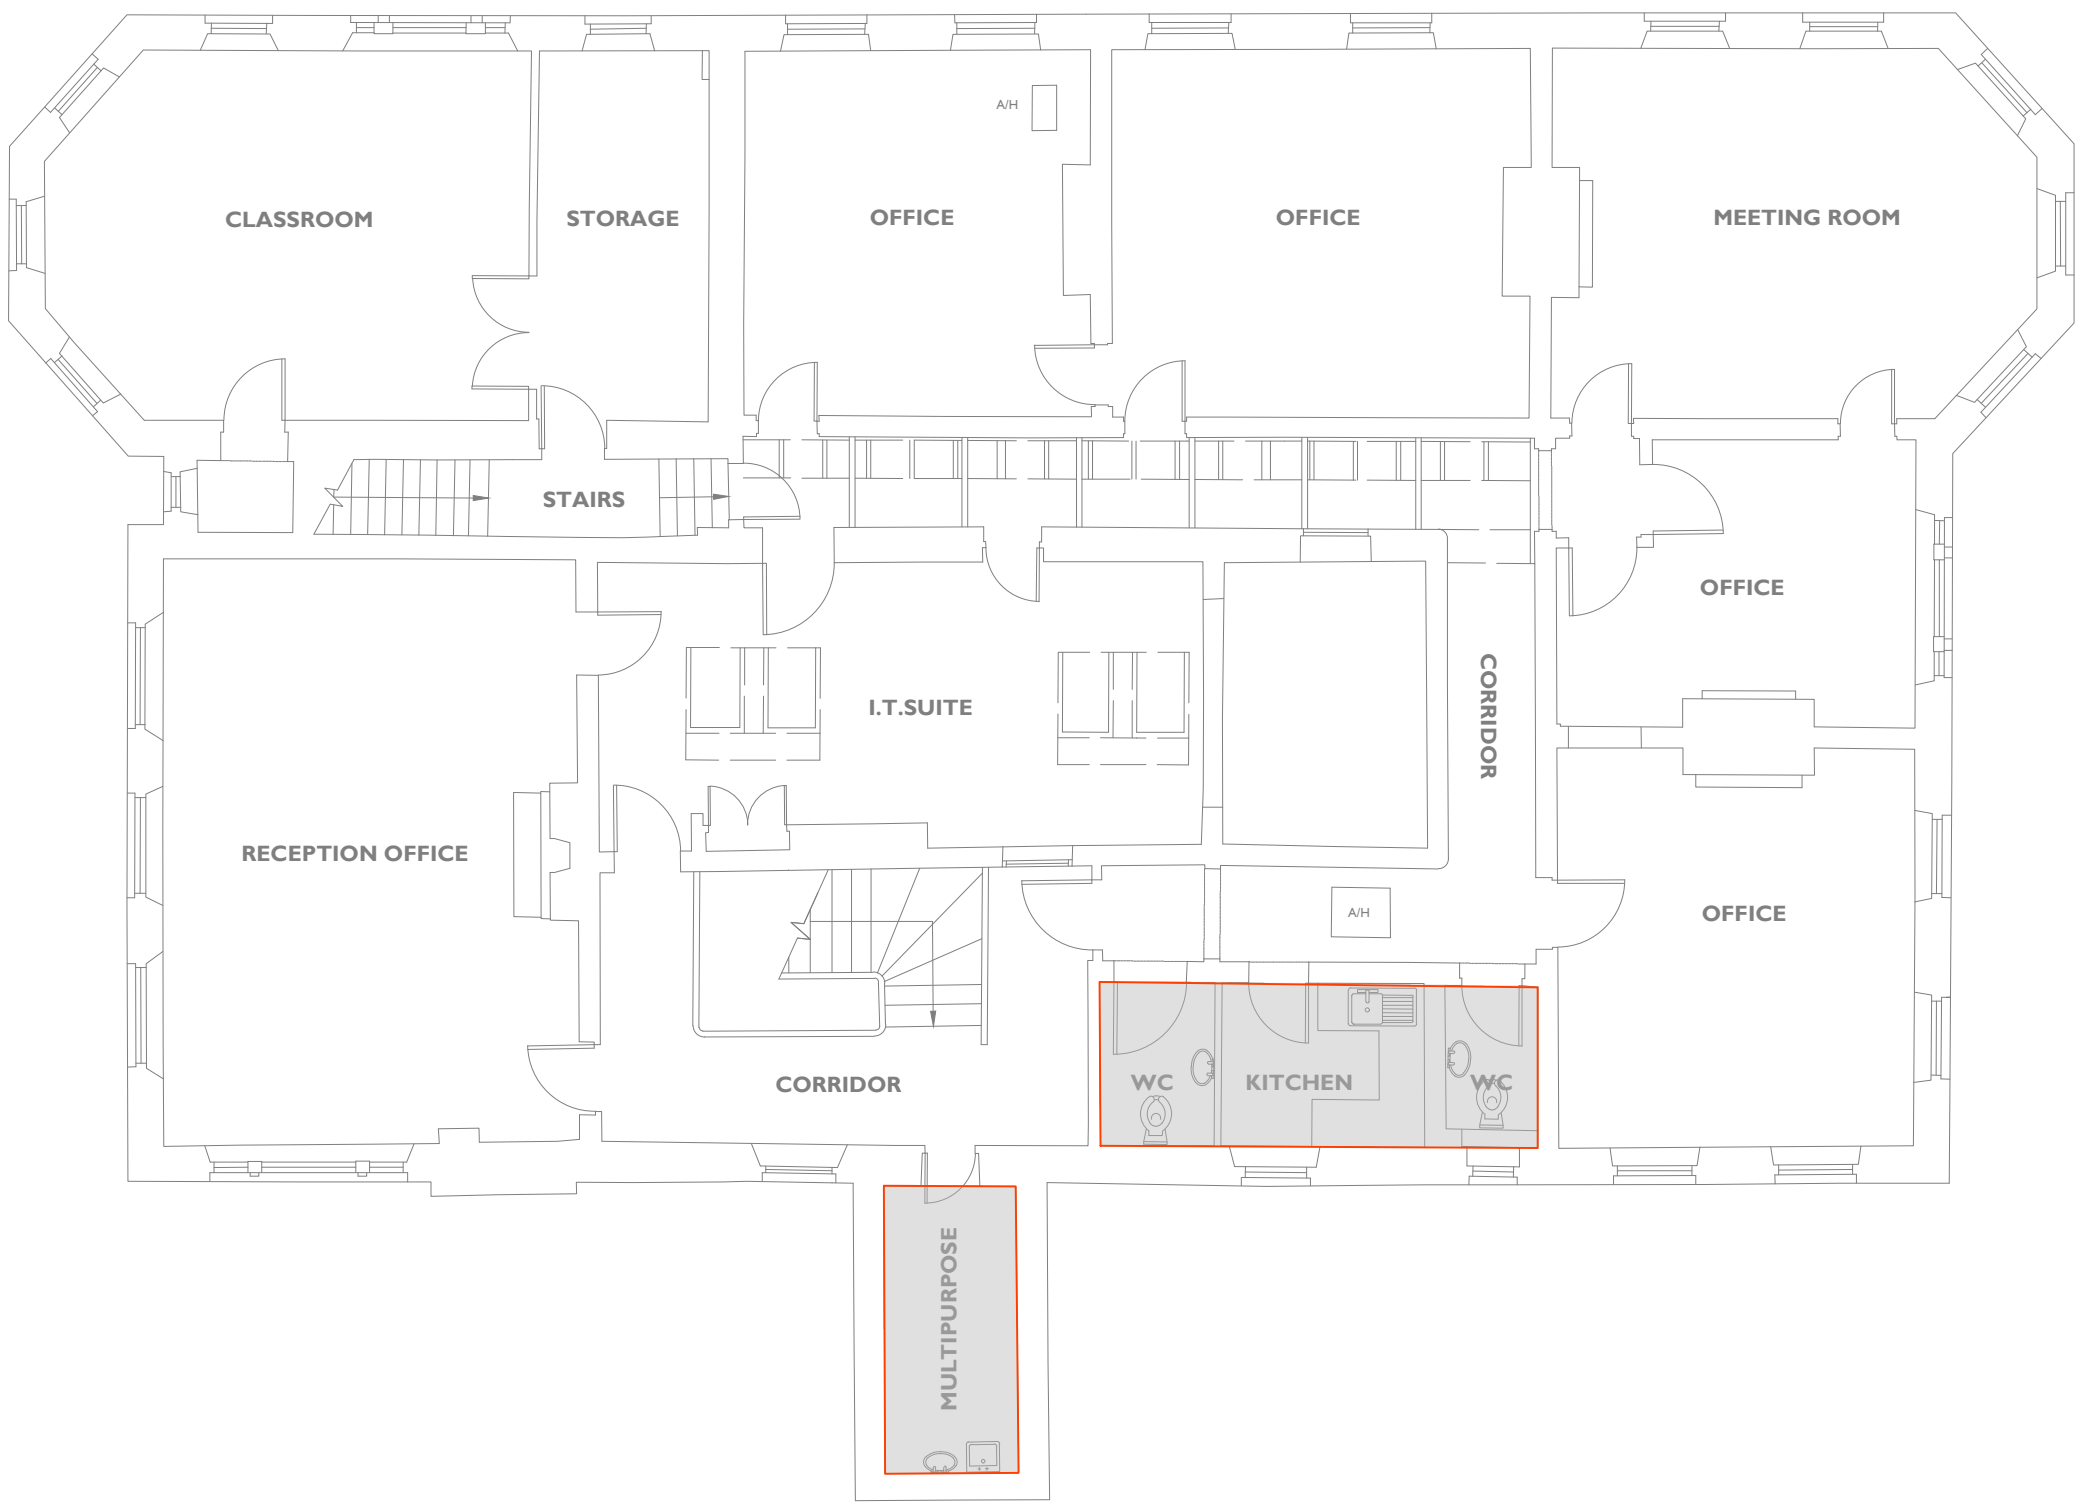

P04	22.08.23	SUITABLE FOR TENDER	RC	RE
P03	25.08.23	STAGE 4 REVIEW	BM	RE
P02	02.06.23	UPDATED TO ARCHITECTS COMMENTS AND LAYOUTS	LC	RP
P01	31.03.23	PRELIMINARY ISSUE	JW	RE
REV	DATE	DESCRIPTION	DRAWN	APP

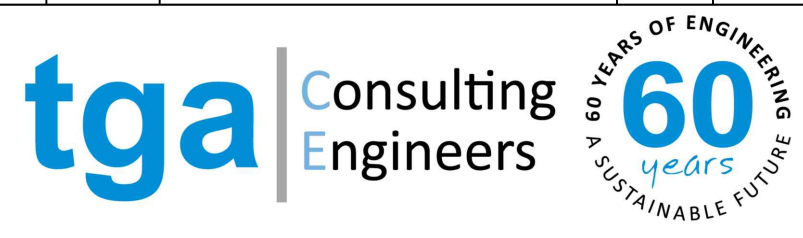

tga Consulting Engineers
A 60 YEARS OF ENGINEERING
years
A SUSTAINABLE FUTURE

TGA Consulting Engineers LLP,
Salvus House, Aykley Heads, Durham City. DH1 5TS.
E: info@tgace.co.uk T: 0191 3862314

Project

ELSECAR: FORGING AHEAD

Title

MECHANICAL ENGINEERING SERVICES
EXISTING ABOVE GROUND DRAINAGE SYSTEM
BUILDING 13
FIRST FLOOR

Architect

PURCELL

Client

BARNSELEY MBC

Suitability:	Code	Description
	D2	FOR TENDER

Revision:	Scale:	TGA Proj No:	Stage:
P04	1:100	8193	4

Drawing Reference:
Project-Originator-Zone-Level-Type-Role-Classification-Number
EFAS-TGA-13-01-DR-M-52001


 Standard construction hazards that a competent contractor would be aware of have not been identified on this drawing. Any risks not immediately apparent are identified within the CDM Residual Risk Register.

LEGEND

- SVP - SOIL VENT PIPE
WVP - WASTE VENT PIPE
WP - WASTE PIPE
AAV - AIR ADMITTANCE VALVE
RE - RODDING EYE

NOTES

- THIS DRAWING SHOWS THE DESIGN PROPOSAL FOR A WORKSTAGE 4 TECHNICAL DESIGN LEVEL OF DETAIL AND COMPLETENESS AS DEFINED BY BSRIA BGS-2018. ALL QUANTITIES AND LOCATIONS ARE BASED ON GENERIC EQUIPMENT SELECTIONS AND SHALL BE CONFIRMED AND FULLY COORDINATED AS PART OF THE CONSTRUCTION STAGE DESIGN ACTIVITIES.
- ALL DIMENSIONS ARE IN MILLIMETERS UNLESS NOTATED OTHERWISE.
- ALL PIPE SIZES AND EQUIPMENT SELECTIONS ARE PROVISIONAL.
- PIPEWORK SHALL BE ADEQUATELY SUPPORTED IN THE RUNNING LENGTH USING PROPRIETARY CLIPS, BRACKETS & SUPPORT SYSTEMS.
- PIPELINES PASSING THROUGH A FIRE RATED ELEMENT OF CONSTRUCTION SHALL INCLUDE A SUITABLY RATED FIRE COLLAR.
- RODDING ACCESS POINTS SHALL BE PROVIDED IN VERTICAL PIPEWORK AT GROUND LEVEL AND EVERY 3RD STOREY, LOCATED 1500mm ABOVE FFL.
- RODDING ACCESS POINTS SHALL BE PROVIDED IN THE ENDS OF HORIZONTAL SOIL AND WASTE PIPEWORK AND AT CHANGES IN PIPE DIRECTION.
- INCLUDE PROPRIETARY WATER-LESS TRAPS AT RELIEF VALVE TUNDRISH WASTE PIPE AND CONDENSATE DISPOSAL PIPE CONNECTIONS INTO THE AGD PIPE SYSTEM.
- SVPS NOT ROUTED TO ABOVE ROOF LEVEL SHALL INCLUDE A PROPRIETARY AIR ADMITTANCE VALVE ASSEMBLY.
- SVPS WHICH EXIT THE BUILDING THROUGH THE ROOF SHALL BE FITTED WITH A SUITABLE WEATHER FLASHING AND PROPRIETARY PIPE TERMINAL/BIRD SCREEN.
- WASTE PIPEWORK AND FITTINGS SHALL BE IN PUSH-JOINTED PVCU PIPE, SIZES < 40mm DA.
- SOIL PIPEWORK AND FITTINGS SHALL BE PUSH-JOINTED PVCU PIPE, SIZES > 82mm DA.

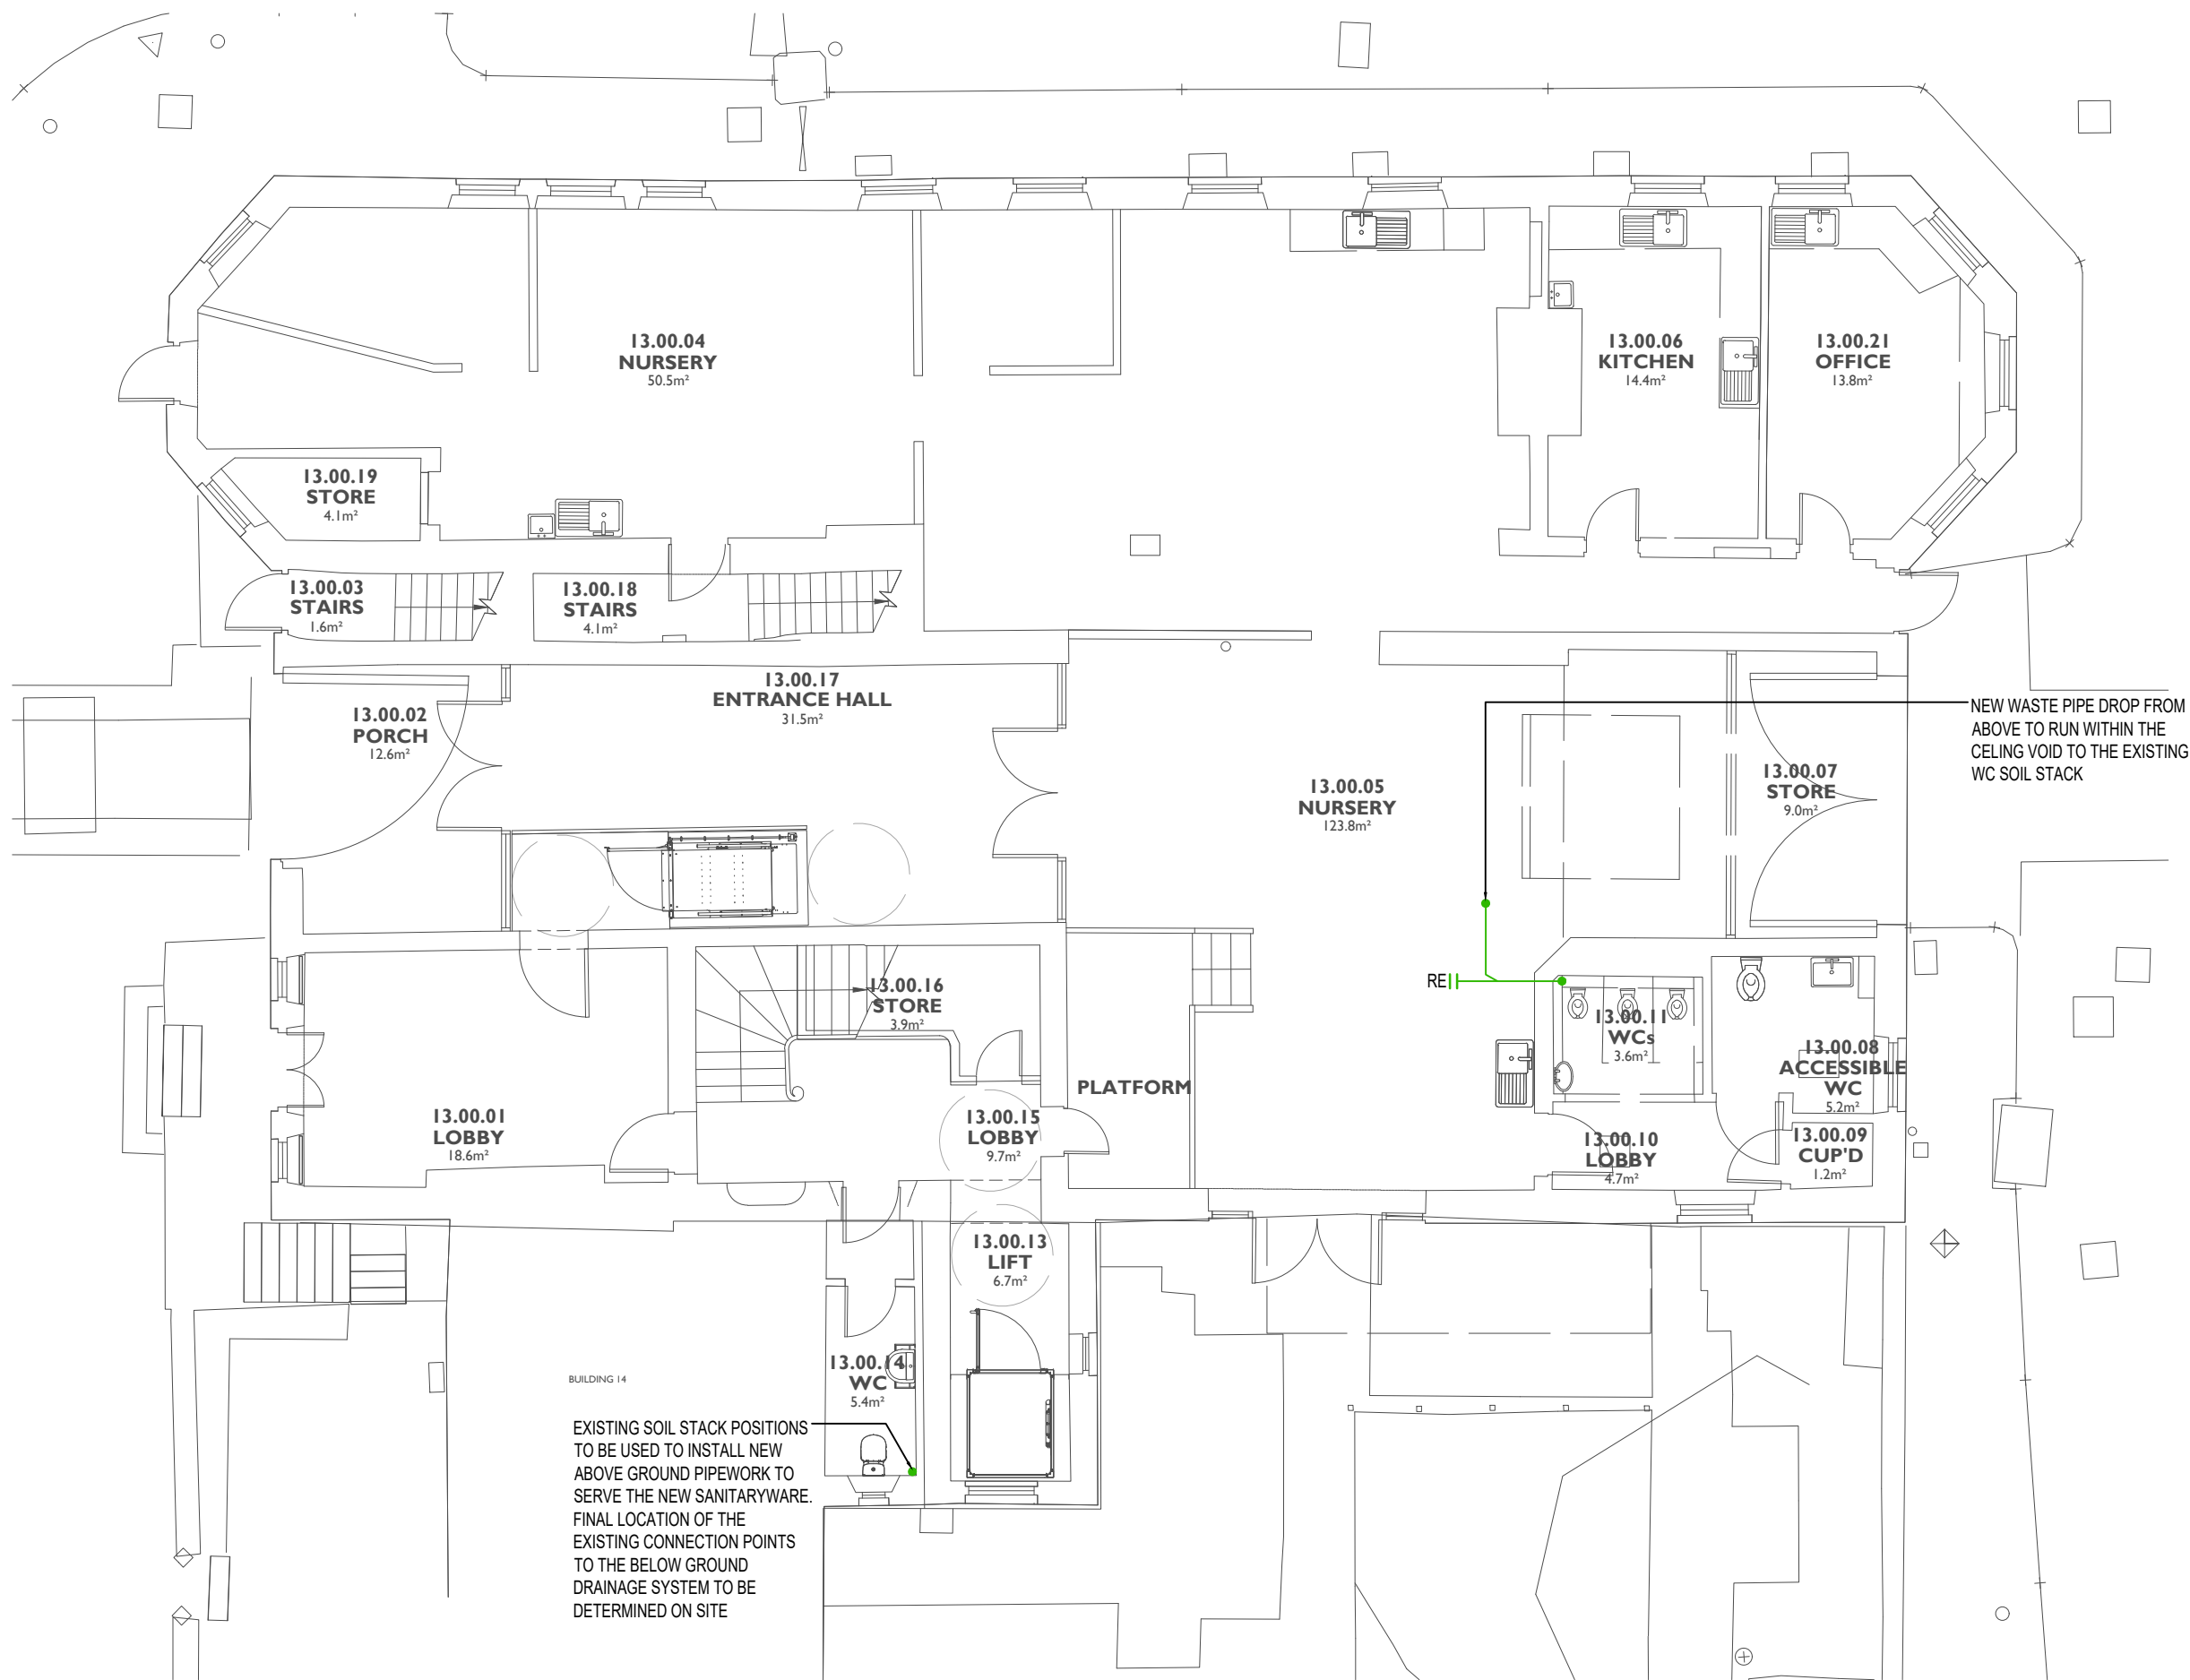

P04	22.08.23	SUITABLE FOR TENDER	RC	RE
P03	25.08.23	STAGE 4 REVIEW	BM	RE
P02	02.06.23	UPDATED TO ARCHITECTS COMMENTS AND LAYOUTS	LC	RP
P01	31.03.23	PRELIMINARY ISSUE	JW	RE
REV	DATE	DESCRIPTION	DRAWN	APP



TGA Consulting Engineers LLP,
Salvus House, Aykley Heads, Durham City. DH1 5TS.
E: info@tgace.co.uk T: 0191 3862314

Project
ELSECAR: FORGING AHEAD

Title
MECHANICAL ENGINEERING SERVICES
PROPOSED ABOVE GROUND DRAINAGE SYSTEM
BUILDING 13
GROUND FLOOR

Architect
PURCELL

Client
BARNESLEY MBC

Suitability: Code Description
D2 FOR TENDER

Revision:	Scale:	TGA Proj No:	Stage:
P04	1:100	8193	4

Drawing Reference:
Project-Originator-Zone-Level-Type-Role-Classification-Number
EFAS-TGA-13-00-DR-M-52002


 Standard construction hazards that a competent contractor would be aware of have not been identified on this drawing. Any risks not immediately apparent are identified within the CDM Residual Risk Register.

LEGEND

SVP - SOIL VENT PIPE
WVP - WASTE VENT PIPE
WP - WASTE PIPE
AAV - AIR ADMITTANCE VALVE
RE - RODDING EYE

NOTES

- THIS DRAWING SHOWS THE DESIGN PROPOSAL FOR A WORKSTAGE 4 TECHNICAL DESIGN LEVEL OF DETAIL AND COMPLETENESS AS DEFINED BY BSRIA BGG 2018. ALL QUANTITIES AND LOCATIONS ARE BASED ON GENERIC EQUIPMENT SELECTIONS AND SHALL BE CONFIRMED AND FULLY COORDINATED AS PART OF THE CONSTRUCTION STAGE DESIGN ACTIVITIES.
- ALL DIMENSIONS ARE IN MILLIMETERS UNLESS NOTATED OTHERWISE.
- PIPEWORK SHALL BE ADEQUATELY SUPPORTED IN THE RUNNING LENGTH USING PROPRIETARY CLIPS, BRACKETS & SUPPORT SYSTEMS.
- PIPELINES PASSING THROUGH A FIRE RATED ELEMENT OF CONSTRUCTION SHALL INCLUDE A SUITABLY RATED FIRE COLLAR.
- RODDING ACCESS POINTS SHALL BE PROVIDED IN VERTICAL PIPEWORK AT GROUND LEVEL AND EVERY 3RD STOREY, LOCATED 1500mm ABOVE FFL.
- RODDING ACCESS POINTS SHALL BE PROVIDED IN THE ENDS OF HORIZONTAL SOIL AND WASTE PIPEWORK AND AT CHANGES IN PIPE DIRECTION.
- INCLUDE PROPRIETARY WATER-LESS TRAPS AT RELIEF VALVE TUNDISH WASTE PIPE AND CONDENSATE DISPOSAL PIPE CONNECTIONS INTO THE AGD PIPE SYSTEM.
- SVPS NOT ROUTED TO ABOVE ROOF LEVEL SHALL INCLUDE A PROPRIETARY AIR ADMITTANCE VALVE ASSEMBLY.
- SVPS WHICH EXIT THE BUILDING THROUGH THE ROOF SHALL BE FITTED WITH A SUITABLE WEATHER FLASHING AND PROPRIETARY PIPE TERMINAL/BIRD SCREEN.
- WASTE PIPEWORK AND FITTINGS SHALL BE IN PUSH-JOINTED PVCU PIPE, SIZES < 40mm DIA.
- SOIL PIPEWORK AND FITTINGS SHALL BE PUSH-JOINTED PVCU PIPE, SIZES > 82mm DIA.

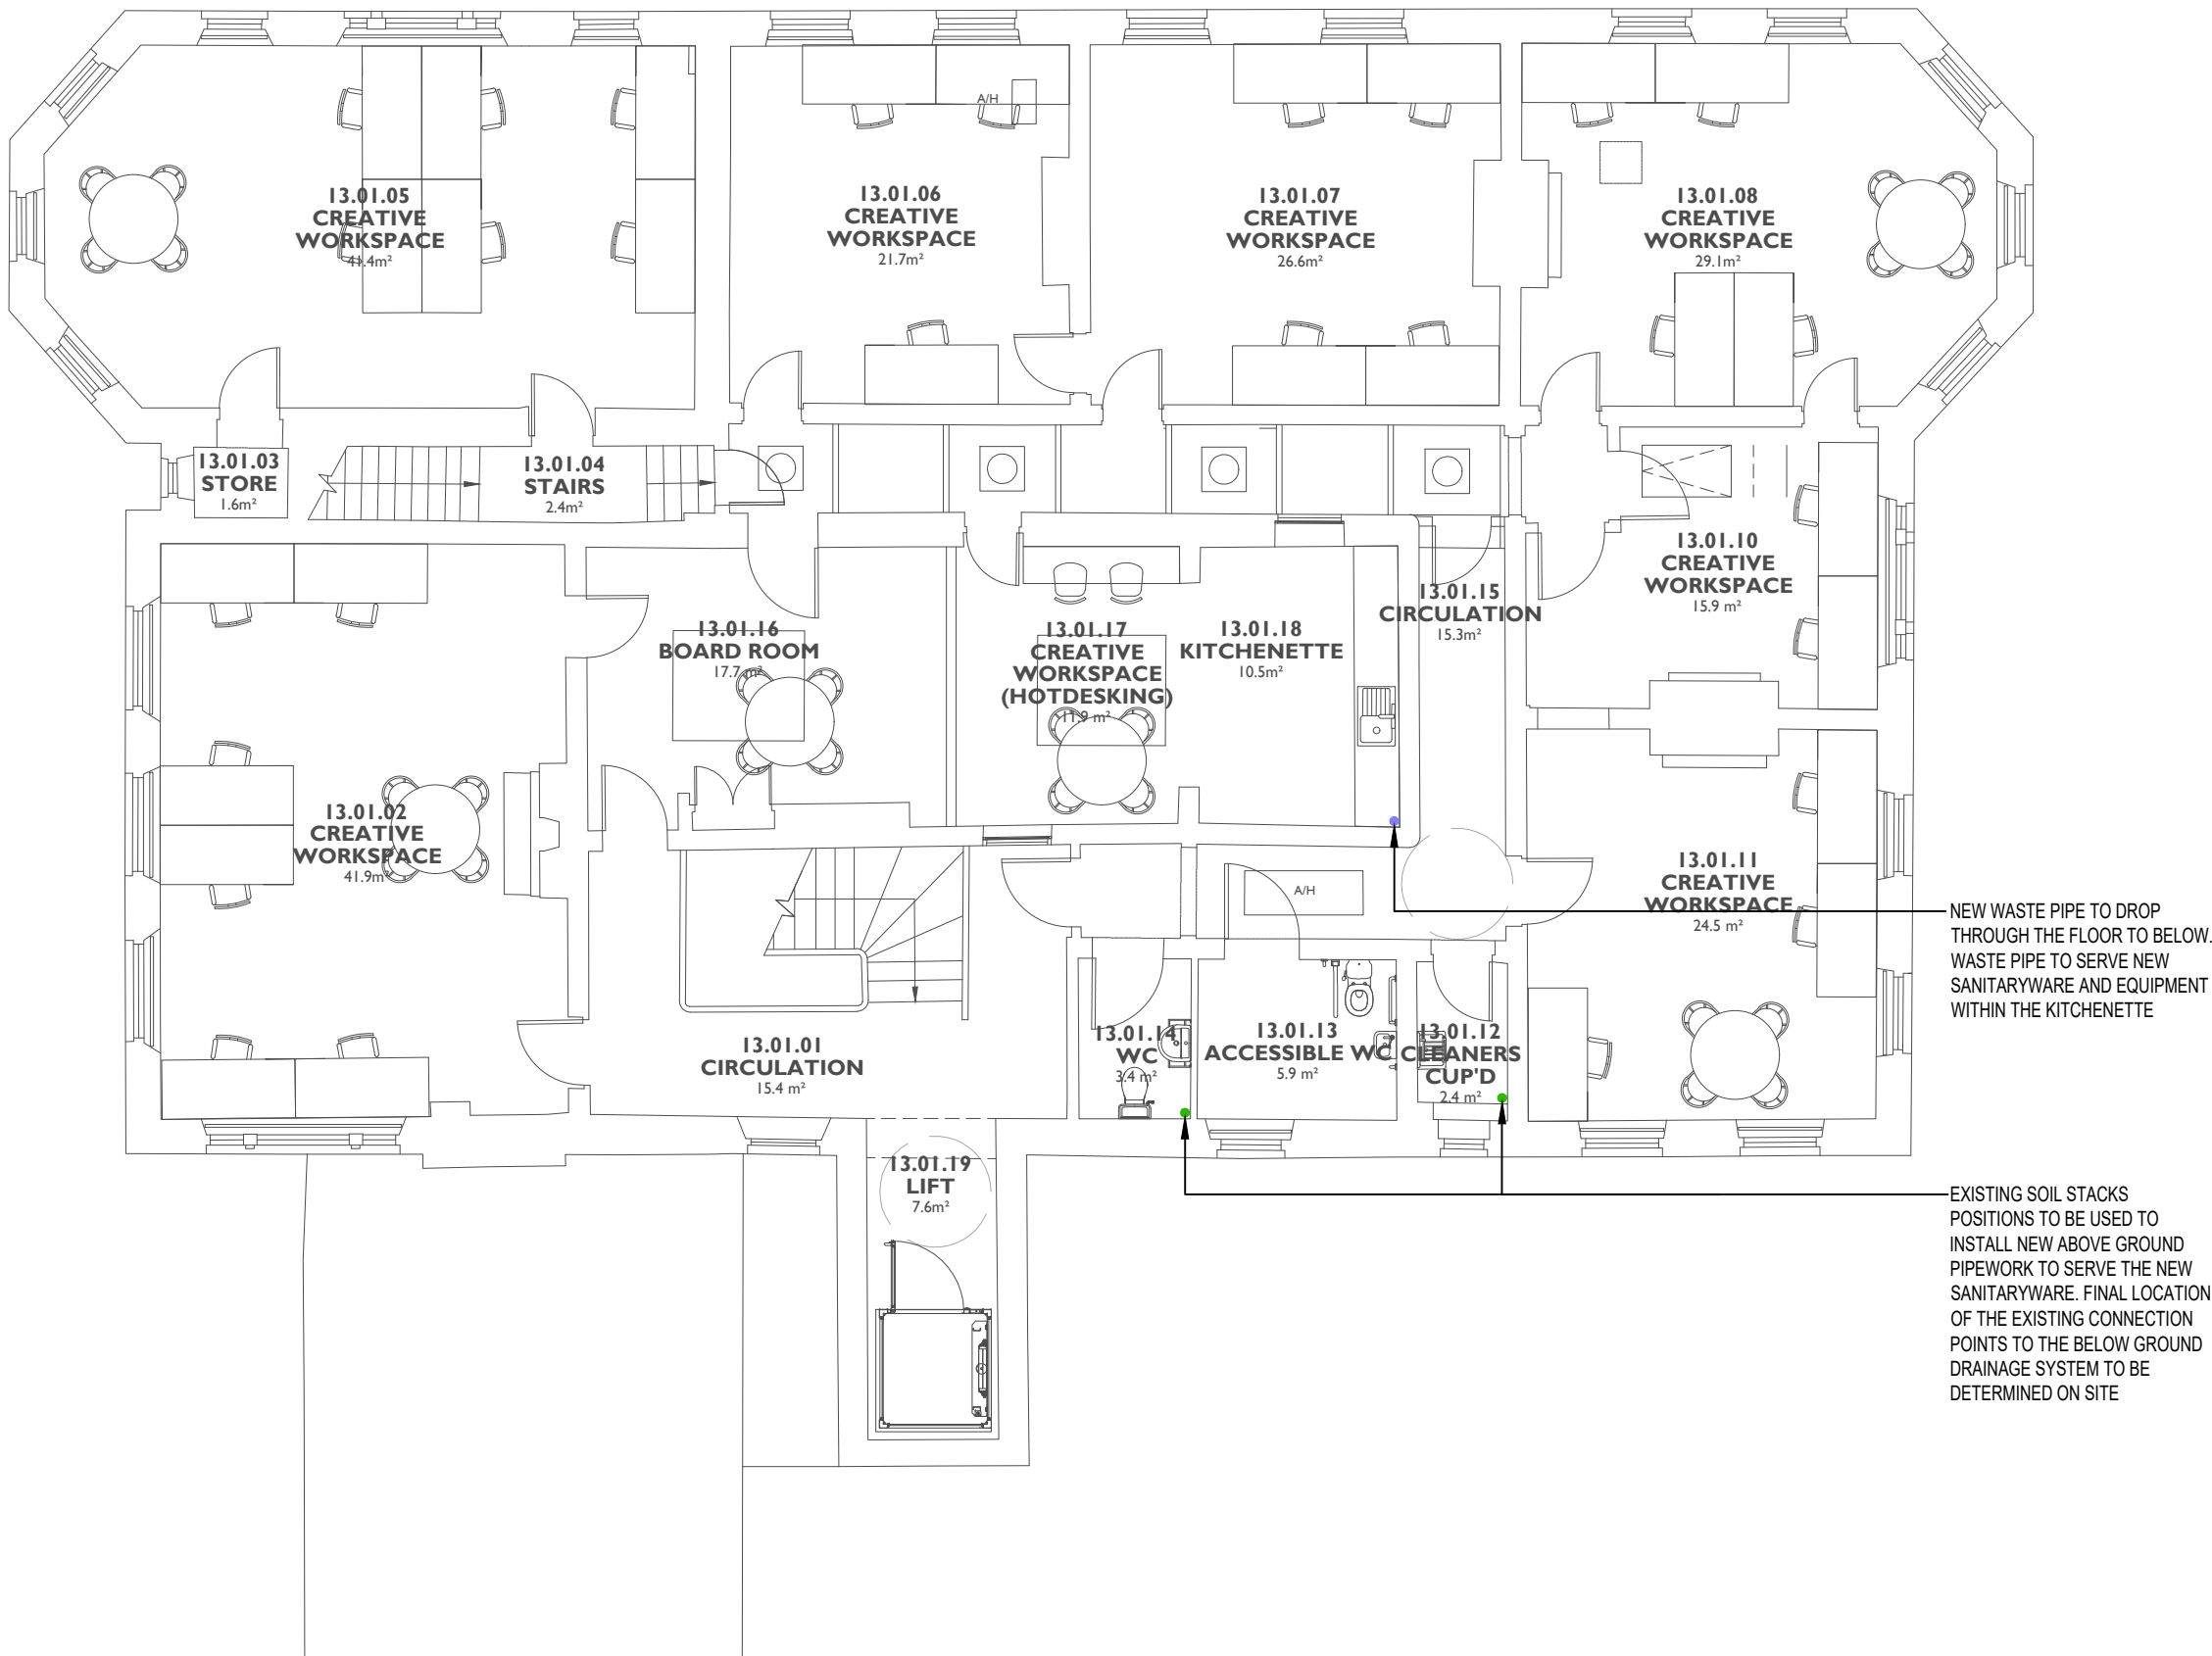

P04	22.08.23	SUITABLE FOR TENDER	RC	RE
P03	25.08.23	STAGE 4 REVIEW	BM	RE
P02	02.06.23	UPDATED TO ARCHITECTS COMMENTS AND LAYOUTS	LC	RP
P01	31.03.23	PRELIMINEY ISSUE	JW	RE
REV	DATE	DESCRIPTION	DRAWN	APP



TGA Consulting Engineers LLP,
Salvus House, Aykley Heads, Durham City. DH1 5TS.
E: info@tgace.co.uk T: 0191 3862314

Project
ELSECAR: FORGING AHEAD

Title
MECHANICAL ENGINEERING SERVICES
PROPOSED ABOVE GROUND DRAINAGE SYSTEM
BUILDING 13
FIRST FLOOR

Architect
PURCELL

Client
BARNSLEY MBC

Suitability: Code Description
D2 FOR TENDER

Revision: P04	Scale: 1:100	TGA Proj No: 8193	Stage: 4
------------------	-----------------	----------------------	-------------


Drawing Reference:
Project-Originator-Zone-Level-Type-Role-Classification-Number
EFAS-TGA-13-01-DR-M-52002

 Standard construction hazards that a competent contractor would be aware of have not been identified on this drawing. Any risks not immediately apparent are identified within the CDM Residual Risk Register.

 EXISTING DOMESTIC HOT AND COLD WATER SERVICES, INCLUDING LOCAL WATER HEATERS, PIPEWORK MAINS, PIPEWORK BRANCHES, BRACKETS, FIXINGS AND ANCILLARY ITEMS TO BE DECOMMISSIONED STRIPPED OUT AND REMOVED.

NOTES

- THIS DRAWING SHOWS THE DESIGN PROPOSAL FOR A WORKSTAGE 4 TECHNICAL DESIGN LEVEL OF DETAIL AND COMPLETENESS AS DEFINED BY BSRIA B66 :2018. ALL QUANTITIES AND LOCATIONS ARE BASED ON GENERIC EQUIPMENT SELECTIONS AND SHALL BE CONFIRMED AND FULLY COORDINATED AS PART OF THE CONSTRUCTION STAGE DESIGN ACTIVITIES.
- ALL DIMENSIONS ARE IN MILLIMETERS UNLESS NOTATED OTHERWISE.
- ALL PIPE SIZES AND EQUIPMENT SELECTIONS ARE PROVISIONAL.
- ALL MATERIALS, PRODUCTS AND EQUIPMENT SELECTIONS ARE PROVISIONAL.
- PIPEWORK SHALL BE ADEQUATELY SUPPORTED IN THE RUNNING LENGTH USING PROPRIETARY CLIPS, BRACKETS & SUPPORT SYSTEMS.
- ALL EQUIPMENT, VALVES AND OTHER ACCESSORIES SHALL BE FULLY ACCESSIBLE.
- PIPELINES PASSING THROUGH A FIRE RATED ELEMENT OF CONSTRUCTION SHALL INCLUDE A SUITABLY RATED FIRE COLLAR.
- ALL DOMESTIC APPLIANCES AND ITEMS OF SANITARYWARE SHALL INCLUDE A ½ - TURN TERMINAL ISOLATING VALVE.
- WHITE GOODS AND OTHER DOMESTIC APPLIANCES SHALL INCLUDE A SINGLE CHECK VALVE AT THE POINT OF CONNECTION TO THE APPLIANCE.
- PIPEWORK SHALL BE IN FRATHERM CPVC PLASTIC.
- ALL WASH HAND BASINS SHALL INCLUDE A TMV2 COMPLIANT THERMOSTATIC MIXING VALVE. SET TEMPERATURE TO 41°C.
- THERMOSTATIC MIXING VALVES SHALL INCLUDE A SINGLE CHECK VALVE ON HOT AND COLD WATER CONNECTIONS.
- ALL PIPELINES SHALL INCLUDE THERMAL INSULATION AND A VAPOUR BARRIER IN THE RUNNING LENGTH.
- THERMAL INSULATION SHALL BE CONTINUOUS THROUGH SUPPORTS AND OVER PIPE FITTINGS.
- VALVES, STRAINERS, AND OTHER PIPELINE ACCESSORIES SHALL INCLUDE PROPRIETARY TIE-ON INSULATED JACKETS.
- PIPELINES SHALL INCLUDE SERVICE IDENTIFICATION/ DIRECTION OF FLOW LABELLING

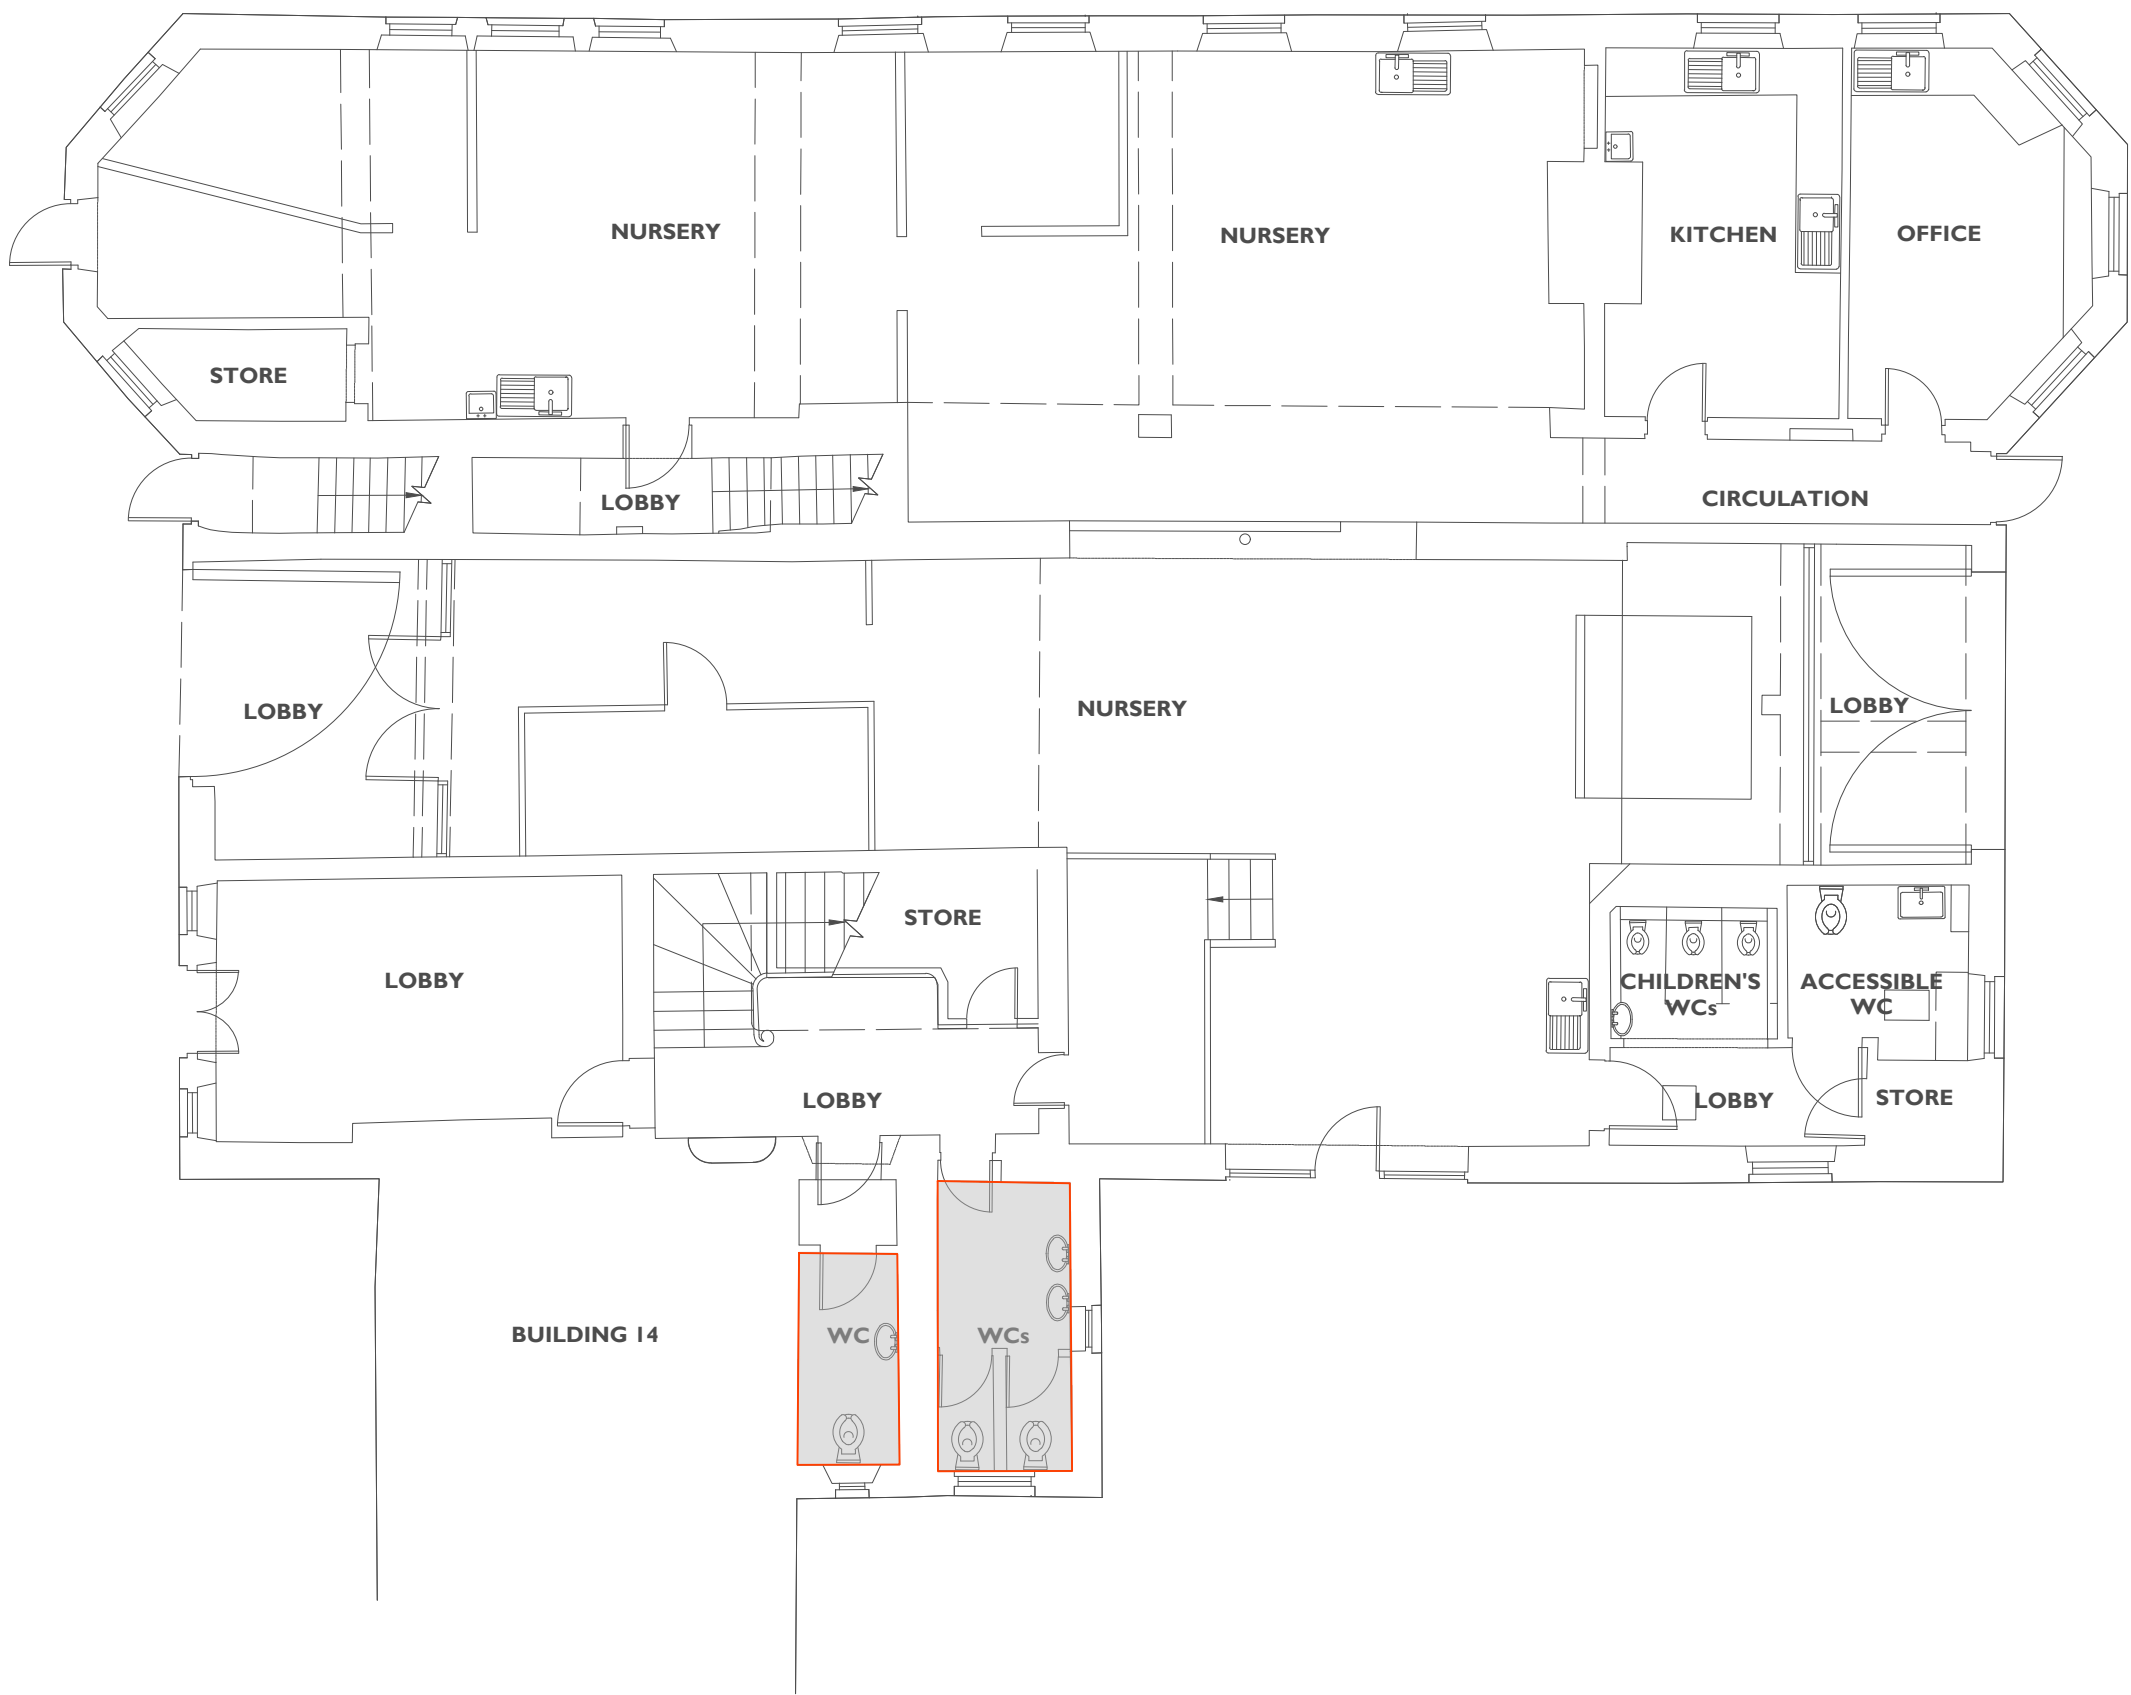

P04	22.08.23	SUITABLE FOR TENDER	RC	RE
P03	25.08.23	STAGE 4 REVIEW	BM	RE
P02	02.06.23	UPDATED TO ARCHITECTS COMMENTS AND LAYOUTS	LC	RP
P01	31.03.23	PRELIMINARY ISSUE	JW	RE
REV	DATE	DESCRIPTION	DRAWN	APP



TGA Consulting Engineers LLP,
Salvus House, Aykley Heads, Durham City. DH1 5TS.
E: info@tgace.co.uk T: 0191 3862314

Project
ELSECAR: FORGING AHEAD

Title
MECHANICAL ENGINEERING SERVICES
EXISTING DOMESTIC WATER SERVICES
BUILDING 13
GROUND FLOOR

Architect
PURCELL

Client
BARNESLEY MBC

Suitability: Code Description
D2 FOR TENDER

Revision: P04	Scale: 1:100	TGA Proj No: 8193	Stage: 4
------------------	-----------------	----------------------	-------------


Drawing Reference:
Project-Originator-Zone-Level-Type-Role-Classification-Number
EFAS-TGA-13-00-DR-M-53001

 Standard construction hazards that a competent contractor would be aware of have not been identified on this drawing. Any risks not immediately apparent are identified within the CDM Residual Risk Register.

 EXISTING DOMESTIC HOT AND COLD WATER SERVICES, INCLUDING LOCAL WATER HEATERS, PIPEWORK MAINS, PIPEWORK BRANCHES, BRACKETS, FIXINGS AND ANCILLARY ITEMS TO BE DECOMMISSIONED STRIPPED OUT AND REMOVED.

NOTES

- THIS DRAWING SHOWS THE DESIGN PROPOSAL FOR A WORKSTAGE 4 TECHNICAL DESIGN LEVEL OF DETAIL AND COMPLETENESS AS DEFINED BY BSRIA B66 :2018. ALL QUANTITIES AND LOCATIONS ARE BASED ON GENERIC EQUIPMENT SELECTIONS AND SHALL BE CONFIRMED AND FULLY COORDINATED AS PART OF THE CONSTRUCTION STAGE DESIGN ACTIVITIES.
- ALL DIMENSIONS ARE IN MILLIMETERS UNLESS NOTATED OTHERWISE.
- PIPEWORK SHALL BE ADEQUATELY SUPPORTED IN THE RUNNING LENGTH USING PROPRIETARY CLIPS, BRACKETS & SUPPORT SYSTEMS.
- ALL EQUIPMENT, VALVES AND OTHER ACCESSORIES SHALL BE FULLY ACCESSIBLE.
- PIPELINES PASSING THROUGH A FIRE RATED ELEMENT OF CONSTRUCTION SHALL INCLUDE A SUITABLY RATED FIRE COLLAR.
- ALL DOMESTIC APPLIANCES AND ITEMS OF SANITARYWARE SHALL INCLUDE A ½" TURN TERMINAL ISOLATING VALVE.
- WHITE GOODS AND OTHER DOMESTIC APPLIANCES SHALL INCLUDE A SINGLE CHECK VALVE AT THE POINT OF CONNECTION TO THE APPLIANCE.
- PIPEWORK SHALL BE IN FRIATHERM CPVC PLASTIC.
- ALL WASH HAND BASINS SHALL INCLUDE A TMV2 COMPLIANT THERMOSTATIC MIXING VALVE. SET TEMPERATURE TO 41°C.
- THERMOSTATIC MIXING VALVES SHALL INCLUDE A SINGLE CHECK VALVE ON HOT AND COLD WATER CONNECTIONS.
- ALL PIPELINES SHALL INCLUDE THERMAL INSULATION AND A VAPOUR BARRIER IN THE RUNNING LENGTH.
- THERMAL INSULATION SHALL BE CONTINUOUS THROUGH SUPPORTS AND OVER PIPE FITTINGS.
- VALVES, STRAINERS, AND OTHER PIPELINE ACCESSORIES SHALL INCLUDE PROPRIETARY TIE-ON INSULATED JACKETS.
- PIPELINES SHALL INCLUDE SERVICE IDENTIFICATION\ DIRECTION OF FLOW LABELLING

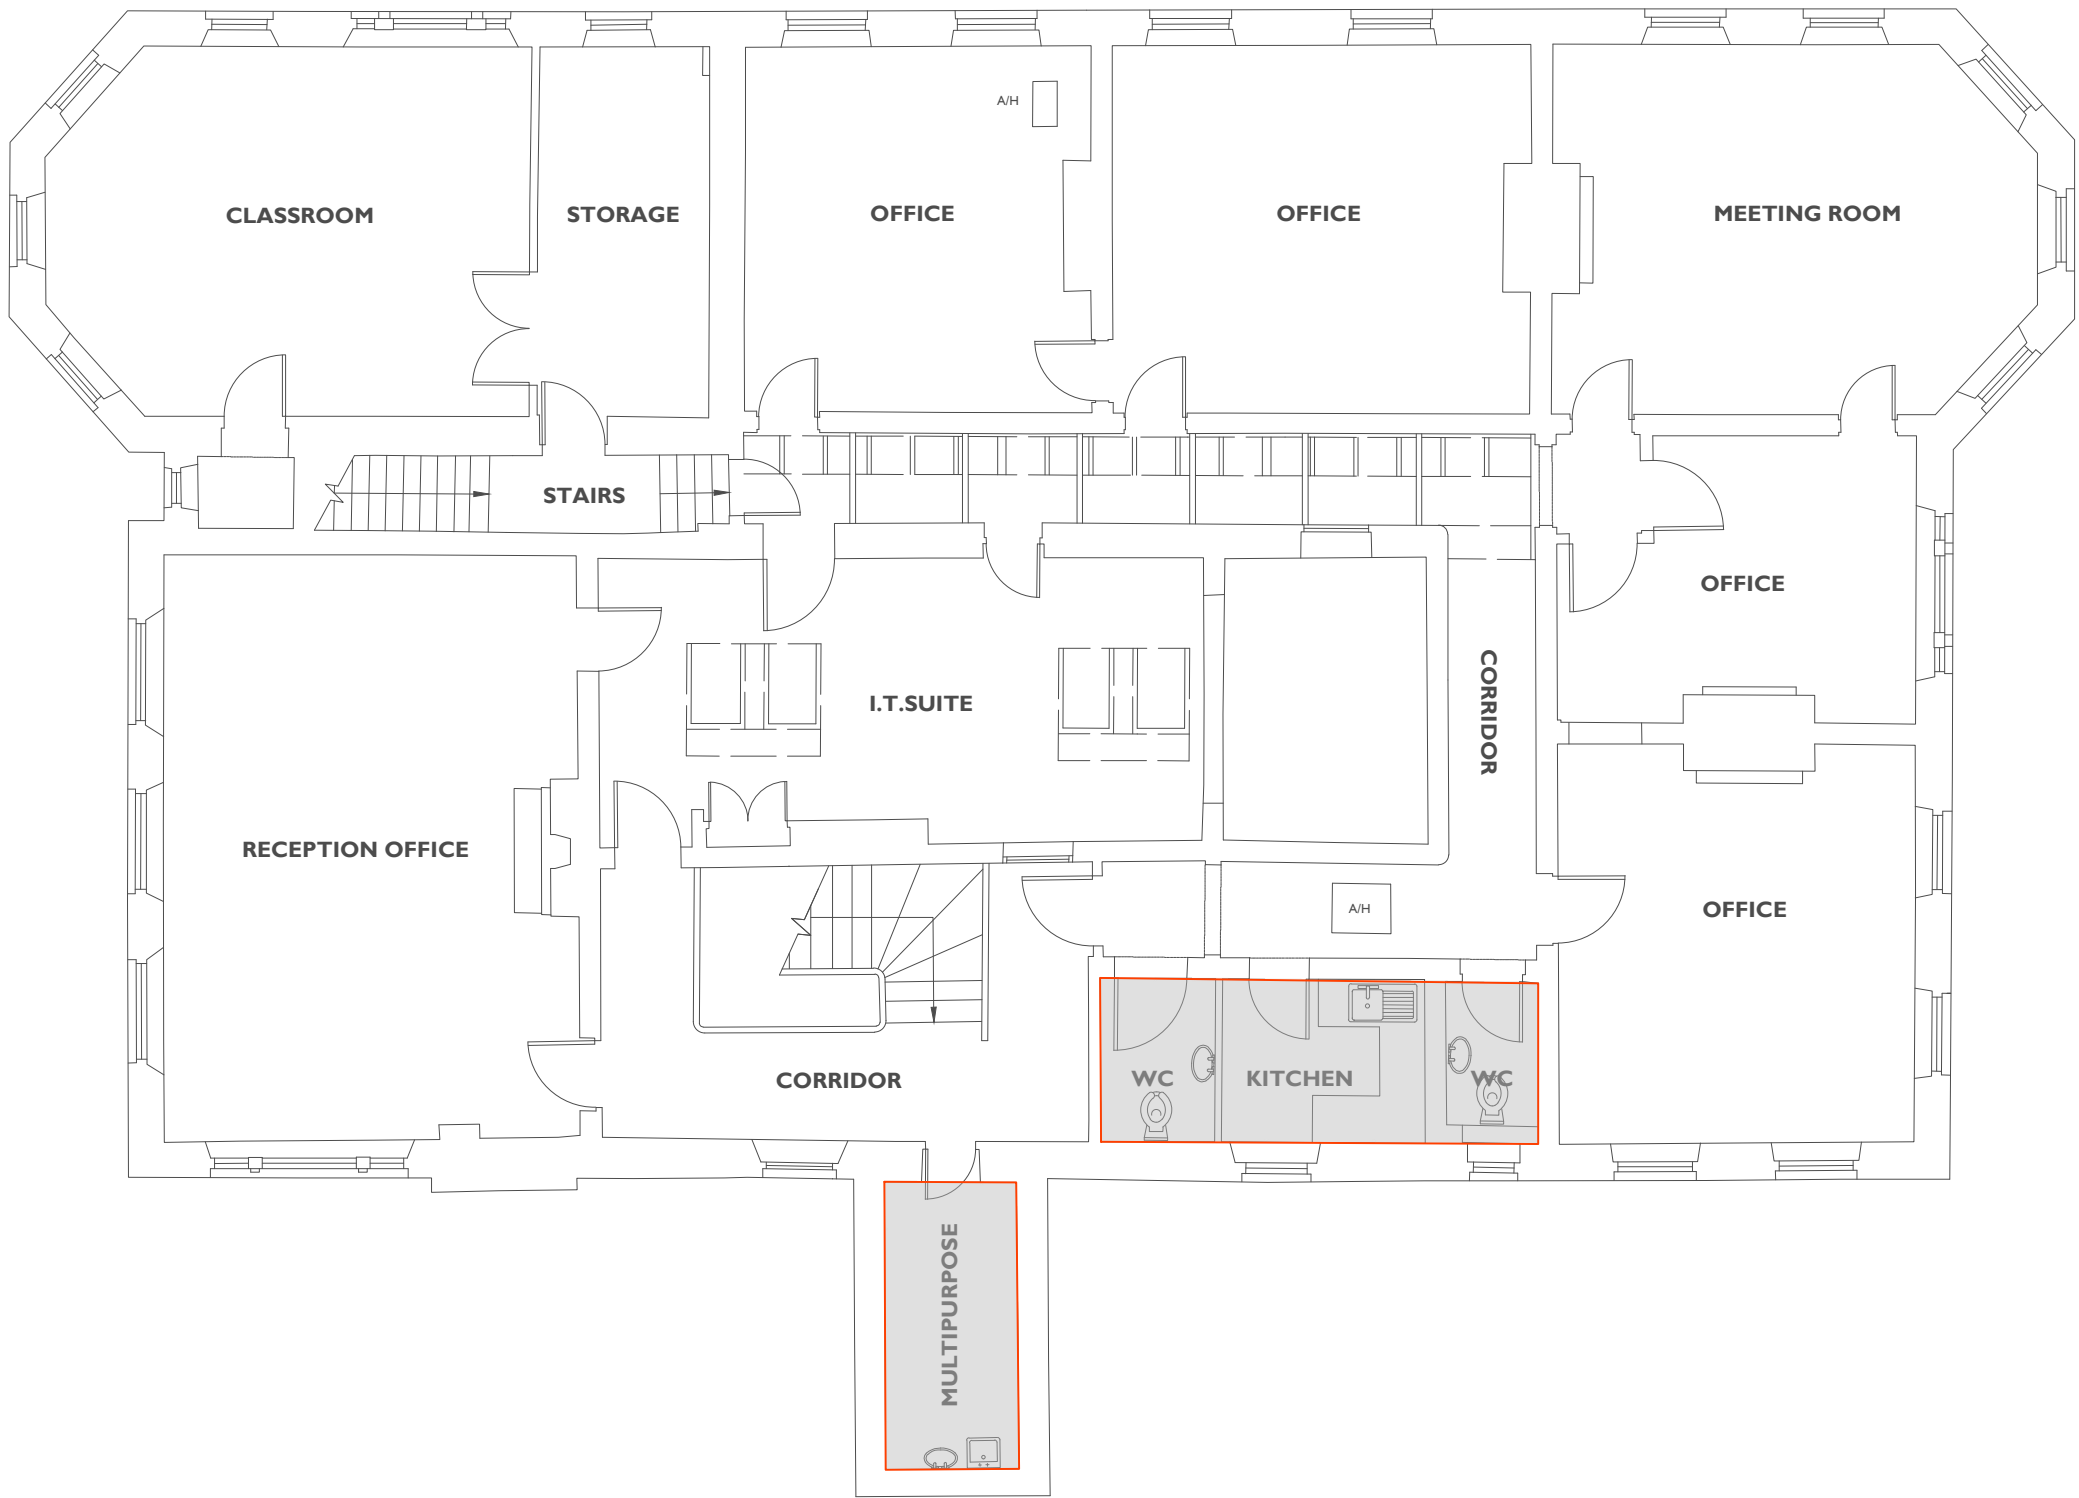

P04	22.08.23	SUITABLE FOR TENDER	RC	RE
P03	25.08.23	STAGE 4 REVIEW	BM	RE
P02	02.06.23	UPDATED TO ARCHITECTS COMMENTS AND LAYOUTS	LC	RP
P01	31.03.23	PRELIMINARY ISSUE	JW	RE
REV	DATE	DESCRIPTION	DRAWN	APP



TGA Consulting Engineers LLP,
Salvus House, Aykley Heads, Durham City. DH1 5TS.
E: info@tgace.co.uk T: 0191 3862314

Project
ELSECAR: FORGING AHEAD

Title
**MECHANICAL ENGINEERING SERVICES
EXISTING DOMESTIC WATER SERVICES
BUILDING 13
FIRST FLOOR**

Architect
PURCELL

Client
BARNSELEY MBC

Suitability: Code Description
D2 FOR TENDER

Revision: P04	Scale: 1:100	TGA Proj No: 8193	Stage: 4
-------------------------	------------------------	-----------------------------	--------------------

Drawing Reference:
Project-Originator-Zone-Level-Type-Role-Classification-Number
EFAS-TGA-13-01-DR-M-53001



 Standard construction hazards that a competent contractor would be aware of have not been identified on this drawing. Any risks not immediately apparent are identified within the CDM Residual Risk Register.

LEGEND

CWS - COLD WATER SERVICED
DTLL - DROP TO LOW LEVEL
RTB - RISE FROM BELOW
RTA - RISE TO ABOVE
RTCV - RISE TO CEILING VOID
DTB - DROP TO BELOW
DTA - DROP FROM ABOVE

NOTES

- THIS DRAWING SHOWS THE DESIGN PROPOSAL FOR A WORKSTAGE 4 TECHNICAL DESIGN LEVEL OF DETAIL AND COMPLETENESS AS DEFINED BY BSRIA 606: 2016. ALL QUANTITIES AND LOCATIONS ARE BASED ON GENERIC EQUIPMENT SELECTIONS AND SHALL BE CONFIRMED AND FULLY COORDINATED AS PART OF THE CONSTRUCTION STAGE DESIGN ACTIVITIES.
- ALL DIMENSIONS ARE IN MILLIMETERS UNLESS NOTATED OTHERWISE.
- ALL PIPE SIZES AND EQUIPMENT SELECTIONS ARE PROVISIONAL.
- ALL MATERIALS, PRODUCTS AND EQUIPMENT SELECTIONS ARE PROVISIONAL.
- PIPEWORK SHALL BE ADEQUATELY SUPPORTED IN THE RUNNING LENGTH USING PROPRIETARY CLIPS, BRACKETS & SUPPORT SYSTEMS.
- ALL EQUIPMENT, VALVES AND OTHER ACCESSORIES SHALL BE FULLY ACCESSIBLE.
- PIPELINES PASSING THROUGH A FIRE RATED ELEMENT OF CONSTRUCTION SHALL INCLUDE A SUITABLY RATED FIRE COLLAR.
- ALL DOMESTIC APPLIANCES AND ITEMS OF SANITARYWARE SHALL INCLUDE A J-TURN TERMINAL ISOLATING VALVE.
- WHITE GOODS AND OTHER DOMESTIC APPLIANCES SHALL INCLUDE A SINGLE CHECK VALVE AT THE POINT OF CONNECTION TO THE APPLIANCE.
- PIPEWORK SHALL BE IN FRATHERM CPVC PLASTIC.
- ALL WASH HAND BASINS SHALL INCLUDE A TMV2 COMPLIANT THERMOSTATIC MIXING VALVE. SET TEMPERATURE TO 41°C.
- THERMOSTATIC MIXING VALVES SHALL INCLUDE A SINGLE CHECK VALVE ON HOT AND COLD WATER CONNECTIONS.
- ALL PIPELINES SHALL INCLUDE THERMAL INSULATION AND A VAPOUR BARRIER IN THE RUNNING LENGTH.
- THERMAL INSULATION SHALL BE CONTINUOUS THROUGH SUPPORTS AND OVER PIPE FITTINGS.
- VALVES, STRAINERS, AND OTHER PIPELINE ACCESSORIES SHALL INCLUDE PROPRIETARY TIE-ON INSULATED JACKETS.
- PIPELINES SHALL INCLUDE SERVICE IDENTIFICATION DIRECTION OF FLOW LABELLING.

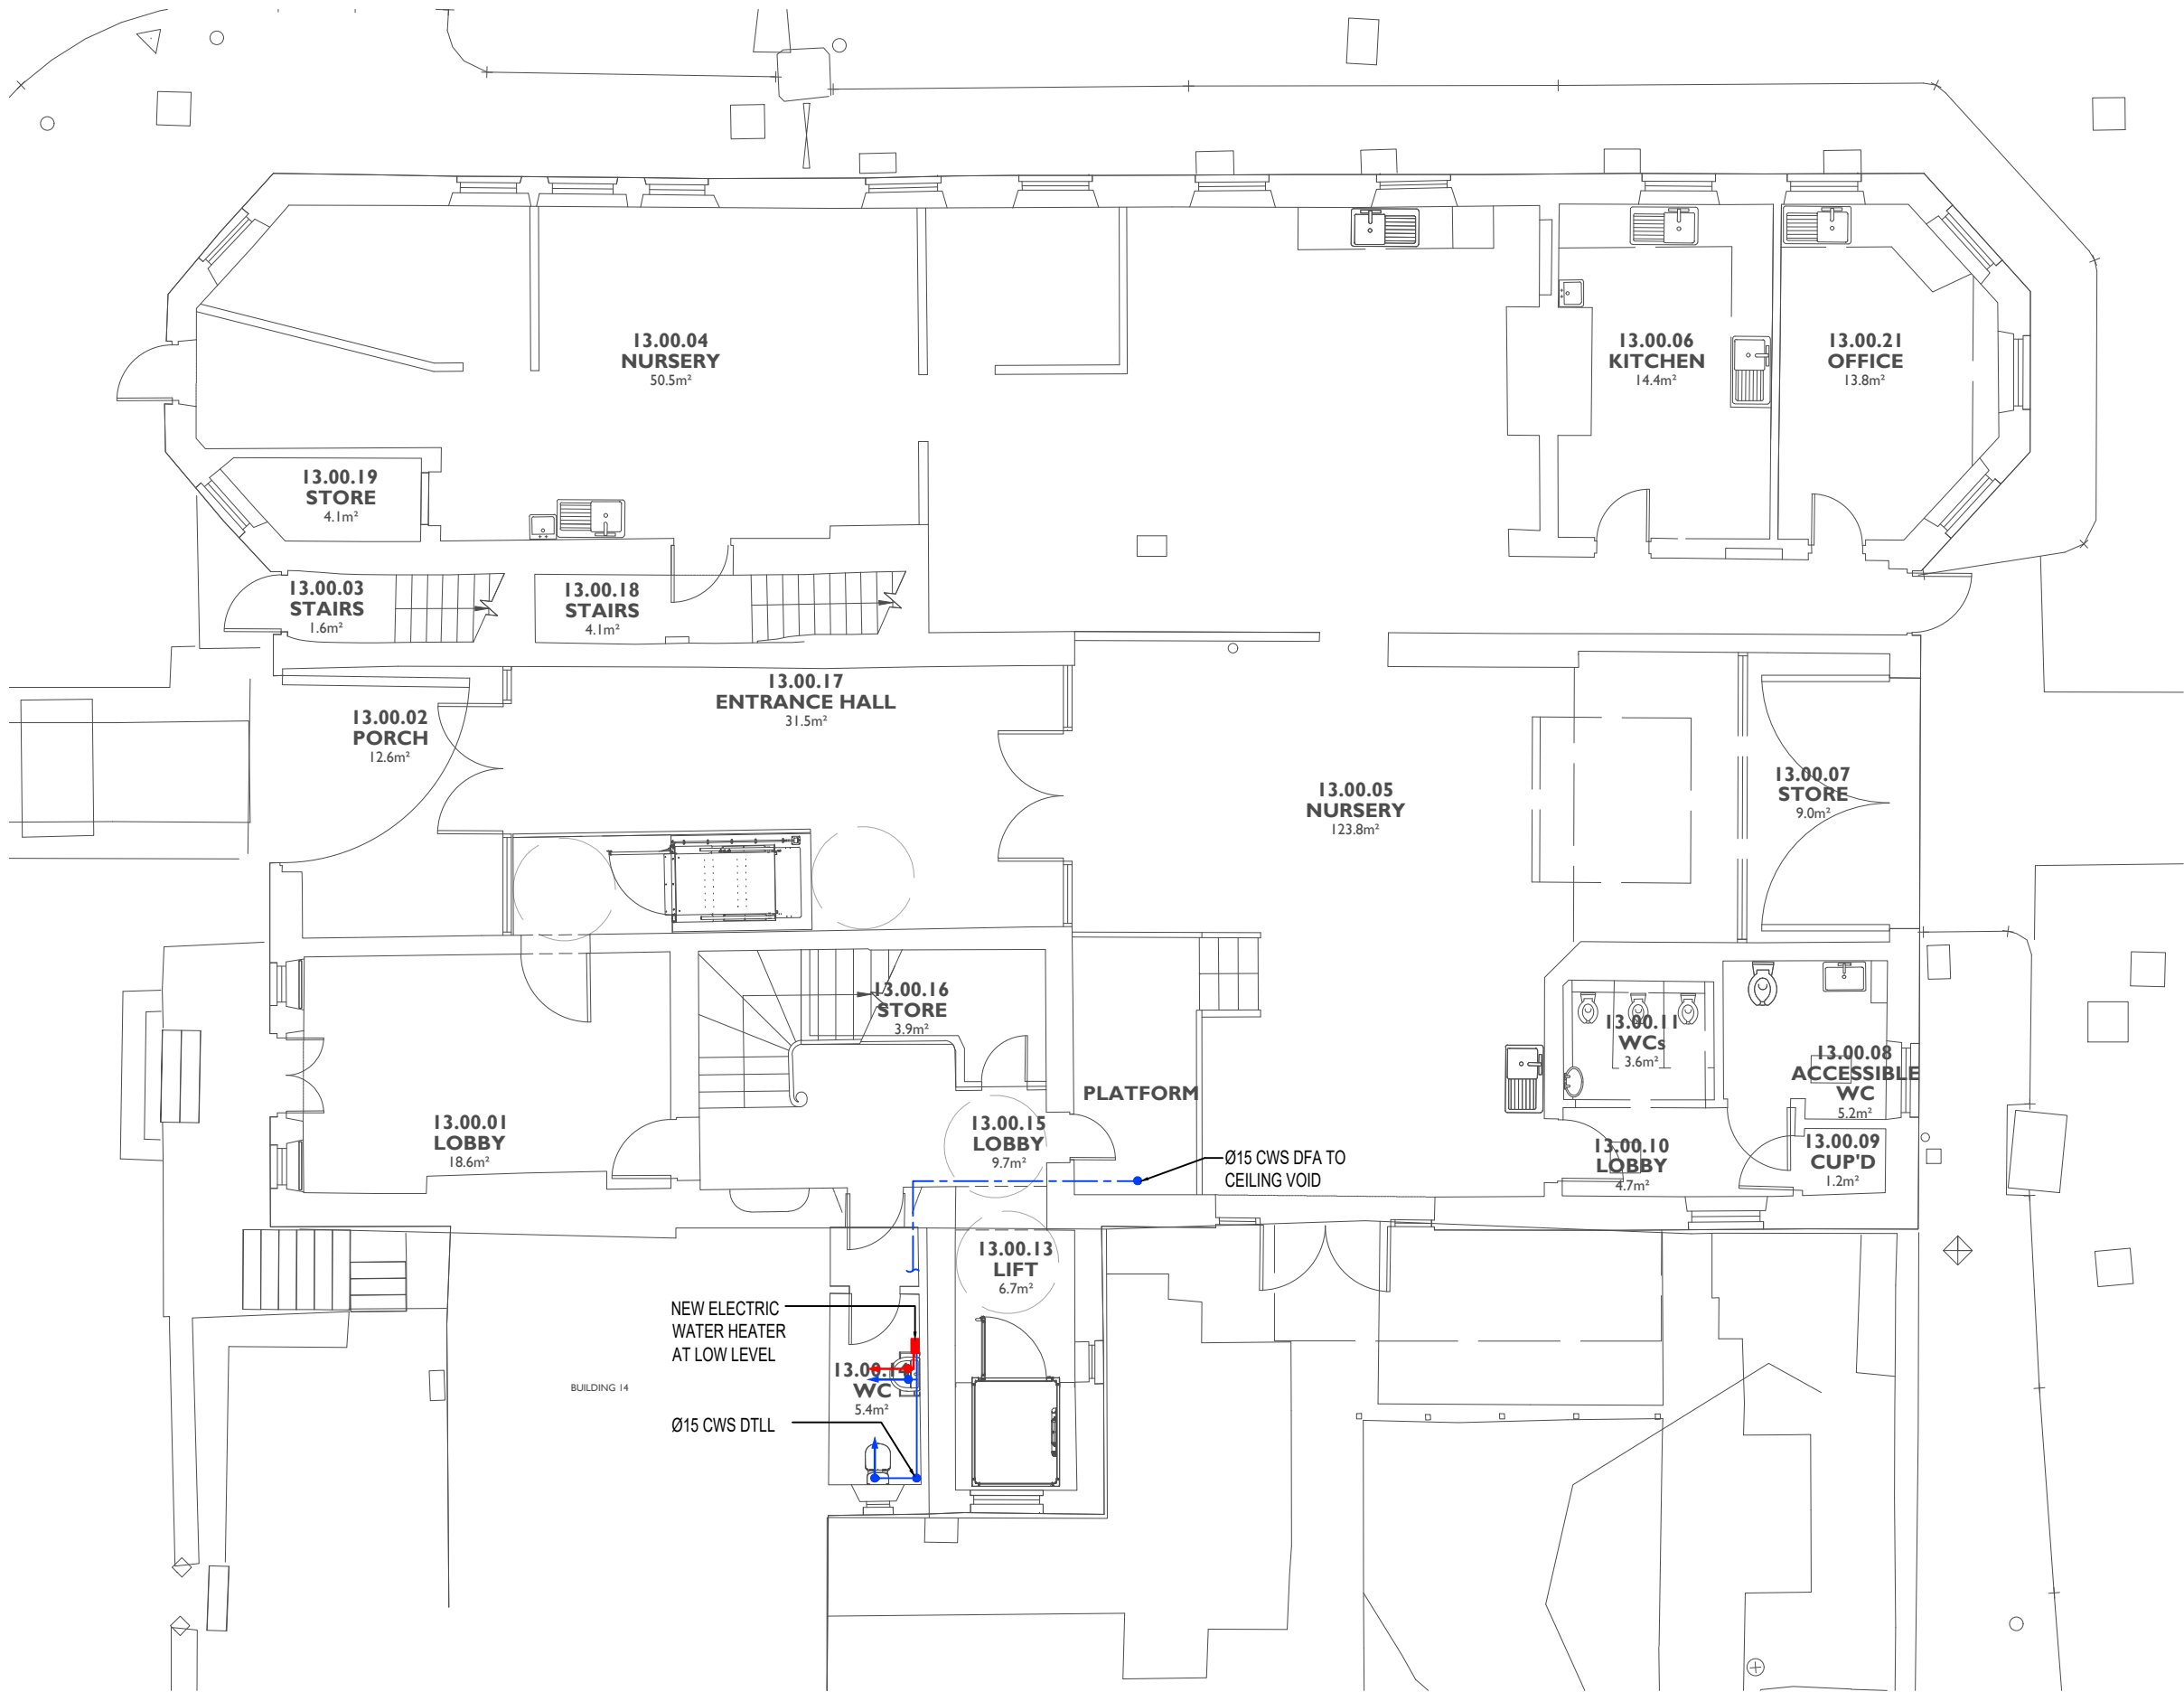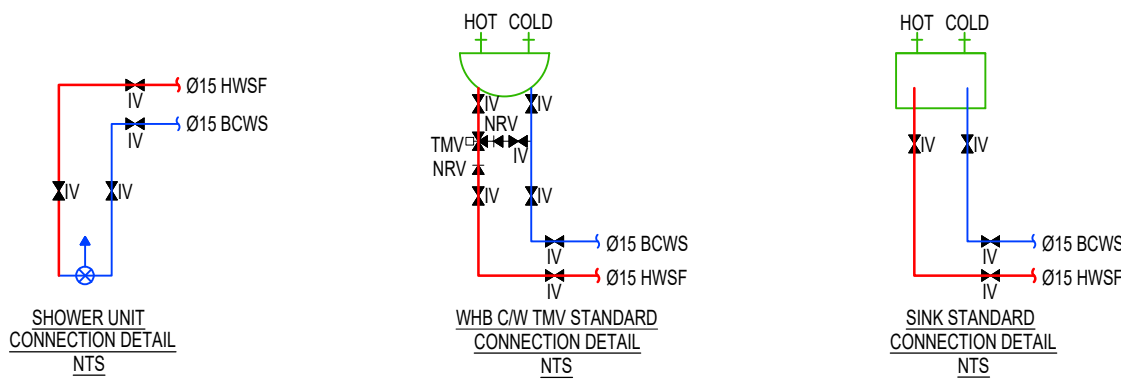

TGA Consulting Engineers LLP,
Salvus House, Aykley Heads, Durham City. DH1 5TS.
E: info@tgace.co.uk T: 0191 3862314

Project
ELSECAR: FORGING AHEAD

Title
MECHANICAL ENGINEERING SERVICES
PROPOSED DOMESTIC WATER SERVICES
BUILDING 13
GROUND FLOOR

Architect
PURCELL

Client
BARNSELY MBC

Suitability: Code Description
D2 FOR TENDER

Revision:	Scale:	TGA Proj No:	Stage:
P04	1:100	8193	4

Drawing Reference:
Project-Originator-Zone-Level-Type-Role-Classification-Number
EFAS-TGA-13-00-DR-M-53002



 Standard construction hazards that a competent contractor would be aware of have not been identified on this drawing. Any risks not immediately apparent are identified within the CDM Residual Risk Register.

LEGEND

CWS - COLD WATER SERVICED
DTLL - DROP TO LOW LEVEL
RTB - RISE FROM BELOW
RTA - RISE TO ABOVE
RTCV - RISE TO CEILING VOID
DTB - DROP TO BELOW
DTA - DROP FROM ABOVE

NOTES

- THIS DRAWING SHOWS THE DESIGN PROPOSAL FOR A WORKSTAGE 4 TECHNICAL DESIGN LEVEL OF DETAIL AND COMPLETENESS AS DEFINED BY BSRIA B66 :2018. ALL QUANTITIES AND LOCATIONS ARE BASED ON GENERIC EQUIPMENT SELECTIONS AND SHALL BE CONFIRMED AND FULLY COORDINATED AS PART OF THE CONSTRUCTION STAGE DESIGN ACTIVITIES.
- ALL DIMENSIONS ARE IN MILLIMETERS UNLESS NOTATED OTHERWISE.
- PIPEWORK SHALL BE ADEQUATELY SUPPORTED IN THE RUNNING LENGTH USING PROPRIETARY CLIPS, BRACKETS & SUPPORT SYSTEMS.
- ALL EQUIPMENT, VALVES AND OTHER ACCESSORIES SHALL BE FULLY ACCESSIBLE.
- PIPELINES PASSING THROUGH A FIRE RATED ELEMENT OF CONSTRUCTION SHALL INCLUDE A SUITABLY RATED FIRE COLLAR.
- ALL DOMESTIC APPLIANCES AND ITEMS OF SANITARYWARE SHALL INCLUDE A 1/2" TURN TERMINAL ISOLATING VALVE.
- WHITE GOODS AND OTHER DOMESTIC APPLIANCES SHALL INCLUDE A SINGLE CHECK VALVE AT THE POINT OF CONNECTION TO THE APPLIANCE.
- PIPEWORK SHALL BE IN FRIATHERM CPVC PLASTIC.
- ALL WASH HAND BASINS SHALL INCLUDE A TMV2 COMPLIANT THERMOSTATIC MIXING VALVE. SET TEMPERATURE TO 41°C.
- THERMOSTATIC MIXING VALVES SHALL INCLUDE A SINGLE CHECK VALVE ON HOT AND COLD WATER CONNECTIONS.
- ALL PIPELINES SHALL INCLUDE THERMAL INSULATION AND A VAPOUR BARRIER IN THE RUNNING LENGTH.
- THERMAL INSULATION SHALL BE CONTINUOUS THROUGH SUPPORTS AND OVER PIPE FITTINGS.
- VALVES, STRAINERS, AND OTHER PIPELINE ACCESSORIES SHALL INCLUDE PROPRIETARY TIE-ON INSULATED JACKETS.
- PIPELINES SHALL INCLUDE SERVICE IDENTIFICATION/ DIRECTION OF FLOW LABELLING.

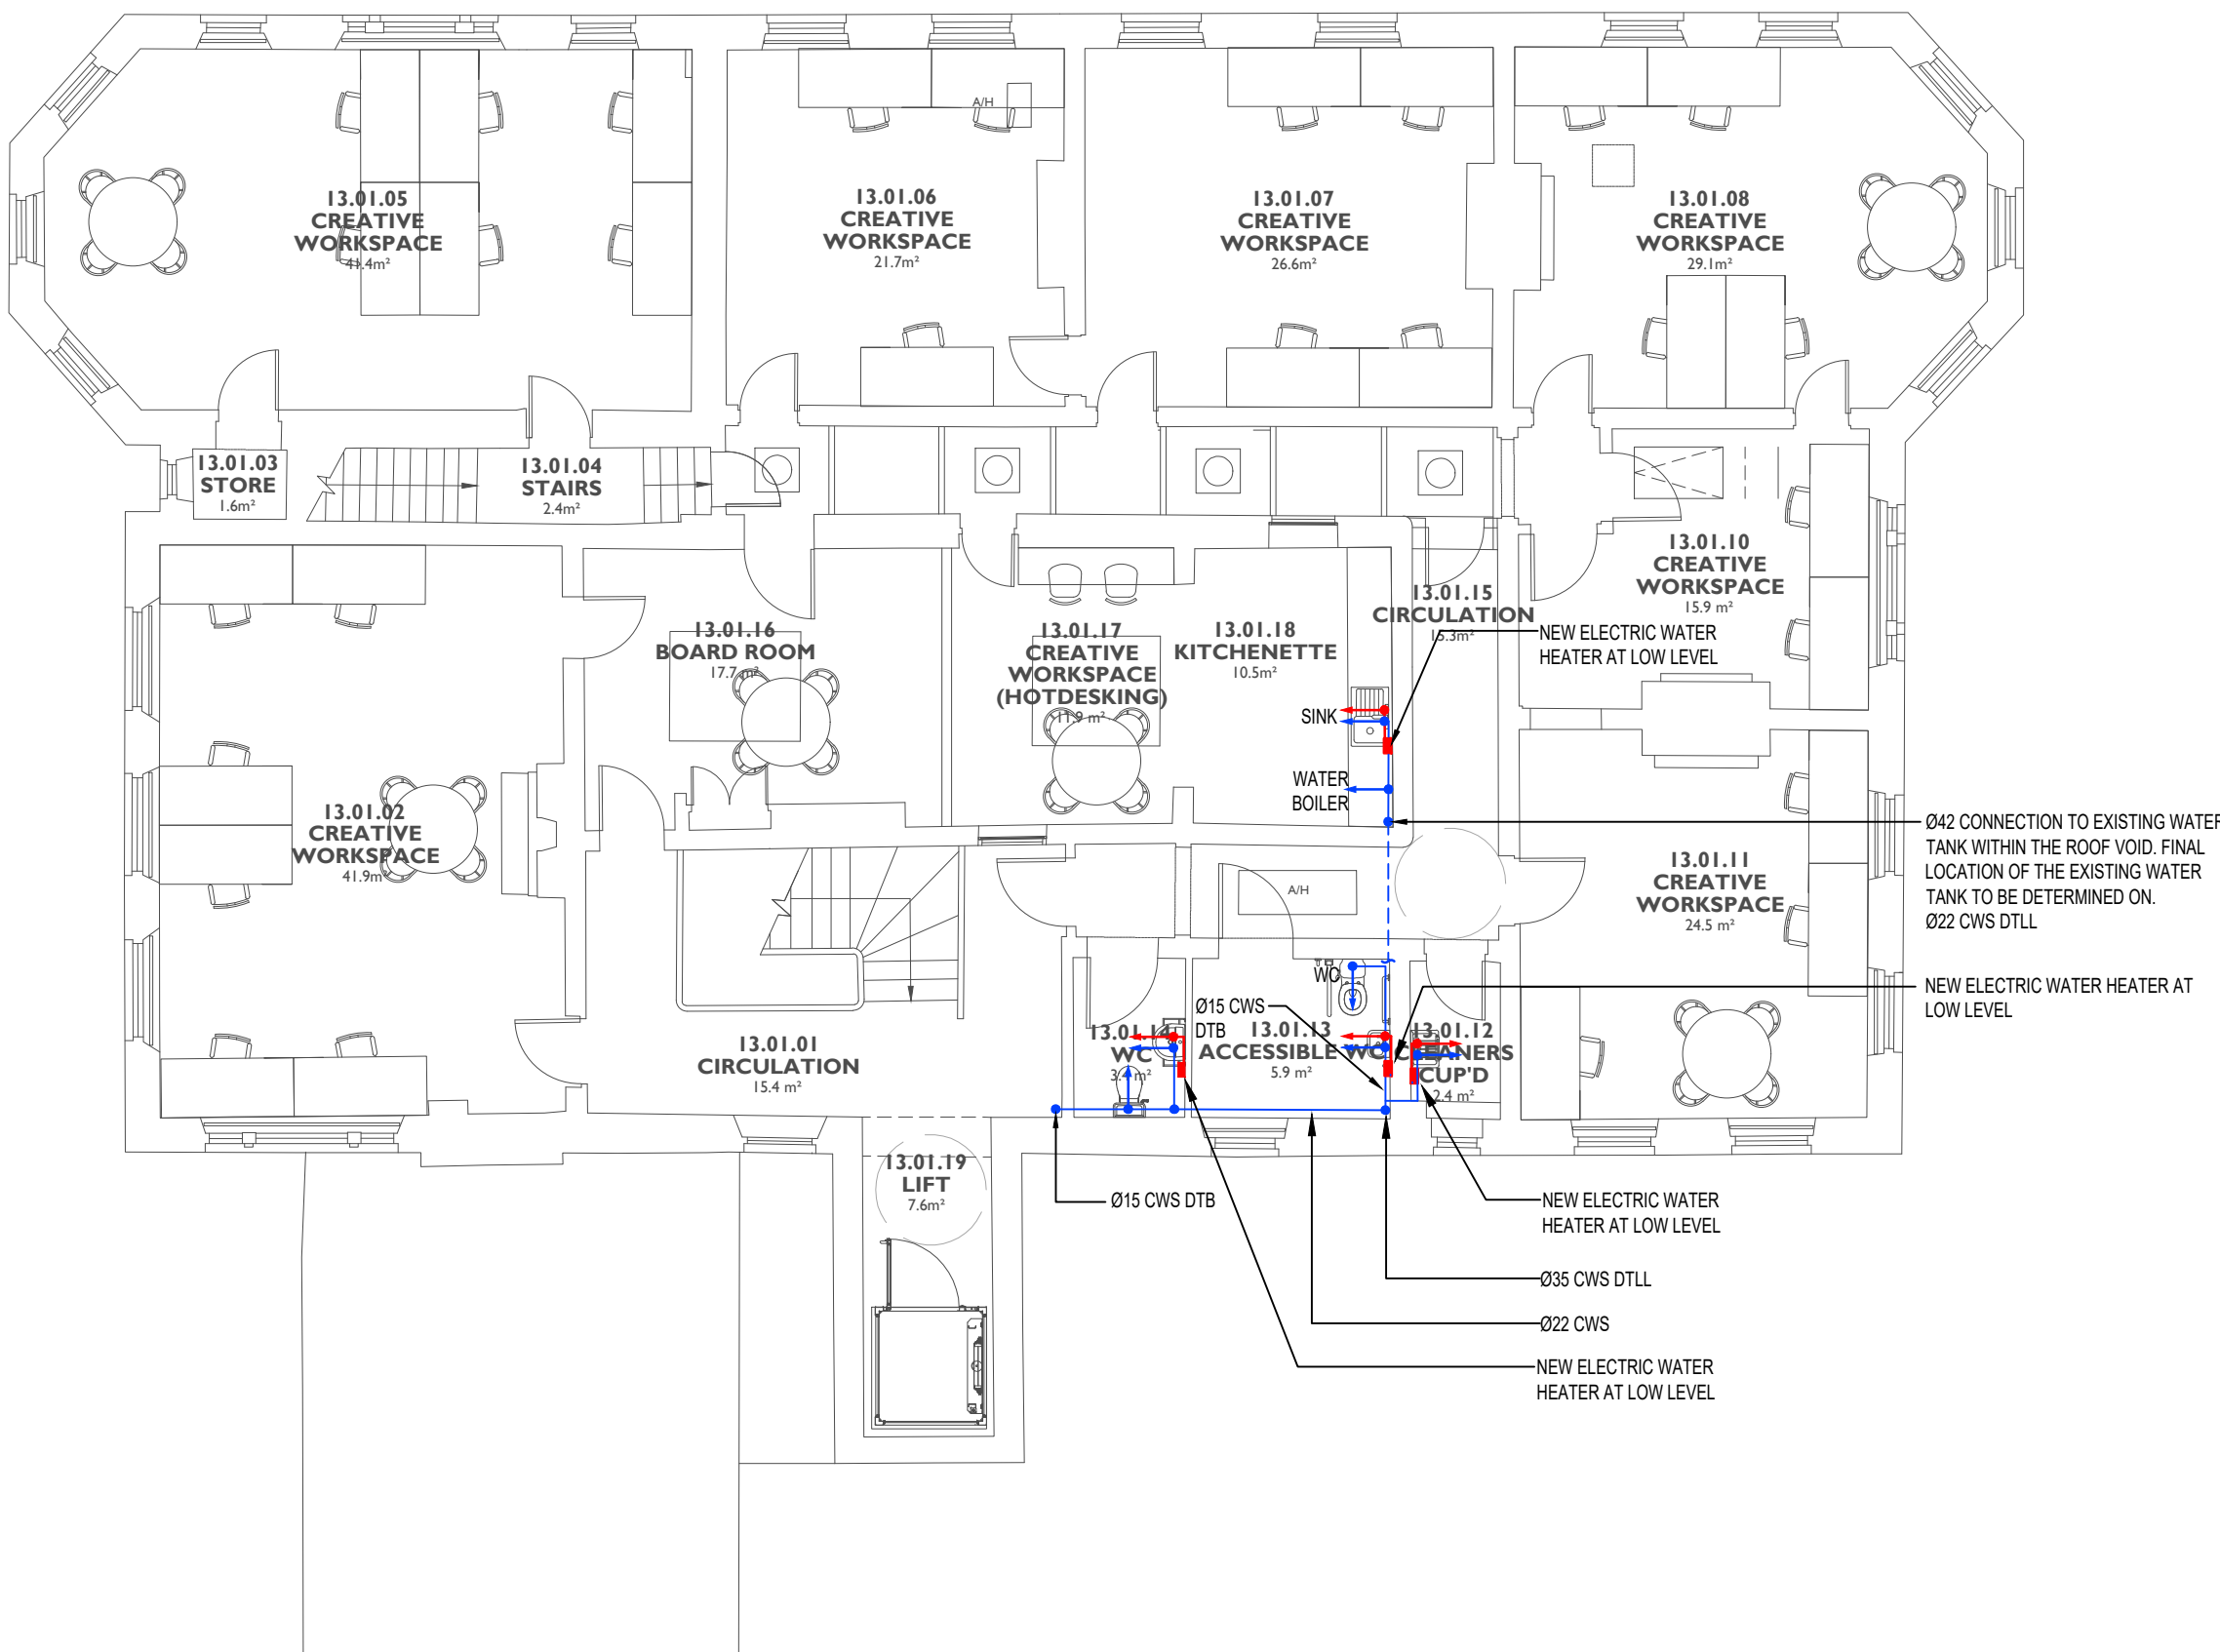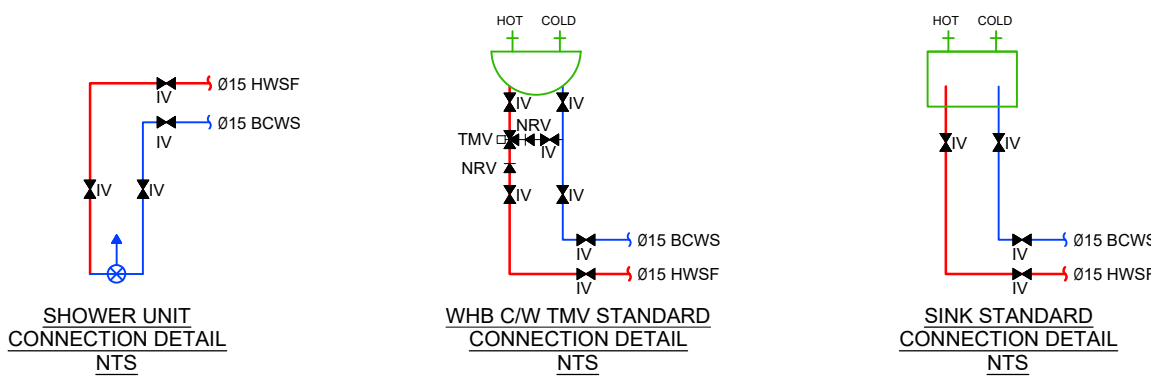

P04	22.08.23	SUITABLE FOR TENDER	RC	RE
P03	25.08.23	STAGE 4	MS	RE
P02	02.06.23	UPDATED TO ARCHITECTS COMMENTS AND LAYOUTS	LC	RP
P01	31.03.23	PRELIMINARY ISSUE	JW	RE
REV	DATE	DESCRIPTION	DRAWN	APP



TGA Consulting Engineers LLP,
Salvus House, Aykley Heads, Durham City. DH1 5TS.
E: info@tgace.co.uk T: 0191 3862314

Project
ELSECAR: FORGING AHEAD

Title
MECHANICAL ENGINEERING SERVICES
PROPOSED DOMESTIC WATER SERVICES
BUILDING 13
FIRST FLOOR

Architect
PURCELL

Client
BARNSELY MBC

Suitability: Code Description
D2 FOR TENDER

Revision: P04	Scale: 1:100	TGA Proj No: 8193	Stage: 4
------------------	-----------------	----------------------	-------------


Drawing Reference:
Project-Originator-Zone-Level-Type-Role-Classification-Number
EFAS-TGA-13-01-DR-M-53002

 Standard construction hazards that a competent contractor would be aware of have not been identified on this drawing. Any risks not immediately apparent are identified within the CDM Residual Risk Register.

 EXISTING HEATING, VENTILATION AND COOLING SYSTEM EMITTERS, PIPEWORK, DUCTWORK, BRACKETS, FIXINGS AND ANCLLARY ITEMS TO BE DECOMMISSIONED, STRIPPED OUT AND REMOVED.

NOTES

- THIS DRAWING SHOWS THE DESIGN PROPOSAL FOR A WORKSTAGE 4 TECHNICAL DESIGN LEVEL OF DETAIL AND COMPLETENESS AS DEFINED BY BSRIA 808 :2018. ALL QUANTITIES AND LOCATIONS ARE BASED ON GENERIC EQUIPMENT SELECTIONS AND SHALL BE CONFIRMED AND FULLY COORDINATED AS PART OF THE CONSTRUCTION STAGE DESIGN ACTIVITIES.
- READ IN CONJUNCTION WITH ALL OTHER RELATED DESIGN INFORMATION INCLUDING BUT NOT LIMITED TO ARCHITECTURAL AND STRUCTURAL INFORMATION.
- ALL DIMENSIONS ARE IN MILLIMETERS UNLESS NOTATED OTHERWISE.
- VENTILATION DUCTWORK SHALL BE IN GALVANISED STEEL TO BESA SPECIFICATION DW144.
- BENDS SHALL BE MEDIUM RADIUS. SQUARE BENDS SHALL INCLUDE TURNING VANES.
- SQUARE BENDS WITHOUT TURNING VANES SHALL NOT BE USED.
- GALVANISED STEEL DUCTWORK, PASSING THROUGH FIRE RATED ELEMENTS OF CONSTRUCTION, SHALL INCLUDE SUITABLY RATED FIRE DAMPERS IN ACCORDANCE WITH THE PUBLISHED FIRE STRATEGY. .
- DUCTWORK SHALL BE ADEQUATELY SUPPORTED IN THE RUNNING LENGTH USING PROPRIETARY CLIPS AND BRACKETS.
- INCLUDE VOLUME CONTROL DAMPERS AND MOTORISED DAMPERS WHERE INDICATED ON THE DRAWINGS.
- ALL DAMPERS AND OTHER DUCTWORK ACCESSORIES SHALL BE ACCESSIBLE. INCLUDE ADEQUALITY SIZED ACCESS DOORS.
- THERMAL INSULATION SHALL BE CONTINUOUS IN THE RUNNING LENGTH. CONTINUOUS THROUGH SUPPORTS AND OVER FITTINGS.
- DUCTLINES SHALL INCLUDE DIRECTION-OF-FLOW AND SERVICE IDENTIFICATION LABELLING.

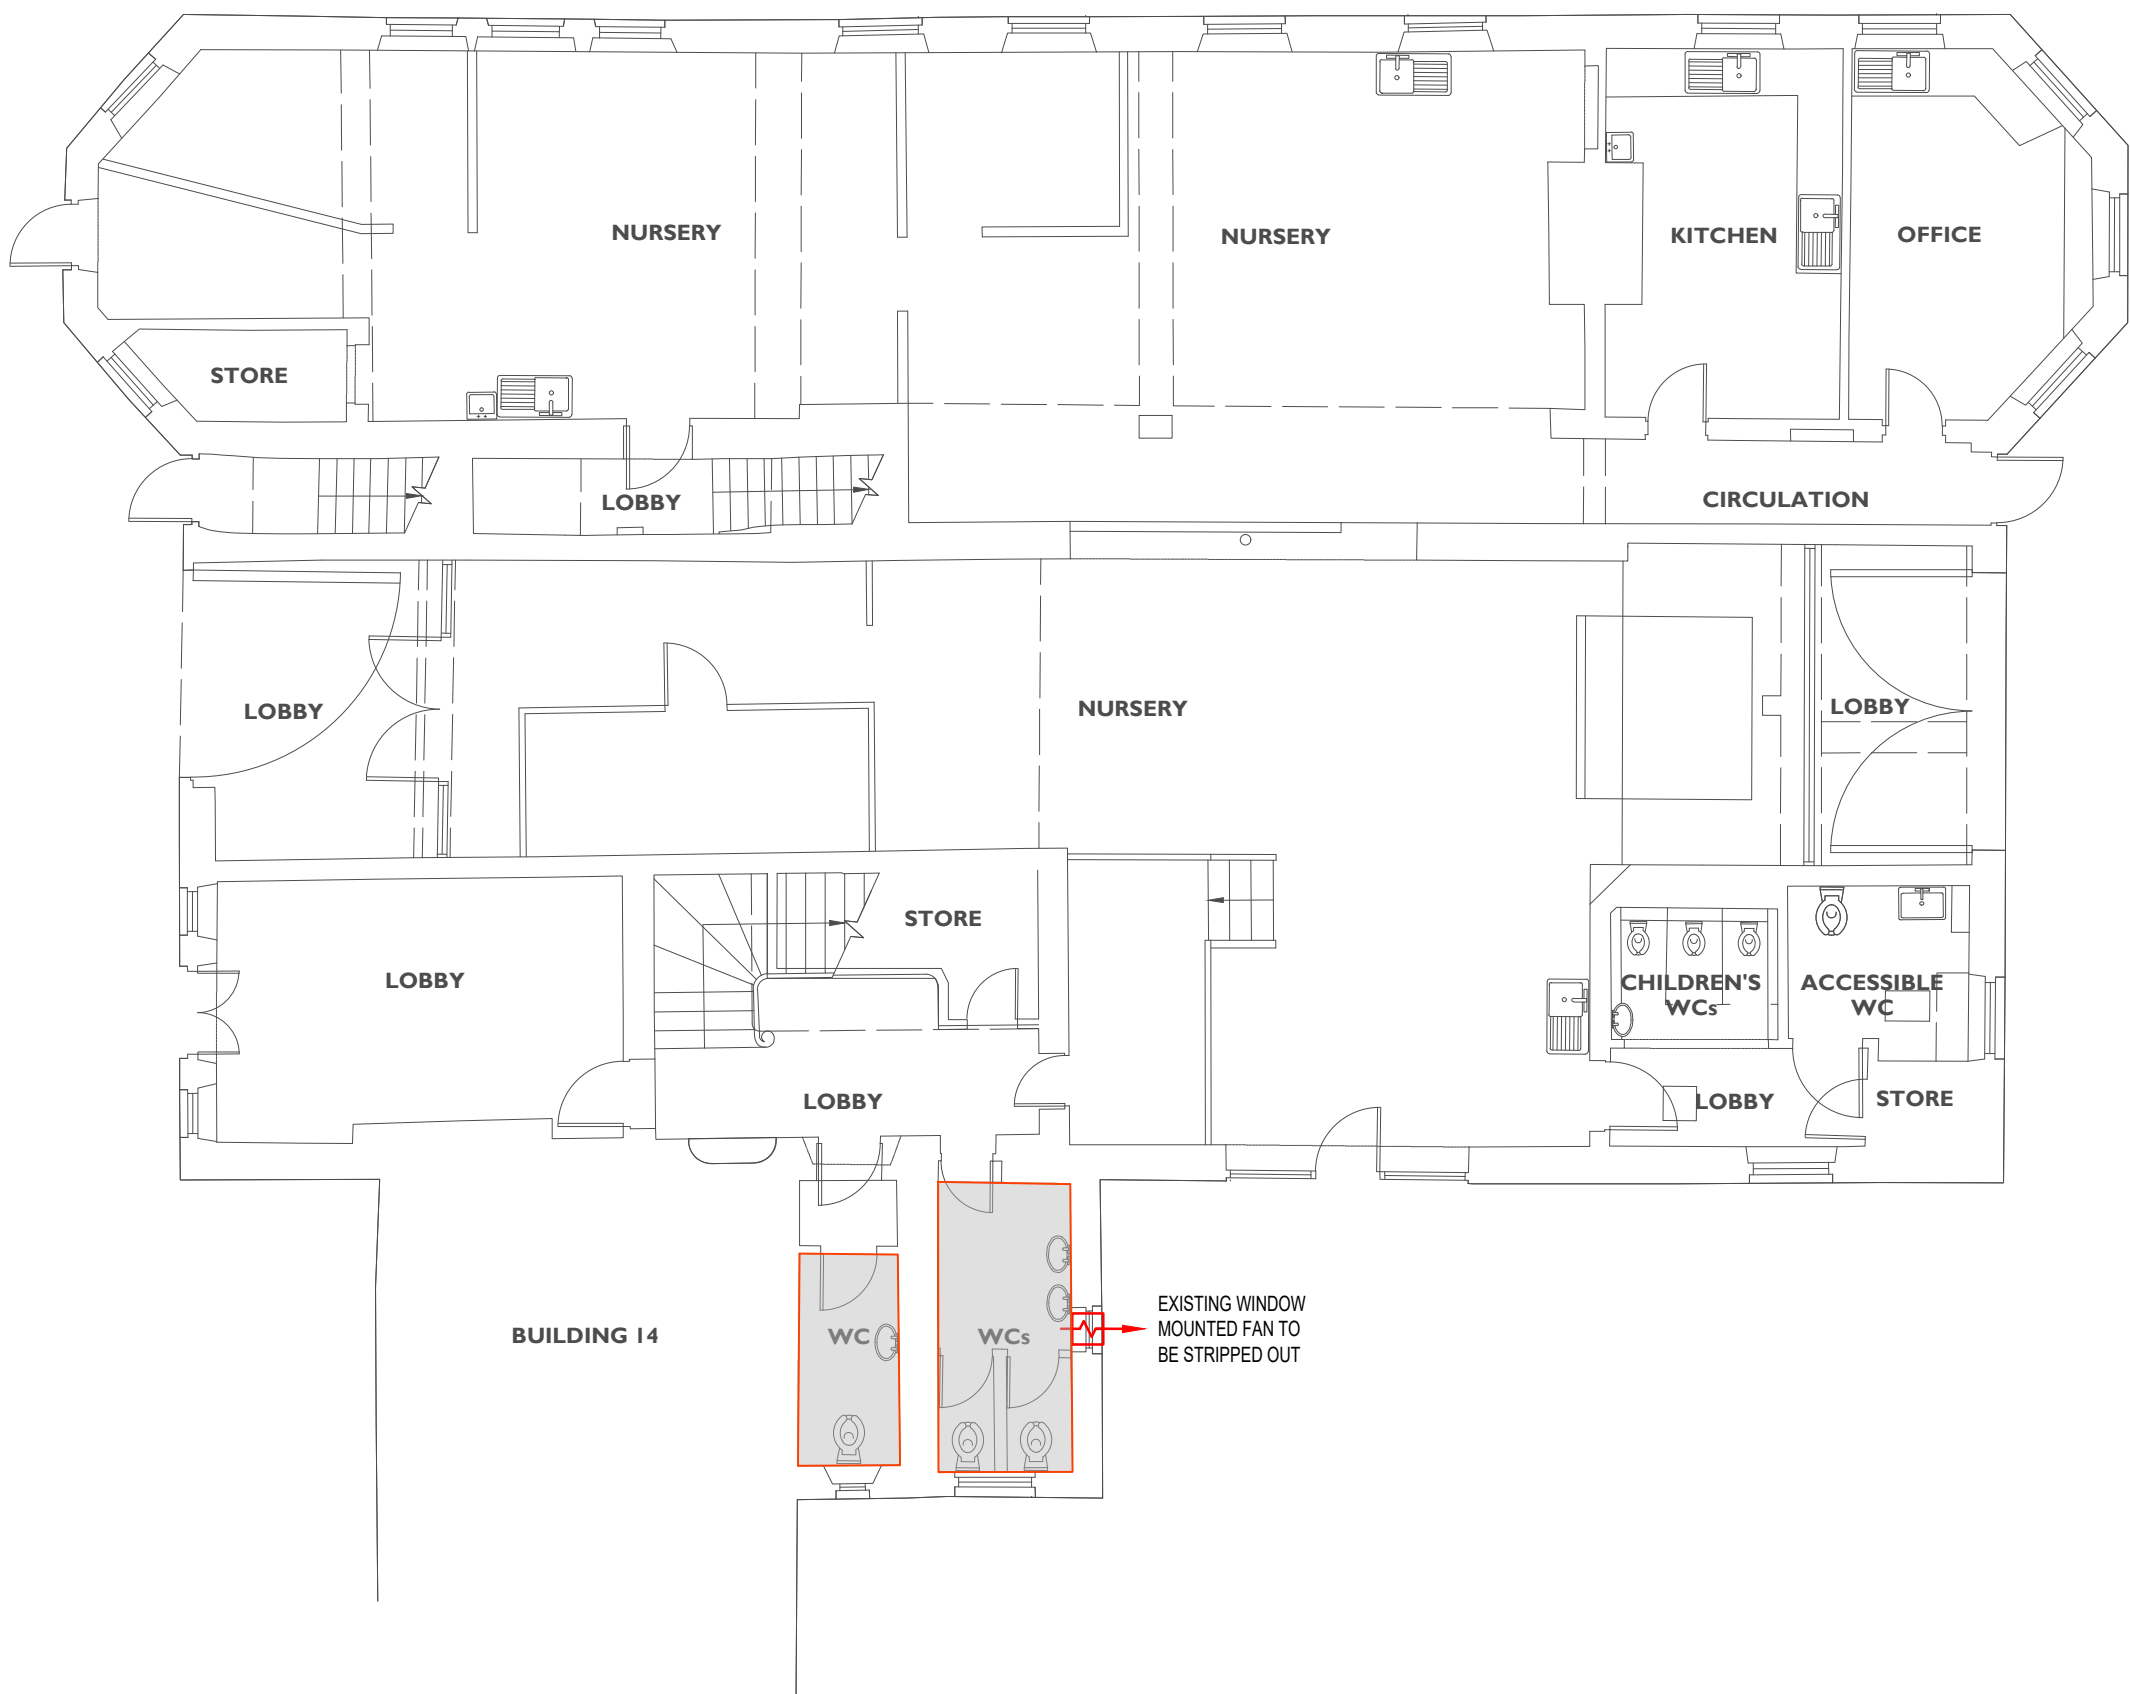

P04	22.08.23	SUITABLE FOR TENDER	RC	RE
P03	25.08.23	STAGE 4 REVIEW	BM	RE
P02	02.06.23	UPDATED TO ARCHITECTS COMMENTS AND LAYOUTS	LC	RP
P01	14.04.23	PRELIMINARY ISSUE	BM	RE
REV	DATE	DESCRIPTION	DRAWN	APP



TGA Consulting Engineers LLP,
Salvus House, Aykley Heads, Durham City. DH1 5TS.
E: info@tgace.co.uk T: 0191 3862314

Project
ELSECAR: FORGING AHEAD

Title
MECHANICAL ENGINEERING SERVICES
EXISTING HEATING, VENTILATION & AIR
CONDITIONING SERVICES
BUILDING 13
GROUND FLOOR

Architect
PURCELL

Client
BARNESLEY MBC

Suitability: Code Description
D2 FOR TENDER

Revision: P04	Scale: 1:100	TGA Proj No: 8193	Stage: 4
------------------	-----------------	----------------------	-------------


Drawing Reference:
Project-Originator-Zone-Level-Type-Role-Classification-Number
EFAS-TGA-13-00-DR-M-56001

 Standard construction hazards that a competent contractor would be aware of have not been identified on this drawing. Any risks not immediately apparent are identified within the CDM Residual Risk Register.

 EXISTING HEATING, VENTILATION AND COOLING SYSTEM EMITTERS, PIPEWORK, DUCTWORK, BRACKETS, FIXINGS AND ANCLLARY ITEMS TO BE DECOMMISSIONED, STRIPPED OUT AND REMOVED.

NOTES

1. THIS DRAWING SHOWS THE DESIGN PROPOSAL FOR A WORKSTAGE 4 TECHNICAL DESIGN LEVEL OF DETAIL AND COMPLETENESS AS DEFINED BY BSRIA B66 :2018. ALL QUANTITIES AND LOCATIONS ARE BASED ON GENERIC EQUIPMENT SELECTIONS AND SHALL BE CONFIRMED AND FULLY COORDINATED AS PART OF THE CONSTRUCTION STAGE DESIGN ACTIVITIES.
2. READ IN CONJUNCTION WITH ALL OTHER RELATED DESIGN INFORMATION INCLUDING BUT NOT LIMITED TO ARCHITECTURAL AND STRUCTURAL INFORMATION.
3. ALL DIMENSIONS ARE IN MILLIMETERS UNLESS NOTATED OTHERWISE.
4. VENTILATION DUCTWORK SHALL BE IN GALVANISED STEEL TO BESA SPECIFICATION DW144.
5. BENDS SHALL BE MEDIUM RADIUS. SQUARE BENDS SHALL INCLUDE TURNING VANES.
6. SQUARE BENDS WITHOUT TURNING VANES SHALL NOT BE USED.
7. GALVANISED STEEL DUCTWORK, PASSING THROUGH FIRE RATED ELEMENTS OF CONSTRUCTION, SHALL INCLUDE SUITABLY RATED FIRE DAMPERS IN ACCORDANCE WITH THE PUBLISHED FIRE STRATEGY. .
8. DUCTWORK SHALL BE ADEQUATELY SUPPORTED IN THE RUNNING LENGTH USING PROPRIETARY CLIPS AND BRACKETS.
9. INCLUDE VOLUME CONTROL DAMPERS AND MOTORISED DAMPERS WHERE INDICATED ON THE DRAWINGS.
10. ALL DAMPERS AND OTHER DUCTWORK ACCESSORIES SHALL BE ACCESSIBLE. INCLUDE ADEQUALITY SIZED ACCESS DOORS.
11. THERMAL INSULATION SHALL BE CONTINUOUS IN THE RUNNING LENGTH, CONTINUOUS THROUGH SUPPORTS AND OVER FITTINGS.
12. DUCTLINES SHALL INCLUDE DIRECTION-OF-FLOW AND SERVICE IDENTIFICATION LABELLING.

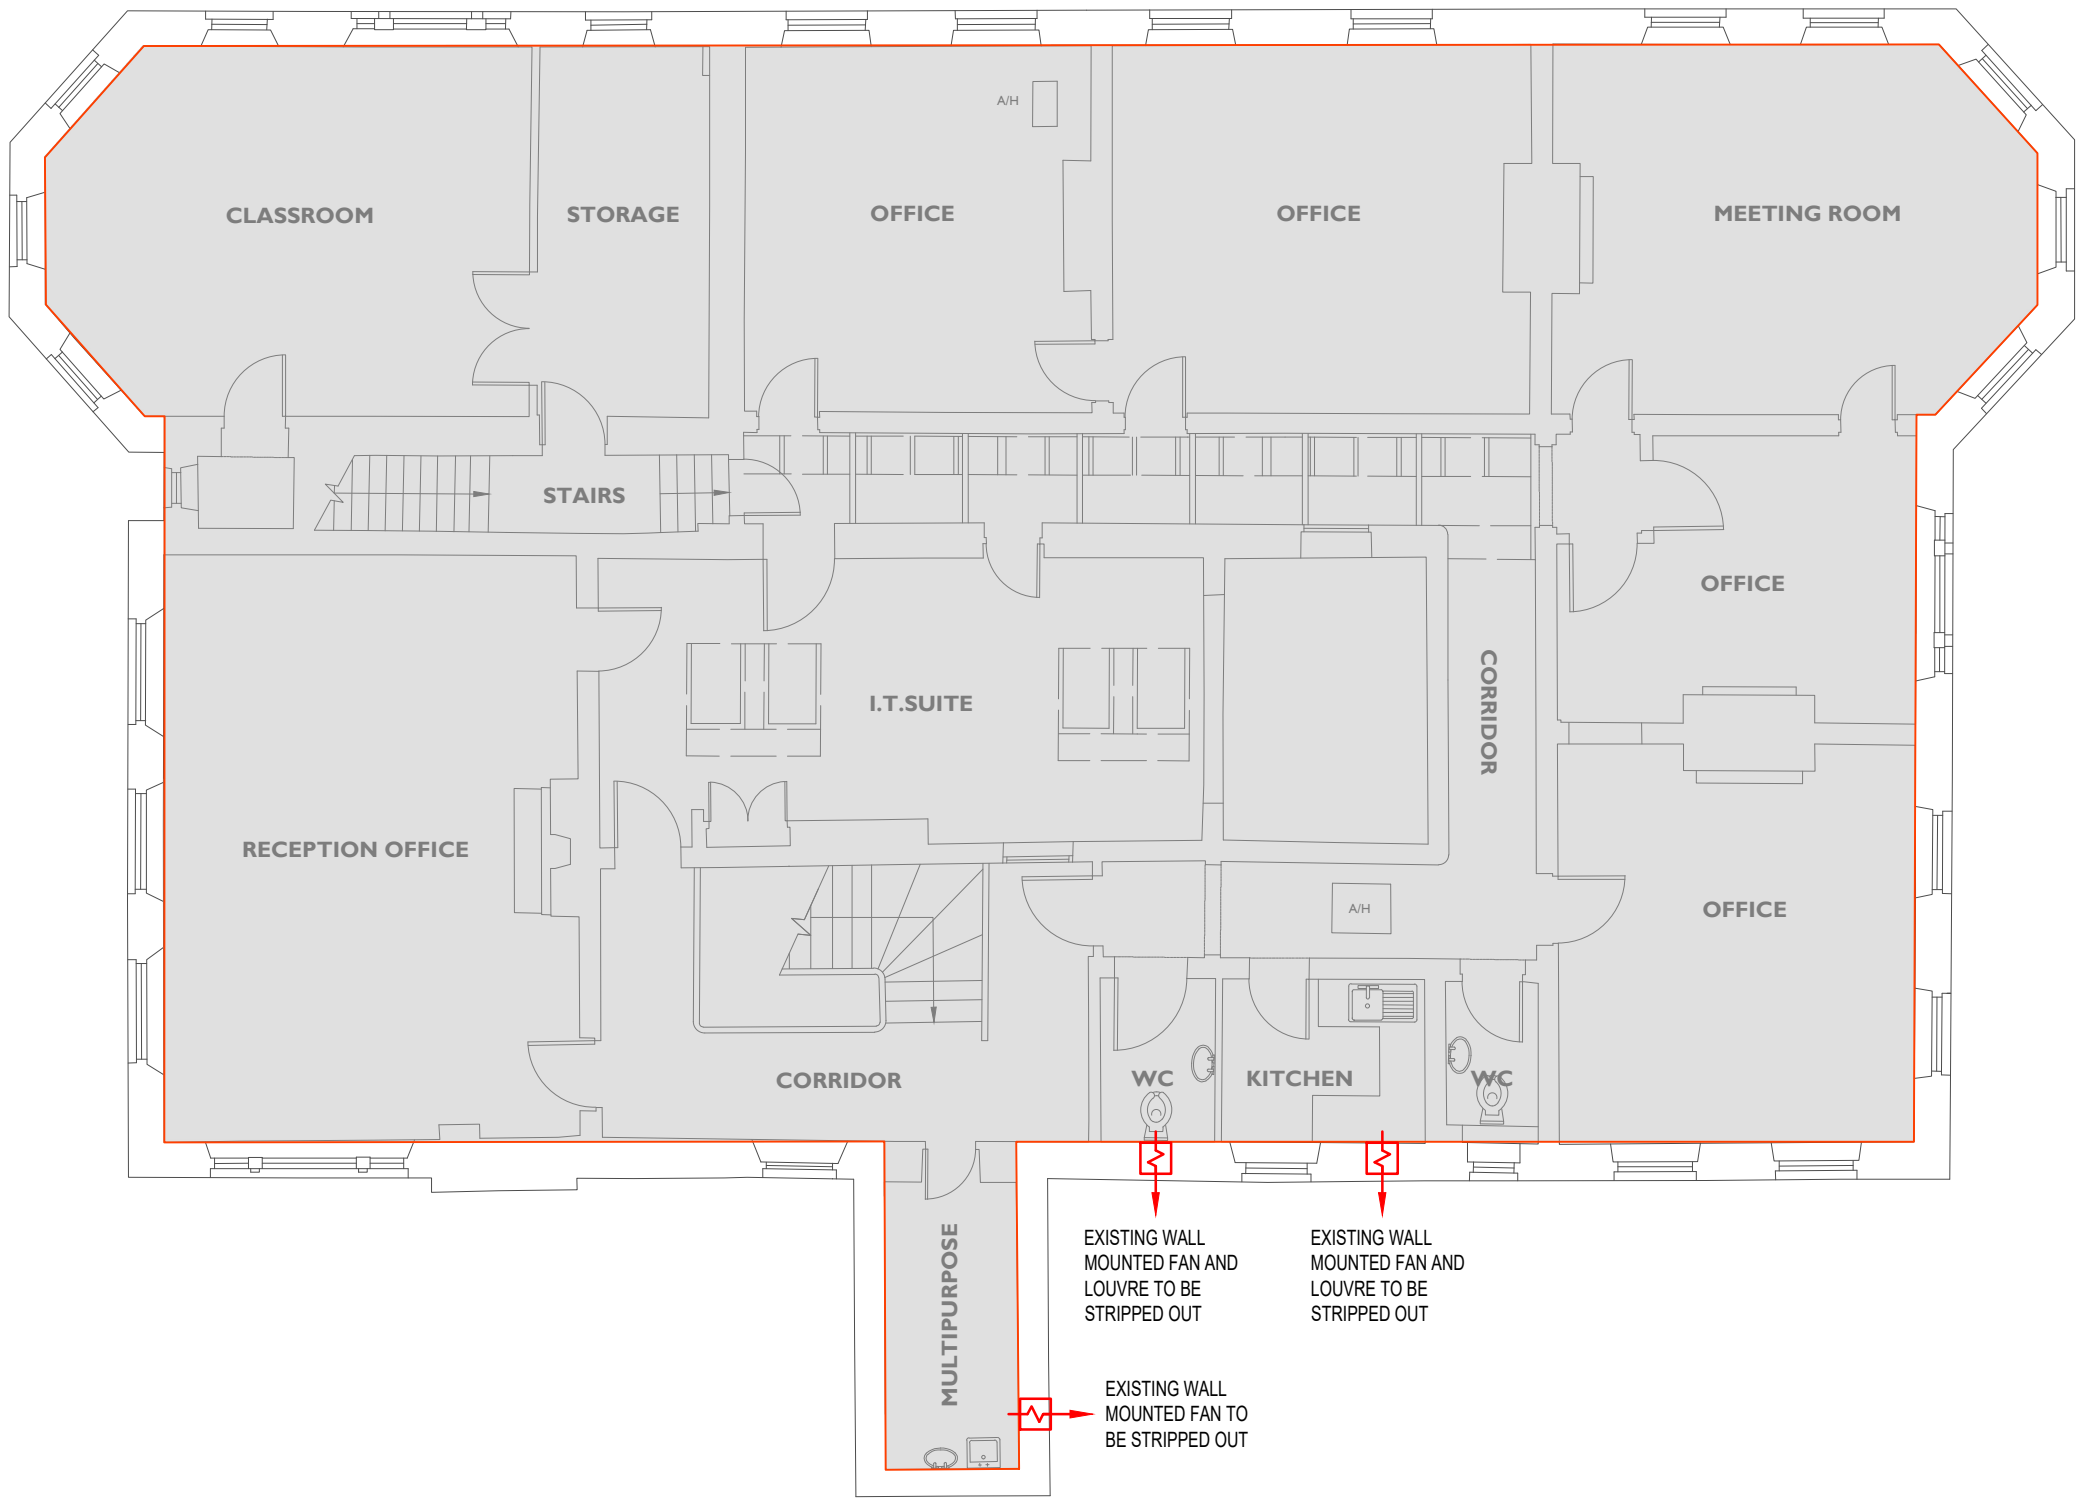

P04	22.08.23	SUITABLE FOR TENDER	RC	RE
P03	25.08.23	STAGE 4 REVIEW	BM	RE
P02	02.06.23	UPDATED TO ARCHITECTS COMMENTS AND LAYOUTS	LC	RP
P01	14.04.23	PRELIMINARY ISSUE	BM	RE
REV	DATE	DESCRIPTION	DRAWN	APP



TGA Consulting Engineers LLP,
Salvus House, Aykley Heads, Durham City. DH1 5TS.
E: info@tgace.co.uk T: 0191 3862314

Project
ELSECAR: FORGING AHEAD

Title
**MECHANICAL ENGINEERING SERVICES
EXISTING HEATING, VENTILATION & AIR
CONDITIONING SERVICES
BUILDING 13
FIRST FLOOR**

Architect
PURCELL

Client
BARNESLEY MBC

Suitability: Code Description
D2 FOR TENDER

Revision: P04	Scale: 1:100	TGA Proj No: 8193	Stage: 4
-------------------------	------------------------	-----------------------------	--------------------

Drawing Reference:
Project-Originator-Zone-Level-Type-Role-Classification-Number
EFAS-TGA-13-01-DR-M-56001

Standard construction hazards that a competent contractor would be aware of have not been identified on this drawing. Any risks not immediately apparent are identified within the CDM Residual Risk Register.

- LEGEND
- RADIATOR
 - LOW SURFACE TEMPERATURE RADIATOR
 - CEILING CASSETE UNIT
 - DAC DOOR AIR CURTAIN
 - EXTRACT FAN
 - HEAT RECOVERY UNIT
 - PIPEWORK IN FLOOR VOID
 - PIPEWORK AT LOW LEVEL
 - DUCTWORK

- NOTES
- THIS DRAWING SHOWS THE DESIGN PROPOSAL FOR A WORKSTAGE 4 TECHNICAL DESIGN LEVEL OF DETAIL AND COMPLETENESS AS DEFINED BY BSRIA 568:2018. ALL QUANTITIES AND LOCATIONS ARE BASED ON GENERIC EQUIPMENT SELECTIONS AND SHALL BE CONFIRMED AND FULLY COORDINATED AS PART OF THE CONSTRUCTION STAGE DESIGN ACTIVITIES.
 - READ IN CONJUNCTION WITH ALL OTHER RELATED DESIGN INFORMATION INCLUDING BUT NOT LIMITED TO ARCHITECTURAL AND STRUCTURAL INFORMATION.
 - ALL DIMENSIONS ARE IN MILLIMETERS UNLESS NOTATED OTHERWISE.
 - VENTILATION DUCTWORK SHALL BE IN GALVANISED STEEL TO BESA SPECIFICATION DW144.
 - BENDS SHALL BE MEDIUM RADIUS. SQUARE BENDS SHALL INCLUDE TURNING VANES.
 - SQUARE BENDS WITHOUT TURNING VANES SHALL NOT BE USED.
 - GALVANISED STEEL DUCTWORK, PASSING THROUGH FIRE RATED ELEMENTS OF CONSTRUCTION, SHALL INCLUDE SUITABLY RATED FIRE DAMPERS IN ACCORDANCE WITH THE PUBLISHED FIRE STRATEGY.
 - DUCTWORK WORK SHALL BE ADEQUATELY SUPPORTED IN THE RUNNING LENGTH USING PROPRIETARY CLIPS AND BRACKETS.
 - INCLUDE VOLUME CONTROL DAMPERS AND MOTORISED DAMPERS WHERE INDICATED ON THE DRAWINGS.
 - ALL DAMPERS AND OTHER DUCTWORK ACCESSORIES SHALL BE ACCESSIBLE. INCLUDE ADEQUATELY SIZED ACCESS DOORS.
 - THERMAL INSULATION SHALL BE CONTINUOUS IN THE RUNNING LENGTH, CONTINUOUS THROUGH SUPPORTS AND OVER FITTINGS.
 - DUCTLINES SHALL INCLUDE DIRECTION-OF-FLOW AND SERVICE IDENTIFICATION LABELLING.

P06	29.09.23	UPDATED PIPE SIZES	BM	RE
P05	22.09.23	SUITABLE FOR TENDER	RC	RE
P04	05.08.23	STAGE 4 ISSUE	BM	RE
P03	05.06.23	ARCHITECTS COMMENTS INCORPORATED	LC	RE
P02	02.06.23	UPDATED TO ARCHITECTS COMMENTS AND LAYOUTS	LC	RP
P01	14.04.23	PRELIMINARY ISSUE	BM	RE
REV	DATE	DESCRIPTION	DRAWN	APP



TGA Consulting Engineers LLP,
Salvus House, Aykley Heads, Durham City. DH1 5TS.
E: info@tgace.co.uk T: 0191 3862314

Project
ELSECAR: FORGING AHEAD

Title
MECHANICAL ENGINEERING SERVICES
PROPOSED HEATING
BUILDING 13
GROUND FLOOR


Architect
PURCELL

Client
BARNSELEY MBC


Suitability: Code Description
D2 FOR TENDER

Revision:	Scale:	TGA Proj No:	Stage:
P06	1:100	8193	4

Drawing Reference:
Project-Originator-Zone-Level-Type-Role-Classification-Number
EFAS-TGA-13-00-DR-M-56002

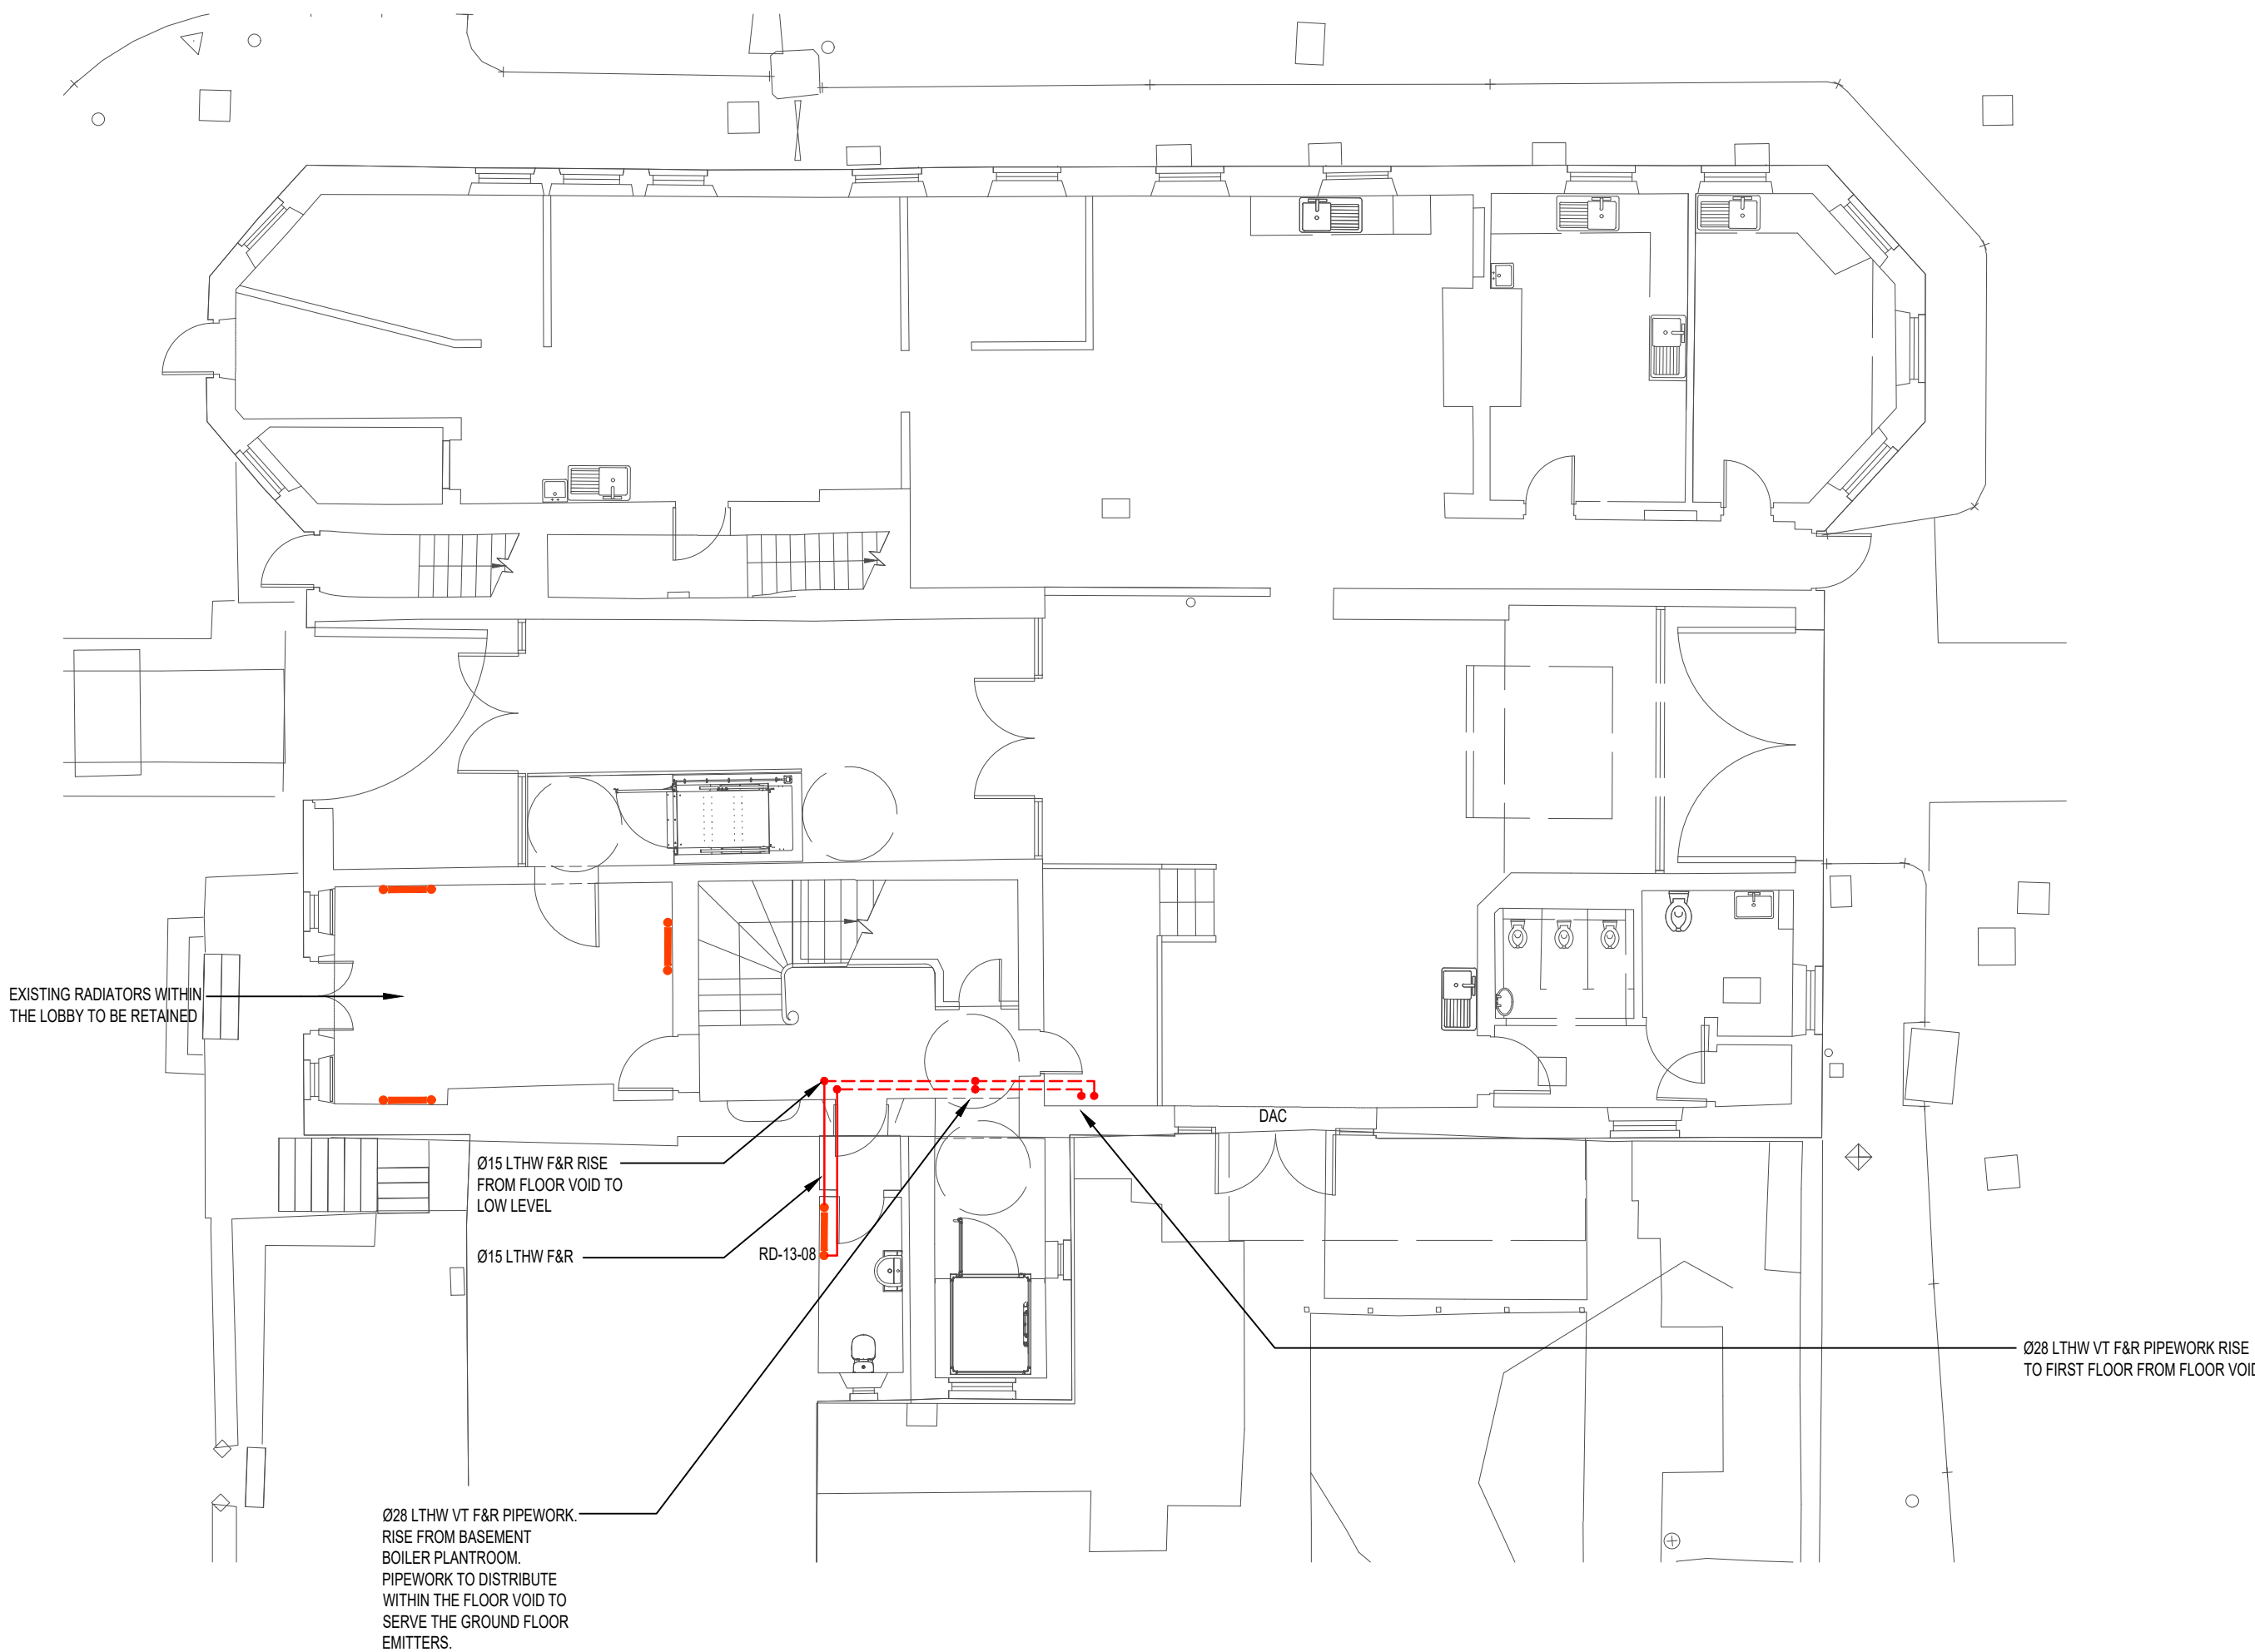

Standard construction hazards that a competent contractor would be aware of have not been identified on this drawing. Any risks not immediately apparent are identified within the CDM Residual Risk Register.

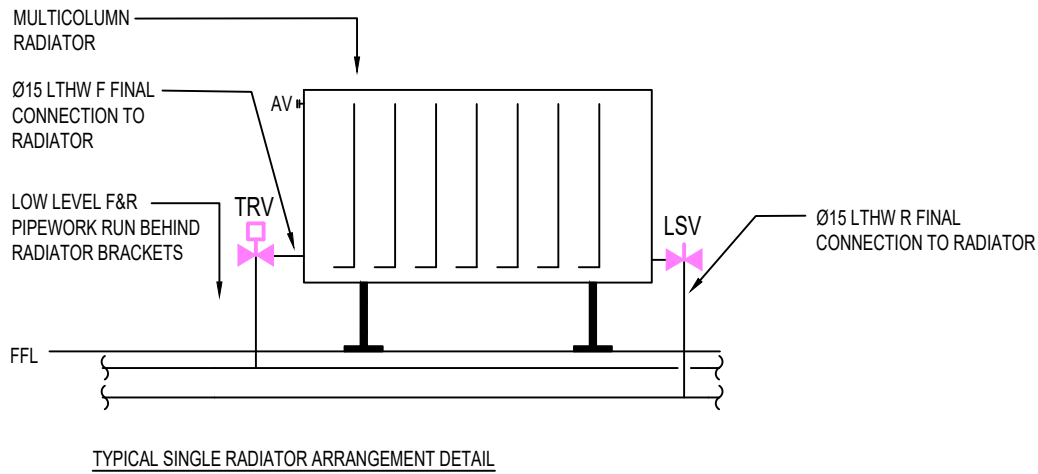


LEGEND

- RADIATOR
- LOW SURFACE TEMPERATURE RADIATOR
- PIPEWORK IN FLOOR VOID
- PIPEWORK AT LOW LEVEL
- PIPEWORK AT HIGH LEVEL
- DTLL DROP TO LOW LEVEL
- F&R FLOW & RETURN
- LTHW LOW TEMPERATURE HOT WATER

NOTES

- THIS DRAWING SHOWS THE DESIGN PROPOSAL FOR A WORKSTAGE 4 TECHNICAL DESIGN LEVEL OF DETAIL AND COMPLETENESS AS DEFINED BY BSRIA B58:2018. ALL QUANTITIES AND LOCATIONS ARE BASED ON GENERIC EQUIPMENT SELECTIONS AND SHALL BE CONFIRMED AND FULLY COORDINATED AS PART OF THE CONSTRUCTION STAGE DESIGN ACTIVITIES.
- READ IN CONJUNCTION WITH ALL OTHER RELATED DESIGN INFORMATION INCLUDING BUT NOT LIMITED TO ARCHITECTURAL AND STRUCTURAL INFORMATION.
- ALL DIMENSIONS ARE IN MILLIMETERS UNLESS NOTATED OTHERWISE.
- THERMAL INSULATION SHALL BE CONTINUOUS IN THE RUNNING LENGTH, CONTINUOUS THROUGH SUPPORTS AND OVER FITTINGS.

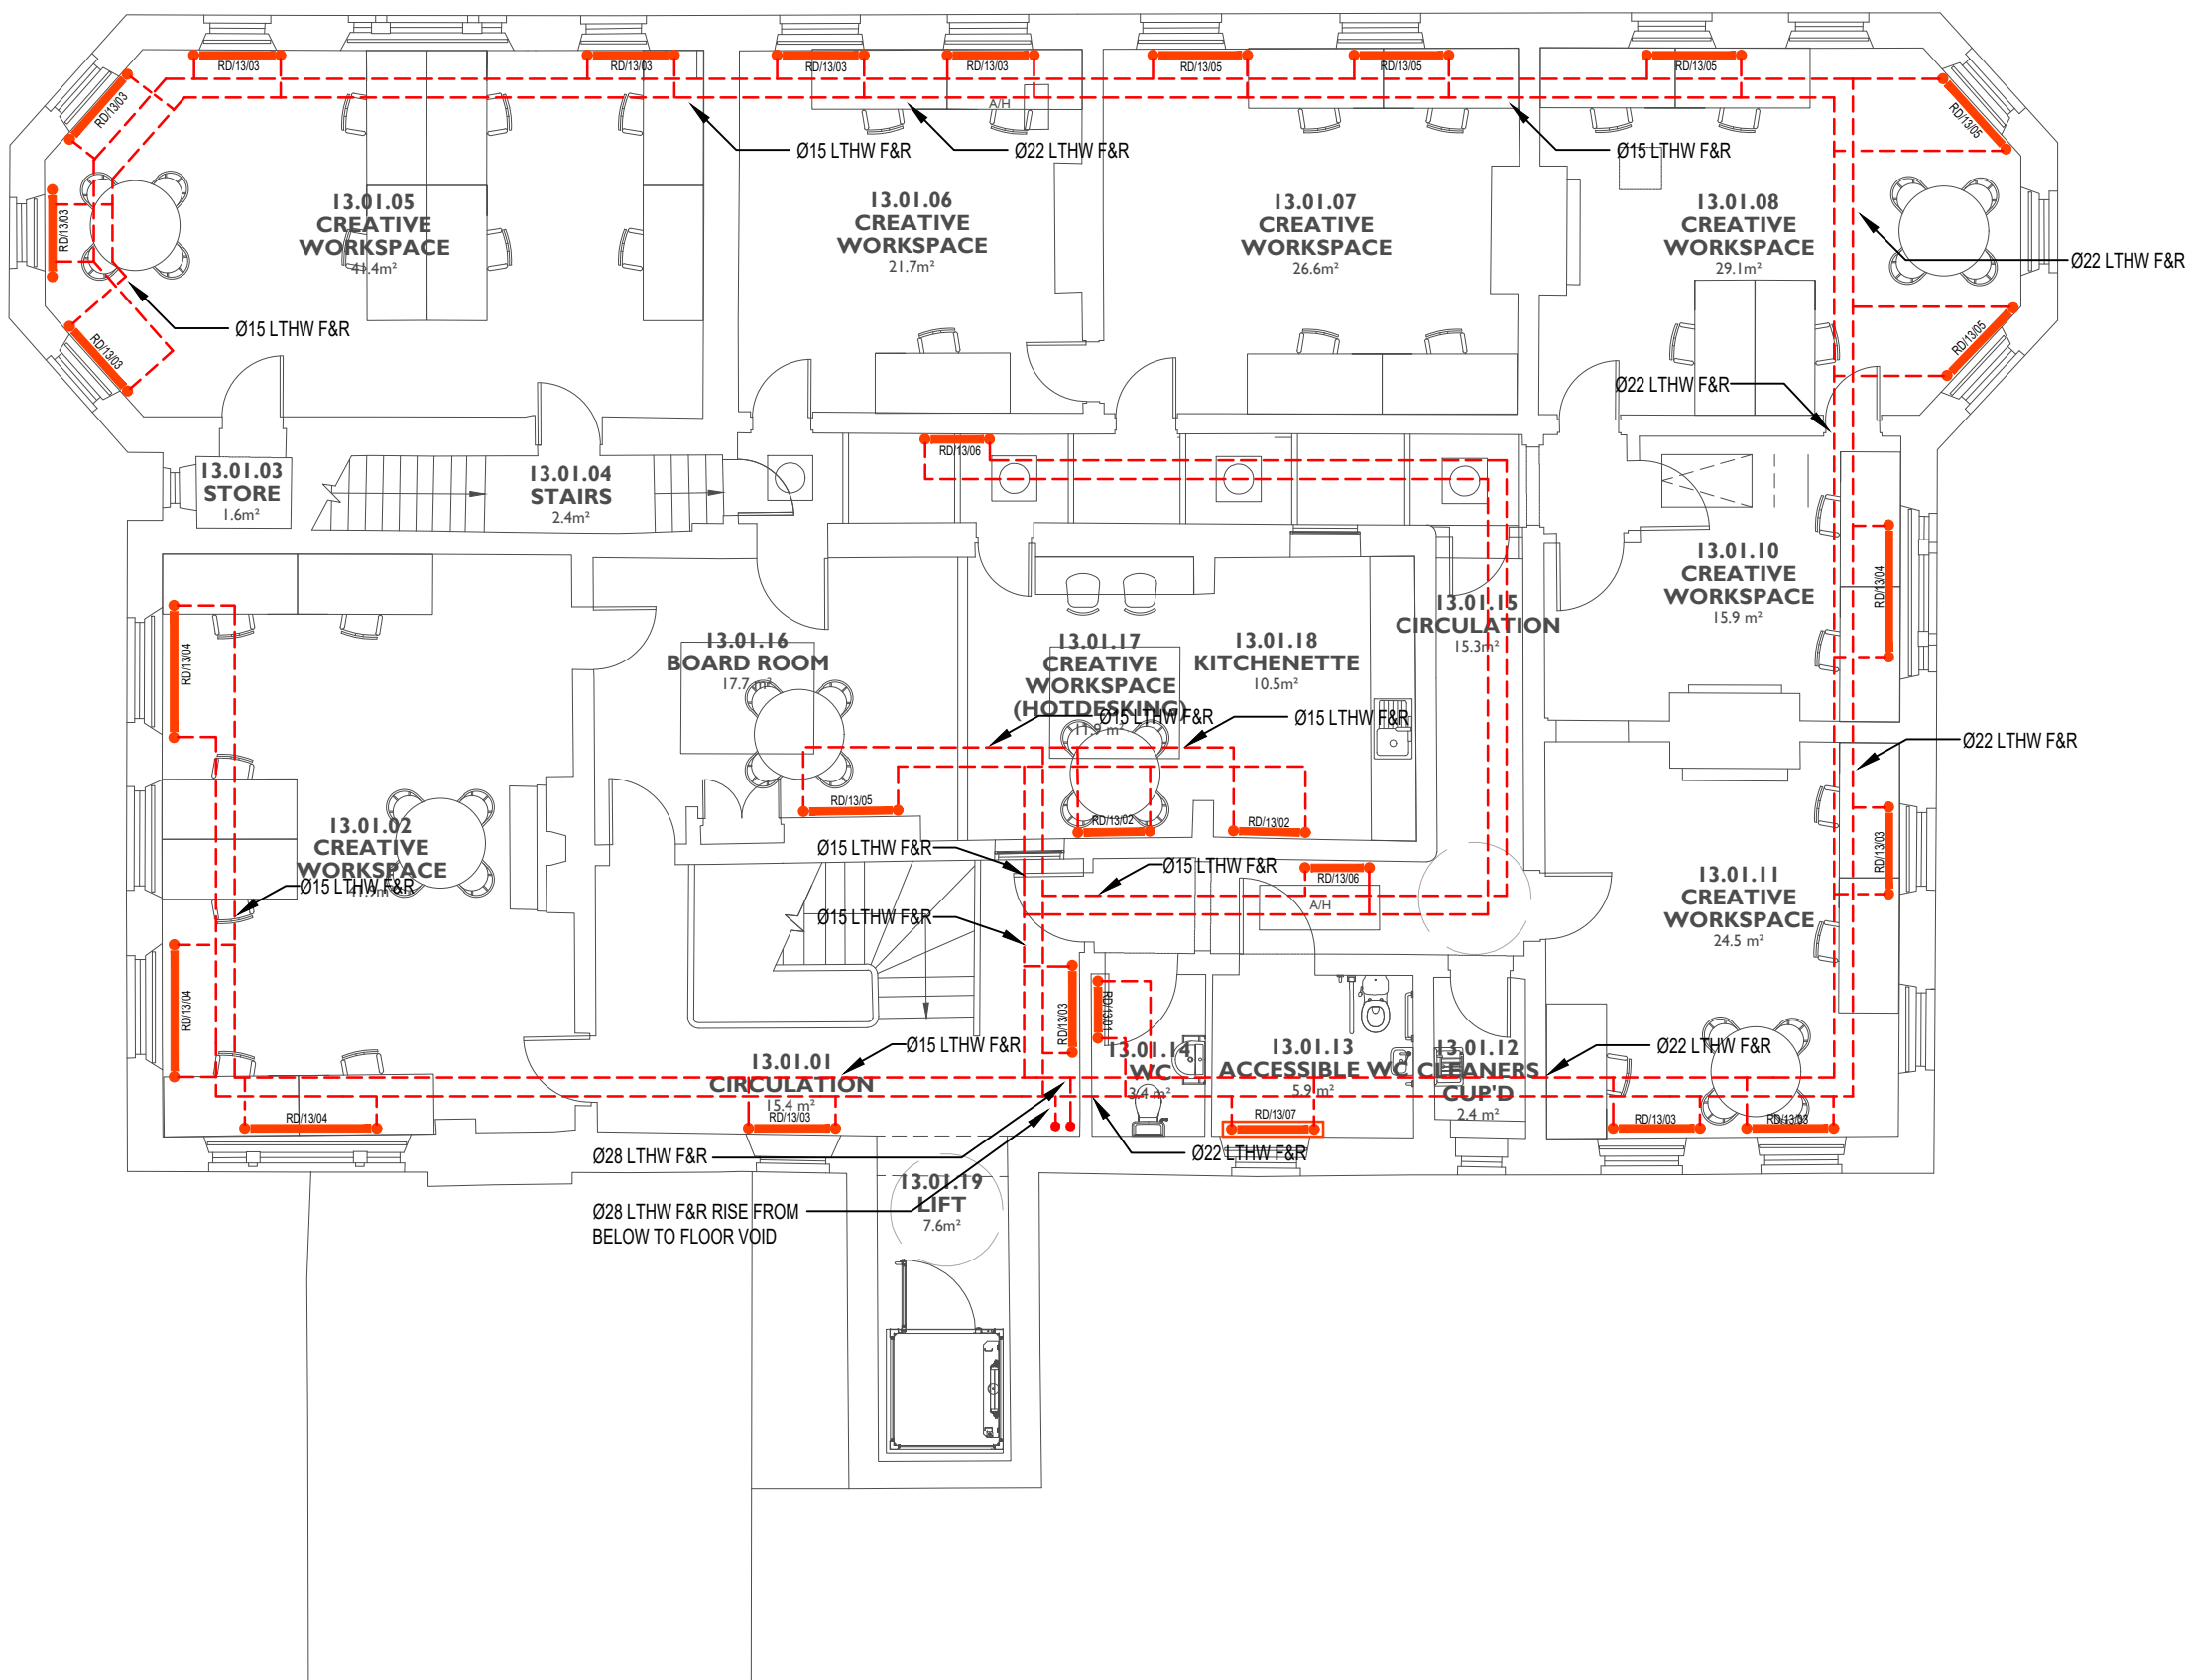

P05	29.09.23	UPDATED PIPE SIZES	BM	RE
P04	22.08.23	SUITABLE FOR TENDER	RC	RE
P03	25.08.23	STAGE 4	MS	RE
P02	02.06.23	UPDATED TO ARCHITECTS COMMENTS AND LAYOUTS	LC	RP
P01	14.04.23	PRELIMINARY ISSUE	BM	RE
REV	DATE	DESCRIPTION	DRAWN	APP



TGA Consulting Engineers LLP,
Salvus House, Aykley Heads, Durham City. DH1 5TS.
E: info@tgace.co.uk T: 0191 3862314

Project
ELSECAR: FORGING AHEAD

Title
MECHANICAL ENGINEERING SERVICES
PROPOSED HEATING LAYOUT
BUILDING 13
FIRST FLOOR

Architect
PURCELL

Client
BARNSELY MBC

Suitability: Code Description
D2 FOR TENDER

Revision:	Scale:	TGA Proj No:	Stage:
P05	1:100	8193	4

Drawing Reference:
Project-Originator-Zone-Level-Type-Role-Classification-Number
EFAS-TGA-13-01-DR-M-56002


Standard construction hazards that a competent contractor would be aware of have not been identified on this drawing. Any risks not immediately apparent are identified within the CDM Residual Risk Register.

LEGEND

- SUPPLY DIFFUSER
- EXTRACT GRILLE
- VOLUME CONTROL DAMPER
- EXTRACT FAN
- HEAT RECOVERY UNIT
- GENERAL SUPPLY
- GENERAL EXTRACT
- FRESH AIR INTAKE
- EXHAUST AIR

NOTES

1. THIS DRAWING SHOWS THE DESIGN PROPOSAL FOR A WORKSTAGE 4 TECHNICAL DESIGN LEVEL OF DETAIL AND COMPLETENESS AS DEFINED BY BSRIA 808:2018. ALL QUANTITIES AND LOCATIONS ARE BASED ON GENERIC EQUIPMENT SELECTIONS AND SHALL BE CONFIRMED AND FULLY COORDINATED AS PART OF THE CONSTRUCTION STAGE DESIGN ACTIVITIES.
2. READ IN CONJUNCTION WITH ALL OTHER RELATED DESIGN INFORMATION INCLUDING BUT NOT LIMITED TO ARCHITECTURAL AND STRUCTURAL INFORMATION.
3. ALL DIMENSIONS ARE IN MILLIMETERS UNLESS NOTATED OTHERWISE.
4. VENTILATION DUCTWORK SHALL BE IN GALVANISED STEEL TO BESA SPECIFICATION DW144.
5. BENDS SHALL BE MEDIUM RADIUS. SQUARE BENDS SHALL INCLUDE TURNING VANES.
6. SQUARE BENDS WITHOUT TURNING VANES SHALL NOT BE USED.
7. GALVANISED STEEL DUCTWORK, PASSING THROUGH FIRE RATED ELEMENTS OF CONSTRUCTION, SHALL INCLUDE SUITABLY RATED FIRE DAMPERS IN ACCORDANCE WITH THE PUBLISHED FIRE STRATEGY.
8. DUCTWORK SHALL BE ADEQUATELY SUPPORTED IN THE RUNNING LENGTH USING PROPRIETARY CLIPS AND BRACKETS.
9. INCLUDE VOLUME CONTROL DAMPERS AND MOTORISED DAMPERS WHERE INDICATED ON THE DRAWINGS.
10. ALL DAMPERS AND OTHER DUCTWORK ACCESSORIES SHALL BE ACCESSIBLE. INCLUDE ADEQUATELY SIZED ACCESS DOORS.
11. THERMAL INSULATION SHALL BE CONTINUOUS IN THE RUNNING LENGTH, CONTINUOUS THROUGH SUPPORTS AND OVER FITTINGS.
12. DUCTLINES SHALL INCLUDE DIRECTION-OF-FLOW AND SERVICE IDENTIFICATION LABELLING.

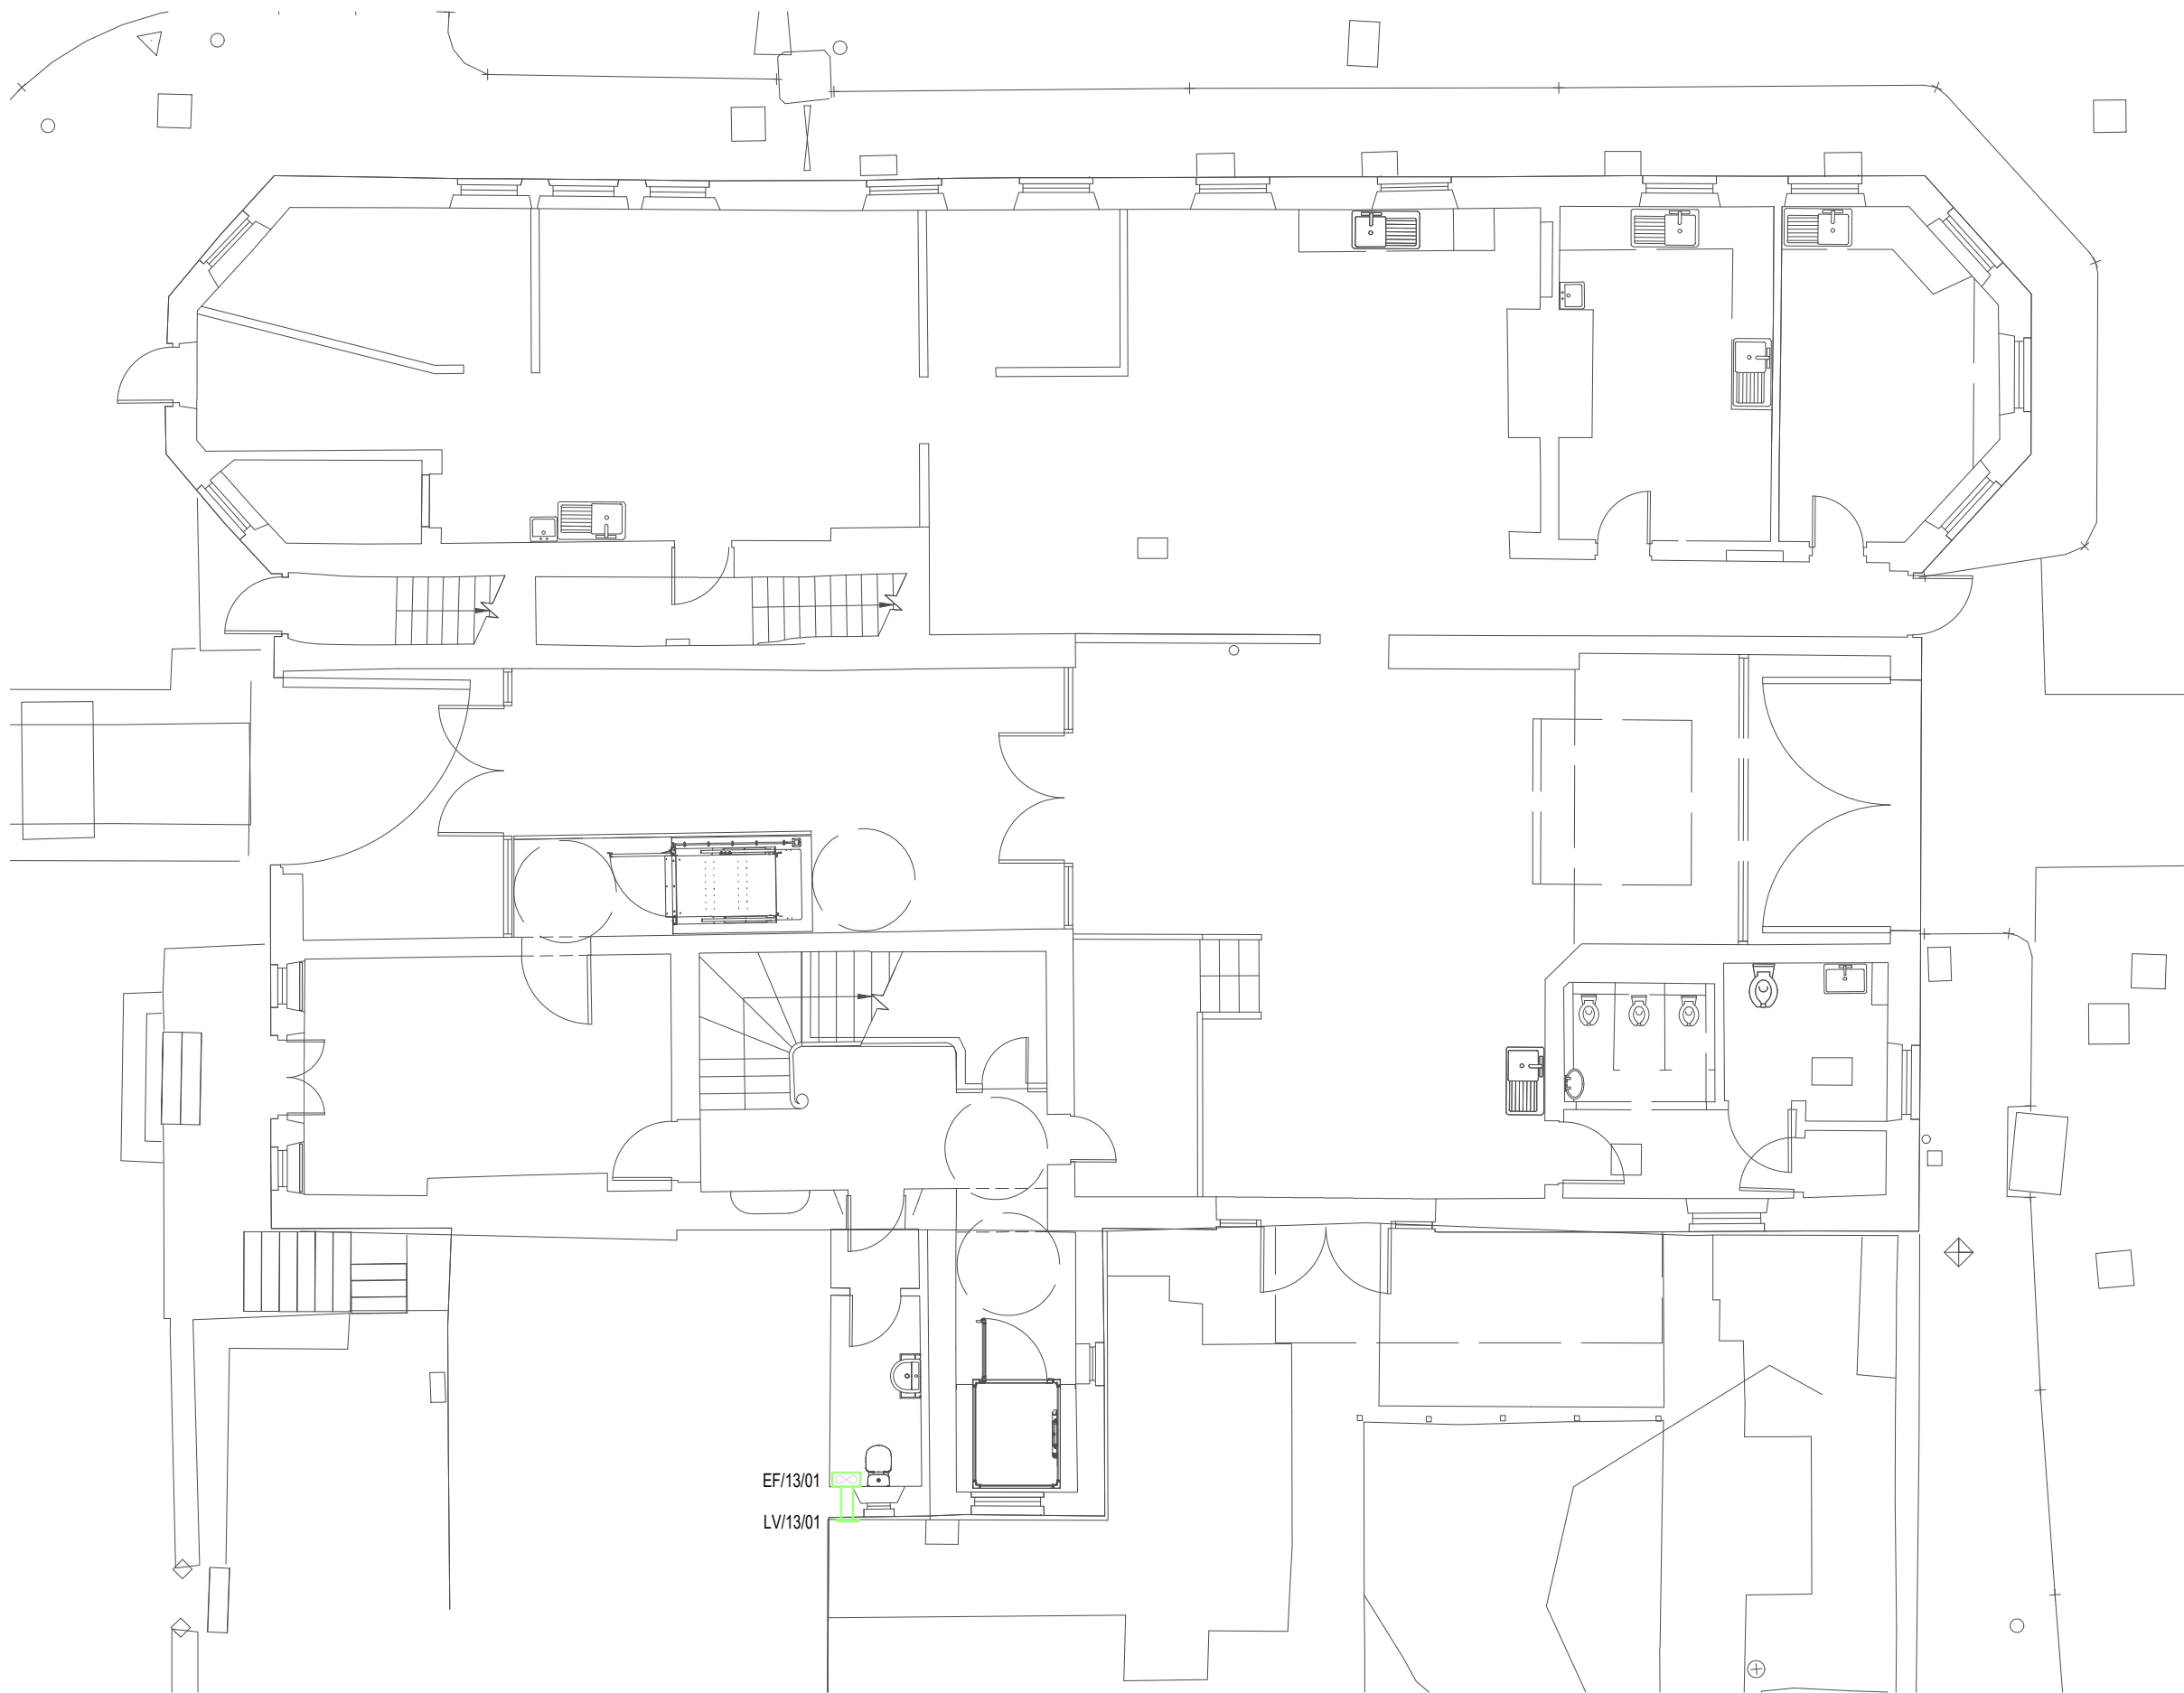

P02	22.09.23	SUITABLE FOR TENDER	RC	RE
P01	25.08.23	STAGE 4	MS	RE
REV	DATE	DESCRIPTION	DRAWN	APP



TGA Consulting Engineers LLP,
Salvus House, Aykley Heads, Durham City. DH1 5TS.
E: info@tgace.co.uk T: 0191 3862314

Project
ELSECAR: FORGING AHEAD

Title
MECHANICAL ENGINEERING SERVICES
PROPOSED VENTILATION LAYOUT
BUILDING 13
GROUND FLOOR

Architect
PURCELL

Client
BARNESLEY MBC

Suitability: Code Description
D2 FOR TENDER

Revision: P02	Scale: 1:100	TGA Proj No: 8193	Stage: 4
------------------	-----------------	----------------------	-------------

Drawing Reference:
Project-Originator-Zone-Level-Type-Role-Classification-Number
EFAS-TGA-13-00-DR-M-57001


Standard construction hazards that a competent contractor would be aware of have not been identified on this drawing. Any risks not immediately apparent are identified within the CDM Residual Risk Register.

LEGEND

- SUPPLY DIFFUSER
- EXTRACT GRILLE
- VOLUME CONTROL DAMPER
- EXTRACT FAN
- HEAT RECOVERY UNIT
- GENERAL SUPPLY
- GENERAL EXTRACT
- FRESH AIR INTAKE
- EXHAUST AIR

NOTES

- THIS DRAWING SHOWS THE DESIGN PROPOSAL FOR A WORKSTAGE 4 TECHNICAL DESIGN LEVEL OF DETAIL AND COMPLETENESS AS DEFINED BY BSRIA B06:2018. ALL QUANTITIES AND LOCATIONS ARE BASED ON GENERIC EQUIPMENT SELECTIONS AND SHALL BE CONFIRMED AND FULLY COORDINATED AS PART OF THE CONSTRUCTION STAGE DESIGN ACTIVITIES.
- READ IN CONJUNCTION WITH ALL OTHER RELATED DESIGN INFORMATION INCLUDING BUT NOT LIMITED TO ARCHITECTURAL AND STRUCTURAL INFORMATION.
- ALL DIMENSIONS ARE IN MILLIMETERS UNLESS NOTATED OTHERWISE.
- VENTILATION DUCTWORK SHALL BE IN GALVANISED STEEL TO BESA SPECIFICATION DW144.
- BENDS SHALL BE MEDIUM RADIUS. SQUARE BENDS SHALL INCLUDE TURNING VANES.
- SQUARE BENDS WITHOUT TURNING VANES SHALL NOT BE USED.
- GALVANISED STEEL DUCTWORK, PASSING THROUGH FIRE RATED ELEMENTS OF CONSTRUCTION, SHALL INCLUDE SUITABLY RATED FIRE DAMPERS IN ACCORDANCE WITH THE PUBLISHED FIRE STRATEGY..
- DUCTWORK WORK SHALL BE ADEQUATELY SUPPORTED IN THE RUNNING LENGTH USING PROPRIETARY CLIPS AND BRACKETS.
- INCLUDE VOLUME CONTROL DAMPERS AND MOTORISED DAMPERS WHERE INDICATED ON THE DRAWINGS.
- ALL DAMPERS AND OTHER DUCTWORK ACCESSORIES SHALL BE ACCESSIBLE. INCLUDE ADEQUATELY SIZED ACCESS DOORS.
- THERMAL INSULATION SHALL BE CONTINUOUS IN THE RUNNING LENGTH, CONTINUOUS THROUGH SUPPORTS AND OVER FITTINGS.
- DUCTLINES SHALL INCLUDE DIRECTION-OF-FLOW AND SERVICE IDENTIFICATION LABELLING.

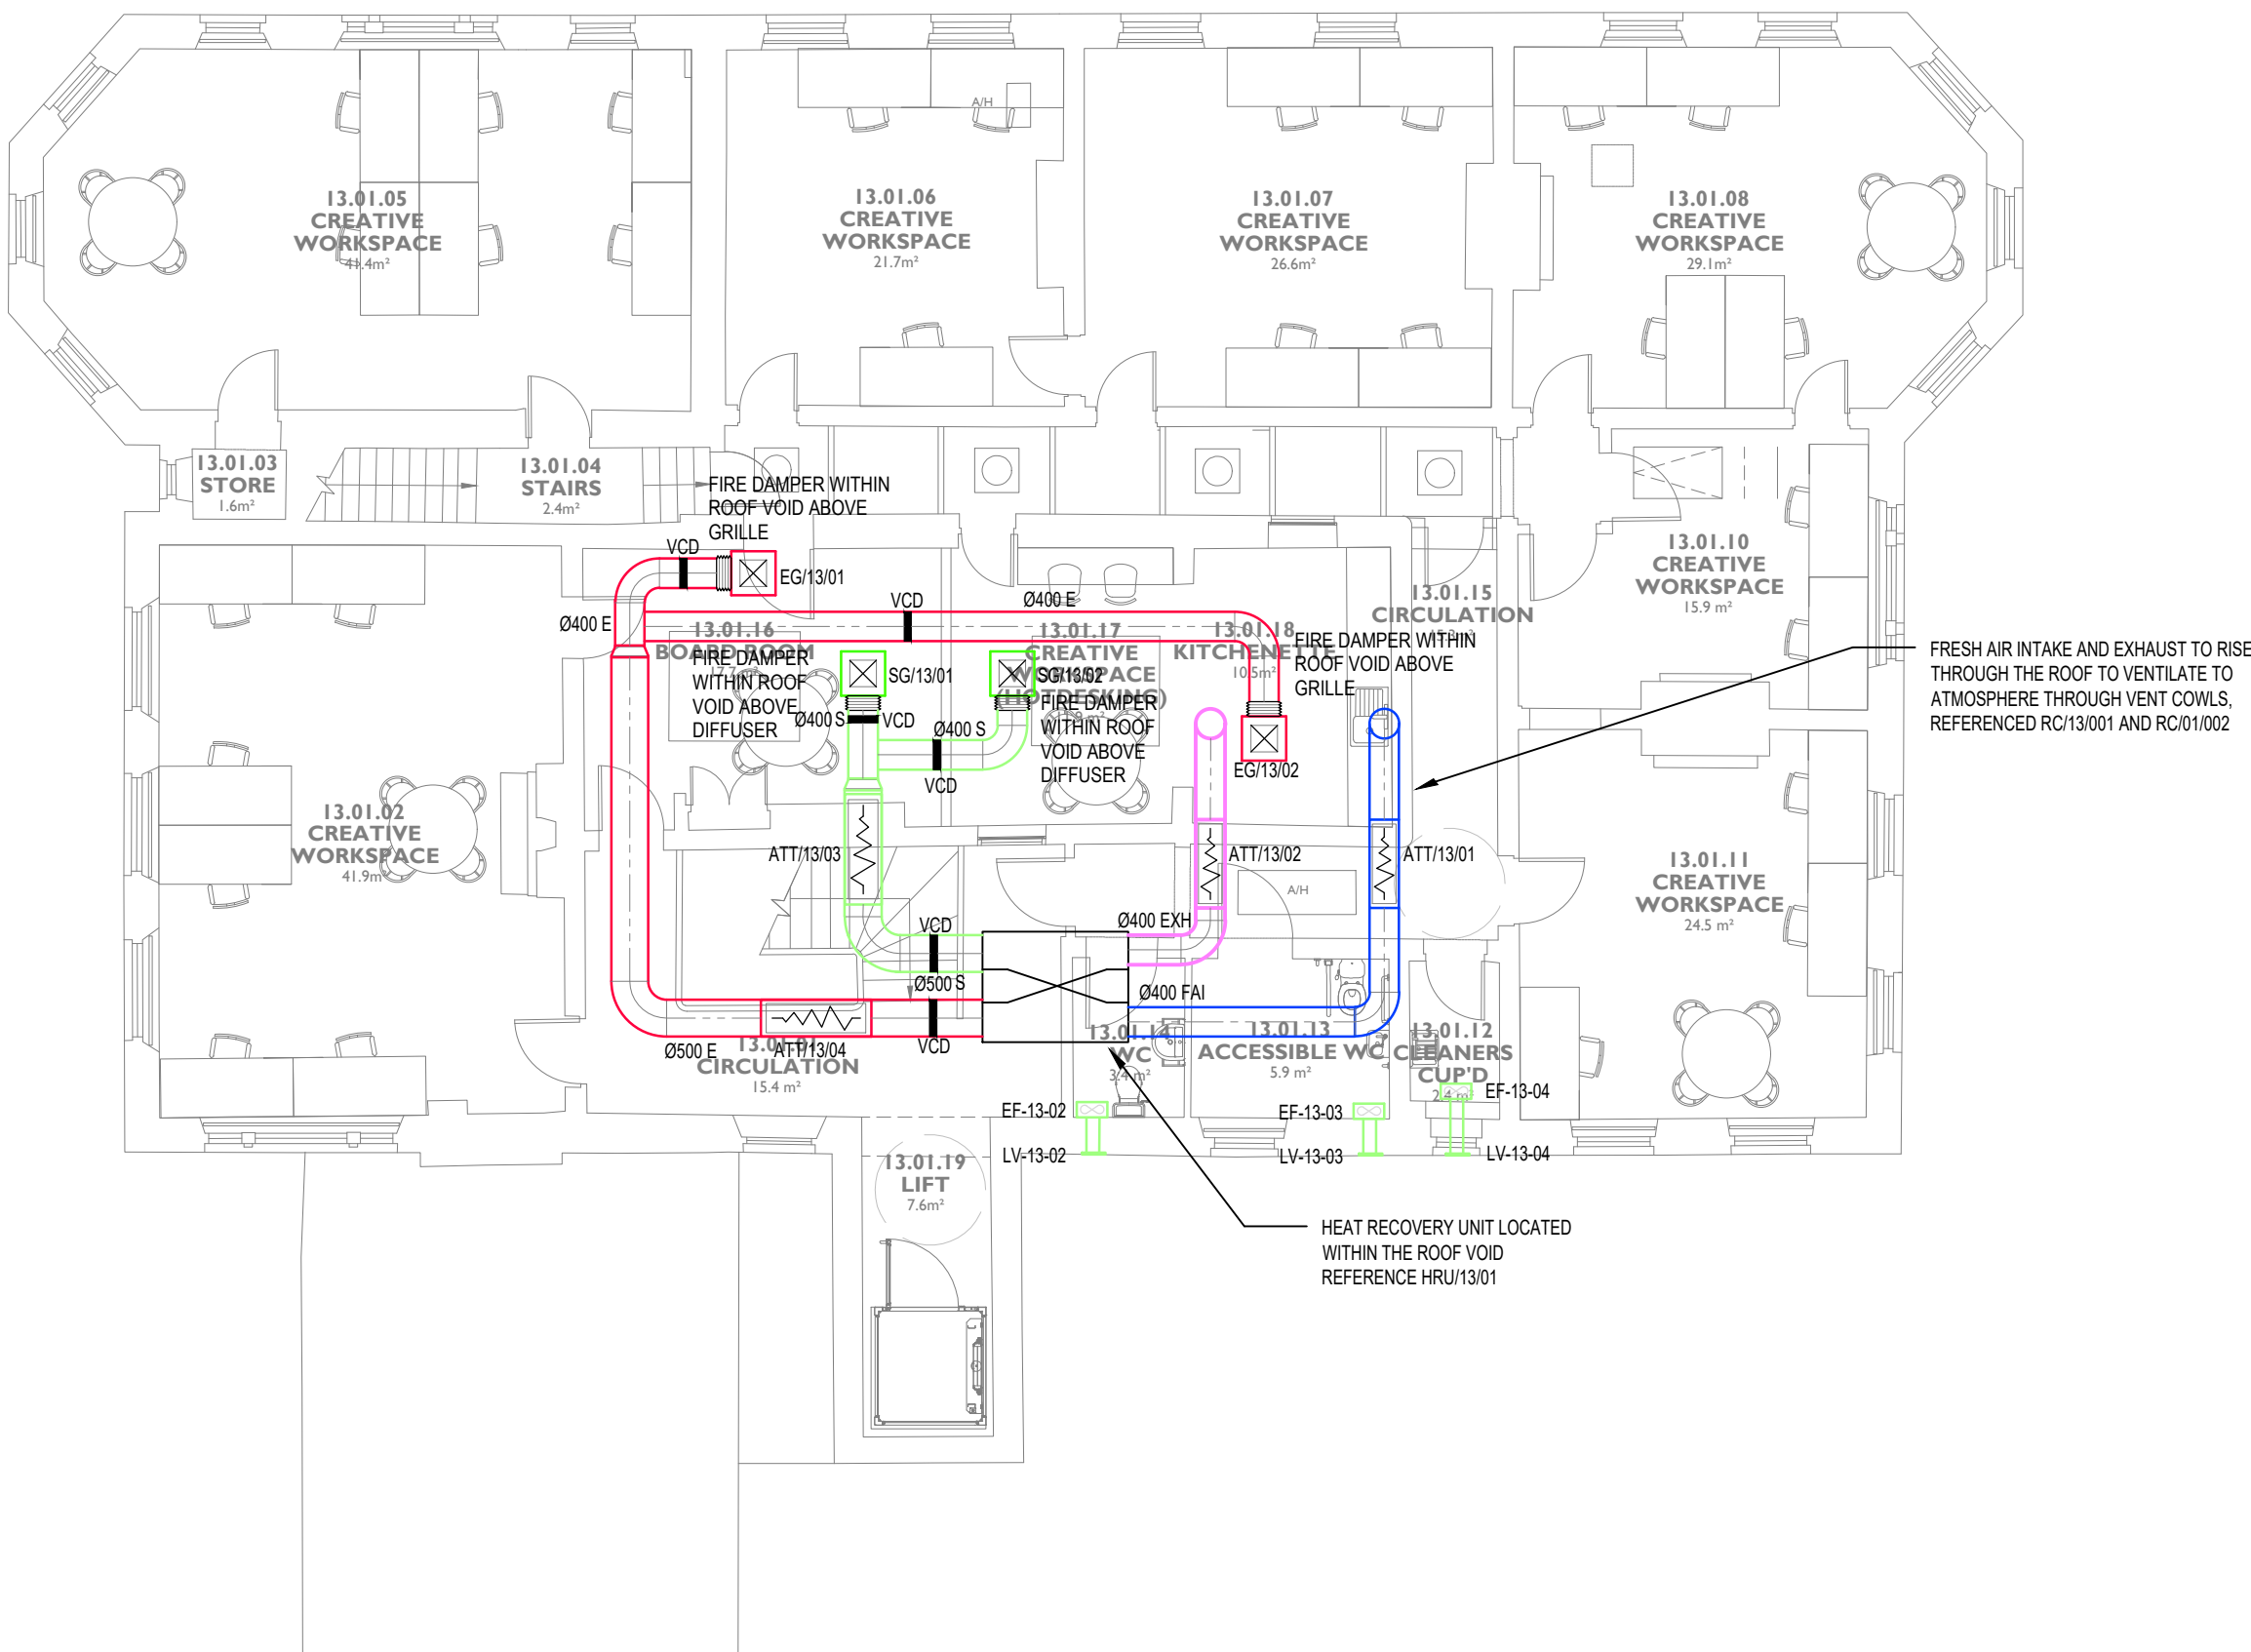

P02	22.08.23	SUITABLE FOR TENDER	RC	RE
P01	25.08.23	STAGE 4	MS	RE
REV	DATE	DESCRIPTION	DRAWN	APP



TGA Consulting Engineers LLP,
Salvus House, Aykley Heads, Durham City. DH1 5TS.
E: info@tgace.co.uk T: 0191 3862314

Project
ELSECAR: FORGING AHEAD

Title
MECHANICAL ENGINEERING SERVICES
PROPOSED VENTILATION LAYOUT
BUILDING 13
FIRST FLOOR

Architect
PURCELL

Client
BARNESLEY MBC

Suitability: Code Description
D2 FOR TENDER

Revision:	Scale:	TGA Proj No:	Stage:
P02	1:100	8193	4

Drawing Reference:
Project-Originator-Zone-Level-Type-Role-Classification-Number
EFAS-TGA-13-01-DR-M-57001