




N.

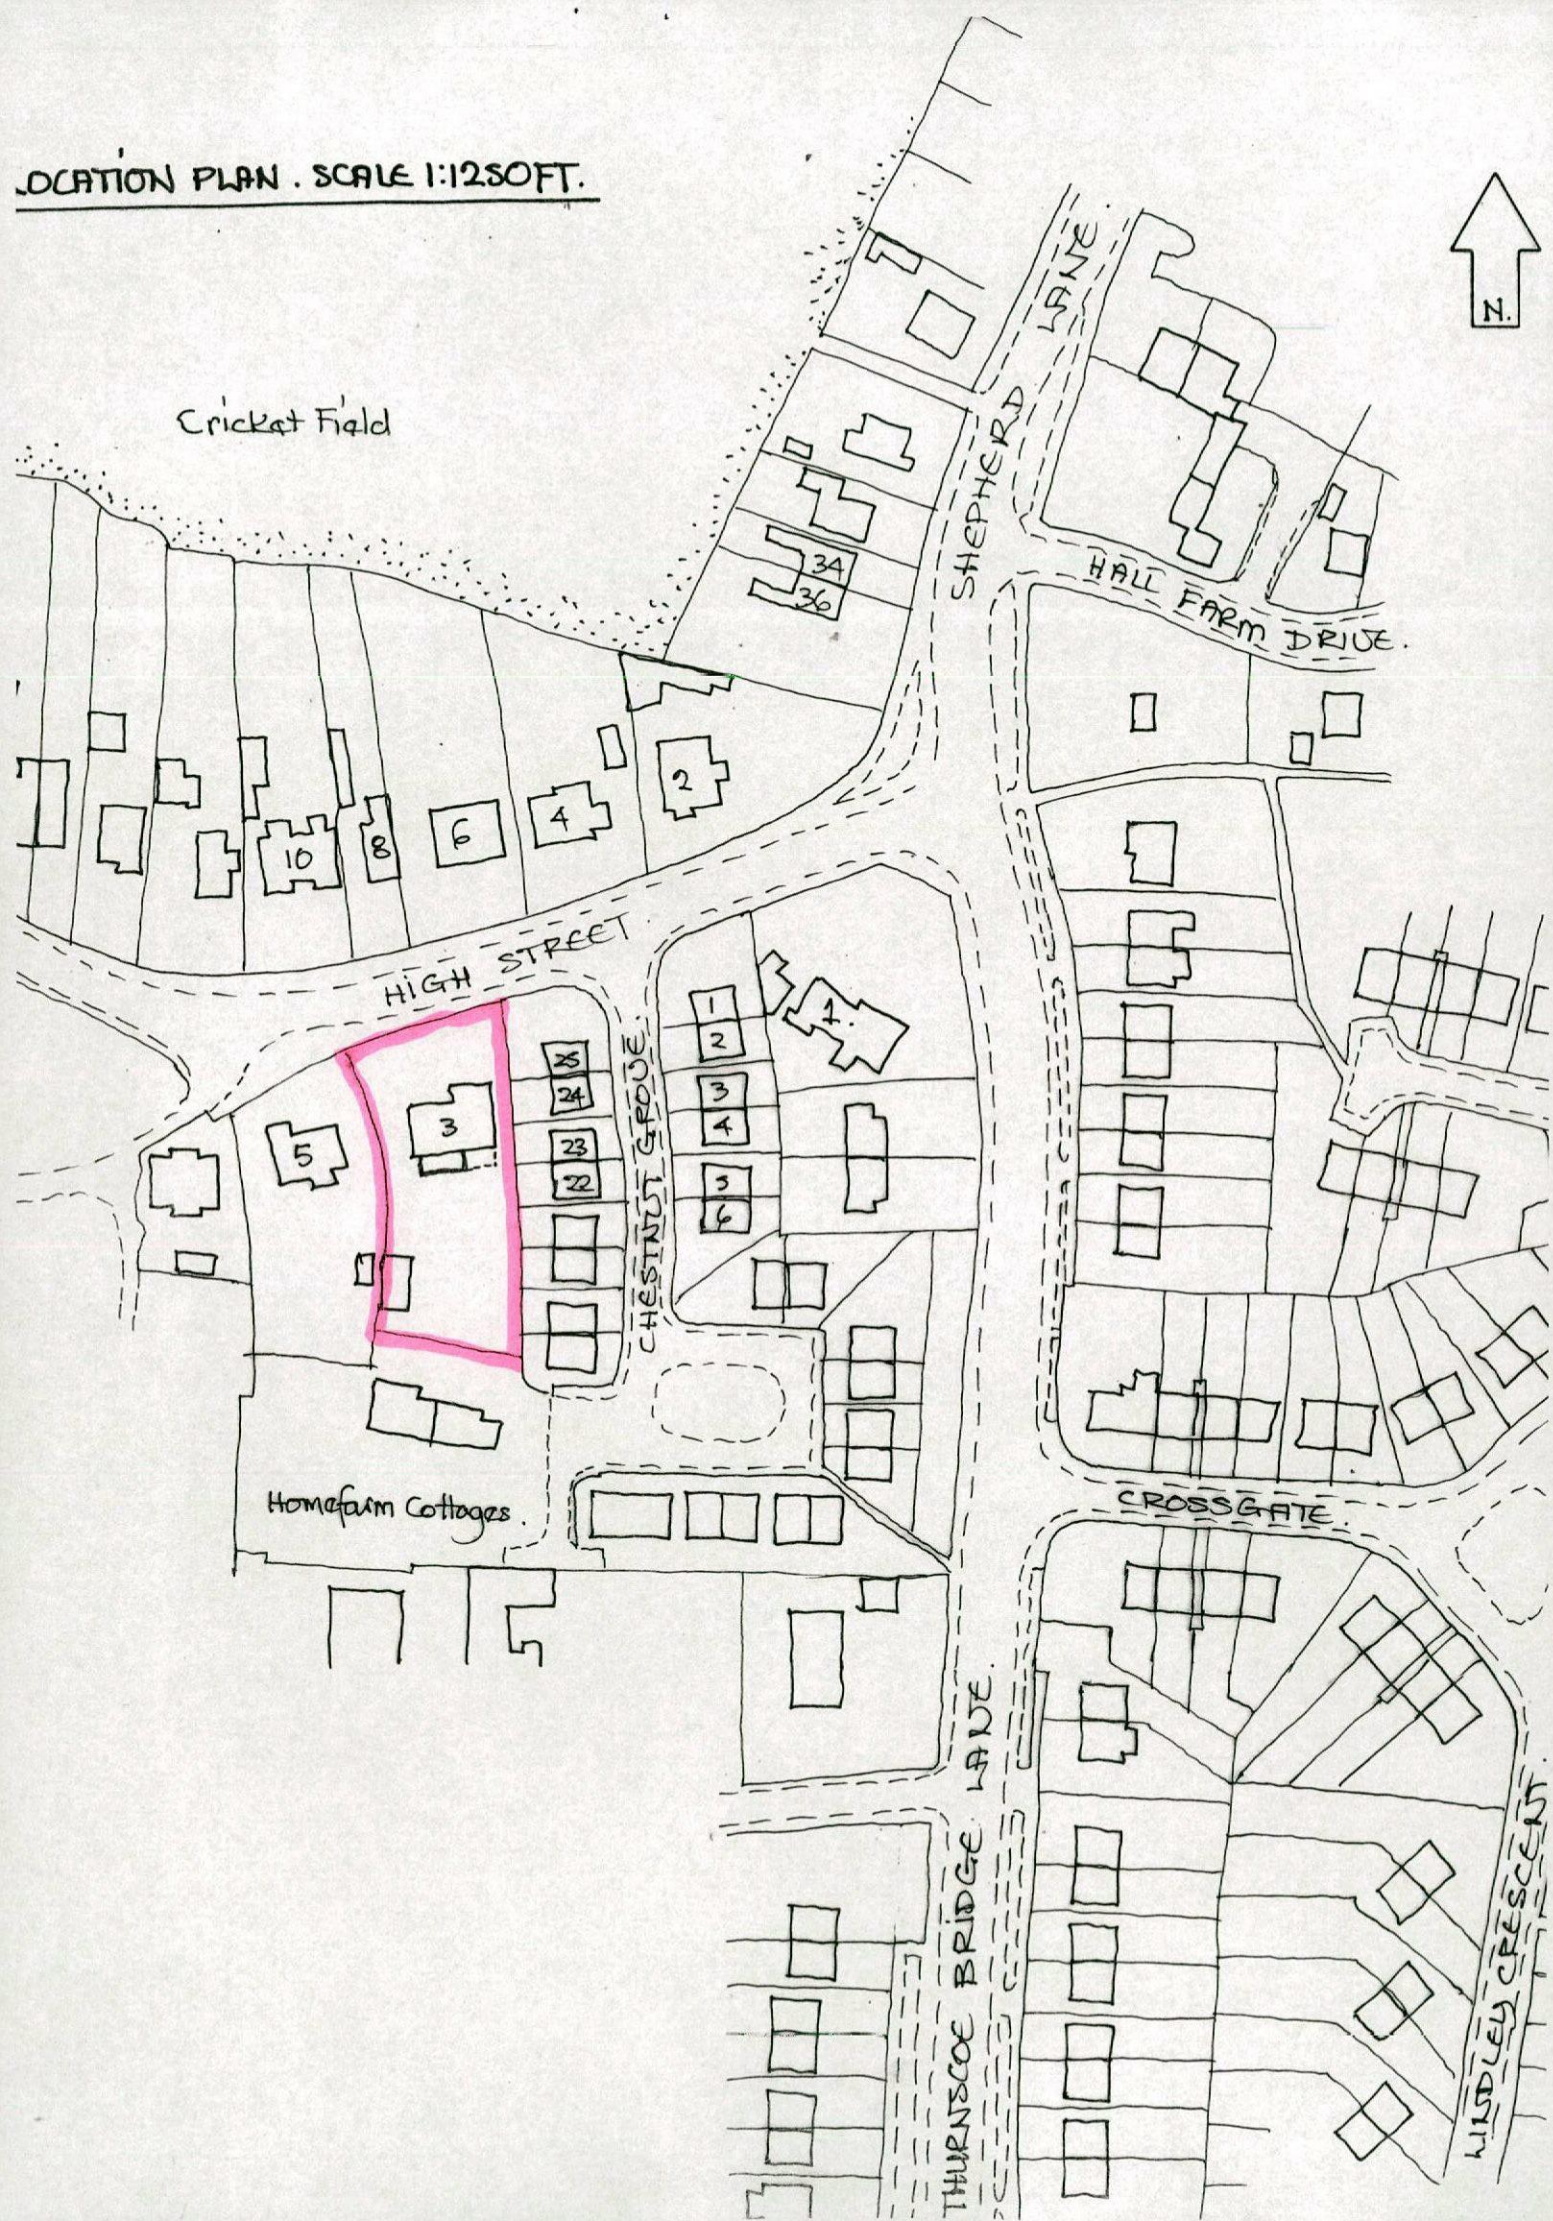



SITE PLAN @ 1:500M.

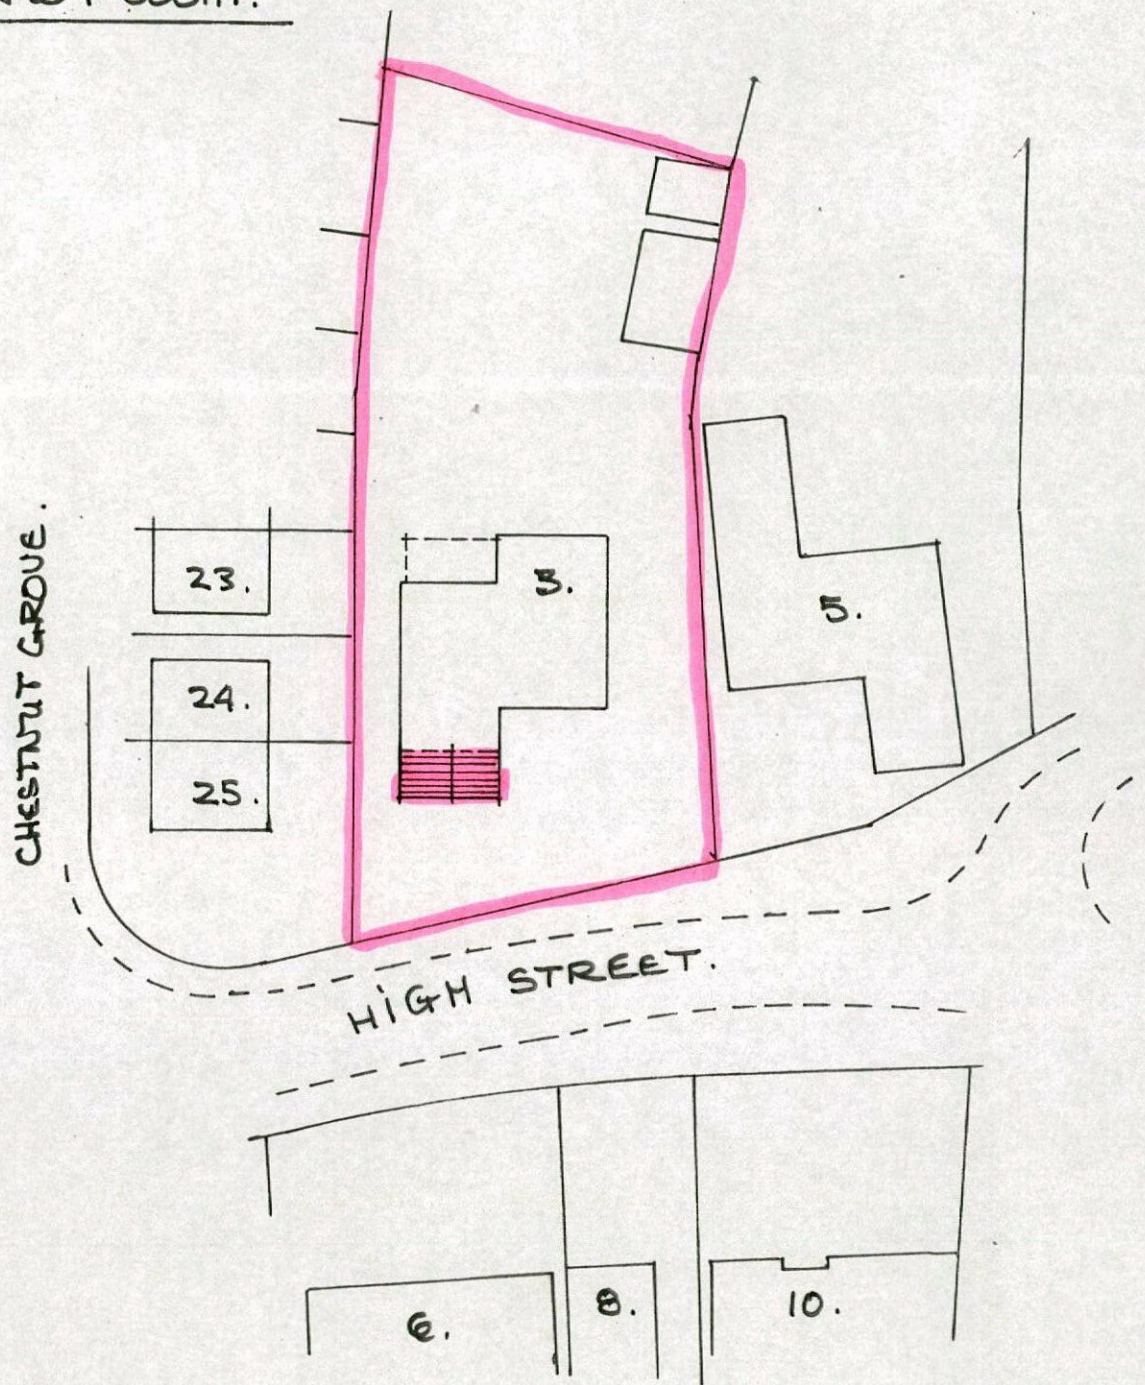

EXISTING GROUND FLOOR LAYOUT (PART).

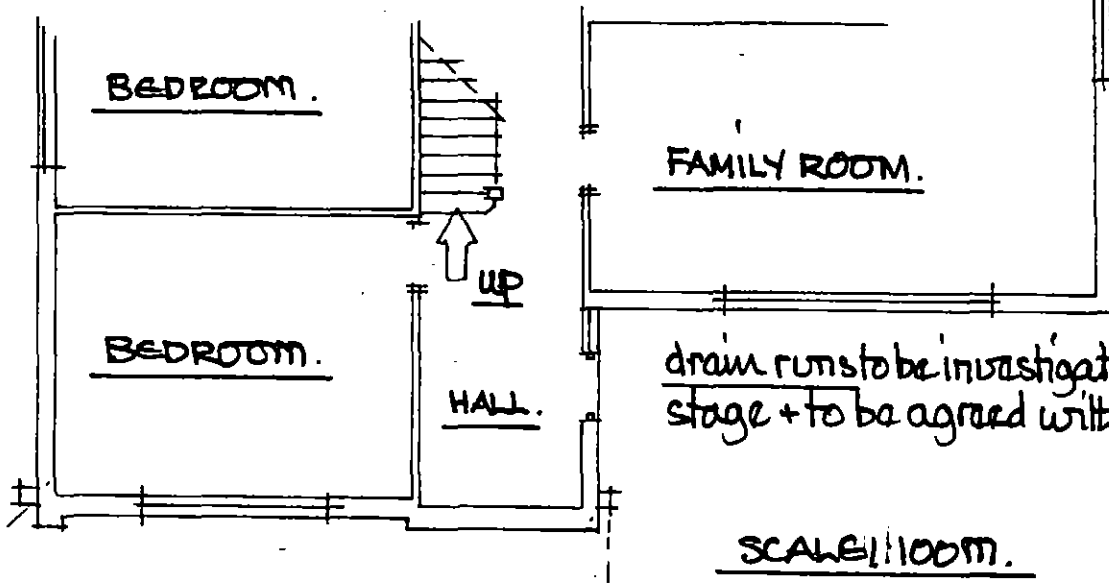


EXISTING SIDE VIEW (FROM NO 5).

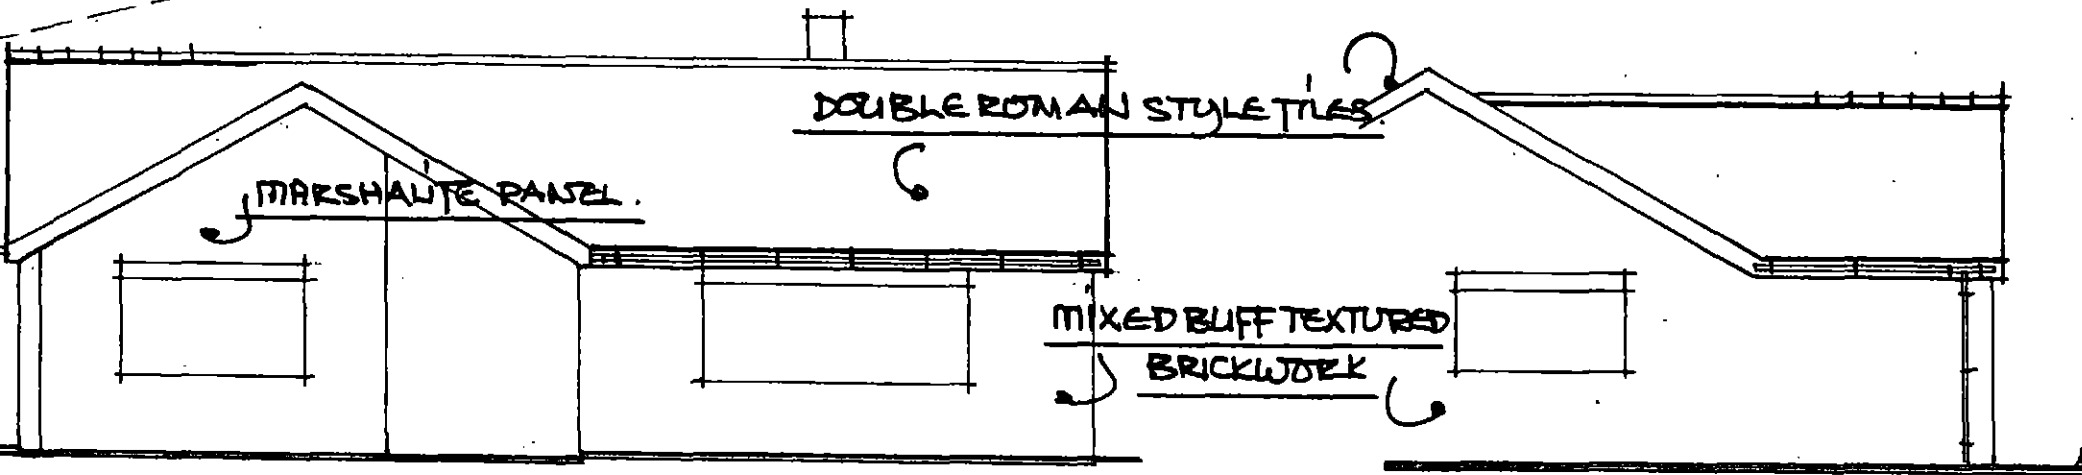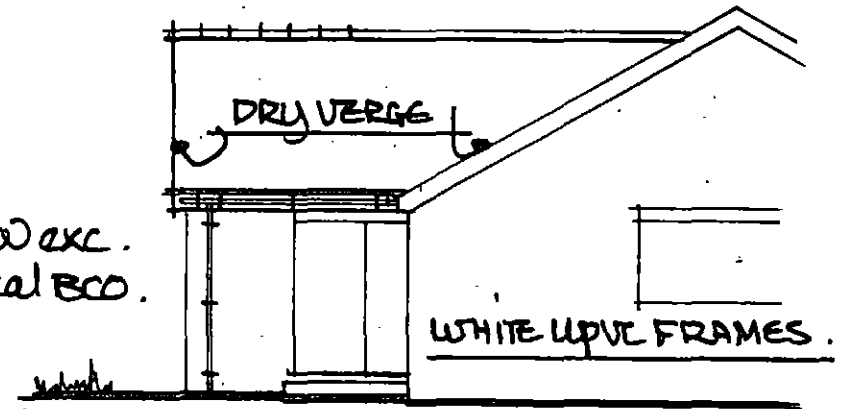

EXISTING FRONT VIEW (FROM HIGH STREET).

EXISTING SIDE VIEW (FROM NOS 24+25).

PROPOSED GROUND FLOOR LAYOUT.

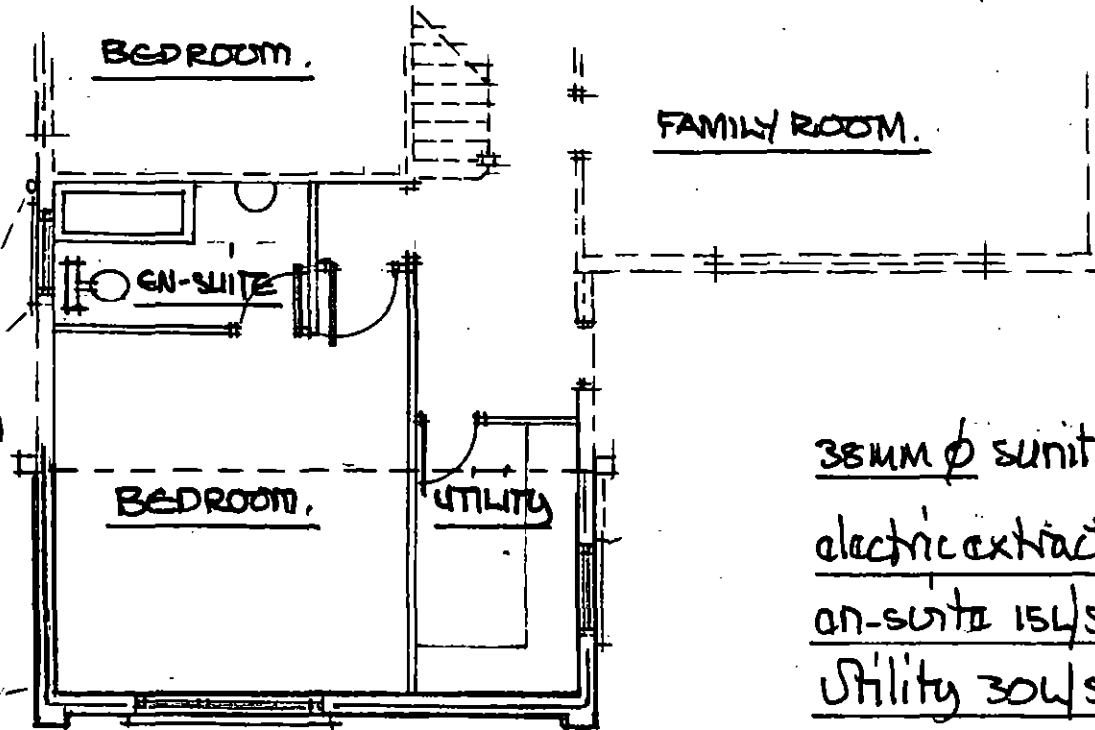

100 ϕ cw drains laid
 @ 1:40 bed + surround
 in granular bedding
 to new i/c - prefabricated
 fixed on concrete
 base.




100 ϕ pvc sup-cage
 terminal 900 above
 d/l.

38 ϕ batt waste

32 ϕ whb "

anti vac traps.

38mm ϕ sunit waste - anti vac trap.
 electric extract - wired to fuse bd -
 on-suite 15L/sec
 Utility 30L/sec
 ducted to external air.

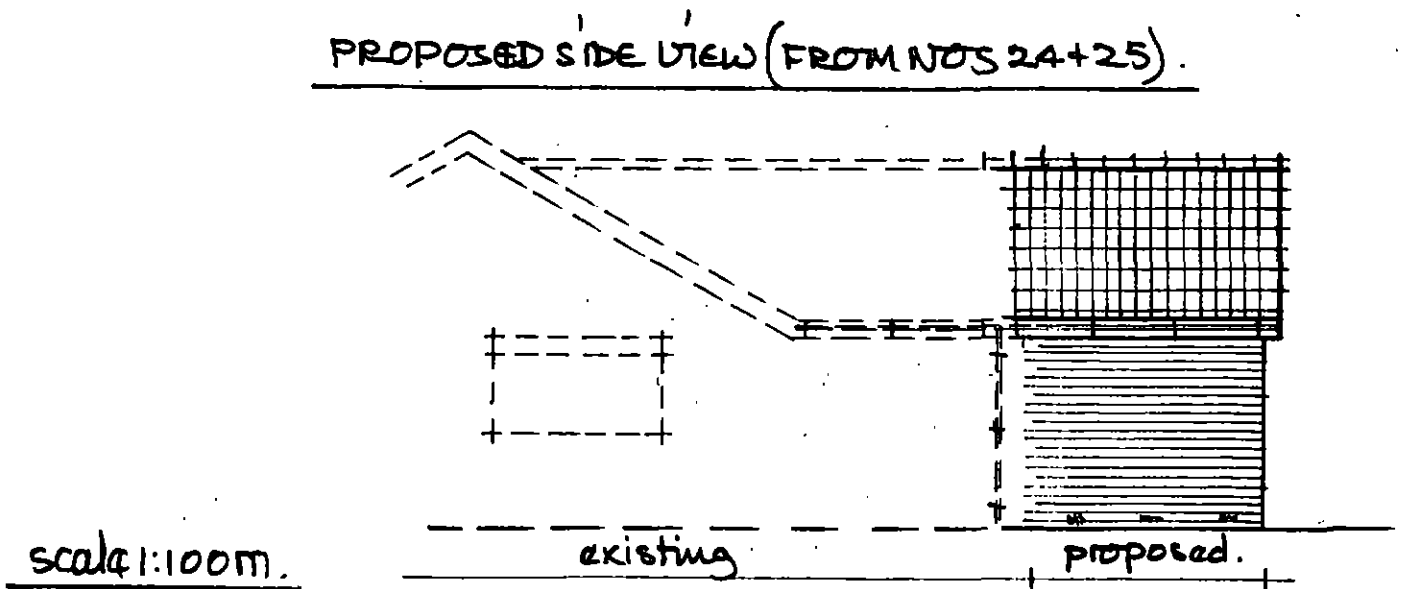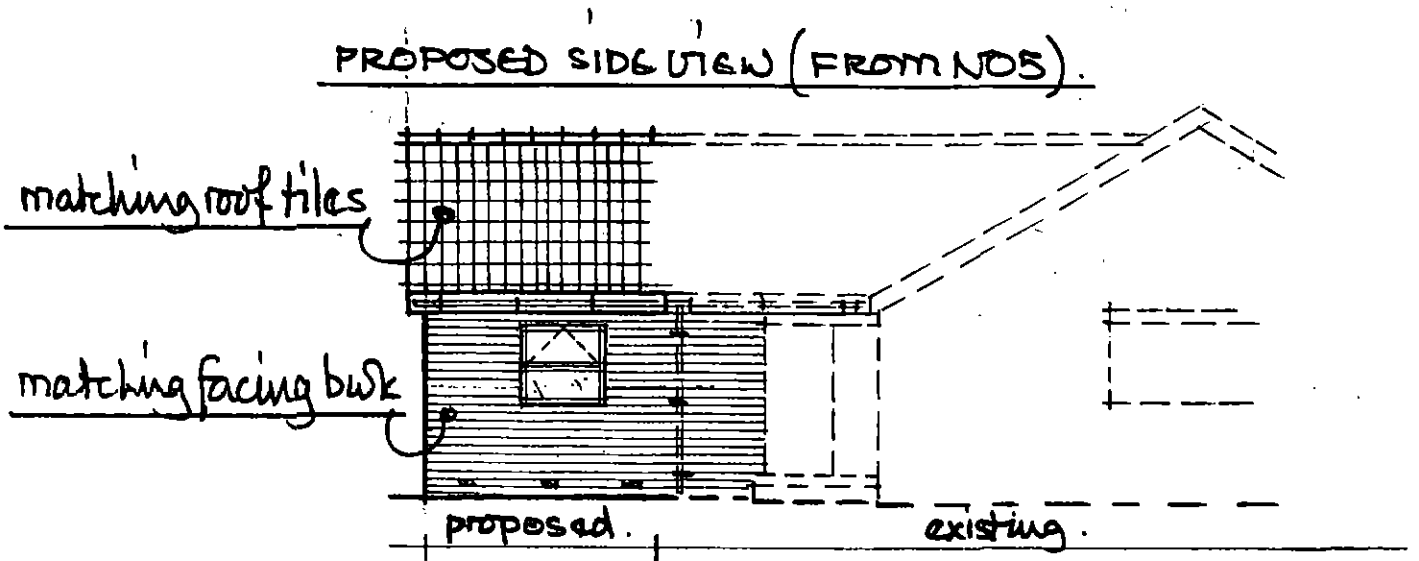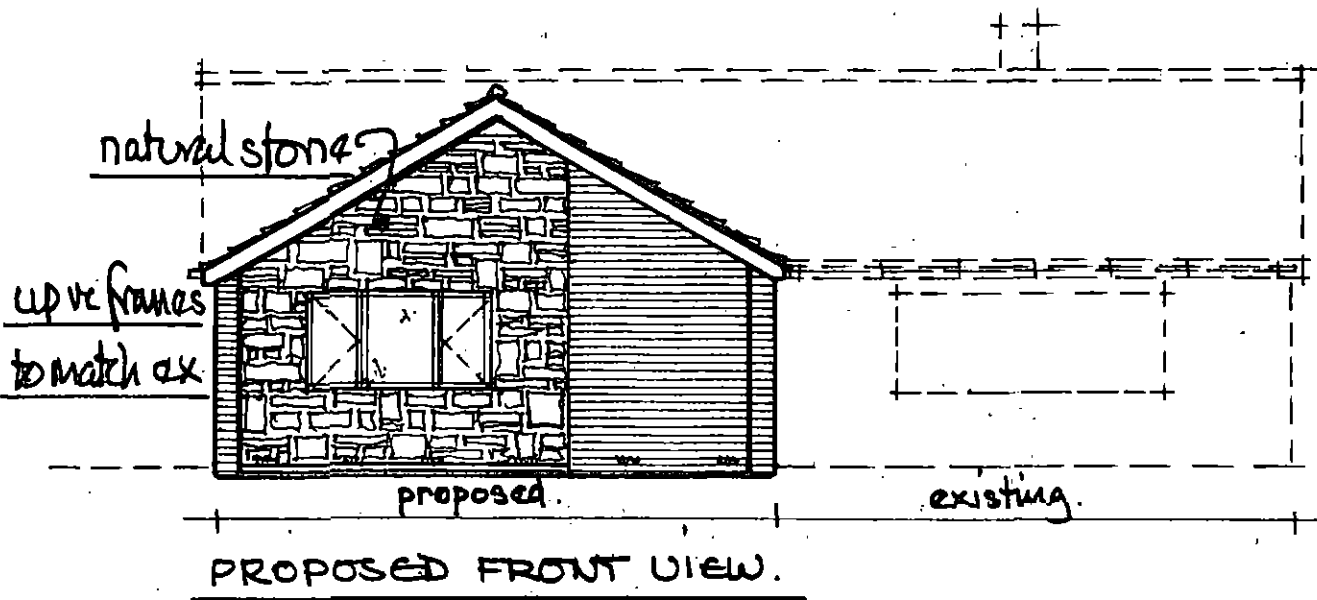

scale 1:100m.