



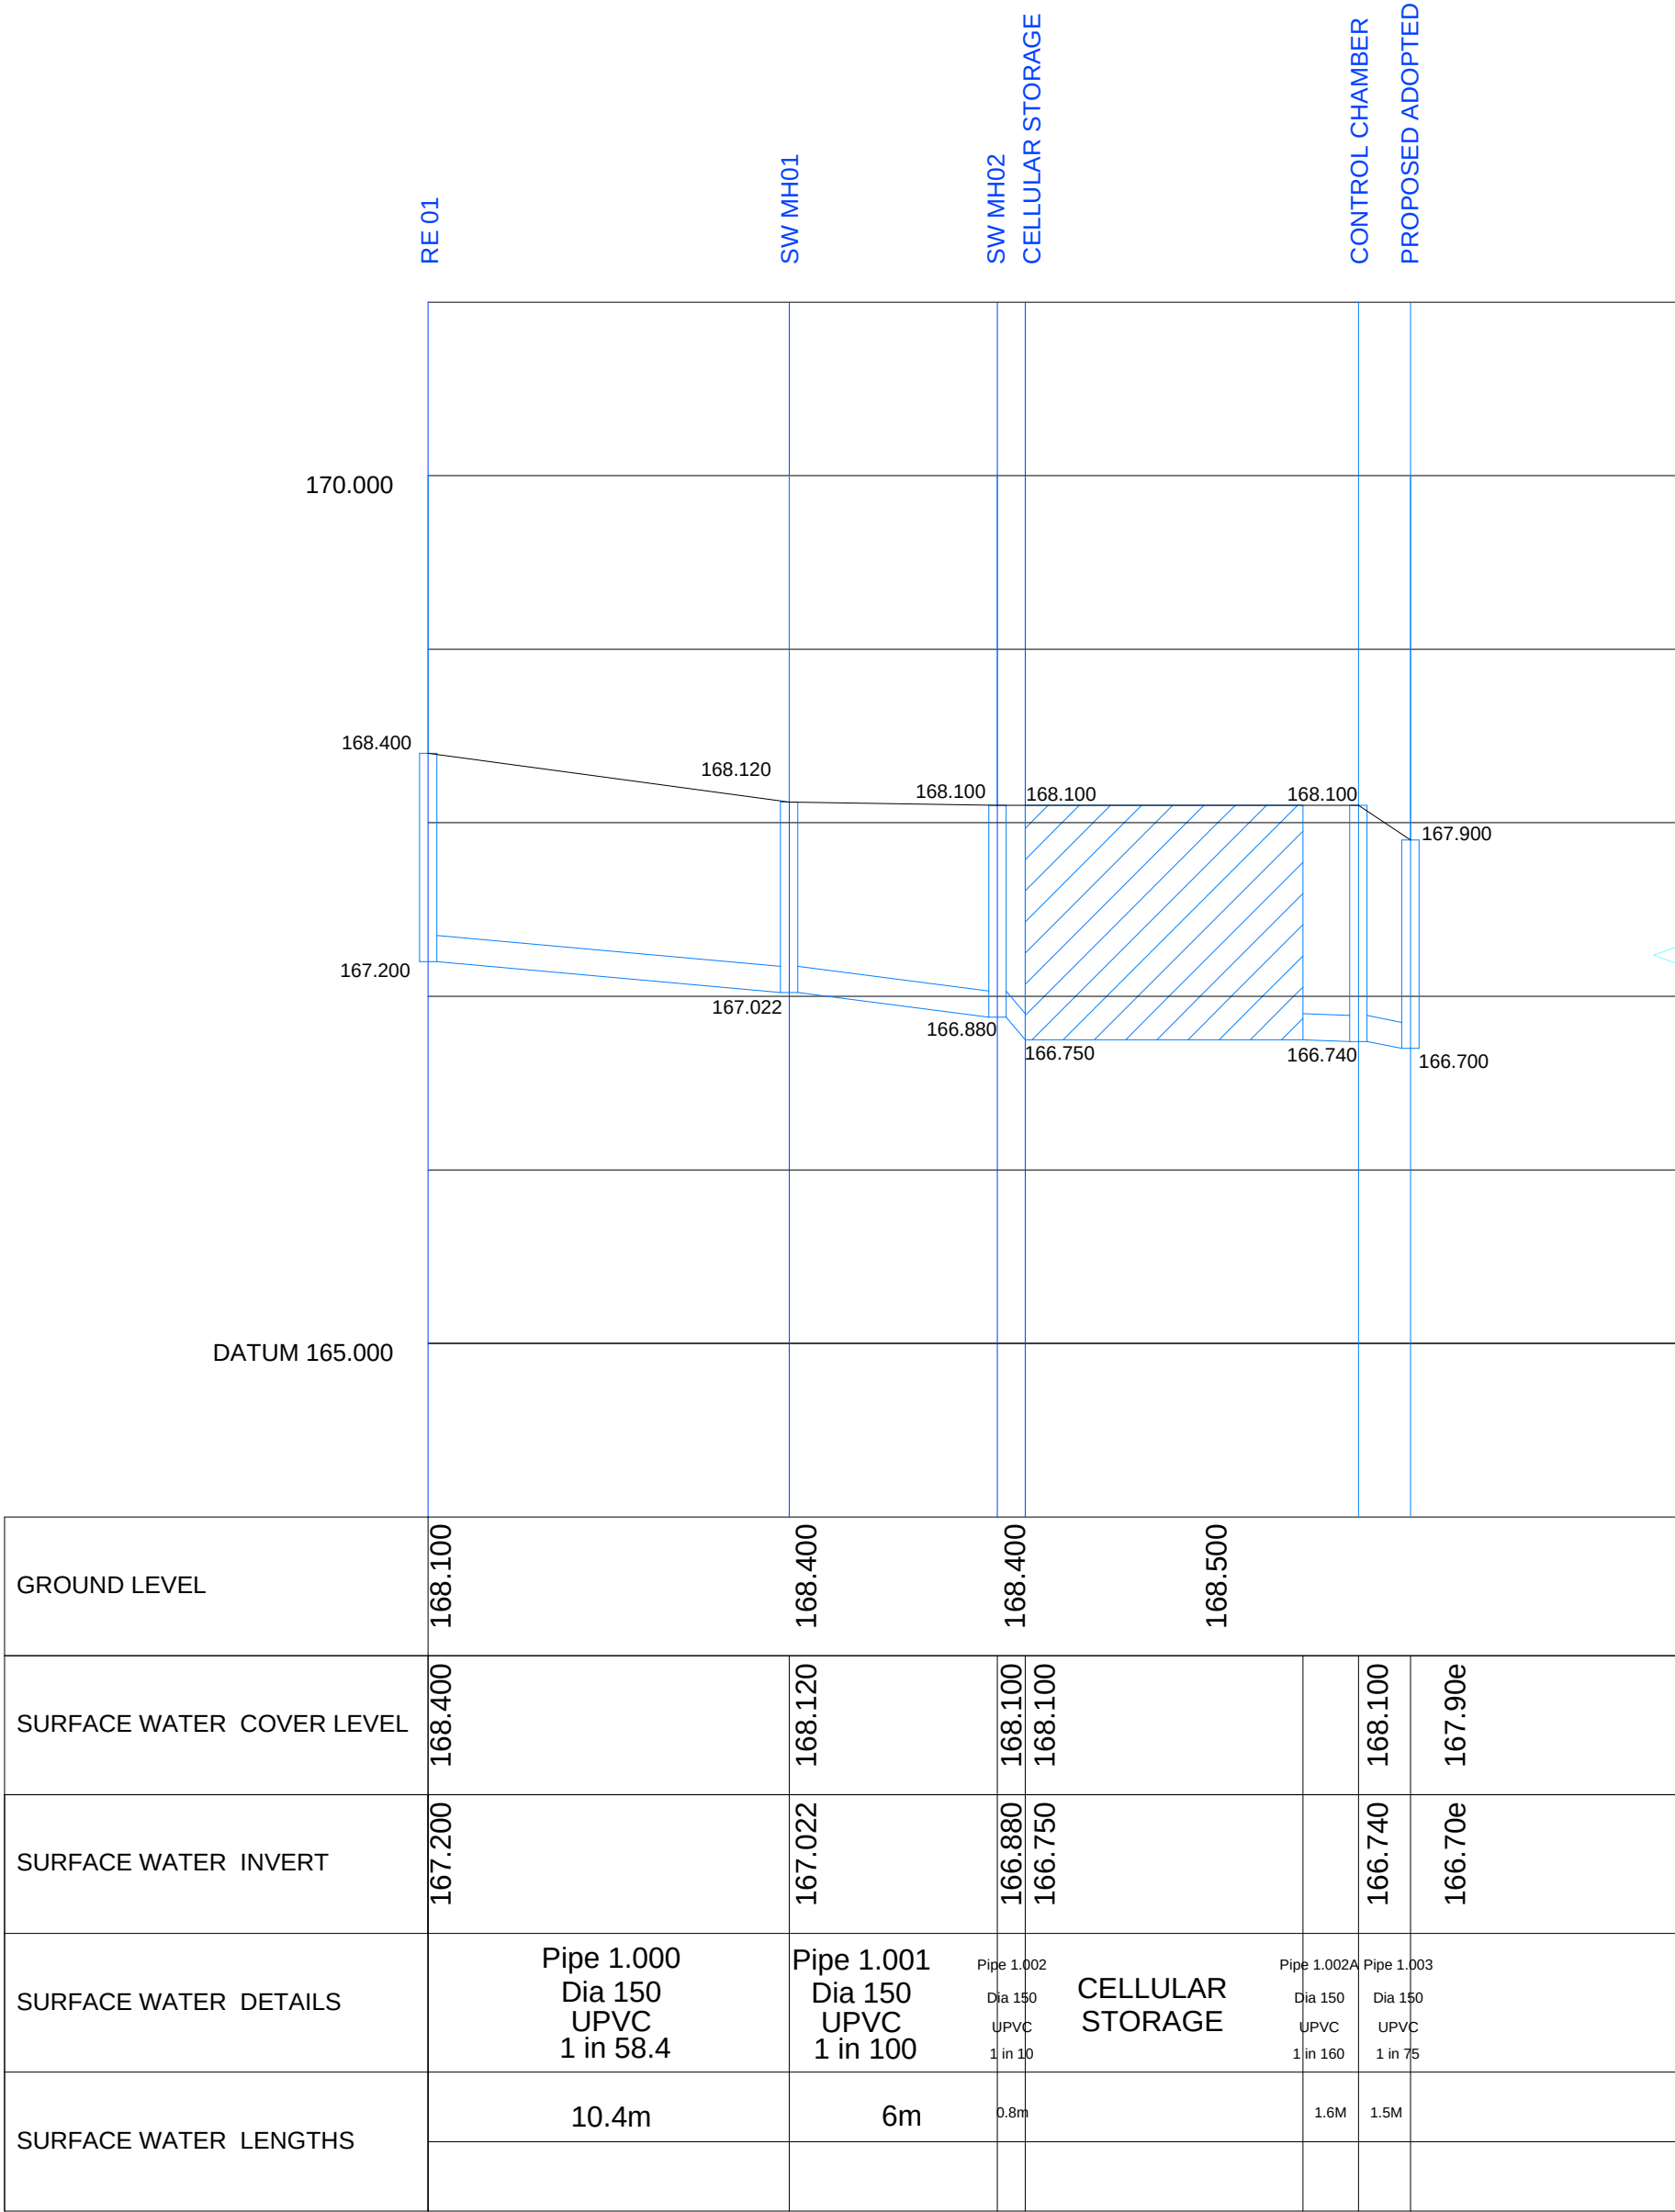

Surface Water Long Section
H 1:1, V 1:5

SURFACE WATER Network 1							
Pipe Code	Diameter (mm)	Gradient (1:)	Pipe Type	Pipe Length	Number	Manhole Invert	Cover
1.000	150	58.4	UPVC	10.400	R E	167.200	168.400
1.001	150	100	UPVC	6.000	SW MH01	167.022	168.120
2.000	100	58.5	UPVC	6.000	N/A	166.983	168.100
3.000	100	58.5	UPVC	6.000	N/A	166.983	168.100
1.002	150	10	UPVC	0.800	SW MH02	166.880	168.100
1.002A	150	160	UPVC	1.600	C C	166.740	168.100
1.003	150	75	UPVC	1.500	P A	166.700	167.900

Surface Water
Manhole Schedule

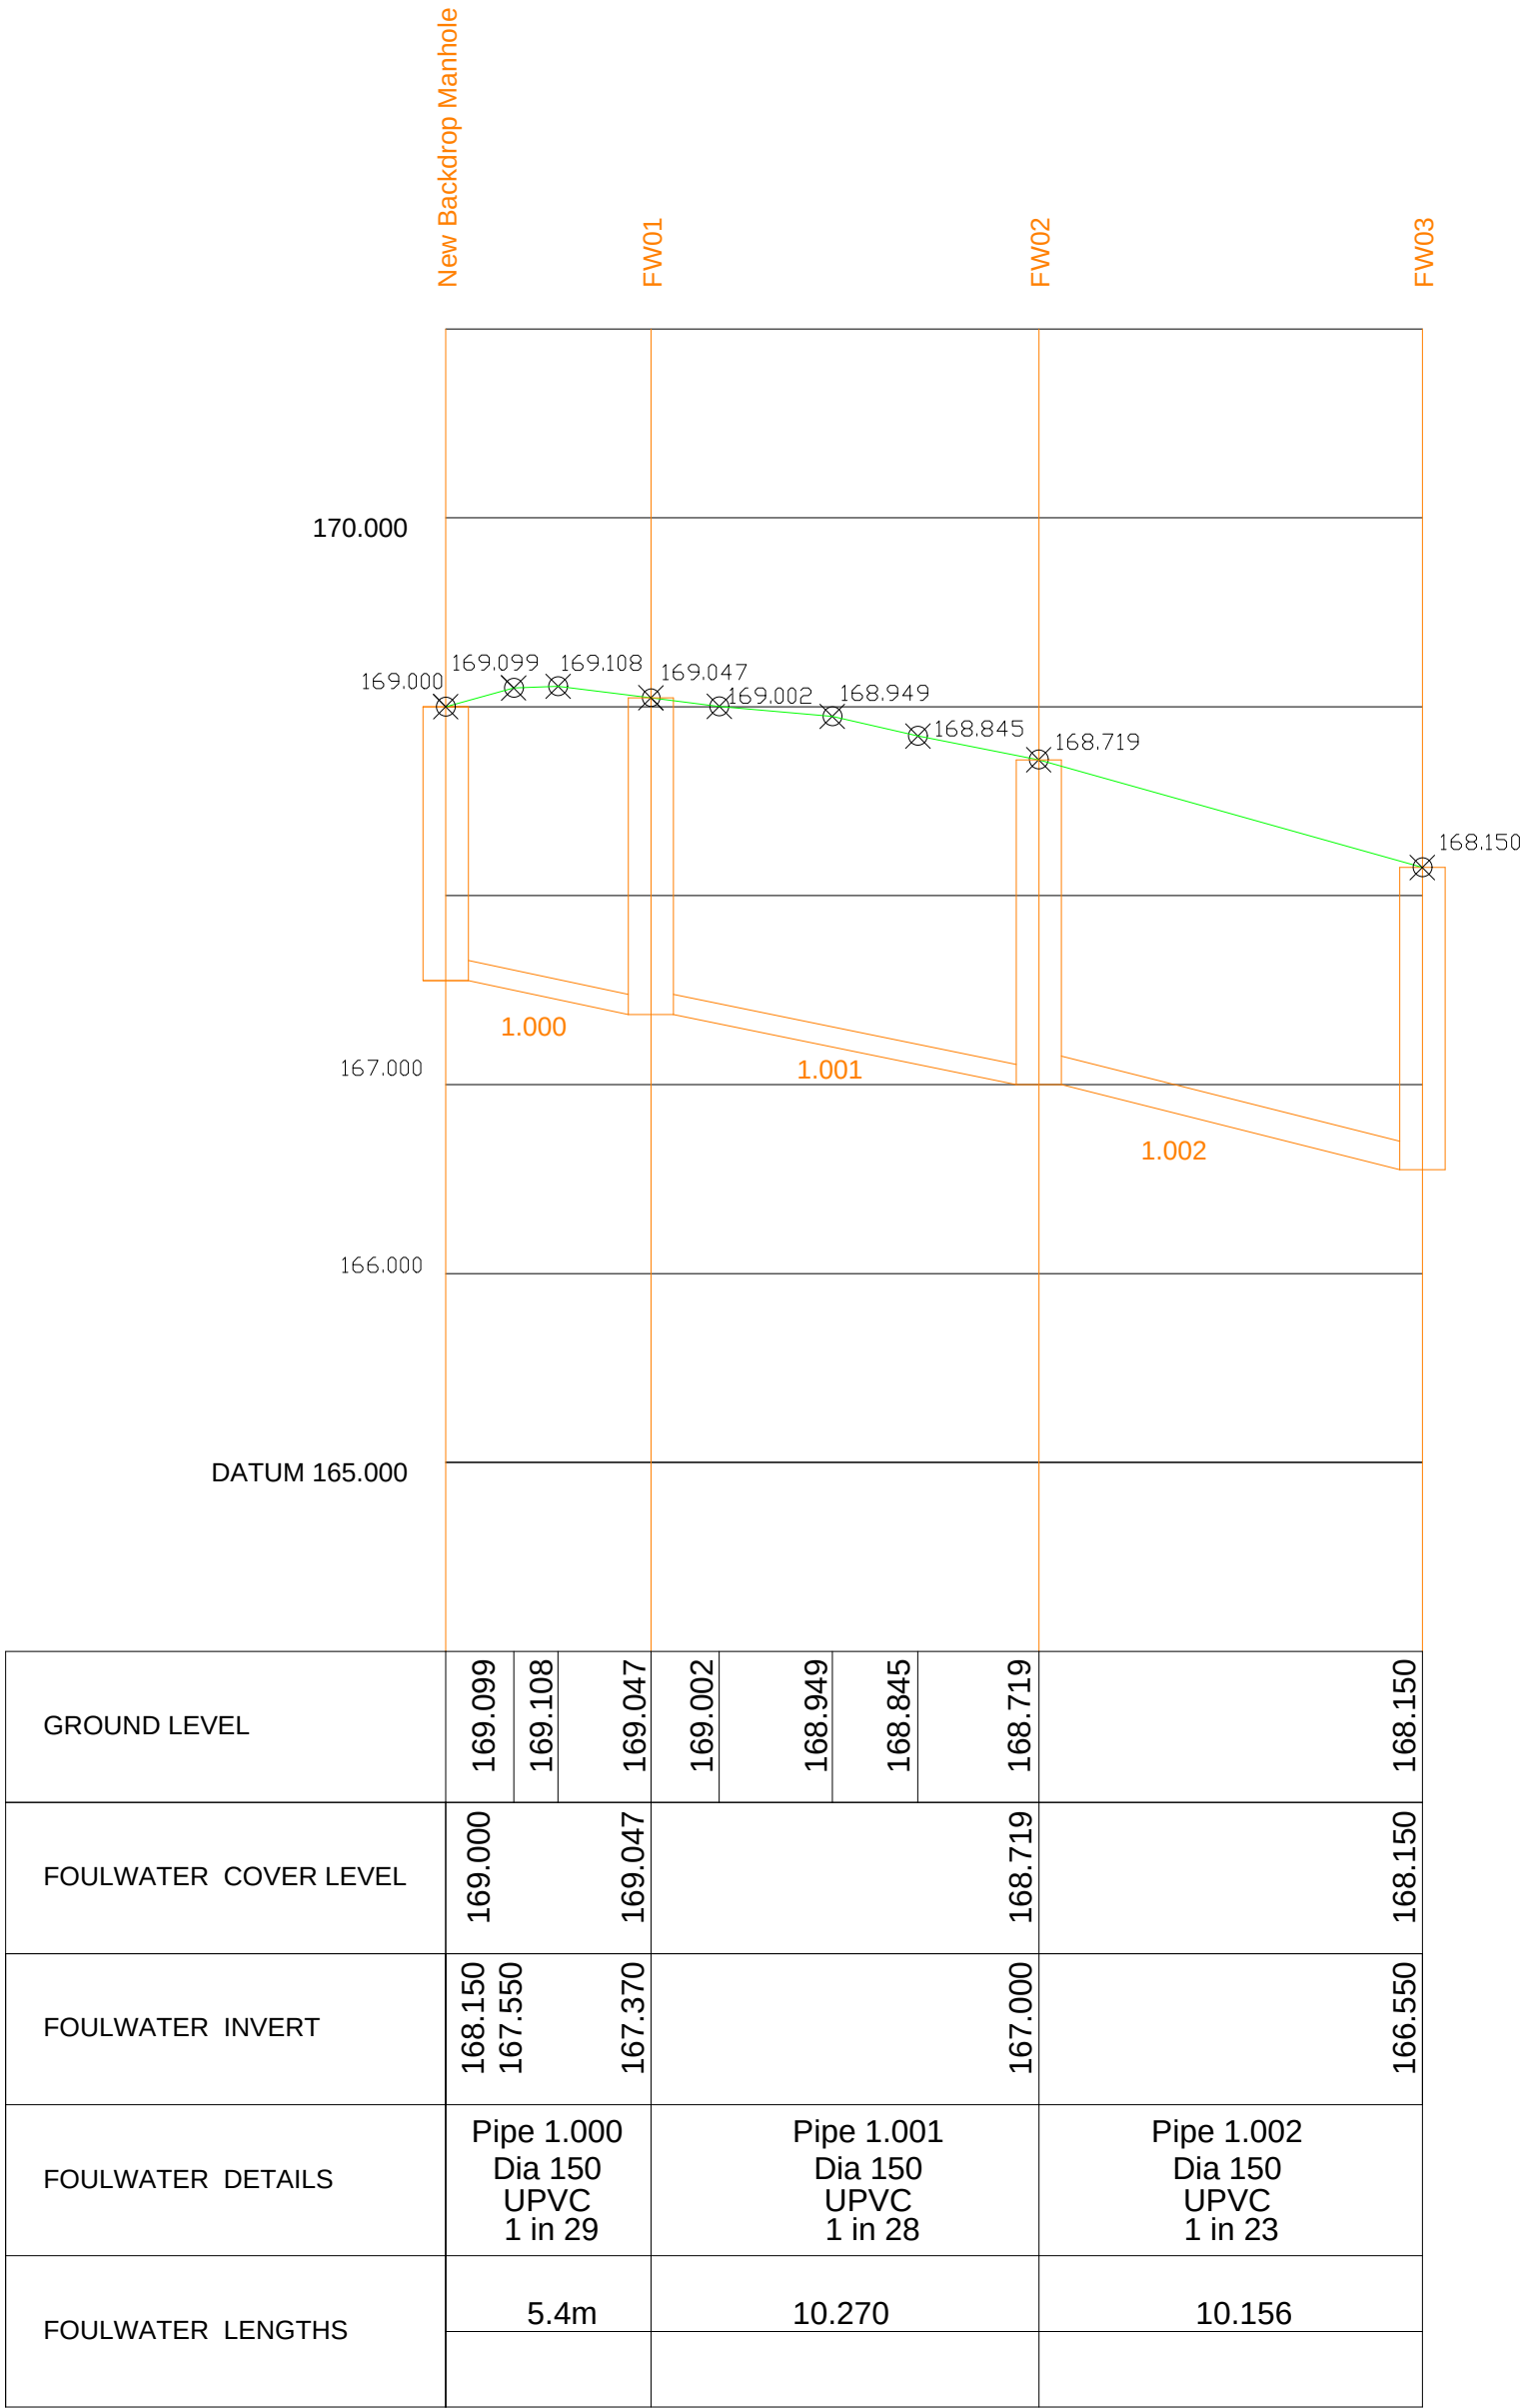

Foul Water Long Section
H 1:1, V 1:5

FOUL Network 1							
Pipe Code	Diameter (mm)	Gradient (1:)	Pipe Type	Pipe Length	Number	Manhole Invert	Cover
1.000	150	28	CLAY	5.4310	EXISTING	168.150in	169.000
1.001	150	29	CLAY	10.270	FW01	167.370	169.047
1.002	150	23	CLAY	10.156	FW02	167.000	168.719
					FW03	166.550	168.150
					FW04	167.410	168.500
					FW05	167.100	168.500
					FW06	167.050	169.000

Foul Water
Manhole Schedule

- Sanderson Associates (Consulting Engineers) Ltd ("the consultant"), has not checked or verified, and shall have no liability whatsoever for any inaccuracies which may be attributable to any data, reports, base plan(s) and drawings provided by the client, or purchased by the consultant on the client's behalf, that may have been utilised within this drawing.
- The consultant shall not be liable for the use by any person of any document for any purpose other than that for which the same were provided by the consultant.
- No liability whatsoever is accepted by the consultant for any error or omissions.
- This consultant is not responsible for the accuracy of the information provided by the client, and shall not be liable for any loss or damage arising from the use of this information. These locations are approximate only and should not be used for any purpose other than for information only.
- The consultant is not responsible for the accuracy of the information provided by the client, and shall not be liable for any loss or damage arising from the use of this information. These locations are approximate only and should not be used for any purpose other than for information only.
- Service connections are shown by dashed lines, and excavation is required to verify the location of any service connections or other appropriate means prior to mechanical excavation.
- Service connections are not shown but their presence should be anticipated.
- Reference to any third party equipment shown on this drawing was only relevant at the time the drawing was prepared.
- It is the client's responsibility to ensure that any equipment ordered meets the design.

A	Redesigned Drainage Plan	JKB	4/10/22	JEM
Rev	Amendment	Drawn	Date	Checked

PRELIMINARY
DRAWING



Client		WHITE STAG HOMES	
Project Title		LOCKWOOD LANE, WORSBOROUGH	
Drawing Title		SURFACE WATER AND FOUL WATER LONG SECTIONS AND MANHOLE SCHEDULES	
Scale	1:100	Drawn By	LOB
Drawing Size	A1	Checked By	JEM
Date	09/09/2022	Approved By	PJM
Drawing Number		Rev	
301192_0500_005		A	