

THIS DRAWING IS COPYRIGHT, AND REMAINS THE PROPERTY OF
HTC ARCHITECTS. IT MUST NOT BE REPRODUCED, USED,
DISCLOSED OR TRANSMITTED TO THIRD PARTIES IN ANY FORM,
IN WHOLE OR IN PART, WITHOUT PRIOR WRITTEN PERMISSION.

DO NOT SCALE!
ALL DIMENSIONS SHOULD BE CHECKED ON SITE BEFORE
WORK COMMENCES

IN ACCORDANCE WITH LIDL SPECIFICATION 2017.3,
RECEIVED 22.02.18

INLINE WITH TOPOGRAPHICAL SURVEY, LANDFORM SURVEY,
DATED 03.07.17, DRAWING NUMBER 001


LIGHTING LAYOUT BASED ON PHILLIPS SCHEME, LIDL
MAPPLEWELL CARPARK LTG PROPOSAL 12.03.18

INLINE WITH AWA ARBORICULTURAL REPORT, REF. AWA1887,
DATED JUNE 2017

SUBJECT TO HIGHWAYS CONSULTANT DESIGN



- KEY**
- 1** 6m LIDL FLAGPOLE SIGNAGE
 - 2** POSTER DISPLAY UNIT (PDU)
 - 3** LARGE COLUMN-MOUNTED ILLUMINATED SIGN
 - 4** SMALL WALL-MOUNTED BILLBOARD
 - 5** LARGE WALL-MOUNTED BILLBOARD
 - 6** SMALL WALL-MOUNTED ILLUMINATED LIDL LOGO SIGN

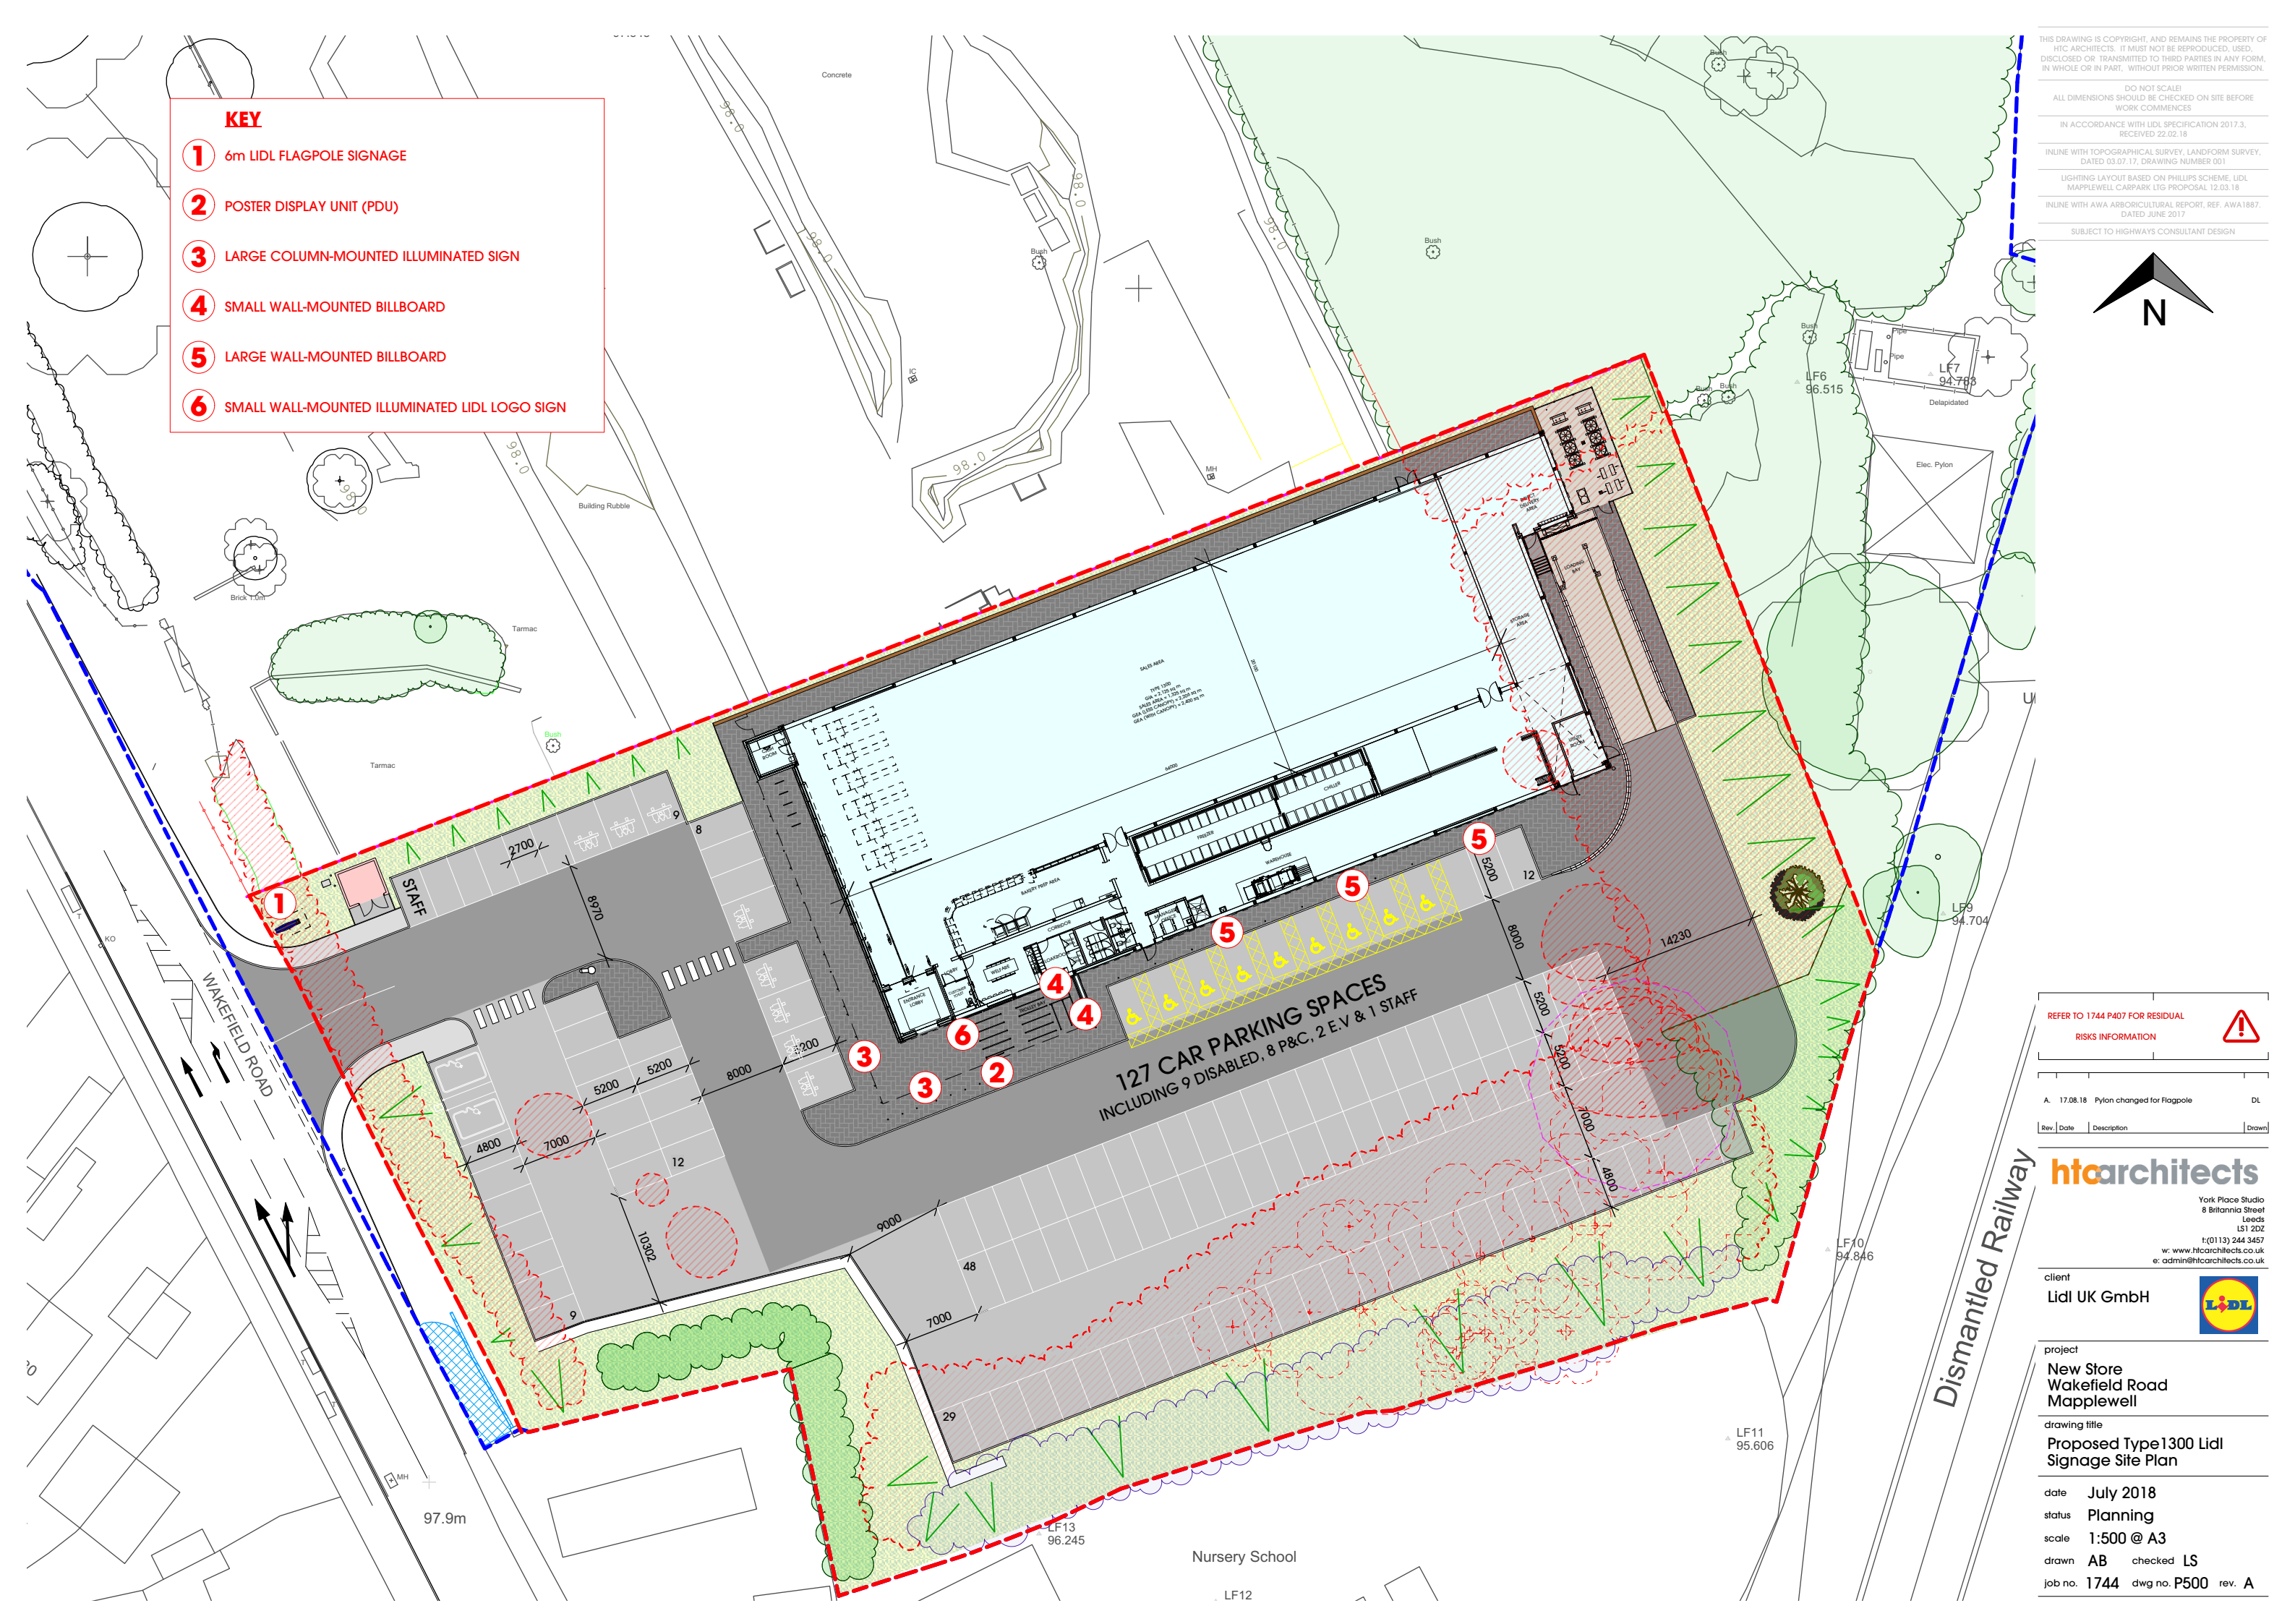

REFER TO 1744 P407 FOR RESIDUAL
RISKS INFORMATION



A.	17.08.18	Pylon changed for Flagpole	DL
Rev.	Date	Description	Drawn

htcarchitects

York Place Studio
8 Britannia Street
Leeds
LS1 2DZ
t: (0113) 244 3457
e: admin@htcarchitects.co.uk

client
Lidl UK GmbH



project
**New Store
Wakefield Road
Mapplewell**

drawing title
**Proposed Type1300 Lidl
Signage Site Plan**

date **July 2018**
status **Planning**
scale **1:500 @ A3**
drawn **AB** checked **LS**
job no. **1744** dwg no. **P500** rev. **A**