


DIGITAL MEDIA

COMPUTA CENTER

1. Install 2x 46" TV screens (Portrait) floor to ceiling.

MAIN CONTRACTOR:

1. Remove existing External Campaign units.
2. Install power and data sockets to ceiling void above screen location.
3. Remove floor socket.
4. Make good to flooring & ceiling.

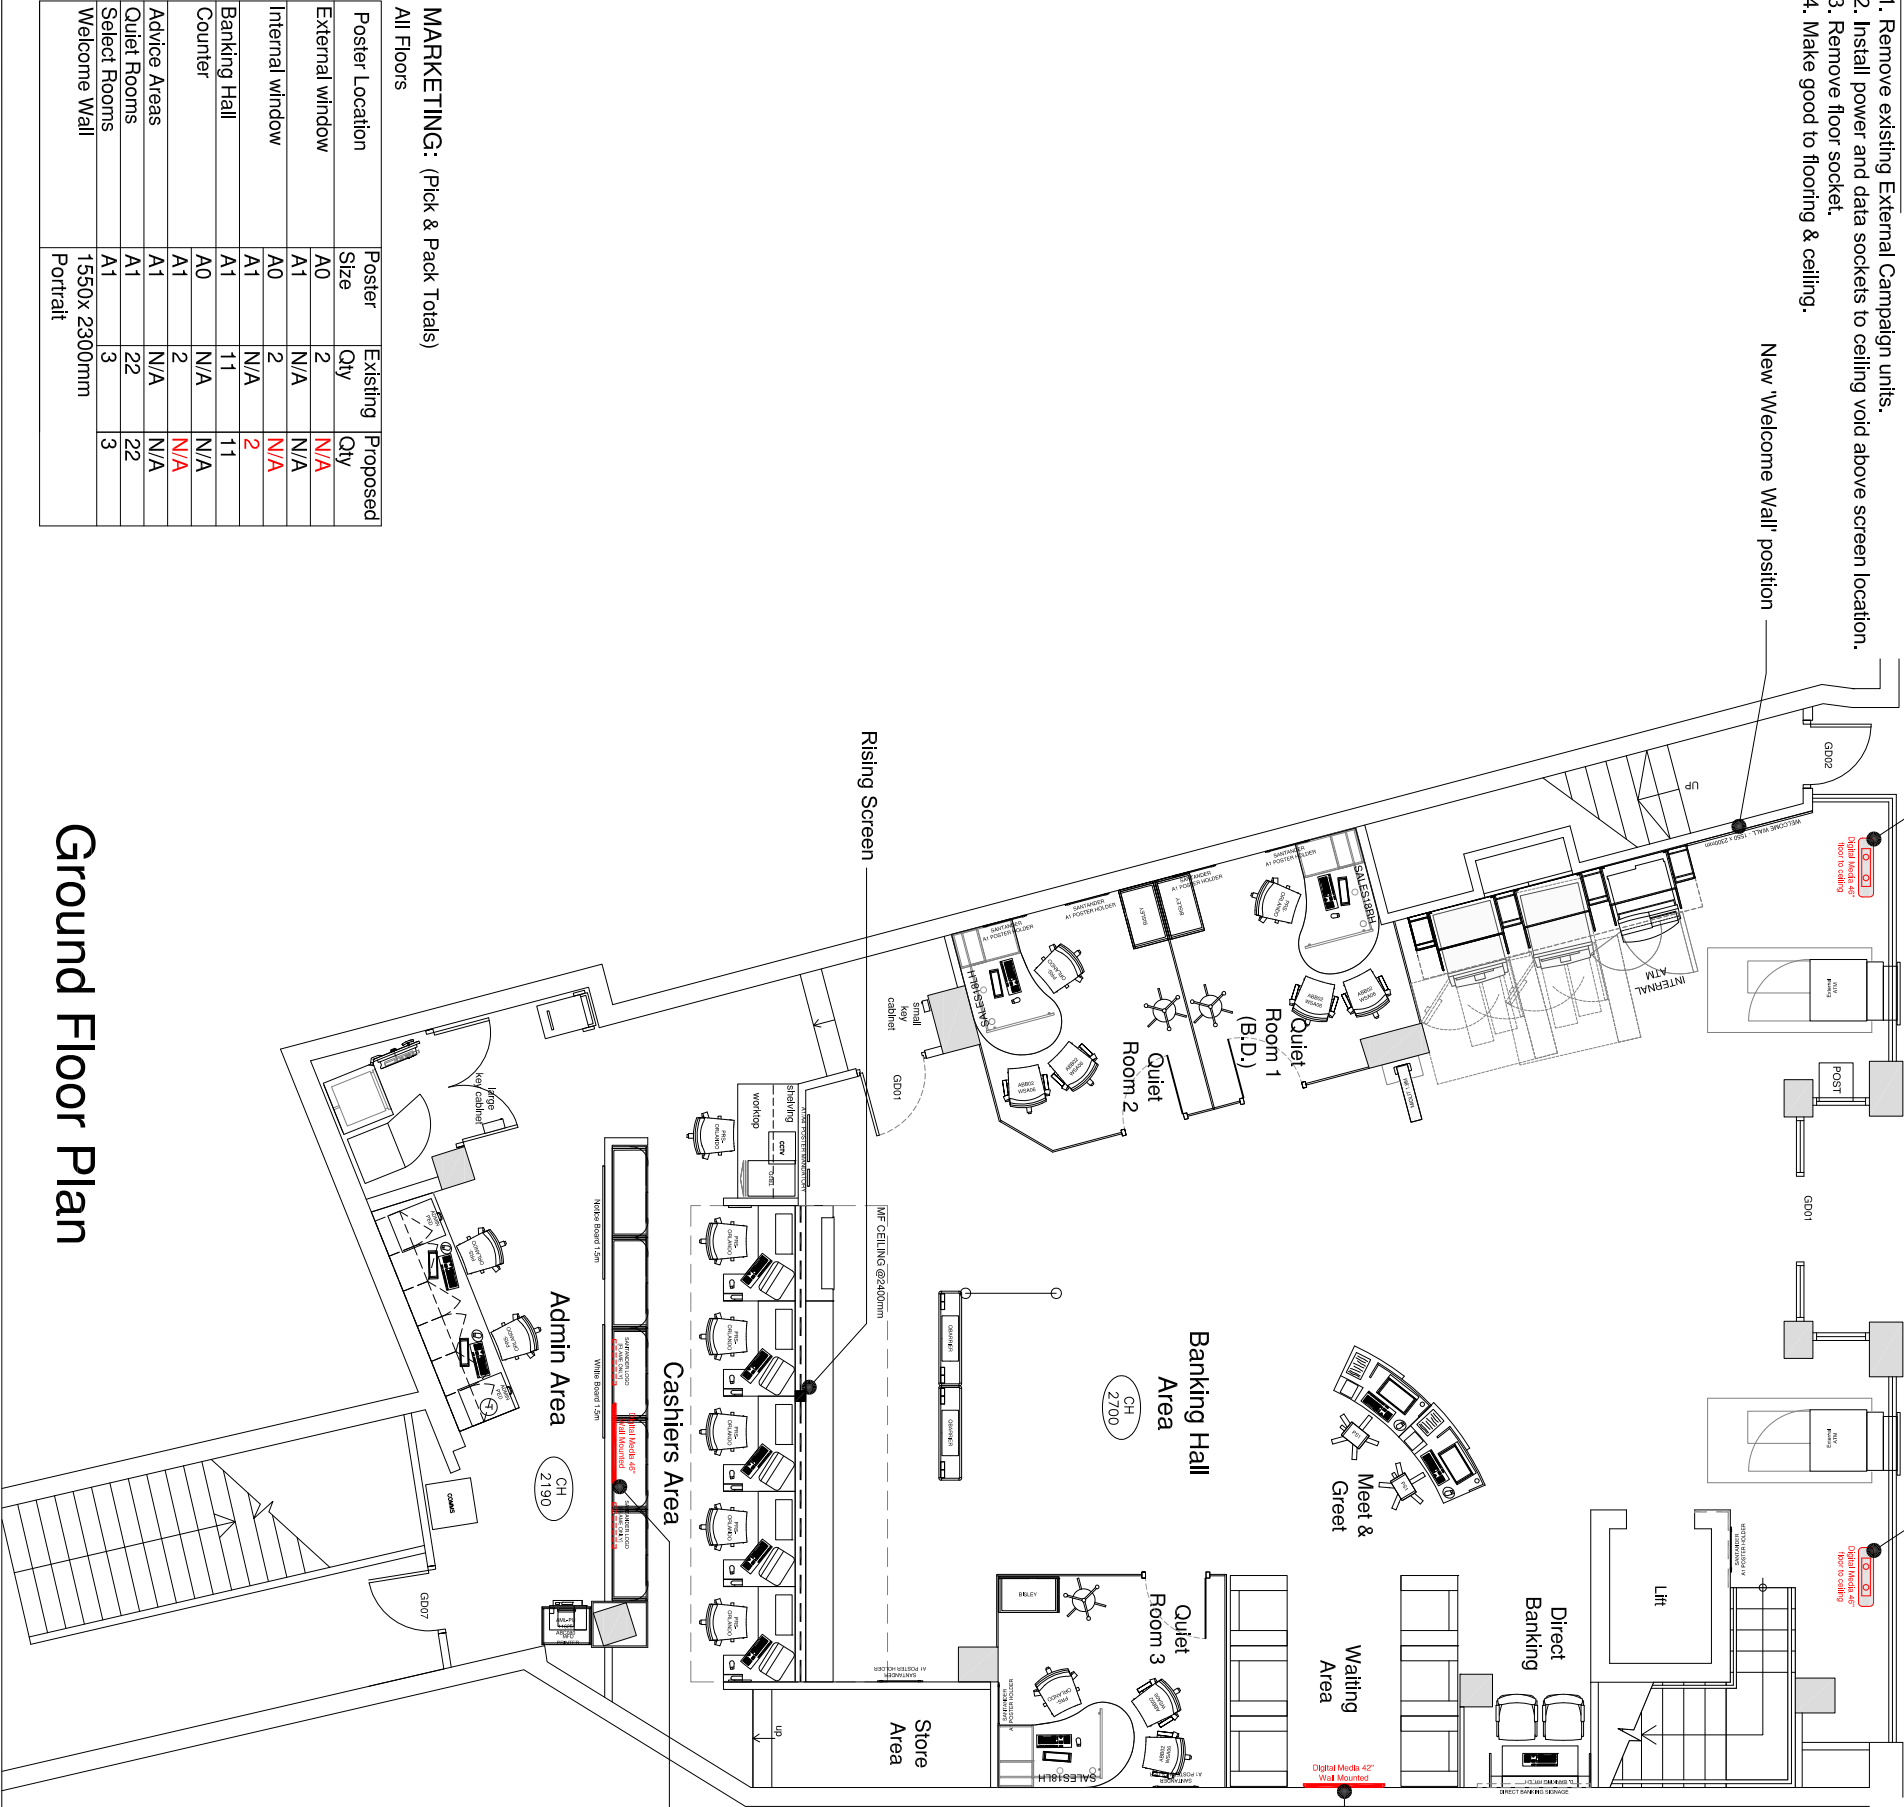

Ground Floor Plan

Poster Location	Poster Size	Existing Qty	Proposed Qty
External window	A0	2	N/A
	A1	N/A	N/A
Internal window	A0	2	N/A
	A1	N/A	2
Banking Hall	A1	11	11
	A0	N/A	N/A
Counter	A1	2	N/A
	A1	N/A	N/A
Advice Areas	A1	22	22
Quiet Rooms	A1	3	3
Select Rooms	A1	3	3
Welcome Wall	1550x 2300mm		
	Portrait		

MARKETING: (Pick & Pack Totals)

All Floors

Notes.

This Drawing is the copyright and property of Santander UK PLC. It must not be copied or published without written consent.

Do not scale from this drawing.

Rev	Description	Date	By
A	Updated to For Approval	06/12/15	SR
B	Updated to Approved	07/12/15	SR

DIGITAL MEDIA PLEASE NOTE

Install dedicated clean power circuit for the purpose of Digital media, within ceiling void, with sockets above all screen locations along with a labelled isolation switch located within the admin area (Digital Media Isolation point - Do not turn off).

COMPUTA CENTER:

1. Install 42" TV on bracket (Landscape).

MAIN CONTRACTOR:

1. Relocate 'Welcome Wall' - 1550 x 2300mm.
2. Chase out masonry for containment.
3. Install containment from ceiling void to back of screen for power & data cables.
4. Install brush grommet to cover cable exit hole.
5. Install power and data sockets to ceiling void above screen location.
6. Make good to walls and decorate.

COMPUTA CENTER:

1. Install 46" TV on bracket (Landscape).

MAIN CONTRACTOR:

1. Remove flame logo and 2x A1 posters.
2. Install 18mm ply Pattress (as per structural engineers details).
3. Install containment from ceiling void to back of screen for power & data cables.
4. Install brush grommet to cover cable exit hole.
5. Install power and data sockets to ceiling void above screen location.
6. Make good to walls and decorate.
7. Install 600x600 flame logos either side of TV.

APPROVED



Project
Santander - Barnsley QS,
3 Queen St, Barnsley,
South Yorks S70 2RJ

Title
Digital Media
Ground Floor Plan

Scale		
1:50 @ A1 & 1:100 @ A3		
Dm	App	
S.R.		
Date	Date	
15/09/15		
Consultants drawing number		brand
Client drawing number		rev.
Barnsley QS-0261-GF-DM-AP		B