



AXONOMETRIC 3D VIEW 1:100_

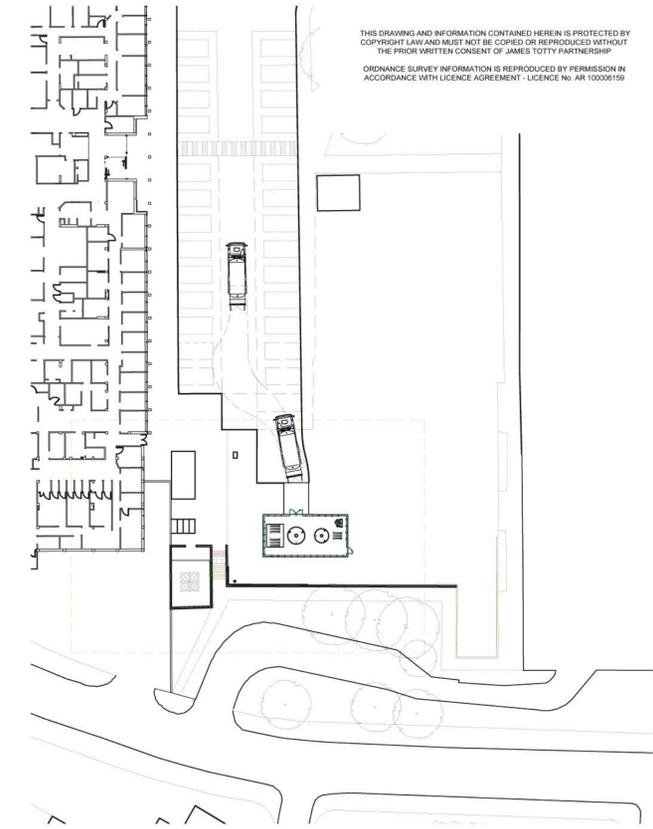

SITE LOCATION PLAN 1:500_

THIS DRAWING AND INFORMATION CONTAINED HEREIN IS PROTECTED BY COPYRIGHT LAW AND MUST NOT BE COPIED OR REPRODUCED WITHOUT THE PRIOR WRITTEN CONSENT OF JAMES TOTTY PARTNERSHIP.
ORDNANCE SURVEY INFORMATION IS REPRODUCED BY PERMISSION IN ACCORDANCE WITH LICENCE AGREEMENT - LICENCE No. AR 10000159

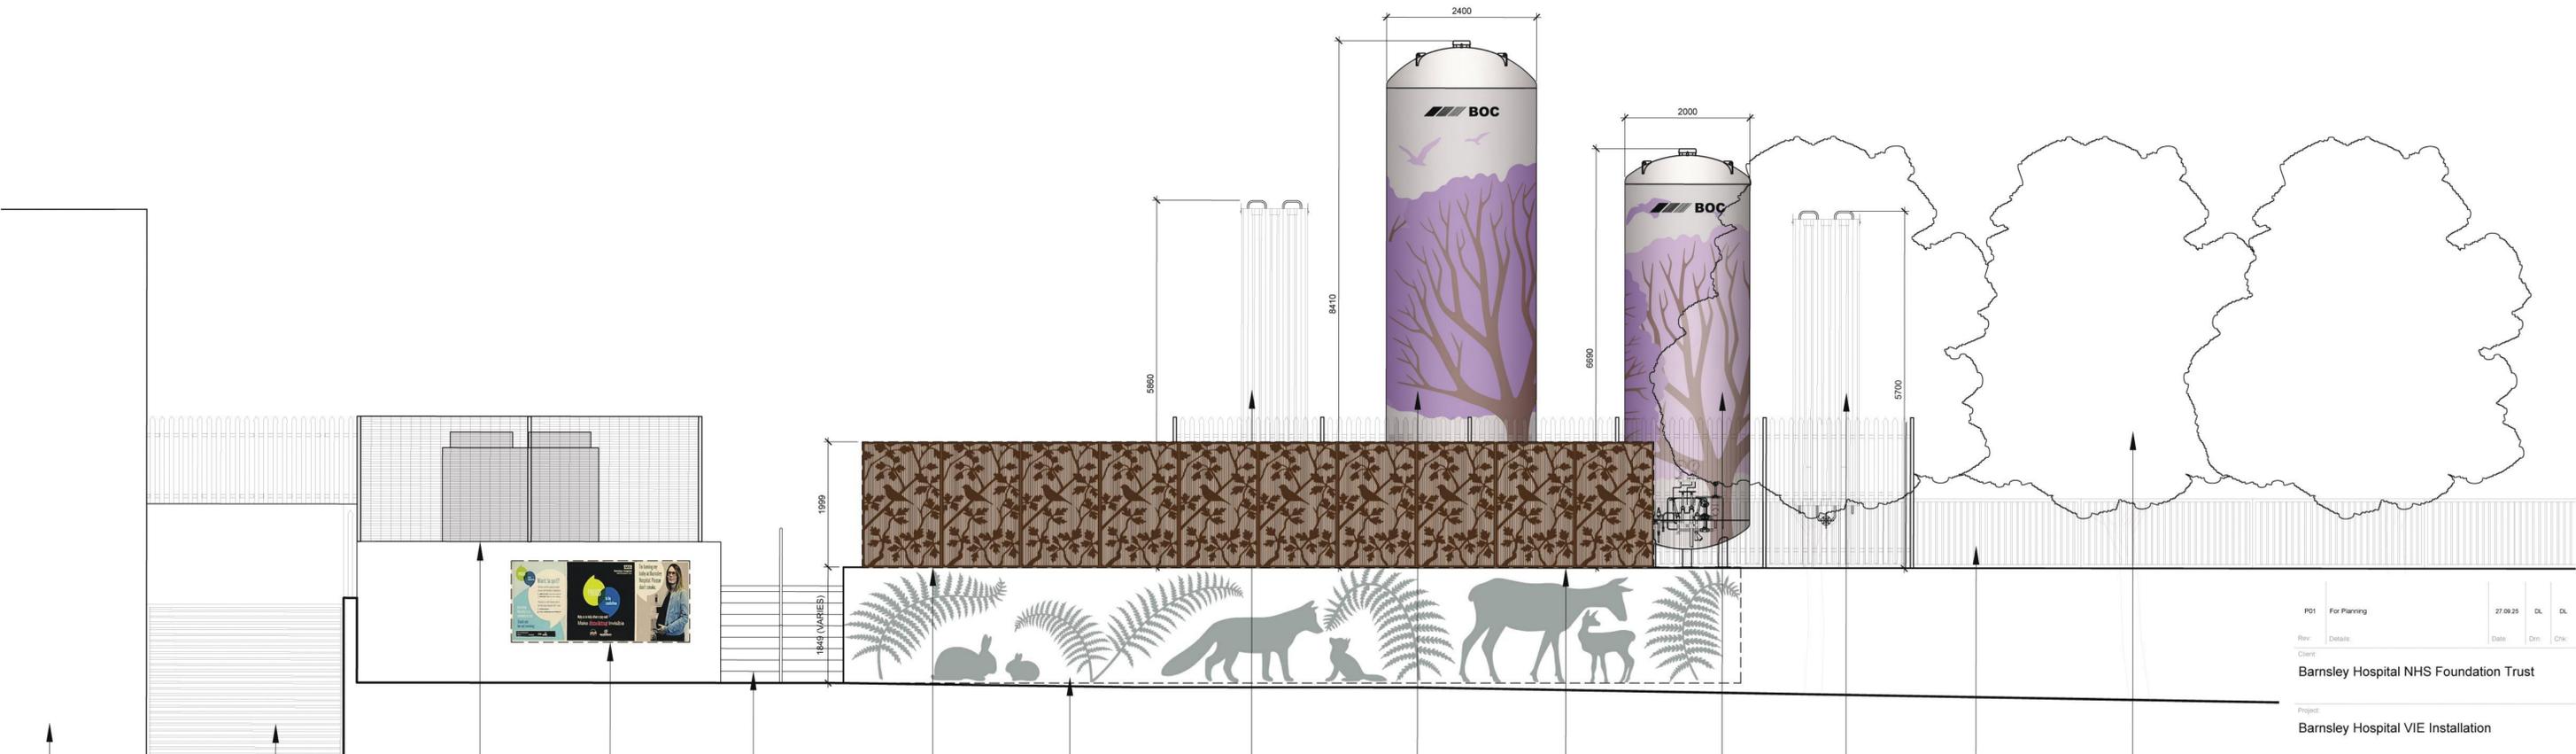

- BARNSELEY HOSPITAL O-BLOCK / WOMEN'S SERVICES DEPARTMENT
- EXISTING PLANT AREA AND CONNECTION TO NEW LIQUID OXYGEN STORAGE
- EXISTING MECHANICAL PLANT COMPOUND AND PALISADE FENCE
- EXISTING POSTER TO BE RELOCATED
- EXISTING STEPS & HANDRAIL (TO BE REFURBISHED)
- 2M HIGH CORTEN VANITY SCREEN 10 x 1.25m x 2m (FINAL DESIGN TBC)
- MURAL ARTWORK SANDBLASTED ONTO EXISTING CONCRETE WALL AND CLEANED (FINAL DESIGN TBC)
- 5.86 M HIGH VAPOURIZER SKID
- V200-18 VESSEL 8.41M HIGH (ARTWORK TBC)
- 2.4 M HIGH DARK COLOUR CT-358 PRISON MESH PANEL SECURITY FENCE DARK GREEN TO MATCH EXISTING FENCING
- V100-18 VESSEL 6.69M HIGH (ARTWORK TBC)
- 5.7M HIGH AMBIENT VAPOURIZER
- EXISTING RAILING TO REMAIN AND REPAINTED TO MATCH CORTEN SCREEN
- EXISTING MATURE TREES

NORTH WEST ELEVATION ALONG POGMOOR ROAD 1:50_



Rev	For Planning	27.09.25	DL	DL
Client	Barnsley Hospital NHS Foundation Trust			
Project	Barnsley Hospital VIE Installation			
Drawing	Proposed Main Elevation and Axonometric 3D View			
Scale	Project No	Drawn	Checked	Date
Varies	15 / 1482	DL	DL	Sept 2025
Status	Purpose			
	FOR PLANNING			
Drawing No	151482 - JTP - XX - XX - D - A - 605 - P02			

JTP ARCHITECTS
 JAMES TOTTY PARTNERSHIP LLP
 CHARTERED ARCHITECTS
 38 WILKINSON STREET
 SHEFFIELD S10 2GB
 Telephone: (0114) 270 0208
 Email: mail@jtp-architects.co.uk
 Web: www.jtp-architects.co.uk