
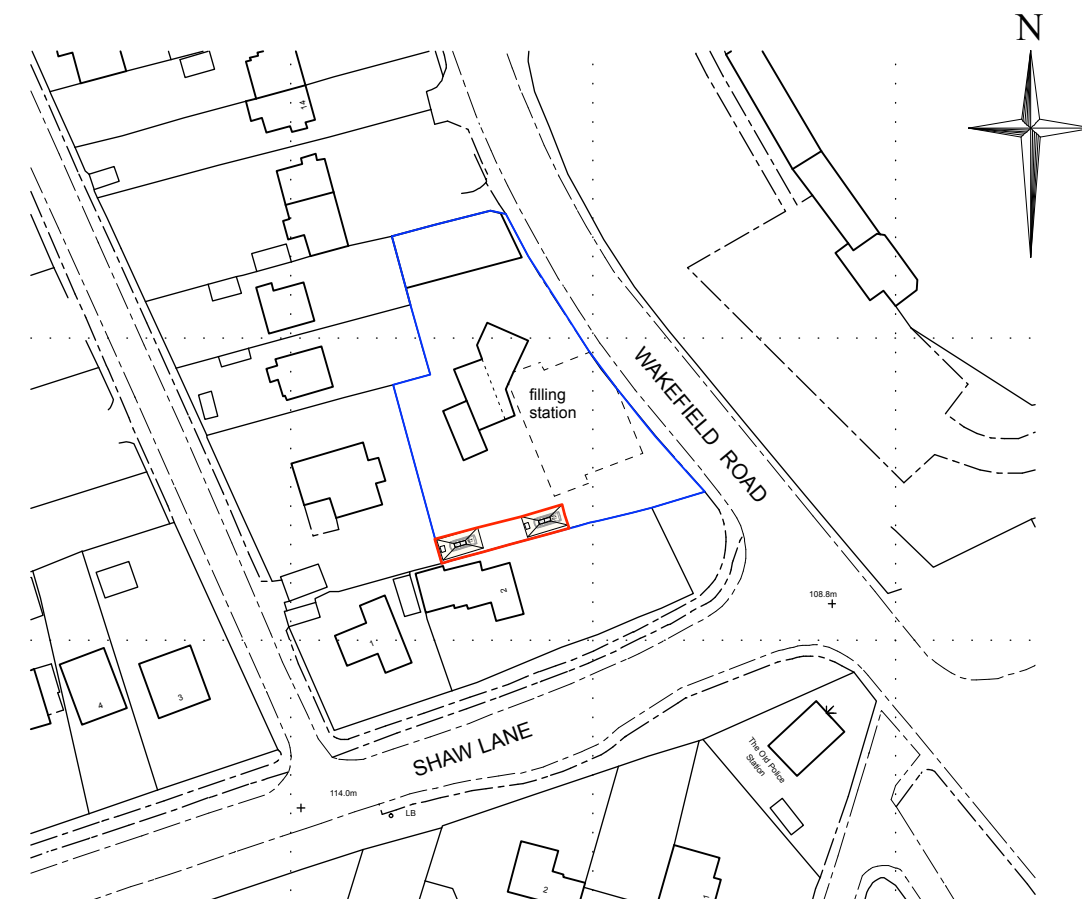


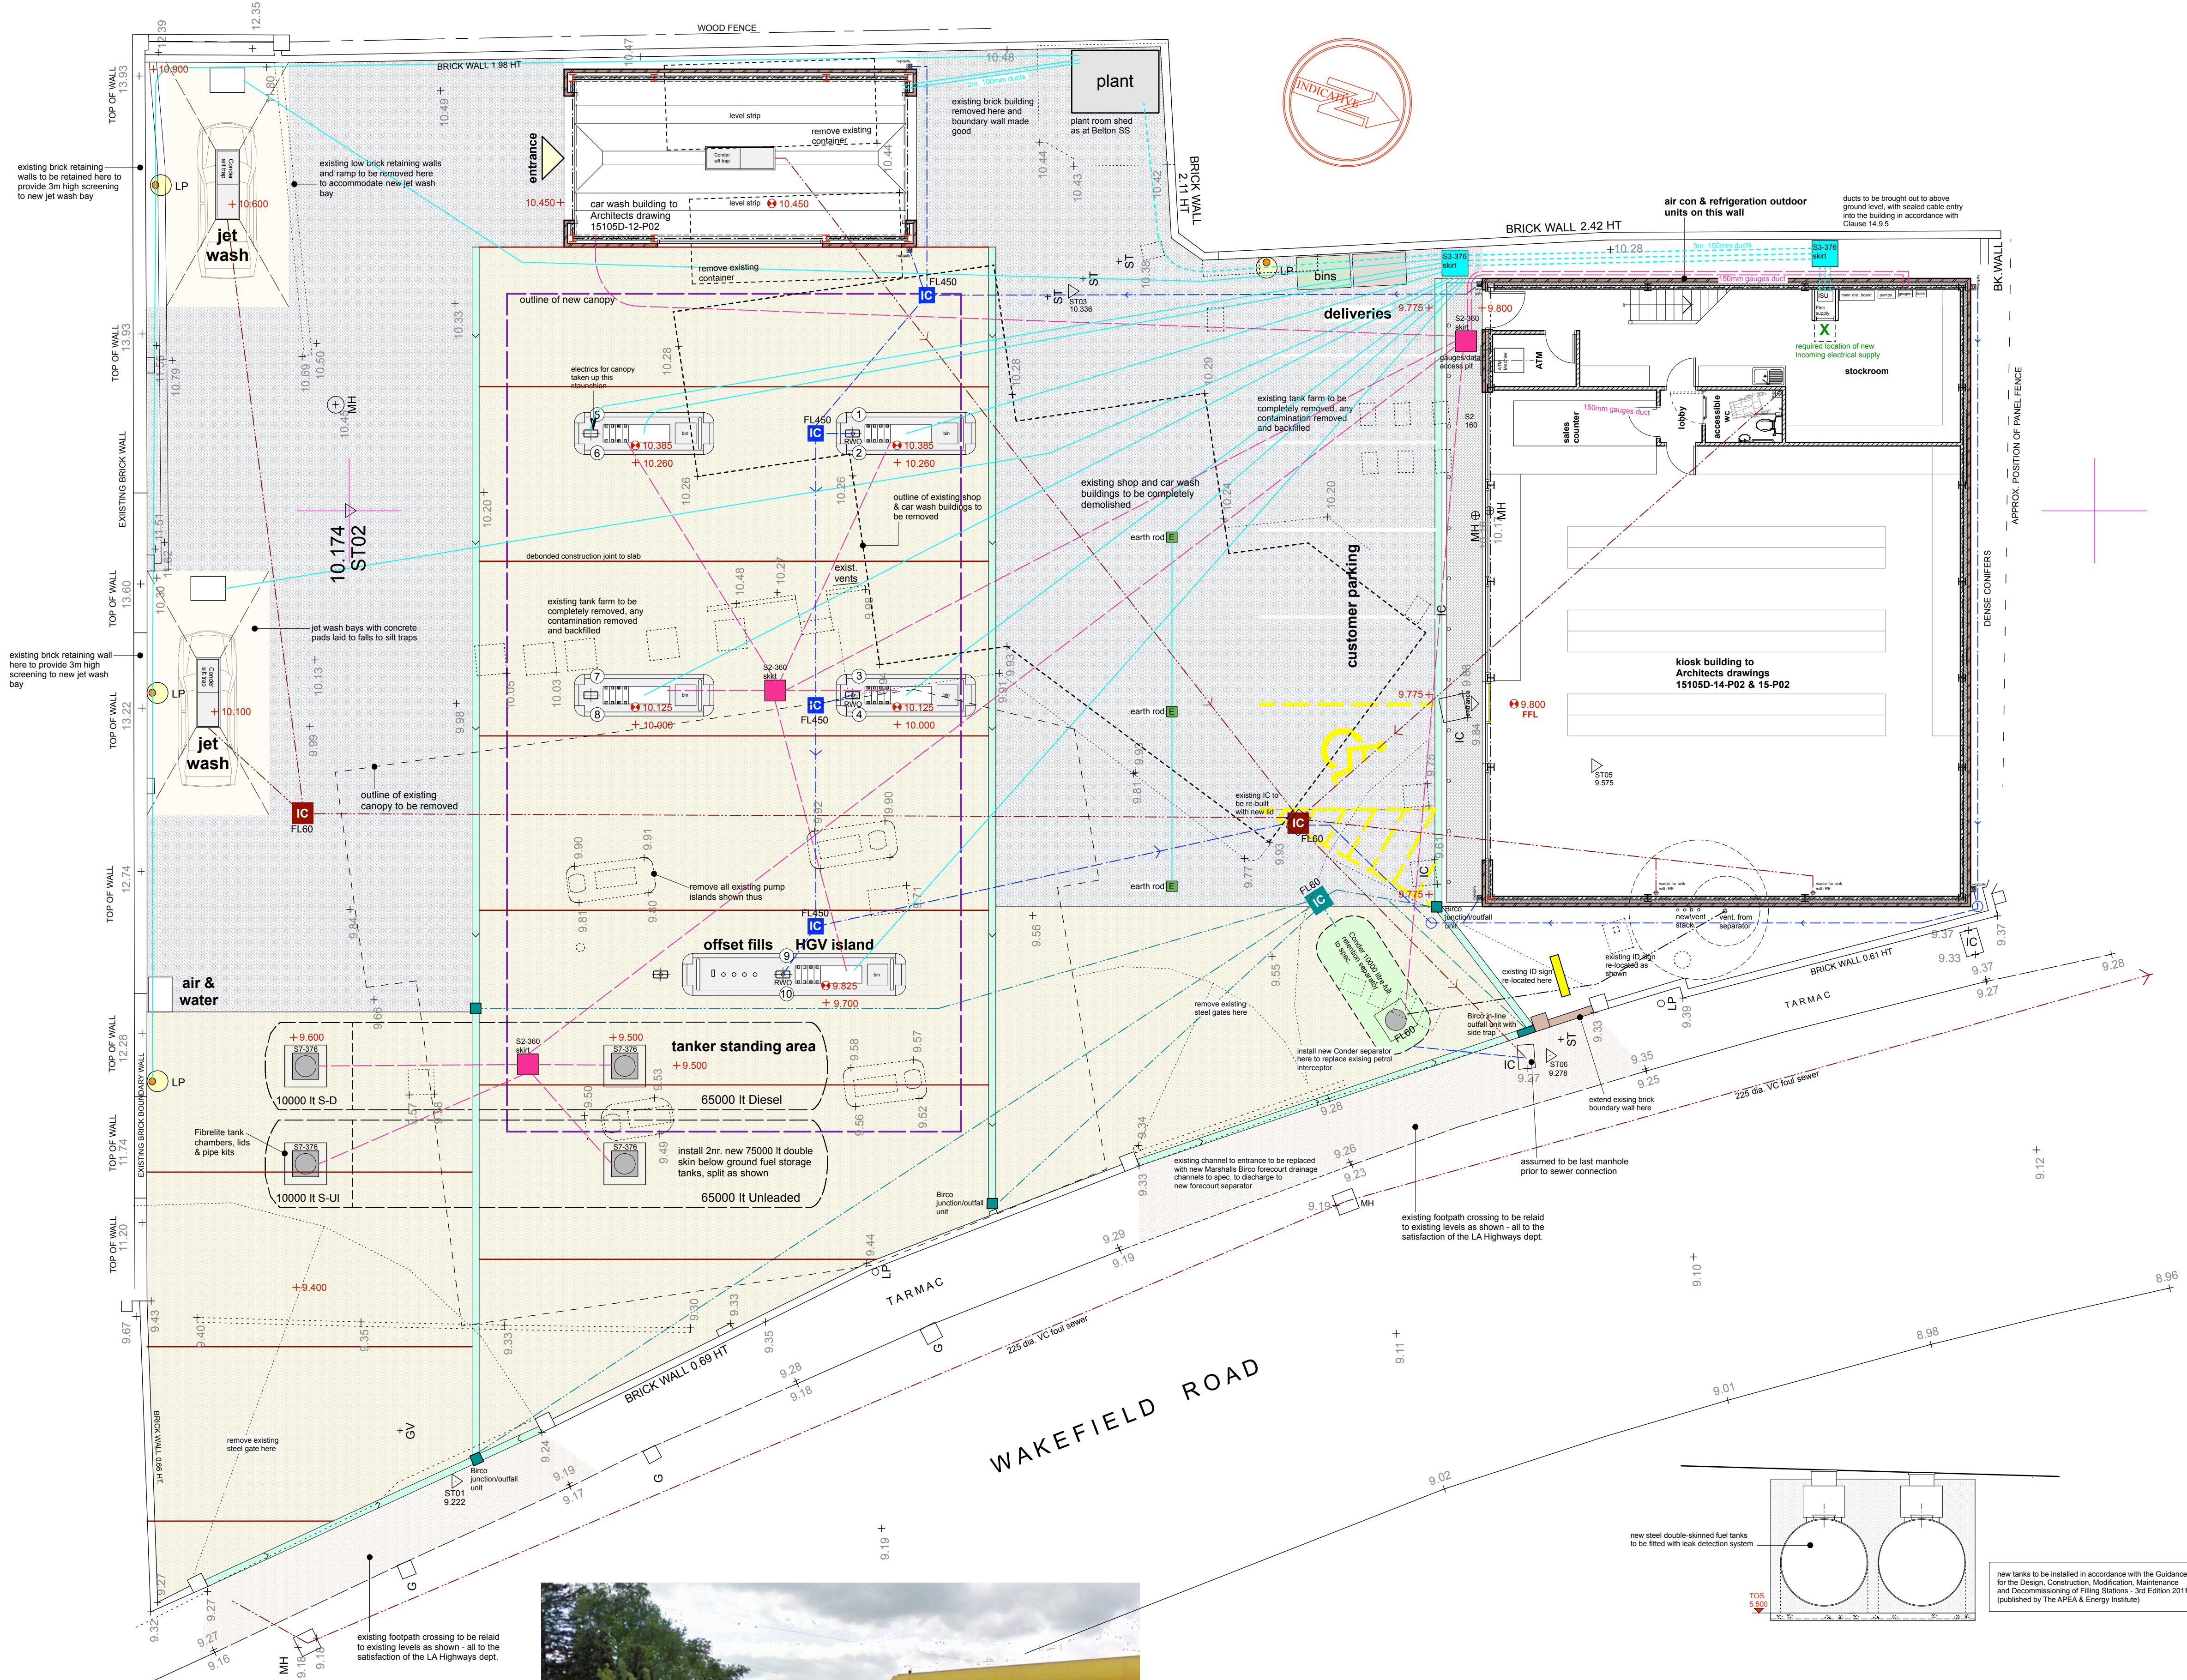


location 1/1250

- concrete surfacing to forecourt shown thus to spec.
- new full build up SMA macadam surfacing shown thus to spec.
- concrete block paving to perimeter footpath to kiosk building to spec.
- 100mm dia. new surface water drains shown thus (except where indicated larger) new inspection chambers where shown with Fibrelite lid type as indicated
- 100mm dia. new foul drains shown thus (new inspection chambers where shown with Fibrelite lid type as indicated)
- 100mm dia. new forecourt drains shown thus (new inspection chambers where shown with Fibrelite lid type as indicated)
- Marshall's Birco 150 channel drainage system fitted with cast iron slotted gratings (D400 load class)
- Marshall's Birco 150 junction/outfall unit
- Marshall's Birco 150 in-line outfall unit
- debonded construction joint to details & spec.
- 100mm gauges or data duct (except where shown larger)
- 100mm electrical duct
- 150mm electrical duct
- Fibrelite sump for electrical services to spec. (chamber/lid reference as indicated on plan)
- Fibrelite sump for gauges equipment to spec. (chamber/lid reference as indicated on plan)
- 5m galv. steel floodlight pole for perimeter lighting
- 3m copper earthing rod approx. location where shown
- 150mm twin wall duct for main electric supply
- water supply pipework
- denotes new finished levels to pump islands etc.
- denotes new finished levels to forecourt areas
- denotes existing levels (generally to be maintained except where new finished levels are shown)
- All fuel lines & vent. pipework shown on A+DP drawing 15105D-08-P01

tender issue

This drawing has been prepared specifically for the purpose of obtaining Planning Permission and/or Building Regulation Approval. Its suitability for other purposes, without supplementary details and specifications cannot be guaranteed. The Permissions and/or Approvals are beyond the Architects control, and no guarantee that such will be granted is given or to be inferred by reason of the preparation of this drawing. Only figured dimensions are to be used. All dimensions to be checked on site. This drawing, together with the design is the property and copyright of the Architect and must not be reproduced without prior written permission.

T07	Updated for new jet wash application	03.04.17	AS	AS
T06	Updated for tendering purposes	10.02.17	AS	AS
P05	General update	26.01.17	AS	AS
P04	Updated for construction purposes	12.07.16	AS	AS
P03	Updated for construction purposes	28.06.16	AS	AS
P02	Tanker tracking added, Jet washes omitted	28.01.16	RE	AS
P01	Drawing originated	26.10.15	AS	AS
rev.	description	date	drawn	approved

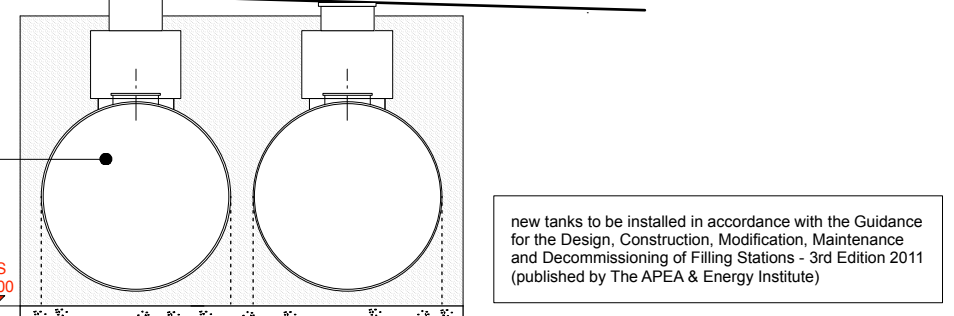

new tanks to be installed in accordance with the Guidance for the Design, Construction, Modification, Maintenance and Decommissioning of Filling Stations - 3rd Edition 2011 (published by The APCA & Energy Institute)



existing brick retaining wall here to provide 3m high screening to new jet wash bays



project Proposed redevelopment of Turnpike Filling Station at Wakefield Road Staincross, Barnsley, S75 6JX for SK Fuel Ltd

title site plan as proposed
number 15105D-05-T07
scale 1:100
size A1