


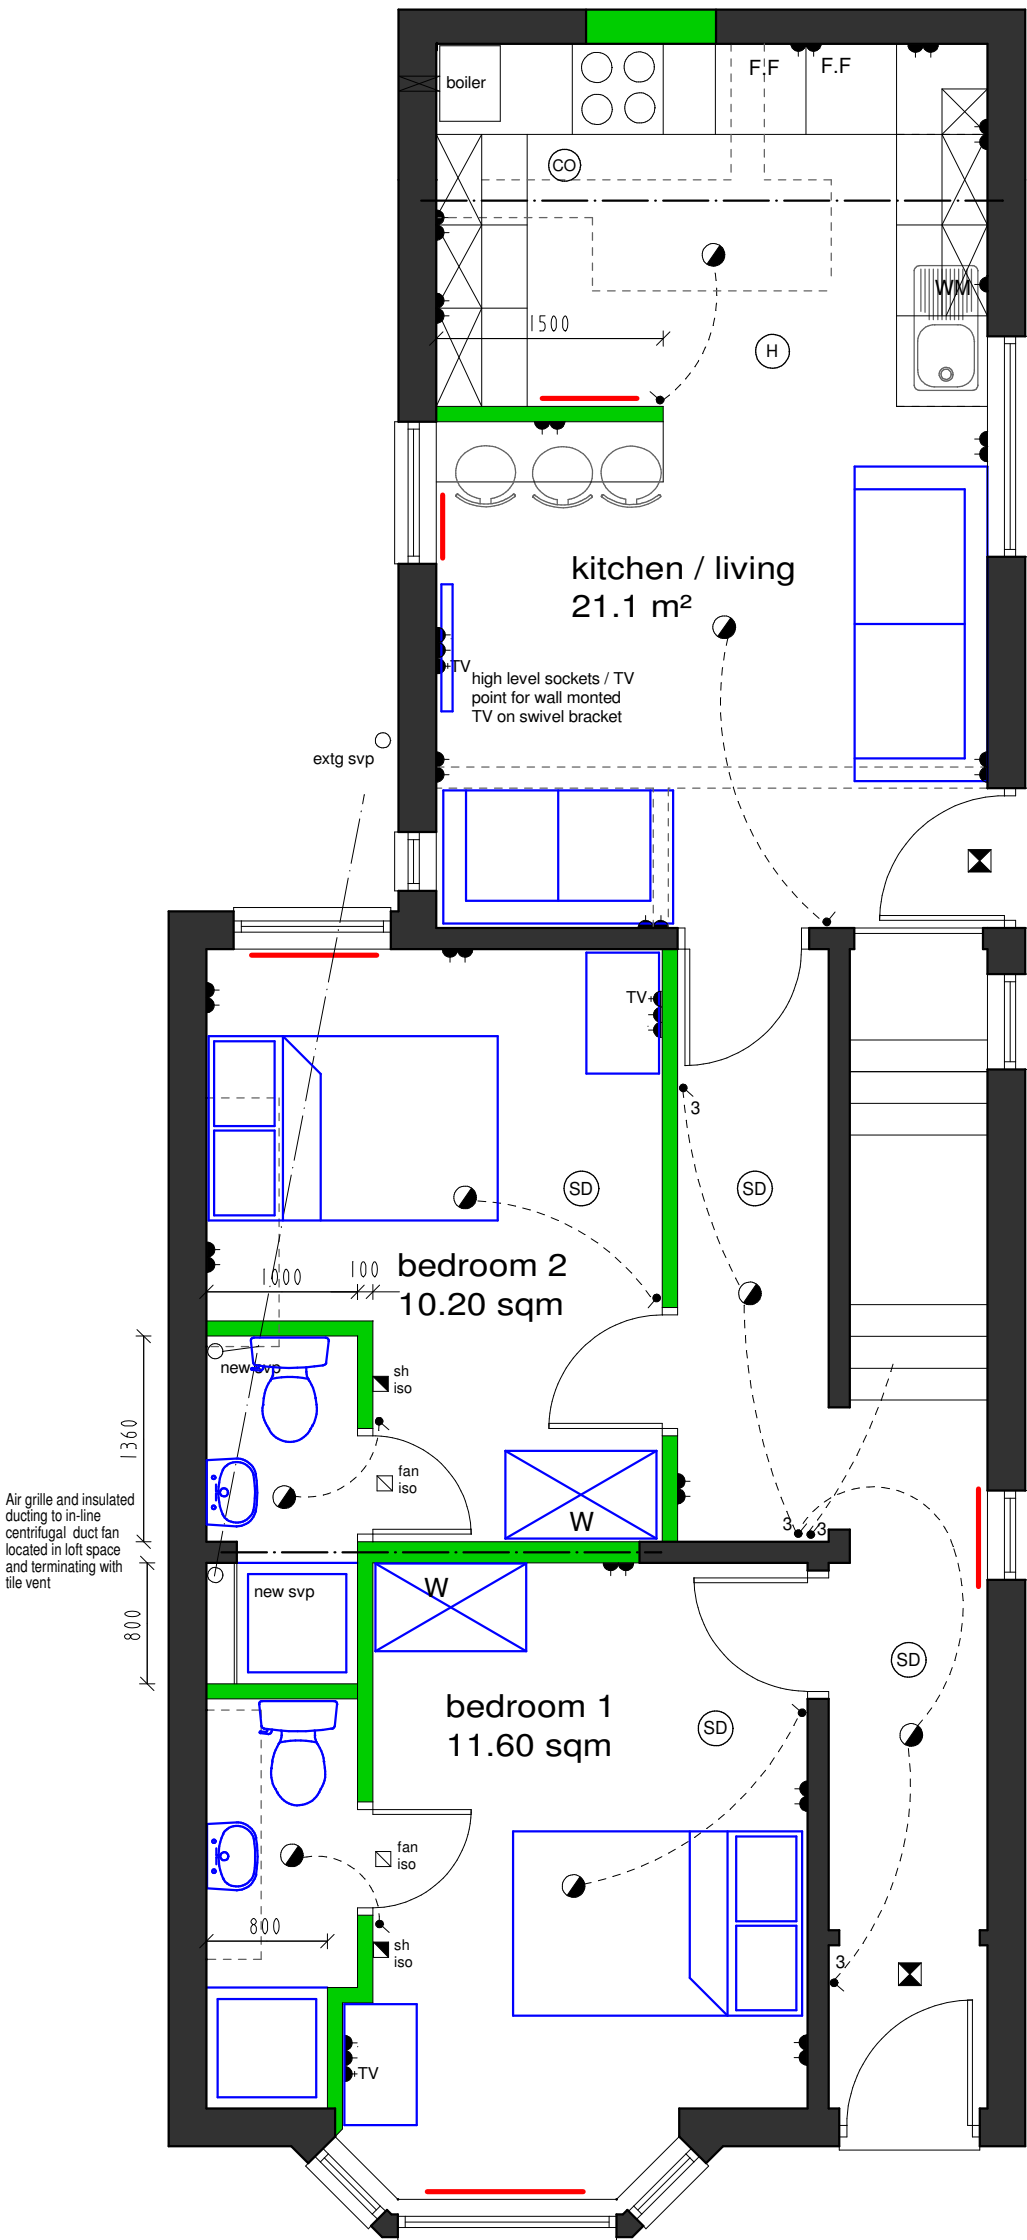

Ground Floor Plan


extg
mh

- (SD) Smoke Detector
 - (CO) Carbon Monoxide Detector
 - (H) Rate Of Rise Heat Detector
- All of the above are to be mains wired, interconnected

chimney breasts removed and steel supports installed to structural engineers details

En-suites to have extract ventilation - 15L/sec
Kitchen to have extract ventilation - 30L/sec adjacent to the hob or 60L/sec elsewhere

EM
LIGHT

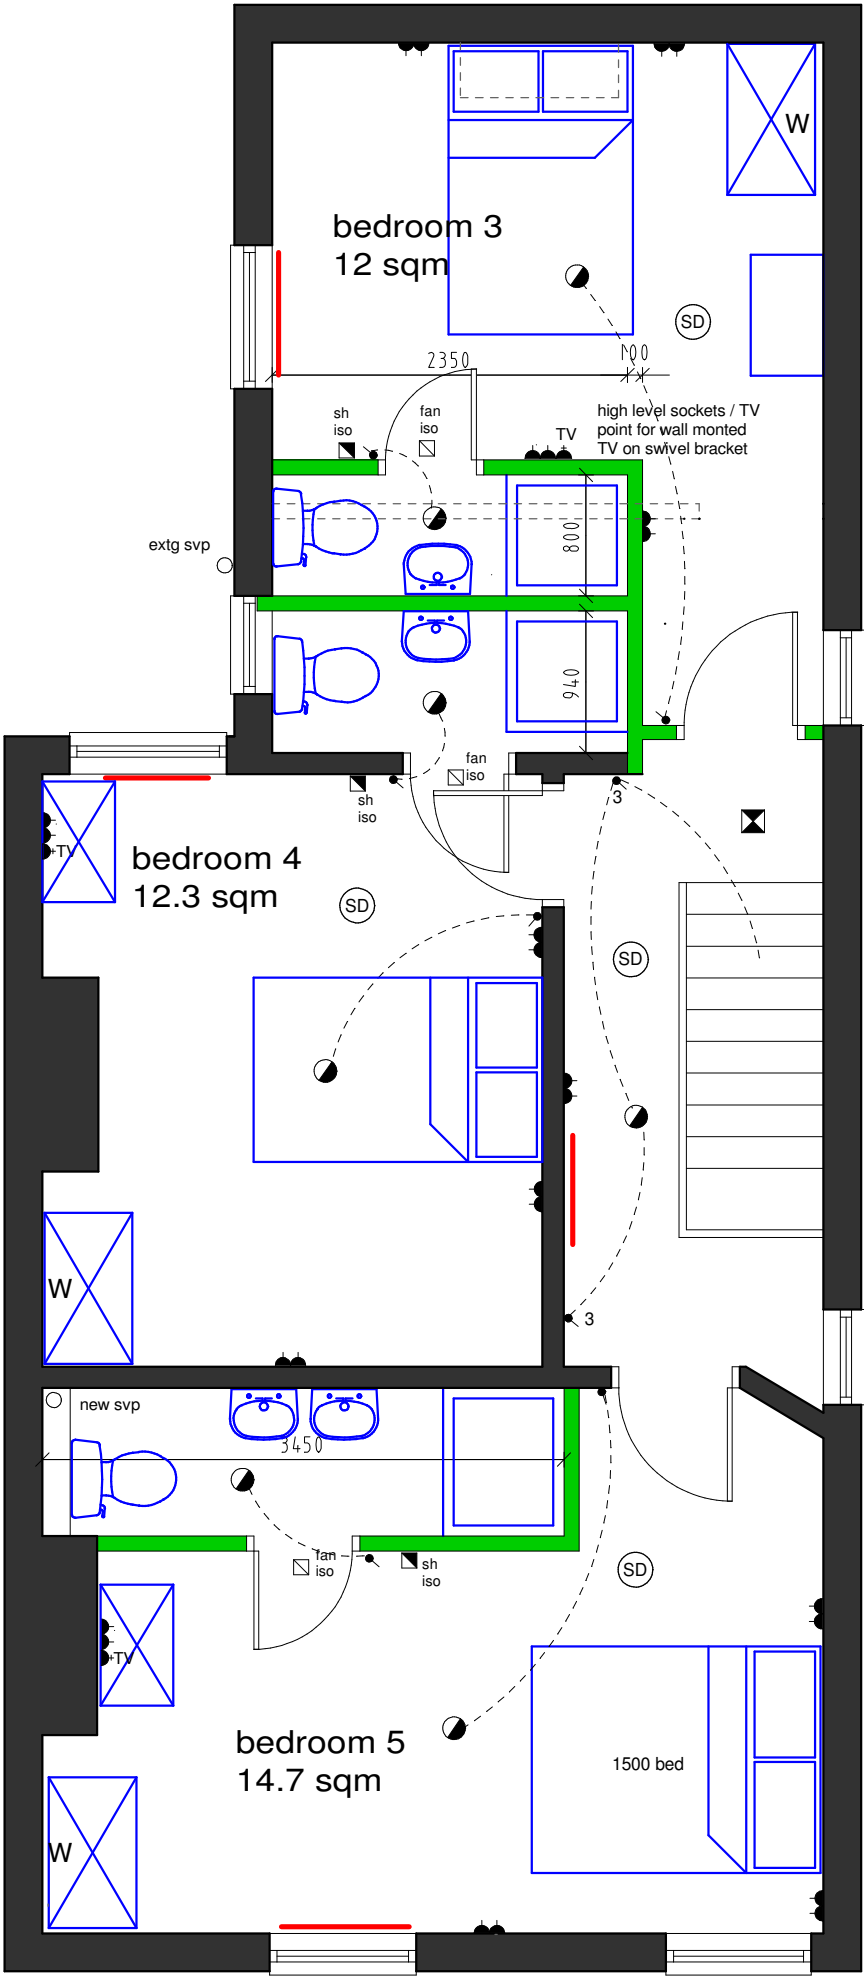

First Floor Plan

FOOT FORWARD PROPERTY INVESTMENTS

15 LORNE ROAD
THURNSCOE
BARNSELEY
S63 0RQ

PROPOSED PLANS

scale	date	drawn	checked
1:50 @ A3	APRIL 20	PB	
drawing no	revision		
FF - 144 - 2	A		

C3 Architecture Planning
& Design

Tel 07963 686613
web www.c3planninganddesign.co.uk
email info@c3planninganddesign.co.uk