


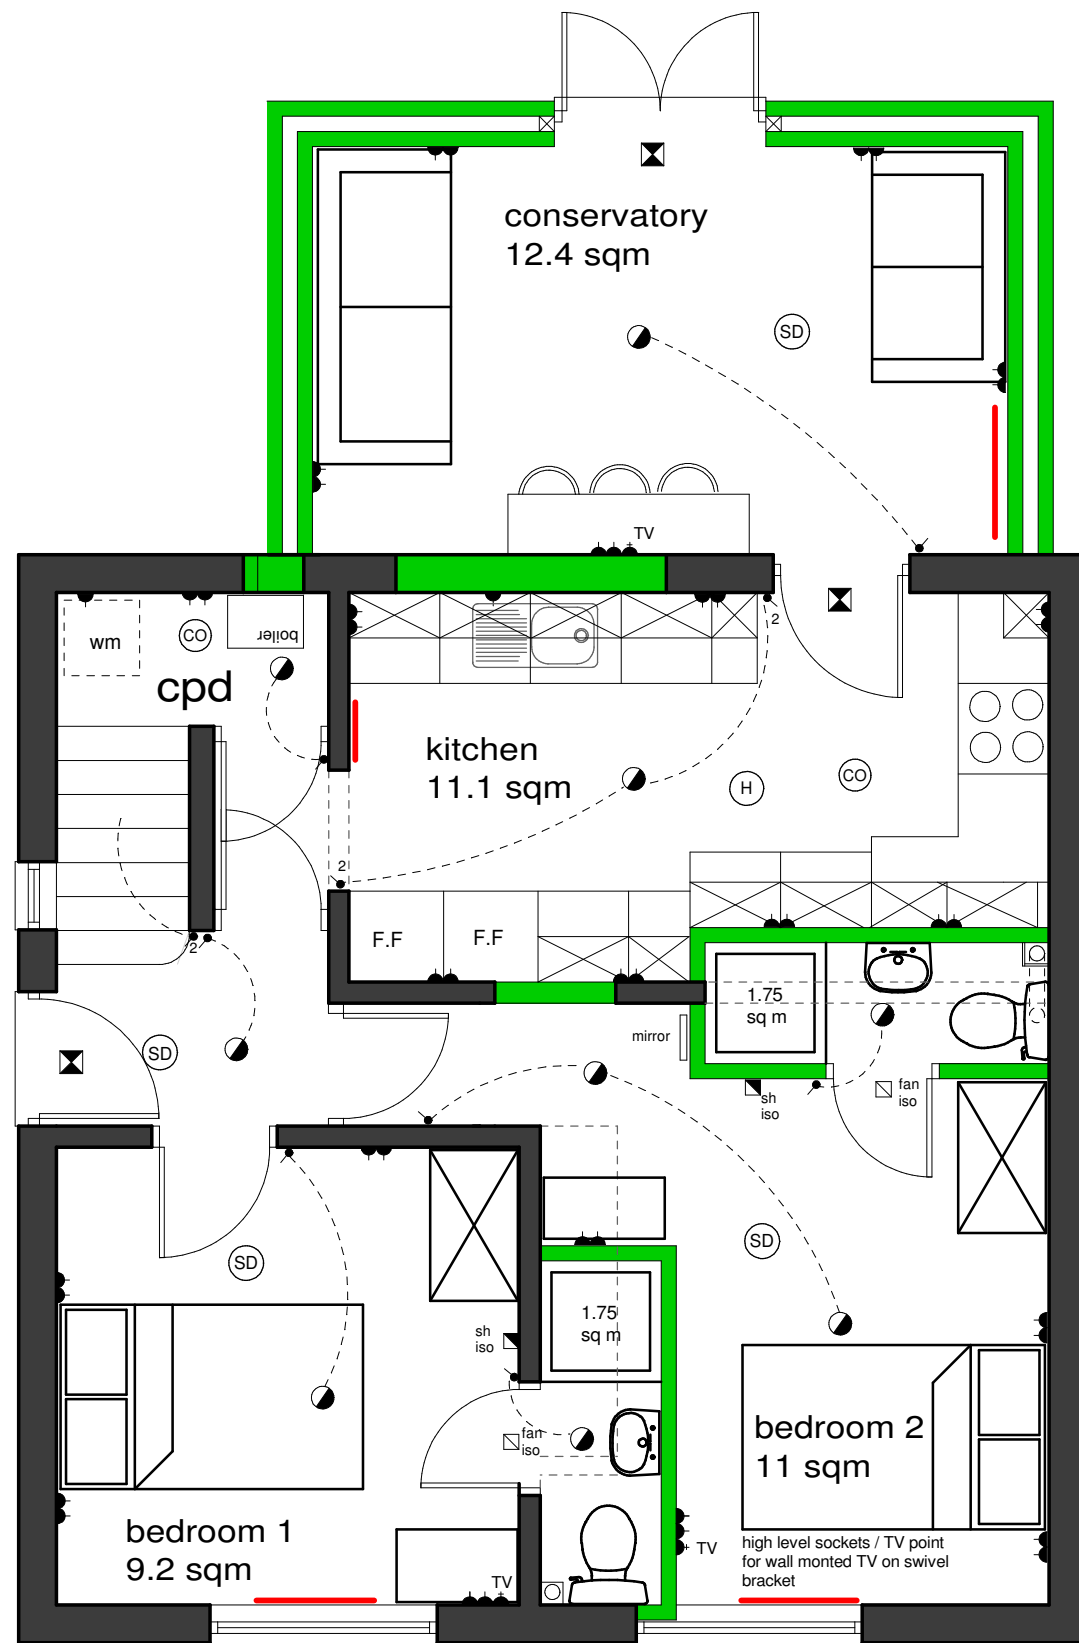


Ground Floor Plan

- (SD) Smoke Detector
 - (CO) Carbon Monoxide Detector
 - (H) Rate Of Rise Heat Detector
- All of the above are to be mains wired, interconnected

chimney breasts removed and steel supports installed to structural engineers details

En-suites to have extract ventilation - 15L/sec
 Kitchen to have extract ventilation - 30L/sec adjacent to the hob or 60L/sec elsewhere
 Utility to have extract ventilation - 30 L/sec

EM LIGHT

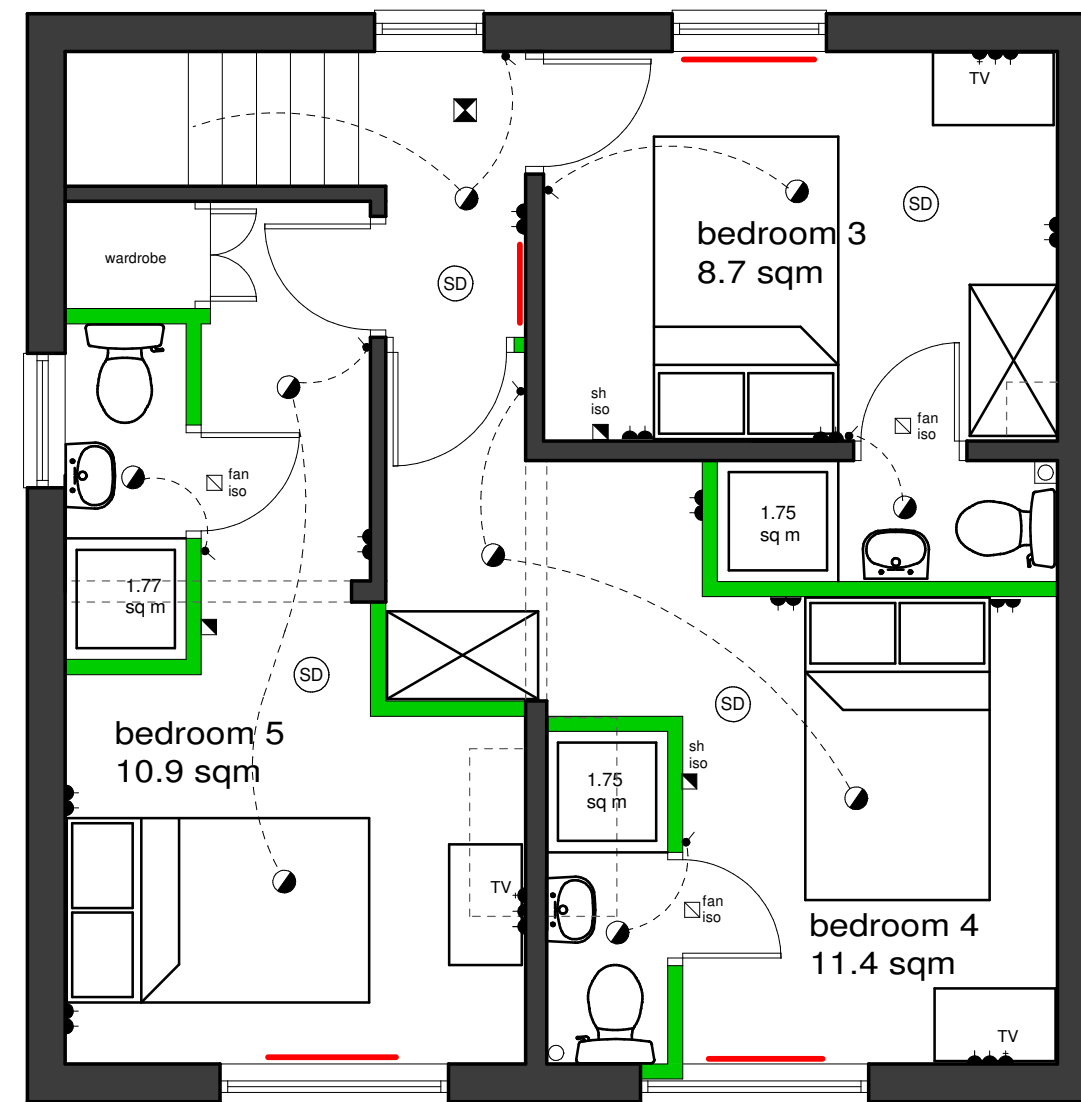

First Floor Plan

FOOT FORWARD PROPERTY INVESTMENTS

41 ROTHERHAM ROAD
 GREAT HOUGHTON
 BARNSELY

PROPOSED PLANS

scale	date	drawn	checked
1:50 @ A3	MAR 21	PB	
drawing no	revision		
FF - 162 - 2	A		

C3 Architecture Planning & Design

Tel 07963 686613
 web www.c3planninganddesign.co.uk
 email info@c3planninganddesign.co.uk