



REVISIONS		
Date	Description	By
11/03/07	Initial Survey	DS
11/03/07	Topographic Survey	DS
11/03/07	Topographic Survey	DS
11/03/07	Topographic Survey	DS

Legend:

- Planning Permissions Area
- Land Under Control of Applicant
- Top of Bank
- Top of Quarry Face
- Bottom of Bank
- Road
- Track
- Verge
- Fence Type 1
- Fence Type 2
- Fence Type 3
- Gate
- River/Stream/Cliff/Ford
- Overhead Electricity Cable
- Building
- 1m Contour Interval
- Ordinance Survey Bench Mark
- Borehole/Trial Pit
- Ordinance Survey Bench Mark
- Survey Control Station
- Electricity Pylon
- Telegraph Pole
- Lamp-post
- Man Hole
- Stop Top (Gas/Water/Felcons)
- Water Level
- Tree (proposed)

FENNELL, GREEN & BATES
25 Smyth Street
Wakefield
West Yorkshire
WF1 1ED
Tel - 01924 372197
Fax - 01924 385559
e-mail - fgb@fgb-surveyors.co.uk

Client
DTS Environmental Ltd
Recycling Centre
Shaw Lane
Carlton
Barnsley

Job Title
Agricultural Improvement

Project Title
Burntwood Road

Scale
1:1000

Date
16.03.07

Drawn by
DS

Checked
JC




Dwg. title
Topographical Survey

DWG No
DTS/BWR

Job no
04

Rev.
00

PLOT SIZE: A2. PLOT SCALE: 1:1 TYPE SCALE HERE

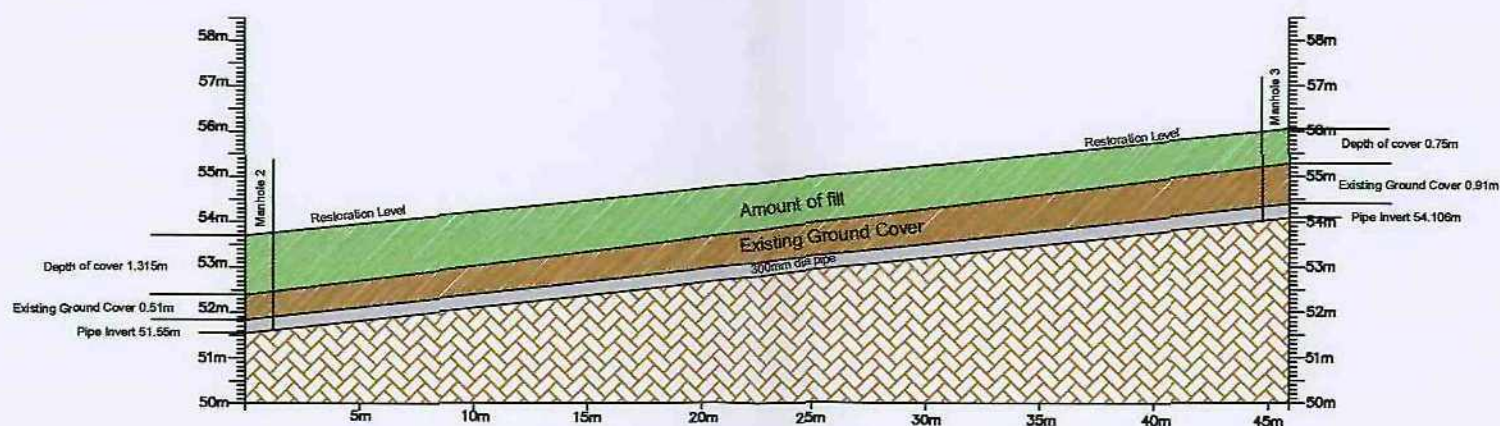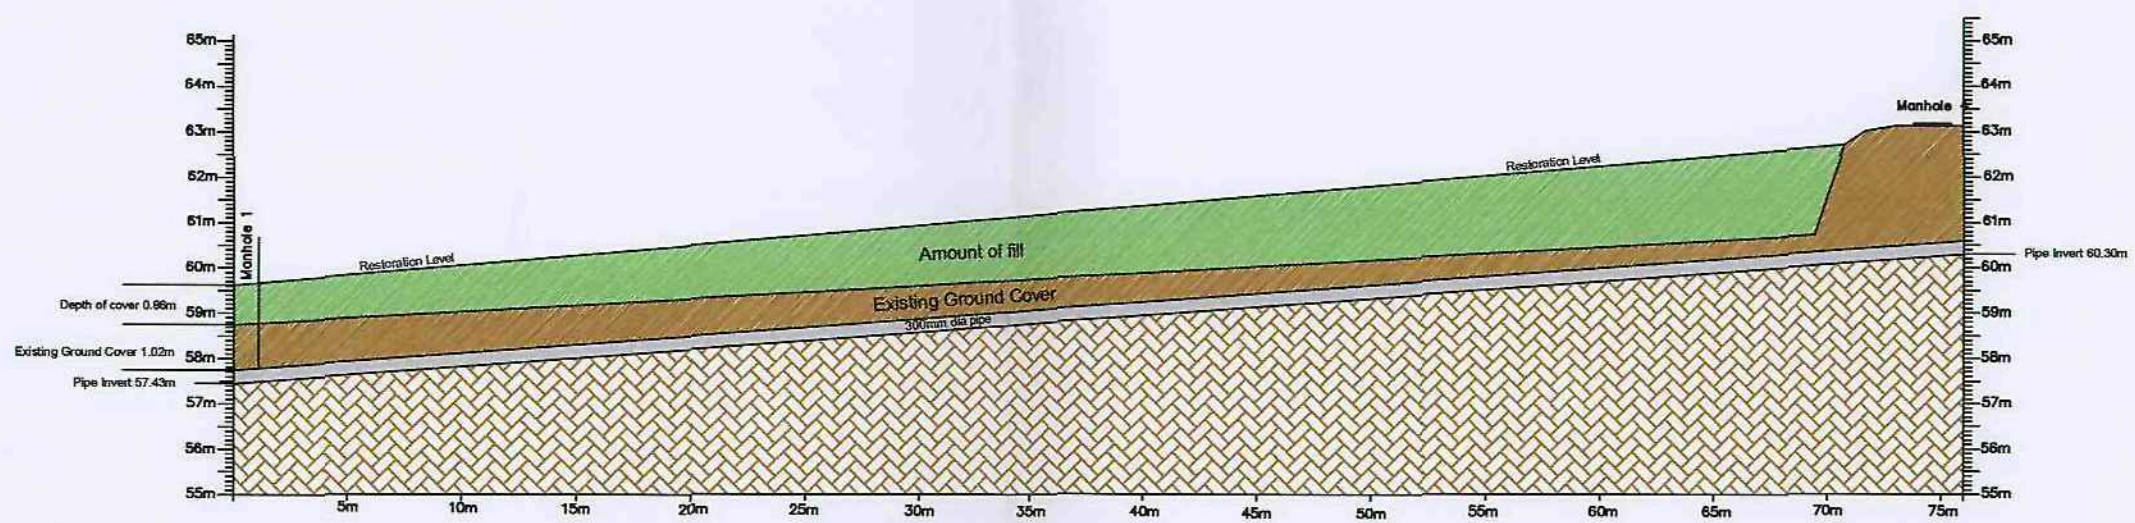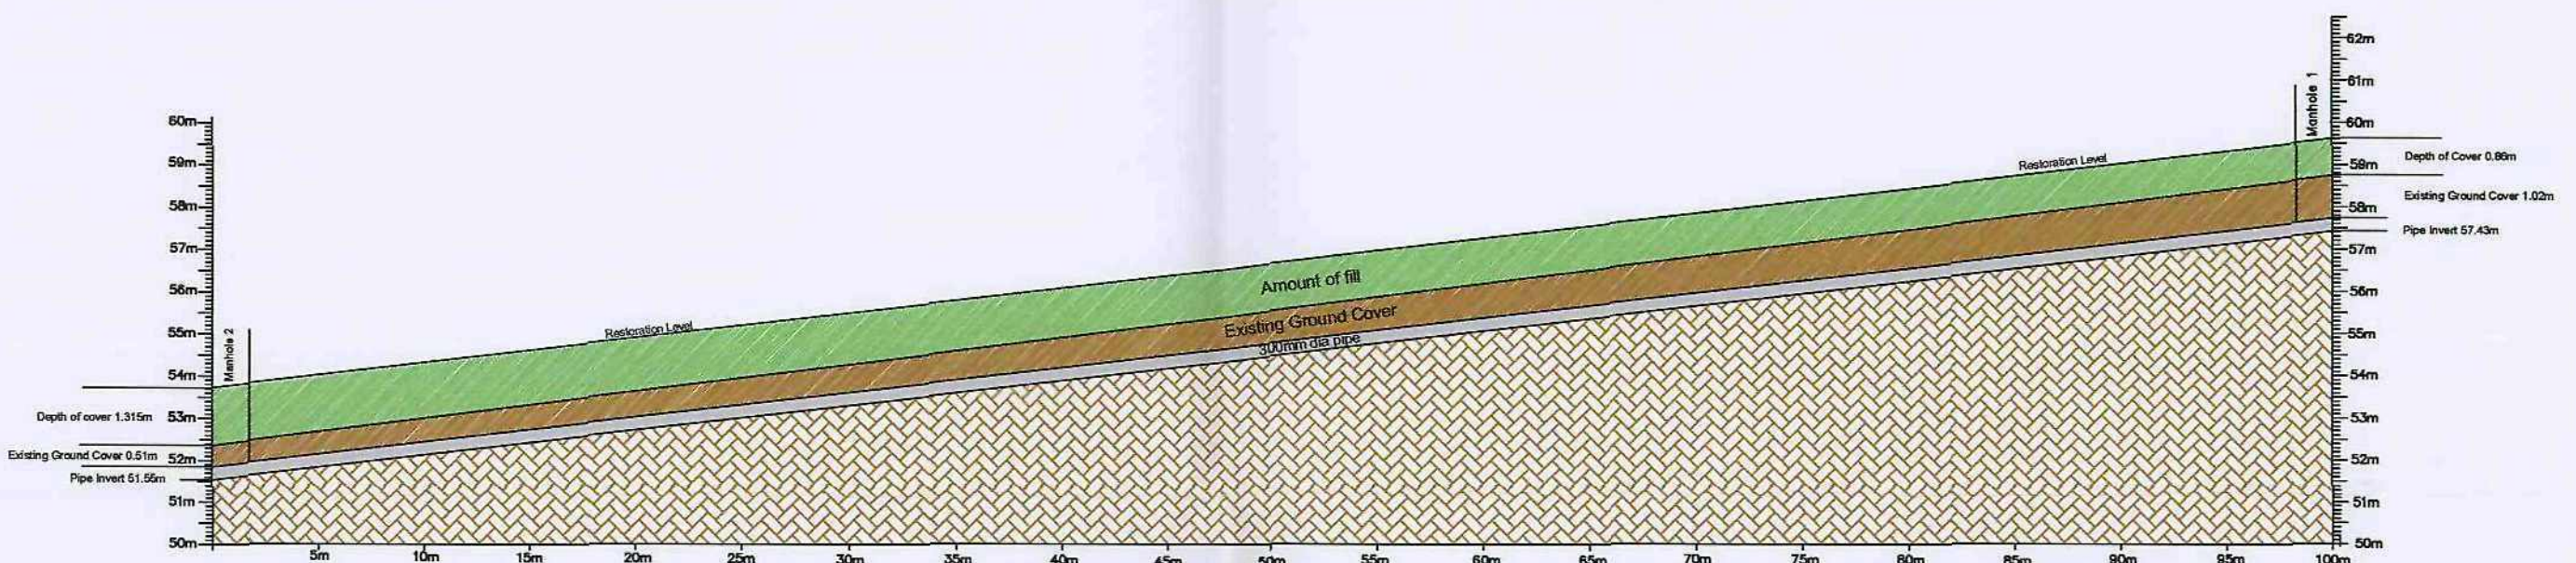

Legend:

- Planning Permissions Area
- Land Under Control of Applicant
- Top of Bank
- Top of Quarry face
- Bottom of Bank
- Road
- Verge
- Fence Type 1
- Fence Type 2
- Fence Type 3
- Gate
- Row of Stones/Block Paving
- Overhead Electricity Cable
- Building
- 1m Contour Interval
- Ordinance Survey Bench Mark
- Bench Mark/Spot PT
- Ordinance Survey Bench Mark
- Survey Control Station
- Electricity Pylon
- Telegraph Pole
- Lamp-post
- Man Hole
- Stop Tap (Gas/Water/Telecom)
- Water Level
- Tree (Groundward)

REVISIONS

Date	Description	By
11/11/07	Initial Design	FG
11/11/07	Revised Design	FG
11/11/07	Final Design	FG

FG B Fennell, Green & Bates
www.fgbsurveyors.co.uk
FENNELL, GREEN & BATES
25 Smyth Street
Wakefield
West Yorkshire
WF1 1ED
Tel - 01924 372197
Fax - 01924 385559
e-mail - fgbs@fgb-surveyors.co.uk

Client
DTS Environmental Ltd
Recycling Centre
Shaw Lane
Carlton
Barnsley

Job Title
Burtwood Road

Project Title
Agricultural Improvement

Scale
NTS

Date
Nov 2007

Drawn by
PS

Checked

Dwg. title
Drainage Cross Sections

DWG No.
DTS/BWR

Job. no.
16

Rev.
00



REVISIONS		
Date	Description	By
11/03/07	Issue for planning	DS
11/03/07	Issue for planning	DS
11/03/07	Issue for planning	DS
11/03/07	Issue for planning	DS

Legend:

Planning Permission Area	BM	Borehole/Well
Land Under Control of Applicant	BM	Ordinance Survey Bench Mark
Top of Bank	BM	Survey Control Station
Top of Quarry Face	BM	Electricity Pylon
Bottom of Bank	BM	Telegraph Pole
Track	BM	Lamp-post
Verge	BM	Man Hole
Fence Type 1	BM	Stop Tap (Gas/Water/Telecom)
Fence Type 2	BM	Water Level
Fence Type 3	BM	Tree (Broadleaved)
Gate	BM	
River/Drain/Cliff/Stream	BM	
Overhead Electricity Cable	BM	
Building	BM	
1m Contour Interval	BM	
Ordinance Survey Boundary	BM	

Client:
DTS Environmental Ltd
Recycling Centre
Shaw Lane
Carlton

Job Title:
Agricultural Improvement

Project Title:
Burntwood Road

Scale:
1:1000

Date:
16.03.07

Drawn by:
DS

Checked:
JC

Dwg title:
Phase 1 & 2 Soil Stripping and Storage

DWG No.:
DTS/BWR

Job no.:
05

Rev.:
B

PLOT SIZE: A2. PLOT SCALE: 1:1 TYPE SCALE HERE



REVISIONS		
Date	Description	By
16.03.07	Initial design	DS
16.03.07	Revised design	DS
16.03.07	Final design	DS
16.03.07	As built	DS

Legend:	
Planning Permissions Area	BM
Land Under Control of Applicant	Top of Quarry face
Top of Bank	Bottom of Bank
Bottom of Quarry face	Road
Road	Track
Track	Verge
Verge	Fence Type 1
Fence Type 1	Fence Type 2
Fence Type 2	Gate
Gate	Overhead Electricity Cable
Overhead Electricity Cable	Building
Building	1m Contour Interval
1m Contour Interval	Ordnance Survey Benchmark
Ordnance Survey Benchmark	Bonehole/Traffic Pit
Bonehole/Traffic Pit	Ordnance Survey Bench Mark
Ordnance Survey Bench Mark	Survey Control Station
Survey Control Station	Electricity Pylon
Electricity Pylon	Telegraph Pole
Telegraph Pole	Lamp-post
Lamp-post	Man Hole
Man Hole	Stop Tap (Gas/Water/Telecom)
Stop Tap (Gas/Water/Telecom)	Water Level
Water Level	Tree (Broadleaved)

FENNELL, GREEN & BATES
25 Smyth Street
Walsley
West Yorkshire
WF1 1ED
Tel - 01924 372197
Fax - 01924 385509
e-mail - fgb@fgb-surveys.co.uk

Client
DTS Environmental Ltd
Recycling Centre
Shaw Lane
Carlton

Job Title
Agricultural Improvement

Project Title
Burntwood Road

Scale
1:1000

Date
16.03.07

Drawn by
DS

Checked
JC


Dwg. title
Phase 2

DWG No.
DTS/BWR

Job no.
06

Rev.
B


PLOT SIZE: A2. PLOT SCALE: 1:1 TYPE SCALE HERE

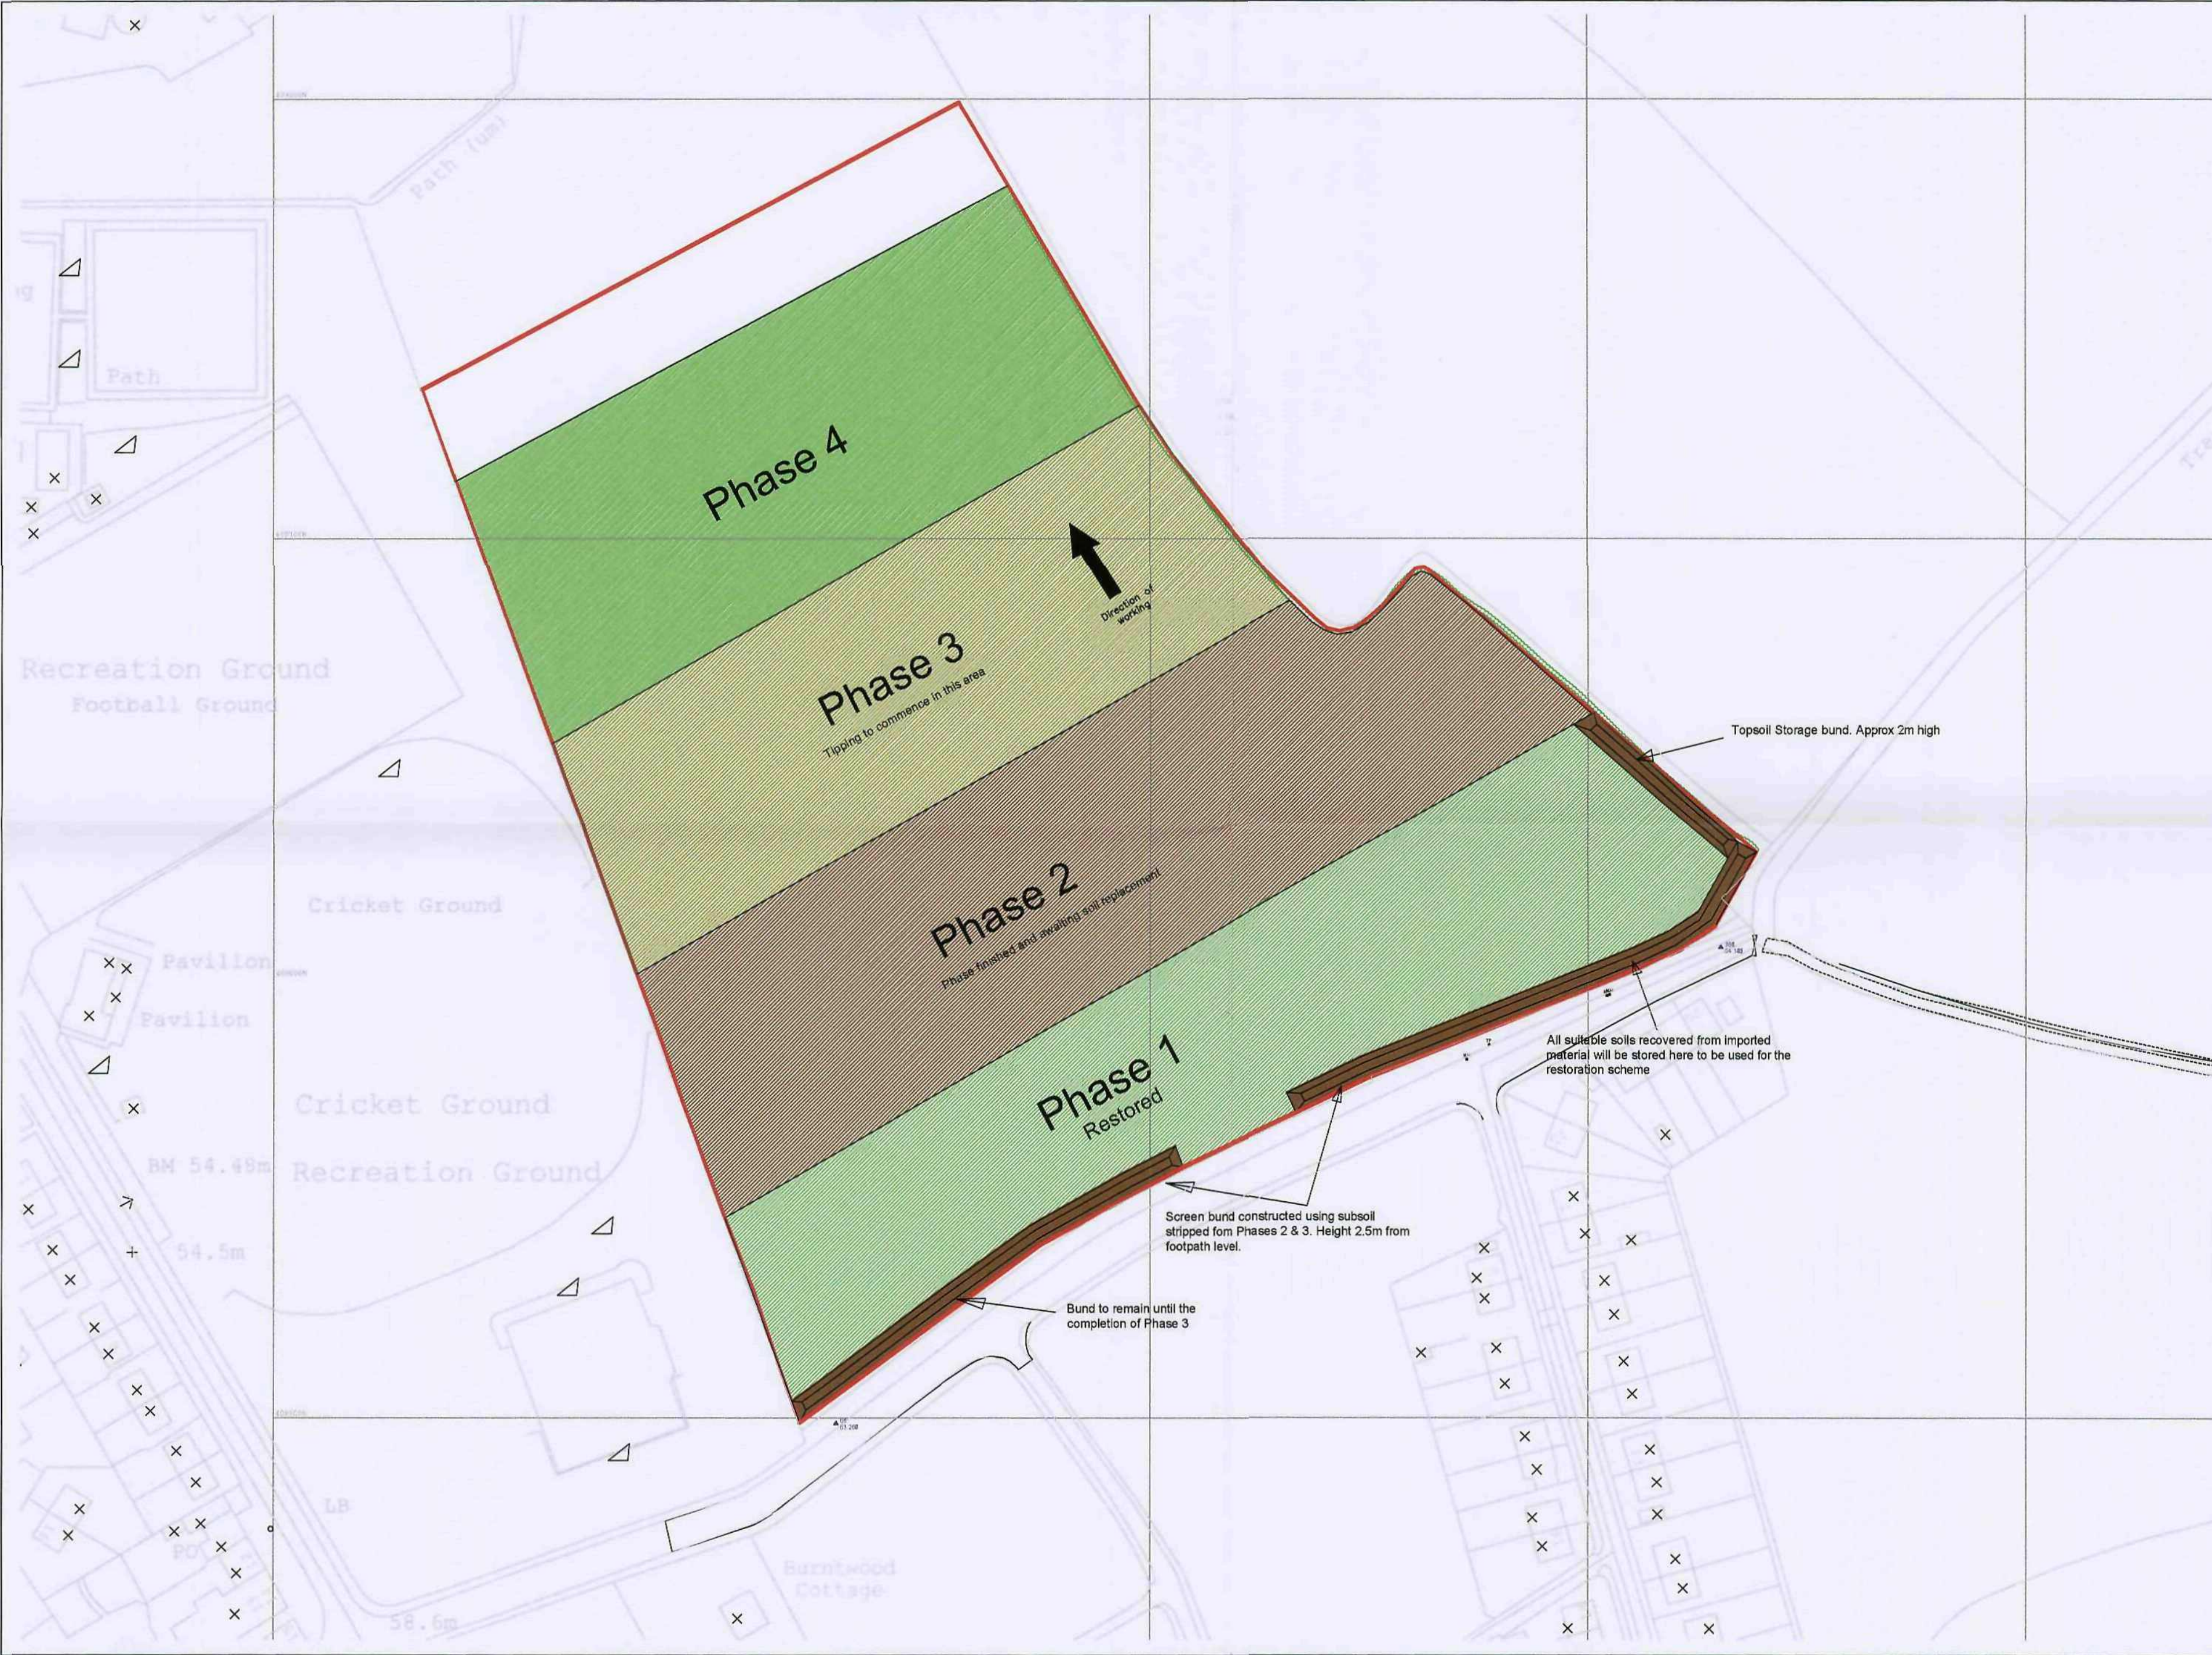

REVISIONS		
Date	Description	By
11/03/07	Issue for planning	DS
11/03/07	Issue for planning	DS
11/03/07	Issue for planning	DS
11/03/07	Issue for planning	DS
11/03/07	Issue for planning	DS

Legend:	
Planning Permissions Area	Borehole/Well Pt
Land Under Control of Applicant	Ordinance Survey Bench Mark
Top of Bank	Survey Control Station
Top of Quarry face	Electricity Pylon
Bottom of Bank	Telegraph Pole
Road	Lamp-post
Track	Man Hole
Vegetation	Stop Tap (Gas/Water/Fuel Oil)
Fence Type 1	Water Level
Fence Type 2	Tree (roadside)
Fence Type 3	
Dike	
Overhead Electricity Cable	
Building	
1m Contour Interval	
Ordinance Survey Backsight	

FENNELL, GREEN & BATES
25 Smyth Street
Wakefield
West Yorkshire
WF1 1ED
Tel - 01924 372197
Fax - 01924 385559
e-mail - fgb@fgb-surveyors.co.uk

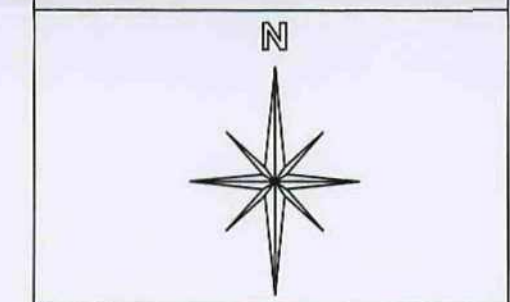

Client:
DTS Environmental Ltd
Recycling Centre
Shaw Lane
Carlton

Job Title
Agricultural Improvement

Project Title
Burntwood Road

Scale	Date	Drawn by	Checked
1:1000	16.03.07	DS	JC

Dwg. title
Phase 3

DWG No.	Job no.	Rev.
DTS/BWR	07	B

PLOT SIZE: A2. PLOT SCALE: 1:1 TYPE SCALE HERE



REVISIONS

Date	Description	By
11/03/07	Initial Design	DS
11/03/07	Revised Design	DS
11/03/07	Final Design	DS
11/03/07	As Built	DS

Legend:

Planning Permission Area

Land Under Control of Applicant

Top of Bank

Top of Quarry face

Bottom of Bank

Road

Track

Verge

Fence Type 1

Fence Type 2

Fence Type 3

Gale

Overhead Electric Cable

Building

1m Contour Interval

Ordnance Survey Backsight

BM

OTF

ORF

OTF

LP

MP

ST

WC

Tree (roadside)

Borehole/Well Pit

Ordnance Survey Bench Mark

Survey Control Station

Electricity Pylon

Telegraph Pole

Lamp post

Man Hole

Stop Tap (Gas/Water/Telecom)

Water Level

FENNELL, GREEN & BATES

25 Smyth Street

Wakefield

West Yorkshire

WF1 1ED

Tel - 01924 372197

Fax - 01924 385559

e-mail - fgb@fgb-surveyors.co.uk

Client

DTS

28 Westgate

Monk Bretton

Job Title

Agricultural Improvement

Project Title

Burntwood Road

Scale

1:1000

Date

16.03.07

Drawn by

DS

Checked

JC

Dwg. title

Phase 4

DWG No.

DTS/BWR

Job. no.




08

Rev.

B

PLOT SIZE: A2

PLOT SCALE: 1:1 TYPE SCALE HERE

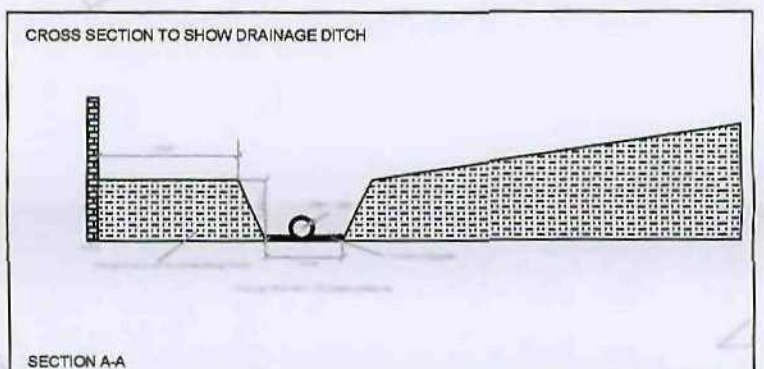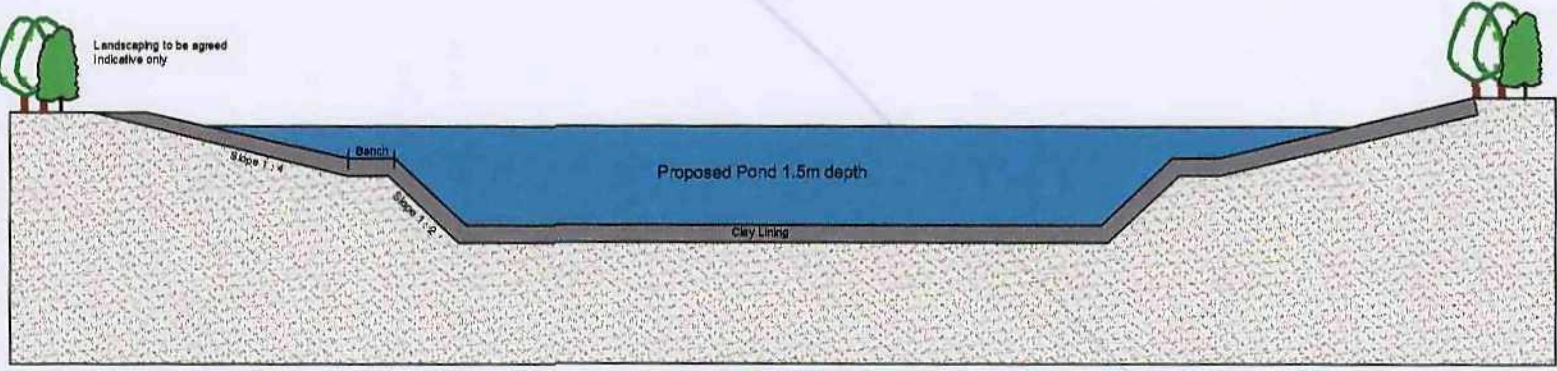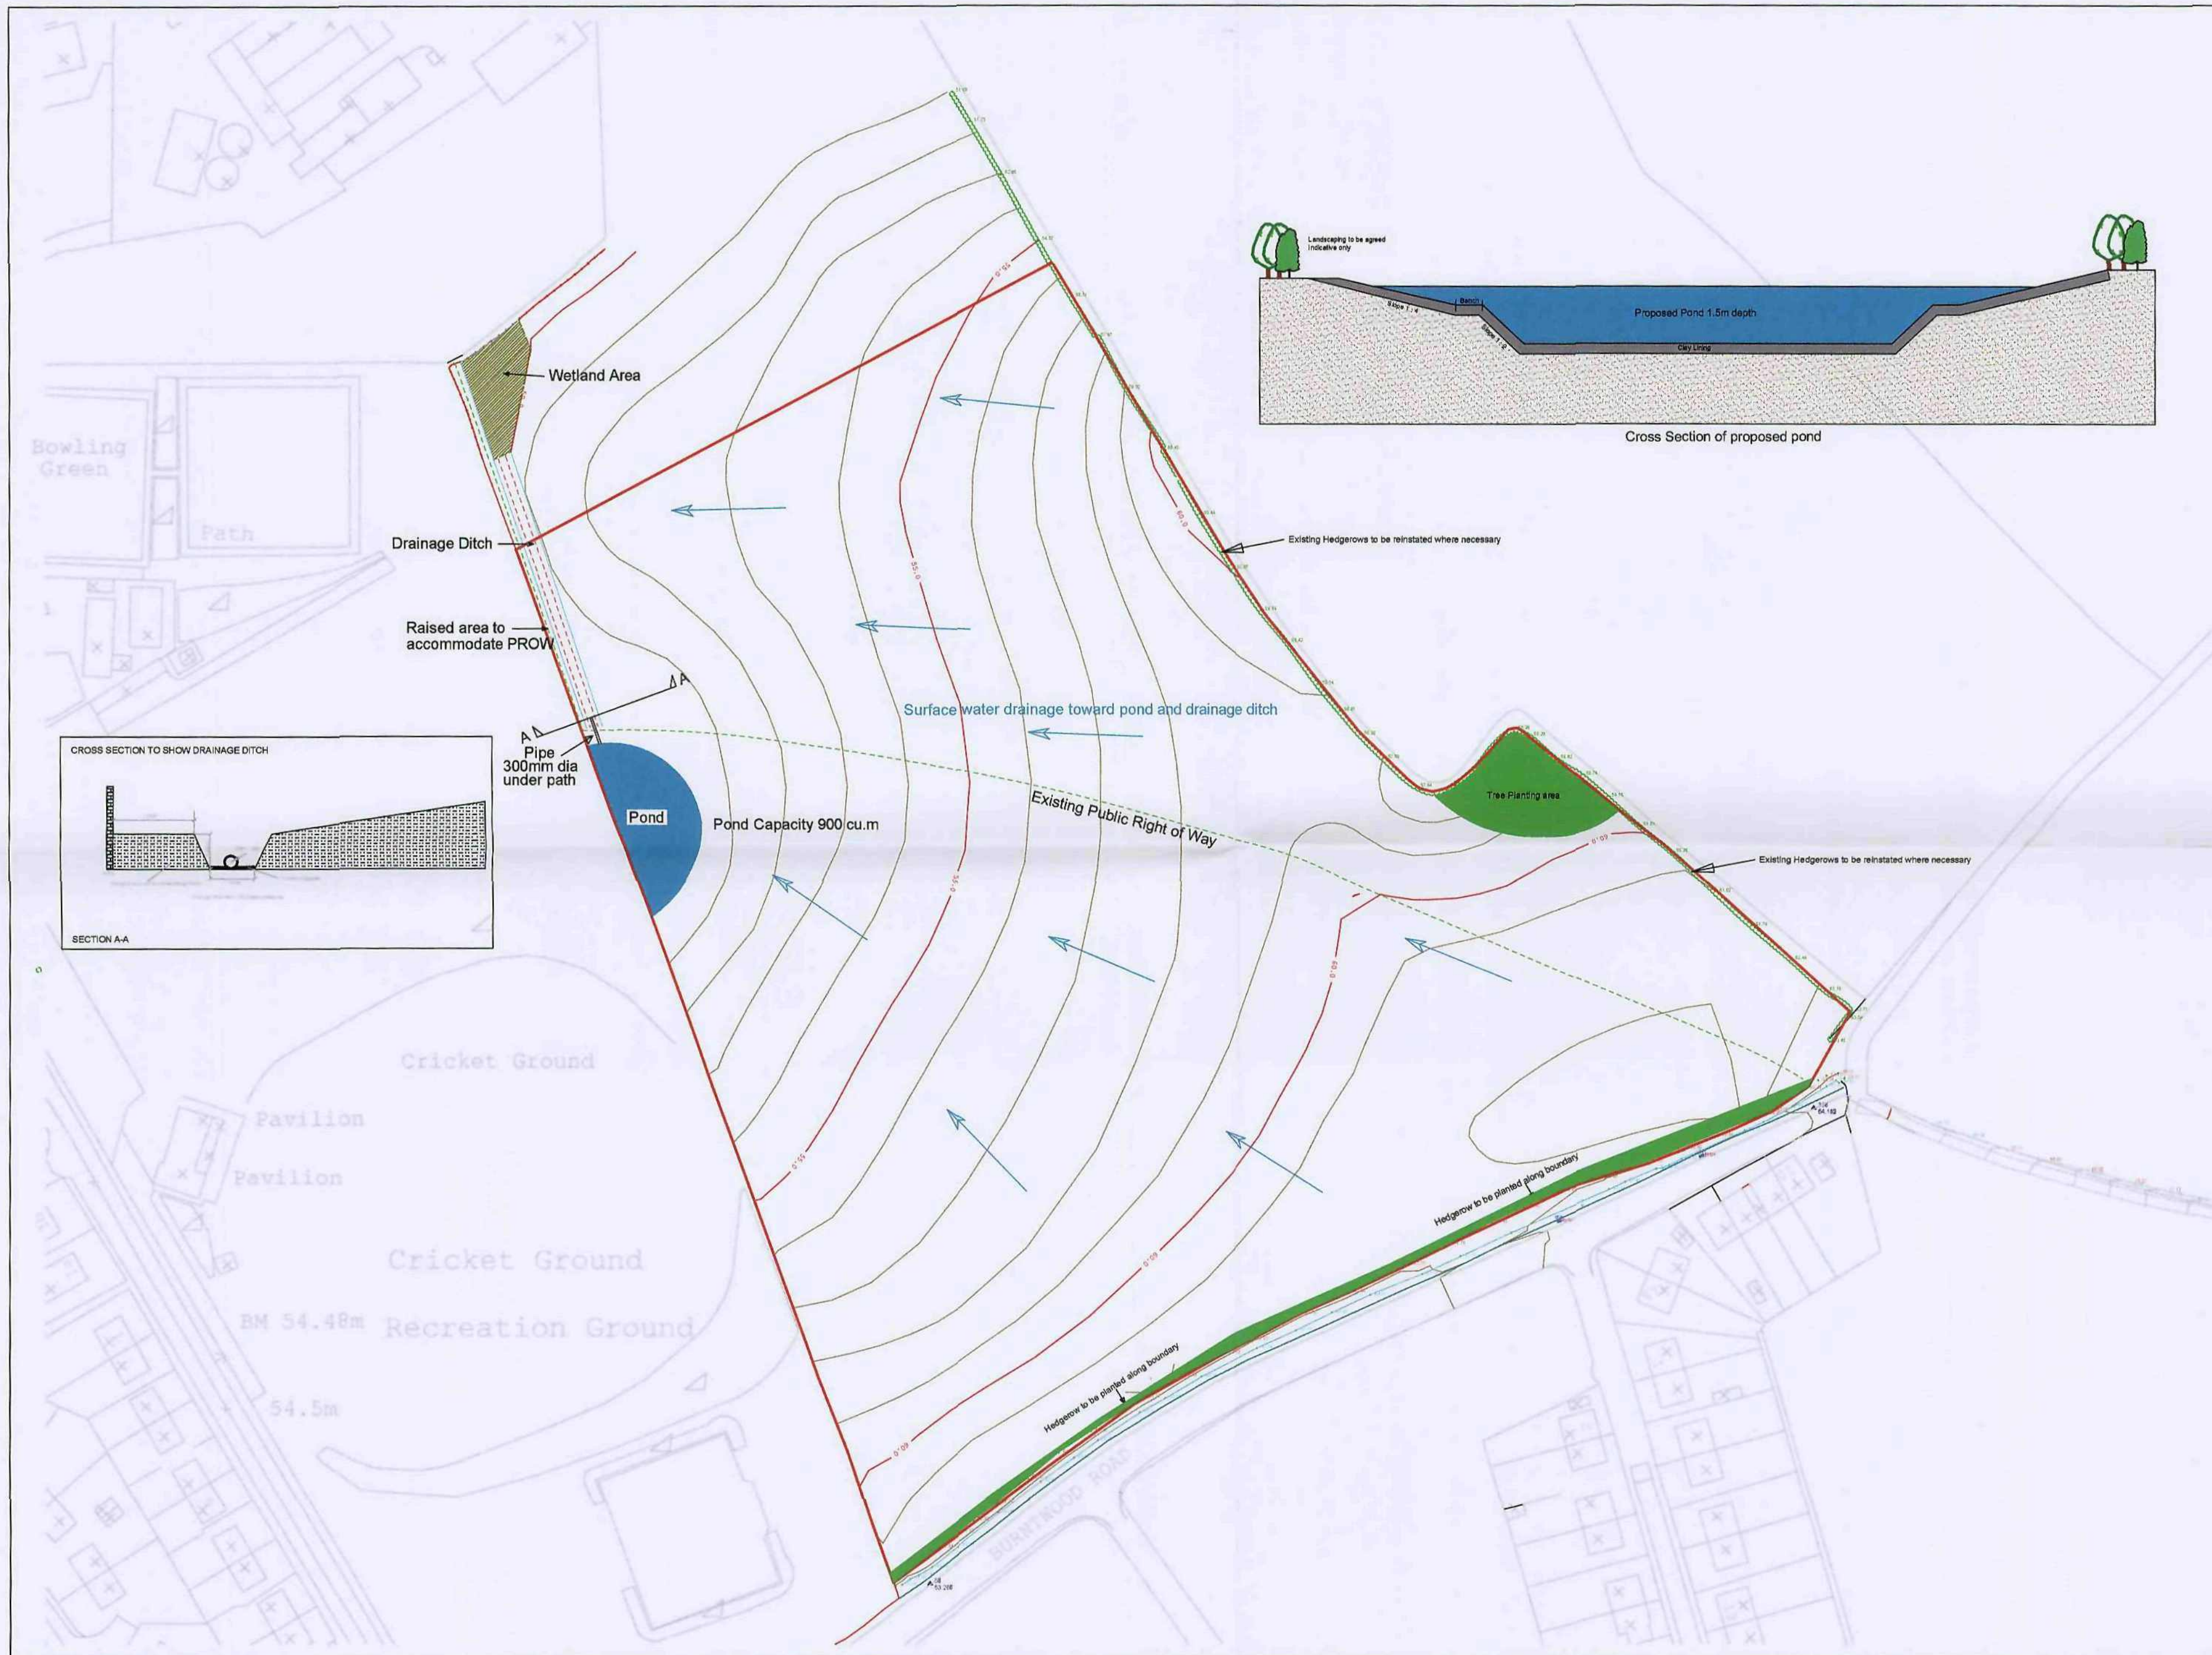

REVISIONS		
Date	Description	By

Legend:

- Planning Permissions Area
- Land Under Control of Applicant
- Top of Bank
- Top of Quarry face
- Bottom of Bank
- Road
- Track
- Verge
- Fence Type 1
- Fence Type 2
- Fence Type 3
- Gate
- River/Stream/Channel
- Overhead Electricity Cable
- Building
- 1m Contour Interval
- Ordnance Survey Backsight
- Borehole/Trail Pit
- Ordnance Survey Bench Mark
- Survey Control Station
- Electricity/Pylon
- Telegraph Pole
- Lamp-post
- Man Hole
- Stop Top (Gas/Water/Falcon)
- Water Level
- Tree (roadside)
- Tree Planting area
- Drainage flow

North Arrow

FENNELL, GREEN & BATES
 25 Smyth Street
 Wakefield
 West Yorkshire
 WF1 1ED
 Tel - 01924 372197
 Fax - 01924 385559
 e-mail - fgb@fgb-surveyors.co.uk

Client:
DTS
Westgate
Monk Bretton
Barnsley
S71 2DJ

Job Title:
Burntwood Road, Grimethorpe


Project Title:
Restoration Design

Scale	Date	Drawn by	Checked
1:1000	01.03.07	DS	JC


Dwg. title:
Final Restoration Contours

DWG No.	Job no.	Rev.
DTS/BWR	09	A


PLOT SIZE: A2, PLOT SCALE: 1:1 TYPE SCALE HERE

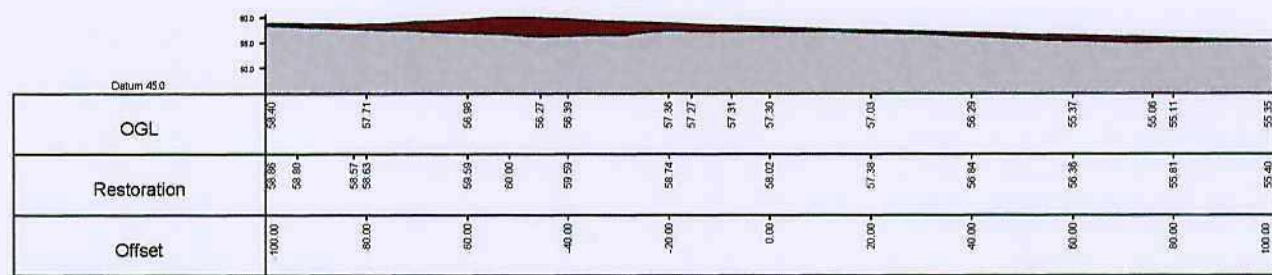


Section No. 5 Chainage 200.0m (441680.7E 409030.3N)

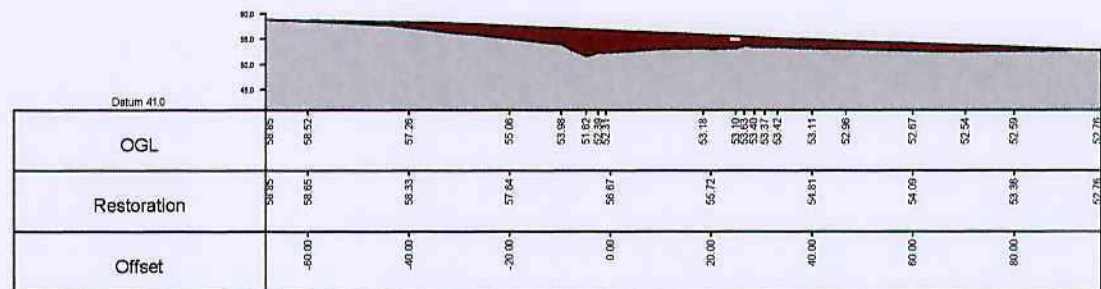


Section No. 4 Chainage 160.0m (441661.5E 409065.4N)

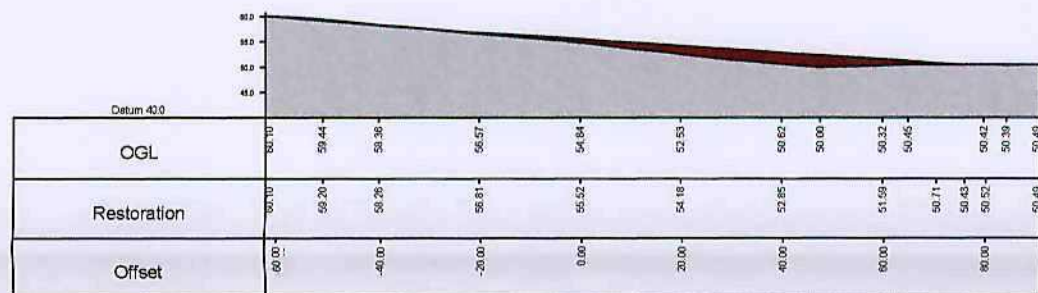


Section No. 3 Chainage 120.0m (441642.4E 409100.5N)

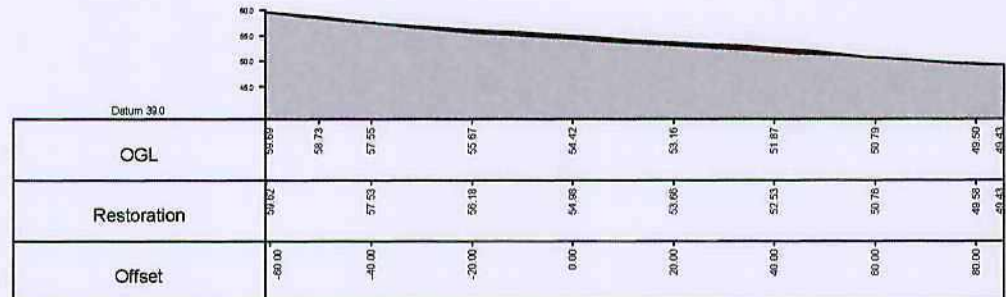


Section No. 2 Chainage 80.0m (441623.2E 409135.7N)

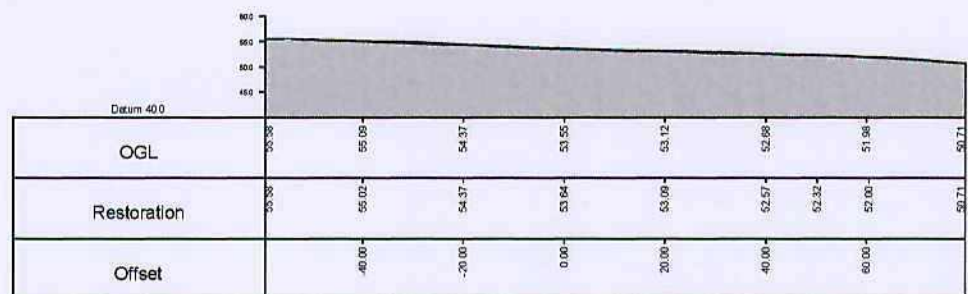

Section No. 1 Chainage 40.0m (441604.1E 409170.8N)

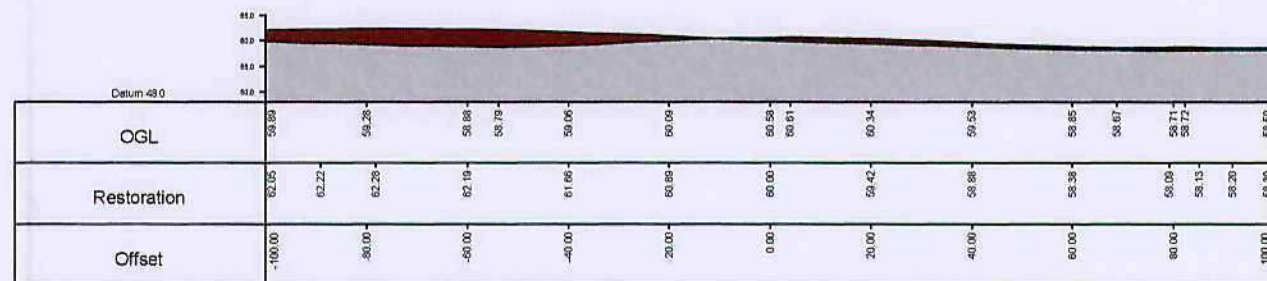


Section No. 6 Chainage 240.0m (441699.8E 408995.2N)

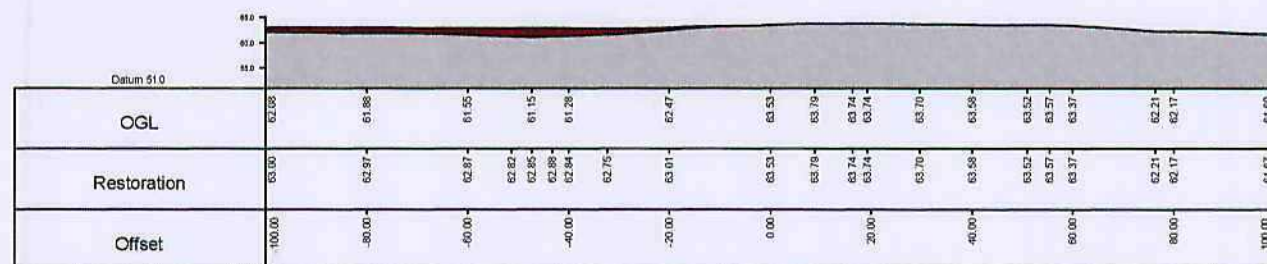

Section No. 7 Chainage 280.0m (441719.0E 408960.1N)

REVISIONS		
Date	Description	By

Legend:	
Planning Permissions Area	BN Branches/Tidal PE
Land Under Control of Applicant	BM Ordnance Survey Bench Mark
Top of Bank	Survey Control Station
Top of Quarry Box	Electricity Pylon
Bottom of Bank	TM Telegraph Pole
Road	LP Lamp-post
Track	Man Hole
Verge	ST Stop Tap (Gas/Water/Telecom)
Fence Type 1	WL Water Level
Fence Type 2	Time (Broadcast)
Fence Type 3	
Gate	
River/stream/Ditch/pond	
Overhead Electricity Cable	
Building	
1m Contour Interval	
Ordnance Survey Boundary	

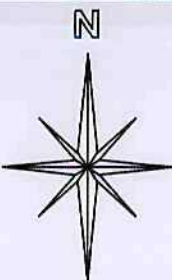

FENNELL, GREEN & BATES
25 Smyth Street
Wakefield
West Yorkshire
WF1 1ED
Tel - 01924 372197
Fax - 01924 365559
e-mail - fg@fgb-surveyors.co.uk

Client
DTS Environmental Ltd
Recycling Centre
Shaw Lane
Carlton
Barnsley

Job Title
Agricultural Improvement


Project Title
Burntwood Road

Scale	Date	Drawn by	Checked
1:1500	30.04.07	DS	PS

Dwg. Title
Cross Sections

DWG No.	Job No.	Rev.
DTS/BWR	10	00

PLOT SIZE: A2. PLOT SCALE: 1:TYPE SCALE HERE

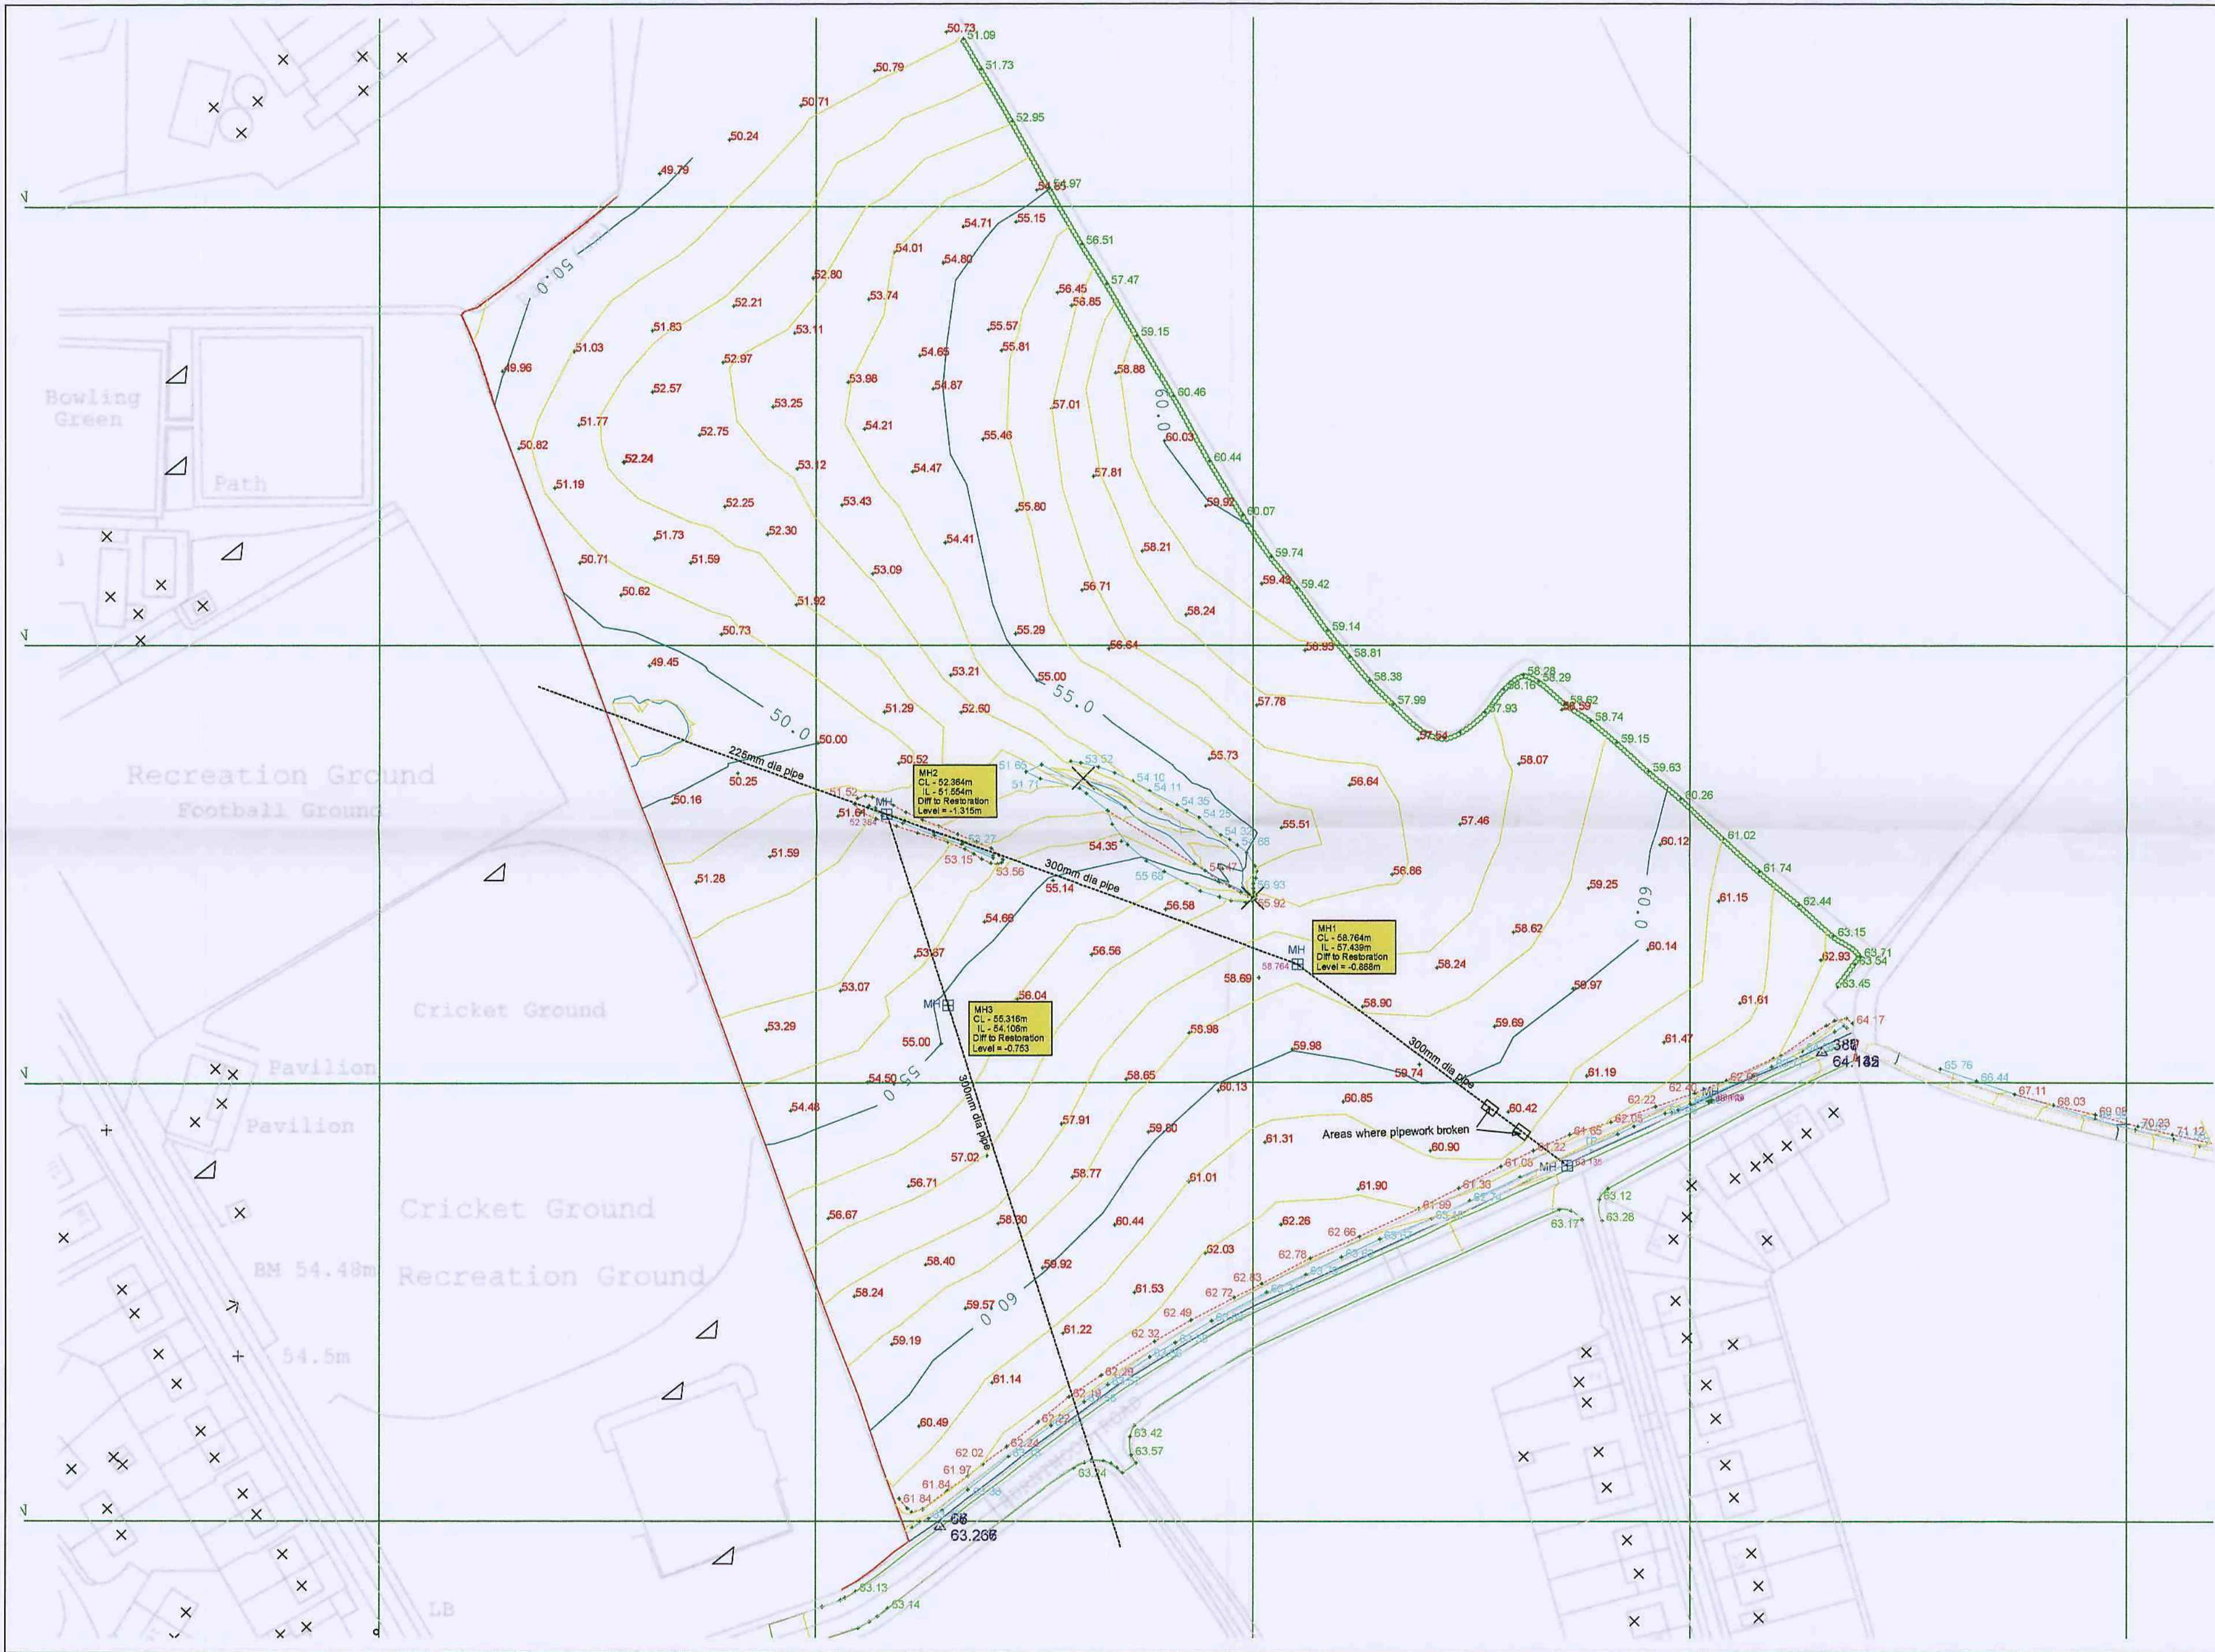

REVISIONS

Date	Description	By
11/11/07		
11/11/07		
11/11/07		
11/11/07		
11/11/07		

Legend:

Planning Permission Area

Land Under Control of Applicant

Top of Bank

Top of Quarry Area

Bottom of Bank

Road

Track

Verge

Fence Type 1

Fence Type 2

Fence Type 3

Gate

River/Stream/Ditch/Pond

Overhead Electricity Cable

Building

1m Contour Interval

Ordnance Survey Boundary

Borehole/Trail Pt

Ordnance Survey Bench Mark

Survey Control Station

Electricity Pylon

TP

Telegraph Pole

Lamp-post

Man Hole

Stop Top (Gas/Water/Telecom)

Water Level

Tree (Broadleaved)

N

PENNELL, GREEN & BATES

25 Smyth Street

Wakefield

West Yorkshire

WF1 1ED

Tel - 01924 372197

Fax - 01924 385559

e-mail - tpb@tpb-surveys.co.uk

Client

DTS Environmental Ltd

Recycling Centre

Shaw Lane

Carlton

Barnsley

Job Title

Burntwood Road, Grimethorpe

Project Title

Agricultural Improvement

Scale

1:1000

Date

Nov 07

Drawn by

PS

Checked

Dwg. title

Existing Drainage Layout

DWG No.

DTS/BWR

Job. no.

13

Rev.

00

PLOT SIZE: A2 - PLOT SCALE: 1:1 TYPE SCALE: HERE