


DO NOT SCALE FROM THIS DRAWING. VERIFY ALL DIMENSIONS AND SETTING OUT ON SITE. NOTIFY ANY DISCREPANCIES TO THE ARCHITECT FOR HEALTH & SAFETY INFORMATION. REFER TO HEALTH & SAFETY RISK ASSESSMENTS.

THIS DRAWING HAS BEEN PREPARED TO ASSIST THE CONTRACTOR IN PREPARING A DESIGN AND BUILD TENDER AND IS NOT INTENDED TO BE A FINAL CONSTRUCTION DRAWING. ALL DETAILS SHOWN ARE SUBJECT TO DESIGN DEVELOPMENT.

 
FOR STRUCTURAL DETAILS REFER TO THE CONSULTING STRUCTURAL & CIVIL ENGINEERING DETAILED DESIGN DRAWINGS & SPECIFICATIONS.

FOR M/E INFORMATION, REFER TO BME M/E ENGINEERS AND SUB CONTRACTOR'S DESIGN DRAWINGS & SPECIFICATIONS.

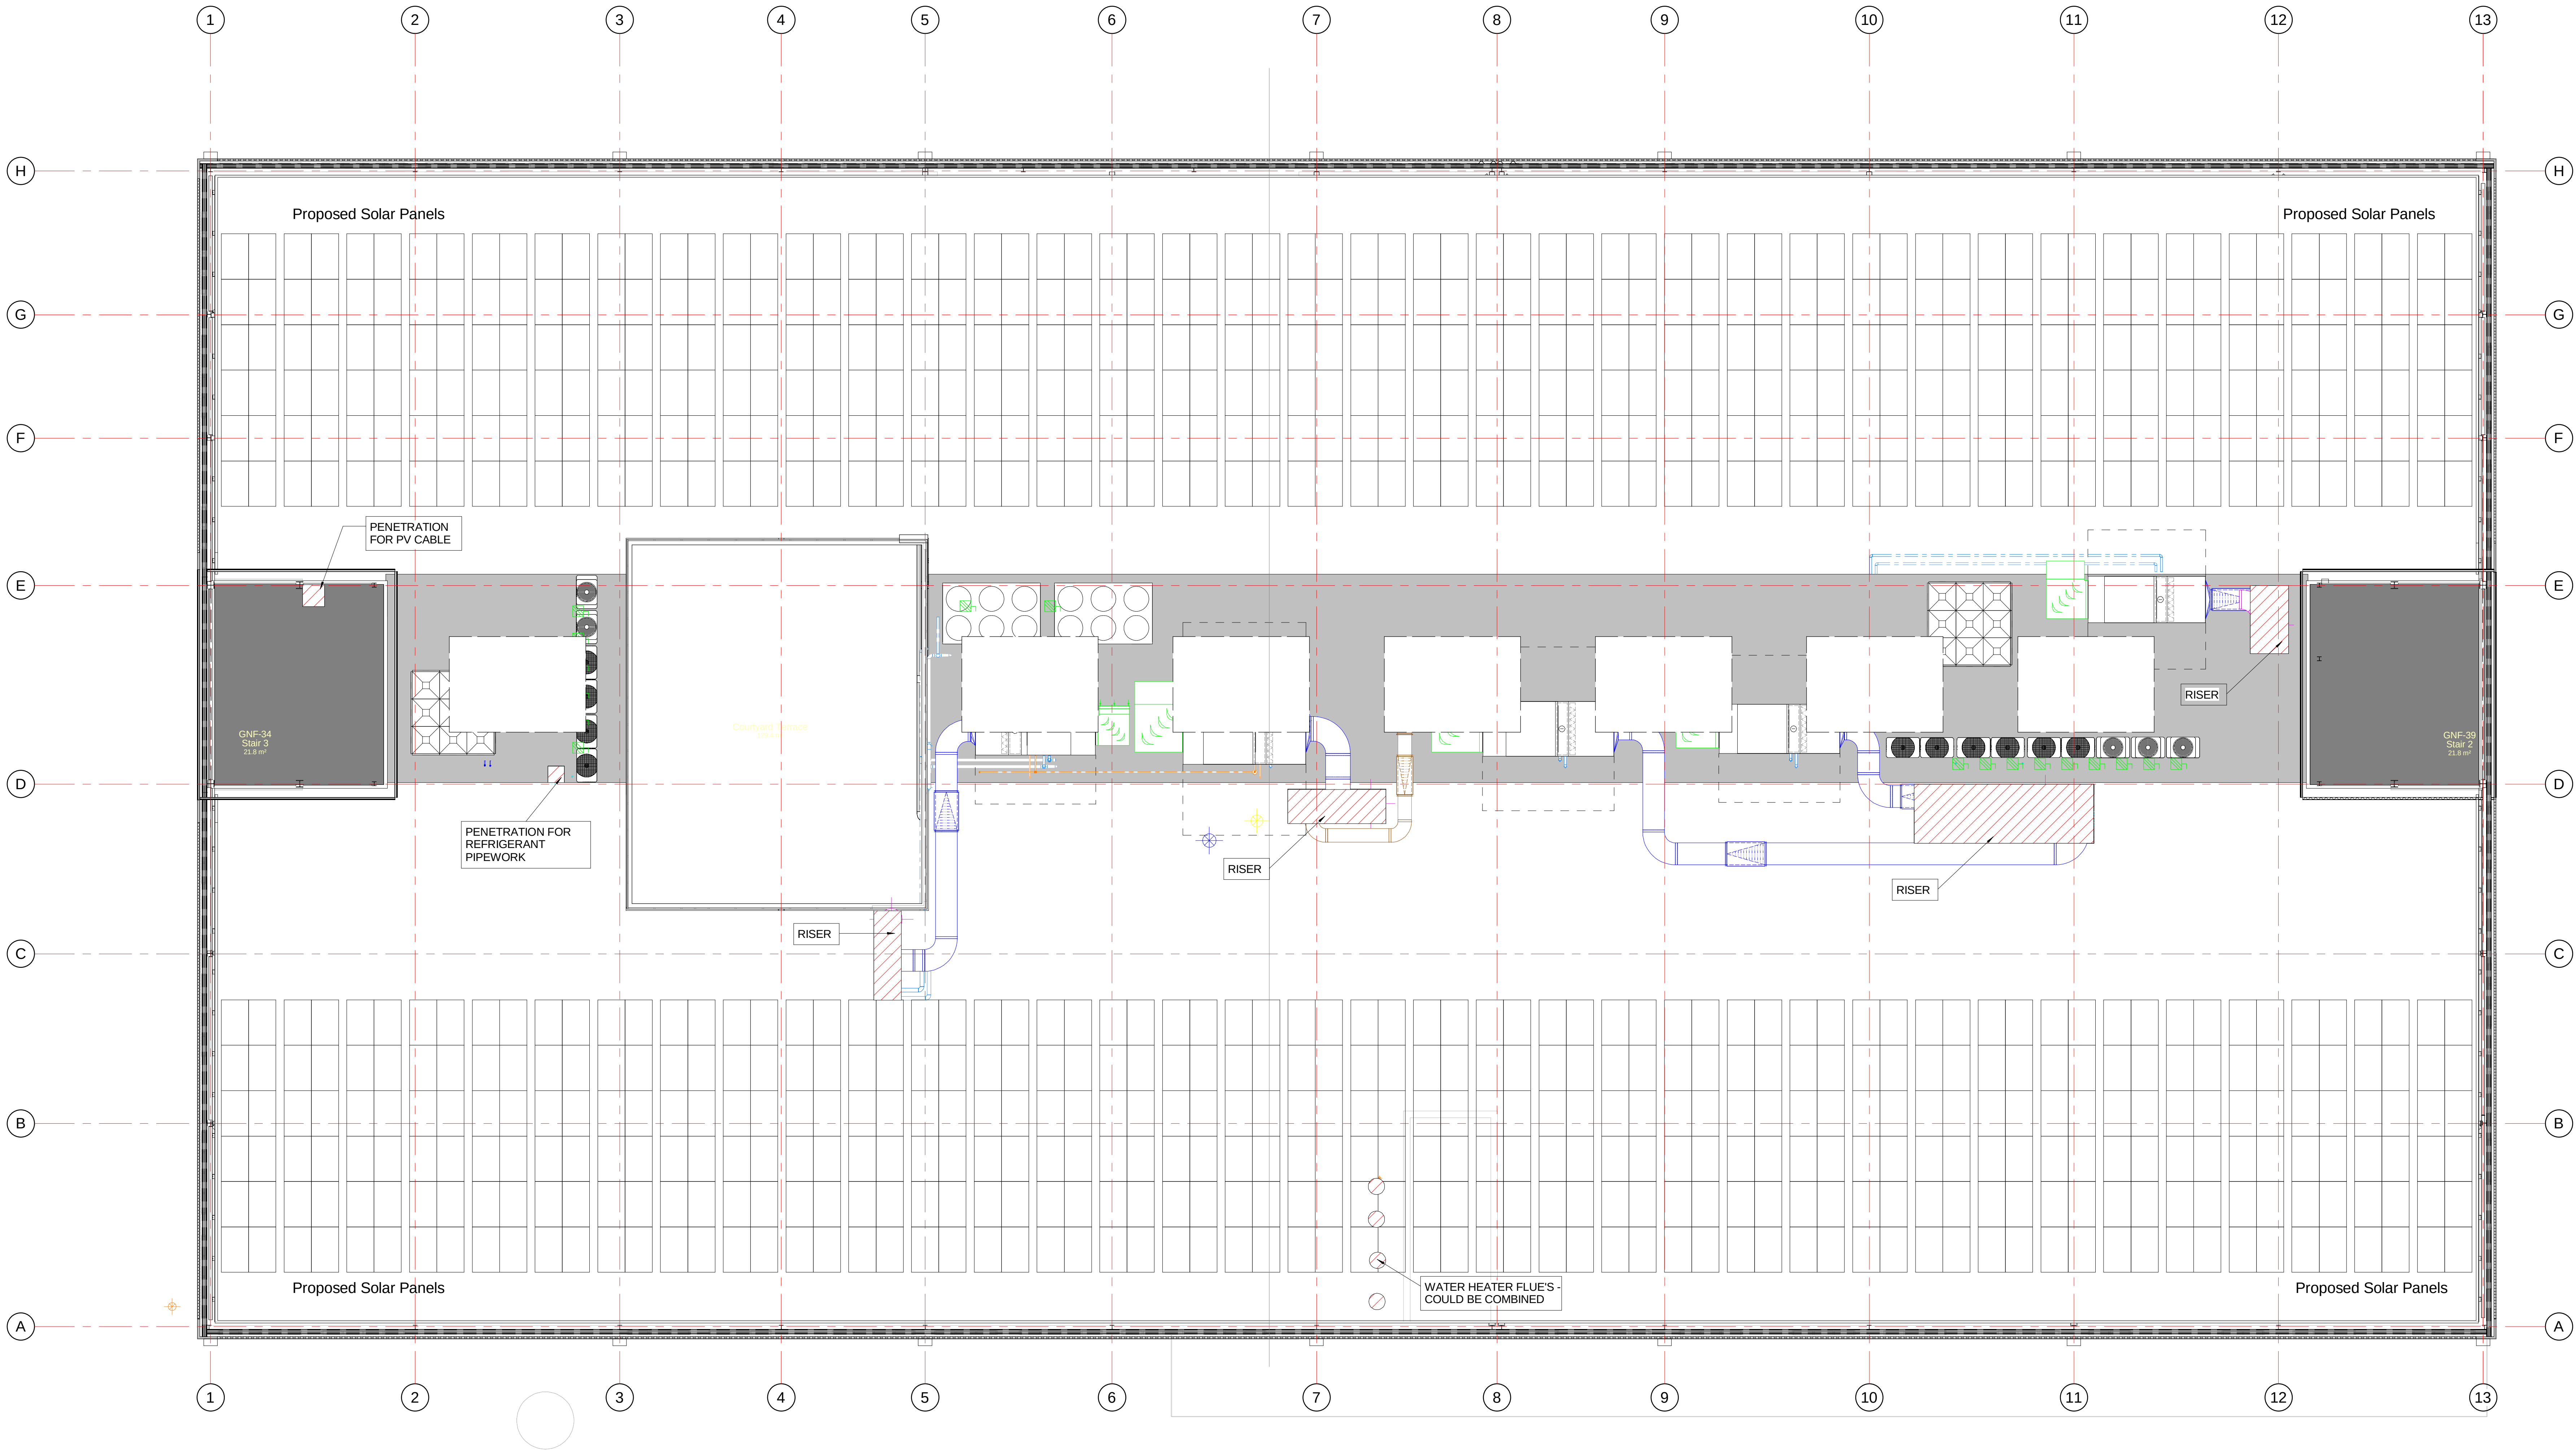

Proposed Roof Plan
1 : 100

Note:
Plant / equipment installation
does not form part of the shell
contract



01235m SCALE 1:100		Q 14.12.17 Notes updated AJR PSM S 15.12.17 Room names AJR PSM U 15.12.17 Updated notes with design changes NBB PSM U 15.12.17 Updated to current planning NBB PSM Rev Date Description Rev By Chk'd By			
Project Title	NHS Blood & Transplant Centre		Drawing No.	Proposed Roof Plan	
	Capitol Park Junction 37 M1 Higham Lane, Barnsley		200-Dwg No.	14120 - 119	
Client	CDP			Rev	D
Status	Planning		255, John Joseph, Wakefield, WF1 3AG 01924 291200 Corvus Warehouse, 77 Dales Street, Manchester, M1 2AG T: 0161 2086555 100 Leach Road, 79 High Street, Manchester, M1 6AB T: 0161 2711167 10 Leach Road, Manchester, M1 6AB T: 0161 2711167 10 Green Court, 10 Greenhatch Place, 1007 4091615		
Scale	1 : 100		Drawing Size	A0	
Down By	NBB	Checked By	PSM	Date	07.2017
ARCHITECTS www.hartnordgroup.co.uk					