


this drawing remains the property of fisch design limited and duplication of this drawing in whole or any part is strictly forbidden without prior written permission from fisch design ltd

all structural alterations are to be approved by a structural engineer


do not scale from this drawing, all dimensions to be checked on site

TYPICAL SYMBOLS LEGEND


LIGHTING	
	Recessed Downlight
	Recessed Spotlight
	Recessed Directional floodlight
	Recessed ceiling mounted loudspeaker
	Recessed/ Surface mounted emergency lighting
	Exterior Light Fitting
	Fly Killer Light (Wall Mounted)
	600x600mm lay-in modular light fitting
ELECTRICAL	
	Incoming electric mains
	Electrical distribution board
	Electric connector heater
	Electric handdryer with 13A fused spur at h/i
SECURITY	
	Security alarm control panel
	CCTV camera
	CCTV monitor
	Disabled WC alarm pull cord
MISC. FITTINGS	
	Water Heater
	Radiator (variable sizes)
	Air conditioning control panel
	Typical air conditioning cassette unit
	Wall mounted air conditioning unit
	Suspended ceiling height relative to fit
	Structural ceiling height relative to immediate fit
	Recessed ventilation grille - small
	Ventilation grille - Medium / Large
	Door number
	Electric panel connector heater with 13A fused spur at low level (variable sizes)
	Gas Mains/ Meter
	Instantaneous Water Heater
	Incoming water main and stop cock
	Water meter
	Suspended ceiling height relative to fit
	Structural ceiling height relative to fit
	Suspended ceiling, 600 x 600mm in standard 24mm exposed grid. Tile/grid colour white.
SMALL POWER AND COMMUNICATIONS	
	Single/ Twin 13A switched socket outlet (13A SSO)
	Outlet mounted at high level, 1850mm
	Outlet mounted above workshop height
	Single/ Twin 13A SSO in socket outlet in floor box or 13A fused connection unit
	Dado Trunking for power
	Telecoms system panel
	Data socket
	Telcoms socket
	Staff Intercom
	Telecoms line box/ entry point
	Door bell push and door bell sounder
FIRE PRECAUTIONS	
	Water fire extinguisher
	Foam fire extinguisher
	Powder fire extinguisher
	Carbon dioxide fire extinguisher
	Fire blanket
	Fire Alarm control panel
	Manual call point with Fire Action Notice S12
	Bell warning device
	Non Illuminated Directional exit signage, L and R
	Illuminated directional exit signage, L and R
	Smoke detector
	Heat detector
	Sounder warning device

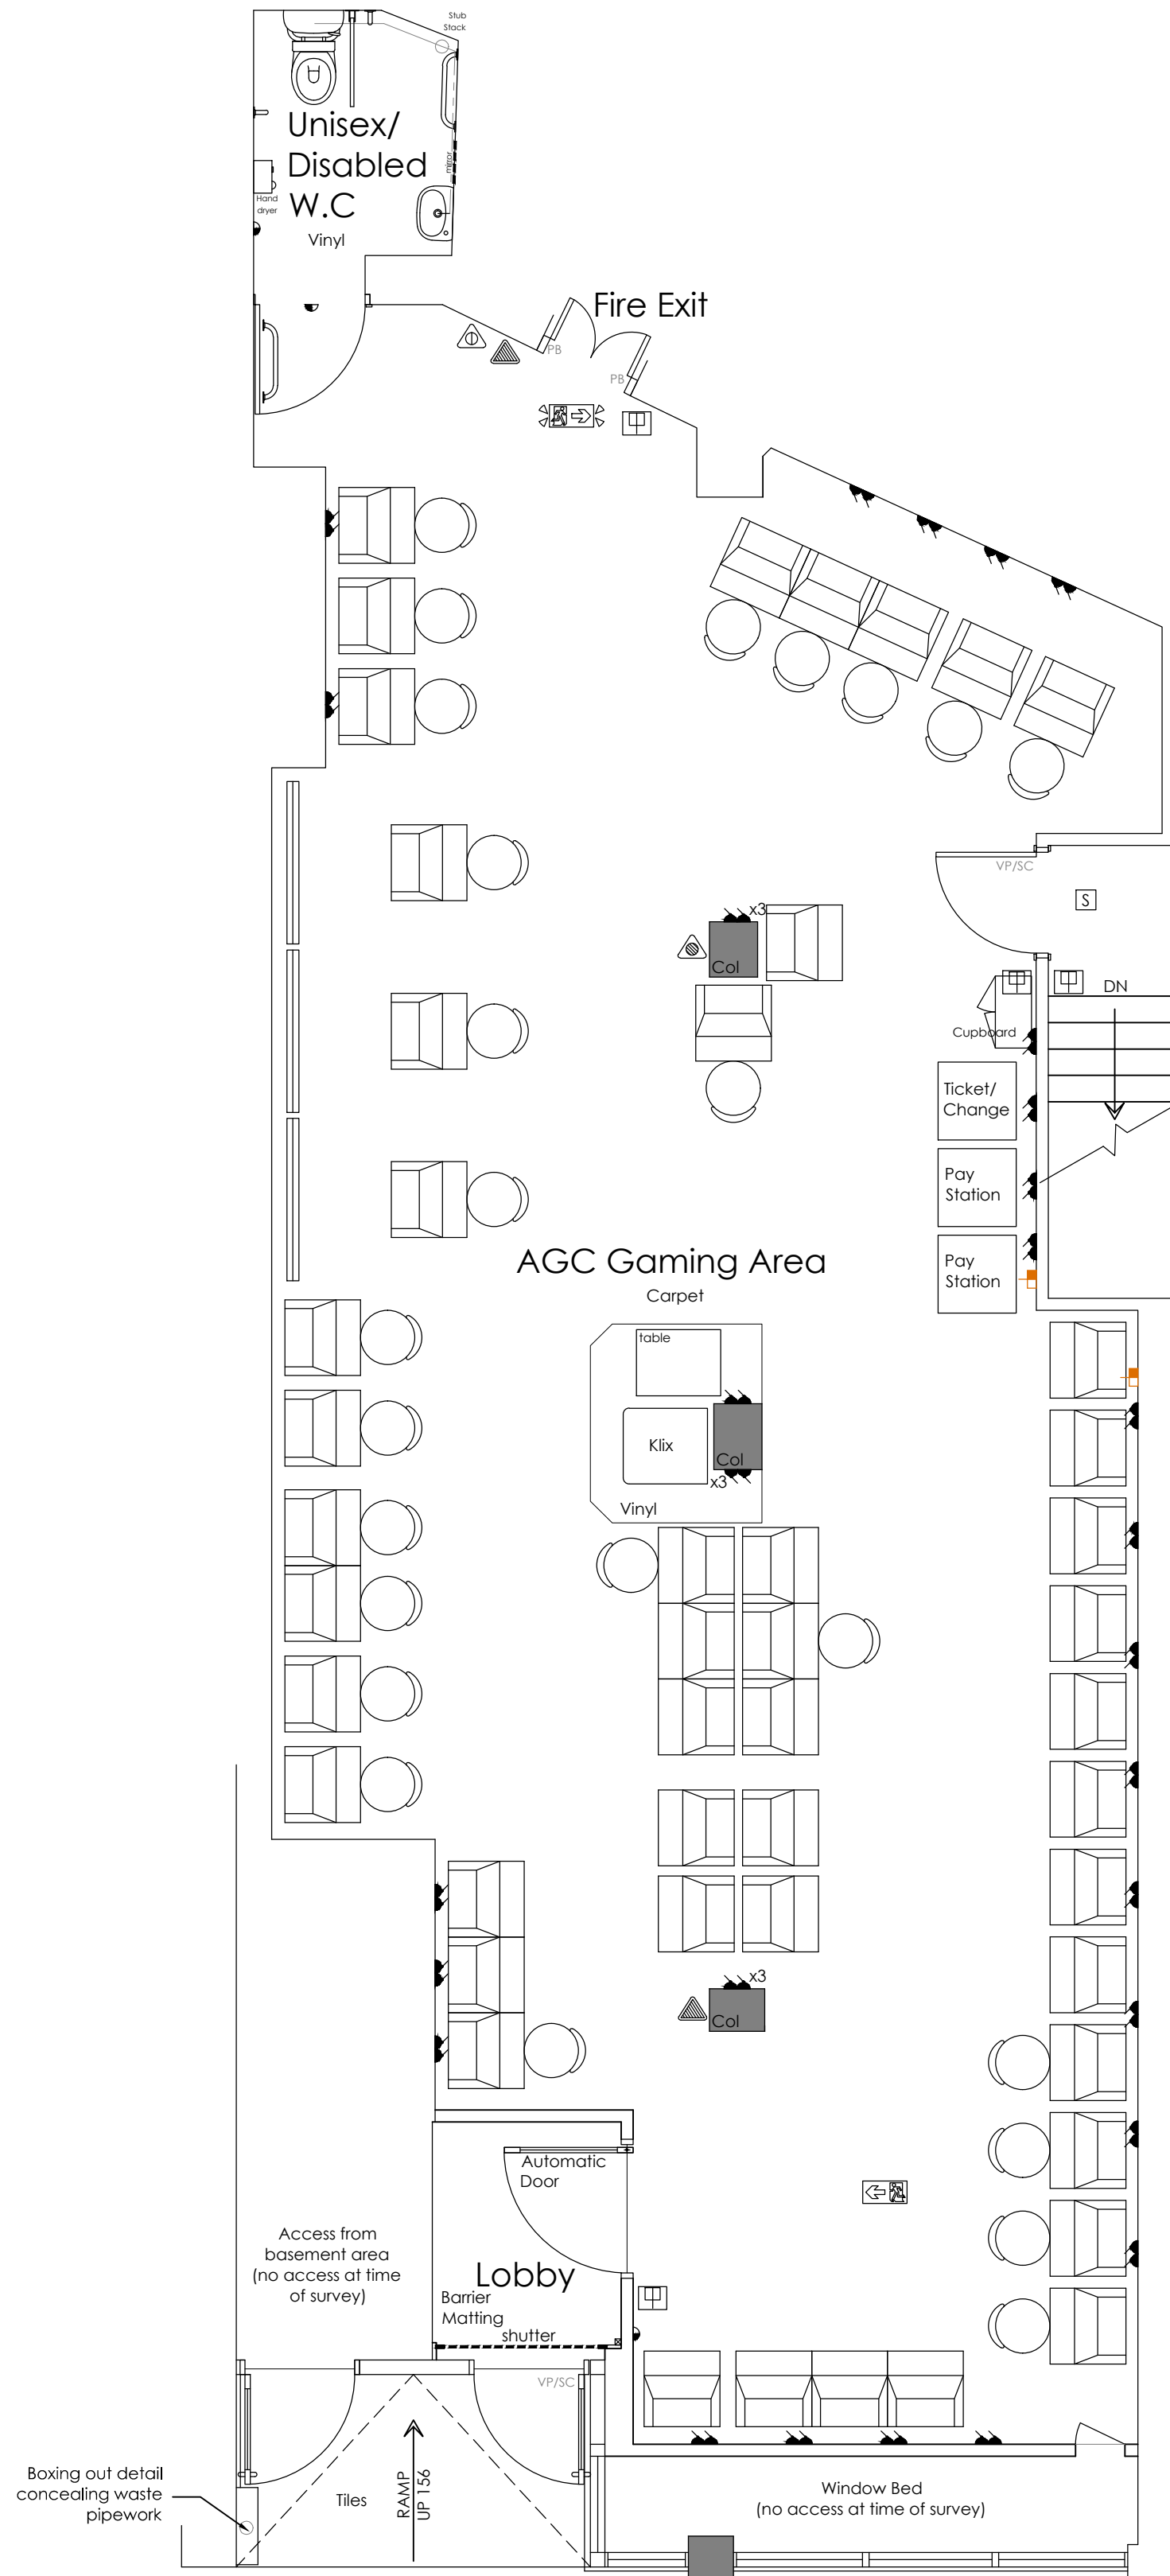

Existing Ground Floor Plan
Scale 1:50@A1

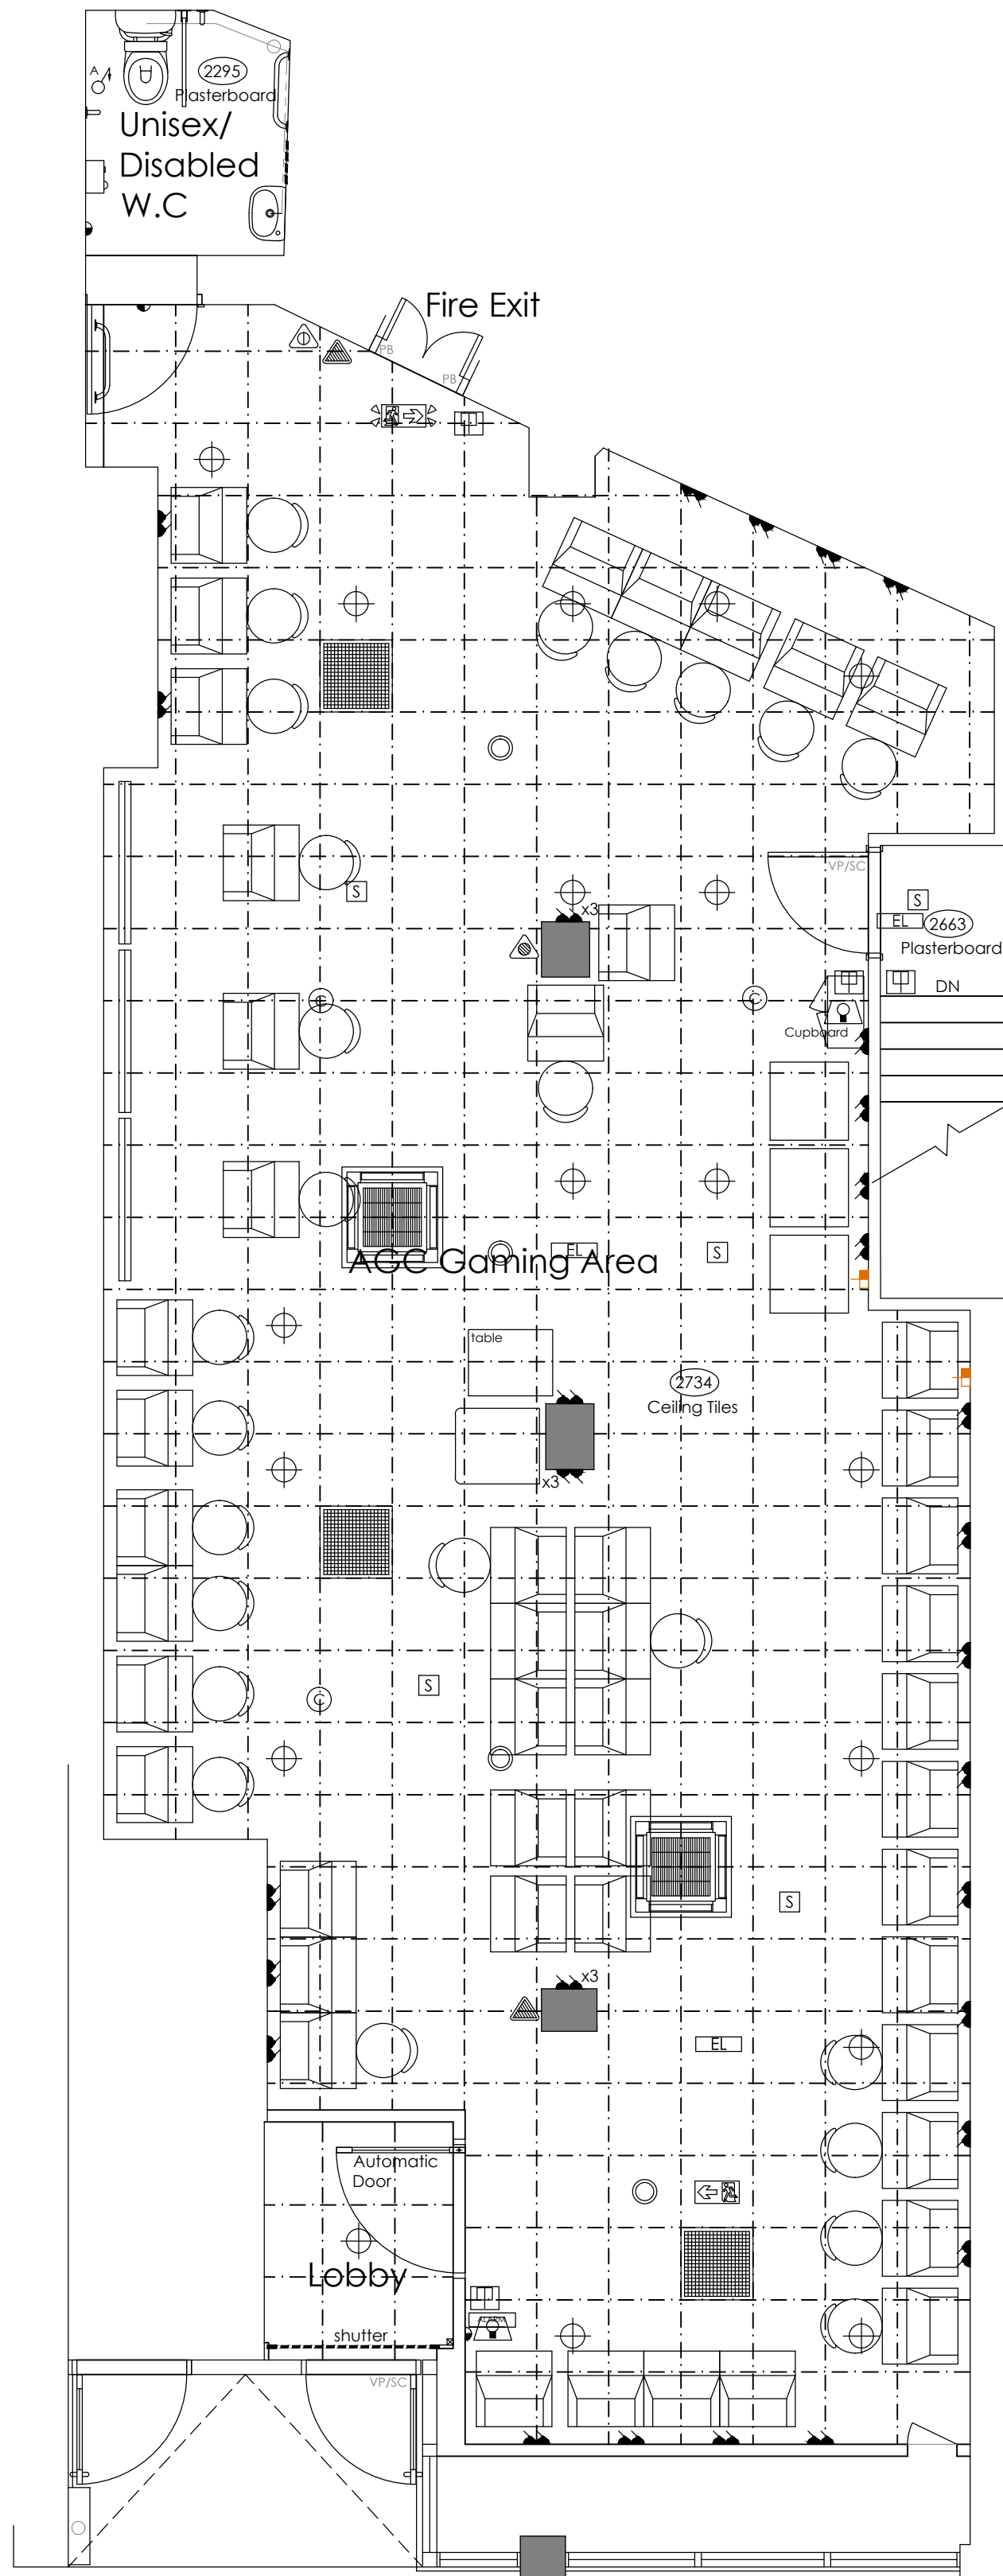

Existing Ground Floor RCP Layout
Scale 1:50@A1

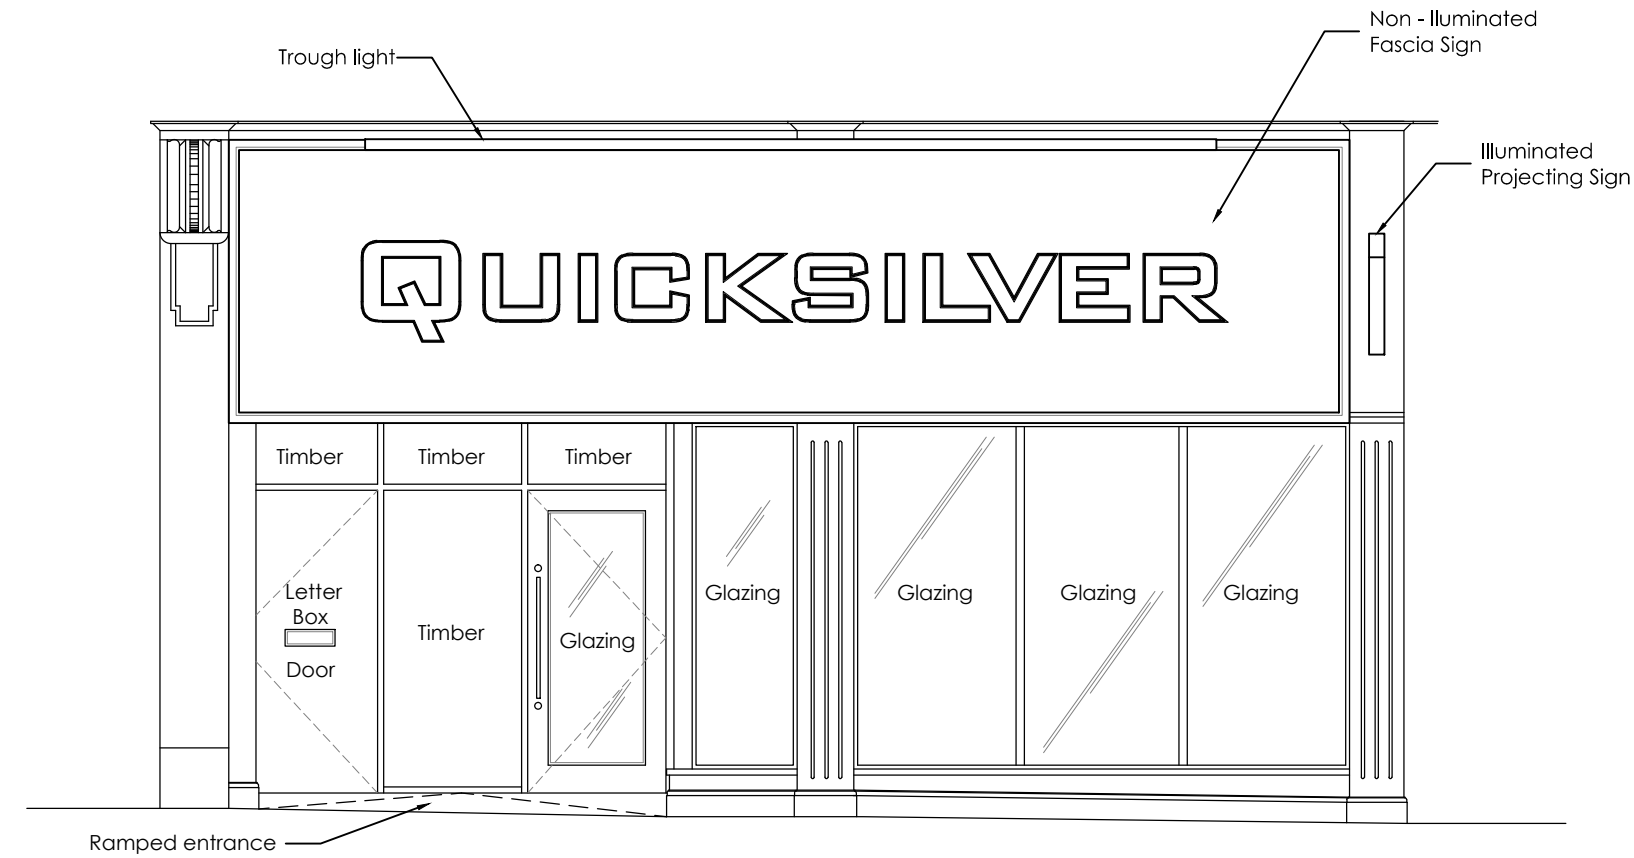

Existing Shopfront Elevation
Scale 1:50@A1

DWG NO: **1226-01** REVISION: -

CLIENT: **Talarus Ltd**

PROJECT: **Quicksilver
20-22 Eldon Street
Barnsley
S70 2JB**

TITLE: **Existing Ground Floor and
Shopfront Survey**

ORIGIN: **JRS** CHECKED: -

SCALE: **1:50@A1** DATE: **13.03.17**

fisch
STRUCTURED CREATIVITY

FISCH DESIGN LTD
3 HERITAGE BUSINESS CENTRE
DERBY ROAD, BELPER
DERBYSHIRE, DE56 1SW

+44 (0)1773 828222 / WWW.FISCHDESIGN.CO.UK / MAIL@FISCHDESIGN.CO.UK