


Ventilation Notes


1. This drawing shall be read in conjunction with the main contract conditions the building services specification and schedules, and all other contract documentation.
2. All ductwork shall be manufactured, installed and tested to DW144.
3. All builders work plenums shall be built to structural engineers details and shall be smooth fair faced and epoxy coated.
4. All ductwork shall be provided with access panels to facilitate internal cleaning.
5. All dampers shall be provided in fully accessible locations to enable commissioning and maintenance.
6. Refer to the architect's drawings for details of all setting out information. No dimensions shall be measured from this drawing.
7. Refer to the architect's reflected ceiling plans for the setting out of all soffit mounted services components.
8. Refer to the architect's drawings for details of all building compartmental. All services shall be fire stopped using the approved penetration details, fully in accordance with the compartment rating.
9. The construction contractor shall provide co-ordinated installation drawings for review and prior to installation on site as defined in contract prelims. The construction contractor shall be responsible for verifying all routes shown and modify where necessary on the installation drawings prior to commencing installation on site. All information shall be issued in a timely manner to allow the review and approval process without affecting the construction programmer.
10. The contractor shall carry out all works, systems, etc. to a method, standard and programme approved by the client team.
11. These design drawings do not show all offsets, bends, transformations, elbows or other elements which may be required to form a complete installation. The contractor shall provide all accessories and fittings as necessary for a complete installation.
12. Access panels are typically not indicated but shall be included and positioned in accordance with CIBSE TM26, HVCA TR17 & HVCA TR19.
13. For ducts through fire barriers, where a fire damper is not fitted, the gap between the duct and its sleeves, and the gap between the ducts and fire barriers must be firmly sealed with soft packing having a period of fire resistance equal to the fire barriers.
14. All fire dampers to be line size.
15. Mechanical services layouts are subject to change following receipt of a frozen architects model.
16. Restaurant R9. Front of house supply & extract duct sizes based on an estimated 2person/m² for 60% of total area. Kitchen extract & supply based on 40 ACH for 40% of total area
17. SUH1 Supply & extract duct sizes based on an estimated 2person/m² of total area
18. FD not shown in roof slab as it is assumed that the protective shaft terminates inside the building. Termination of shaft at the underside of the slab is not required to be enclosed at the top hence allowing the omission of the FD. TBC with architect

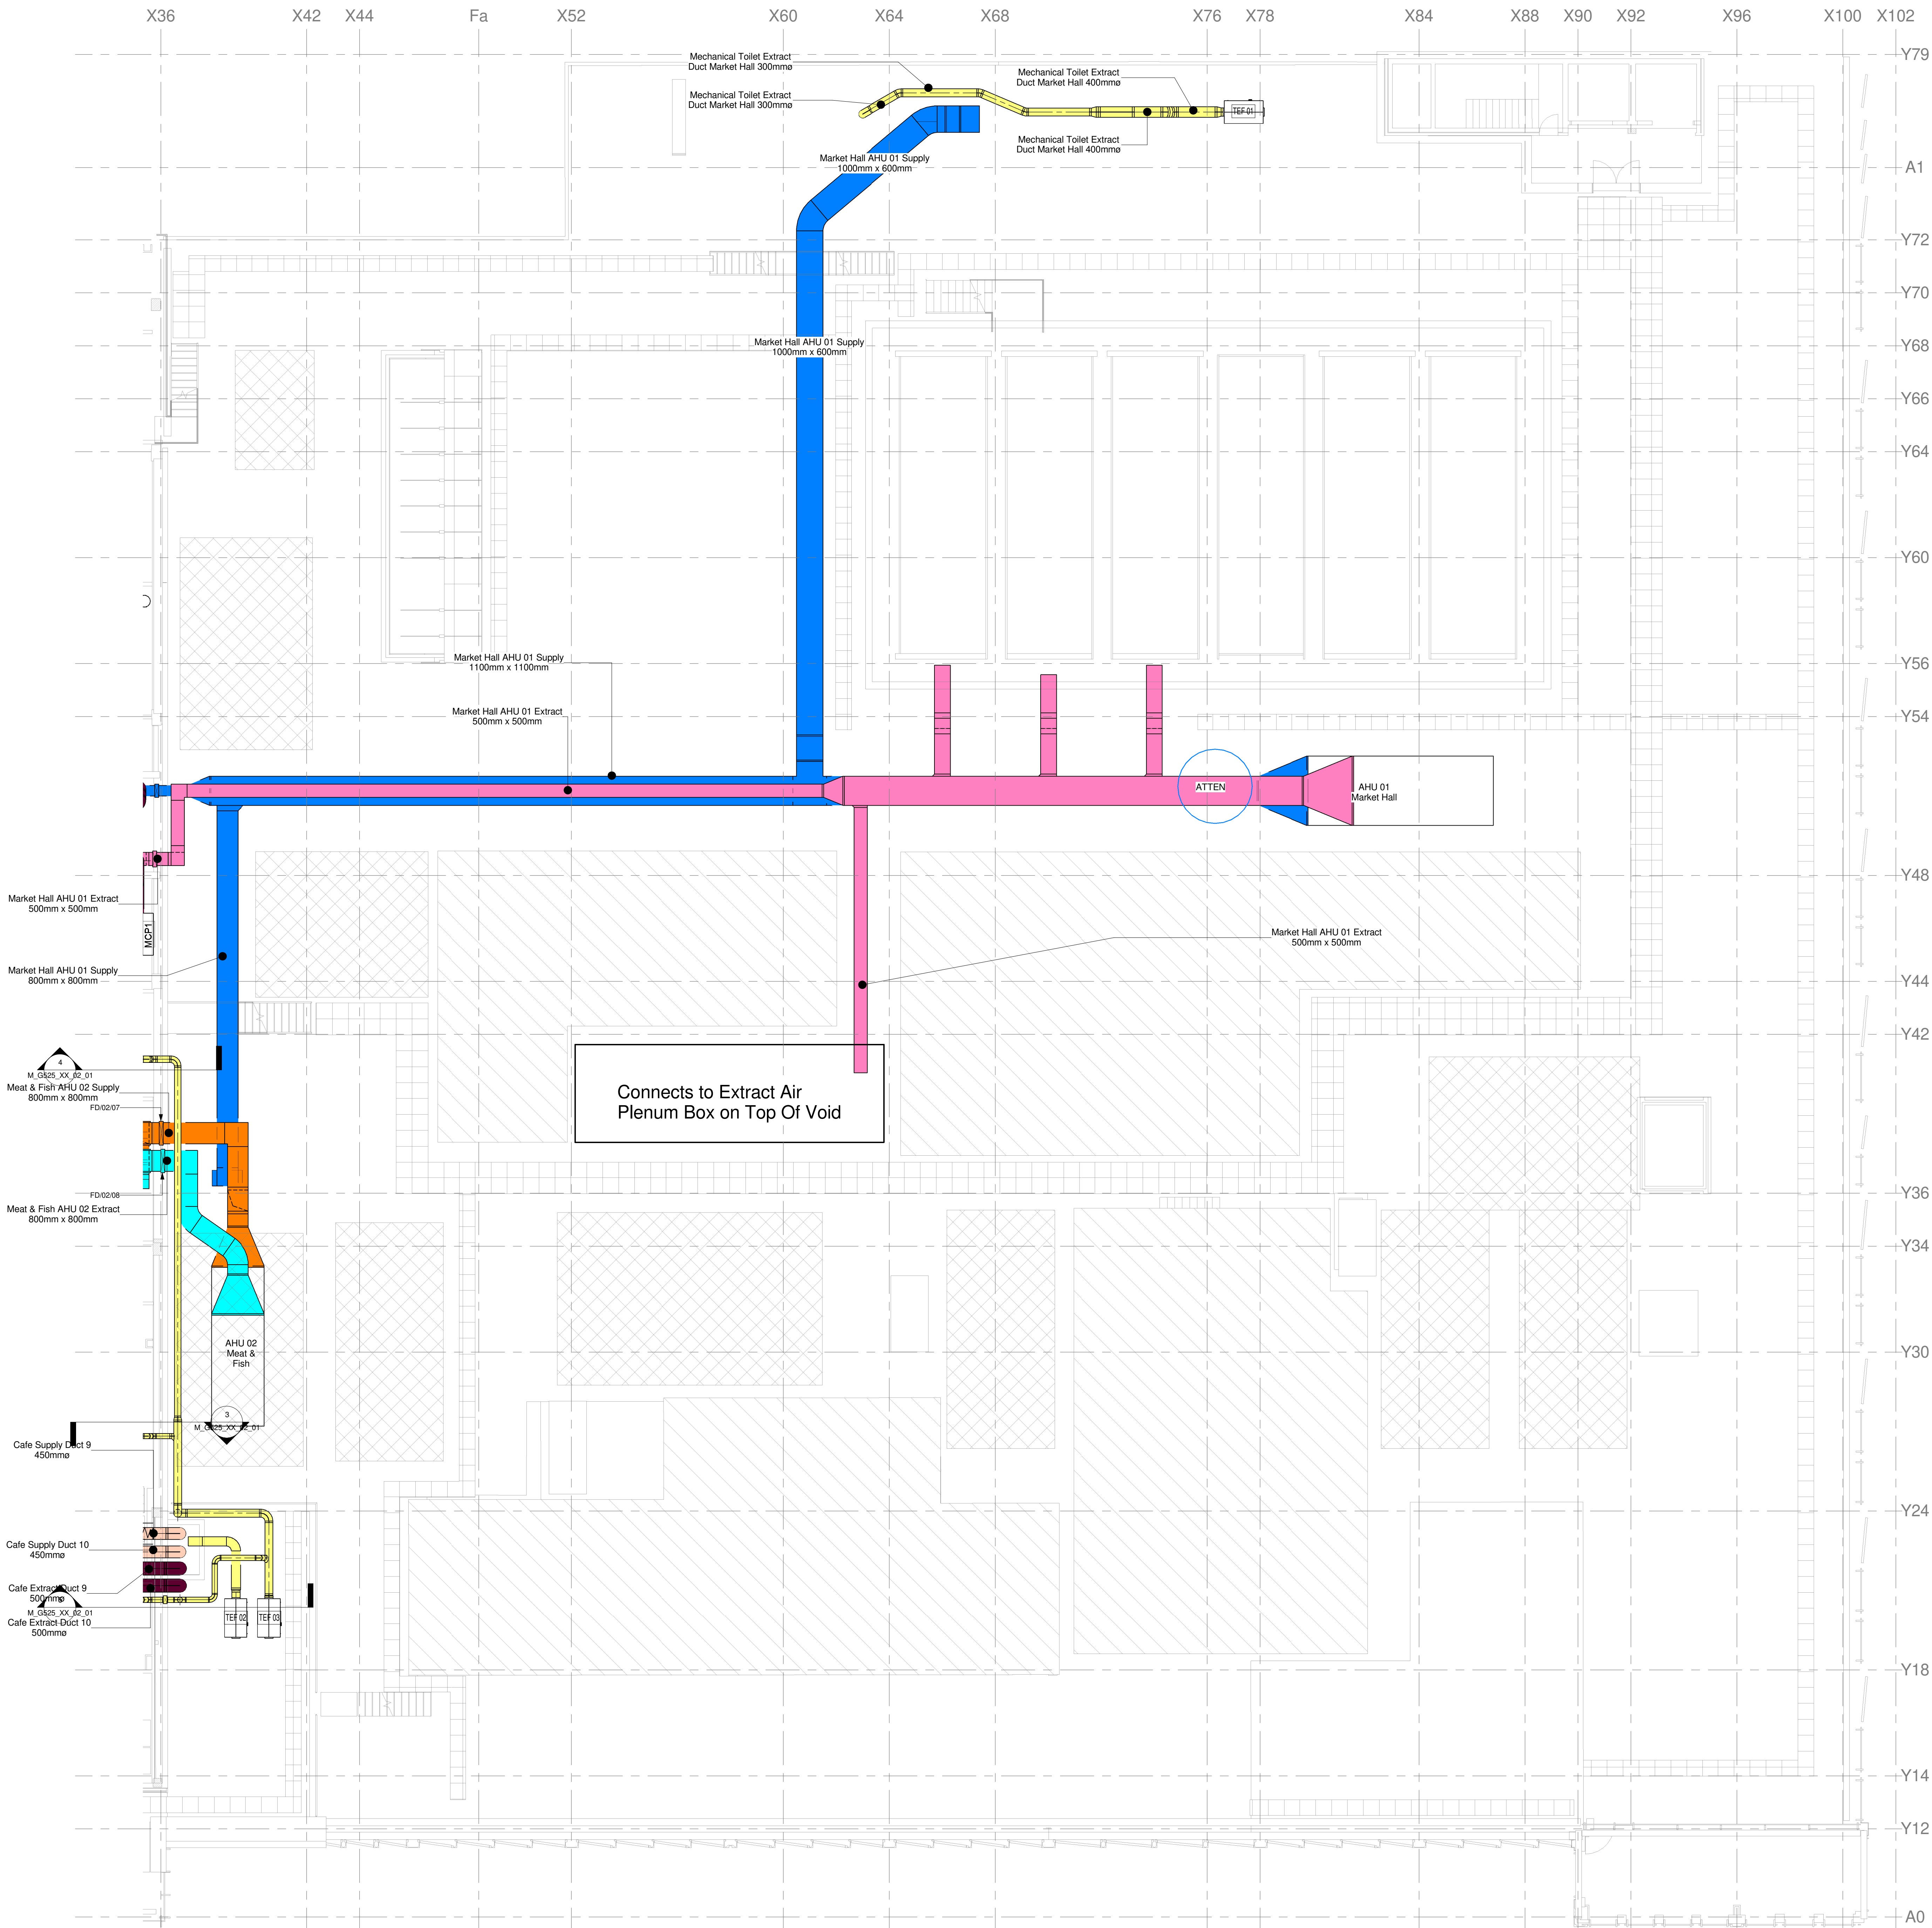

Responsibility is not accepted for others scaling from this drawing. Do not scale from this drawing use written dimensions only



KEY PLAN

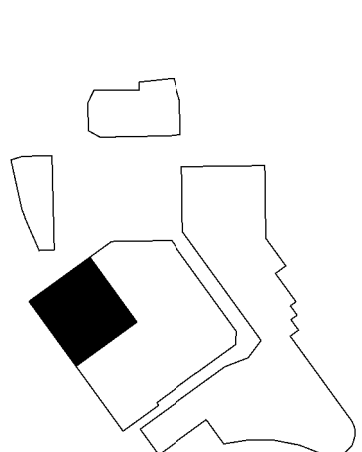


This drawing is produced for use in this project only and may not be used for any other purpose. NPS Property Consultants Ltd accept no liability for the use of this drawing other than the purpose for which it was intended in connection with this project as recorded on the title block fields 'Purpose of Issue' and 'File Status Code'. This drawing may not be reproduced in any form without prior written agreement. Crown Copyright & Database Rights (2016) Ordnance Survey (100022254)

NOTES

Service Name	Colour
Market Hall Supply	Blue
Market Hall Extract	Pink
Meat & Fish Supply	Orange
Meat & Fish Extract	Cyan
Kitchen Supply	Light Orange
Kitchen Extract	Dark Purple
Toilet Extract	Yellow
Basement Dirty Extract	Green

Ventilation Legend

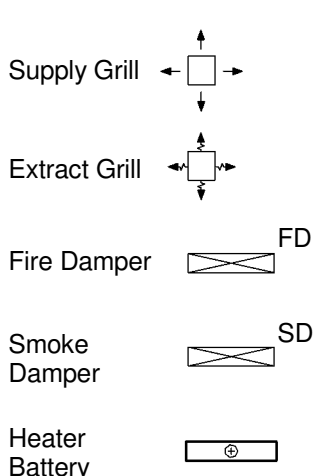

REV	COMMENT	DRN	CHK	DATE
2	Fire & Smoke Dampers Added	TW	MD	22-03-18
1	First Issue For Construction All Previous Ventilation Drawings At Tender Issue Are Superseded	AH	MD	07-11-17



NPS Barnsley LTD
Gateway Plaza, Sudcliffe St, Barnsley, South Yorkshire, S70 2HD.
TEL: 01226774605, 014625, 014626; Barnsley@nps.co.uk, WEB: www.nps.co.uk

CLIENT
BARNESLEY METROPOLITAN BOROUGH COUNCIL

PROJECT
THE GLASS WORKS PHASE 1

TITLE
Roof Ventilation Layout
Sheet 1 Of 1

SCALE	DISCIPLINE	PROJECT NUMBER
As indicated	MECHANICAL	16-1-1093
FILE: DRAWING NAME	PROJECT NUMBER	REV CODE
BBTC_NPS_MC_M_G525_PL_RF_01	16-1-1093	2
STATUS CODE	PURPOSE OF ISSUE	DRAWN
	CONSTRUCTION	AH