



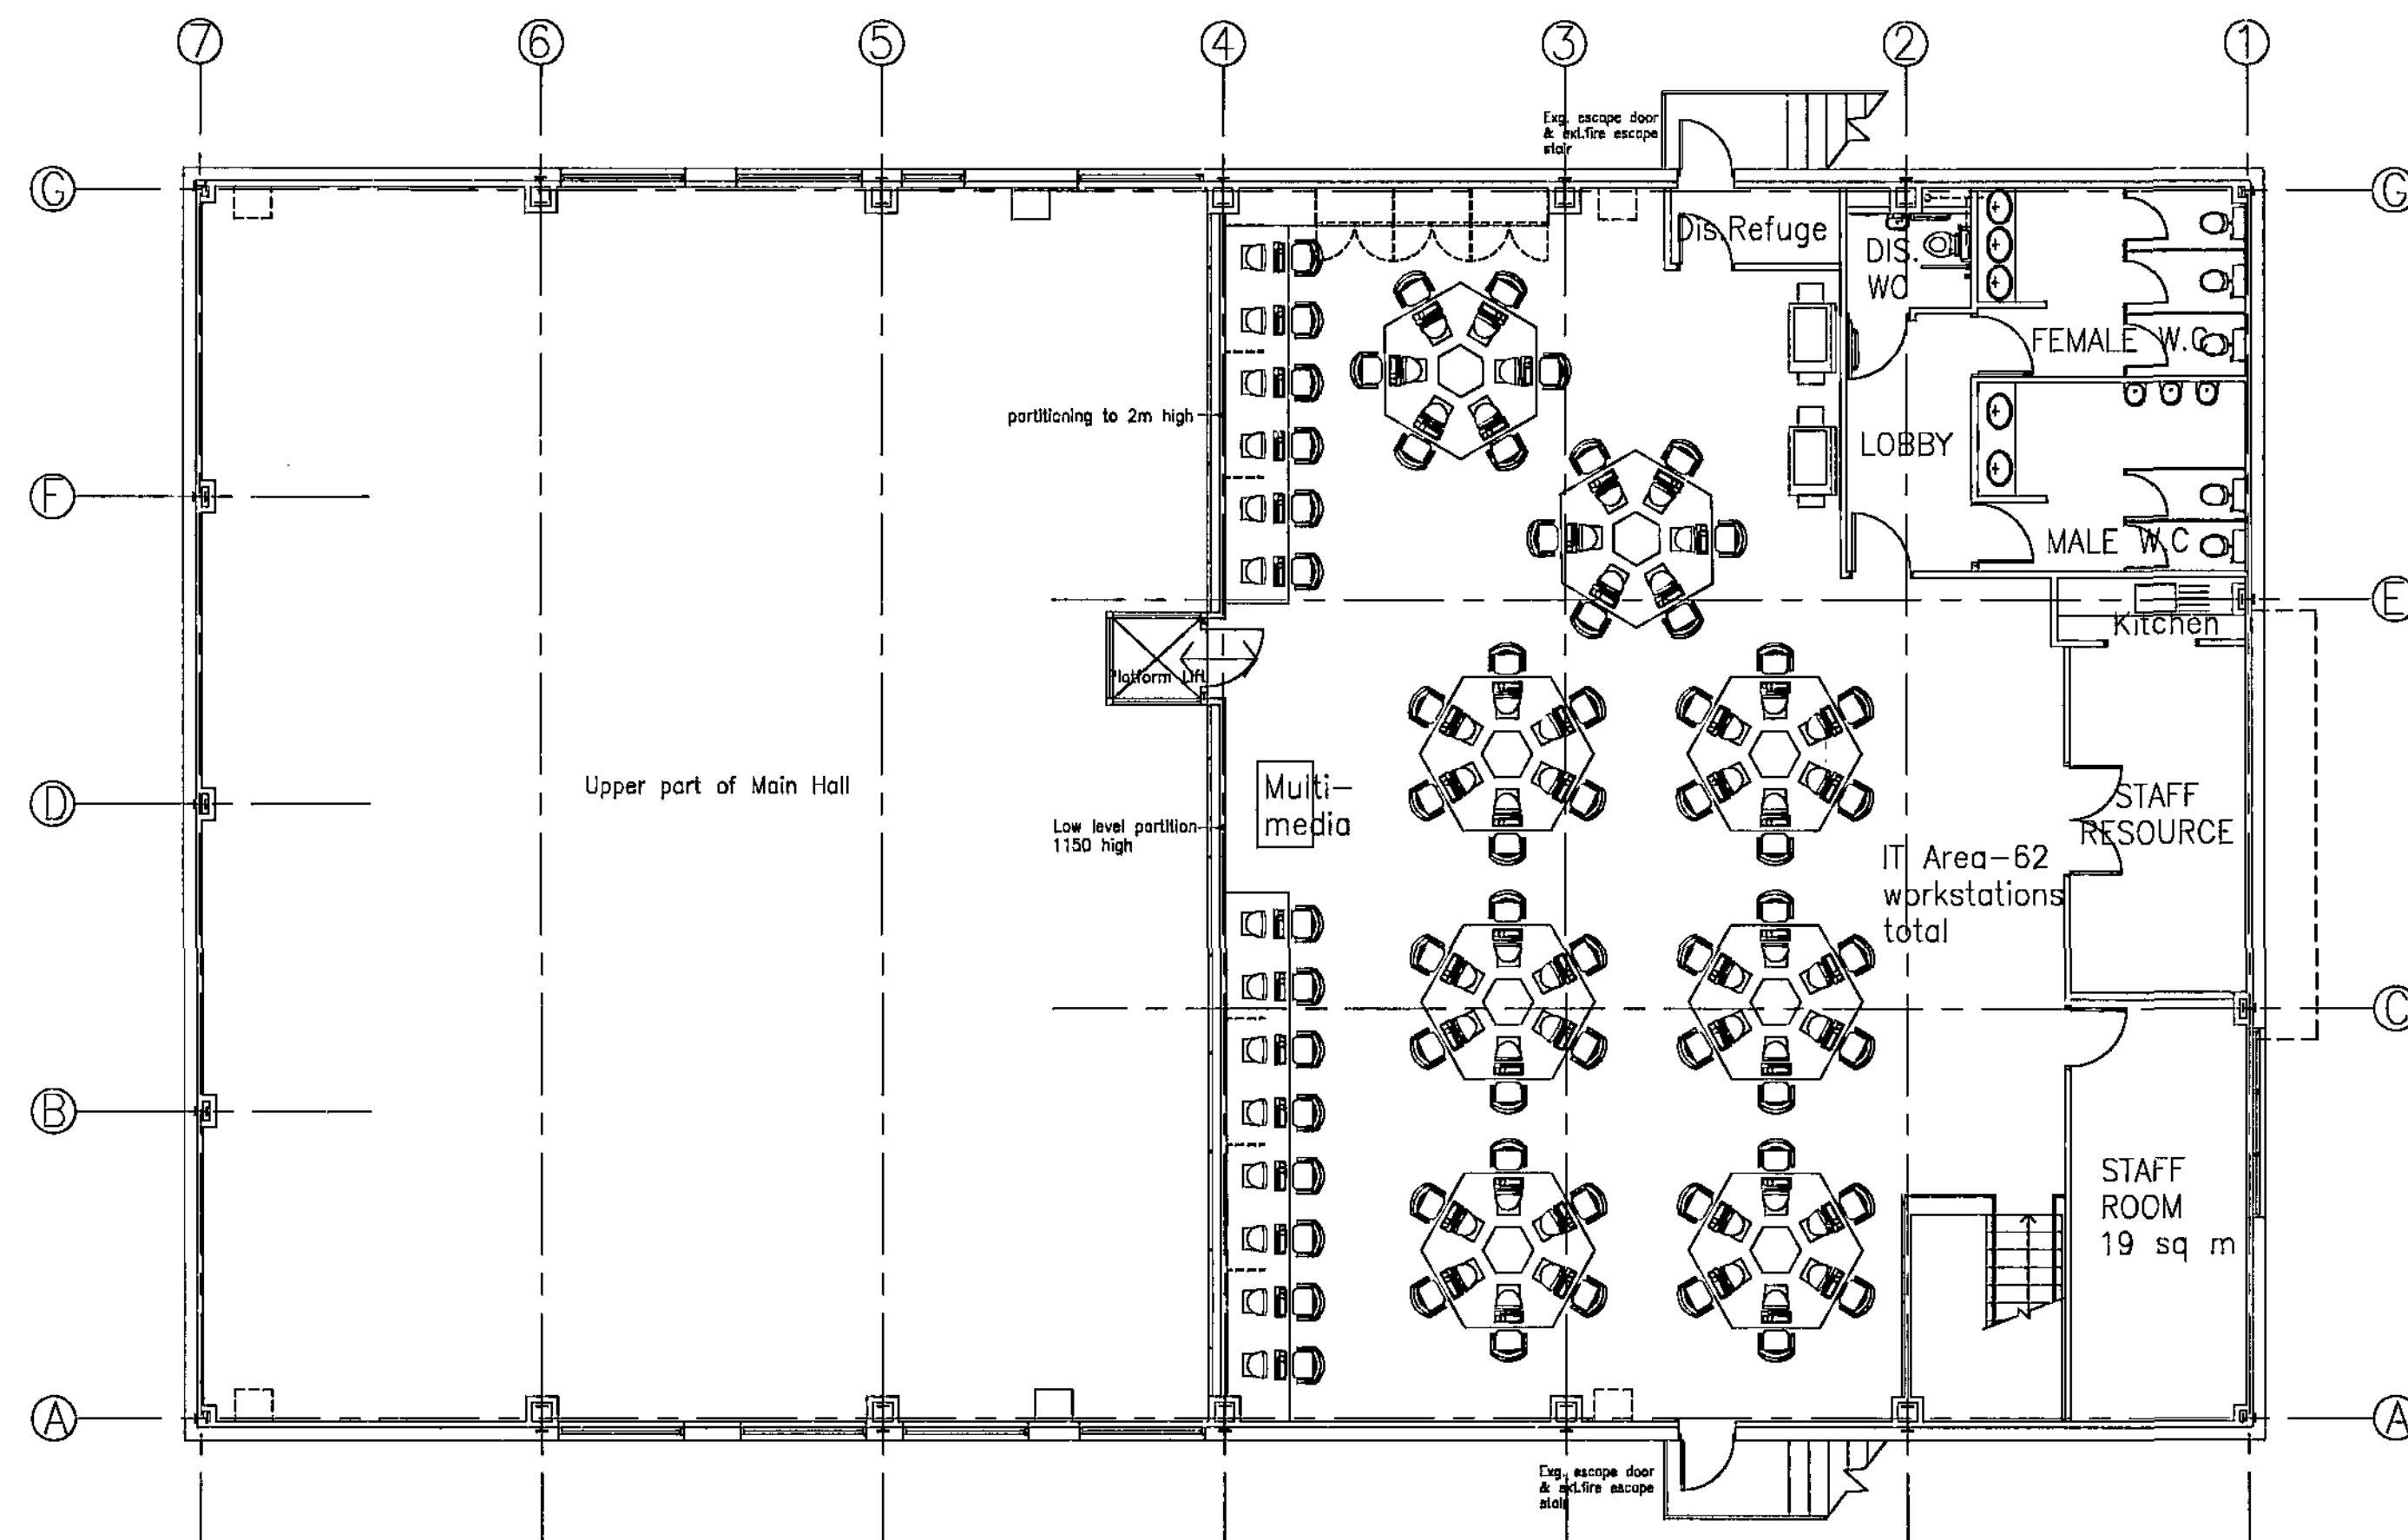

Existing Mezzanine Gallery

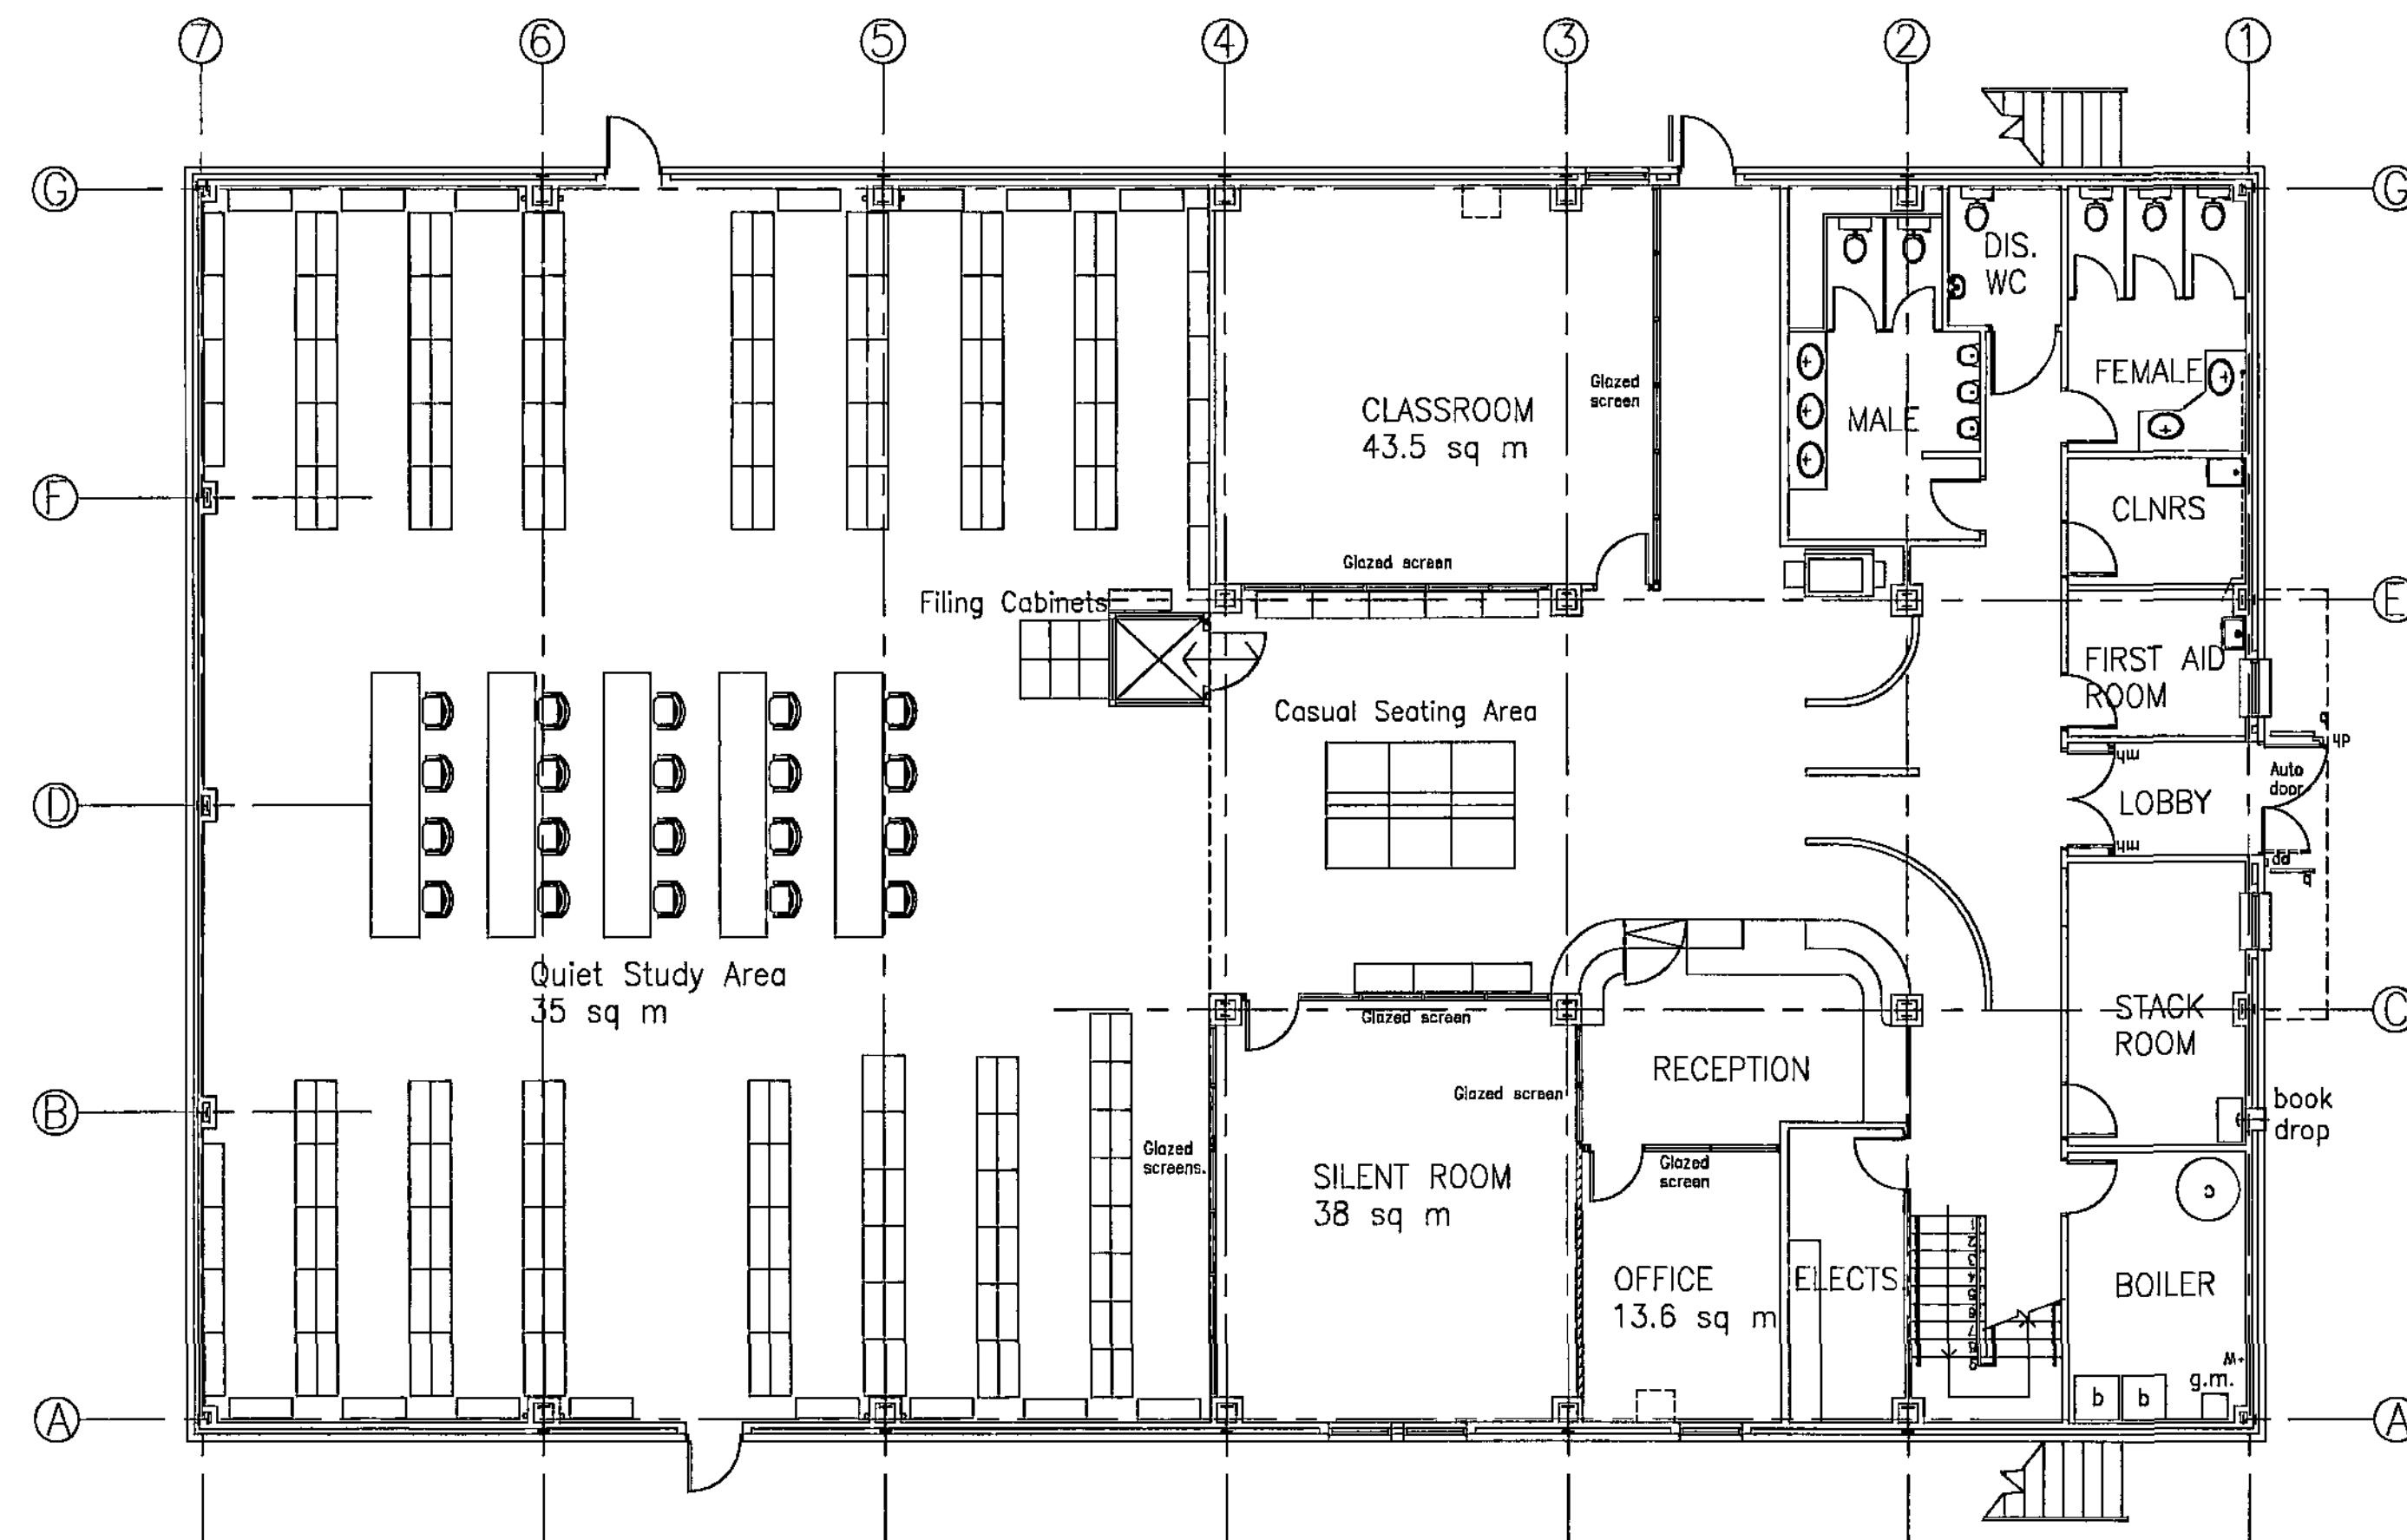

Existing Ground Floor Plan

Do not scale from this drawing.
The contractor is to check all dimensions on site
and report any discrepancies to the architect.
All rights described in copyright 12 or the
copyright, designs and patents act 1988
have been generally accepted.

General Note:
Contractor to check suitability of existing raised
access floor in library space for refurbishment or
demolition

Planning Issue

B	18.11.10	Drawn: AL	Check: PP
Issued for Planning Approval			
A	12.11.10	Drawn: AL	Check: PP
Issued for tender			
-	13.08.10	Drawn: AL	Check: PP
Initial Issue			

Fulcrum
2 Sidney Street
Stafford: ST 4RH
Telephone +44(0)1142761651
Facsimile +44(0)1142799191
Website www.jeffersonsheard.com


**Jefferson
Sheard
Architects**

Drawn: AL	Check: PP
-----------	-----------


Project
Barnsley College
Performing Arts (Falcon Centre)

Drawing
Existing General Arrangements


Scale 1:100@A1	Date 13.08.10
Ref. 0011	Number 0001
Rev. B	

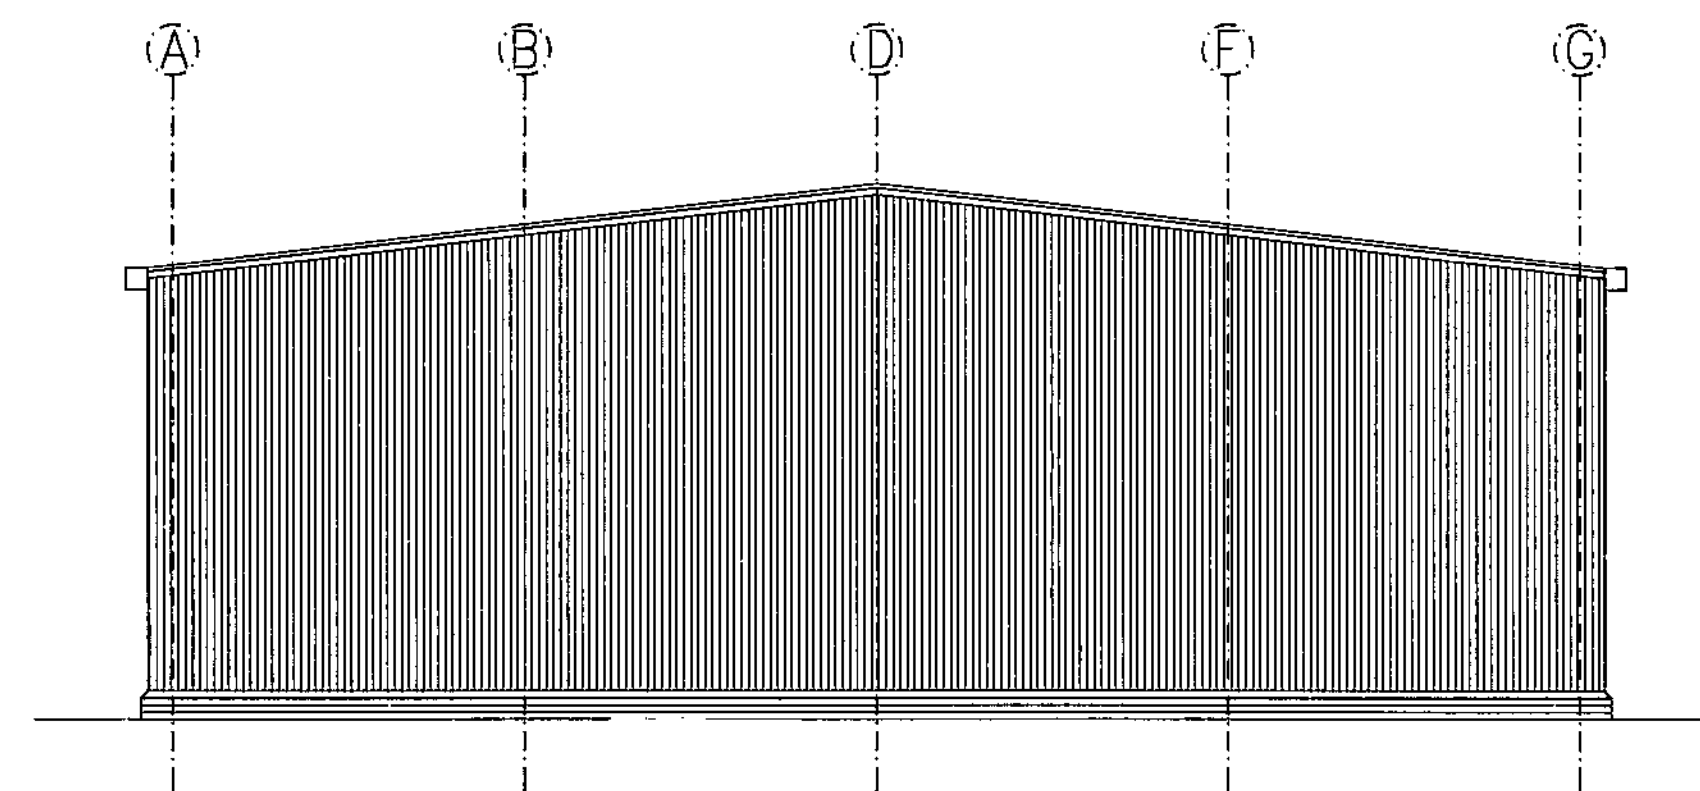


Existing North Elevation

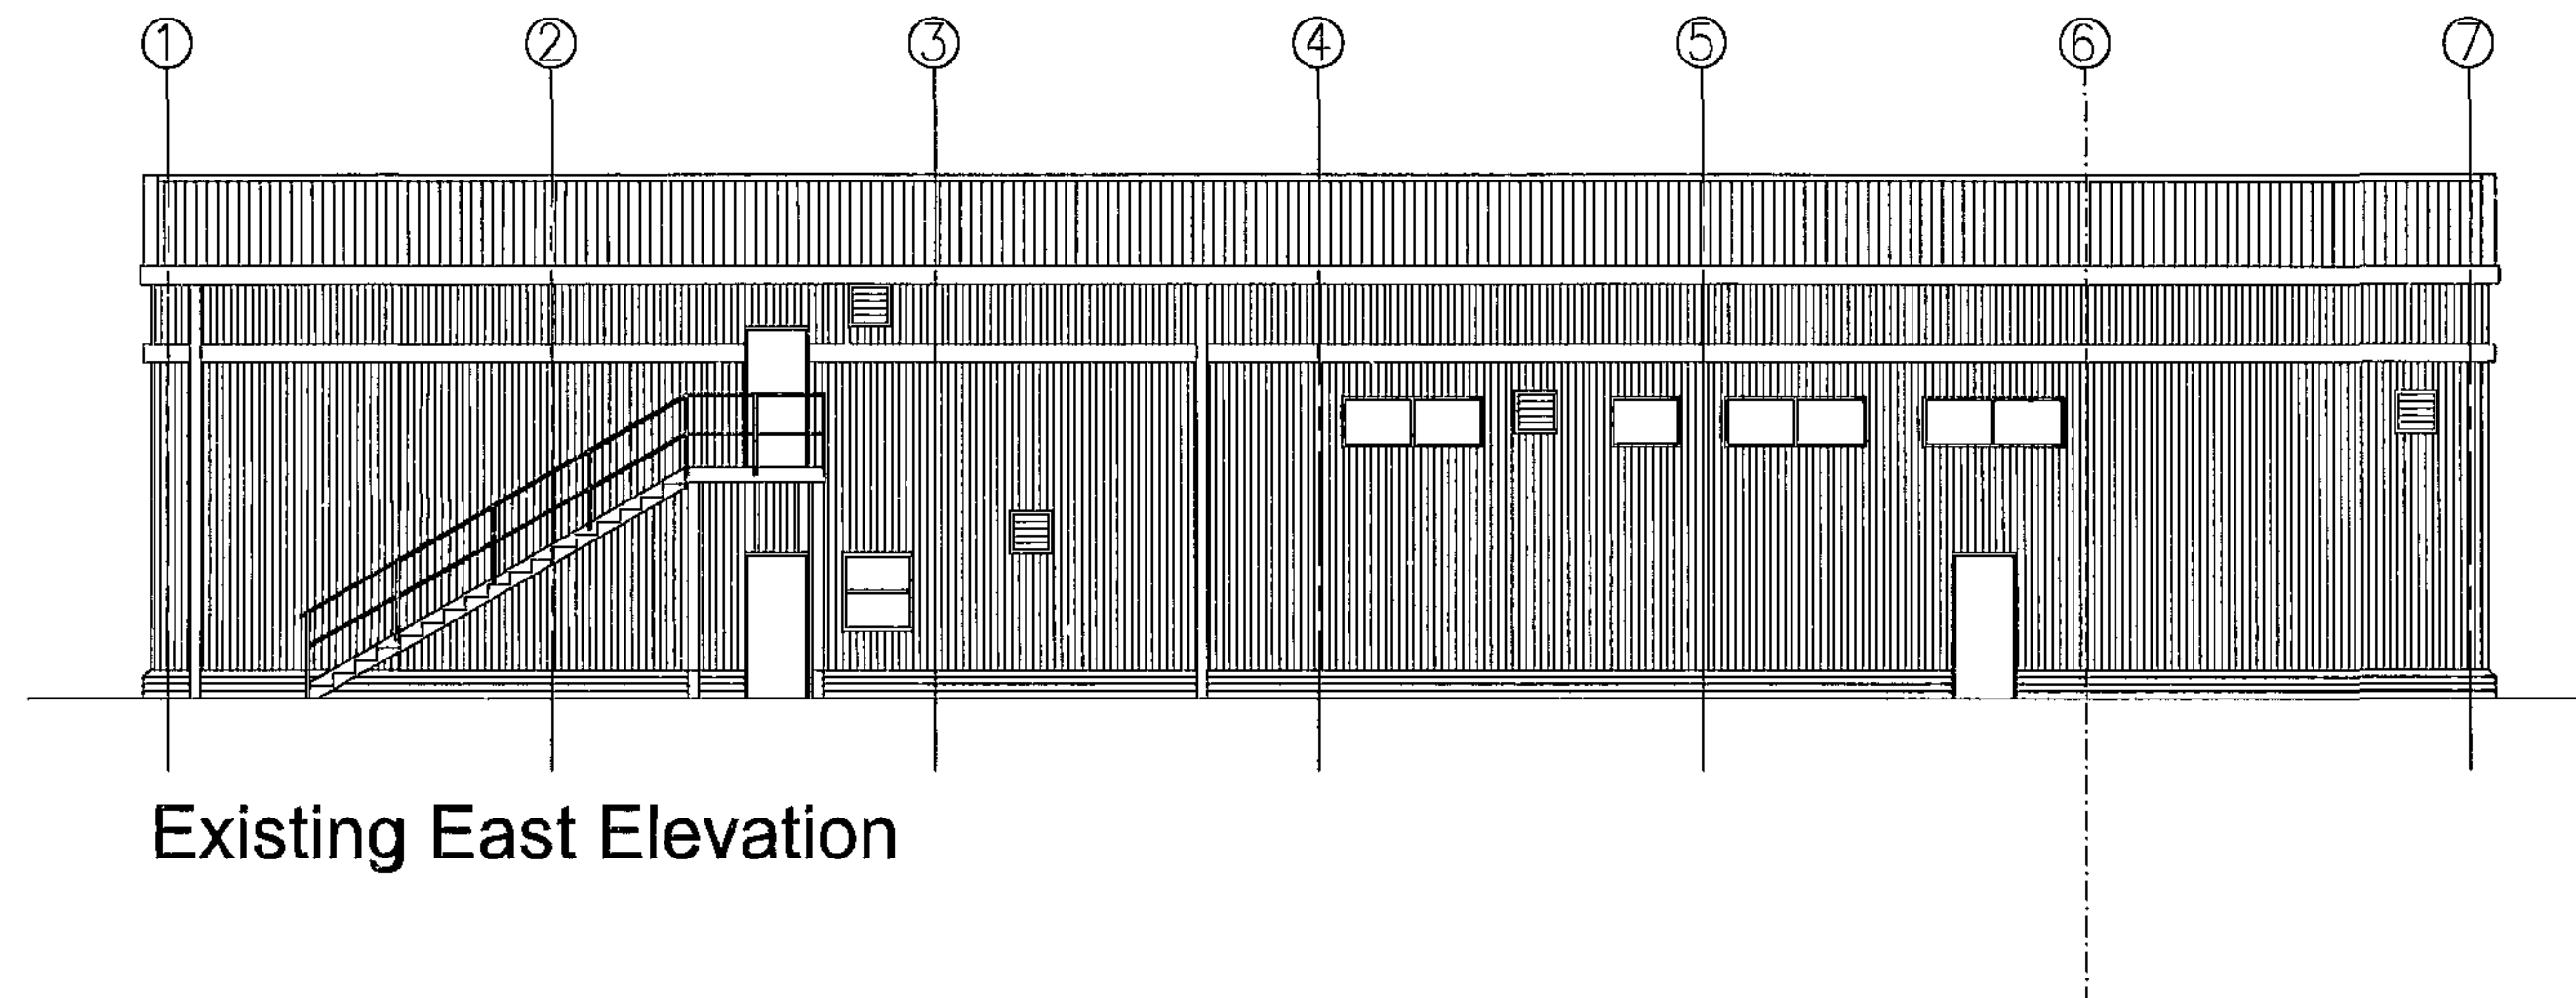

Existing East Elevation

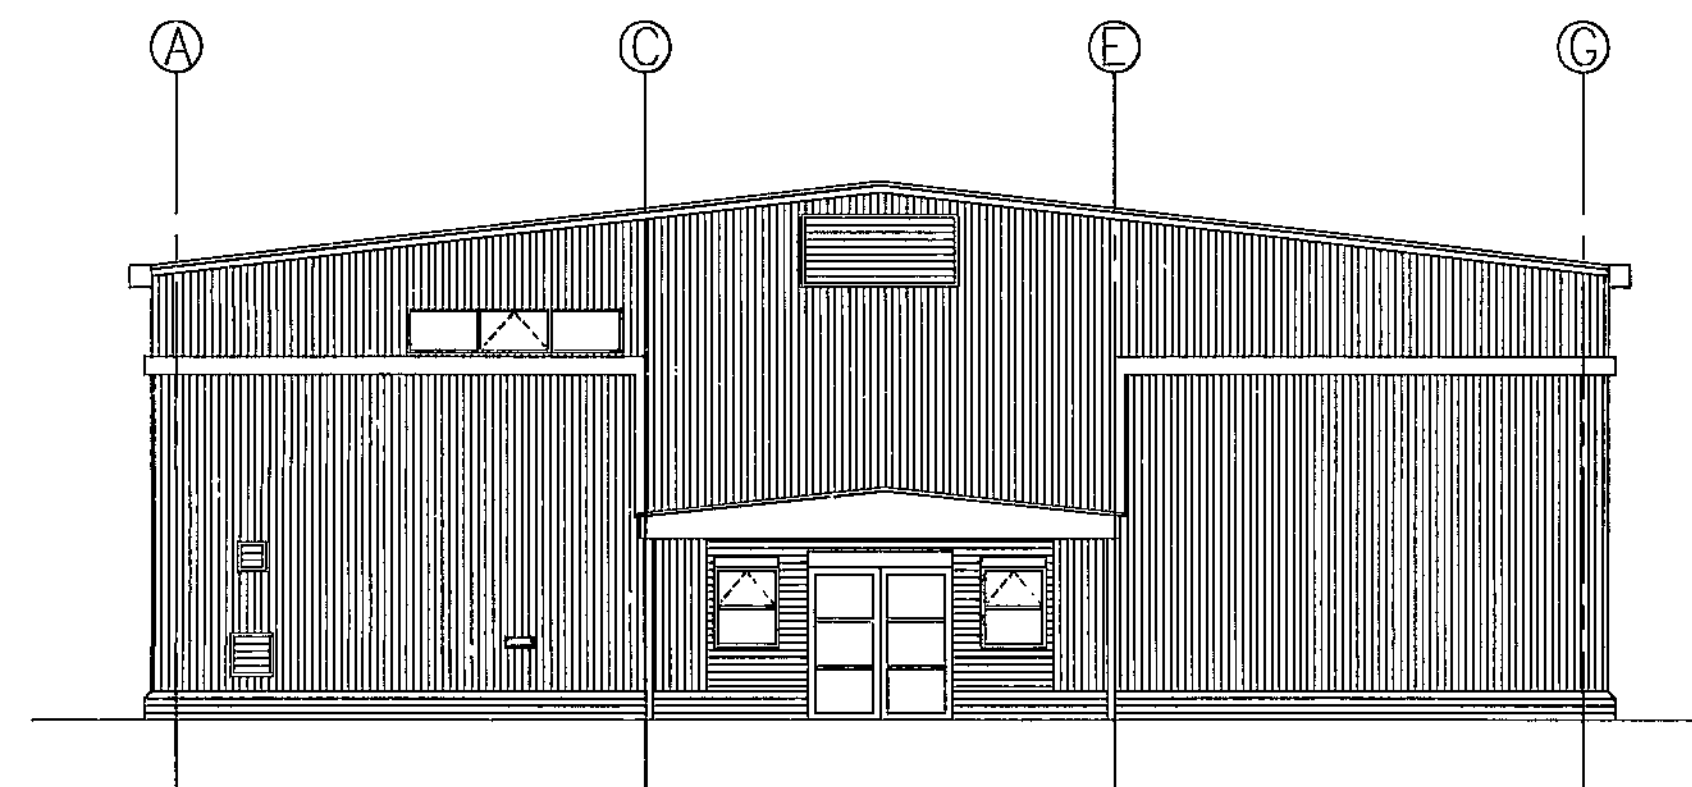

Existing South Elevation

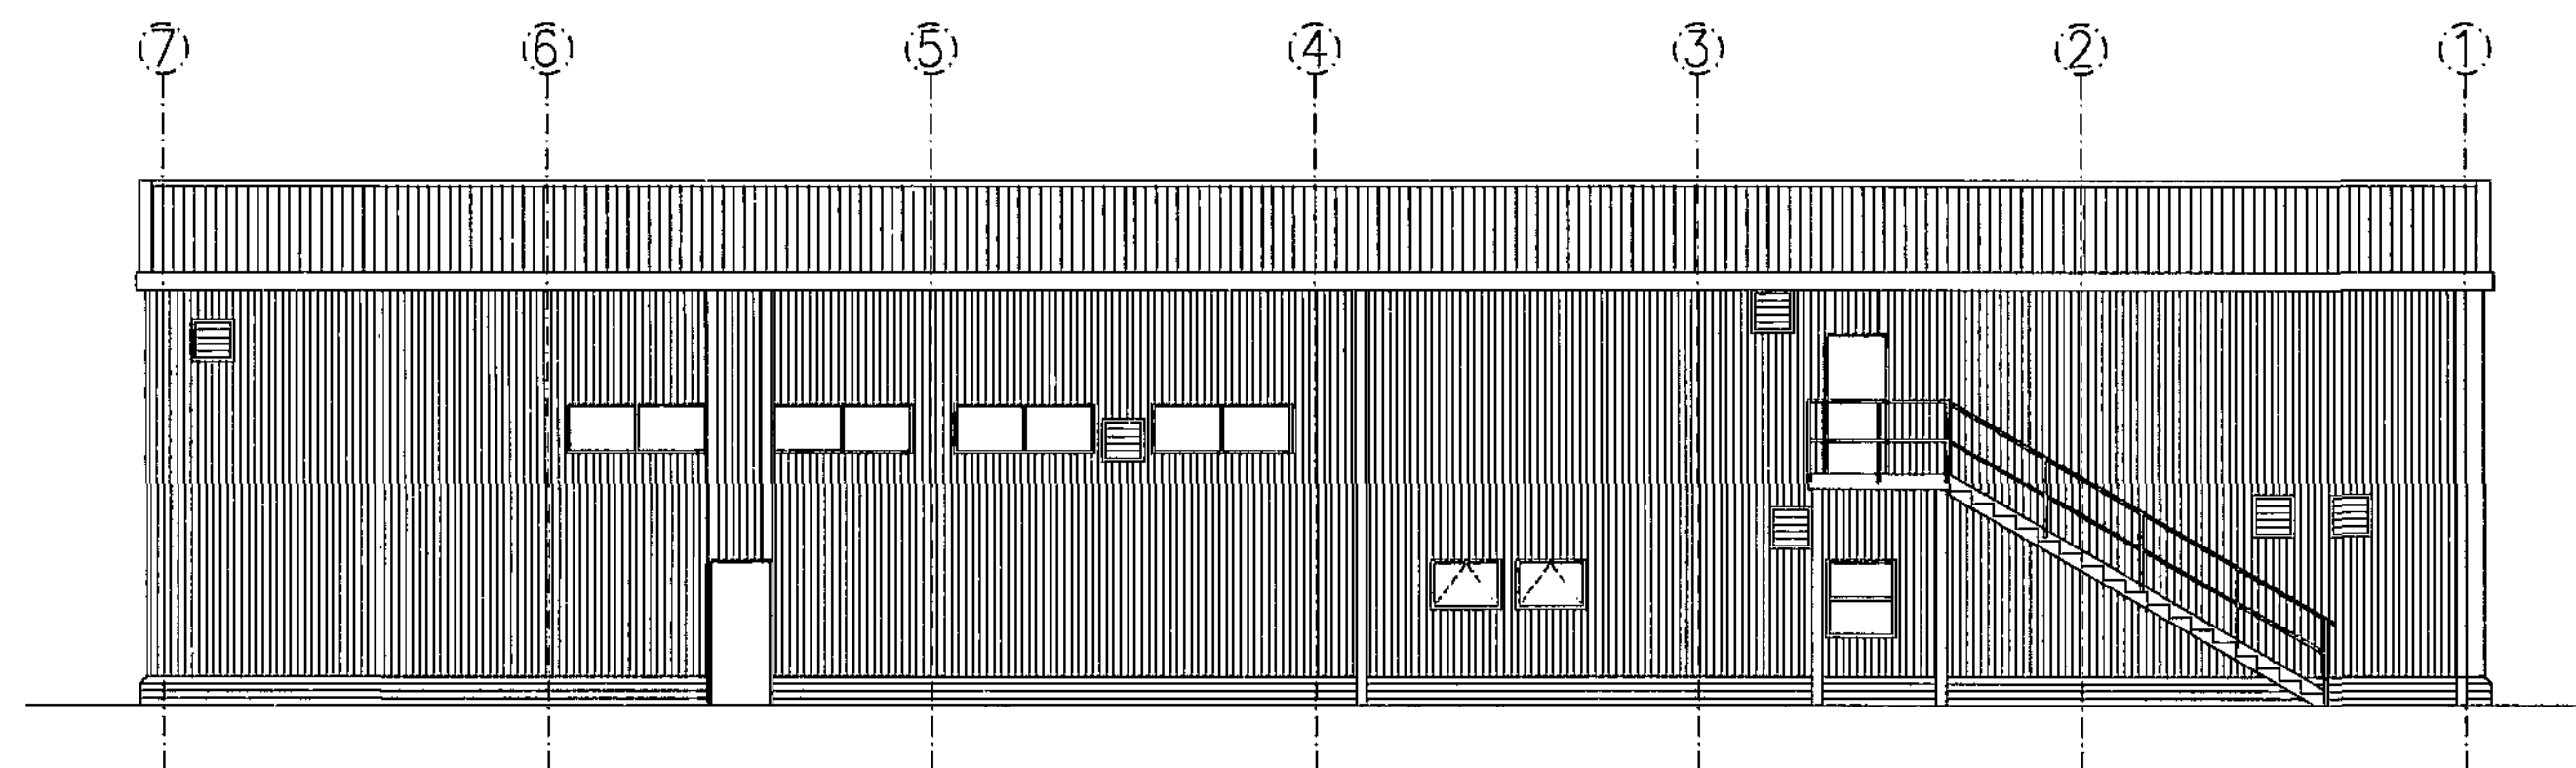

Existing West Elevation

Do not scale from this drawing.
The contractor is to check all dimensions on site
and report any discrepancies to the architect.
All rights reserved in chapter 17 of the
copyright, designs are patents and 1088
have been generally attached.

Planning Issue

B	19.11.10	Drawn: AL	Check: PP
Issued for Planning Approval			
A	12.11.10	Drawn: AL	Check: PP
Issued for tender			
-	13.08.10	Drawn: AL	Check: PP
Initial Issue			

Fulcrum
2 Sidney Street
Sheffield S1 4RH
Telephone +44(0)1142761651
Facsimile +44(0)1142799191
Website www.jeffersonsheard.com


**Jefferson
Sheard
Architects**

Drawn: AL Check: PP

Project:
Barnsley College
Performing Arts (Falcon Centre)

Drawing:
Existing Elevations

Scale 1:100@A1	Date 13.08.10
Ref. 0011	Number 0002
	Rev. B

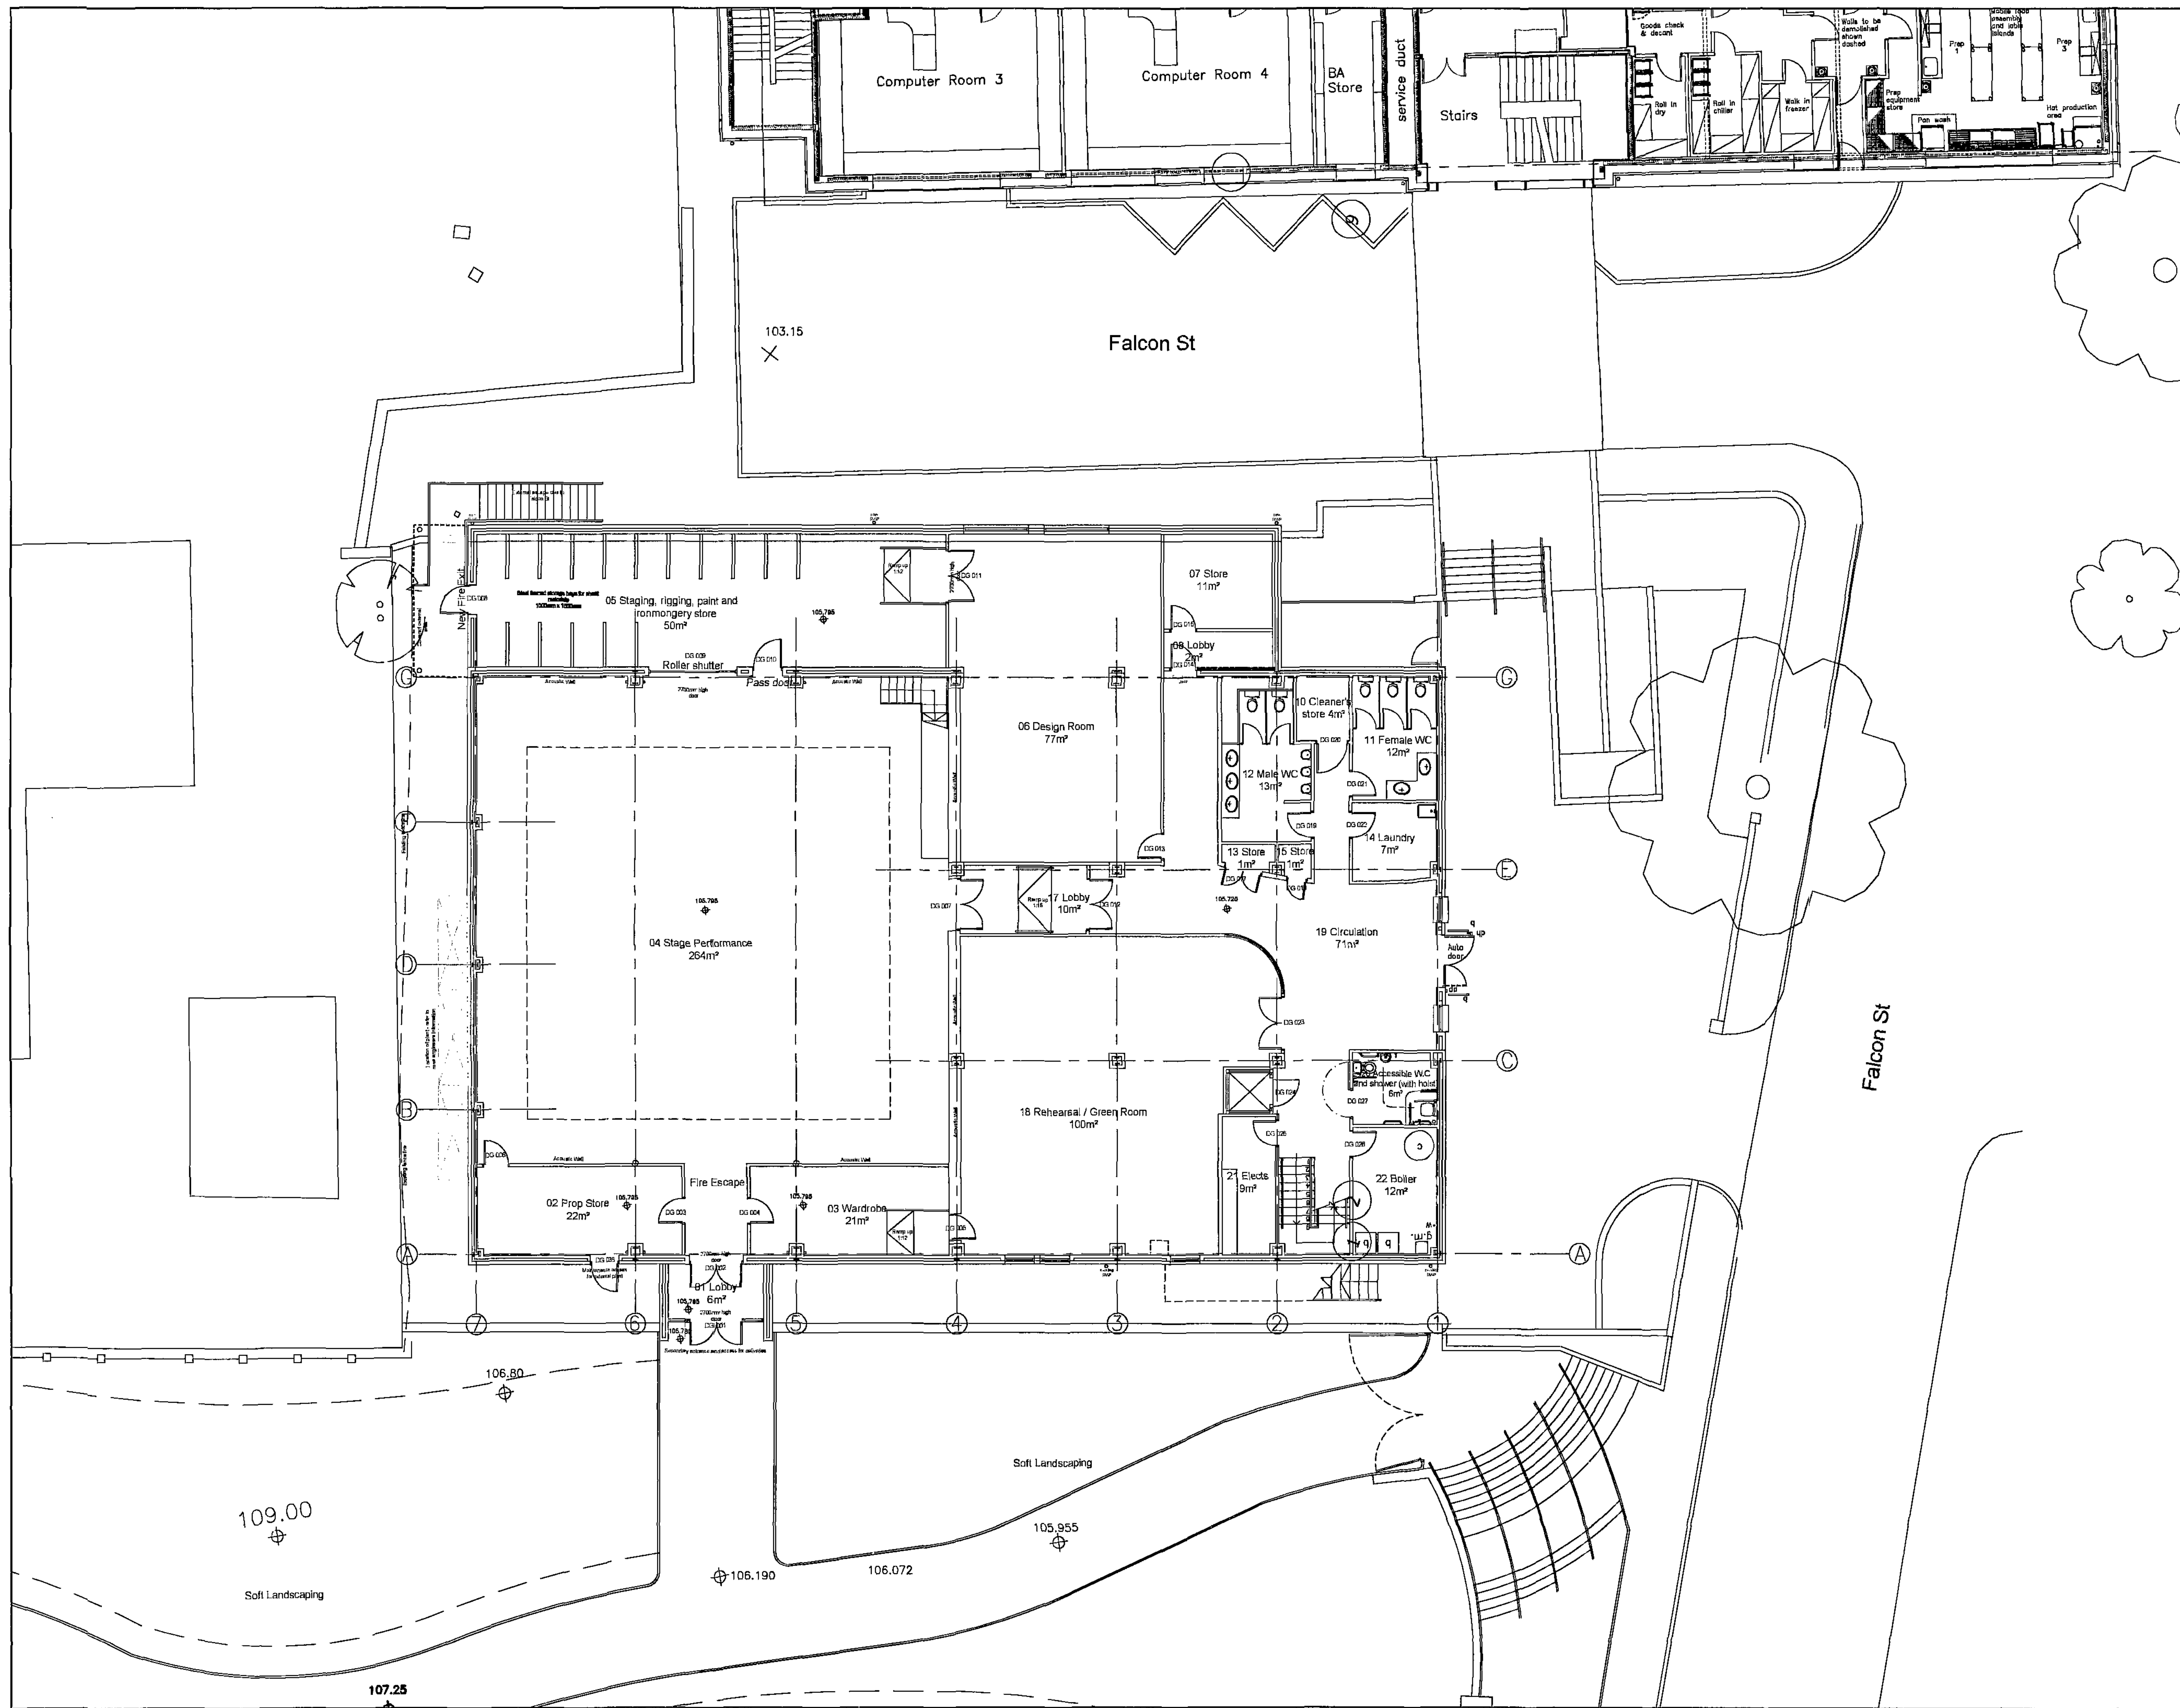

Do not scale from this drawing.
The contractor is to check all dimensions on site
and report any discrepancies to the architect.
All rights reserved in chapter IV of the
copyright, designs and patents act 1988
have been previously assigned.



Drawn: AL	Check: PP
-----------	-----------

Initial Issue

Pukem
 2 Sidney Street
 Sheffield S1 4RH
 Telephone +44(0)1142761651
 Facsimile +44(0)1142769191
 Website www.jeffersonsheard.com

**Jefferson
Sheard
Architects**

Scale 1:100@A1	Date 11.08.10
Ref. 0011	Number 2100.1
Rev.	

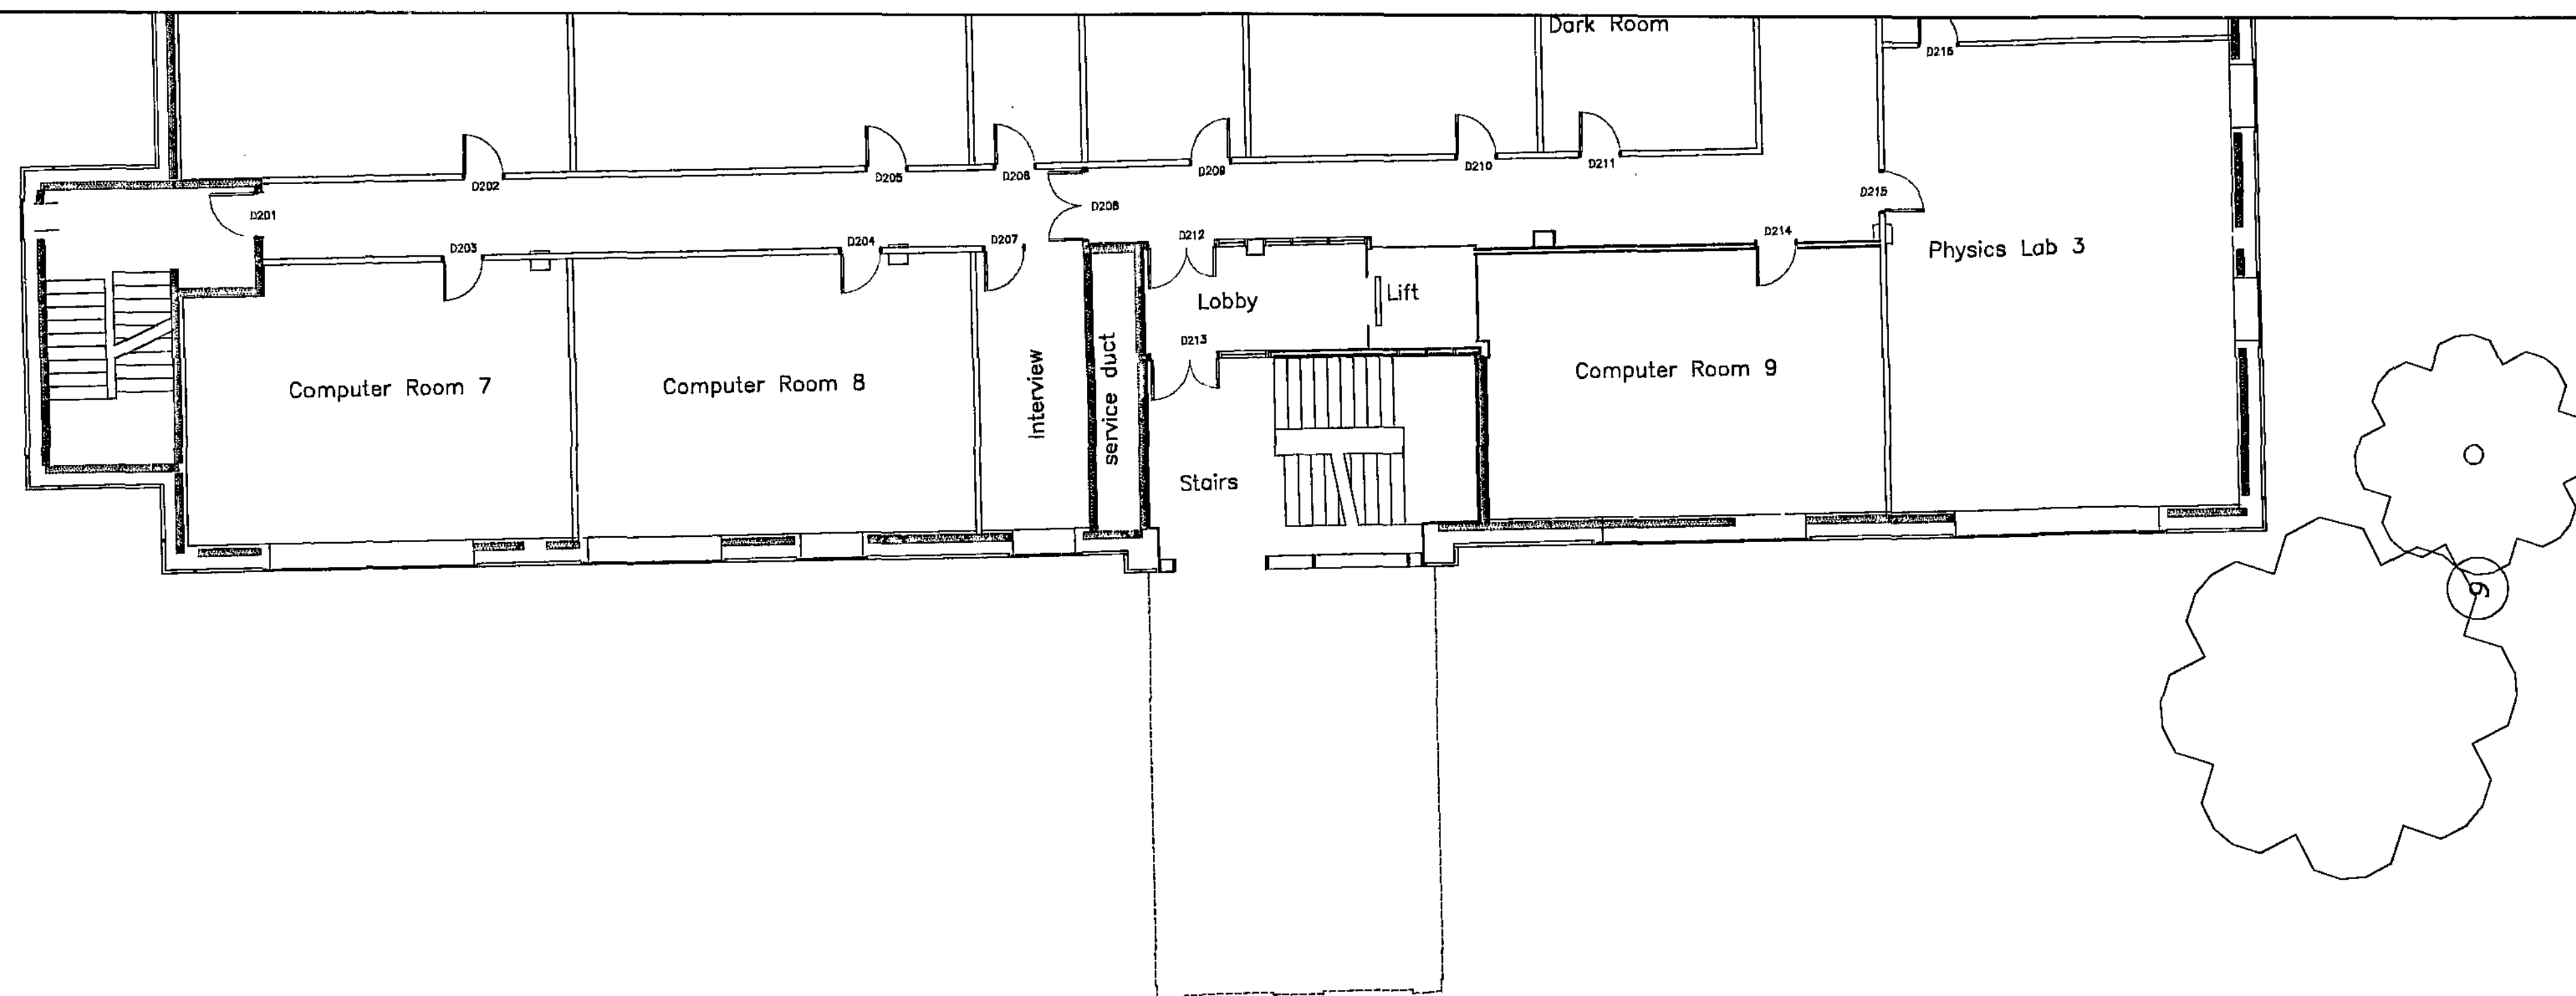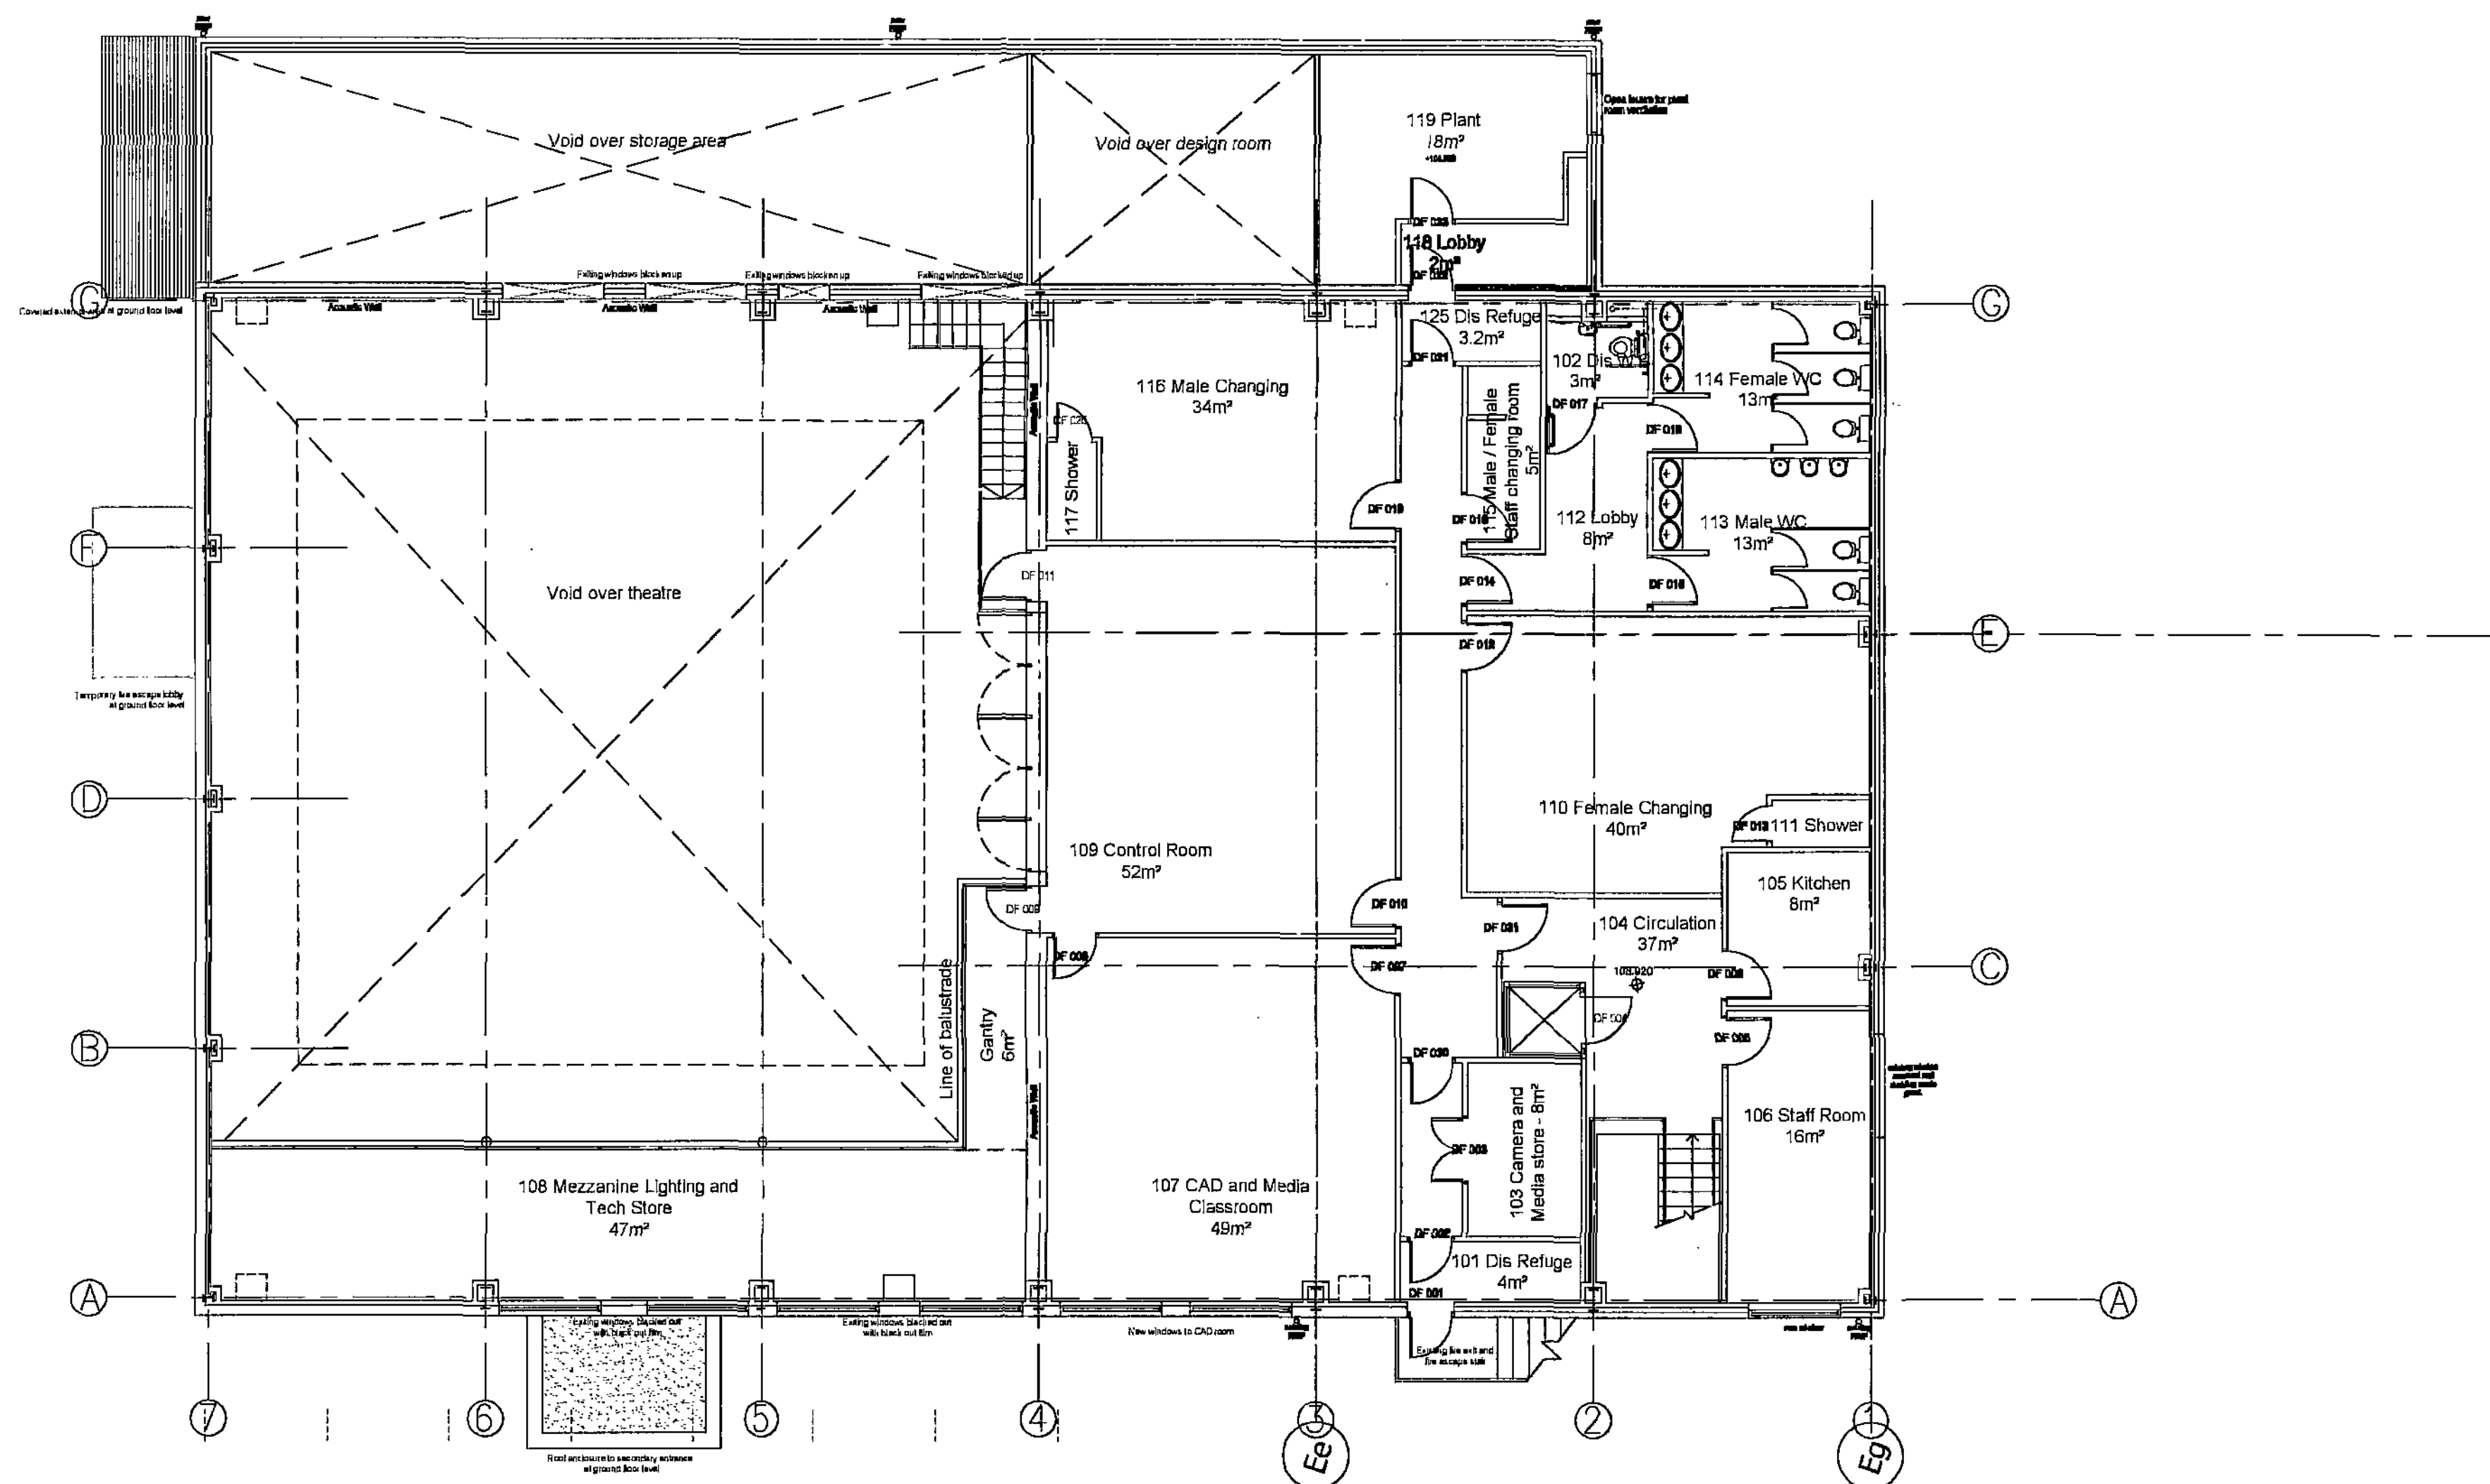

Do not scale from this drawing.
The contractor is to check all dimensions on site
and report any discrepancies to the architect.
All rights reserved in copyright of the
copyright, designs and patterns are 1988
have been previously assigned.

General Note:
For column positions refer to structural engineers
information

Drawn: - Check: -
1st Issue

Fulcrum
2 Sidney Street
Sheffield S1 4RH
Telephone: +44(0)114 2761551
Facsimile: +44(0)114 2750181
Website: www.jeffersonsheard.com

**Jefferson
Sheard
Architects**

Drawn: AL Check: PP

Project:
Barnsley College
Performing Arts (Falcon Centre)

Drawing:
Proposed First Floor Plan
Phase 1 Works

Scale: 1:100@A1	Date: 11-08-11
Ref: 0011	Number: 2101.1
	Rev:



Existing Sci -
Tech Centre

New double
height extension

Existing Falcon Centre

Covered external area

Existing fencing

Secondary entrance and
access for deliveries

Falcon St

Do not scale from this drawing
The contractor is to check all dimensions on site
and report any discrepancies to the architect
All rights described in clause 11 of the
copyright, design and patents act 1988
have been previously assigned

Initial issue	Drawn:	Check:
---------------	--------	--------

Fulcrum
2 Sidney Street
Sheffield S1 4PH
Telephone +44(0)1142761651
Facsimile +44(0)1142761691
Website: www.jeffersonsheard.com

**Jefferson
Sheard
Architects**





Drawn: AL	Check: PP
-----------	-----------

Project
Barnsley College
Performing Arts (Falcon Centre)

Drawing
Proposed Roof Level Plan
Phase 1 Works

Scale 1:100@A1	Date 11-08-2011
Ref. 0011	Number 2102.1
Rev.	

Do not scale from this drawing
The contractor to check all dimensions on site
and report any discrepancies to the architect
All rights reserved in respect of other
copyright, design and patent and 1998
have been generally assumed

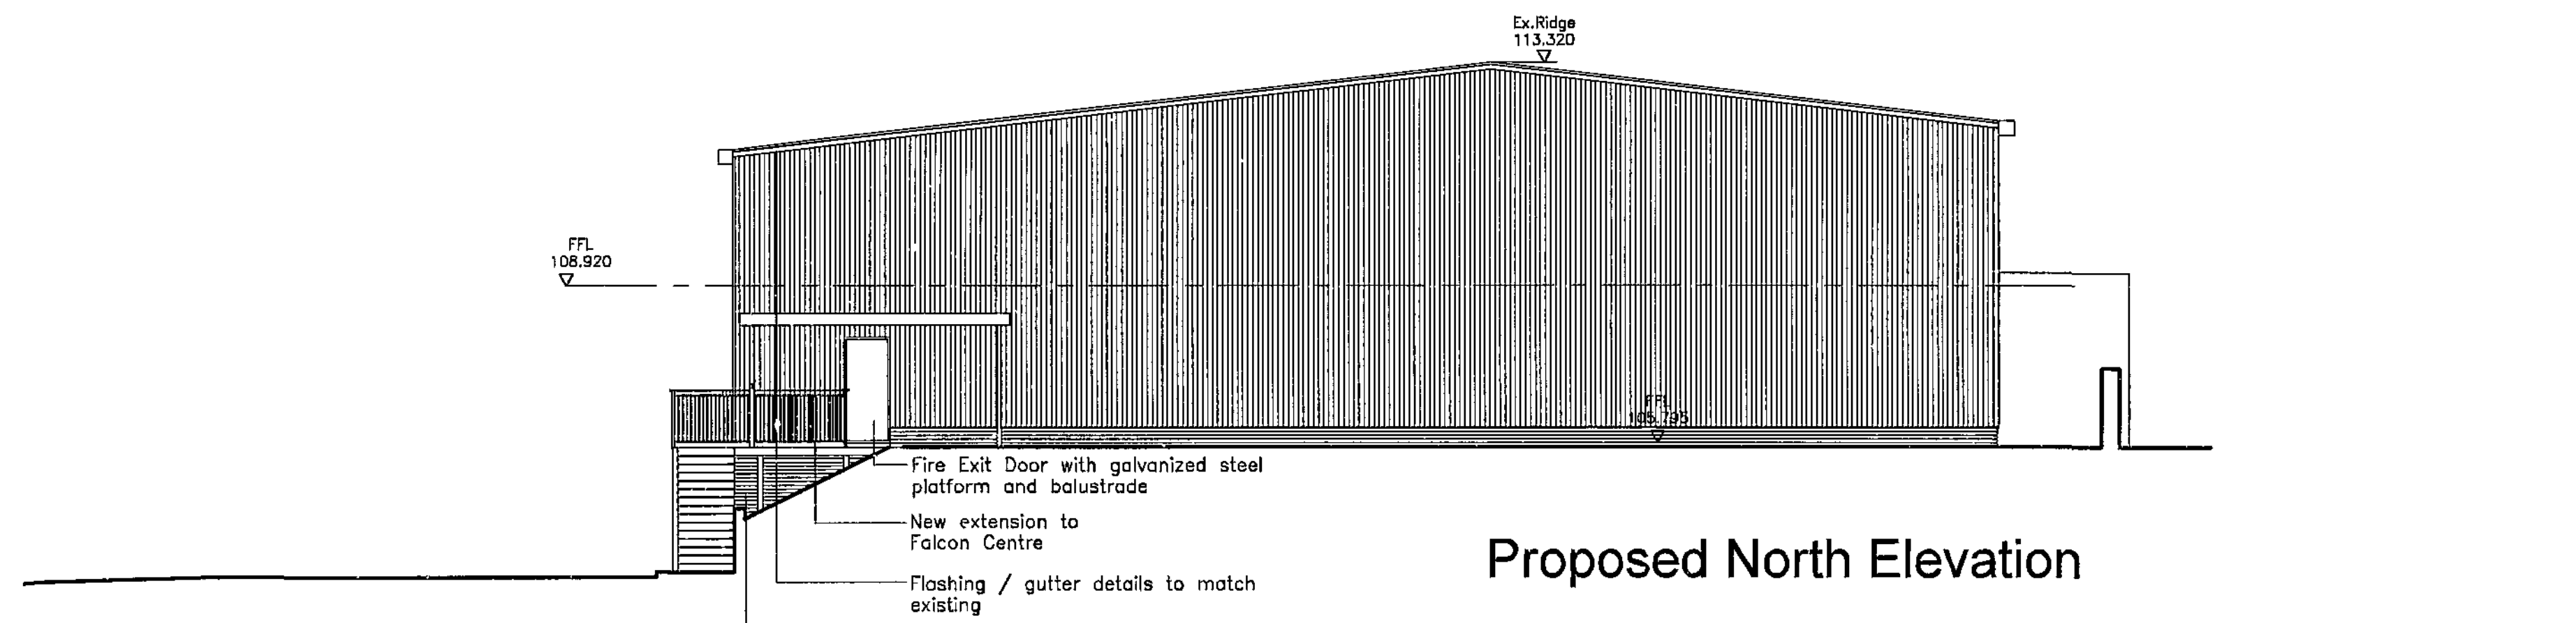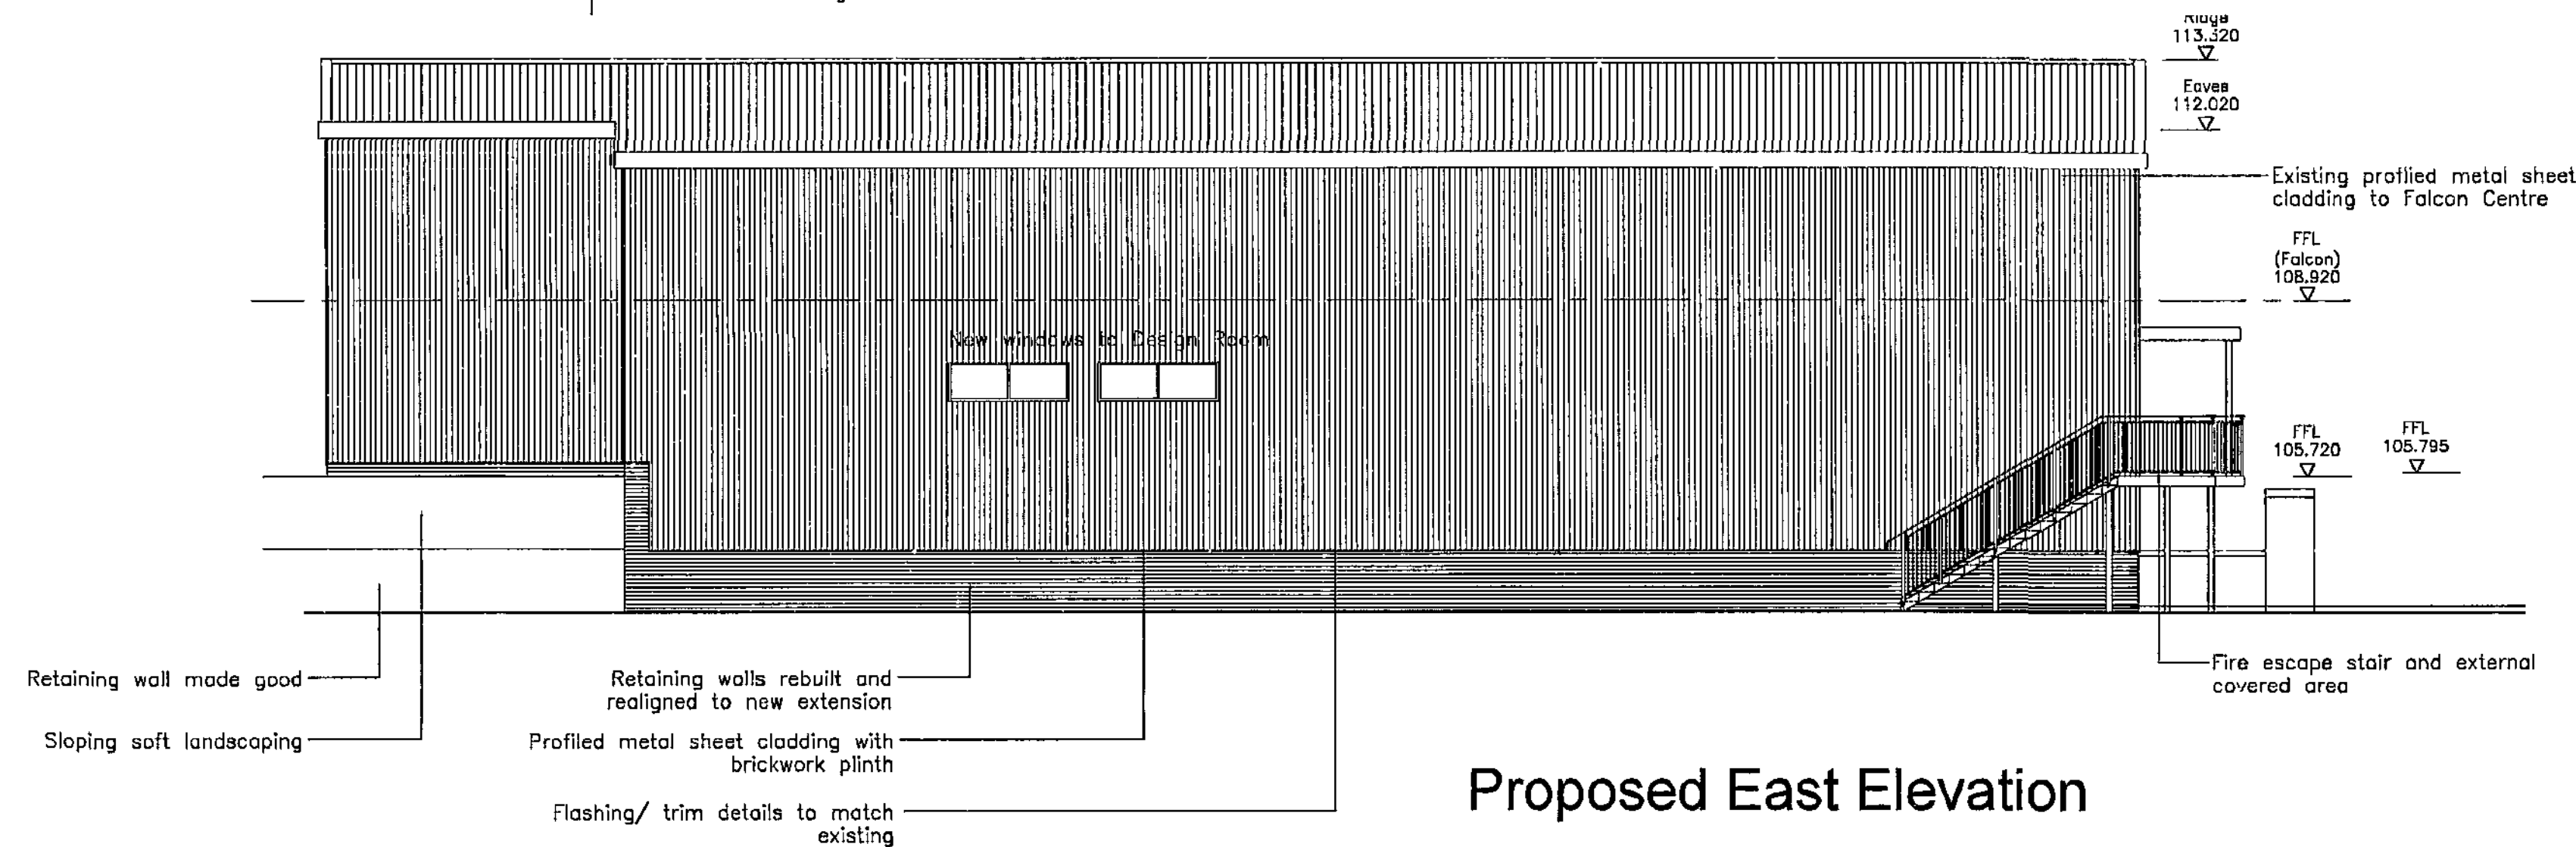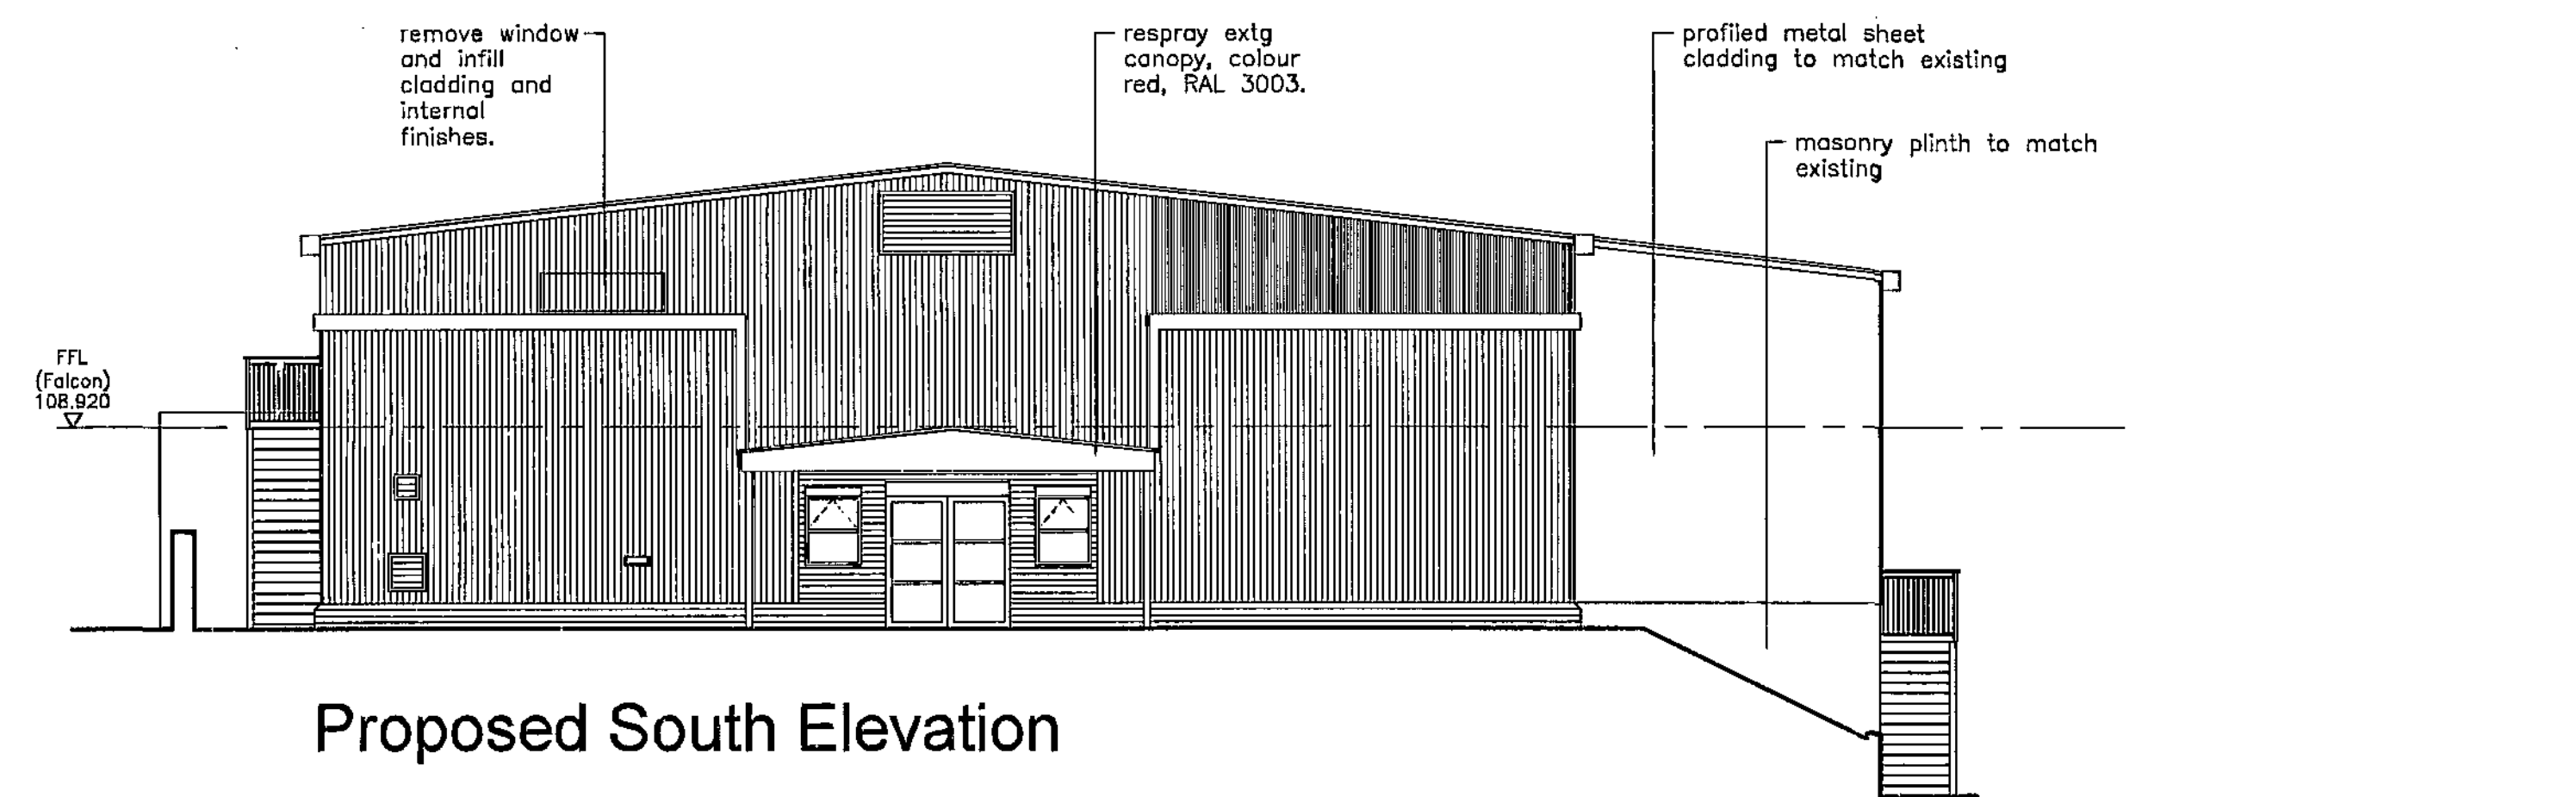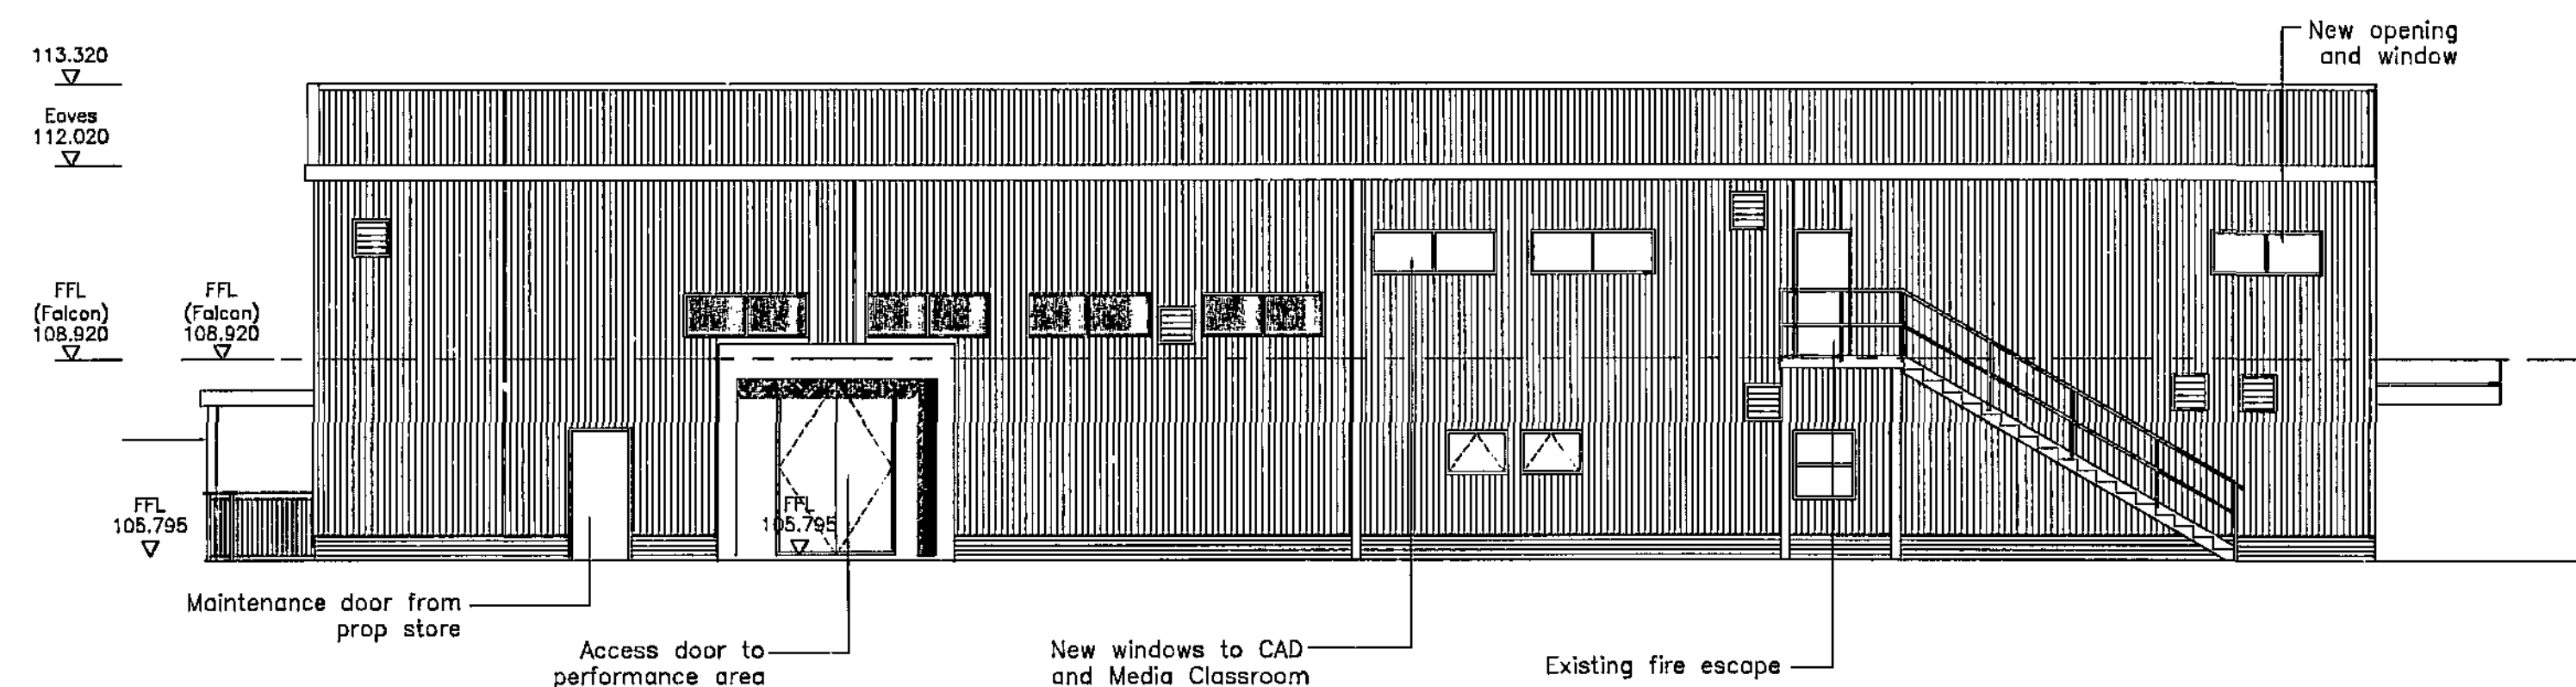

Initial Issue	Drawn: -	Check: -
---------------	----------	----------

Fulcrum
2 Slinway Street
Sheffield S1 4PH
Telephone +44(0)1142761651
Facsimile +44(0)1142756191
Website www.fulcrumarchitects.com


Jefferson Sheard Architects

Project
Barnsley College
Performing Arts (Falcon Centre)


Drawing
Proposed GA Elevations
Phase 1 Works

Scale 1:100@A1	Date 11-08-2011
Ref. 0011	Rev. 3100.1

Section A-A OMITTED

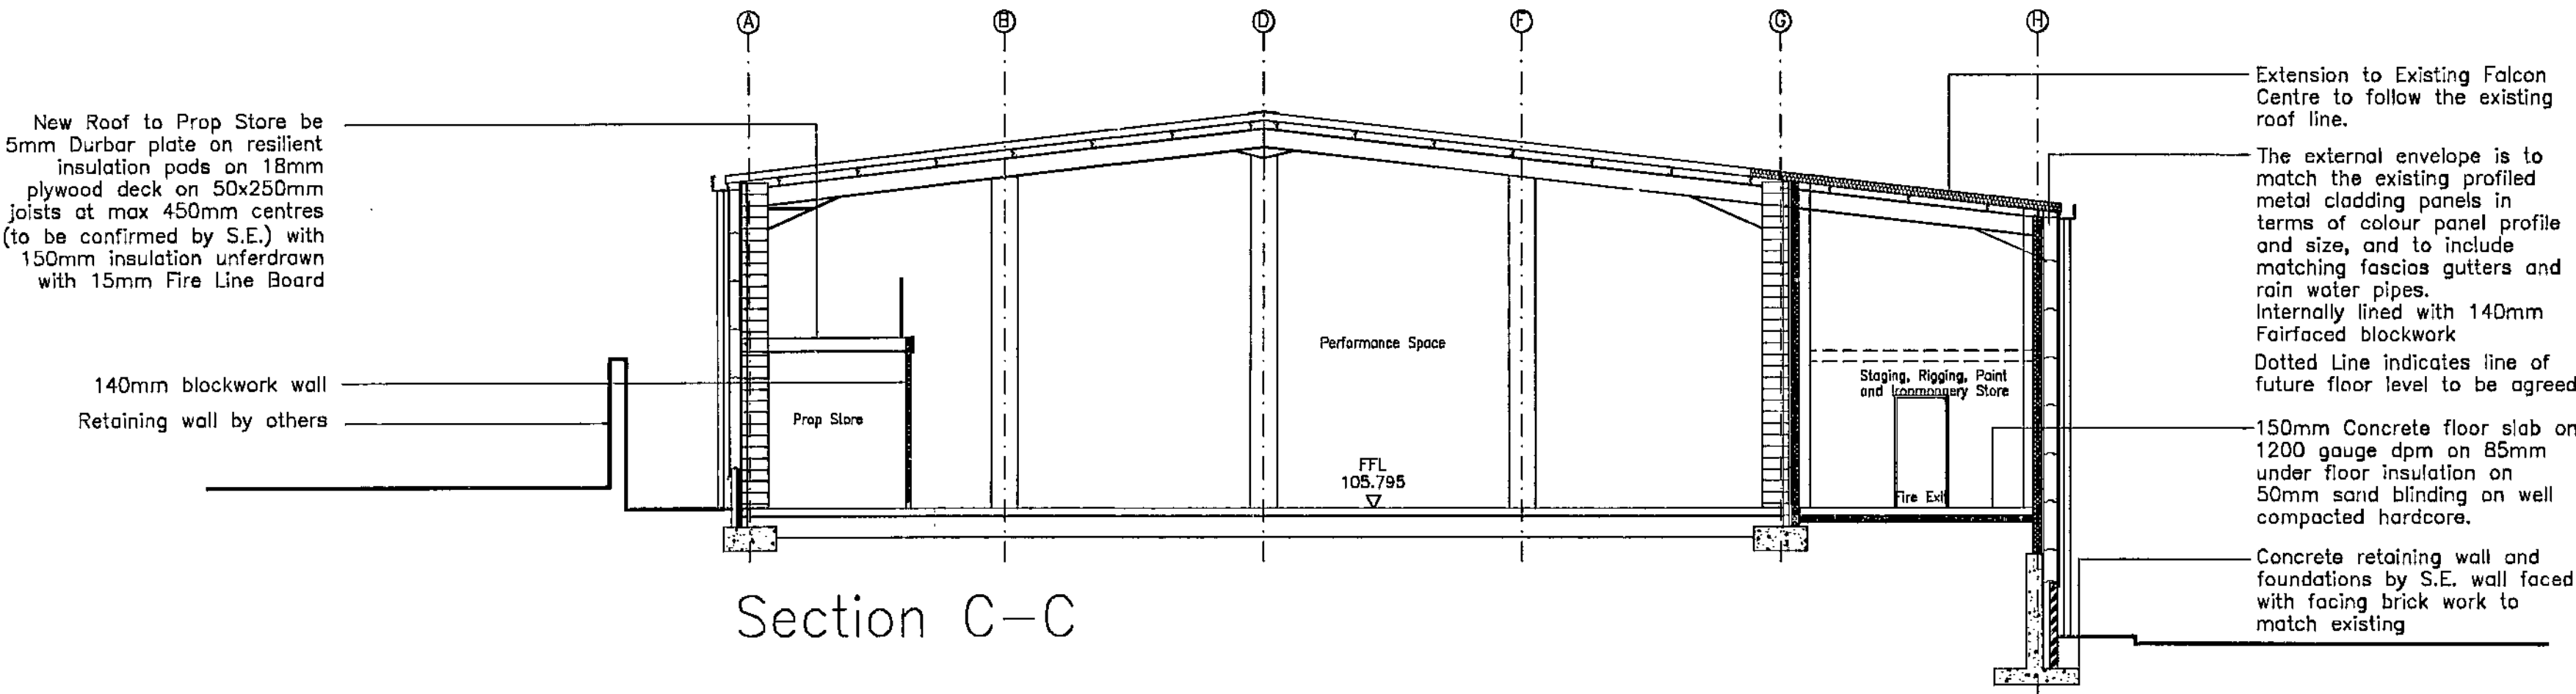

Section Location Key

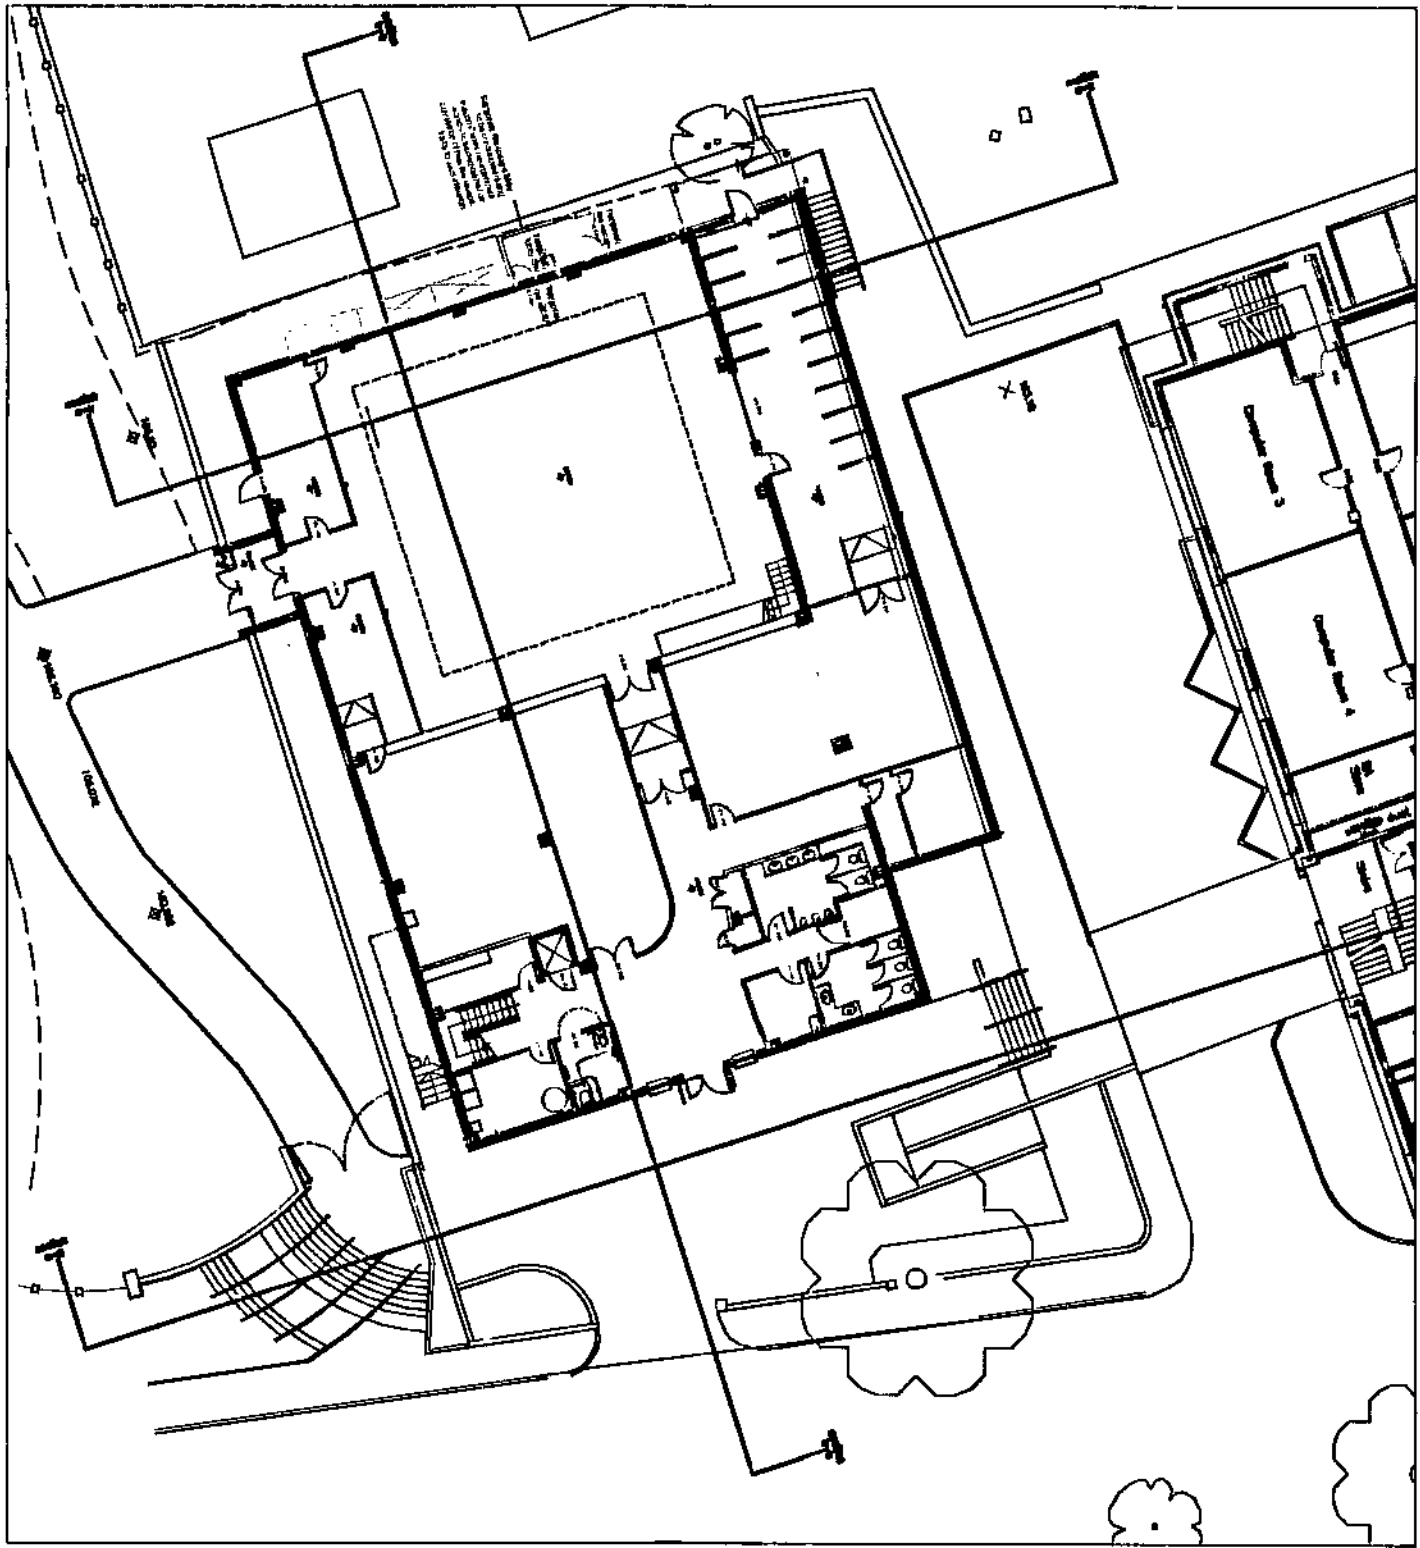

Do not scale from this drawing
The contractor is to check all dimensions on site
and report any discrepancies to the architect
All rights reserved in copyright by the
copyright, design and patents act 1988
have been properly secured

Drawn: AL Check: PP
Initial Issue

Fulcrum
2 Station Street
Sheffield S1 4SE
Telephone +44(0)1142761691
Facsimile +44(0)1142766181
Website www.jeffersonsheard.com


Jefferson Sheard Architects

Project
Barnsley College
Performing Arts Centre


Drawing
Sections A - A C - C
Phase 1 Works

Scale	Date	
1:100@A1	11-08-2011	
Ref.	Number	Rev.
0011	4101.1	

Do not scale from this drawing
The contractor is to check all dimensions on site
and report any discrepancies to the architect
All rights reserved in copyright of the
copyright design and patents are held
have been generally issued

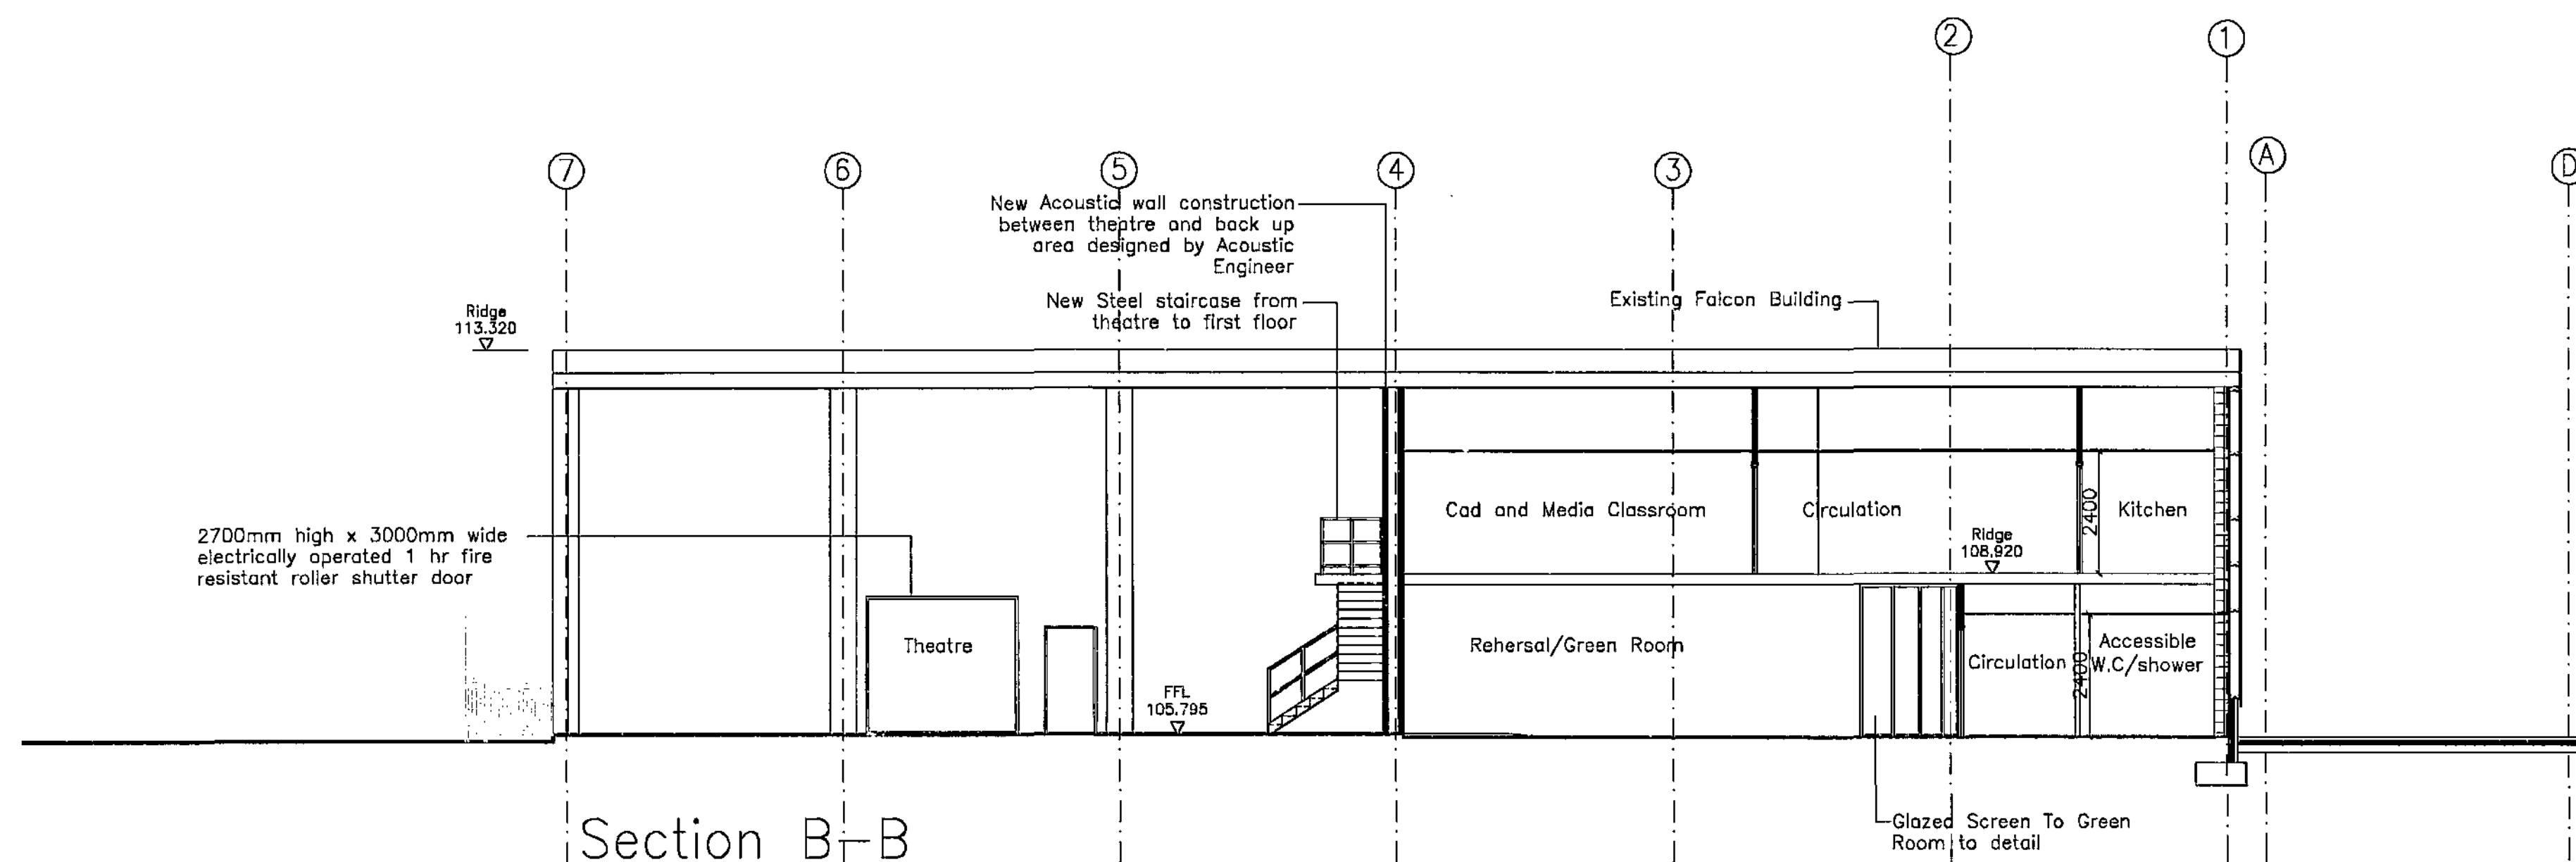

Section Location Key

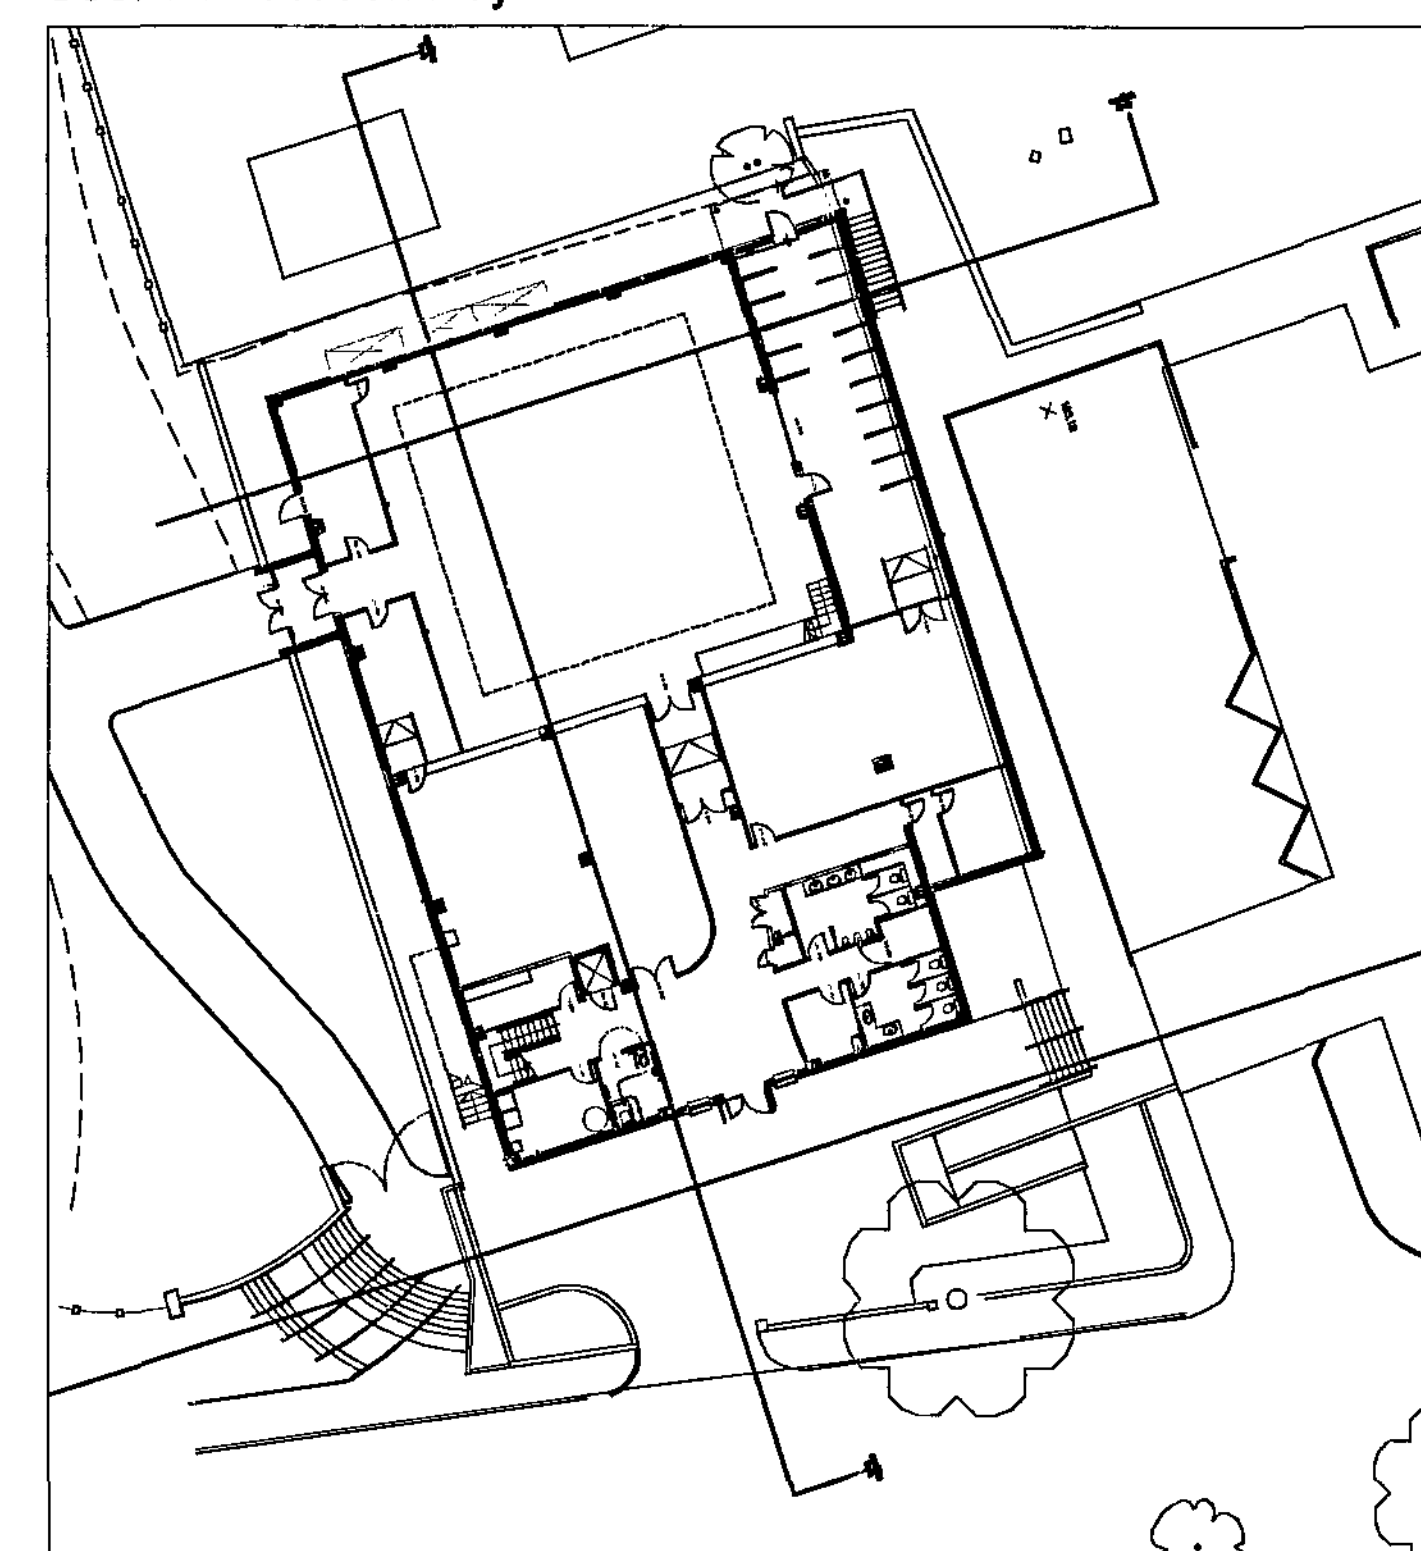

Initial Issue

Fidrum
2 Sidney Street
Sheffield S1 4BH
Telephone +44(0)1142761661
Facsimile +44(0)1142766181
Website www.jeffersonsheard.com

**Jefferson
Sheard
Architects**

Drawn: GM Check: PP

Project
Barnsley College
Performing Arts Centre

Drawing
Sections B-B
Phase 1 Works

Scale 1:100@A1	Date 11-08-2011
Ref. 0011	Number 4102.1
	Rev.