




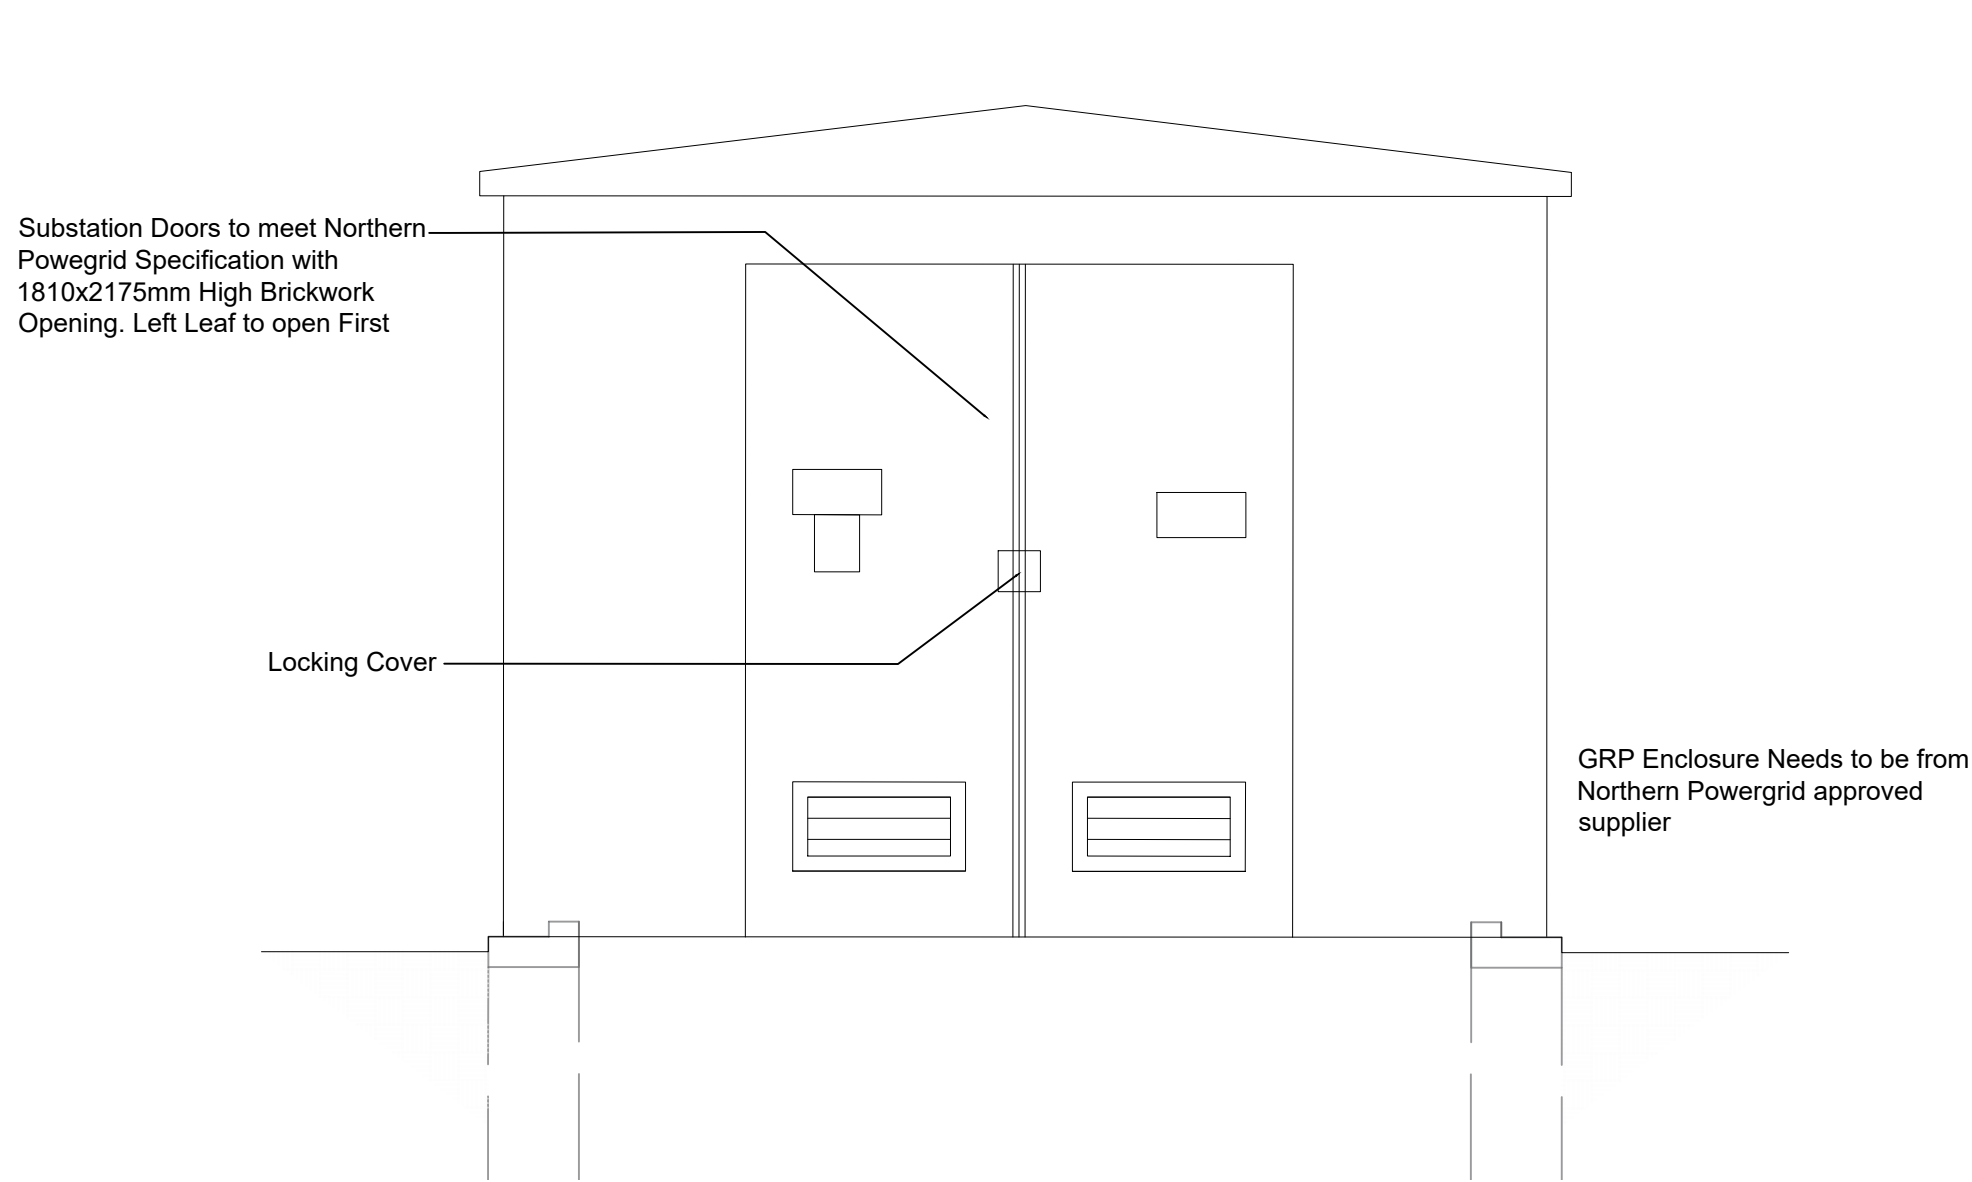


Front Elevation Scale 1:25

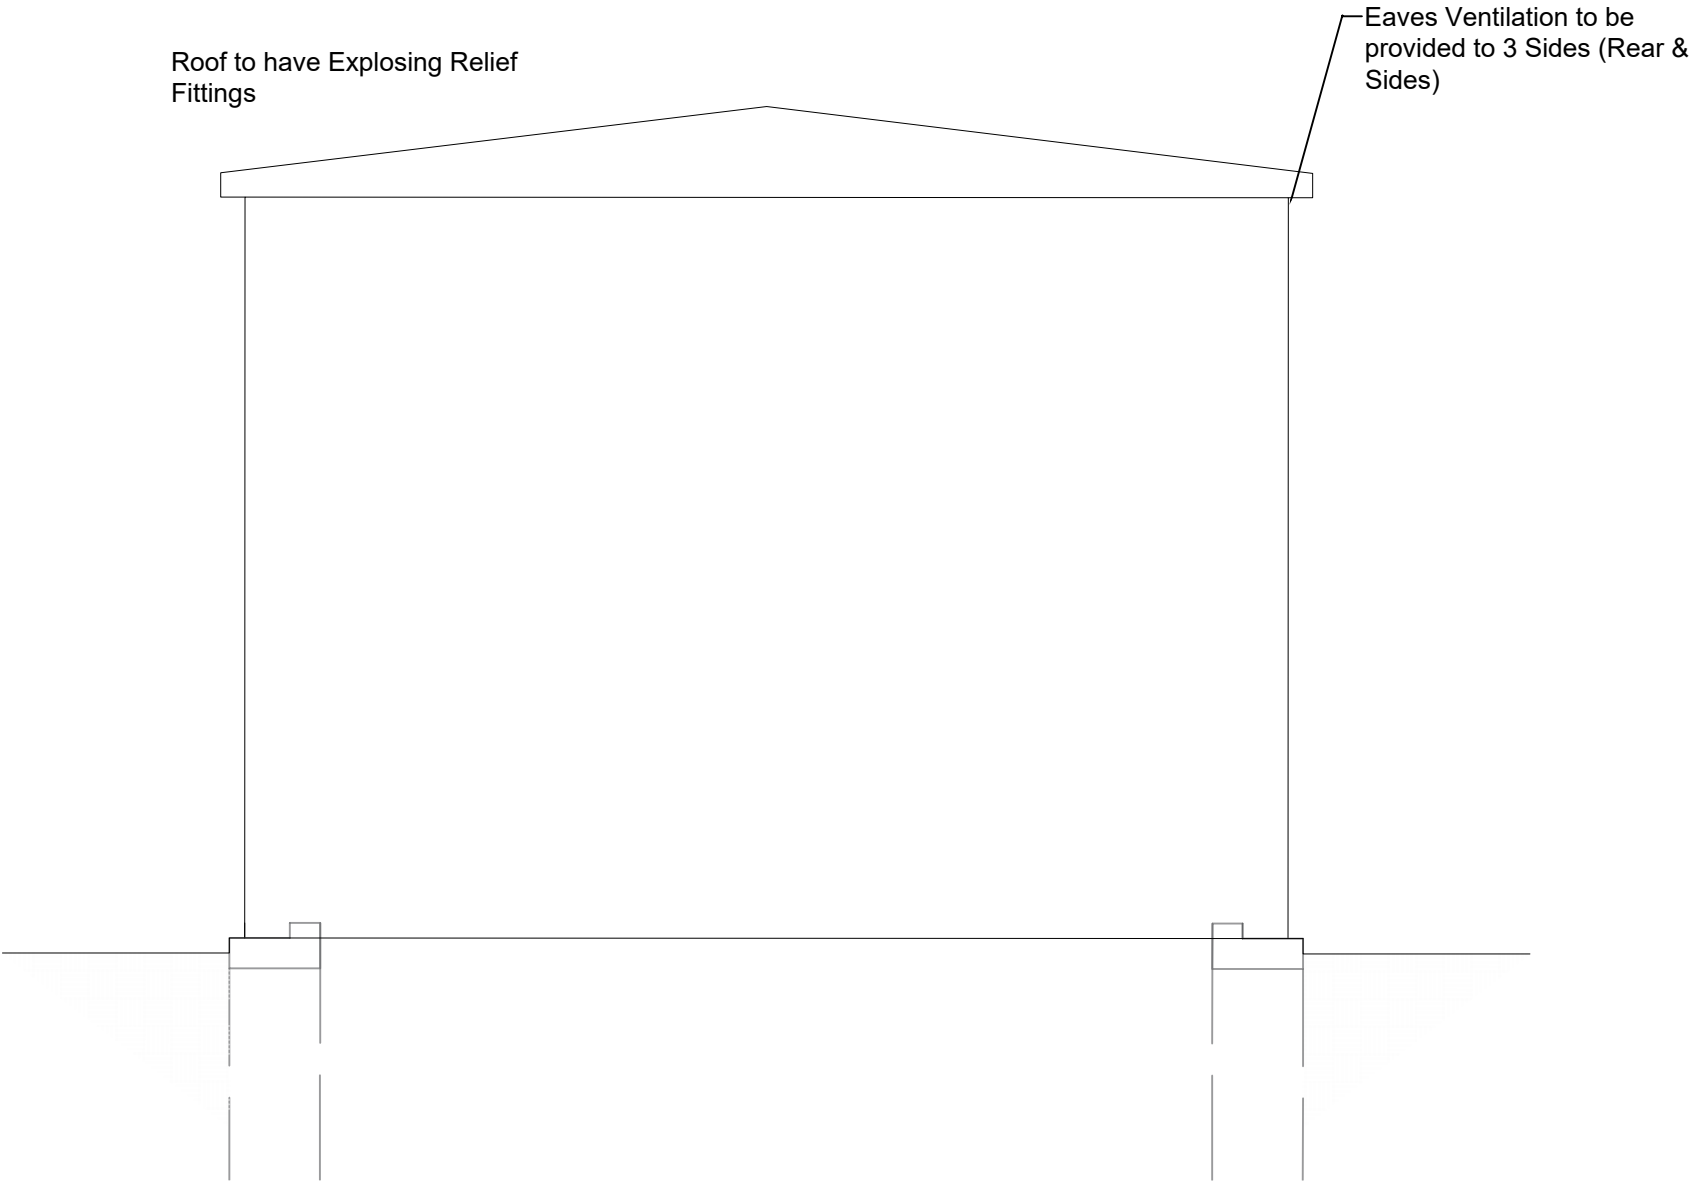


Rear Elevation Scale 1:25

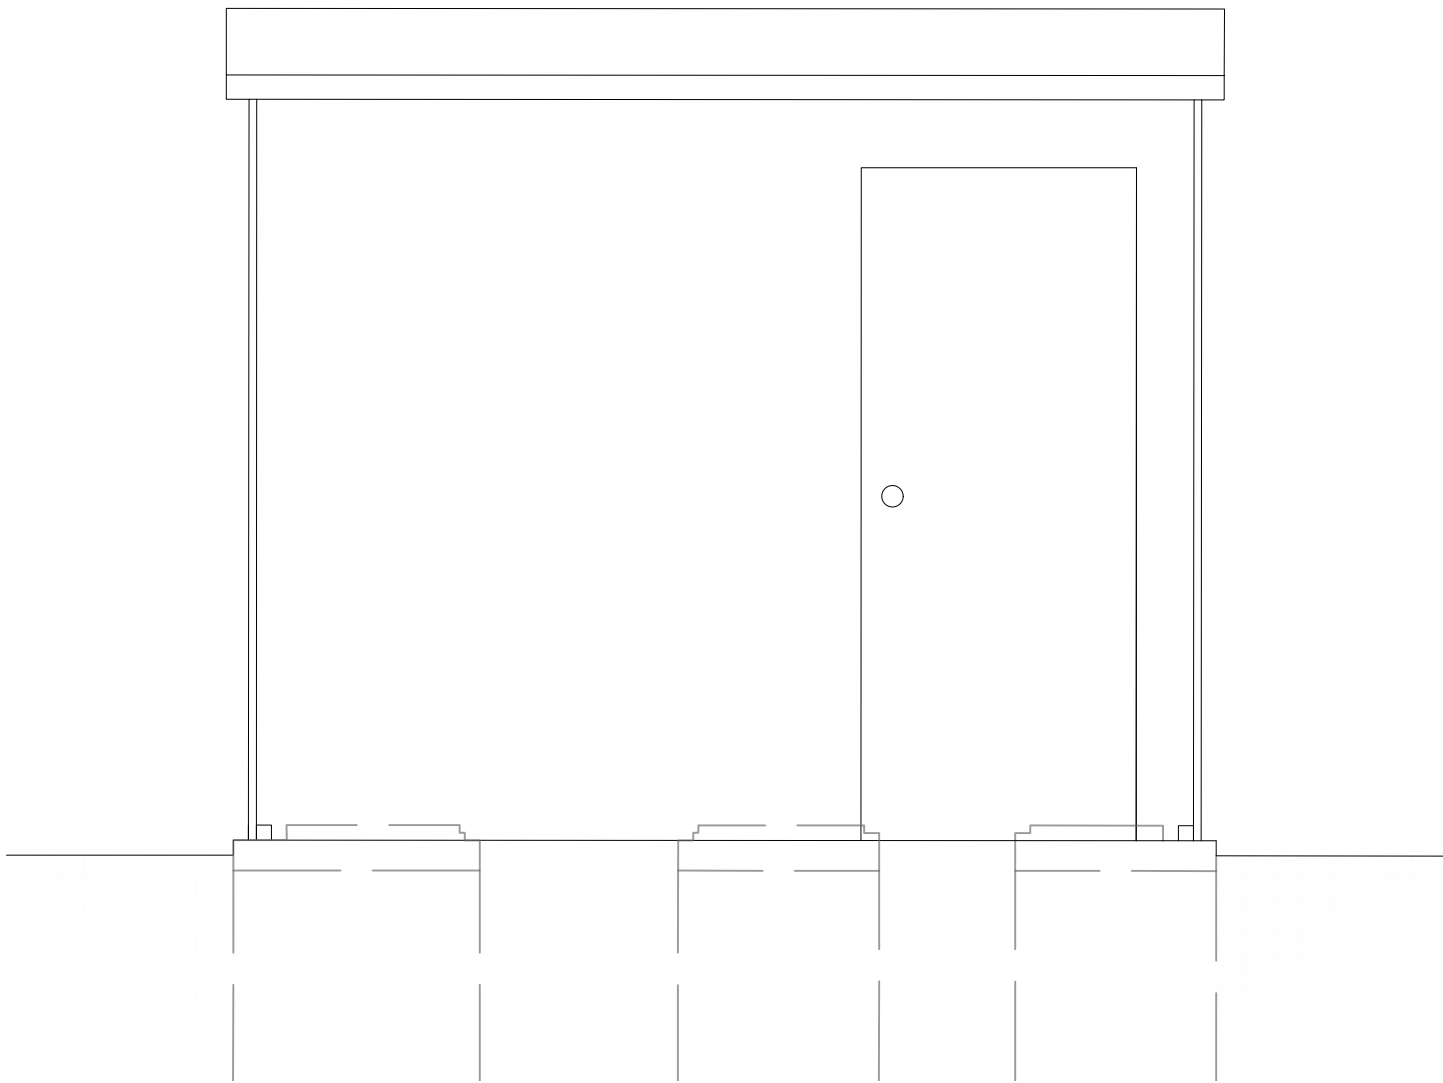

Side Elevation Scale 1:25

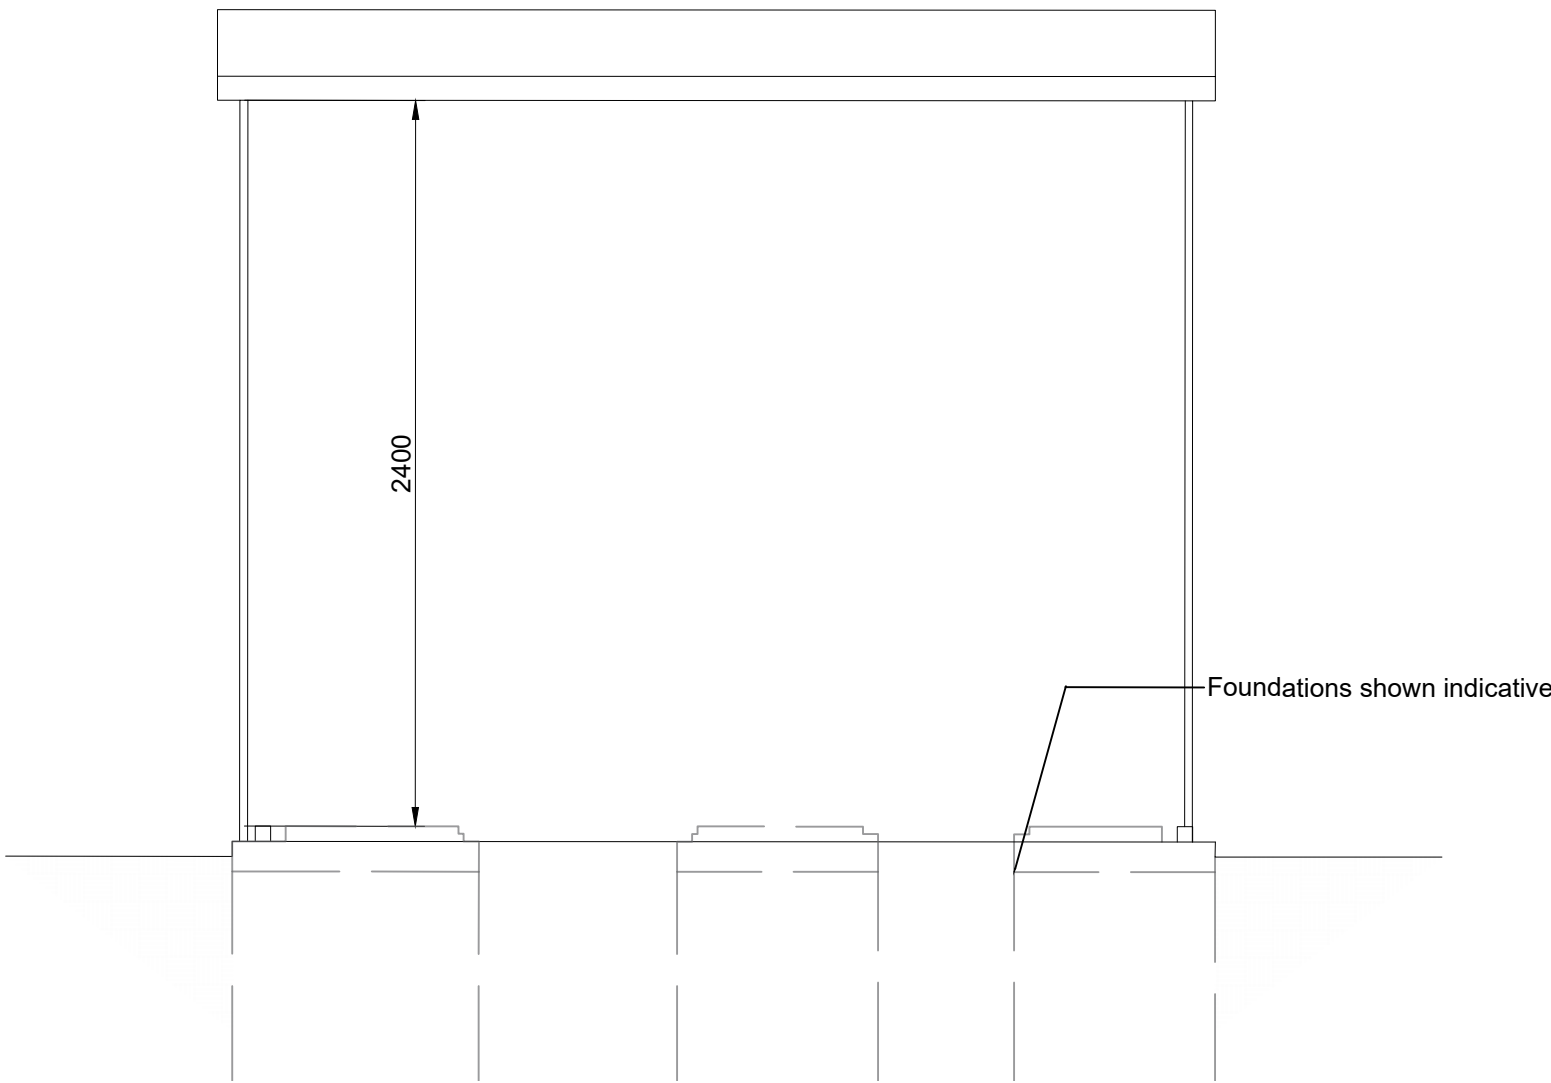


Side Elevation Scale 1:25

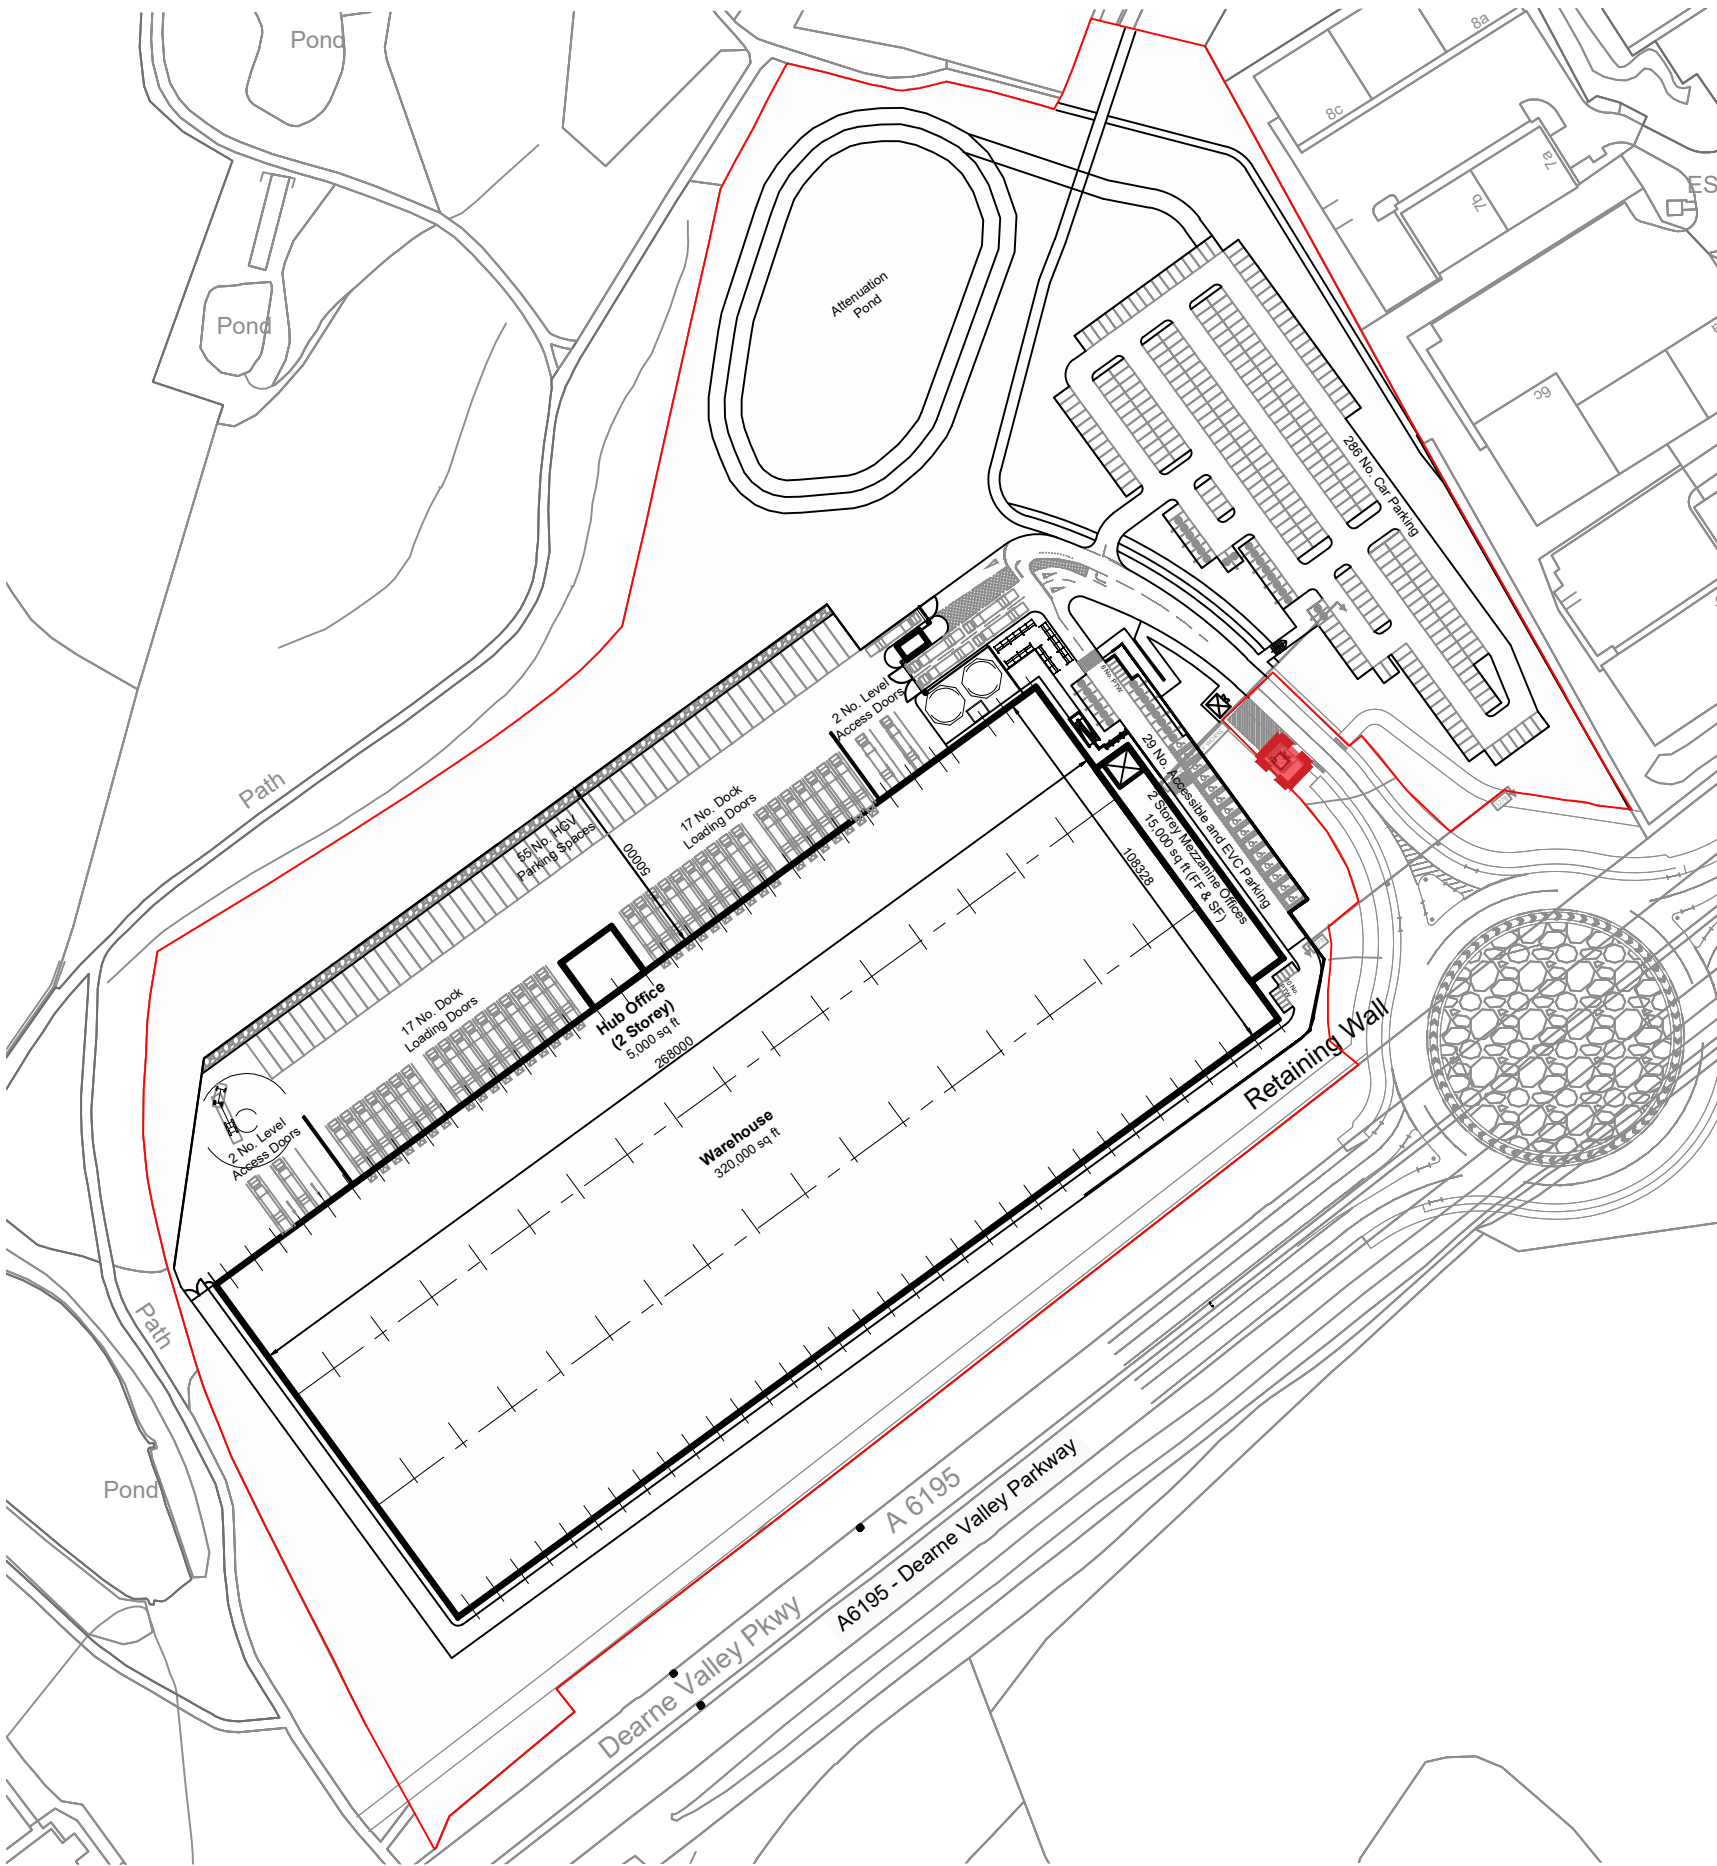

Site Plan Scale 1:2000

- Dimensions are in millimeters, unless stated otherwise.
- Scaling of this drawing is not recommended.
- It is the recipients responsibility to print this document to the correct scale.
- All relevant drawings and specifications should be read in conjunction with this drawing.

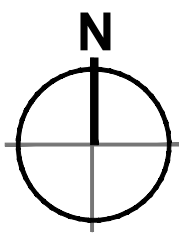


Key

Demise Boundary



Denotes Location of Substation.

NOTE: Substation finishes colour:
RAL 18-B-25 Merlin Grey

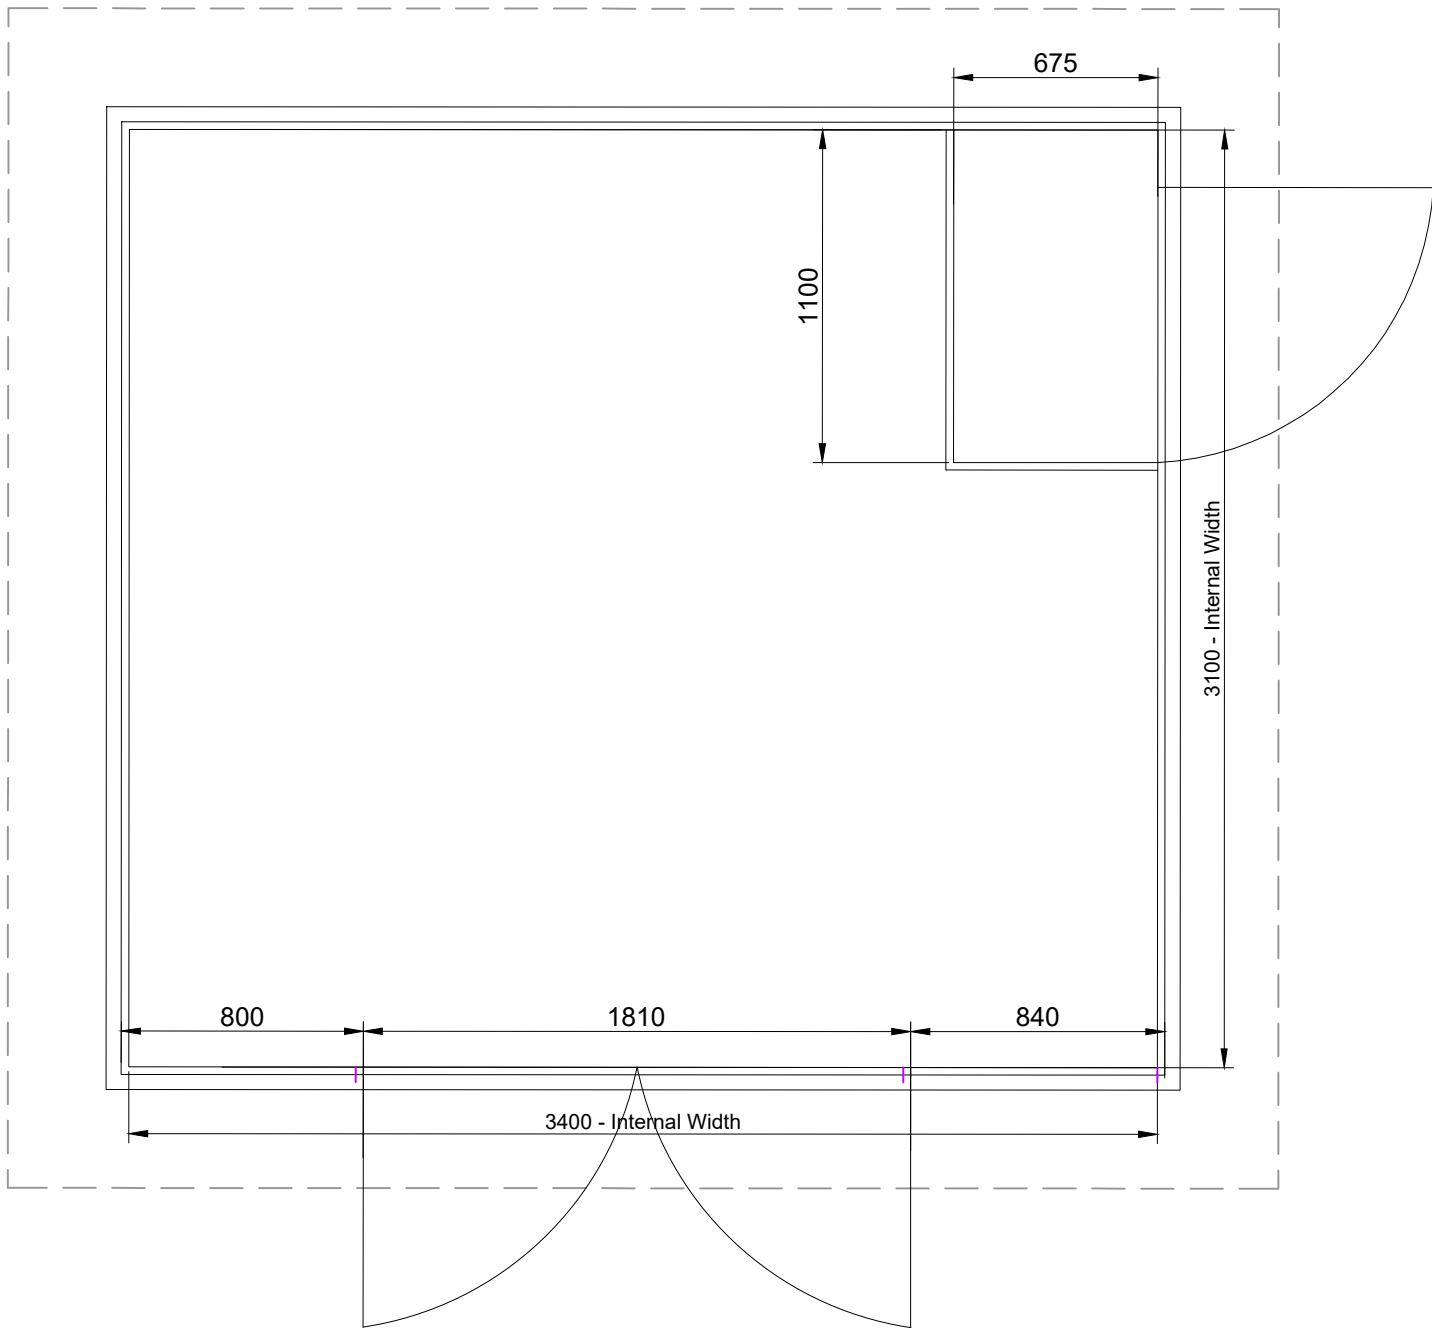

Substation Plan Scale 1:25



rev	amendments	by	ckd	date
-----	------------	----	-----	------

Dearne Valley Parkway, Barnsley

Substation no. 2 Details

Information Container LOD:

Verified

FirethornTRUST
Glencar
CONSTRUCTION

umc
architects
3rd Floor, Manchester Club, 81 King Street, Manchester, M2 4AH
t: +44 (0)161 413 0590 e: info@umcarchitects.com

RIBA PoW Stage:	3 - Spatial Coordination
Document Suitability:	S1
Drawn / Checked:	CO / BSC
Date:	31/05/2023
Scale:	As shown @A1
UMC Project Number:	21049
Document Reference:	Drawing no: Revision:
G1144 - UMC -ZZ-XX - DR - A	00705 P03

PLANNING