




SITE PHOTOGRAPHS

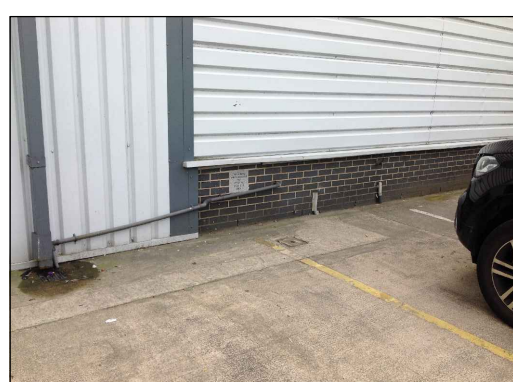


SITE ADDRESS
CITY PLUMBING SUPPLIES LIMITED
UNIT 4, WHARFCLIFFE BUSINESS PARK
MIDDLEWOODS WAY
CARLTON, BARNSELEY
S71 3HK

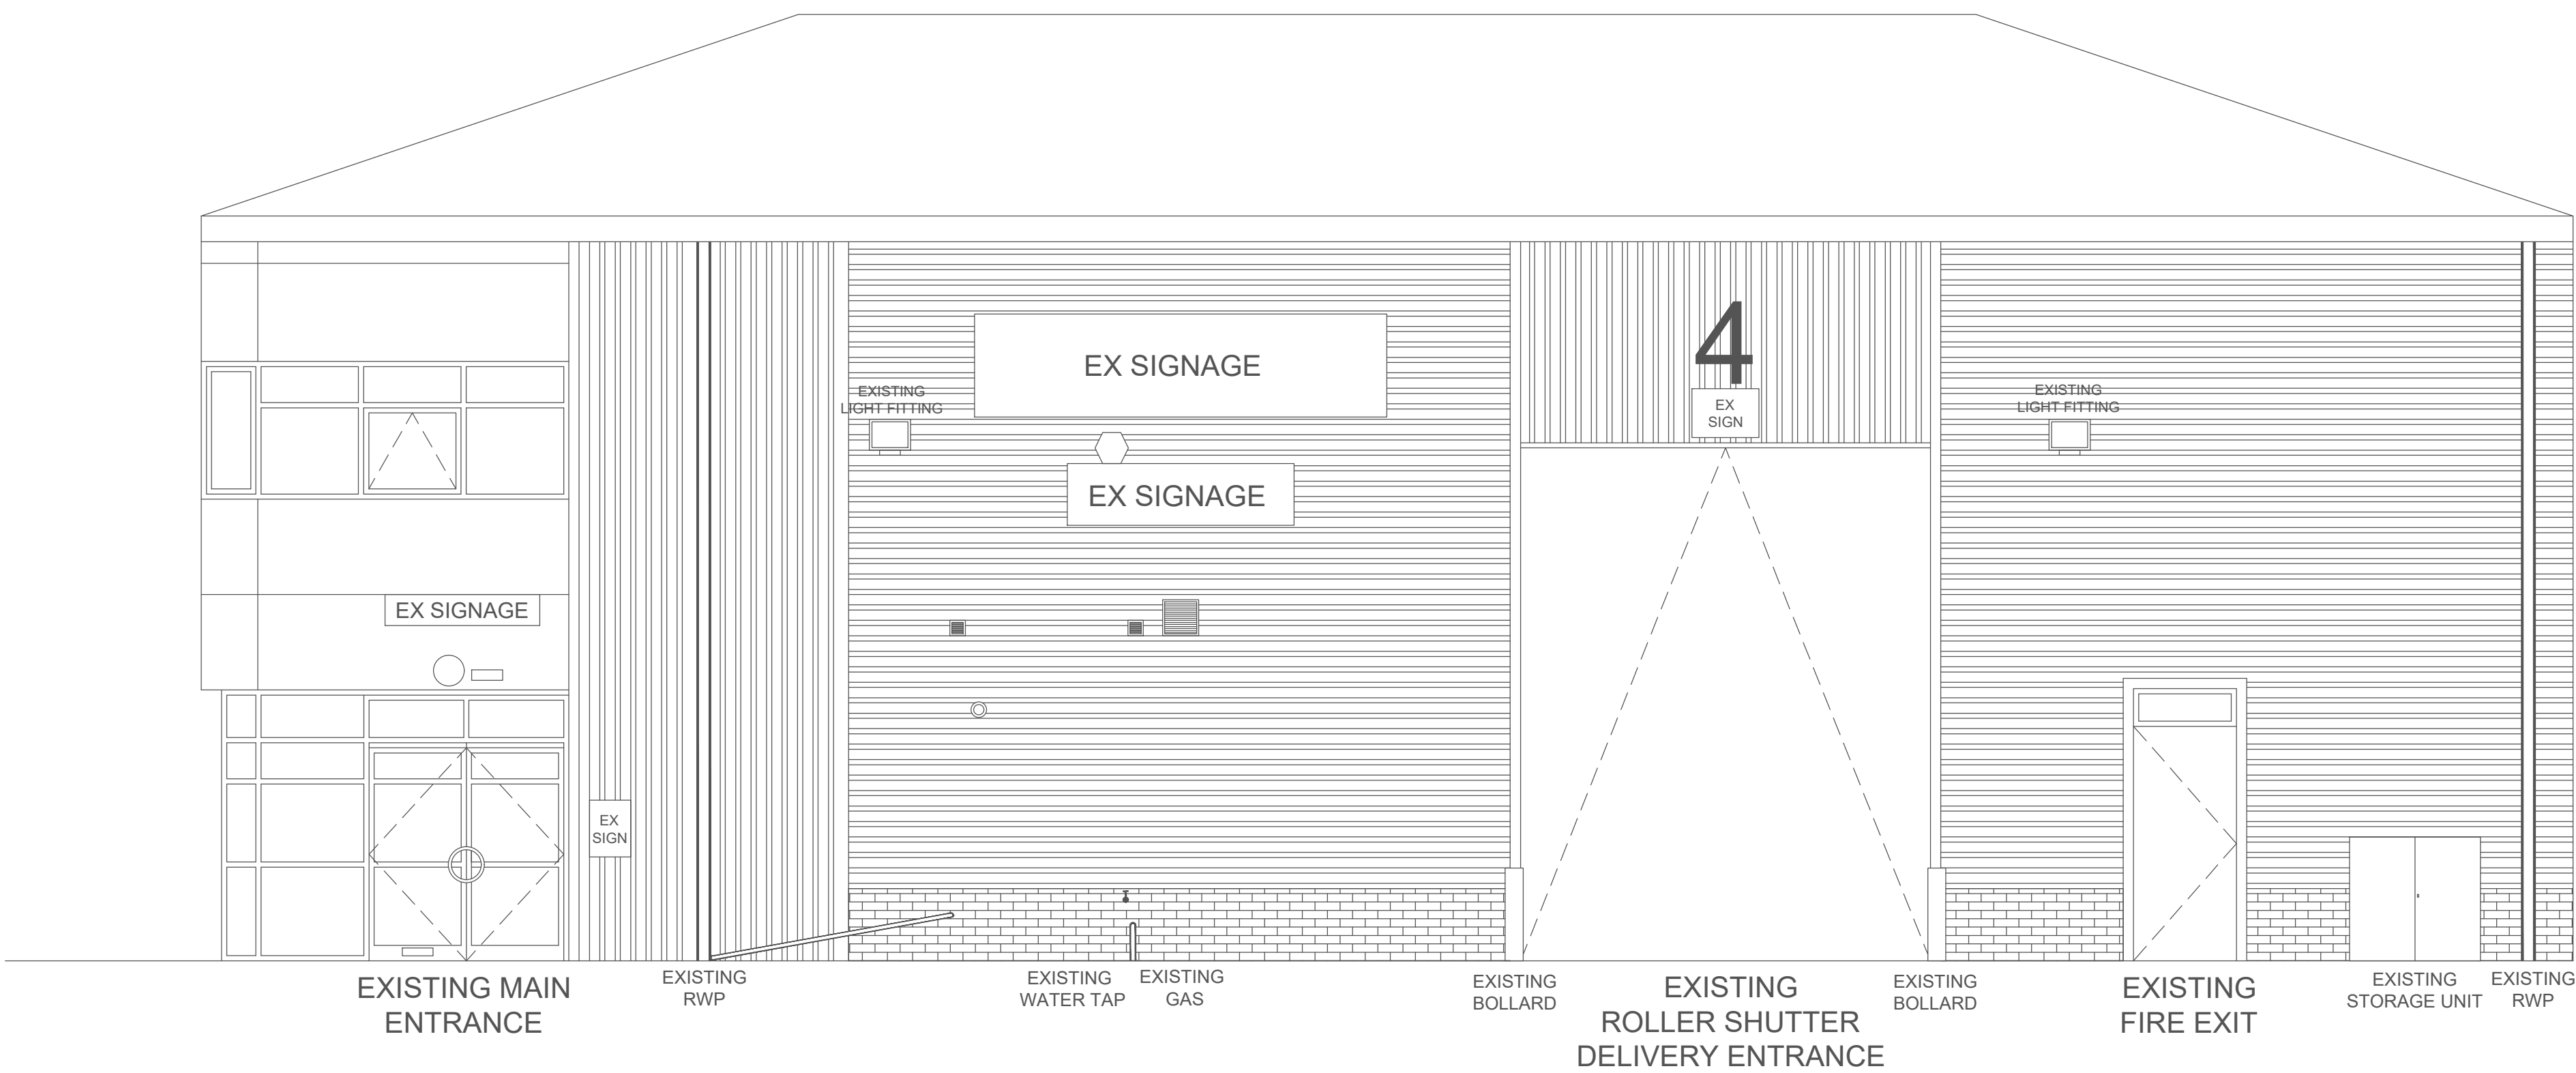

EXISTING FRONT ELEVATION

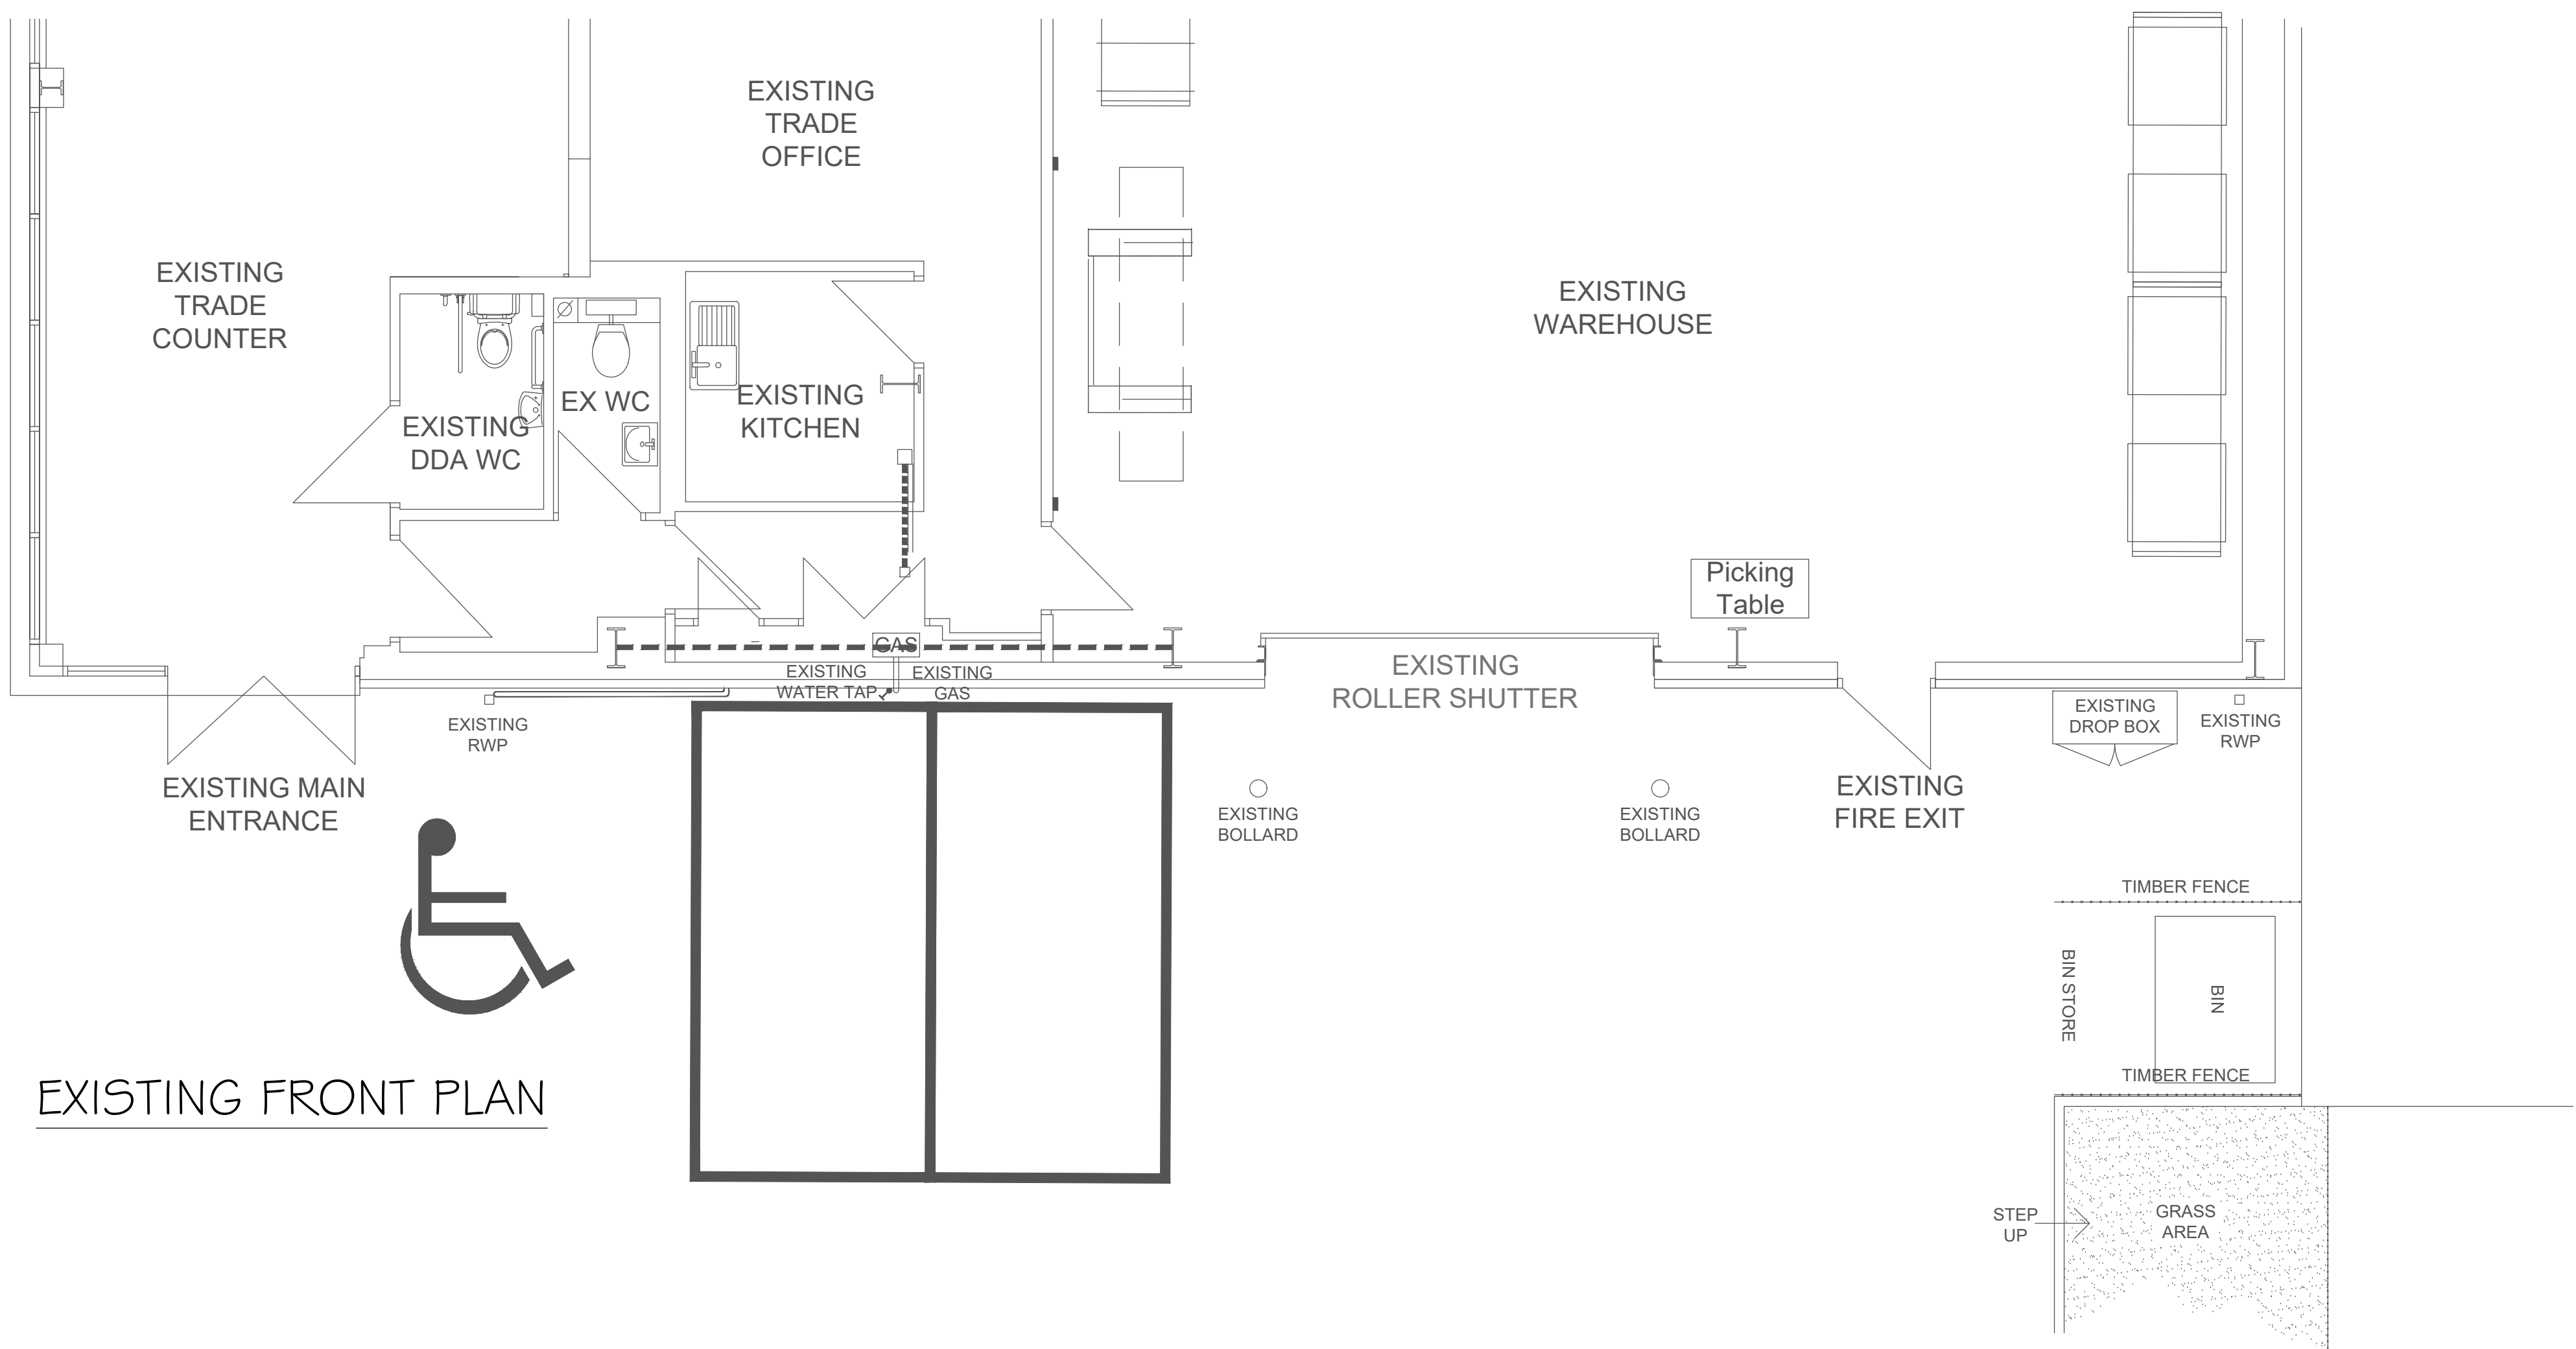

EXISTING FRONT PLAN

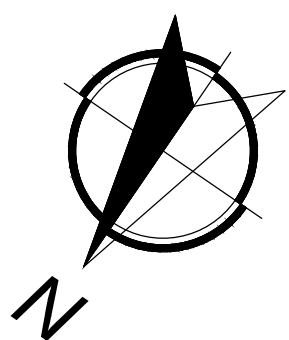

EXISTING ELEVATION
STAGE 2

0m 5m 10m

NOTES			
1. All Dimensions to be checked on site			
Existing Drawings supplied by City Plumbing Supplies Ltd			
James Sifton (TP Group Head Of Format)			
T: 07292 100200			
E: James.Sifton@cityplumbing.co.uk			
This drawing should not be copied or used in full or in part without prior permission from City Plumbing Supplies Ltd. Details within the drawing remain the copyright of City Plumbing Supplies Ltd.			
Rev:	Date:	Description:	By:
See above			
interior design			
100 Boulevard Road, Barnsley, Leeds, LS14 4DY			
01422 519170 james@cityplumbing.co.uk			
CITY PLUMBING			
Lodge Way Farm, Lodge Way, Harrogate Road, Northampton NN2 7UG			
01603 700000			
CLIENT			
CITY PLUMBING SUPPLIES			
PROJECT			
NEW PROJECT 2021-PTS to CPS			
PROJECT LOCATION			
ST AUSTELL			
TITLE			
Existing Elevations			
STAGE 2 Drawing			
DATE	DRAWN	APPROVED	
AUG 2021	L.D	J.M	
SCALE	PAPER SIZE	SHEET	
1:50 / 1:100 @ A1	A1	2	
PROJECT NO.	DRAWING NO.	REV	
BARNSELEY - 01	01	/	