


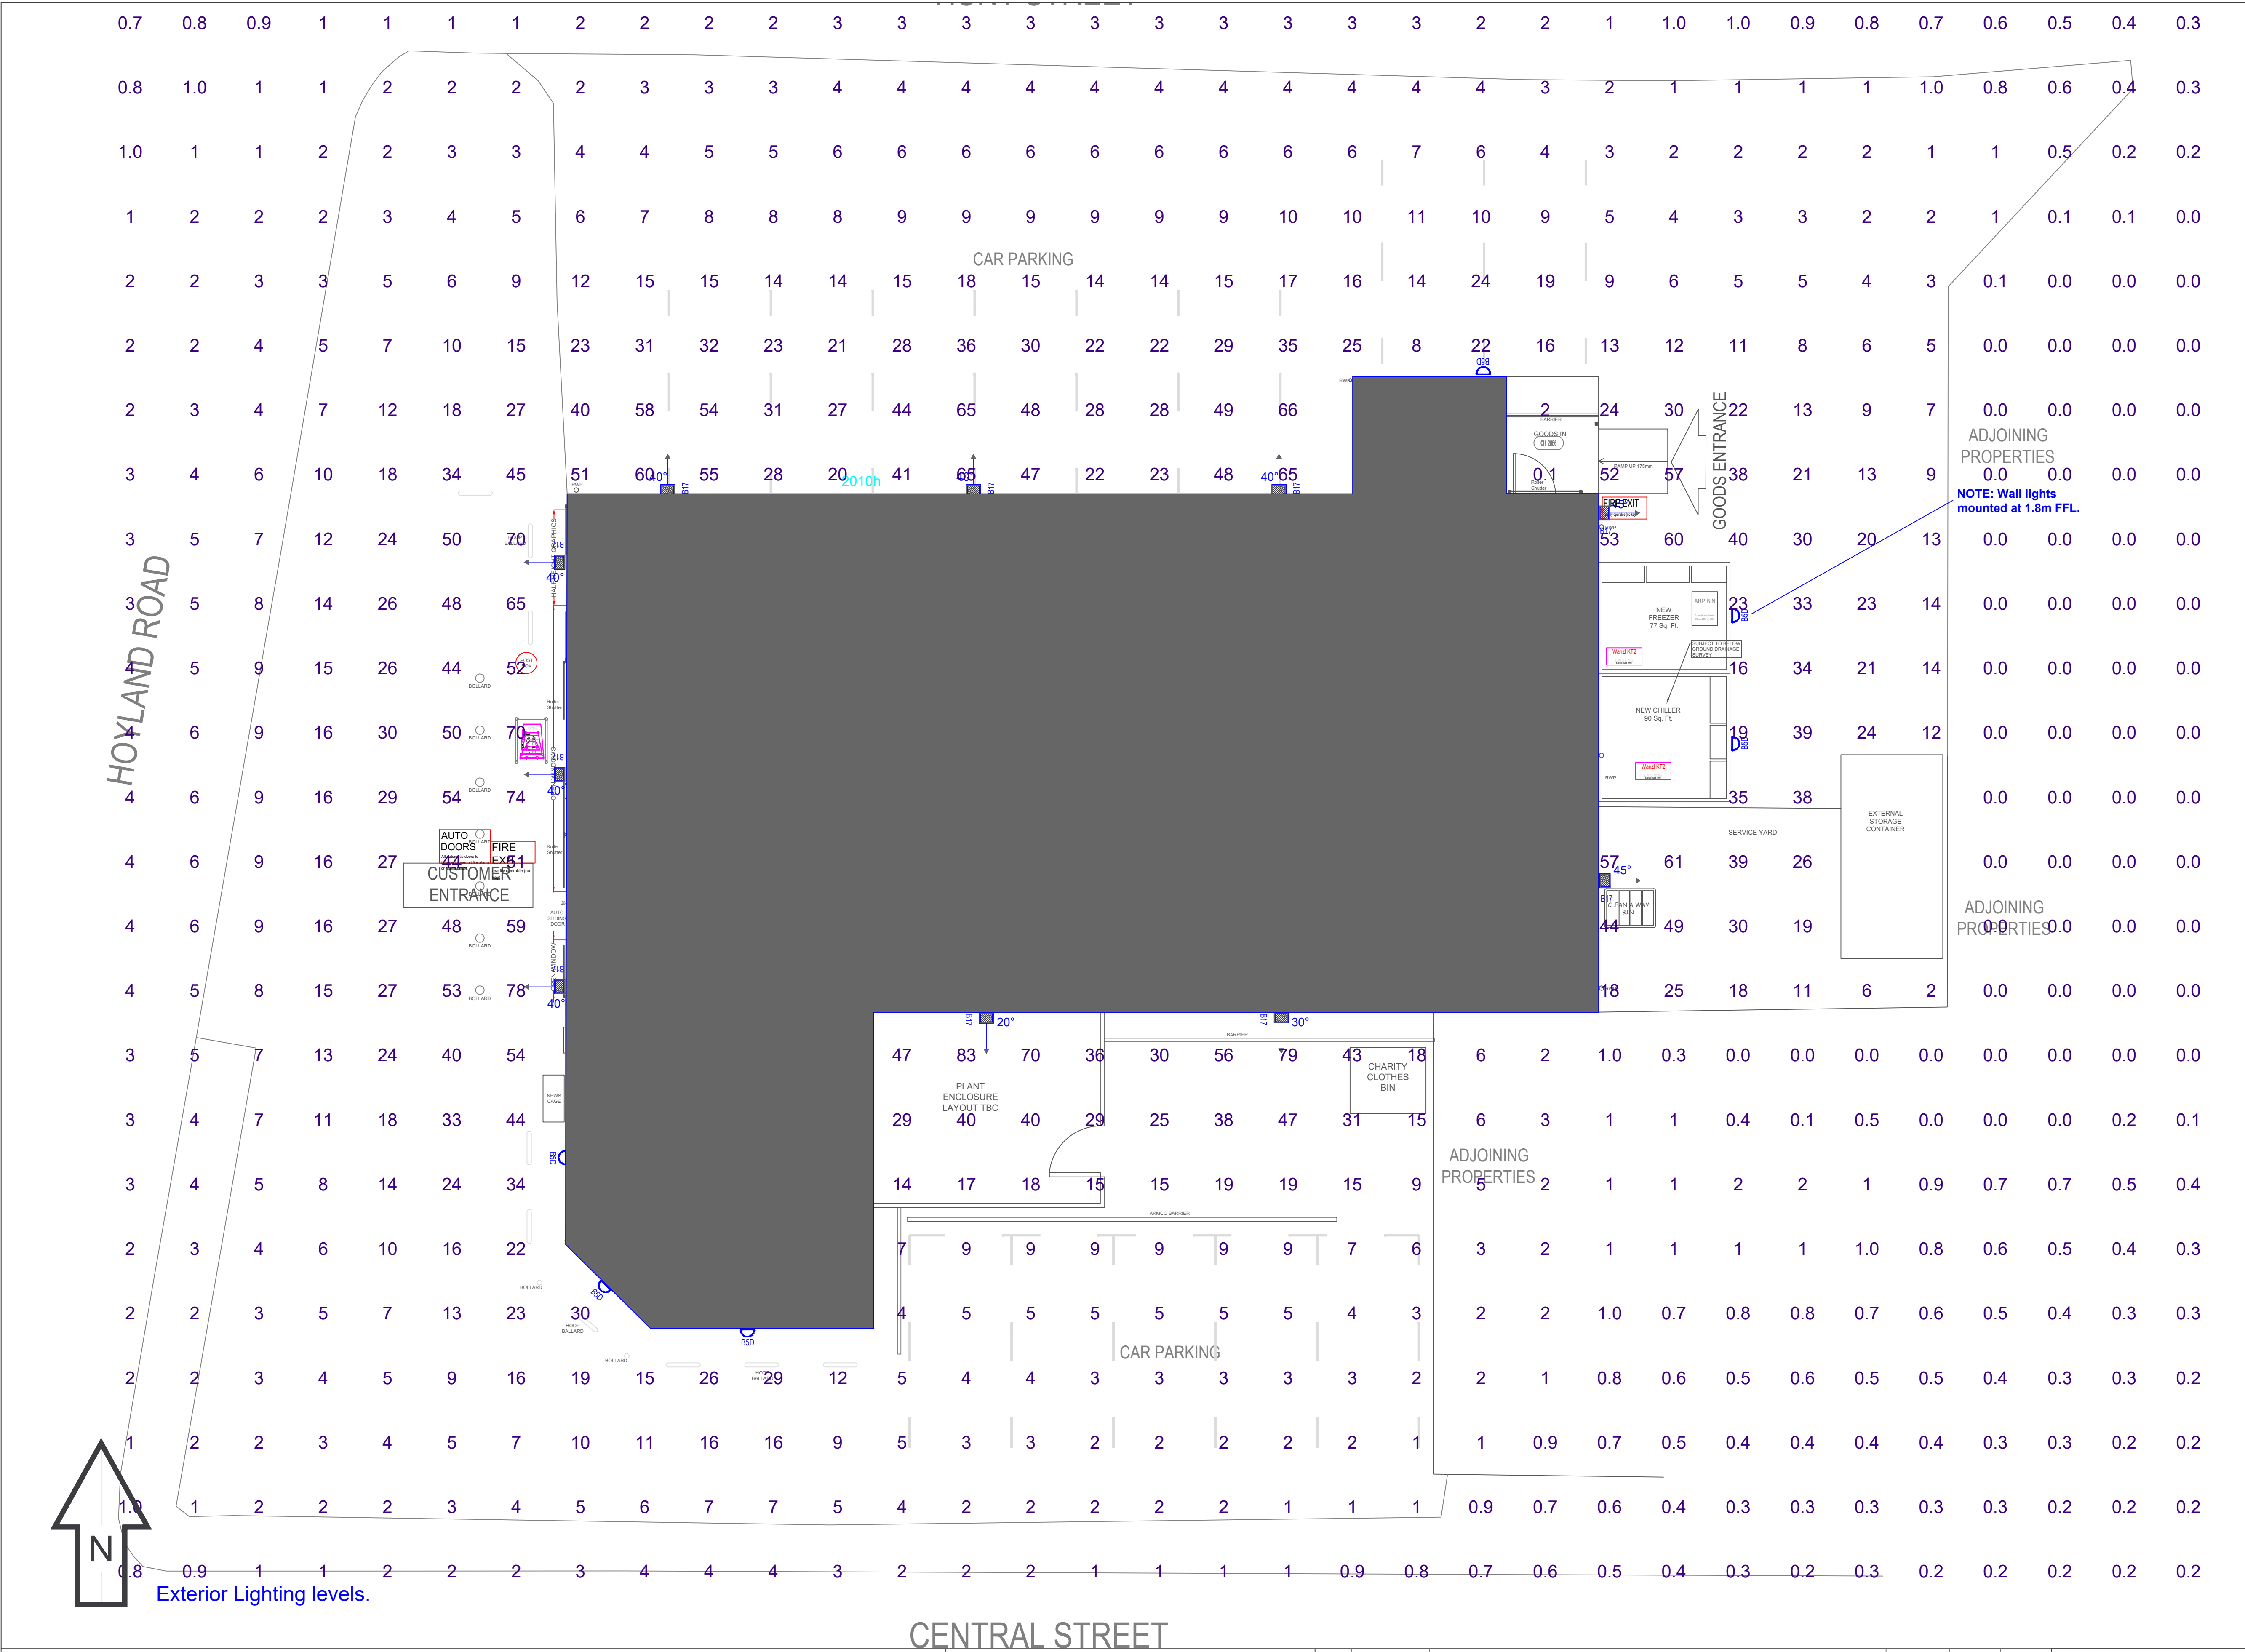

Key:

LUMINAIRE KEY	
CAD Key	Description
	Ledinaire Floodlight mini Wide Beam 8UP10S LED250040 PSU VWS100 Lumen Output: 2.5klm Luminaire Quantity: 10No Mounting Height: 3.0m Facade Mounted (12NC 912401483117)
	CoreLine Wall-mounted 4000K WL120V LED165040 PSR VWH Lumen Output: 1200lm Luminaire Quantity: 6No Mounting Height: 1.8m (12NC 912401483197)

NOTE: All Emergency exit signs to be suspended/mounted between 2m-2.5mtrs.

Notes:

1) Unless agreed otherwise, the lighting proposal produced by the Lighting Application Specialist (LIAS) team of Signify UK&I is not intended for construction purposes, as it does not take into account the elimination of health and safety risks at this stage. For further details please refer to sheet number **DWG 00**

2) Do not scale for this drawing

PROPOSAL
(NOT FOR CONSTRUCTION)

Rev	DSR no.	Comment	Date	LIAS	KAM
1	D-301292	INITIAL PROPOSAL	09/05/19	HSR	RH
2	D-301292	EXTERIOR LIGHTING REVISION	15/05/19	HSR	RH

Project Number	Project Name
0400330942	Co-Op Hoyland
Scale & Sheet Size	Drawing Name
1:75 @ A1	PROPOSED LIGHTING LAYOUT
Sheet No	
DWG 01	